




NEW SOUTH GLASGOW HOSPITALS (NSGH) PROJECT

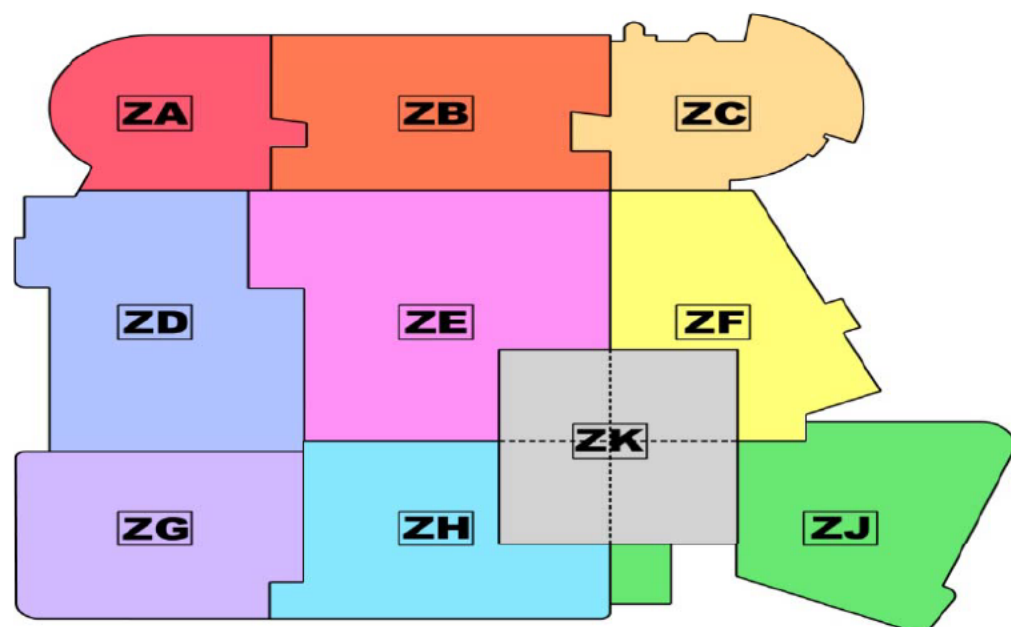

Adults & Childrens Hospital



Brookfield Multiplex Europe

RDD MASTER SCHEDULE

Status
Reviewable Design Data - Issued for Approval

Prepared by		26/03/2014
Checked by		REVISION DATE

Document Number	BCL-AC-XX-SH-001	Revision	39

39	26/03/2014	BM	Updated drawing issues.							
38	26/02/2014	BM	Updated drawing issues.							
37	29/01/2014	BM	Updated drawing issues.							
36	18/12/2013	BM	Updated drawing issues.							
35	27/11/2013	BM	U, dated drawin_ issues.							
34	29/10/2013	BM	Updated drawing issues.							
33	25/09/2013	BM	Updated drawing issues.							
32	28/08/2013	BM	Updated drawing issues.							
31	31/07/2013	BM	Updated drawing issues.							
30	25/06/2013	BM	Updated drawing issues. Car Park Drawings Added							
29	29/05/2013	BM	Updated drawing issues							
28	24/04/2013	BM	Updated drawing issues							
27	27/03/2013	BM	Updated drawing issues							
26	27/02/2013	BM	Updated drawing issues							
25	30/01/2013	BM	Updated drawing issues							
24	09/01/2013	BM	Updated drawing issues							
23	28/11/2012	BM	Updated drawing issues							
22	31/10/2012	BM	Updated drawing issues							
21	26/09/2012	BM	Updated drawing issues							
20	29/08/2012	BM	Updated drawing issue and land Gillespies return dates							
19	25/07/2012	BM	Updated drawing issue and return dates							
18	27/06/2012	BM	Updated drawing issue and return dates							
17	30/05/2012	BM	Updated drawing issue and return dates							
15	28/03/2012	BM	Updated drawing issue and return dates							
14	29/02/2012	BM	Updated with Mercury, ZBP information							
13	10/02/2012	BM	Updated with Mercury and ZBP information							
12	26/11/2011	BM	Updated in line with NA Design Strategy Review Programme Summary							
11	31/08/2011	BM	Amendments as DS comments 31/08/11							
10	30/08/2011	BM	ibined NA, GIL & M&E schedules.(M&E Dates 6 Month Lookahead							
08	25/082011	NA	Dates adjusted							
07	16/08/2011	NA	Re-formatted with Worksheet per RDD Item; Title sheet, Revision Notes sheet, Contents sheet and hyperlinks added; DT issue proposed issue dates added (to date required by Consultant)							
06	03/08/2011	GB	NHS comments added: issued to Design Team (DT) for issue date input							

Rev	Date	Drw	Revision Notes	Chk	App

1BCL-AC-XX-SH-001															1st Submission												2nd Submission										OVERDUE
			Action By	Drawing Number	Drawing Title	Date Required from Consultant	Date Submitted by Consultant	Document Revision	Planned Date to be Submitted to Board	Date Submitted to Board	Date Response Required from Board (+3 Weeks)	Date Returned from Board	Board Status	Date returned to Consultant	Date Required from Consultant	Date Submitted by Consultant	Document Revision	Planned Date to be Submitted to Board	Date Submitted to Board	Date Response Required from Board (+4 Weeks)	Date Received from Board	Board Status	Date Returned to Consultant	OVERDUE													
Item	Submission	Comments																																			
1	Block Plans	1:500 Adjacency Layouts																																			
		STATUS: These are approved under Appendix K.	GIL	GIL-EW-XX-PL-700-000	Masterplan GA	07/10/11			11/10/2011							The following matters are shown on the 1:500 scale adjacency layouts and landscape drawings:																					
			GIL	GIL-EW-XX-PL-700-001	Existing Site-1	07/10/11			11/10/2011							The following matters are shown on the 1:500 scale adjacency layouts and landscape drawings:																					
		The following matters are shown on the 1:500 scale adjacency layouts and landscape drawings:	GIL	GIL-EW-XX-PL-700-002	Existing Site-2	07/10/11			11/10/2011							The following matters are shown on the 1:500 scale adjacency layouts and landscape drawings:																					
		(1) The points of access to and within the Sites and the buildings	GIL	GIL-EW-XX-PL-700-003	Existing Site-3	07/10/11			11/10/2011							The following matters are shown on the 1:500 scale adjacency layouts and landscape drawings:																					
		(2) The relationship between one or more buildings that comprise the development	GIL	GIL-EW-XX-PL-700-004	Site location & context	07/10/11			11/10/2011							The following matters are shown on the 1:500 scale adjacency layouts and landscape drawings:																					
		(3) The adjacencies between different Hospital departments and corridors	GIL	GIL-EW-XX-PL-700-005	Outline of New Building Overlay	07/10/11			11/10/2011							The following matters are shown on the 1:500 scale adjacency layouts and landscape drawings:																					
			GIL	GIL-EW-XX-PL-700-006	Reference Grid	07/10/11			11/10/2011							The following matters are shown on the 1:500 scale adjacency layouts and landscape drawings:																					
		Aspect of review:																																			
		Site and whole hospital opration	NA	NA-XX-B1-PL-252-010	Basement Plan - Departmental Adjacencies					App K Date			App K Status		02/09/2011	02.09.11	5	06/09/2011	09.09.11	04.10.11	12/10/2011	A	15/11/2011 BMCE-TRANSMIT-0667207														
		Relationship to existing operations	NA	NA-XX-00-PL-252-010	Ground Floor Plan - Departmental Adjacencies					App K Date			App K Status		02/09/2011	02.09.11	3	06/09/2011	09.09.11	04.10.11	12/10/2011	A	15/11/2011 BMCE-TRANSMIT-0667207														
			NA	NA-XX-01-PL-252-010	First Floor Plan - Departmental Adjacencies					App K Date			App K Status		02/09/2011	02.09.11	3	06/09/2011	09.09.11	04.10.11	12/10/2011	A	15/11/2011 BMCE-TRANSMIT-0667207														
			NA	NA-XX-02-PL-252-010	Second Floor Plan - Departmental Adjacencies					App K Date			App K Status		02/09/2011	02.09.11	3	06/09/2011	09.09.11	04.10.11	12/10/2011	A	15/11/2011 BMCE-TRANSMIT-0667207														
			NA	NA-XX-03-PL-252-010	Third Floor Plan - Departmental Adjacencies					App K Date			App K Status		02/09/2011	02.09.11	3	06/09/2011	09.09.11	04.10.11	12/10/2011	A	15/11/2011 BMCE-TRANSMIT-0667207														
			NA	NA-XX-04-PL-252-010	Fourth Floor Plan - Departmental Adjacencies					App K Date			App K Status		02/09/2011	02.09.11	3	06/09/2011	09.09.11	04.10.11	12/10/2011	A	15/11/2011 BMCE-TRANSMIT-0667207														
			NA	NA-XX-05-PL-252-010	Fifth Floor Plan - Departmental Adjacencies					App K Date			App K Status		02/09/2011	02.09.11	3	06/09/2011	09.09.11	04.10.11	12/10/2011	A	15/11/2011 BMCE-TRANSMIT-0667207														
			NA	NA-XX-06-PL-252-010	Sixth Floor Plan - Departmental Adjacencies					App K Date			App K Status		02/09/2011	02.09.11	3	06/09/2011	09.09.11	04.10.11	12/10/2011	A	15/11/2011 BMCE-TRANSMIT-0667207														
			NA	NA-XX-07-PL-252-010	Seventh Floor Plan - Departmental Adjacencies					App K Date			App K Status		02/09/2011	02.09.11	4	06/09/2011	09.09.11	04.10.11	12/10/2011	A	15/11/2011 BMCE-TRANSMIT-0667207														
			NA	NA-XX-08-PL-252-010	Eighth Floor Plan - Departmental Adjacencies					App K Date			App K Status		02/09/2011	02.09.11	3	06/09/2011	09.09.11	04.10.11	12/10/2011	A	15/11/2011 BMCE-TRANSMIT-0667207														
			NA	NA-XX-09-PL-252-010	Ninth Floor Plan - Departmental Adjacencies					App K Date			App K Status		02/09/2011	02.09.11	3	06/09/2011	09.09.11	04.10.11	12/10/2011	A	15/11/2011 BMCE-TRANSMIT-0667207														
			NA	NA-XX-10-PL-252-010	Tenth Floor Plan - Departmental Adjacencies					App K Date			App K Status		02/09/2011	02.09.11	3	06/09/2011	09.09.11	04.10.11	12/10/2011	A	15/11/2011 BMCE-TRANSMIT-0667207														
			NA	NA-XX-11-PL-252-010	Eleventh Floor Plan - Departmental Adjacencies					App K Date			App K Status		02/09/2011	02.09.11	3	06/09/2011	09.09.11	04.10.11	12/10/2011	A	15/11/2011 BMCE-TRANSMIT-0667207														
			NA	NA-XX-12-PL-252-010	Twelfth Floor Plan - Departmental Adjacencies					App K Date			App K Status		02/09/2011	02.09.11	3	06/09/2011	09.09.11	04.10.11	12/10/2011	A	15/11/2011 BMCE-TRANSMIT-0667207														
			NA	NA-XX-13-PL-252-010	Thirteenth Floor Plan - Departmental Adjacencies					App K Date			App K Status		02/09/2011	02.09.11	2	06/09/2011	09.09.11	04.10.11	12/10/2011	A	15/11/2011 BMCE-TRANSMIT-0667207														
			NA	NA-XX-14-PL-252-010	Fourteenth Floor Plan - Departmental Adjacencies					App K Date			App K Status		02/09/2011	02.09.11	2	06/09/2011	09.09.11	04.10.11	12/10/2011	A	15/11/2011 BMCE-TRANSMIT-0667207														

2 BCL-AC-XX-SH-001			1st Submission											2nd Submission										OVERDUE		
			Action By	Drawing Number	Drawing Title	Date Required from Consultant	Date Submitted by Consultant	Document Revision	Planned Date to be Submitted to Board	Date Submitted to Board	Date Response Required from Board (+3 Weeks)	Date Returned from Board	Board Status	Date returned to Consultant	Date Required from Consultant	Date Submitted by Consultant	Document Revision	Planned Date to be Submitted to Board	Date Submitted to Board	BMCE TRANSMITTAL NO	Date Response Required from Board (+4 Weeks)	Date Received from Board	Board Status	Date Returned to Consultant	OVERDUE	
Item	Submission	Comments																								
2	Departmental Layouts	1:200 Department Plans																								
	Departmental Layouts - Co-ordinated B&W 1:200's	STATUS: These are approved under Appendix K.	NA	NA-XX-B1-PL-252-100	Basement Plan - Kitchen FM Stores Distribution Bed Maintenance & AGV Charging		30/09/10			15/10/2010		21/10/2010	B		02/09/2011			06/09/2011		D E P A R T M E N T A L L A Y O U T C O L O U R D R A W I N G S S U B M I T T E D - B M C E - T R A N S M I T - 0 0 5 0 0 9						
			NA	NA-XX-B1-PL-252-101	Basement Plan - Kitchen FM Stores Distribution		30/11/10			06/12/2010		14/12/2010	A		02/09/2011			06/09/2011								
			NA	NA-XX-00-PL-252-100	Ground Floor Plan - NSGH Entrance Reception and Atrium Space		22/09/10			01/10/2010		21/10/2010	B		02/09/2011			06/09/2011								
		The following matters are shown on the 1:200 scale department layouts:	NA	NA-XX-00-PL-252-101	Ground Floor Plan - NCH Rehab		22/09/10			01/10/2010		21/10/2010	A		02/09/2011			06/09/2011								
		(1) The adjacencies between different Hospital departments and corridors	NA	NA-XX-00-PL-252-102	Ground Floor Plan - NCH Entrance and OPD		22/09/10			01/10/2010		21/10/2010	B		02/09/2011			06/09/2011								
		(2) The quantity description and area (in square metres) of these rooms and spaces shown on the agreed Schedule of Accommodation	NA	NA-XX-00-PL-252-103	Ground Floor Plan - NCH Observation Ward / Child Protection / Sanctuary		22/09/10			01/10/2010		21/10/2010	B		02/09/2011			06/09/2011								
		(2) The location of the inter-relationships between rooms within a department.	NA	NA-XX-00-PL-252-104	Ground Floor Plan - NCH Emergency Department/ Decontamination Unit		22/09/10			01/10/2010		21/10/2010	B		02/09/2011			06/09/2011								
			NA	NA-XX-00-PL-252-105	Ground Floor Plan - NSGH Emergency Department		22/09/10			01/10/2010		21/10/2010	B		02/09/2011			06/09/2011								
			NA	NA-XX-00-PL-252-106	Ground Floor Plan - NSGH Acute Assessment		22/09/10			01/10/2010		21/10/2010	B		02/09/2011			06/09/2011								
			NA	NA-XX-00-PL-252-107	Ground Floor Plan - NSGH Radiology / Medical Illustration		22/09/10			01/10/2010		21/10/2010	B		02/09/2011			06/09/2011								
			NA	NA-XX-00-PL-252-108	Ground Floor Plan - NCH Radiology		22/09/10			01/10/2010		21/10/2010	A		02/09/2011			06/09/2011								
		Aspect of review:	NA	NA-XX-00-PL-252-109	Ground Floor Plan - NSGH OPD / Rehab & Therapies		22/09/10			01/10/2010		21/10/2010	B		02/09/2011			06/09/2011								
		Clinical functionality	NA	NA-XX-01-PL-252-100	First Floor Plan - NSGH Restaurant Sanctuary and Atrium Space		22/09/10			01/10/2010		21/10/2010	B		02/09/2011			06/09/2011								
		Room relationships within departments	NA	NA-XX-01-PL-252-101	First Floor Plan - NCH Theatres / Interventional Radiology and Radiology		22/09/10			01/10/2010		21/10/2010	A		02/09/2011			06/09/2011								
			NA	NA-XX-01-PL-252-102	First Floor Plan - NCH 23 Hour Unit		22/09/10			01/10/2010		21/10/2010	A		02/09/2011			06/09/2011								
		NOTE: The Ceiling Layouts noted in item (3) above are provided as indicated in the Reflected Ceiling Layouts section below.	NA	NA-XX-01-PL-252-103	First Floor Plan - NCH Critical Care (PICU) / Cardiology Ward / Support / MDU and Special Feeds		22/09/10			01/10/2010		21/10/2010	B		02/09/2011			06/09/2011								
			NA	NA	First Floor Plan - NSGH CCU and Critical Care (1 of 2)		22/09/10			01/10/2010		21/10/2010	A		02/09/2011			06/09/2011								
			NA	NA-XX-01-PL-252-105	First Floor Plan - NSGH Critical Care (2 of 2)		22/09/10			01/10/2010		21/10/2010	B		02/09/2011			06/09/2011								
			NA	NA-XX-01-PL-252-106	First Floor Plan - NSGH Stroke Ward / MDU / Pre Assessment		22/09/10			01/10/2010		21/10/2010	B		02/09/2011			06/09/2011								
			NA	NA-XX-01-PL-252-107	First Floor Plan - NSGH Radiology		22/09/10			01/10/2010		21/10/2010	A		02/09/2011			06/09/2011								
			NA	NA-XX-01-PL-252-108	First Floor Plan - NSGH Nuclear Medicine		22/09/10			01/10/2010		21/10/2010	A		02/09/2011			06/09/2011								
			NA	NA-XX-01-PL-252-109	First Floor Plan - NSGH OPD & Pre-op Assessment		22/09/10			01/10/2010		21/10/2010	A		02/09/2011			06/09/2011								
			NA	NA-XX-02-PL-252-100	Second Floor Plan - NSGH Atrium		22/09/10			01/10/2010		21/10/2010	B		02/09/2011			06/09/2011								
			NA	NA-XX-02-PL-252-101	Second Floor Plan - NSGH Dermatology Ward + Plant		22/09/10			01/10/2010		21/10/2010	A		02/09/2011			06/09/2011								

2 BCL-AC-XX-SH-001			1st Submission												2nd Submission										OVERDUE
Item	Submission	Comments	Action By	Drawing Number	Drawing Title	Date Required from Consultant	Date Submitted by Consultant	Document Revision	Planned Date to be Submitted to Board	Date Submitted to Board	Date Response Required from Board (+3 Weeks)	Date Returned from Board	Board Status	Date returned to Consultant	Date Required from Consultant	Date Submitted by Consultant	Document Revision	Planned Date to be Submitted to Board	Date Submitted to Board	BMCE TRANSMITTAL NO	Date Response Required from Board (+4 Weeks)	Date Received from Board	Board Status	Date Returned to Consultant	OVERDUE
			NA	NA-XX-02-PL-252-102	Second Floor Plan - NCH Schiehallion Ward / Day Case Unit / Theatres and Anaesthetic Service Offices		22/09/10			01/10/2010		21/10/2010	B		02/09/2011			06 09/2011		D E P A R T M E N T A L L A Y O U T C O L O U R D R A W I N G S S U B M I T T E D - B M C E - T R A N S M I T - 0 0 5 0 0 9					
			NA	NA-XX-02-PL-252-103	Second Floor Plan - NCH Acute Receiving Ward		22/09/10			01/10/2010		21/10/2010	B		02/09/2011			06 09/2011							
			NA	NA-XX-02-PL-252-104	Second Floor Plan - NSGH Endoscopy / Decontamination / Medical Physics / Stores		22/09/10			01/10/2010		21/10/2010	B		02/09/2011			06 09/2011							
			NA	NA-XX-02-PL-252-105	Second Floor Plan - NSGH Theatres (1 of 2) + Plant		22/09/10			01/10/2010		21/10/2010	B		02/09/2011			06 09/2011							
			NA	NA-XX-02-PL-252-106	Second Floor Plan - NSGH Theatres (2 of 2) + Plant		22/09/10			01/10/2010		21/10/2010	B		02/09/2011			06 09/2011							
			NA	NA-XX-02-PL-252-109	Second Floor Plan - NSGH Dermatology OPD / Renal Dialysis		22/09/10			01/10/2010		21/10/2010	A		02/09/2011			06 09/2011							
			NA	NA-xx-03-PL-252-100	Third Floor Plan - NSGH Atrium		22/09/10			01/10/2010		21/10/2010	B		02/09/2011			06 09/2011							
			NA	NA-xx-03-PL-252-101	Third Floor Plan - PLANT		22/09/10			01/10/2010		08/11/2010	B		02/09/2011			06 09/2011							
			NA	NA-xx-03-PL-252-102	Third Floor Plan - NCH In-Patient Ward		22/09/10			01/10/2010		21/10/2010	B		02/09/2011			06 09/2011							
			NA	NA-xx-03-PL-252-103	Third Floor Plan - NCH In-Patient Ward / Ward Support		22/09/10			01/10/2010		21/10/2010	B		02/09/2011			06 09/2011							
			NA	NA-xx-03-PL-252-105	Third Floor Plan - PLANT		22/09/10			01/10/2010		08/11/2010	B		02/09/2011			06 09/2011							
			NA	NA-xx-03-PL-252-106	Third Floor Plan - PLANT		22/09/10			01/10/2010		08/11/2010	A		02/09/2011			06 09/2011							
			NA	NA-xx-03-PL-252-109	Third Floor Plan - PLANT		22/09/10			01/10/2010		08/11/2010	A		02/09/2011			06 09/2011							
			NA	NA-xx-04-PL-252-100	Fourth Floor Plan - NSGH Atrium + Lift Core		22/09/10			01/10/2010		08/11/2010	A		02/09/2011			06 09/2011							
			NA	NA-xx-04-PL-252-101	Fourth Floor Plan - Higher Acuity Renal Ward		22/09/10			01/10/2010		08/11/2010	B		02/09/2011			06 09/2011							
			NA	NA-xx-04-PL-252-102	Fourth Floor Plan - NCH DCFP		22/09/10			01/10/2010		08/11/2010	A		02/09/2011			06 09/2011							
			NA	NA-xx-04-PL-252-103	Fourth Floor Plan - Haemo-Oncology Ward		22/09/10			01/10/2010		21/10/2010	B		02/09/2011			06 09/2011							
			NA	NA-xx-04-PL-252-104	Fourth Floor Plan - NSGH Generic Ward (1 of 2)		22/09/10			01/10/2010		21/10/2010	B		02/09/2011			06 09/2011							
			NA	NA-xx-04-PL-252-105	Fourth Floor Plan - NSGH Generic Ward (1 of 2)		22/09/10			01/10/2010		21/10/2010	B		02/09/2011			06 09/2011							
			NA	NA-xx-04-PL-252-106	Fourth Floor Plan - NCH Plant		22/09/10			11/11/2010		25/11/2010	A		02/09/2011			06 09/2011							
			NA	NA-xx-05-PL-252-100	Fifth Floor Plan - NSGH Atrium + Lift Core		22/09/10			01/10/2010		21/10/2010	B		02/09/2011			06 09/2011							
			NA	NA-xx-05-PL-252-101	Fifth Floor Plan - NSGH Generic Ward (1 of 4)		22/09/10			01/10/2010		21/10/2010	B		02/09/2011			06 09/2011							
			NA	NA-xx-05-PL-252-102	Fifth Floor Plan - NSGH Generic Ward (2 of 4)		22/09/10			01/10/2010		21/10/2010	B		02/09/2011			06 09/2011							
			NA	NA-xx-05-PL-252-103	Fifth Floor Plan - NSGH Generic Ward (3 of 4)		22/09/10			01/10/2010		21/10/2010	B		02/09/2011			06 09/2011							
			NA	NA-xx-05-PL-252-104	Fifth Floor Plan - NSGH Generic Ward (4 of 4)		22/09/10			01/10/2010		21/10/2010	B		02/09/2011			06 09/2011							
			NA	NA-XX-06-PL-252-100	Sixth Floor Plan - NSGH Atrium + Lift Core		22/09/10			01/10/2010		21/10/2010	B		02/09/2011			06 09/2011							
			NA	NA-XX-06-PL-252-101	Sixth Floor Plan - NSGH Generic Ward (1 of 4)		22/09/10			01/10/2010		21/10/2010	B		02/09/2011			06 09/2011							
			NA	NA-XX-06-PL-252-102	Sixth Floor Plan - NSGH Generic Ward (2 of 4)		22/09/10			01/10/2010		21/10/2010	B		02/09/2011			06 09/2011							
			NA	NA-XX-06-PL-252-103	Sixth Floor Plan - NSGH Generic Ward (3 of 4)		22/09/10			01/10/2010		21/10/2010	B		02/09/2011			06 09/2011							
			NA	NA-XX-06-PL-252-104	Sixth Floor Plan - NSGH Generic Ward (4 of 4)		22/09/10			01/10/2010		21/10/2010	B		02/09/2011			06 09/2011							

2 BCL-AC-XX-SH-001			1st Submission											2nd Submission										OVERDUE	
			Action By	Drawing Number	Drawing Title	Date Required from Consultant	Date Submitted by Consultant	Document Revision	Planned Date to be Submitted to Board	Date Submitted to Board	Date Response Required from Board (+3 Weeks)	Date Returned from Board	Board Status	Date returned to Consultant	Date Required from Consultant	Date Submitted by Consultant	Document Revision	Planned Date to be Submitted to Board	Date Submitted to Board	BMCE TRANSMITTAL NO	Date Response Required from Board (+4 Weeks)	Date Received from Board	Board Status	Date Returned to Consultant	OVERDUE
Item	Submission	Comments																							
			NA	NA-XX-07-PL-252-100	Seventh Floor Plan - NSGH Atrium + L ft Core		22/09/10			01/10/2010		21/10/2010	B		02/09/2011			06 09/2011							
			NA	NA-XX-07-PL-252-101	Seventh Floor Plan - NSGH Generic Ward (1 of 4)		22/09/10			01/10/2010		21/10/2010	B		02/09/2011			06 09/2011							
			NA	NA-XX-07-PL-252-102	Seventh Floor Plan - NSGH Generic Ward (2 of 4)		22/09/10			01/10/2010		21/10/2010	B		02/09/2011			06 09/2011							
			NA	NA-XX-07-PL-252-103	Seventh Floor Plan - NSGH Generic Ward (3 of 4)		22/09/10			01/10/2010		21/10/2010	B		02/09/2011			06 09/2011							
			NA	NA-XX-07-PL-252-104	Seventh Floor Plan - NSGH Generic Ward (4 of 4)		22/09/10			01/10/2010		21/10/2010	B		02/09/2011			06 09/2011							
			NA	NA-XX-08-PL-252-100	Eighth Floor Plan - NSGH Atrium + Lift Core		22/09/10			01/10/2010		21/10/2010	B		02/09/2011			06 09/2011							
			NA	NA-XX-08-PL-252-101	Eighth Floor Plan - NSGH Generic Ward (1 of 4)		22/09/10			01/10/2010		21/10/2010	B		02/09/2011			06 09/2011							
			NA	NA-XX-08-PL-252-102	Eighth Floor Plan - NSGH Generic Ward (2 of 4)		22/09/10			01/10/2010		21/10/2010	B		02/09/2011			06 09/2011							
			NA	NA-XX-08-PL-252-103	Eighth Floor Plan - NSGH Generic Ward (3 of 4)		22/09/10			01/10/2010		21/10/2010	B		02/09/2011			06 09/2011							
			NA	NA-XX-08-PL-252-104	Eighth Floor Plan - NSGH Generic Ward (4 of 4)		22/09/10			01/10/2010		21/10/2010	B		02/09/2011			06 09/2011							
			NA	NA-XX-09-PL-252-100	Ninth Floor Plan - NSGH Atrium + Lift Core		22/09/10			01/10/2010		21/10/2010	B		02/09/2011			06 09/2011							
			NA	NA-XX-09-PL-252-101	Ninth Floor Plan - NSGH Generic Ward (1 of 4)		22/09/10			01/10/2010		21/10/2010	B		02/09/2011			06 09/2011							
			NA	NA-XX-09-PL-252-102	Ninth Floor Plan - NSGH Generic Ward (2 of 4)		22/09/10			01/10/2010		21/10/2010	B		02/09/2011			06 09/2011							
			NA	NA-XX-09-PL-252-103	Ninth Floor Plan - NSGH Generic Ward (3 of 4)		22/09/10			01/10/2010		21/10/2010	B		02/09/2011			06 09/2011							
			NA	NA-XX-09-PL-252-104	Ninth Floor Plan - NSGH Generic Ward (4 of 4)		22/09/10			01/10/2010		21/10/2010	B		02/09/2011			06 09/2011							
			NA	NA-XX-10-PL-252-100	Tenth Floor Plan - NSGH Atrium + Lift Core		22/09/10			01/10/2010		21/10/2010	B		02/09/2011			06 09/2011							
			NA	NA-XX-10-PL-252-101	Tenth Floor Plan - NSGH Generic Ward (1 of 4)		22/09/10			01/10/2010		21/10/2010	B		02/09/2011			06 09/2011							
			NA	NA-XX-10-PL-252-102	Tenth Floor Plan - NSGH Generic Ward (2 of 4)		22/09/10			01/10/2010		21/10/2010	B		02/09/2011			06 09/2011							
			NA	NA-XX-10-PL-252-103	Tenth Floor Plan - NSGH Generic Ward (3 of 4)		22/09/10			01/10/2010		21/10/2010	B		02/09/2011			06 09/2011							
			NA	NA-XX-10-PL-252-104	Tenth Floor Plan - NSGH Generic Ward (4 of 4)		22/09/10			01/10/2010		21/10/2010	B		02/09/2011			06 09/2011							
			NA	NA-XX-11-PL-252-100	Eleventh Floor Plan - NSGH Atrium + Lift Core		22/09/10			01/10/2010		21/10/2010	B		02/09/2011			06 09/2011							
			NA	NA-XX-11-PL-252-101	Eleventh Floor Plan - NSGH Generic Ward (1 of 4)		22/09/10			01/10/2010		21/10/2010	B		02/09/2011			06 09/2011							
			NA	NA-XX-11-PL-252-102	Eleventh Floor Plan - NSGH Generic Ward (2 of 4)		22/09/10			01/10/2010		21/10/2010	B		02/09/2011			06 09/2011							
			NA	NA-XX-11-PL-252-103	Eleventh Floor Plan - NSGH Generic Ward (3 of 4)		22/09/10			01/10/2010		21/10/2010	B		02/09/2011			06 09/2011							
			NA	NA-XX-11-PL-252-104	Eleventh Floor Plan - NSGH Generic Ward (4 of 4)		22/09/10			01/10/2010		21/10/2010	B		02/09/2011			06 09/2011							
				NA-XX-12-PL-252-100	Twelfth Floor Plan - NSGH Atrium / Lift Cores		22/09/10			01/10/2010		08/11/2010	A		02/09/2011			06 09/2011							
			NA	NA-XX-12-PL-252-101	Twe fth Floor Plan - Plant (1 of 4)		22/09/10			01/10/2010		08/11/2010	B		02/09/2011			06 09/2011							

2 BCL-AC-XX-SH-001														1st Submission											2nd Submission											OVERDUE
			Action By	Drawing Number	Drawing Title	Date Required from Consultant	Date Submitted by Consultant	Document Revision	Planned Date to be Submitted to Board	Date Submitted to Board	Date Response Required from Board (+3 Weeks)	Date Returned from Board	Board Status	Date returned to Consultant	Date Required from Consultant	Date Submitted by Consultant	Document Revision	Planned Date to be Submitted to Board	Date Submitted to Board	BMCE TRANSMITTAL NO	Date Response Required from Board (+4 Weeks)	Date Received from Board	Board Status	Date Returned to Consultant	OVERDUE											
Item	Submission	Comments																																		
			NA	NA-XX-12-PL-252-102	Two th Floor Plan - Plant (2 of 4)		22/09/10			01/10/2010		08/11/2010	B		02/09/2011			06 09/2011		DEPARTMENTAL LAYOUT COLOUR DRAWINGS SUBMITTED - BMCE-TRANSMIT-005009																
			NA	NA-XX-12-PL-252-103	Two th Floor Plan - Plant (3 of 4)		22/09/10			01/10/2010		08/11/2010	B		02/09/2011			06 09/2011																		
			NA	NA-XX-12-PL-252-104	Two th Floor Plan - Plant (4 of 4)		22/09/10			01/10/2010		08/11/2010	A		02/09/2011			06 09/2011																		
			NA	NA-xx-13-PL-252-102	Thirteenth Floor Plan - Ramp Access to Helipad		22/09/10			01/10/2010		08/11/2010	A		02/09/2011			06 09/2011																		
			NA	NA-xx-14-PL-252-102	Fourteenth Floor Plan - Helipad		22/09/10			01/10/2010		08/11/2010	A		02/09/2011			06 09/2011																		
	Departmental Layouts - Colour 1:200's		NA	NA-XX-B1-PL-252-400	Basement Plan - Kitchen FM Stores Distribution Bed Maintenance & AGV Charging					App K Date			App K Status		02/09/2011	02/09/2011	6	06 09/2011	12/09/2011	BMCE-TRANSMIT-005009	10/10/2011	17/10/2011	A	25/11/2011 BMCE TRANSMIT-006859												
			NA	NA-XX-B1-PL-252-401	Basement Plan - Kitchen FM Stores Distribution					App K Date			App K Status		02/09/2011	02/09/2011	1	06 09/2011	12/09/2011	BMCE-TRANSMIT-005009	10/10/2011	17/10/2011	A	25/11/2011 BMCE TRANSMIT-006859												
		Produced for information during user group meetings. Not required for RDD issue.	NA	NA-XX-00-PL-252-400	Ground Floor Plan - NSGH Entrance Reception and Atrium Space					App K Date			App K Status		02/09/2011			06 09/2011																		
			NA	NA-XX-00-PL-252-401	Ground Floor Plan - NCH Rehab					App K Date			App K Status		02/09/2011	02/09/2011	6	06 09/2011	12/09/2011	BMCE-TRANSMIT-005009	10/10/2011	17/10/2011	A	25/11/2011 BMCE TRANSMIT-006859												
			NA	NA-XX-00-PL-252-402	Ground Floor Plan - NCH Entrance and OPD					App K Date			App K Status		02/09/2011	02/09/2011	8	06 09/2011	12/09/2011	BMCE-TRANSMIT-005009	10/10/2011	17/10/2011	A	25/11/2011 BMCE TRANSMIT-006859												
			NA	NA-XX-00-PL-252-403	Ground Floor Plan - NCH Observation Ward / Child Protection / Sanctuary					App K Date			App K Status		02/09/2011	02/09/2011	6	06 09/2011	12/09/2011	BMCE-TRANSMIT-005009	10/10/2011	17/10/2011	A	25/11/2011 BMCE TRANSMIT-006859												
			NA	NA-XX-00-PL-252-404	Ground Floor Plan - NCH Emergency Department / Decontamination Unit					App K Date			App K Status		02/09/2011	02/09/2011	7	06 09/2011	12/09/2011	BMCE-TRANSMIT-005009	10/10/2011	17/10/2011	A	25/11/2011 BMCE TRANSMIT-006859												
			NA	NA-XX-00-PL-252-405	Ground Floor Plan - NSGH Emergency Department					App K Date			App K Status		02/09/2011	02/09/2011	9	06 09/2011	12/09/2011	BMCE-TRANSMIT-005009	10/10/2011	17/10/2011	A	25/11/2011 BMCE TRANSMIT-006859												
			NA	NA-XX-00-PL-252-406	Ground Floor Plan - NSGH Acute Assessment					App K Date			App K Status		02/09/2011	02/09/2011	6	06 09/2011	12/09/2011	BMCE-TRANSMIT-005009	10/10/2011	17/10/2011	A	25/11/2011 BMCE TRANSMIT-006859												
			NA	NA-XX-00-PL-252-407	Ground Floor Plan - NSGH Radiology / Medical Illustration					App K Date			App K Status		02/09/2011	02/09/2011	14	06 09/2011	12/09/2011	BMCE-TRANSMIT-005009	10/10/2011	17/10/2011	A	25/11/2011 BMCE TRANSMIT-006859												
			NA	NA-XX-00-PL-252-408	Ground Floor Plan - NCH Radiology					App K Date			App K Status		02/09/2011	02/09/2011	6	06 09/2011	12/09/2011	BMCE-TRANSMIT-005009	10/10/2011	17/10/2011	A	25/11/2011 BMCE TRANSMIT-006859												
		Departmental plans are not required for RDD. Drawings were issued for information only and for use during user group meetings.	NA	NA-XX-00-PL-252-409	Ground Floor Plan - NSGH OPD / Rehab & Therapies					App K Date			App K Status		02/09/2011	02/09/2011	7	06 09/2011	12/09/2011	BMCE-TRANSMIT-005009	10/10/2011	17/10/2011	B	25/11/2011 BMCE TRANSMIT-006859												
		Departmental plans are not required for RDD. Drawings were issued for information only and for use during user group meetings.	NA	NA-XX-00-PL-252-411	Ground Floor Plan - Entrance Reception Atrium Space Pharmacy FM Offices & Discharge Lounge					App K Date			App K Status		02/09/2011	02/09/2011	10	06 09/2011	12/09/2011	BMCE-TRANSMIT-005009	10/10/2011	17/10/2011	B	25/11/2011 BMCE TRANSMIT-006859												
		Departmental plans are not required for RDD. Drawings were issued for information only and for use during user group meetings.	NA	NA-XX-01-PL-252-400	First Floor Plan - NSGH Restaurant Sanctuary and Atrium Space					App K Date			App K Status		02/09/2011	02/09/2011	9	06 09/2011	12/09/2011	BMCE-TRANSMIT-005009	10/10/2011	17/10/2011	B	25/11/2011 BMCE TRANSMIT-006859												
			NA	NA-XX-01-PL-252-401	First Floor Plan - NCH Theatres / Interventional Radiology and Radiology					App K Date			App K Status		02/09/2011	02/09/2011	10	06 09/2011	12/09/2011	BMCE-TRANSMIT-005009	10/10/2011	17/10/2011	A	25/11/2011 BMCE TRANSMIT-006859												
			NA	NA-XX-01-PL-252-402	First Floor Plan - NCH 23 Hour Unit					App K Date			App K Status		02/09/2011	02/09/2011	6	06 09/2011	12/09/2011	BMCE-TRANSMIT-005009	10/10/2011	17/10/2011	A	25/11/2011 BMCE TRANSMIT-006859												
			NA	NA-XX-01-PL-252-403	First Floor Plan - NCH Critical Care (PICU) / Cardiology Ward / Support / MDU and Special Feeds					App K Date			App K Status		02/09/2011	02/09/2011	11	06 09/2011	12/09/2011	BMCE-TRANSMIT-005009	10/10/2011	17/10/2011	A	25/11/2011 BMCE TRANSMIT-006859												
			NA	NA-XX-01-PL-252-404	First Floor Plan - NSGH CCU and Cri ical Care (1 of 2)					App K Date			App K Status		02/09/2011	02/09/2011	8	06 09/2011	12/09/2011	BMCE-TRANSMIT-005009	10/10/2011	17/10/2011	A	25/11/2011 BMCE TRANSMIT-006859												
			NA	NA-XX-01-PL-252-405	First Floor Plan - NSGH Critical Care (2 of 2)					App K Date			App K Status		02/09/2011	02/09/2011	6	06 09/2011	12/09/2011	BMCE-TRANSMIT-005009	10/10/2011	17/10/2011	A	25/11/2011 BMCE TRANSMIT-006859												

2 BCL-AC-XX-SH-001															1st Submission												2nd Submission												OVERDUE
			Action By	Drawing Number	Drawing Title	Date Required from Consultant	Date Submitted by Consultant	Document Revision	Planned Date to be Submitted to Board	Date Submitted to Board	Date Response Required from Board (+3 Weeks)	Date Returned from Board	Board Status	Date returned to Consultant	Date Required from Consultant	Date Submitted by Consultant	Document Revision	Planned Date to be Submitted to Board	Date Submitted to Board	BMCE TRANSMITTAL NO	Date Response Required from Board (+4 Weeks)	Date Received from Board	Board Status	Date Returned to Consultant	OVERDUE														
Item	Submission	Comments																																					
		Departmental plans are not required for RDD. Drawings were issued for information only and for use during user group meetings.	NA	NA-XX-01-PL-252-406	First Floor Plan - NSGH Stroke Ward / MDU / Pre Assessment					App K Date			App K Status		02/09/2011	02/09/2011	9	06 09/2011	12/09/2011	BMCE-TRANSMIT-005009	10/10/2011	17/10/2011	B	25/11/2011 BMCE TRANSMIT-006859															
			NA	NA-XX-01-PL-252-407	First Floor Plan - NSGH Radiology					App K Date			App K Status		02/09/2011	02/09/2011	9	06 09/2011	12/09/2011	BMCE-TRANSMIT-005009	10/10/2011	17/10/2011	A	25/11/2011 BMCE TRANSMIT-006859															
			NA	NA-XX-01-PL-252-408	First Floor Plan - NSGH Nuclear Medicine					App K Date			App K Status		02/09/2011	02/09/2011	6	06 09/2011	12/09/2011	BMCE-TRANSMIT-005009	10/10/2011	17/10/2011	A	25/11/2011 BMCE TRANSMIT-006859															
			NA	NA-XX-01-PL-252-409	First Floor Plan - NSGH OPD & Pre-op Assessment					App K Date			App K Status		02/09/2011	02/09/2011	9	06 09/2011	12/09/2011	BMCE-TRANSMIT-005009	10/10/2011	17/10/2011	A	25/11/2011 BMCE TRANSMIT-006859															
		Departmental plans are not required for RDD. Drawings were issued for information only and for use during user group meetings. Can be updated at end of project for record purposes.	NA	NA-XX-02-PL-252-400	Second Floor Plan - NSGH Atrium					App K Date			App K Status		02/09/2011	02/09/2011	5	06 09/2011	12/09/2011	BMCE-TRANSMIT-005009	10/10/2011	17/10/2011	B	25/11/2011 BMCE TRANSMIT-006859															
			NA	NA-XX-02-PL-252-401	Second Floor Plan - NSGH Dermatology Ward + Plant					App K Date			App K Status		02/09/2011	02/09/2011	6	06 09/2011	12/09/2011	BMCE-TRANSMIT-005009	10/10/2011	17/10/2011	A	25/11/2011 BMCE TRANSMIT-006859															
		Departmental plans are not required for RDD. Drawings were issued for information only and for use during user group meetings.	NA	NA-XX-02-PL-252-402	Second Floor Plan - NCH Schiehallion Ward / Day Case Unit / Theatres and Anaesthetic Service Offices					App K Date			App K Status		02/09/2011	02/09/2011	9	06 09/2011	12/09/2011	BMCE-TRANSMIT-005009	10/10/2011	17/10/2011	B	25/11/2011 BMCE TRANSMIT-006859															
		Departmental plans are not required for RDD. Drawings were issued for information only and for use during user group meetings.	NA	NA-XX-02-PL-252-403	Second Floor Plan - NCH Acute Receiving Ward					App K Date			App K Status		02/09/2011	02/09/2011	6	06 09/2011	12/09/2011	BMCE-TRANSMIT-005009	10/10/2011	17/10/2011	B	25/11/2011 BMCE TRANSMIT-006859															
			NA	NA-XX-02-PL-252-404	Second Floor Plan - NSGH Endoscopy / Decontamination / Medical Physics / Stores					App K Date			App K Status		02/09/2011	02/09/2011	13	06 09/2011	12/09/2011	BMCE-TRANSMIT-005009	10/10/2011	17/10/2011	A	25/11/2011 BMCE TRANSMIT-006859															
			NA	NA-XX-02-PL-252-405	Second Floor Plan - NSGH Theatres (1 of 2) + Plant					App K Date			App K Status		02/09/2011	05/09/2011	9	06 09/2011	12/09/2011	BMCE-TRANSMIT-005009	10/10/2011	17/10/2011	A	25/11/2011 BMCE TRANSMIT-006859															
			NA	NA-XX-02-PL-252-406	Second Floor Plan - NSGH Theatres (2 of 2) + Plant					App K Date			App K Status		02/09/2011			06 09/2011	12/09/2011	BMCE-TRANSMIT-005009	10/10/2011	17/10/2011	A	25/11/2011 BMCE TRANSMIT-006859															
			NA	NA-XX-02-PL-252-409	Second Floor Plan - NSGH Dermatology OPD / Renal Dialysis					App K Date			App K Status		02/09/2011	02/09/2011	8	06 09/2011	12/09/2011	BMCE-TRANSMIT-005009	10/10/2011	17/10/2011	A	25/11/2011 BMCE TRANSMIT-006859															
			NA	NA-XX-02-PL-252-415	Second Floor Plan - NSGH Theatres					App K Date			App K Status		02/09/2011	02/09/2011	6	06 09/2011	12/09/2011	BMCE-TRANSMIT-005009	10/10/2011	17/10/2011	A	25/11/2011 BMCE TRANSMIT-006859															
		Departmental plans are not required for RDD. Drawings were issued for information only and for use during user group meetings.	NA	NA-xx-03-PL-252-400	Third Floor Plan - NSGH Atrium					App K Date			App K Status		02/09/2011	02/09/2011	8	06 09/2011	12/09/2011	BMCE-TRANSMIT-005009	10/10/2011	17/10/2011	B	25/11/2011 BMCE TRANSMIT-006859															
			NA	NA-xx-03-PL-252-401	Third Floor Plan - PLANT					App K Date			App K Status		02/09/2011	02/09/2011	1	06 09/2011	12/09/2011	BMCE-TRANSMIT-005009	10/10/2011	17/10/2011	A	25/11/2011 BMCE TRANSMIT-006859															
		Departmental plans are not required for RDD. Drawings were issued for information only and for use during user group meetings.	NA	NA-xx-03-PL-252-402	Third Floor Plan - NCH In-Patient Ward					App K Date			App K Status		02/09/2011	02/09/2011	6	06 09/2011	12/09/2011	BMCE-TRANSMIT-005009	10/10/2011	17/10/2011	B	25/11/2011 BMCE TRANSMIT-006859															
			NA	NA-xx-03-PL-252-403	Third Floor Plan - NCH In-Patient Ward / Ward Support					App K Date			App K Status		02/09/2011	02/09/2011	7	06 09/2011	12/09/2011	BMCE-TRANSMIT-005009	10/10/2011	17/10/2011	A	25/11/2011 BMCE TRANSMIT-006859															
			NA	NA-xx-03-PL-252-405	Third Floor Plan - PLANT					App K Date			App K Status		02/09/2011	02/09/2011	1	06 09/2011	12/09/2011	BMCE-TRANSMIT-005009	10/10/2011	17/10/2011	A	25/11/2011 BMCE TRANSMIT-006859															
			NA	NA-xx-03-PL-252-406	Third Floor Plan - PLANT					App K Date			App K Status		02/09/2011	02/09/2011	1	06 09/2011	12/09/2011	BMCE-TRANSMIT-005009	10/10/2011	17/10/2011	A	25/11/2011 BMCE TRANSMIT-006859															
			NA	NA-xx-03-PL-252-409	Third Floor Plan - PLANT					App K Date			App K Status		02/09/2011	02/09/2011	1	06 09/2011	12/09/2011	BMCE-TRANSMIT-005009	10/10/2011	17/10/2011	A	25/11/2011 BMCE TRANSMIT-006859															
		Produced for information during user group meetings. Not required for RDD issue.	NA	NA-xx-04-PL-252-400	Fourth Floor Plan - NSGH Atrium + Lift Core					App K Date			App K Status		02/09/2011			06 09/2011																					
		Produced for information during user group meetings. Not required for RDD issue.	NA	NA-xx-04-PL-252-401	Fourth Floor Plan - Higher Acuity Renal Ward					App K Date			App K Status		02/09/2011			06 09/2011																					
			NA	NA-xx-04-PL-252-402	Fourth Floor Plan - NCH DCFP					App K Date			App K Status		02/09/2011	02/09/2011	6	06 09/2011	12/09/2011	BMCE-TRANSMIT-005009	10/10/2011	17/10/2011	A	25/11/2011 BMCE TRANSMIT-006859															
			NA	NA-xx-04-PL-252-403	Fourth Floor Plan - Haemo-Oncology Ward					App K Date			App K Status		02/09/2011	02/09/2011	5	06 09/2011	12/09/2011	BMCE-TRANSMIT-005009	10/10/2011	17/10/2011	A	25/11/2011 BMCE TRANSMIT-006859															
		Produced for information during user group meetings. Not required for RDD issue.	NA	NA-xx-04-PL-252-404	Fourth Floor Plan - NSGH Generic Ward (1 of 2)					App K Date			App K Status																										
		Produced for information during user group meetings. Not required for RDD issue.	NA	NA-xx-04-PL-252-405	Fourth Floor Plan - NSGH Generic Ward (1 of 2)					App K Date			App K Status																										
			NA	NA-xx-04-PL-252-406	Fourth Floor Plan - NCH Plant					App K Date			App K Status		02/09/2011	02/09/2011	1	06 09/2011	12/09/2011	BMCE-TRANSMIT-005009	10/10/2011	17/10/2011	A	25/11/2011 BMCE TRANSMIT-006859															
		Departmental plans are not required for RDD. Drawings were issued for information only and for use during user group meetings.	NA	NA-XX-04-PL-252-411	Fourth Floor Plan - NSGH Generice Ward Support Higher Acuity Renal Ward & Renal Ward										02/09/2011	02/09/2011	6	06 09/2011	12/09/2011	BMCE-TRANSMIT-005009	10/10/2011	17/10/2011	B	25/11/2011 BMCE TRANSMIT-006859															
		NA	NA-xx-05-PL-252-400	Fifth Floor Plan - NSGH Atrium + Lift Core					App K Date			App K Status		02/09/2011	02/09/2011	1	06 09/2011	12/09/2011	BMCE-TRANSMIT-005009	10/10/2011	17/10/2011	A	25/11/2011 BMCE TRANSMIT-006859																

2 BCL-AC-XX-SH-001														1st Submission											2nd Submission											OVERDUE
			Action By	Drawing Number	Drawing Title	Date Required from Consultant	Date Submitted by Consultant	Document Revision	Planned Date to be Submitted to Board	Date Submitted to Board	Date Response Required from Board (+3 Weeks)	Date Returned from Board	Board Status	Date returned to Consultant	Date Required from Consultant	Date Submitted by Consultant	Document Revision	Planned Date to be Submitted to Board	Date Submitted to Board	BMCE TRANSMITTAL NO	Date Response Required from Board (+4 Weeks)	Date Received from Board	Board Status	Date Returned to Consultant	OVERDUE											
Item	Submission	Comments																																		
			NA	NA-xx-05-PL-252-401	Fifth Floor Plan - NSGH Generic Ward (1 of 4)					App K Date			App K Status		02/09/2011	02/09/2011	2	06 09/2011	12/09/2011	BMCE-TRANSMIT-005009	10/10/2011	17/10/2011	A	25/11/2011 BMCE TRANSMIT-006859												
			NA	NA-xx-05-PL-252-402	Fifth Floor Plan - NSGH Generic Ward (2 of 4)					App K Date			App K Status		02/09/2011	02/09/2011	2	06 09/2011	12/09/2011	BMCE-TRANSMIT-005009	10/10/2011	17/10/2011	A	25/11/2011 BMCE TRANSMIT-006859												
			NA	NA-xx-05-PL-252-403	Fifth Floor Plan - NSGH Generic Ward (3 of 4)					App K Date			App K Status		02/09/2011	02/09/2011	2	06 09/2011	12/09/2011	BMCE-TRANSMIT-005009	10/10/2011	17/10/2011	A	25/11/2011 BMCE TRANSMIT-006859												
			NA	NA-xx-05-PL-252-404	Fifth Floor Plan - NSGH Generic Ward (4 of 4)					App K Date			App K Status		02/09/2011	02/09/2011	2	06 09/2011	12/09/2011	BMCE-TRANSMIT-005009	10/10/2011	17/10/2011	A	25/11/2011 BMCE TRANSMIT-006859												
			NA	NA-XX-06-PL-252-400	Sixth Floor Plan - NSGH Atrium + Lift Core					App K Date			App K Status		02/09/2011	02/09/2011	7	06 09/2011	12/09/2011	BMCE-TRANSMIT-005009	10/10/2011	17/10/2011	A	25/11/2011 BMCE TRANSMIT-006859												
			NA	NA-XX-06-PL-252-401	Sixth Floor Plan - NSGH Generic Ward (1 of 4)					App K Date			App K Status		02/09/2011	02/09/2011	7	06 09/2011	12/09/2011	BMCE-TRANSMIT-005009	10/10/2011	17/10/2011	A	25/11/2011 BMCE TRANSMIT-006859												
			NA	NA-XX-06-PL-252-402	Sixth Floor Plan - NSGH Generic Ward (2 of 4)					App K Date			App K Status		02/09/2011	02/09/2011	3	06 09/2011	12/09/2011	BMCE-TRANSMIT-005009	10/10/2011	17/10/2011	A	25/11/2011 BMCE TRANSMIT-006859												
			NA	NA-XX-06-PL-252-403	Sixth Floor Plan - NSGH Generic Ward (3 of 4)					App K Date			App K Status		02/09/2011	02/09/2011	1	06 09/2011	12/09/2011	BMCE-TRANSMIT-005009	10/10/2011	17/10/2011	A	25/11/2011 BMCE TRANSMIT-006859												
			NA	NA-XX-06-PL-252-404	Sixth Floor Plan - NSGH Generic Ward (4 of 4)					App K Date			App K Status		02/09/2011	02/09/2011	1	06 09/2011	12/09/2011	BMCE-TRANSMIT-005009	10/10/2011	17/10/2011	A	25/11/2011 BMCE TRANSMIT-006859												
		Departmental plans are not required for RDD. Drawings were issued for information only and for use during user group meetings.	NA	NA-XX-07-PL-252-400	Seventh Floor Plan - NSGH Atrium + Lft Core					App K Date			App K Status		02/09/2011	02/09/2011	1	06 09/2011	12/09/2011	BMCE-TRANSMIT-005009	10/10/2011	17/10/2011	B	25/11/2011 BMCE TRANSMIT-006859												
			NA	NA-XX-07-PL-252-401	Seventh Floor Plan - NSGH Generic Ward (1 of 4)					App K Date			App K Status		02/09/2011	02/09/2011	1	06 09/2011	12/09/2011	BMCE-TRANSMIT-005009	10/10/2011	17/10/2011	A	25/11/2011 BMCE TRANSMIT-006859												
			NA	NA-XX-07-PL-252-402	Seventh Floor Plan - NSGH Generic Ward (2 of 4)					App K Date			App K Status		02/09/2011	02/09/2011	1	06 09/2011	12/09/2011	BMCE-TRANSMIT-005009	10/10/2011	17/10/2011	A	25/11/2011 BMCE TRANSMIT-006859												
			NA	NA-XX-07-PL-252-403	Seventh Floor Plan - NSGH Generic Ward (3 of 4)					App K Date			App K Status		02/09/2011	02/09/2011	1	06 09/2011	12/09/2011	BMCE-TRANSMIT-005009	10/10/2011	17/10/2011	A	25/11/2011 BMCE TRANSMIT-006859												
			NA	NA-XX-07-PL-252-404	Seventh Floor Plan - NSGH Generic Ward (4 of 4)					App K Date			App K Status		02/09/2011	02/09/2011	1	06 09/2011	12/09/2011	BMCE-TRANSMIT-005009	10/10/2011	17/10/2011	A	25/11/2011 BMCE TRANSMIT-006859												
			NA	NA-XX-08-PL-252-400	Eighth Floor Plan - NSGH Atrium + Lift Core					App K Date			App K Status		02/09/2011	02/09/2011	1	06 09/2011	12/09/2011	BMCE-TRANSMIT-005009	10/10/2011	17/10/2011	A	25/11/2011 BMCE TRANSMIT-006859												
			NA	NA-XX-08-PL-252-401	Eighth Floor Plan - NSGH Generic Ward (1 of 4)					App K Date			App K Status		02/09/2011	02/09/2011	1	06 09/2011	12/09/2011	BMCE-TRANSMIT-005009	10/10/2011	17/10/2011	A	25/11/2011 BMCE TRANSMIT-006859												
			NA	NA-XX-08-PL-252-402	Eighth Floor Plan - NSGH Generic Ward (2 of 4)					App K Date			App K Status		02/09/2011	02/09/2011	1	06 09/2011	12/09/2011	BMCE-TRANSMIT-005009	10/10/2011	17/10/2011	A	25/11/2011 BMCE TRANSMIT-006859												
			NA	NA-XX-08-PL-252-403	Eighth Floor Plan - NSGH Generic Ward (3 of 4)					App K Date			App K Status		02/09/2011	02/09/2011	1	06 09/2011	12/09/2011	BMCE-TRANSMIT-005009	10/10/2011	17/10/2011	A	25/11/2011 BMCE TRANSMIT-006859												
			NA	NA-XX-08-PL-252-404	Eighth Floor Plan - NSGH Generic Ward (4 of 4)					App K Date			App K Status		02/09/2011	02/09/2011	1	06 09/2011	12/09/2011	BMCE-TRANSMIT-005009	10/10/2011	17/10/2011	A	25/11/2011 BMCE TRANSMIT-006859												
			NA	NA-XX-09-PL-252-400	Ninth Floor Plan - NSGH Atrium + Lift Core					App K Date			App K Status		02/09/2011	02/09/2011	1	06 09/2011	12/09/2011	BMCE-TRANSMIT-005009	10/10/2011	17/10/2011	A	25/11/2011 BMCE TRANSMIT-006859												
			NA	NA-XX-09-PL-252-401	Ninth Floor Plan - NSGH Generic Ward (1 of 4)					App K Date			App K Status		02/09/2011	02/09/2011	1	06 09/2011	12/09/2011	BMCE-TRANSMIT-005009	10/10/2011	17/10/2011	A	25/11/2011 BMCE TRANSMIT-006859												
			NA	NA-XX-09-PL-252-402	Ninth Floor Plan - NSGH Generic Ward (2 of 4)					App K Date			App K Status		02/09/2011	02/09/2011	1	06 09/2011	12/09/2011	BMCE-TRANSMIT-005009	10/10/2011	17/10/2011	A	25/11/2011 BMCE TRANSMIT-006859												
			NA	NA-XX-09-PL-252-403	Ninth Floor Plan - NSGH Generic Ward (3 of 4)					App K Date			App K Status		02/09/2011	02/09/2011	1	06 09/2011	12/09/2011	BMCE-TRANSMIT-005009	10/10/2011	17/10/2011	A	25/11/2011 BMCE TRANSMIT-006859												
			NA	NA-XX-09-PL-252-404	Ninth Floor Plan - NSGH Generic Ward (4 of 4)					App K Date			App K Status		02/09/2011	02/09/2011	1	06 09/2011	12/09/2011	BMCE-TRANSMIT-005009	10/10/2011	17/10/2011	A	25/11/2011 BMCE TRANSMIT-006859												
			NA	NA-XX-10-PL-252-400	Tenth Floor Plan - NSGH Atrium + Lift Core					App K Date			App K Status		02/09/2011	02/09/2011	1	06 09/2011	12/09/2011	BMCE-TRANSMIT-005009	10/10/2011	17/10/2011	A	25/11/2011 BMCE TRANSMIT-006859												
			NA	NA-XX-10-PL-252-401	Tenth Floor Plan - NSGH Generic Ward (1 of 4)					App K Date			App K Status		02/09/2011	02/09/2011	1	06 09/2011	12/09/2011	BMCE-TRANSMIT-005009	10/10/2011	17/10/2011	A	25/11/2011 BMCE TRANSMIT-006859												
			NA	NA-XX-10-PL-252-402	Tenth Floor Plan - NSGH Generic Ward (2 of 4)					App K Date			App K Status		02/09/2011	02/09/2011	1	06 09/2011	12/09/2011	BMCE-TRANSMIT-005009	10/10/2011	17/10/2011	A	25/11/2011 BMCE TRANSMIT-006859												
			NA	NA-XX-10-PL-252-403	Tenth Floor Plan - NSGH Generic Ward (3 of 4)					App K Date			App K Status		02/09/2011	02/09/2011	1	06 09/2011	12/09/2011	BMCE-TRANSMIT-005009	10/10/2011	17/10/2011	A	25/11/2011 BMCE TRANSMIT-006859												
			NA	NA-XX-10-PL-252-404	Tenth Floor Plan - NSGH Generic Ward (4 of 4)					App K Date			App K Status		02/09/2011	02/09/2011	1	06 09/2011	12/09/2011	BMCE-TRANSMIT-005009	10/10/2011	17/10/2011	A	25/11/2011 BMCE TRANSMIT-006859												
			NA	NA-XX-11-PL-252-400	Eleventh Floor Plan - NSGH Atrium + Lift Core					App K Date			App K Status		02/09/2011	02/09/2011	1	06 09/2011	12/09/2011	BMCE-TRANSMIT-005009	10/10/2011	17/10/2011	A	25/11/2011 BMCE TRANSMIT-006859												
			NA	NA-XX-11-PL-252-401	Eleventh Floor Plan - NSGH Generic Ward (1 of 4)					App K Date			App K Status		02/09/2011	02/09/2011	1	06 09/2011	12/09/2011	BMCE-TRANSMIT-005009	10/10/2011	17/10/2011	A	25/11/2011 BMCE TRANSMIT-006859												

2 BCL-AC-XX-SH-001			1st Submission											2nd Submission											OVERDUE
			Action By	Drawing Number	Drawing Title	Date Required from Consultant	Date Submitted by Consultant	Document Revision	Planned Date to be Submitted to Board	Date Submitted to Board	Date Response Required from Board (+3 Weeks)	Date Returned from Board	Board Status	Date returned to Consultant	Date Required from Consultant	Date Submitted by Consultant	Document Revision	Planned Date to be Submitted to Board	Date Submitted to Board	BMCE TRANSMITTAL NO	Date Response Required from Board (+4 Weeks)	Date Received from Board	Board Status	Date Returned to Consultant	OVERDUE
Item	Submission	Comments																							
			NA	NA-XX-11-PL-252-402	Eleventh Floor Plan - NSGH Generic Ward (2 of 4)					App K Date			App K Status		02/09/2011	02/09/2011	1	06 09/2011	12/09/2011	BMCE-TRANSMIT-005009	10/10/2011	17/10/2011	A	25/11/2011 BMCE TRANSMIT-006859	
			NA	NA-XX-11-PL-252-403	Eleventh Floor Plan - NSGH Generic Ward (3 of 4)					App K Date			App K Status		02/09/2011	02/09/2011	1	06 09/2011	12/09/2011	BMCE-TRANSMIT-005009	10/10/2011	17/10/2011	A	25/11/2011 BMCE TRANSMIT-006859	
			NA	NA-XX-11-PL-252-404	Eleventh Floor Plan - NSGH Generic Ward (4 of 4)					App K Date			App K Status		02/09/2011	02/09/2011	1	06 09/2011	12/09/2011	BMCE-TRANSMIT-005009	10/10/2011	17/10/2011	A	25/11/2011 BMCE TRANSMIT-006859	
			NA	NA-XX-12-PL-252-400	Twelfth Floor Plan - NSGH Atrium / Lift Cores					App K Date			App K Status		02/09/2011	02/09/2011	1	06 09/2011	12/09/2011	BMCE-TRANSMIT-005009	10/10/2011	17/10/2011	A	25/11/2011 BMCE TRANSMIT-006859	
			NA	NA-XX-12-PL-252-401	Two fth Floor Plan - Plant (1 of 4)					App K Date			App K Status		02/09/2011	02/09/2011	1	06 09/2011	12/09/2011	BMCE-TRANSMIT-005009	10/10/2011	17/10/2011	A	25/11/2011 BMCE TRANSMIT-006859	
			NA	NA-XX-12-PL-252-402	Two fth Floor Plan - Plant (2 of 4)					App K Date			App K Status		02/09/2011	02/09/2011	1	06 09/2011	12/09/2011	BMCE-TRANSMIT-005009	10/10/2011	17/10/2011	A	25/11/2011 BMCE TRANSMIT-006859	
			NA	NA-XX-12-PL-252-403	Two fth Floor Plan - Plant (3 of 4)					App K Date			App K Status		02/09/2011	02/09/2011	1	06 09/2011	12/09/2011	BMCE-TRANSMIT-005009	10/10/2011	17/10/2011	A	25/11/2011 BMCE TRANSMIT-006859	
			NA	NA-XX-12-PL-252-404	Two fth Floor Plan - Plant (4 of 4)					App K Date			App K Status		02/09/2011	02/09/2011	1	06 09/2011	12/09/2011	BMCE-TRANSMIT-005009	10/10/2011	17/10/2011	A	25/11/2011 BMCE TRANSMIT-006859	
			NA	NA-xx-13-PL-252-402	Thirteenth Floor Plan - Ramp Access to Helipad					App K Date			App K Status		02/09/2011	02/09/2011	1	06 09/2011	12/09/2011	BMCE-TRANSMIT-005009	10/10/2011	17/10/2011	A	25/11/2011 BMCE TRANSMIT-006859	
			NA	NA-xx-14-PL-252-402	Fourteenth Floor Plan - Helipad					App K Date			App K Status		02/09/2011	02/09/2011	1	06 09/2011	12/09/2011	BMCE-TRANSMIT-005009	10/10/2011	17/10/2011	A	25/11/2011 BMCE TRANSMIT-006859	

[illegible]

Final Submission								
Date Required from Consultant	Date Submitted by Consultant	Document Revision	Planned Date to be Submitted to Board	Date Submitted to Board	Date Response Required from Board, if Applicable	Date Returned from Board	Board Status	Date returned to Consultant
23/06/2012	06/07/2012	B	06/07/2012	BMCE-TRANSMIT-00952 14/07/12	06/08/2012	15/10/2012	B	BMCE-TRANSMIT 011627 15/10/2012
03/08/2012	20/07/2012	B	17/08/2012	BMCE-TRANSMIT-00952 20/07/12	10/08/2012	25/10/2012	B	BMCE-TRANSMIT 012062 01/11/2012
03/08/2012	20/07/2012	B	17/08/2012	BMCE-TRANSMIT-00952 20/07/12	10/08/2012	25/10/2012	B	BMCE-TRANSMIT 012062 01/11/2012
06/07/2012	03/08/2012	B	20/07/2012	BMCE-TRANSMIT-010163 06/08/12	27/08/2012	15/10/2012	B	BMCE-TRANSMIT 011717 18/10/2012
31/08/2012	06/10/2012	B	14/09/2012	BMCE-TRANSMIT-0011427 08/10/2012	29/10/2012	20/12/2012	B	BMCE-TRANSMIT 012293 14/01/2013
31/08/2012	06/10/2012	B	14/09/2012	BMCE-TRANSMIT-0011427 08/10/2012	29/10/2012	20/12/2012	B	BMCE-TRANSMIT 012293 14/01/2013
13/08/2012	05/10/2012	A	14/09/2012	BMCE-TRANSMIT-011523 10/10/2012	31/10/2012	20/11/2012	B	BMCE-TRANSMIT 012462 20/11/2012
31/08/2012	06/10/2012	B	14/09/2012	BMCE-TRANSMIT-0011427 08/10/2012	29/10/2012	20/12/2012	A	BMCE-TRANSMIT 012293 14/01/2013
08/06/2012	09/07/2012	B	22/06/2012	BMCE-TRANSMIT-000744 09/07/12	30/07/2012		B	BMCE-TRANSMIT 011155 26/09/2012
08/06/2012	09/07/2012	B	22/06/2012	BMCE-TRANSMIT-000744 09/07/12	30/07/2012	29/08/2012	B	BMCE-TRANSMIT 010836 14/09/2012
08/06/2012	09/07/2012	B	22/06/2012	BMCE-TRANSMIT-000744 09/07/12	30/07/2012		B	BMCE-TRANSMIT 011155 26/09/2012
08/06/2012	09/07/2012	B	22/06/2012	BMCE-TRANSMIT-000744 09/07/12	30/07/2012		B	BMCE-TRANSMIT 011155 26/09/2012
08/06/2012	06/07/2012	B	22/06/2012	BMCE-TRANSMIT-000743 09/07/12	30/07/2012	17/08/2012	A	BMCE-TRANSMIT 010566 29/08/2012
08/06/2012	06/07/2012	B	22/06/2012	BMCE-TRANSMIT-000743 09/07/12	30/07/2012		C	BMCE-TRANSMIT-000743 09/07-2012
06/07/2012	03/08/2012	B	20/07/2012	BMCE-TRANSMIT-010161 06/08/12	27/08/2012	15/10/2012	B	BMCE-TRANSMIT 011723 18/10/2012
06/07/2012	03/08/2012	B	20/07/2012	BMCE-TRANSMIT-010161 06/08/12	27/08/2012	15/10/2012	B	BMCE-TRANSMIT 011723 18/10/2012
06/07/2012	03/08/2012	B	20/07/2012	BMCE-TRANSMIT-010153 03/08/2012	24/08/2012	29/10/2012	B	BMCE-TRANSMIT 011961 31/10/2012
06/07/2012	03/08/2012	A	20/07/2012	BMCE-TRANSMIT-010153 03/08/2012	24/08/2012	29/10/2012	B	BMCE-TRANSMIT 011961 31/10/2012
06/07/2012	03/08/2012	B	20/07/2012	BMCE-TRANSMIT-010159 03/08/2012	24/08/2012	15/10/2012	B	BMCE-TRANSMIT 011721 18/10/2012
06/07/2012	03/08/2012	B	20/07/2012	BMCE-TRANSMIT-010152 03/08/2012	24/08/2012	18/10/2012	B	BMCE-TRANSMIT 011792 23/10/2012
06/07/2012	03/08/2012	A	20/07/2012	BMCE-TRANSMIT-010152 03/08/2012	24/08/2012	18/10/2012	B	BMCE-TRANSMIT-011792
06/07/2012	03/08/2012	B	20/07/2012	BMCE-TRANSMIT-010152 03/08/2012	24/08/2012	18/10/2012	B	BMCE-TRANSMIT 011792 23/10/2012
06/07/2012	03/08/2012	B	20/07/2012	BMCE-TRANSMIT-010162 06/08/12	27/08/2012	15/10/2012	B	BMCE-TRANSMIT 011746 18/10/2012
13/04/2012	25/05/2012	A	27/04/2012	BMCE-TRANSMIT-009152 29/05/12	19/06/2012	23/07/2012	B	BMCE-TRANSMIT 010868 30/07/2012
13/04/2012	25/05/2012	A	27/04/2012	BMCE-TRANSMIT-009152 29/05/12	19/06/2012	23/07/2012	B	BMCE-TRANSMIT 010868 30/07/2012
13/04/2012	25/05/2012	A	27/04/2012	BMCE-TRANSMIT-009156 29/05/12	19/06/2012	19/07/2012	B	BMCE-TRANSMIT 010871 30/07/2012
13/04/2012	25/05/2012	A	27/04/2012	BMCE-TRANSMIT-009156 29/05/12	19/06/2012	19/07/2012	B	BMCE-TRANSMIT 010871 30/07/2012
13/04/2012	25/05/2012	A	27/04/2012	BMCE-TRANSMIT-009156 29/05/12	19/06/2012	19/07/2012	B	BMCE-TRANSMIT 010871 30/07/2012
13/04/2012	25/05/2012	A	27/04/2012	BMCE-TRANSMIT-009156 29/05/12	19/06/2012	19/07/2012	B	BMCE-TRANSMIT 010871 30/07/2012
27/04/2012	08/06/2012	B	11/05/2012	BMCE-TRANSMIT-009321 12/06/12	03/07/2012	26/07/2012	A	BMCE-TRANSMIT 010894 30/07/2012
27/04/2012	08/06/2012	B	11/05/2012	BMCE-TRANSMIT-009321 12/06/12	03/07/2012	26/07/2012	B	BMCE-TRANSMIT 010894 30/07/2012
27/04/2012	08/06/2012	B	11/05/2012	BMCE-TRANSMIT-0091919 12/06/12	03/07/2012	23/07/2012	B	BMCE-TRANSMIT 010866 30/07/2012
27/04/2012	08/06/2012	B	11/05/2012	BMCE-TRANSMIT-009318 12/06/12	03/07/2012	20/07/2012	B	BMCE-TRANSMIT 010864 30/07/2012
27/04/2012	08/06/2012	B		BMCE-TRANSMIT-009316 11/05/2012	03/07/2012	31/07/2012	B	BMCE-TRANSMIT 010182 06/08/12
27/04/2012	08/06/2012	B		BMCE-TRANSMIT-009316 11/05/2012	03/07/2012	31/07/2012	B	BMCE-TRANSMIT 010182 06/08/12
27/04/2012	08/06/2012	B	11/05/2012	BMCE-TRANSMIT-009316 11/05/2012	03/07/2012	31/07/2012	B	BMCE-TRANSMIT 010182 06/08/12
27/04/2012	08/16/12	B	11/05/2012	BMCE-TRANSMIT-009335	03/07/2012	30/07/2012	C	BMCE-TRANSMIT 010891 31/07/2012
03/08/2012	20/07/2012	B	17/08/2012	BMCE-TRANSMIT-009952 20/07/12	10/08/2012	25/10/2012	B	BMCE-TRANSMIT 012062 02/11/2012
03/08/2012	20/07/2012	B	17/08/2012	BMCE-TRANSMIT-009952 20/07/12	10/08/2012	25/10/2012	B	BMCE-TRANSMIT 012062 02/11/2012
03/08/2012	20/07/2012	B	17/08/2012	BMCE-TRANSMIT-009952 20/07/12	10/08/2012	25/10/2012	B	BMCE-TRANSMIT 012062 02/11/2012
31/08/2012	06/10/2012	B	14/09/2012	BMCE-TRANSMIT-0011427 08/10/2012	29/10/2012	20/12/2012	A	BMCE-TRANSMIT 012293 14/01/2013
31/08/2012	20/07/2001	B	14/09/2012	BMCE-TRANSMIT-009948 20/07/12	10/08/2012	10/09/2012	B	BMCE-TRANSMIT 011909 10/09/2012
31/08/2012	20/07/2001	B	14/09/2012	BMCE-TRANSMIT-009948 20/07/12	10/08/2012	10/09/2012	A	BMCE-TRANSMIT 011909 10/09/2012
31/08/2012	20/07/2001	B	14/09/2012	BMCE-TRANSMIT-009948 20/07/12	10/08/2012	10/09/2012	A	BMCE-TRANSMIT 011909 10/09/2012
31/08/2012	20/07/2001	B	14/09/2012	BMCE-TRANSMIT-009948 20/07/12	10/08/2012	10/09/2012	B	BMCE-TRANSMIT 011909 10/09/2012
03/08/2012	14/09/2012	B	17/08/2012	BMCE-TRANSMIT-011624 19/08/2012	10/10/2012	30/10/2012	B	BMCE-TRANSMIT 012105 02/11/2012

Final Submission								
Date Required from Consultant	Date Submitted by Consultant	Document Revision	Planned Date to be Submitted to Board	Date Submitted to Board	Date Response Required from Board, if Applicable	Date Returned from Board	Board Status	Date returned to Consultant
03/08/2012	14/09/2012	B	17/08/2012	BMCE-TRANSMIT-011024 19/09/2012	10/10/2012	30/10/2012	B	BMCE-TRANSMIT 012105 05/11/2012
03/08/2012	14/09/2012	B	17/08/2012	BMCE-TRANSMIT-011024 19/09/2012	10/10/2012	30/10/2012	B	BMCE-TRANSMIT 012105 05/11/2012
03/08/2012	14/09/2012	B	17/08/2012	BMCE-TRANSMIT-011030 19/09/2012	10/10/2012	30/10/2012	B	BMCE-TRANSMIT 012085 05/11/2012
03/08/2012	14/09/2012	B	17/08/2012	BMCE-TRANSMIT-011030 19/09/2012	10/10/2012	30/10/2012	B	BMCE-TRANSMIT 012085 05/11/2012
08/08/2012	14/09/2012	B	22/08/2012	BMCE-TRANSMIT-011027 19/09/2012	10/10/2012	30/11/2012	B	BMCE-TRANSMIT 012083 05/11/2012
03/08/2012	14/09/2012	B	17/08/2012	BMCE-TRANSMIT-011032 19/09/2012	10/10/2012	30/10/2012	B	BMCE-TRANSMIT 012084 05/11/2012
03/08/2012	14/09/2012	B	17/08/2012	BMCE-TRANSMIT-011032 19/09/2012	10/10/2012	30/10/2012	B	BMCE-TRANSMIT 012090 22/11/2012
03/08/2012	17/09/2012	B	17/08/2012	BMCE-TRANSMIT-011033 19/09/2012	10/10/2012	30/10/2012	B	BMCE-TRANSMIT 012090 22/11/2012
03/08/2012	17/09/2012	B	17/08/2012	BMCE-TRANSMIT-011033 19/09/2012	10/10/2012	30/10/2012	B	BMCE-TRANSMIT 012090 22/11/2012
03/08/2012	14/09/2012	A	17/08/2012	BMCE-TRANSMIT-011023 19/09/2012	10/10/2012	30/10/2012	B	BMCE-TRANSMIT 012108 05/11/2012
31/08/2012	20/07/2001	B	14/09/2012	BMCE-TRANSMIT-009146 20/07/12	10/08/2012	10/09/2012	A	BMCE-TRANSMIT 010939 14/09/12
13/04/2012	23/07/2012	B	27/04/2012	BMCE-TRANSMIT-009662 23/07/2012	13/08/2012		B	BMCE-TRANSMIT 011021 19/09/2012
22/06/2012	06/07/2012	A	06/07/2012	BMCE-TRANSMIT-009409 10/07/2012	06/08/2012	11/10/2012	A	BMCE-TRANSMIT 0011670 17/10/2012
22/06/2012	06/07/2012	A	06/07/2012	BMCE-TRANSMIT-009624 13/07/12	03/08/2012		B	BMCE-TRANSMIT 011027 11/10/2012
27/04/2012	12/06/2012	B	11/05/2012	BMCE-TRANSMIT-009315 08/06/2012	03/07/2012	02/08/2012	B	BMCE-TRANSMIT 010250 08/08/2012
27/04/2012	12/06/2012	B	11/05/2012	BMCE-TRANSMIT-009315 08/06/2012	03/07/2012	02/08/2012	B	BMCE-TRANSMIT 010250 08/08/2012
27/04/2012	12/06/2012	B	11/05/2012	BMCE-TRANSMIT-009315 08/06/2012	03/07/2012	02/08/2012	B	BMCE-TRANSMIT 010718 04/02/2013
27/04/2012	12/06/2012	B	11/05/2012	BMCE-TRANSMIT-009315 08/06/2012	03/07/2012	02/08/2012	B	BMCE-TRANSMIT 010250 08/08/2012
27/04/2012	12/06/2012	B	11/05/2012	BMCE-TRANSMIT-009315 08/06/2012	03/07/2012	02/08/2012	B	BMCE-TRANSMIT 010250 08/08/2012
27/04/2012	12/06/2012	B	11/05/2012	BMCE-TRANSMIT-009315 08/06/2012	03/07/2012	02/08/2012	B	BMCE-TRANSMIT 010250 08/08/2012
27/04/2012	12/06/2012	B	11/05/2012	BMCE-TRANSMIT-009315 08/06/2012	03/07/2012	02/08/2012	B	BMCE-TRANSMIT 010250 08/08/2012
27/04/2012	12/06/2012	A	11/05/2012	BMCE-TRANSMIT-009315 08/06/2012	03/07/2012	02/08/2012	A	BMCE-TRANSMIT 010250 08/08/2012
03/08/2012	14/09/2012	B	17/08/2012	BMCE-TRANSMIT-011025 19/09/2012	10/10/2012	30/10/2012	B	BMCE-TRANSMIT 012087 05/11/2012
03/08/2012	14/09/2012	B	17/08/2012	BMCE-TRANSMIT-011025 19/09/2012	10/10/2012	30/10/2012	B	BMCE-TRANSMIT 012087 05/11/2012
14/09/2012	14/09/2012	B	28/09/2012	BMCE-TRANSMIT-011028 19/09/2012	10/10/2012	30/10/2012	B	BMCE-TRANSMIT 012400 30/10/2012
14/09/2012	14/09/2012	B	28/09/2012	BMCE-TRANSMIT-011028 19/09/2012	10/10/2012	30/10/2012	B	BMCE-TRANSMIT 012400 30/10/2012
14/09/2012	14/09/2012	B	28/09/2012	BMCE-TRANSMIT-011028 19/09/2012	10/10/2012	30/10/2012	B	BMCE-TRANSMIT 012400 30/10/2012
23/06/2012	06/07/2012	A	06/07/2012	BMCE-TRANSMIT-009014 13/07/12	03/08/2012		B	BMCE-TRANSMIT 010849 17/09/2012
31/08/2012	09/10/2012	B	14/09/2012	BMCE-TRANSMIT-011467 09/10/2012	30/10/2012	16/11/2012	A	BMCE-TRANSMIT 012460 22/11/2012
31/08/2012	09/10/2012	B	14/09/2012	BMCE-TRANSMIT-011467 09/10/2012	30/10/2012	16/11/2012	A	BMCE-TRANSMIT 012460 22/11/2012
31/08/2012	09/10/2012	B	14/09/2012	BMCE-TRANSMIT-011428 09/10/2012	29/10/2012	16/11/2012	B	BMCE-TRANSMIT 012464 22/11/2012
31/08/2012	09/10/2012	B	14/09/2012	BMCE-TRANSMIT-011428 09/10/2012	29/10/2012	16/11/2012	B	BMCE-TRANSMIT 012464 22/11/2012
14/09/2012	19/10/2012	B	28/09/2012	BMCE-TRANSMIT-011052 25/10/2012	15/11/2012	26/11/2012	B	BMCE-TRANSMIT 012038 07/12/2012
14/09/2012	19/10/2012	B	28/09/2012	BMCE-TRANSMIT-011054 25/10/2012	15/11/2012	07/12/2012	B	BMCE-TRANSMIT 012056 19/12/2012
14/09/2012	19/10/2012	B	28/09/2012	BMCE-TRANSMIT-011054 25/10/2012	15/11/2012	07/12/2012	B	BMCE-TRANSMIT 012056 19/12/2012
14/09/2012	19/10/2012	B	28/09/2012	BMCE-TRANSMIT-011054 25/10/2012	15/11/2012	07/12/2012	B	BMCE-TRANSMIT 012056 19/12/2012
14/09/2012	19/10/2012	B	28/09/2012	BMCE-TRANSMIT-011054 25/10/2012	15/11/2012	07/12/2012	B	BMCE-TRANSMIT 012056 19/12/2012
14/09/2012	19/10/2012	B	28/09/2012	BMCE-TRANSMIT-011054 25/10/2012	15/11/2012	07/12/2012	B	BMCE-TRANSMIT 012056 19/12/2012
14/09/2012	19/10/2012	B	28/09/2012	BMCE-TRANSMIT-011054 25/10/2012	15/11/2012	07/12/2012	B	BMCE-TRANSMIT 012056 19/12/2012
14/09/2012	19/10/2012	B	28/09/2012	BMCE-TRANSMIT-011054 25/10/2012	15/11/2012	07/12/2012	B	BMCE-TRANSMIT 012056 19/12/2012
14/09/2012	19/10/2012	B	28/09/2012	BMCE-TRANSMIT-011054 25/10/2012	15/11/2012	07/12/2012	B	BMCE-TRANSMIT 012056 19/12/2012
25/05/2012	22/06/2012	B	08/06/2012	BMCE-TRANSMIT-009492 25/06/12	16/07/2012		B	BMCE-TRANSMIT 010239 08/08/12
25/05/2012	22/06/2012	B	08/06/2012	BMCE-TRANSMIT-009492 25/06/12	16/07/2012		A	BMCE-TRANSMIT 010239 08/08/12
25/05/2012	22/06/2012	B	08/06/2012	BMCE-TRANSMIT-009492 25/06/12	16/07/2012		B	BMCE-TRANSMIT 010239 08/08/12
25/05/2012	22/06/2012	B	08/06/2012	BMCE-TRANSMIT-009492 25/06/12	16/07/2012		B	BMCE-TRANSMIT 010239 08/08/12
25/05/2012	22/06/2012	B	08/06/2012	BMCE-TRANSMIT-009492 25/06/12	16/07/2012		B	BMCE-TRANSMIT 010239 08/08/12

[illegible]

[illegible]

Final Submission								
Date Required from Consultant	Date Submitted by Consultant	Document Revision	Planned Date to be Submitted to Board	Date Submitted to Board	Date Response Required from Consultant (See cell 3, Row 4)	Date Returned from Board	Board Status	Date returned to Consultant
17/08/2012	24/09/2012	A	31/08/2012	BMCCE-TRANSMIT-011124 25/08/2012	15/10/2012	05/11/2012	B	BMCCE-TRANSMIT 012137 07/11/2012
17/08/2012	24/09/2012	A	31/08/2012	BMCCE-TRANSMIT-011124 25/08/2012	15/10/2012	05/11/2012	B	BMCCE-TRANSMIT 012137 07/11/2012
17/08/2012		A	31/08/2012	BMCCE-TRANSMIT-011124 25/08/2012	15/10/2012	05/11/2012	B	BMCCE-TRANSMIT 012137 07/11/2012
17/08/2012		A	31/08/2012	BMCCE-TRANSMIT-011124 25/08/2012	15/10/2012	05/11/2012	B	BMCCE-TRANSMIT 012137 07/11/2012
17/08/2012		A	31/08/2012	BMCCE-TRANSMIT-011124 25/08/2012	15/10/2012	05/11/2012	B	BMCCE-TRANSMIT 012137 07/11/2012
17/08/2012		A	31/08/2012	BMCCE-TRANSMIT-011124 25/08/2012	15/10/2012	05/11/2012	B	BMCCE-TRANSMIT 012137 07/11/2012
17/08/2012		A	31/08/2012	BMCCE-TRANSMIT-011124 25/08/2012	15/10/2012	05/11/2012	B	BMCCE-TRANSMIT 012137 07/11/2012
17/08/2012		A	31/08/2012	BMCCE-TRANSMIT-011124 25/08/2012	15/10/2012	05/11/2012	B	BMCCE-TRANSMIT 012137 07/11/2012
17/08/2012	24/09/2012	A	31/08/2012	BMCCE-TRANSMIT-011124 25/08/2012	15/10/2012	05/11/2012	B	BMCCE-TRANSMIT 012137 07/11/2012
17/08/2012	24/09/2012	A	31/08/2012	BMCCE-TRANSMIT-011124 25/08/2012	15/10/2012	05/11/2012	B	BMCCE-TRANSMIT 012137 07/11/2012
17/08/2012	24/09/2012	B	31/08/2012	BMCCE-TRANSMIT-011124 25/08/2012	15/10/2012	05/11/2012	B	BMCCE-TRANSMIT 012137 07/11/2012
17/08/2012	24/09/2012	A	31/08/2012	BMCCE-TRANSMIT-011124 25/08/2012	15/10/2012	05/11/2012	B	BMCCE-TRANSMIT 012137 07/11/2012

4 BCL-AC-XX-SH-001																1st Submission													2nd Submission													OVERDUE	
			Action By	Drawing Number	Drawing Title														Date Required from Consultant	Date Submitted by Consultant	Document Revision	Planned Date to be Submitted to Board	Date Submitted to Board	Date Response Required from Board (+3 Weeks)	Date Returned from Board	Board Status	Date returned to Consultant	Date Required from Consultant	Date Submitted by Consultant	Document Revision	Planned Date to be Submitted to Board	Date Submitted to Board	BMCE Transmittal No	Date Response Required from Board (+2 Weeks)	Date Received from Board	Board Status	Date Returned to Consultant	OVERDUE					
Item	Submission	Comments																																									
4	Equipment	Room Data Sheets																																									
			NA	NA-SZ-B1-RD-400-FMB	Room Data Sheets - FM Basement																																						
		The following matters are shown on the Room Data Sheets:	NA	NA-SZ-B1-RD-400-KIT	Room Data Sheets - NSGH Kitchen/Catering																																						
			NA	NA-SZ-01-RD-400-FMA1	Room Data Sheets - NSGH FM Facilities First Floor																																						
			NA	NA-SZ-B1-RD-400-COMMS	Room Data Sheets - NSGH Communication - Basement																																						
		(1) Items of Equipment as shown on the Equipment Schedule and the 1:50 Room Layout Drawings	NA	NA-SZ-00-RD-400-ENTA	Room Data Sheets - NSGH Main Entrance & Public Areas																																						
		(2) Environmental Design Data such as the operational temperature tolerances	NA	NA-SZ-00-RD-400-DLO	Room Data Sheets - NSGH Main Entrance - Discharge Lounge																																						
		(3) Room Activity Data	NA	NA-SZ-00-RD-400-PHA	Room Data Sheets - Pharmacy Dispensary (NSGH & NCH)																																						
			NA	NA-SZ-00-RD-400-REH	Room Data Sheets - NCH Rehabilitation Suite & Therapies																																						
		Aspect of review:	NA	NA-SZ-00-RD-400-OPDC	Room Data Sheets - NCH OPD																																						
		Clinical functionality	NA	NA-SZ-00-RD-400-ENTC	Room Data Sheets - NCH Main Entrance & Public Areas																																						
		Location and quantities of Group 1, 2, 3 and 4 equipment	NA	NA-SZ-00-RD-400-SANC	Room Data Sheets - NCH Sanctuary																																						
		Environmental data (	NA	NA-SZ-00-RD-400-CPS	Room Data Sheets - Ch Id Protection																																						
			NA	NA-SZ-00-RD-400-DCT	Room Data Sheets - Decontamination Unit																																						
			NA	NA-SZ-00-RD-400-OBW	Room Data Sheets - NCH Observation Ward																																						
			NA	NA-SZ-00-RD-400-EMC	Room Data Sheets - NCH Emergency Department																																						
			NA	NA-SZ-00-RD-400-EMA	Room Data Sheets - NSGH Emergency Department																																						
			NA	NA-SZ-00-RD-400-AAW	Room Data Sheets - NSGH Acute Assessment Unit																																						
			NA	NA-SZ-00-RD-400-RAG	Room Data Sheets - NSGH Radiology																																						
			NA	NA-SZ-00-RD-400-MIL	Room Data Sheets - Medical Illustration (NSGH & NCH)																																						
			NA	NA-SZ-00-RD-400-RCG	Room Data Sheets - NCH Radiology																																						
			NA	NA-SZ-00-RD-400-ORT	Room Data Sheets - NSGH Rehabilitation & Therapies																																						
			NA	NA-SZ-00-RD-400-OPDA0	Room Data Sheets - NSGH OPD																																						
			NA	NA-SZ-00-RD-400-CA0	Room Data Sheets - NSGH Ground Communications																																						
			NA	NA-SZ-00-RD-400-CC0	Room Data Sheets - NCH Ground Communications																																						
		Does not Exist	NA	NA-SZ-00-RD-00-FMSG	Room Data Sheets - NSGH FM Core 0																																						
			NA	NA-SZ-01-RD-400-RES	Room Data Sheets - Restaurant Dining & Servery																																						
			NA	NA-SZ-01-RD-400-RNM	Room Data Sheets - NSGH-NCH Nuclear Medicine																																						
			NA	NA-SZ-01-RD-400-SANA	Room Data Sheets - NSGH Main Entrance - Sanctuary & Public Core B																																						
		Does Not Exist	NA	NA-SZ-01-RD-00-FMG0	Room Data Sheets - NSGH FM Core 0																																						
			NA	NA-SZ-01-RD-400-THEC	Room Data Sheets - NCH Theatres Endoscopy & Recovery																																						
		This is incorporated in NA-SZ-01-RD-400-RCF	NA	NA-SZ-01-RD-400-RCI	Room Data Sheets - NCH Interventional Radiology																																						
			NA	NA-SZ-01-RD-400-RCF	Room Data Sheets - NCH Radiology CT & MRI																																						
			NA	NA-SZ-01-RD-400-23HU	Room Data Sheets - NCH Day & 23 Hour Unit																																						
			NA	NA-SZ-01-RD-400-CAR	Room Data Sheets - NCH Cardiology Ward																																						
			NA	NA-SZ-01-RD-400-SPF	Room Data Sheets - NCH Special Feeds																																						
			NA	NA-SZ-01-RD-400-PICU	Room Data Sheets - NCH Critical Care - PICU																																						
			NA	NA-SZ-01-RD-400-MDUC	Room Data Sheets - NCH Medical Day Unit																																						
			NA	NA-SZ-01-RD-400-CCU	Room Data Sheets - NSGH Coronary Care Unit - CCU																																						
			NA	NA-SZ-01-RD-400-CCW	Room Data Sheets - NSGH Critical Care																																						
			NA	NA-SZ-01-RD-400-STW	Room Data Sheets - NSGH Stroke Ward																																						

4 BCL-AC-XX-SH-001			1st Submission												2nd Submission												OVERDUE	
			Action By	Drawing Number	Drawing Title	Date Required from Consultant	Date Submitted by Consultant	Document Revision	Planned Date to be Submitted to Board	Date Submitted to Board	Date Response Required from Board (+3 Weeks)	Date Returned from Board	Board Status	Date returned to Consultant	Date Required from Consultant	Date Submitted by Consultant	Document Revision	Planned Date to be Submitted to Board	Date Submitted to Board	BMCE Transmittal No	Date Response Required from Board (+2 Weeks)	Date Received from Board	Board Status	Date Returned to Consultant	OVERDUE			
Item	Submission	Comments																										
			NA	NA-SZ-01-RD-400-MDUA	Room Data Sheets - NSGH MDU/Clinical Investigations Unit		10/02/2011		13/02/2011	06/03/2011					07/10/2011	07/10/2011	3	11/10/2011	10/10/2011	BMCE-TRANSMIT-006168	25/10/2011		A	BMCE-TRANSMIT 008622 01/05/2012				
			NA	NA-SZ-01-RD-400-POA	Room Data Sheets - NSGH OPD - Pre Assessment Unit		10/02/2011		13/02/2011	06/03/2011					07/10/2011	07/10/2011	3	11/10/2011	10/10/2011	BMCE-TRANSMIT-006168	25/10/2011		A	BMCE-TRANSMIT 008627 01/05/2012				
			NA	NA-SZ-00-RD-400-FMA0B	Room Data Sheets - NSGH Ground Floor - FM Facilities B										07/10/2011	2		10/10/2011	BMCE-TRANSMIT-006168	25/10/2011	04/05/2012	A	BMCE-TRANSMIT 008934 18/05/12					
			NA	NA-SZ-03-RD-400-FMA3A												2		10/10/2011	BMCE-TRANSMIT-006168	25/10/2011	04/05/2012	B	BMCE-TRANSMIT 008927 18.05.12					
			NA	NA-SZ-01-RD-400-RAF	Room Data Sheets - NSGH Radiology		31/03/2011		03/04/2011	24/04/2011							4			BMCE-TRANSMIT-006636	10/11/2011	04/05/2012	B	BMCE-TRANSMIT 008813 15/05/12				
			NA	NA-SZ-01-RD-400-RNM	Room Data Sheets - Nuclear Medicine (NSGH & NCH)		25/03/2011		28/03/2011	18/04/2011									20/10/2011	BMCE-TRANSMIT-005834	03/11/2011	26/04/2012	A	BMCE-TRANSMIT 008856 15/05/12				
			NA	NA-SZ-01-RD-400-OPDA1	Room Data Sheets - NSGH OPD First Floor		24/02/2011		27/02/2011	20/03/2011					28/10/2011	03/11/2011	2	01/11/2011	04/11/2011	BMCE-TRANSMIT-006544	22/11/2011	04/05/2012	B	BMCE-TRANSMIT 008773 11/05/12				
			NA	NA-SZ-01-RD-400-FMA1	Room Data Sheets - NSGH FM Facilities First Floor											08/09/2011	2		09/09/2011	BMCE-TRANSMIT-004982	23/09/2011	25/04/2012	B	BMCE-TRANSMIT 008935 18/05/12				
			NA	NA-SZ-01-RD-400-FMA1C	Room Data Sheets - NSGH First Floor FM Facilities											23/09/2011 07/10/2011	1 2		27/09/2011 10/10/2011	BMCE-TRANSMIT-005973 BMCE-TRANSMIT-006168	11/10/2011 25/10/2011	04/05/2012	A	BMCE-TRANSMIT 008933 18/05/12				
			Does not Exist	NA	NA-SZ-01-RD-400-FMA2	Room Data Sheets - NSGH Public Core A & FM Support											-											
		This previously had the wrong RDS no.	NA	NA-SZ-01-RD-400-FMC0A	Room Data Sheets - NSGH FM/Bed Core C & FM Support											10/10/2011	1		25/07/2012	BMCE-TRANSMIT-009976	15/08/2012	24/07/2012	A	BMCE-TRANSMIT 010037 28/07/2012				
		This previously had the wrong RDS no.	NA	NA-SZ-01-RD-400-FMC0B	Room Data Sheets - NSGH Public Core B & Support											10/10/2011	-		25/07/2012	BMCE-TRANSMIT-009976	15/08/2012	24/07/2012	A	BMCE-TRANSMIT 010037 28/07/2012				
			NA	NA-SZ-01-RD-400-CA1	Room Data Sheets - NSGH First Communications										07/10/2011	14/11/2011	2	11/10/2011	16/11/2011	BMCE-TRANSMIT-006704	30/11/2011	08/05/2012	A	BMCE-TRANSMIT 008866 15/05/12				
			NA	NA-SZ-01-RD-400-CC1	Room Data Sheets - NCH First Communications										07/10/2011	14/11/2011	2	11/10/2011	16/11/2011	BMCE-TRANSMIT-006704	30/11/2011	08/05/2012	A	BMCE-TRANSMIT 008862 15/05/12				
		Does Not Exist	NA	NA-SZ-00-RD-400-FMS1	Room Data Sheets - FM Support First										07/10/2011	-		11/10/2011										
			NA	NA-SZ-02-RD-400-DMW	Room Data Sheets - NSGH Dermatology Ward		17/02/2011		20/02/2011	13/03/2011					14/10/2011	14/10/2011	3	18/10/2011	20/10/2011	BMCE-TRANSMIT-006304	03/11/2011	04/05/2012	B	BMCE-TRANSMIT 008620 01/05/2012				
			NA	NA-SZ-02-RD-400-SCH	Room Data Sheets - NCH Schiehallion Ward Day Case & TCT		04/03/2011		07/03/2011	28/03/2011						03/11/2011	3	04/01/1900	04/11/2011	BMCE-TRANSMIT-006561	22/11/2011	17/05/2012	A	BMCE-TRANSMIT 009051 24/05/12				
			NA	NA-SZ-02-RD-400-AFD	Room Data Sheets - NCH Hospital at Night		07/04/2011		10/04/2011	01/05/2011					23/09/2011	23/09/2011	4	27/09/2011	27/09/2011	BMCE-TRANSMIT-005975	11/10/2011	21/05/2012	A	BMCE-TRANSMIT 009084 25/05/12				
			NA	NA-SZ-02-RD-400-DCU	Room Data Sheets - NCH Day Case Unit		04/03/2011		07/03/2011	28/03/2011					21/10/2011	03/11/2011	3	25/10/2011	04/11/2011	BMCE-TRANSMIT-006561	22/11/2011	17/05/2012	A	BMCE-TRANSMIT 009176 31/05/12				
			NA	NA-SZ-02-RD-400-ARU	Room Data Sheets - NCH Acute Receiving Unit		04/03/2011		07/03/2011	28/03/2011					21/10/2011	21/10/2011 03/11/2011	3 4	25/10/2011	28/10/2011 08/11/2011	BMCE-TRANSMIT-006456 BMCE-TRANSMIT-006582	11/11/2011 22/11/2011	11/05/2012	A	BMCE-TRANSMIT 009044 24/05/12				
			NA	NA-SZ-02-RD-400-ASU	Room Data Sheets - Aseptic Suite (NSGH & NCH)		03/02/2011		06/02/2011	27/02/2011						30/09/2011	4		05/10/2011	BMCE-TRANSMIT-006070	19/10/2011	04/05/2012	B	BMCE-TRANSMIT 008802 15/05/2012				
			NA	NA-SZ-02-RD-400-TPS	Room Data Sheets - NSGH Telephone Services										- / 0/20 -	-		- 8/ - 0/20 -										
		Please see NA-SZ-02-RD-400-PL2	NA	NA-SZ-02-RD-400-PL2	Room Data Sheets - NSGH Reception		- / 0/20 -		- / 0/20 -	0 - 10 - 20 -					- / 0/20 -	-		- 8/ - 0/20 -										
			NA	NA-SZ-02-RD-400-FMC2	Room Data Sheets - NSGH FM Emergency Linen		10/02/2011		13/02/2011	06/03/2011					14/10/2011	14/10/2011	3	18/10/2011	20/10/2011	BMCE-TRANSMIT-006304	03/11/2011	10/05/2012	B	BMCE-TRANSMIT 009045 24.05.12				
			NA	NA-SZ-02-RD-400-MP	Room Data Sheets - Medical Physics & Bio-Engineering (NSGH & NCH)		17/02/2011		20/02/2011	13/03/2011					14/10/2011	14/10/2011	3	18/10/2011	20/10/2011	BMCE-TRANSMIT-006304	03/11/2011	04/05/2012	B	BMCE-TRANSMIT 008941 18.05.12				
			NA	NA-SZ-02-RD-400-DCT	Room Data Sheets - NSGH Decontamination Suite		/								14/10/2011	14/10/2011	3	18/10/2011	20/10/2011	BMCE-TRANSMIT-006304	03/11/2011	10/05/2012	A	BMCE-TRANSMIT 009139 29/05/12				
			NA	NA-SZ-02-RD-400-END	Room Data Sheets - NSGH Endoscopy		24/02/2011		27/02/2011	20/03/2011					21/10/2011	03/11/2011	4	25/10/2011	08/11/2011	BMCE-TRANSMIT-006582	22/11/2011		B	BMCE-TRANSMIT 008598 27/04/2012				
			NA	NA-SZ-02-RD-400-THEA	Room Data Sheets - NSGH Operating Theatres AODS & Recovery		11/03/2011		14/03/2011	04/04/2011					02/09/2011	14/09/2011	5	06/09/2011	15/09/2011	BMCE-TRANSMIT-005093	28/09/2011		B	BMCE-TRANSMIT 008629 01/05/2012				
			NA	NA-SZ-02-RD-400-DOPO	Room Data Sheets - NSGH Dermatology OPD		17/02/2011		20/02/2011	13/03/2011					14/10/2011	14/10/2011	3	18/10/2011	20/10/2011	BMCE-TRANSMIT-006304	03/11/2011		B	BMCE-TRANSMIT 008621 01/05/2012				
			NA	NA-SZ-02-RD-400-RENO	Room Data Sheets - NSGH Renal Dialysis		03/02/2011		06/02/2011	27/02/2011					30/09/2011	19/09/2011	4 3	04/10/2011	21/09/2011 05/10/2011	BMCE-TRANSMIT-005886 BMCE-TRANSMIT-006070	05/10/2011 19/10/2011		B	BMCE-TRANSMIT 008227/04/2012				
			NA	NA-SZ-02-RD-400-TPB	Room Data Sheets - NCH Transport Base		10/02/2011		13/02/2011	06/03/2011					14/10/2011	14/10/2011	3	18/10/2011	20/10/2011	BMCE-TRANSMIT-006304	03/11/2011	10/05/2012	A	BMCE-TRANSMIT 009005 23.05.12				
			NA	NA-SZ-02-RD-400-CA2	Room Data Sheets - NSGH Second Communications										14/10/2011	14/11/2011	2	18/10/2011	16/11/2011	BMCE-TRANSMIT-006704	30/11/2011	08/05/2012	A	BMCE-TRANSMIT 008861 15/05/12				
			NA	NA-SZ-02-RD-400-CC2	Room Data Sheets - NCH Second Communications										14/10/2011	14/11/2011	2	18/10/2011	16/11/2011	BMCE-TRANSMIT-006704	30/11/2011	08/05/2012	A	BMCE-TRANSMIT 008863 15/05/12				
			NA	NA-SZ-02-RD-400-PL2												05/10/2011	2	05/10/2011	05/10/2011	BMCE-TRANSMIT-006071	19/10/2011		A	BMCE-TRANSMIT 009652 04/07/12				
			NA	NA-SZ-02-RD-400-FMA2	Room Data Sheets - FM Support Second										14/10/2011	14/10/2011	3	18/10/2011	20/10/2011	BMCE-TRANSMIT-006304	03/11/2011		A	BMCE-TRANSMIT 009652 04/07/12				
			NA	NA-SZ-04-RD-400-FMA4	Room Data Sheets - NSGH Fourth Floor - Ward Support											30/09/2011	3		05/10/2011	BMCE-TRANSMIT-006070	19/10/2011	10/05/2012	A	BMCE-TRANSMIT 008788 15/05/12				
			NA	NA-SZ-00-RD0400-FMC2A	Room Data Sheets - NSGH Second Floor - FM Facilities											30/09/2011	2		05/10/2011	BMCE-TRANSMIT-006070	19/10/2011	04/05/2012	A	BMCE-TRANSMIT 008925 18.05.12				
			NA	NA-SZ-00-RD-400-FMA0A	Room Data Sheets - NSGH Ground Floor - FM Facilities											30/09/2011	2		05/10/2011	BMCE-TRANSMIT-006070	19/10/2011	04/05/2012	A	BMCE-TRANSMIT 008929 18.05.12				
			NA&gt																									

4 BCL-AC-XX-SH-001			1st Submission												2nd Submission												OVERDUE	
			Action By	Drawing Number	Drawing Title	Date Required from Consultant	Date Submitted by Consultant	Document Revision	Planned Date to be Submitted to Board	Date Submitted to Board	Date Response Required from Board (+3 Weeks)	Date Returned from Board	Board Status	Date returned to Consultant	Date Required from Consultant	Date Submitted by Consultant	Document Revision	Planned Date to be Submitted to Board	Date Submitted to Board	BMCE Transmittal No	Date Response Required from Board (+2 Weeks)	Date Received from Board	Board Status	Date Returned to Consultant	OVERDUE			
Item	Submission	Comments	NA	NA-SZ-03-RD-400-GWS	Room Data Sheets - NCH Inpatient Wards - Medicinema		04/03/2011		07/03/2011		28/03/2011				21/10/2011			25/10/2011	28/10/2011	BMCE-TRANSMIT-006448	11/11/2011	17/05/2012	A	BMCE-TRANSMIT 009177 31/05/12				
			NA	NA-SZ-03-RD-400-GWA	Room Data Sheets - NCH Inpatient Wards		04/03/2011		07/03/2011		28/03/2011				21/10/2011	03/11/2011	3	25/10/2011	08/11/2011	BMCE-TRANSMIT-006582	22/11/2011	17/05/2012	A	BMCE-TRANSMIT 009179 31/05/12				
			NA	NA-SZ-03-RD-400-GWB	Room Data Sheets - NCH Inpatient Wards & Renal Services		04/03/2011		07/03/2011		28/03/2011				21/10/2011	21/10/2011 03/11/2011	2 3	25/10/2011	28/10/2011 08/11/2011	BMCE-TRANSMIT-006443 BMCE-TRANSMIT-006582	11/11/2011 22/11/2011	17/05/2012	A	BMCE-TRANSMIT 009175 31/05/12				
			NA	NA-SZ-03-RD-400-GWC	Room Data Sheets - NCH Inpatient Ward Support		04/03/2011		07/03/2011		28/03/2011				21/10/2011	21/10/2011 03/11/2011	2 3	25/10/2011	28/10/2011 08/11/2011	BMCE-TRANSMIT-006443 BMCE-TRANSMIT-006582	11/11/2011 22/11/2011	22 05/12	A	BMCE-TRANSMIT 009180 31/05/12				
			NA	NA-SZ-03-RD-400-CA3	Room Data Sheets - NSGH Third Communications										07/10/2011	14/11/2011	2	11/10/2011	16/11/2011	BMCE-TRANSMIT-006704	30/11/2011	08/05/2012	A	BMCE-TRANSMIT 008858 15/05/12				
			NA	NA-SZ-03-RD-400-CC3	Room Data Sheets - NCH Third Communications										07/10/2011	14/11/2011	2	11/10/2011	16/11/2011	BMCE-TRANSMIT-006704	30/11/2011	08/05/2012	A	BMCE-TRANSMIT 008859 15/05/12				
		Does Not Exist	NA	NA-SZ-03-RD-400-FMS3	Room Data Sheets - FM Support Third-										07/10/2011	-		11/10/2011										
			NA	NA-SZ-04-RD-400-RENV	Room Data Sheets - NSGH Renal Inpatients & Day Unit		03/02/2011		06/02/2011		27/02/2011				30/09/2011	30/09/2011	3	04/10/2011	05/10/2011	BMCE-TRANSMIT-006070	19/10/2011		B	BMCE-TRANSMIT 008672 04/05/12				
			NA	NA-SZ-04-RD-400-HOW	Room Data Sheets - NSGH Haemato-oncology Inpatient Ward		17/02/2011		20/02/2011		13/03/2011				14/10/2011	14/10/2011	3	18/10/2011	20/10/2011	BMCE-TRANSMIT-006304	03/11/2011	08/05/2012	B	BMCE-TRANSMIT 008870 15/05/12				
			NA	NA-SZ-04-RD-400-DCFP	Room Data Sheets - NCH Psychiatry / DCFP		04/03/2011		07/03/2011		28/03/2011				04/11/2011	11/11/2011	3	08/11/2011	11/11/2011	BMCE-TRANSMIT-006670	25/11/2011	14/05/2012	A	BMCE-TRANSMIT 008992 23.05.12				
		NA	NA-SZ-04-RD-400-CA4	Room Data Sheets - NSGH Fourth Communications										30/09/2011	14/11/2011	2	04/10/2011	16/11/2011	BMCE-TRANSMIT-006704	30/11/2011	08/05/2012	A	BMCE-TRANSMIT 008855 15/05/12					
		NA	NA-SZ-04-RD-400-CC4	Room Data Sheets - NCH Fourth Communications										04/11/2011	14/11/2011	2	08/11/2011	16/11/2011	BMCE-TRANSMIT-006704	30/11/2011	08/05/2012	A	BMCE-TRANSMIT 008865 15/05/12					
	Does Not Exist	NA	NA-SZ-04-RD-400-FMS4	Room Data Sheets - FM Support Fourth-										30/09/2011	-		04/10/2011											
			NA	NA-SZ-04-RD-400-FMC4	Room Data Sheets - NCH Fourth Floor - FM Facilities											11/11/2011	2		11/11/2011	BMCE-TRANSMIT-006670	25/11/2011		A	BMCE-TRANSMIT 008946 18/05/12				
			NA	NA-SZ-05-RD-400-GENWA	Room Data Sheets - NSGH Fifth Floor Generic Ward A		04/03/2011		07/03/2011		28/03/2011				04/11/2011	11/11/2011	3	08/11/2011	11/11/2011	BMCE-TRANSMIT-006670	25/11/2011	11/06/2012	A	BMCE-TRANSMIT 009391 19/06/12				
			NA	NA-SZ-05-RD-400-GENWB	Room Data Sheets - NSGH Fifth Floor Generic Ward B											11/11/2011	3		11/11/2011	BMCE-TRANSMIT-006670	25/11/2011	18/06/2012	A	BMCE-TRANSMIT 009604 29/06/12				
			NA	NA-SZ-05-RD-400-GENWC	Room Data Sheets - NSGH Fifth Floor Generic Ward C											11/11/2011	3		11/11/2011	BMCE-TRANSMIT-006670	25/11/2011	11/06/2012	A	BMCE-TRANSMIT 009388 19/06/12				
			NA	NA-SZ-05-RD-400-GENWD	Room Data Sheets - NSGH Fifth Floor Generic Ward D											11/11/2011	3		11/11/2011	BMCE-TRANSMIT-006670	25/11/2011	11/06/2012	A	BMCE-TRANSMIT 009389 19/06/12				
			NA	NA-SZ-05-RD-400-CA5	Room Data Sheets - NSGH Fifth Communications		04/03/2011		07/03/2011		28/03/2011				04/11/2011	11/11/2011	2	08/11/2011	11/11/2011	BMCE-TRANSMIT-006670	25/11/2011	14/05/2012	A	BMCE-TRANSMIT 008994 22.05.12				
			NA	NA-SZ-05-RD-400-WS5	Room Data Sheets - Fifth Floor Ward Support 5											11/11/2011	2		11/11/2011	BMCE-TRANSMIT-006670	25/11/2011		B	BMCE-TRANSMIT 009336 13/06/12				
	Does Not Exist	NA	NA-SZ-06-RD-400-GENWA	Room Data Sheets - NSGH Inpatient Wards-		04/03/2011		07/03/2011		28/03/2011				04/11/2011			08/11/2011											
		NA	NA-SZ-06-RD-400-CA6	Room Data Sheets - NSGH Sixth Communications		04/03/2011		07/03/2011		28/03/2011				04/11/2011	11/11/2011	2	08/11/2011	11/11/2011	BMCE-TRANSMIT-006670	25/11/2011	10/05/2012	A	BMCE-TRANSMIT 008943 18.05.12					
	Does Not Exist	NA	NA-SZ-07-RD-400-GENWA	Room Data Sheets - NSGH Inpatient Wards-		04/03/2011		07/03/2011		28/03/2011				04/11/2011	-		08/11/2011											
			NA	NA-SZ-06-RD-400-GENW1	Room Data Sheets - Sixth Floor Rheumatology Ward 1											11/11/2011	2		11/11/2011	BMCE-TRANSMIT-006670	25/11/2011	18/06/2012	A	BMCE-TRANSMIT 009565 28/06/12				
			NA	NA-SZ-06-RD-400-GENW2	Room Data Sheets - NSGH Sixth Floor Generic Ward 2											11/11/2011	1		11/11/2011	BMCE-TRANSMIT-006670	25/11/2011	18/06/2012	A	BMCE-TRANSMIT 009606 29/06/12				
			NA	NA-SZ-06-RD-400-GENW3	Room Data Sheets - NSGH Sixth Floor Generic Ward 3											11/11/2011	1		11/11/2011	BMCE-TRANSMIT-006670	25/11/2011		A	BMCE-TRANSMIT 009694 05/07/12				
			NA	NA-SZ-06-RD-400-GENW4	Room Data Sheets - NSGH Sixth Floor Generic Ward 4											11/11/2011	1		11/11/2011	BMCE-TRANSMIT-006670	25/11/2011	18/06/2012	A	BMCE-TRANSMIT 009493 25/06/12				
			NA	NA-SZ-06-RD-400-WS6	Room Data Sheets - Sixth Floor Ward Support 6											11/11/2011	2		11/11/2011	BMCE-TRANSMIT-006670	25/11/2011		B	BMCE-TRANSMIT 009661 13/06/12				
			NA	NA-SZ-07-RD-400-CA7	Room Data Sheets - NSGH Seventh Communications		04/03/2011		07/03/2011		28/03/2011				04/11/2011	11/11/2011	2	08/11/2011	11/11/2011	BMCE-TRANSMIT-006670	25/11/2011	10/05/2012	A	BMCE-TRANSMIT 008948 18.05.12				
			NA	NA-SZ-07-RD-400-GENW5	Room Data Sheets - NSGH Seventh Floor Generic Ward 5											11/11/2011	2		11/11/2011	BMCE-TRANSMIT-006670	25/11/2012	18/06/2012	A	BMCE-TRANSMIT 009601 29/06/12				
			NA	NA-SZ-07-RD-400-GENW6	Room Data Sheets - NSGH Seventh Floor Generic Ward 6											11/11/2011	1		11/11/2011	BMCE-TRANSMIT-006670	25/11/2011	18/06/2012	A	BMCE-TRANSMIT 009587 28/06/12				
			NA	NA-SZ-07-RD-400-GENW7	Room Data Sheets - NSGH Seventh Floor Generic Ward 7											11/11/2011	1		11/11/2011	BMCE-TRANSMIT-006670	25/11/2011	18/06/2012	A	BMCE-TRANSMIT 009598 29/06/12				
			NA	NA-SZ-07-RD-400-GENW8	Room Data Sheets - NSGH Seventh Floor Generic Ward 8											11/11/2011	1		11/11/2011	BMCE-TRANSMIT-006670	25/11/2011	18/06/2012	A	BMCE-TRANSMIT 009599 28/06/12				
		NA	NA-SZ-07-RD-400-WS7	Room Data Sheets - Seventh Floor Ward Support 7											11/11/2011	2		11/11/2011	BMCE-TRANSMIT-006670	25/11/2011	31/05/2012	B	BMCE-TRANSMIT 009396 19/06/12					
	Does Not Exist	NA	NA-SZ-08-RD-400-GENWA	Room Data Sheets - NSGH Inpatient Wards-		04/03/2011		07/03/2011		28/03/2011				04/11/2011	-		08/11/2011											
			NA	NA-SZ-08-RD-400-CA8	Room Data Sheets - NSGH Eighth Communications		04/03/2011		07/03/2011		28/03/2011				04/11/2011	11/11/2011	2	08/11/2011	11/11/2011	BMCE-TRANSMIT-006670	25/11/2011	10/05/2012	A	BMCE-TRANSMIT 008942 18.05.12				
			N/A	NA-SZ-08-RD-400-CA8	Room Data Sheets - NSGH Ninth Communications															BMCE-TRANSMIT-006670	25/11/2011	10/05/2012	A	BMCE-TRANSMIT 008947 18.05.12				
			N/A	NA-SZ-09-RD-400-CA9	Room Data Sheets - NSGH Ninth Communications															BMCE-TRANSMIT-006670	25/11/2011	10/05/2012	A	BMCE-TRANSMIT 008947 18.05.12				
			NA	NA-SZ-08-RD-400-WS8	Room Data Sheets - Eighth Floor Ward Support											11/11/2011	2		11/11/2011	BMCE-TRANSMIT-006670	25/11/2011	06/06/2012	B	BMCE-TRANSMIT 009343 14/06/12				
			NA	NA-SZ-08-RD-400-GENW10	Room Data Sheets - Eighth Floor Generic Ward 10											11/11/2011	2		11/11/2011	BMCE-TRANSMIT-000498	23/09/2011	21/06/2012	A	BMCE-TRANSMIT 009563 26/06/12				
			NA	NA-SZ-08-RD-400-GENW11	Room Data Sheets - Eighth Floor Generic Ward 11																							

BCL-AC-XX-SH-001			1st Submission												2nd Submission												OVERDUE
			Action By	Drawing Number	Drawing Title	Date Required from Consultant	Date Submitted by Consultant	Document Revision	Planned Date to be Submitted to Board	Date Submitted to Board	Date Response Required from Board (+3 Weeks)	Date Returned from Board	Board Status	Date returned to Consultant	Date Required from Consultant	Date Submitted by Consultant	Document Revision	Planned Date to be Submitted to Board	Date Submitted to Board	BMCE Transmittal No	Date Response Required from Board (+2 Weeks)	Date Received from Board	Board Status	Date Returned to Consultant	OVERDUE		
Item	Submission	Comments																									
			NA	NA-SZ-08-RD-400-GENW12	Room Data Sheets - Eighth Floor Generic Ward 12											11/11/2011	2		11/11/2011	BMCE-TRANSMIT-006670	25/11/2011	21/06/2012	A	BMCE-TRANSMIT 009564 28/06/12			
			NA	NA-SZ-08-RD-400-GENW9	Room Data Sheets - Eighth Floor Elderly Ward 9											11/11/2011	2		11/11/2011	BMCE-TRANSMIT-006670	25/11/2011	21/06/2012	A	BMCE-TRANSMIT 009562 28/06/12			
		Does Not Exist	NA	NA-SZ-09-RD-400-GENWA	Room Data Sheets - NSGH Ninth Floor Communications--		04/03/2011		07/03/2011		28/03/2011				04/11/2011			08/11/2011									
			NA	NA-SZ-0-RD-400-GENW13	Room Data Sheets - NSGH Ninth Floor Generic Ward 13											11/11/2011	2		11/11/2011	BMCE-TRANSMIT-006670	25/11/2011		A	BMCE-TRANSMIT 009801 12/07/12			
			NA	NA-SZ-0-RD-400-GENW14	Room Data Sheets - NSGH Ninth Floor Generic Ward 14											11/11/2011	1		11/11/2011	BMCE-TRANSMIT-006670	25/11/2011	21/06/2012	A	BMCE-TRANSMIT 009561 28/06/12			
			NA	NA-SZ-0-RD-400-GENW15	Room Data Sheets - NSGH Ninth Floor Generic Ward 15											11/11/2011	1		11/11/2011	BMCE-TRANSMIT-006670	25/11/2011		A	BMCE-TRANSMIT 009708 06/07/12			
			NA	NA-SZ-0-RD-400-GENW16	Room Data Sheets - NSGH Ninth Floor Generic Ward 16											11/11/2011	1		11/11/2011	BMCE-TRANSMIT-006670	25/11/2011	21/06/2012	A	BMCE-TRANSMIT 009560 28/06/12			
			NA	NA-SZ-09-RD-400-WS9	Room Data Sheets - Ninth Floor Ward Support											11/11/2011	2		11/11/2011	BMCE-TRANSMIT-006670	25/11/2011		B	BMCE-TRANSMIT 009330 13/06/12			
		Does Not Exist	NA	NA-SZ-0-RD-00-GENWA	Room Data Sheets - NSGH Inpatient Wards--		04/03/2011		07/03/2011		28/03/2011				04/11/2011	-		08/11/2011									
			NA	NA-SZ-10-RD-400-CA10	Room Data Sheets - NSGH Tenth Floor Communications		04/03/2011		07/03/2011		28/03/2011				04/11/2011	11/11/2011	2	08/11/2011	11/11/2011	BMCE-TRANSMIT-006670	25/11/2011	10/05/2012	A	BMCE-TRANSMIT 008949 18/05/12			
			NA	NA-SZ-10-RD-400-GENW17	Room Data Sheets - Tenth Floor Generic Ward 17											11/11/2011	2		11/11/2011	BMCE-TRANSMIT-006670	25/11/2011		A	BMCE-TRANSMIT 009872 17/07/12			
			NA	NA-SZ-10-RD-400-GENW18	Room Data Sheets - Tenth Floor Generic Ward 18											11/11/2011	1		11/11/2011	BMCE-TRANSMIT-006670	25/11/2011		A	BMCE-TRANSMIT 009870 17/07/12			
			NA	NA-SZ-10-RD-400-GENW19	Room Data Sheets - Tenth Floor Generic Ward 19											11/11/2011	1		11/11/2011	BMCE-TRANSMIT-006670	25/11/2011	26/06/12	A	BMCE-TRANSMIT 009802 12/07/12			
			NA	NA-SZ-10-RD-400-GENW20	Room Data Sheets - Tenth Floor Generic Ward 20											11/11/2011	1		11/11/2011	BMCE-TRANSMIT-006670	25/11/2011		A	BMCE-TRANSMIT 009873 17/07/12			
			NA	NA-SZ-10-RD-400-WS10	Room Data Sheets - Tenth Floor Ward Support 10											11/11/2011	2		11/11/2011	BMCE-TRANSMIT-006670	25/11/2011		B	BMCE-TRANSMIT 009332 13/06/12			
		Does Not Exist	NA	NA-SZ-10-RD-00-GENWA	Room Data Sheets - NSGH Inpatient Wards--		04/03/2011		07/03/2011		28/03/2011				04/11/2011	-		08/11/2011									
			NA	NA-SZ-11-RD-400-GENW21	Room Data Sheets - NSGH Eleventh Floor Generic Ward 21											11/11/2011	2		11/11/2011	BMCE-TRANSMIT-006670	25/11/2011		A	BMCE-TRANSMIT 009801 12/07/12			
			NA	NA-SZ-11-RD-400-GENW22	Room Data Sheets - NSGH Eleventh Floor Generic Ward 22											11/11/2011	1		11/11/2011	BMCE-TRANSMIT-006670	25/11/2011	26/06/12	A	BMCE-TRANSMIT 009802 12/07/12			
			NA	NA-SZ-11-RD-400-GENW23	Room Data Sheets - NSGH Eleventh Floor Generic Ward 23											11/11/2011	1		11/11/2011	BMCE-TRANSMIT-006670	25/11/2011	26/06/12	A	BMCE-TRANSMIT 009802 12/07/12			
			NA	NA-SZ-11-RD-400-GENW24	Room Data Sheets - NSGH Eleventh Floor Generic Ward 24											11/11/2011	2		11/11/2011	BMCE-TRANSMIT-006670	25/11/2011		A	BMCE-TRANSMIT 009801 12/07/12			
			NA	NA-SZ-11-RD-400-WS11												11/11/2011	2		11/11/2011	BMCE-TRANSMIT-006670	25/11/2011		B	BMCE-TRANSMIT 009336 13/06/12			
			NA	NA-SZ-11-RD-400-CA11	Room Data Sheets - NSGH Eleventh Inpatient Wards		04/03/2011		07/03/2011		28/03/2011				04/11/2011	11/11/2011	2	08/11/2011	11/11/2011	BMCE-TRANSMIT-006670	25/11/2011	10.05.12	A	BMCE-TRANSMIT 008950 18.05.12			
			NA	NA-SZ-00-RD-400-CAR	Room Data Sheets - NCH Cardiology Ward											21/10/2011 03/11/2011	3 4		28/10/2011 08/11/2011	BMCE-TRANSMIT-006443 BMCE-TRANSMIT-006582	11/11/2011		A	BMCE-TRANSMIT 009056 24/05/12			
			NA	NA-SZ-02-RD-400-ARU	Room Data Sheets - NCH Acute Receiving Unit											21/10/2011	3		28/10/2011	BMCE-TRANSMIT-006443	11/11/2011		A	BMCE-TRANSMIT 009044 24/05/12			
			NA	NA-SZ-02-RD-400-END	Room Data Sheets - NSGH Endoscopy											21/10/2011	3		28/10/2011	BMCE-TRANSMIT-006443	11/11/2011		B	BMCE-TRANSMIT 008958 27/04/12			
			NA	NA-SZ-02-RD-400-HAN	Room Data Sheets - Schiehallion and ARU Support											21/10/2011 03/11/2011	2 3		28/10/2011 08/11/2011	BMCE-TRANSMIT-006443 BMCE-TRANSMIT-006582	11/11/2011 22/11/2011	10/05/2012	A	BMCE-TRANSMIT 009004 23.05.12			
			NA	NA-SZ-03-RD-400-FMC3	Room Data Sheets - NCH Third Floor FM Facilities											21/10/2011 03/11/2011	2 3		28/10/2011 08/11/2011	BMCE-TRANSMIT-006443 BMCE-TRANSMIT-006582	11/11/2011 22/11/2011	08/05/2012	A	BMCE-TRANSMIT 008853 15/05/12			
			NA	NA-SZ-03-RD-400-GWA	Room Data Sheets - NCH Inpatient Ward & Ward Support											21/10/2011 03/11/2011	2 3		28/10/2011 08/11/2011	BMCE-TRANSMIT-006443 BMCE-TRANSMIT-006582	11/11/2011 22/11/2011		A	BMCE-TRANSMIT 009177 31/05/12			
			NA	NA-SX-03-RD-400-GWS	Room Data Sheets - NCH Inpatient Ward Support											21/10/2011 03/11/2011	3 4		28/10/2011 08/11/2011	BMCE-TRANSMIT-006443 BMCE-TRANSMIT-006582	11/11/2011 22/11/2011		A	BMCE-TRANSMIT 009179 31/05/12			
			NA	NA-SZ-03-RD-400-RENC	Room Data Sheets - NCH Renal Day Case											21/10/2011	2 3		28/10/2011	BMCE-TRANSMIT-006443 BMCE-TRANSMIT-006582	11/11/2011 22/11/2011	10/05/2012	A	BMCE-TRANSMIT 009003 23.05.12			
			NA	NA-SZ-01-RD-400-FMC1	Room Data Sheets - MCH First Floor FM Facilities											21/10/2011 03/11/2011	2 3		28/10/2011 03/11/2011	BMCE-TRANSMIT-006458 BMCE-TRANSMIT-006560	11/11/2011 22/11/2011	08/05/2012	A	BMCE-TRANSMIT 008851 15/05/12			
		NA	NA-SZ-03-RD-400-GWM	Room Data Sheets - NCH Inpatient Ward Medicinema											11/11/2011	2		11/11/2011	BMCE-TRANSMIT-006670	25/11/2011	10/05/2012	A	BMCE-TRANSMIT 009083 25/05/12				
	Equipment List	Does Not exist	NA	NA-SH-00-00	Equipment Report - Children's Hospital																						
	Equipment Schedules	Equipment By Room/By Department	NA	NA-SH-400-201	Equipment Report - Children's Hospital																						
			NA	NA-SH-400-301	Equipment Report - Adult Hospital																						

4BCL-AC-XX-SH-001																										

[illegible]

- Internal Room Elevators

Internal Room Elevations

Ref: AC 00 00 00		Art no By		D only Number		D only Title		1st Phase only										2nd Phase only										3rd Phase only										4th Phase only										5th Phase only										6th Phase only										7th Phase only										8th Phase only										9th Phase only										10th Phase only										11th Phase only										12th Phase only										13th Phase only										14th Phase only										15th Phase only										16th Phase only										17th Phase only										18th Phase only										19th Phase only										20th Phase only										21st Phase only										22nd Phase only										23rd Phase only										24th Phase only										25th Phase only										26th Phase only										27th Phase only										28th Phase only										29th Phase only										30th Phase only										31st Phase only										32nd Phase only										33rd Phase only										34th Phase only										35th Phase only										36th Phase only										37th Phase only										38th Phase only										39th Phase only										40th Phase only										41st Phase only										42nd Phase only										43rd Phase only										44th Phase only										45th Phase only										46th Phase only										47th Phase only										48th Phase only										49th Phase only										50th Phase only										51st Phase only										52nd Phase only										53rd Phase only										54th Phase only										55th Phase only										56th Phase only										57th Phase only										58th Phase only										59th Phase only										60th Phase only										61st Phase only										62nd Phase only										63rd Phase only										64th Phase only										65th Phase only										66th Phase only										67th Phase only										68th Phase only										69th Phase only										70th Phase only										71st Phase only										72nd Phase only										73rd Phase only										74th Phase only										75th Phase only										76th Phase only										77th Phase only										78th Phase only										79th Phase only										80th Phase only										81st Phase only										82nd Phase only										83rd Phase only										84th Phase only										85th Phase only										86th Phase only										87th Phase only										88th Phase only										89th Phase only										90th Phase only										91st Phase only										92nd Phase only										93rd Phase only										94th Phase only										95th Phase only										96th Phase only										97th Phase only										98th Phase only										99th Phase only										100th Phase only										101st Phase only										102nd Phase only										103rd Phase only										104th Phase only										105th Phase only										106th Phase only										107th Phase only										108th Phase only										109th Phase only										110th Phase only										111th Phase only										112th Phase only										113th Phase only										114th Phase only										115th Phase only										116th Phase only										117th Phase only										118th Phase only										119th Phase only										120th Phase only										121st Phase only										122nd Phase only										123rd Phase only										124th Phase only										125th Phase only										126th Phase only										127th Phase only										128th Phase only										129th Phase only										130th Phase only										131st Phase only									
Substitution		Comments		Art no By		D only Number		D only Title		Date		Date		Date</																																																																																																																																																																																																																																																																																																																																																																																																																																																																																																																																																																																																																																																																																																																																																																			

- Internal Room Elevations

[illegible]

Internal Room Elevations

Internal Room Elevations

- Internal Room Elevations

- Internal Room Elevations

- Internal Room Elevations

Internal Room Elevations

ISS MASTER SCHEDULE - E - NIS D area - Outgoing & C yde / New South Glasgow Hospital & NISDH) - a not - Add to & Ch d area Hospital

01_02_03_04_05

06_07_08_09_10_11_12_13_14_15_16_17_18_19_20_21_22_23_24_25_26_27_28_29_30_31_32_33_34_35_36_37_38_39_40_41_42_43_44_45_46_47_48_49_50_51_52_53_54_55_56_57_58_59_60_61_62_63_64_65_66_67_68_69_70_71_72_73_74_75_76_77_78_79_80_81_82_83_84_85_86_87_88_89_90_91_92_93_94_95_96_97_98_99_100_101_102_103_104_105_106_107_108_109_110_111_112_113_114_115_116_117_118_119_120_121_122_123_124_125_126_127_128_129_130_131_132_133_134_135_136_137_138_139_140_141_142_143_144_145_146_147_148_149_150_151_152_153_154_155_156_157_158_159_160_161_162_163_164_165_166_167_168_169_170_171_172_173_174_175_176_177_178_179_180_181_182_183_184_185_186_187_188_189_190_191_192_193_194_195_196_197_198_199_200_201_202_203_204_205_206_207_208_209_210_211_212_213_214_215_216_217_218_219_220_221_222_223_224_225_226_227_228_229_230_231_232_233_234_235_236_237_238_239_240_241_242_243_244_245_246_247_248_249_250_251_252_253_254_255_256_257_258_259_260_261_262_263_264_265_266_267_268_269_270_271_272_273_274_275_276_277_278_279_280_281_282_283_284_285_286_287_288_289_290_291_292_293_294_295_296_297_298_299_300_301_302_303_304_305_306_307_308_309_310_311_312_313_314_315_316_317_318_319_320_321_322_323_324_325_326_327_328_329_330_331_332_333_334_335_336_337_338_339_340_341_342_343_344_345_346_347_348_349_350_351_352_353_354_355_356_357_358_359_360_361_362_363_364_365_366_367_368_369_370_371_372_373_374_375_376_377_378_379_380_381_382_383_384_385_386_387_388_389_390_391_392_393_394_395_396_397_398_399_400_401_402_403_404_405_406_407_408_409_410_411_412_413_414_415_416_417_418_419_420_421_422_423_424_425_426_427_428_429_430_431_432_433_434_435_436_437_438_439_440_441_442_443_444_445_446_447_448_449_450_451_452_453_454_455_456_457_458_459_460_461_462_463_464_465_466_467_468_469_470_471_472_473_474_475_476_477_478_479_480_481_482_483_484_485_486_487_488_489_490_491_492_493_494_495_496_497_498_499_500_501_502_503_504_505_506_507_508_509_510_511_512_513_514_515_516_517_518_519_520_521_522_523_524_525_526_527_528_529_530_531_532_533_534_535_536_537_538_539_540_541_542_543_544_545_546_547_548_549_550_551_552_553_554_555_556_557_558_559_560_561_562_563_564_565_566_567_568_569_570_571_572_573_574_575_576_577_578_579_580_581_582_583_584_585_586_587_588_589_590_591_592_593_594_595_596_597_598_599_600_601_602_603_604_605_606_607_608_609_610_611_612_613_614_615_616_617_618_619_620_621_622_623_624_625_626_627_628_629_630_631_632_633_634_635_636_637_638_639_640_641_642_643_644_645_646_647_648_649_650_651_652_653_654_655_656_657_658_659_660_661_662_663_664_665_666_667_668_669_670_671_672_673_674_675_676_677_678_679_680_681_682_683_684_685_686_687_688_689_690_691_692_693_694_695_696_697_698_699_700_701_702_703_704_705_706_707_708_709_710_711_712_713_714_715_716_717_718_719_720_721_722_723_724_725_726_727_728_729_730_731_732_733_734_735_736_737_738_739_740_741_742_743_744_745_746_747_748_749_750_751_752_753_754_755_756_757_758_759_760_761_762_763_764_765_766_767_768_769_770_771_772_773_774_775_776_777_778_779_780_781_782_783_784_785_786_787_788_789_790_791_792_793_794_795_796_797_798_799_800_801_802_803_804_805_806_807_808_809_810_811_812_813_814_815_816_817_818_819_820_821_822_823_824_825_826_827_828_829_830_831_832_833_834_835_836_837_838_839_840_841_842_843_844_845_846_847_848_849_850_851_852_853_854_855_856_857_858_859_860_861_862_863_864_865_866_867_868_869_870_871_872_873_874_875_876_877_878_879_880_881_882_883_884_885_886_887_888_889_890_891_892_893_894_895_896_897_898_899_900_901_902_903_904_905_906_907_908_909_910_911_912_913_914_915_916_917_918_919_920_921_922_923_924_925_926_927_928_929_930_931_932_933_934_935_936_937_938_939_940_941_942_943_944_945_946_947_948_949_950_951_952_953_954_955_956_957_958_959_960_961_962_963_964_965_966_967_968_969_970_971_972_973_974_975_976_977_978_979_980_981_982_983_984_985_986_987_988_989_990_991_992_993_994_995_996_997_998_999_1000

- Internal Room Elevations

- Internal Room Elevators

- Internal Room Elevations

- Internal Room Elevators

BCL-AC-XX-SH-001		1st Submission																
		Action By	Drawing Number	Drawing Title	Date Required from Consultant	Date Submitted by Consultant	Document Revision	Planned Date to be Submitted to Board	Date Submitted to Board	Date Response Required from Board (+3 Weeks)	Date Returned from Board	Board Status	Date returned to Consultant	Date Required from Consultant	Date Submitted by Consultant	Document Revision		
Item	Submission	Comments																
6	Fire Strategy																	
	1:500 Fire Strategy Plans	NA	NA-XX-00-PL-572-001	Site Plan - Fire Strategy		As Appendix K									25/05/2012			
		NA	NA-XX-00-PL-572-010	Ground Floor Fire Strategy Plan		As Appendix K									05/10/2012			
		NA	NA-XX-01-PL-572-010	First Floor Fire Strategy Plan		As Appendix K									25/05/2012			
		NA	NA-XX-02-PL-572-010	Second Floor Fire Strategy Plan		As Appendix K									25/05/2012			
		NA	NA-XX-03-PL-572-010	Third Floor Fire Strategy Plan		As Appendix K									25/05/2012			
		NA	NA-XX-04-PL-572-010	Fourth Floor Fire Strategy Plan		As Appendix K									25/05/2012			
		NA	NA-XX-05-PL-572-010	Fifth Floor Plan Fire Strategy		As Appendix K									25/05/2012			
		NA	NA-XX-06-PL-572-010	Sixth Floor Plan Fire Strategy		As Appendix K									25/05/2012			
		NA	NA-xx-07-PL-572-010	Seventh Floor Plan Fire Strategy		As Appendix K									25/05/2012			
		NA	NA-xx-08-PL-572-010	Eighth Floor Plan Fire Strategy		As Appendix K									25/05/2012			
		NA	NA-xx-09-PL-572-010	Ninth Floor Plan Fire Strategy		As Appendix K									25/05/2012			
		NA	NA-xx-10-PL-572-010	Tenth Floor Plan Fire Strategy		As Appendix K									25/05/2012			
		NA	NA-xx-11-PL-572-010	Eleventh Floor Plan Fire Strategy		As Appendix K									25/05/2012			
		NA	NA-XX-12-PL-572-010	Twelfth Floor Plan - Fire Strategy		As Appendix K									25/05/2012			
		NA	NA-XX-13-PL-572-010															
		NA	NA-XX-B1-PL-572-010	Basement Plan - Fire Strategy		As Appendix K									25/05/2012			
		NA	NA-EC-XX-PL-572-101	Energy Centre Ground Floor and First Floor Fire Strategy		As Appendix K									25/05/2012	4		
		NA	NA-EC-XX-PL-572-102	Energy Centre Second Floor and Roof Fire Strategy		As Appendix K									25/05/2012	5		
		NA	NA-EC-XX-EL-572-101	Energy Centre Elevations Fire Strategy		As Appendix K									25/05/2012	4		
		NA	NA-EC-XX-SE-572-101	Energy Centre Sections Fire Strategy		As Appendix K									25/05/2012			
		NA	NA-XX-00-PL-572-100	Ground Floor Plan - NSGH Main Entrance, FM Offices, Pharmacy, Discharge Lounge - Fire Strategy Plan		As Appendix K									11/11/2011	6		
		NA	NA-XX-00-PL-572-101	Ground Floor Plan - NCH Rehab - Fire Strategy Plan		As Appendix K									11/11/2011	6		
		NA	NA-XX-00-PL-572-102	Ground Floor Plan - NCH Entrance and OPD - Fire Strategy Plan		As Appendix K									11/11/2011	6		

6BCL-AC-XX-SH-001			1st Submission														
			Action By	Drawing Number	Drawing Title	Date Required from Consultant	Date Submitted by Consultant	Document Revision	Planned Date to be Submitted to Board	Date Submitted to Board	Date Response Required from Board (+3 Weeks)	Date Returned from Board	Board Status	Date returned to Consultant	Date Required from Consultant	Date Submitted by Consultant	Document Revision
Item	Submission	Comments															
			NA	NA-XX-00-PL-572-103	Ground Floor Plan - NCH Observation Ward - Fire Strategy Plan		As Appendix K									11/11/2011	7
			NA	NA-XX-00-PL-572-104	Ground Floor Plan - NCH Emergency Department & Decontamination Unit - Fire Strategy Plan		As Appendix K									11/11/2011	7
			NA	NA-XX-00-PL-572-105	Ground Floor Plan - NSGH Emergency Department - Fire Strategy Plan		As Appendix K									11/11/2011	6
			NA	NA-XX-00-PL-572-106	Ground Floor Plan - NSGH Acute Assessment - Fire Strategy Plan		As Appendix K									11/11/2011	6
			NA	NA-XX-00-PL-572-107	Ground Floor Plan - NSGH Radiology & Medical Illustration - Fire Strategy Plan		As Appendix K									11/11/2011	7

6BCL-AC-XX-SH-001		1st Submission														
		Action By	Drawing Number	Drawing Title	Date Required from Consultant	Date Submitted by Consultant	Document Revision	Planned Date to be Submitted to Board	Date Submitted to Board	Date Response Required from Board (+3 Weeks)	Date Returned from Board	Board Status	Date returned to Consultant	Date Required from Consultant	Date Submitted by Consultant	Document Revision
Item	Submission	Comments														
			NA	NA-XX-00-PL-572-108	Ground Floor Plan - NCH Radiology - Fire Strategy Plan		As Appendix K								11/11/2011	7
			NA	NA-XX-00-PL-572-109	Ground Floor Plan - NSGH OPD / Rehab & Therapies - Fire Strategy Plan		As Appendix K								11/11/2011	6
			NA	NA-XX-01-PL-572-100	First Floor Plan - NSGH Restaurant, Sanctuary and Atrium Space - Fire Strategy Plan		As Appendix K								11/11/2011	8
			NA	NA-XX-01-PL-572-101	First Floor Plan - NCH Theatres, Radiology & Interventional Radiology - Fire Strategy Plan		As Appendix K								11/11/2011	7
			NA	NA-XX-01-PL-572-102	First Floor Plan - NCH 23 Hour Unit - Fire Strategy Plan		As Appendix K								11/11/2011	6
			NA	NA-XX-01-PL-572-103	First Floor Plan - NCH Critical Care (PICU) / Cardiology Ward / Support / MDU and Special Feeds - Fire Strategy Plan		As Appendix K								11/11/2011	6
			NA	NA-XX-01-PL-572-104	First Floor Plan - NSGH CCU and Critical Care (1 of 2) - Fire Strategy Plan		As Appendix K								11/11/2011	6
			NA	NA-XX-01-PL-572-105	First Floor Plan - NSGH Critical Care (2 of 2) - Fire Strategy Plan		As Appendix K								11/11/2011	6
			NA	NA-XX-01-PL-572-106	First Floor Plan - NSGH Stroke Ward & Medical Day Unit - Fire Strategy Plan		As Appendix K								11/11/2011	6
			NA	NA-XX-01-PL-572-107	First Floor Plan - NSGH Radiology - Fire Strategy Plan		As Appendix K								11/11/2011	7
			NA	NA-XX-01-PL-572-108	First Floor Plan - Nuclear Medicine - Fire Strategy Plan		As Appendix K								11/11/2011	7
			NA	NA-XX-01-PL-572-109	First Floor Plan - NSGH OPD & Pre-op Assessment - Fire Strategy Plan		As Appendix K								11/11/2011	6
			NA	NA-XX-02-PL-572-100	Second Floor Plan - NSGH Atrium, Lift Cores & Bed Management - Fire Strategy Plan		As Appendix K								11/11/2011	7
			NA	NA-XX-02-PL-572-101	Second Floor Plan - NSGH Dermatology Ward + Plant - Fire Strategy Plan		As Appendix K								11/11/2011	6
			NA	NA-XX-02-PL-572-102	Second Floor Plan - NCH Schiehallion Ward / Day Case Unit / Anaesthetics / TCT & Hospital At Night - Fire Strategy Plan		As Appendix K								11/11/2011	6
			NA	NA-XX-02-PL-572-103	Second Floor Plan - NCH Acute Receiving Ward & Aseptic Suite - Fire Strategy Plan		As Appendix K								11/11/2011	7
			NA	NA-XX-02-PL-572-104	Second Floor Plan - NSGH Endoscopy / Decontamination / Medical Physics / Emergency Linen / Transport Base / Telephone Services - Fire Strategy Plan		As Appendix K								11/11/2011	6
			NA	NA-XX-02-PL-572-105	Second Floor Plan - NSGH Theatres (1 of 2) + Plant - Fire Strategy Plan		As Appendix K								11/11/2011	7
			NA	NA-XX-02-PL-572-106	Second Floor Plan - NSGH Theatres (2 of 2) + Plant - Fire Strategy Plan		As Appendix K								11/11/2011	7
			NA	NA-XX-02-PL-572-109	Second Floor Plan - NSGH Dermatology OPD / Renal Dialysis - Fire Strategy Plan		As Appendix K								11/11/2011	6
			NA	NA-xx-03-PL-572-100	Third Floor Plan - NSGH Atrium / Health Records / Radiology Hot Desks / FM Facilities / Equipment Library / Staff Change / Meeting Rooms - Fire Strategy Plan		As Appendix K								11/11/2011	7
			NA	NA-xx-03-PL-572-101	Third Floor Plan - PLANT - Fire Strategy Plan		As Appendix K								11/11/2011	5
			NA	NA-xx-03-PL-572-102	Third Floor Plan - NCH In-Patient Ward & Ward Support (Medicinema) - Fire Strategy Plan		As Appendix K								11/11/2011	7
			NA	NA-xx-03-PL-572-103	Third Floor Plan - NCH In-Patient Ward / Ward Support - Fire Strategy Plan		As Appendix K								11/11/2011	8

6BCL-AC-XX-SH-001		1st Submission														
		Action By	Drawing Number	Drawing Title	Date Required from Consultant	Date Submitted by Consultant	Document Revision	Planned Date to be Submitted to Board	Date Submitted to Board	Date Response Required from Board (+3 Weeks)	Date Returned from Board	Board Status	Date returned to Consultant	Date Required from Consultant	Date Submitted by Consultant	Document Revision
Item	Submission	Comments														
			NA	NA-xx-03-PL-572-105	Third Floor Plan - PLANT - Fire Strategy Plan		As Appendix K								11/11/2011	6
			NA	NA-xx-03-PL-572-106	Third Floor Plan - PLANT - Fire Strategy Plan		As Appendix K								11/11/2011	6
			NA	NA-xx-03-PL-572-109	Third Floor Plan - PLANT - Fire Strategy Plan		As Appendix K								11/11/2011	5
			NA	NA-xx-04-PL-572-100	Fourth Floor Plan - NSGH Atrium / Generic Ward Support / Lift Cores - Fire Strategy Plan		As Appendix K								11/11/2011	7
			NA	NA-xx-04-PL-572-101	Fourth Floor Plan - Higher Acuity Renal Ward - Fire Strategy Plan		As Appendix K								11/11/2011	6
			NA	NA-xx-04-PL-572-102	Fourth Floor Plan - NCH DCFP - Fire Strategy Plan		As Appendix K								11/11/2011	6
			NA	NA-xx-04-PL-572-103	Fourth Floor Plan - Haemo-Oncology Ward - Fire Strategy Plan		As Appendix K								11/11/2011	6
			NA	NA-xx-04-PL-572-104	Fourth Floor Plan - NSGH Renal Ward & Day Case Ward (1 of 2) - Fire Strategy Plan		As Appendix K								11/11/2011	6

6BCL-AC-XX-SH-001		1st Submission														
		Action By	Drawing Number	Drawing Title	Date Required from Consultant	Date Submitted by Consultant	Document Revision	Planned Date to be Submitted to Board	Date Submitted to Board	Date Response Required from Board (+3 Weeks)	Date Returned from Board	Board Status	Date returned to Consultant	Date Required from Consultant	Date Submitted by Consultant	Document Revision
Item	Submission	Comments														
			NA	NA-xx-04-PL-572-105	Fourth Floor Plan - NSGH Renal Ward & Day Case Ward (2 of 2) - Fire Strategy Plan		As Appendix K								11/11/2011	6
			NA	NA-XX-04-PL-572-106	Fourth Floor Plan - NCH Plant Fire Strategy Plan										11/11/2011	6
			NA	NA-xx-05-PL-572-100	Fifth Floor Plan - NSGH Atrium / Generic Ward Support / Lift Core - Fire Strategy Plan		As Appendix K								11/11/2011	7
			NA	NA-xx-05-PL-572-101	Fifth Floor Plan - NSGH Rheumatology Ward - Fire Strategy Plan		As Appendix K								11/11/2011	7
			NA	NA-xx-05-PL-572-102	Fifth Floor Plan - NSGH ENT Ward - Fire Strategy Plan		As Appendix K								11/11/2011	6
			NA	NA-xx-05-PL-572-103	Fifth Floor Plan - NSGH Generic Ward (1 of 2) - Fire Strategy Plan		As Appendix K								11/11/2011	6
			NA	NA-xx-05-PL-572-104	Fifth Floor Plan - NSGH Generic Ward (2 of 2) - Fire Strategy Plan		As Appendix K								11/11/2011	6
			NA	NA-XX-05-PL-572-106	Fifth Floor Plan - NCH Plant Fire Strategy Plan										11/11/2011	5
			NA	NA-xx-06-PL-572-100	Sixth Floor Plan - NSGH Atrium / Generic Ward Support / Lift Core - Fire Strategy Plan		As Appendix K								11/11/2011	7
			NA	NA-xx-06-PL-572-101	Sixth Floor Plan - NSGH Generic Ward (1 of 4) - Fire Strategy Plan		As Appendix K								11/11/2011	7
			NA	NA-xx-06-PL-572-102	Sixth Floor Plan - NSGH Generic Ward (2 of 4) - Fire Strategy Plan		As Appendix K								11/11/2011	6
			NA	NA-xx-06-PL-572-103	Sixth Floor Plan - NSGH Generic Ward (3 of 4) - Fire Strategy Plan		As Appendix K								11/11/2011	6
			NA	NA-xx-06-PL-572-104	Sixth Floor Plan - NSGH Generic Ward (4 of 4) - Fire Strategy Plan		As Appendix K								11/11/2011	6
			NA	NA-xx-07-PL-572-100	Seventh Floor Plan - NSGH Atrium / Generic Ward Support / Lift Core - Fire Strategy Plan		As Appendix K								11/11/2011	2
			NA	NA-xx-07-PL-572-101	Seventh Floor Plan - NSGH Generic Ward (1 of 4) - Fire Strategy Plan		As Appendix K								11/11/2011	2
			NA	NA-xx-07-PL-572-102	Seventh Floor Plan - NSGH Generic Ward (2 of 4) - Fire Strategy Plan		As Appendix K								11/11/2011	2
			NA	NA-xx-07-PL-572-103	Seventh Floor Plan - NSGH Generic Ward (3 of 4) - Fire Strategy Plan		As Appendix K								11/11/2011	2
			NA	NA-xx-07-PL-572-104	Seventh Floor Plan - NSGH Generic Ward (4 of 4) - Fire Strategy Plan		As Appendix K								11/11/2011	2
			NA	NA-xx-08-PL-572-100	Eighth Floor Plan - NSGH Atrium / Generic Ward Support / Lift Core - Fire Strategy Plan		As Appendix K								11/11/2011	2
			NA	NA-xx-08-PL-572-101	Eighth Floor Plan - NSGH Generic Ward (1 of 4) - Fire Strategy Plan		As Appendix K								11/11/2011	2
			NA	NA-xx-08-PL-572-102	Eighth Floor Plan - NSGH Generic Ward (2 of 4) - Fire Strategy Plan		As Appendix K								11/11/2011	2
			NA	NA-xx-08-PL-572-103	Eighth Floor Plan - NSGH Generic Ward (3 of 4) - Fire Strategy Plan		As Appendix K								11/11/2011	2
			NA	NA-xx-08-PL-572-104	Eighth Floor Plan - NSGH Generic Ward (4 of 4) - Fire Strategy Plan		As Appendix K								11/11/2011	2
			NA	NA-xx-09-PL-572-100	Nineth Floor Plan - NSGH Atrium / Generic Ward Support / Lift Core - Fire Strategy Plan		As Appendix K								11/11/2011	2

6BCL-AC-XX-SH-001			1st Submission														
			Action By	Drawing Number	Drawing Title	Date Required from Consultant	Date Submitted by Consultant	Document Revision	Planned Date to be Submitted to Board	Date Submitted to Board	Date Response Required from Board (+3 Weeks)	Date Returned from Board	Board Status	Date returned to Consultant	Date Required from Consultant	Date Submitted by Consultant	Document Revision
Item	Submission	Comments															
			NA	NA-xx-09-PL-572-101	Nineth Floor Plan - NSGH Generic Ward (1 of 4) - Fire Strategy Plan		As Appendix K									11/11/2011	2
			NA	NA-xx-09-PL-572-102	Nineth Floor Plan - NSGH Generic Ward (2 of 4) - Fire Strategy Plan		As Appendix K									11/11/2011	2
			NA	NA-xx-09-PL-572-103	Nineth Floor Plan - NSGH Generic Ward (3 of 4) - Fire Strategy Plan		As Appendix K									11/11/2011	2
			NA	NA-xx-09-PL-572-104	Nineth Floor Plan - NSGH Generic Ward (4 of 4) - Fire Strategy Plan		As Appendix K									11/11/2011	2
			NA	NA-xx-10-PL-572-100	Tenth Floor Plan - NSGH Atrium / Generic Ward Support / Lift Core - Fire Strategy Plan		As Appendix K									11/11/2011	2
			NA	NA-xx-10-PL-572-101	Tenth Floor Plan - NSGH Generic Ward (1 of 4) - Fire Strategy Plan		As Appendix K									11/11/2011	2
			NA	NA-xx-10-PL-572-102	Tenth Floor Plan - NSGH Generic Ward (2 of 4) - Fire Strategy Plan		As Appendix K									11/11/2011	2
			NA	NA-xx-10-PL-572-103	Tenth Floor Plan - NSGH Generic Ward (3 of 4) - Fire Strategy Plan		As Appendix K									11/11/2011	2
			NA	NA-xx-10-PL-572-104	Tenth Floor Plan - NSGH Generic Ward (4 of 4) - Fire Strategy Plan		As Appendix K									11/11/2011	2
			NA	NA-xx-11-PL-572-100	Eleventh Floor Plan - NSGH Atrium / Generic Ward Support / Lift Core - Fire Strategy Plan		As Appendix K									11/11/2011	2

6BCL-AC-XX-SH-001			1st Submission														
			Action By	Drawing Number	Drawing Title	Date Required from Consultant	Date Submitted by Consultant	Document Revision	Planned Date to be Submitted to Board	Date Submitted to Board	Date Response Required from Board (+3 Weeks)	Date Returned from Board	Board Status	Date returned to Consultant	Date Required from Consultant	Date Submitted by Consultant	Document Revision
Item	Submission	Comments															
			NA	NA-xx-11-PL-572-101	Eleventh Floor Plan - NSGH Generic Ward (1 of 4) - Fire Strategy Plan		As Appendix K									11/11/2011	2
			NA	NA-xx-11-PL-572-102	Eleventh Floor Plan - NSGH Generic Ward (2 of 4) - Fire Strategy Plan		As Appendix K									11/11/2011	2
			NA	NA-xx-11-PL-572-103	Eleventh Floor Plan - NSGH Generic Ward (3 of 4) - Fire Strategy Plan		As Appendix K									11/11/2011	2
			NA	NA-xx-11-PL-572-104	Eleventh Floor Plan - NSGH Generic Ward (4 of 4) - Fire Strategy Plan		As Appendix K									11/11/2011	2
			NA	NA-xx-12-PL-572-100	Twelfth Floor Plan - Atrium / Lift Cores		As Appendix K									11/11/2011	8
			NA	NA-xx-12-PL-572-101	Twelfth Floor Plan - PLANT - Fire Strategy Plan (1 of 4)		As Appendix K									11/11/2011	8
			NA	NA-xx-12-PL-572-102	Twelfth Floor Plan - PLANT - Fire Strategy Plan (2 of 4)		As Appendix K									11/11/2011	8
			NA	NA-xx-12-PL-572-103	Twelfth Floor Plan - PLANT - Fire Strategy Plan (3 of 4)		As Appendix K									11/11/2011	8
			NA	NA-xx-12-PL-572-104	Twelfth Floor Plan - PLANT - Fire Strategy Plan (4 of 4)		As Appendix K									11/11/2011	8
			NA	NA-XX-13-PL-572-102	Thirteenth Floor Plan - Helipad Access Fire Strategy Plan											11/11/2011	2
			NA	NA-XX-14-PL-572-102	Fourteenth Floor Plan - Helipad Access Fire Strategy Plan											11/11/2011	2
			NA	NA-XX-15-PL-572-102	Helipad Level Fire Strategy Plan											11/11/2011	2
			NA	NA-XX-B1-PL-572-100	Basement Floor Plan Fire Strategy (1 of 2)											11/11/2011	7
			NA	NA-XX-B1-PL-572-101	Basement Floor Plan Fire Strategy (2 of 2)											11/11/2011	7
			WSP	WSP-SZ-XX-DC-572-043	Atrium Fire Loads		12/07/2013	1		BMCE-TRANSMIT-017323 16/08/2013	06/09/2013	01/10/2013	A	BMCE-TRANSMIT-018220 25/10/2013			
	Fire Strategy Reports		WSP	WSP-SZ-XX-DC-572-200	Fire Safety Design Strategy		26/04/2012	8		BMCE-TRANSMIT-009167 30/05/12	20/06/2012		B	BMCE-TRANSMIT-009661 04/07/2012		12/07/2013	9
			WSP	WSP-SZ-XX-DC-572-500	Atria CFD Modelling		08/06/2012	8		BMCE-TRANSMIT-009300 11/06/12	02/07/2012	17/07/2012	C	BMCE-TRANSMIT-009969 24/07/2012			
		Produced to identify dry riser locations. Not part of list of deliverables and therefore not required for RDD. See Fire Strategy 572-100 series drawings for Dry Riser Locations used to obtain Stage 8 Warrant approval. DRO's on Fire Strategy Plans, Fire Hose Lengths - Principal noted on WSP Fire Safety Design Strategy	NA	NA-xx-00-PL-572-011	Level 00 - Fire Strategy - Fire Hose Lengths and DRO		25/05/2012		11/07/2012								
		Produced to identify dry riser locations. Not part of list of deliverables and therefore not required for RDD. See Fire Strategy 572-100 series drawings for Dry Riser Locations used to obtain Stage 8 Warrant approval. DRO's on Fire Strategy Plans, Fire Hose Lengths - Principal noted on WSP Fire Safety Design Strategy	NA	NA-xx-01-PL-572-011	Level 01 - Fire Strategy - Fire Hose Lengths and DRO		25/05/2012		11/07/2012								
		Produced to identify dry riser locations. Not part of list of deliverables and therefore not required for RDD. See Fire Strategy 572-100 series drawings for Dry Riser Locations used to obtain Stage 8 Warrant approval. DRO's on Fire Strategy Plans, Fire Hose Lengths - Principal noted on WSP Fire Safety Design Strategy	NA	NA-xx-02-PL-572-011	Level 02 - Fire Strategy - Fire Hose Lengths and DRO		25/05/2012		11/07/2012								

6BCL-AC-XX-SH-001			1st Submission														
			Action By	Drawing Number	Drawing Title	Date Required from Consultant	Date Submitted by Consultant	Document Revision	Planned Date to be Submitted to Board	Date Submitted to Board	Date Response Required from Board (+3 Weeks)	Date Returned from Board	Board Status	Date returned to Consultant	Date Required from Consultant	Date Submitted by Consultant	Document Revision
Item	Submission	Comments															
		Produced to identify dry riser locations. Not part of list of deliverables and therefore not required for RDD. See Fire Strategy 572-100 series drawings for Dry Riser Locations used to obtain Stage 8 Warrant approval. DRO's on Fire Strategy Plans, Fire Hose Lengths - Principal noted on WSP Fire Safety Design Strategy	NA	NA-xx-03-PL-572-011	Level 03 - Fire Strategy - Fire Hose Lengths and DRO		25/05/2012		11/07/2012								
		Produced to identify dry riser locations. Not part of list of deliverables and therefore not required for RDD. See Fire Strategy 572-100 series drawings for Dry Riser Locations used to obtain Stage 8 Warrant approval. DRO's on Fire Strategy Plans, Fire Hose Lengths - Principal noted on WSP Fire Safety Design Strategy	NA	NA-xx-04-PL-572-011	Level 04 - Fire Strategy - Fire Hose Lengths and DRO		25/05/2012		11/07/2012								
		Produced to identify dry riser locations. Not part of list of deliverables and therefore not required for RDD. See Fire Strategy 572-100 series drawings for Dry Riser Locations used to obtain Stage 8 Warrant approval. DRO's on Fire Strategy Plans, Fire Hose Lengths - Principal noted on WSP Fire Safety Design Strategy	NA	NA-xx-05-PL-572-011	Level 05 - Fire Strategy - Fire Hose Lengths and DRO		25/05/2012		11/07/2012								
		Produced to identify dry riser locations. Not part of list of deliverables and therefore not required for RDD. See Fire Strategy 572-100 series drawings for Dry Riser Locations used to obtain Stage 8 Warrant approval. DRO's on Fire Strategy Plans, Fire Hose Lengths - Principal noted on WSP Fire Safety Design Strategy	NA	NA-xx-06-PL-572-011	Level 06 - Fire Strategy - Fire Hose Lengths and DRO		25/05/2012		11/07/2012								
		Produced to identify dry riser locations. Not part of list of deliverables and therefore not required for RDD. See Fire Strategy 572-100 series drawings for Dry Riser Locations used to obtain Stage 8 Warrant approval. DRO's on Fire Strategy Plans, Fire Hose Lengths - Principal noted on WSP Fire Safety Design Strategy	NA	NA-xx-07-PL-572-011	Level 07 - Fire Strategy - Fire Hose Lengths and DRO		25/05/2012		11/07/2012								
		Produced to identify dry riser locations. Not part of list of deliverables and therefore not required for RDD. See Fire Strategy 572-100 series drawings for Dry Riser Locations used to obtain Stage 8 Warrant approval. DRO's on Fire Strategy Plans, Fire Hose Lengths - Principal noted on WSP Fire Safety Design Strategy	NA	NA-xx-08-PL-572-011	Level 08 - Fire Strategy - Fire Hose Lengths and DRO		25/05/2012		11/07/2012								
		Produced to identify dry riser locations. Not part of list of deliverables and therefore not required for RDD. See Fire Strategy 572-100 series drawings for Dry Riser Locations used to obtain Stage 8 Warrant approval. DRO's on Fire Strategy Plans, Fire Hose Lengths - Principal noted on WSP Fire Safety Design Strategy	NA	NA-xx-09-PL-572-011	Level 09 - Fire Strategy - Fire Hose Lengths and DRO		25/05/2012		11/07/2012								
		Produced to identify dry riser locations. Not part of list of deliverables and therefore not required for RDD. See Fire Strategy 572-100 series drawings for Dry Riser Locations used to obtain Stage 8 Warrant approval. DRO's on Fire Strategy Plans, Fire Hose Lengths - Principal noted on WSP Fire Safety Design Strategy	NA	NA-xx-10-PL-572-011	Level 10 - Fire Strategy - Fire Hose Lengths and DRO		25/05/2012		11/07/2012								
		Produced to identify dry riser locations. Not part of list of deliverables and therefore not required for RDD. See Fire Strategy 572-100 series drawings for Dry Riser Locations used to obtain Stage 8 Warrant approval. DRO's on Fire Strategy Plans, Fire Hose Lengths - Principal noted on WSP Fire Safety Design Strategy	NA	NA-xx-11-PL-572-011	Level 11 - Fire Strategy - Fire Hose Lengths and DRO		25/05/2012		11/07/2012								
		Produced to identify dry riser locations. Not part of list of deliverables and therefore not required for RDD. See Fire Strategy 572-100 series drawings for Dry Riser Locations used to obtain Stage 8 Warrant approval. DRO's on Fire Strategy Plans, Fire Hose Lengths - Principal noted on WSP Fire Safety Design Strategy	NA	NA-xx-12-PL-572-011	Level 12 - Fire Strategy - Fire Hose Lengths and DRO		25/05/2012		11/07/2012								
		Produced to identify dry riser locations. Not part of list of deliverables and therefore not required for RDD. See Fire Strategy 572-100 series drawings for Dry Riser Locations used to obtain Stage 8 Warrant approval. DRO's on Fire Strategy Plans, Fire Hose Lengths - Principal noted on WSP Fire Safety Design Strategy	NA	NA-xx-B1-PL-572-011	Level B1 - Fire Strategy - Fire Hose Lengths and DRO		25/05/2012		11/07/2012								
		Adults Fire Evacuation Plans	NA	NA-XX-00-PI-572-500	Ground Floor Adults Hospital Fire Evacuation Plan		26/11/2012	1		BMCE-TRANSMIT-012751 05/12/2012	03/01/2013	03/01/2013	B	BMCE-TRANSMIT-013295 14/01/2013		13/02/2014	A
			NA	NA-XX-00-PI-572-501	Ground Floor Adults Hospital Fire Evacuation Plan		26/11/2012	1		BMCE-TRANSMIT-012751 05/12/2012	03/01/2013	03/01/2013	B	BMCE-TRANSMIT-013295 14/01/2013		13/02/2014	A
			NA	NA-XX-00-PI-572-502	Ground Floor Adults Hospital Fire Evacuation Plan		26/11/2012	1		BMCE-TRANSMIT-012751 05/12/2012	03/01/2013	03/01/2013	B	BMCE-TRANSMIT-013295 14/01/2013		13/02/2014	A
			NA	NA-XX-00-PI-572-503	Ground Floor Adults Hospital Fire Evacuation Plan		26/11/2012	1		BMCE-TRANSMIT-012751 05/12/2012	03/01/2013	03/01/2013	B	BMCE-TRANSMIT-013295 14/01/2013		13/02/2014	A
			NA	NA-XX-01-PI-572-500	First Floor Adults Hospital Fire Evacuation Plan		26/11/2012	1		BMCE-TRANSMIT-012751 05/12/2012	03/01/2013	03/01/2013	C	BMCE-TRANSMIT-013295 14/01/2013		13/02/2014	A
			NA	NA-XX-01-PI-572-501	First Floor Adults Hospital Fire Evacuation Plan		26/11/2012	1		BMCE-TRANSMIT-012751 05/12/2012	03/01/2013	03/01/2013	B	BMCE-TRANSMIT-013295 14/01/2013		13/02/2014	A

6BCL-AC-XX-SH-001			1st Submission														
			Action By	Drawing Number	Drawing Title	Date Required from Consultant	Date Submitted by Consultant	Document Revision	Planned Date to be Submitted to Board	Date Submitted to Board	Date Response Required from Board (+3 Weeks)	Date Returned from Board	Board Status	Date returned to Consultant	Date Required from Consultant	Date Submitted by Consultant	Document Revision
Item	Submission	Comments															
			NA	NA-XX-01-PI-572-502	First Floor Adults Hospital Fire Evacuation Plan		26/11/2012	1		BMCE-TRANSMIT-012751 05/12/2012	03/01/2013	03/01/2013	B	BMCE-TRANSMIT-013295 14/01/2013		13/02/2014	A
			NA	NA-XX-01-PI-572-503	First Floor Adults Hospital Fire Evacuation Plan		26/11/2012	1		BMCE-TRANSMIT-012751 05/12/2012	03/01/2013	03/01/2013	B	BMCE-TRANSMIT-013295 14/01/2013		13/02/2014	A
			NA	NA-XX-02-PI-572-500	Second Floor Adults Hospital Fire Evacuation Plan		26/11/2012	1		BMCE-TRANSMIT-012751 05/12/2012	03/01/2013	03/01/2013	B	BMCE-TRANSMIT-013295 14/01/2013		13/02/2014	A
			NA	NA-XX-02-PI-572-501	Second Floor Adults Hospital Fire Evacuation Plan		26/11/2012	1		BMCE-TRANSMIT-012751 05/12/2012	03/01/2013	03/01/2013	B	BMCE-TRANSMIT-013295 14/01/2013		13/02/2014	A
			NA	NA-XX-02-PI-572-502	Second Floor Adults Hospital Fire Evacuation Plan		26/11/2012	1		BMCE-TRANSMIT-012751 05/12/2012	03/01/2013	03/01/2013	B	BMCE-TRANSMIT-013295 14/01/2013		13/02/2014	A
			NA	NA-XX-02-PI-572-503	Second Floor Adults Hospital Fire Evacuation Plan		26/11/2012	1		BMCE-TRANSMIT-012751 05/12/2012	03/01/2013	03/01/2013	B	BMCE-TRANSMIT-013295 14/01/2013		13/02/2014	A
			NA	NA-XX-03-PI-572-500	Third Floor Adults Hospital Fire Evacuation Plan		26/11/2012	1		BMCE-TRANSMIT-012751 05/12/2012	03/01/2013	03/01/2013	B	BMCE-TRANSMIT-013295 14/01/2013		13/02/2014	A
			NA	NA-XX-03-PI-572-501	Third Floor Adults Hospital Fire Evacuation Plan		26/11/2012	1		BMCE-TRANSMIT-012751 05/12/2012	03/01/2013	03/01/2013	B	BMCE-TRANSMIT-013295 14/01/2013		13/02/2014	A
			NA	NA-XX-03-PI-572-502	Third Floor Adults Hospital Fire Evacuation Plan		26/11/2012	1		BMCE-TRANSMIT-012751 05/12/2012	03/01/2013	03/01/2013	B	BMCE-TRANSMIT-013295 14/01/2013		13/02/2014	A
			NA	NA-XX-03-PI-572-503	Third Floor Adults Hospital Fire Evacuation Plan		26/11/2012	1		BMCE-TRANSMIT-012751 05/12/2012	03/01/2013	03/01/2013	B	BMCE-TRANSMIT-013295 14/01/2013		13/02/2014	A
			NA	NA-XX-04-PL-572-500	Fourth Floor Adults Hospital Fire Evacuation Plan		22/04/2013	1		BMCE-TRANSMIT-015546 09/05/2013	30/05/2013	13/06/201	B	BMCE-TRANSMIT-016550 01/07/2013		13/02/2014	A
			NA	NA-XX-04-PL-572-501	Fourth Floor Adults Hospital Fire Evacuation Plan		22/04/2013	1		BMCE-TRANSMIT-015546 09/05/2013	30/05/2013	13/06/201	B	BMCE-TRANSMIT-016550 01/07/2013		13/02/2014	A
			NA	NA-XX-04-PL-572-502	Fourth Floor Adults Hospital Fire Evacuation Plan		22/04/2013	1		BMCE-TRANSMIT-015546 09/05/2013	30/05/2013	13/06/201	B	BMCE-TRANSMIT-016550 01/07/2013		13/02/2014	A
			NA	NA-XX-04-PL-572-503	Fourth Floor Adults Hospital Fire Evacuation Plan		22/04/2013	1		BMCE-TRANSMIT-015546 09/05/2013	30/05/2013	13/06/201	B	BMCE-TRANSMIT-016550 01/07/2013		13/02/2014	A
			NA	NA-XX-04-PL-572-504	Fourth Floor Adults Hospital Fire Evacuation Plan		22/04/2013	1		BMCE-TRANSMIT-015546 09/05/2013	30/05/2013	13/06/201	B	BMCE-TRANSMIT-016550 01/07/2013		13/02/2014	A
			NA	NA-XX-05-PL-572-500	Fifth Floor Adults Hospital Fire Evacuation Plan		22/04/2013	1		BMCE-TRANSMIT-015546 09/05/2013	30/05/2013	13/06/201	A	BMCE-TRANSMIT-016550 01/07/2013		13/02/2014	A
			NA	NA-XX-05-PL-572-501	Fifth Floor Adults Hospital Fire Evacuation Plan		22/04/2013	1		BMCE-TRANSMIT-015546 09/05/2013	30/05/2013	13/06/201	B	BMCE-TRANSMIT-016550 01/07/2013		13/02/2014	A
			NA	NA-XX-05-PL-572-502	Fifth Floor Adults Hospital Fire Evacuation Plan		22/04/2013	1		BMCE-TRANSMIT-015546 09/05/2013	30/05/2013	13/06/201	B	BMCE-TRANSMIT-016550 01/07/2013		13/02/2014	A
			NA	NA-XX-05-PL-572-503	Fifth Floor Adults Hospital Fire Evacuation Plan		22/04/2013	1		BMCE-TRANSMIT-015546 09/05/2013	30/05/2013	13/06/201	B	BMCE-TRANSMIT-016550 01/07/2013		13/02/2014	A
			NA	NA-XX-05-PL-572-504	Fifth Floor Adults Hospital Fire Evacuation Plan		22/04/2013	1		BMCE-TRANSMIT-015546 09/05/2013	30/05/2013	13/06/201	B	BMCE-TRANSMIT-016550 01/07/2013		13/02/2014	A
			NA	NA-XX-06-PL-572-500	Sixth Floor Adults Hospital Fire Evacuation Plan		22/04/2013	1		BMCE-TRANSMIT-015546 09/05/2013	30/05/2013	13/06/201	A	BMCE-TRANSMIT-016550 01/07/2013		13/02/2014	A
			NA	NA-XX-06-PL-572-501	Sixth Floor Adults Hospital Fire Evacuation Plan		22/04/2013	1		BMCE-TRANSMIT-015546 09/05/2013	30/05/2013	13/06/201	B	BMCE-TRANSMIT-016550 01/07/2013		13/02/2014	A
			NA	NA-XX-06-PL-572-502	Sixth Floor Adults Hospital Fire Evacuation Plan		22/04/2013	1		BMCE-TRANSMIT-015546 09/05/2013	30/05/2013	13/06/201	B	BMCE-TRANSMIT-016550 01/07/2013		13/02/2014	A
			NA	NA-XX-06-PL-572-503	Sixth Floor Adults Hospital Fire Evacuation Plan		22/04/2013	1		BMCE-TRANSMIT-015546 09/05/2013	30/05/2013	13/06/201	B	BMCE-TRANSMIT-016550 01/07/2013		13/02/2014	A

6BCL-AC-XX-SH-001			1st Submission														
			Action By	Drawing Number	Drawing Title	Date Required from Consultant	Date Submitted by Consultant	Document Revision	Planned Date to be Submitted to Board	Date Submitted to Board	Date Response Required from Board (+3 Weeks)	Date Returned from Board	Board Status	Date returned to Consultant	Date Required from Consultant	Date Submitted by Consultant	Document Revision
Item	Submission	Comments															
			NA	NA-XX-06-PL-572-504	Sixth Floor Adults Hospital Fire Evacuation Plan		22/04/2013	1		BMCE-TRANSMIT-015546 09/05/2013	30/05/2013	13/06/201	B	BMCE-TRANSMIT-016550 01/07/2013		13/02/2014	A
			NA	NA-XX-07-PL-572-500	Seventh Floor Adults Hospital Fire Evacuation Plan		22/04/2013	1		BMCE-TRANSMIT-015546 09/05/2013	30/05/2013	13/06/201	A	BMCE-TRANSMIT-016550 01/07/2013		13/02/2014	A
			NA	NA-XX-07-PL-572-501	Seventh Floor Adults Hospital Fire Evacuation Plan		22/04/2013	1		BMCE-TRANSMIT-015546 09/05/2013	30/05/2013	13/06/201	B	BMCE-TRANSMIT-016550 01/07/2013		13/02/2014	A
			NA	NA-XX-07-PL-572-502	Seventh Floor Adults Hospital Fire Evacuation Plan		22/04/2013	1		BMCE-TRANSMIT-015546 09/05/2013	30/05/2013	13/06/201	B	BMCE-TRANSMIT-016550 01/07/2013		13/02/2014	A
			NA	NA-XX-07-PL-572-503	Seventh Floor Adults Hospital Fire Evacuation Plan		22/04/2013	1		BMCE-TRANSMIT-015546 09/05/2013	30/05/2013	13/06/201	B	BMCE-TRANSMIT-016550 01/07/2013		13/02/2014	A
			NA	NA-XX-07-PL-572-504	Seventh Floor Adults Hospital Fire Evacuation Plan		22/04/2013	1		BMCE-TRANSMIT-015546 09/05/2013	30/05/2013	13/06/201	B	BMCE-TRANSMIT-016550 01/07/2013		13/02/2014	A
			NA	NA-XX-08-PL-572-500	Eighth Floor Adults Hospital Fire Evacuation Plan		22/04/2013	1		BMCE-TRANSMIT-015546 09/05/2013	30/05/2013	13/06/201	A	BMCE-TRANSMIT-016550 01/07/2013		13/02/2014	A
			NA	NA-XX-08-PL-572-501	Eighth Floor Adults Hospital Fire Evacuation Plan		22/04/2013	1		BMCE-TRANSMIT-015546 09/05/2013	30/05/2013	13/06/201	B	BMCE-TRANSMIT-016550 01/07/2013		13/02/2014	A
			NA	NA-XX-08-PL-572-502	Eighth Floor Adults Hospital Fire Evacuation Plan		22/04/2013	1		BMCE-TRANSMIT-015546 09/05/2013	30/05/2013	13/06/201	B	BMCE-TRANSMIT-016550 01/07/2013		13/02/2014	A
			NA	NA-XX-08-PL-572-503	Eighth Floor Adults Hospital Fire Evacuation Plan		22/04/2013	1		BMCE-TRANSMIT-015546 09/05/2013	30/05/2013	13/06/201	B	BMCE-TRANSMIT-016550 01/07/2013		13/02/2014	A
			NA	NA-XX-08-PL-572-504	Eighth Floor Adults Hospital Fire Evacuation Plan		22/04/2013	1		BMCE-TRANSMIT-015546 09/05/2013	30/05/2013	13/06/201	B	BMCE-TRANSMIT-016550 01/07/2013		13/02/2014	A
			NA	NA-XX-09-PL-572-500	Ninth Floor Adults Hospital Fire Evacuation Plan		22/04/2013	1		BMCE-TRANSMIT-015546 09/05/2013	30/05/2013	13/06/201	A	BMCE-TRANSMIT-016550 01/07/2013		13/02/2014	A
			NA	NA-XX-09-PL-572-501	Ninth Floor Adults Hospital Fire Evacuation Plan		22/04/2013	1		BMCE-TRANSMIT-015546 09/05/2013	30/05/2013	13/06/201	B	BMCE-TRANSMIT-016550 01/07/2013		13/02/2014	A
			NA	NA-XX-09-PL-572-502	Ninth Floor Adults Hospital Fire Evacuation Plan		22/04/2013	1		BMCE-TRANSMIT-015546 09/05/2013	30/05/2013	13/06/201	B	BMCE-TRANSMIT-016550 01/07/2013		13/02/2014	A
			NA	NA-XX-09-PL-572-503	Ninth Floor Adults Hospital Fire Evacuation Plan		22/04/2013	1		BMCE-TRANSMIT-015546 09/05/2013	30/05/2013	13/06/201	B	BMCE-TRANSMIT-016550 01/07/2013		13/02/2014	A
			NA	NA-XX-09-PL-572-504	Ninth Floor Adults Hospital Fire Evacuation Plan		22/04/2013	1		BMCE-TRANSMIT-015546 09/05/2013	30/05/2013	13/06/201	B	BMCE-TRANSMIT-016550 01/07/2013		13/02/2014	A
			NA	NA-XX-10-PL-572-500	Tenth Floor Adults Hospital Fire Evacuation Plan		22/04/2013	1		BMCE-TRANSMIT-015546 09/05/2013	30/05/2013	13/06/201	A	BMCE-TRANSMIT-016550 01/07/2013		13/02/2014	A
			NA	NA-XX-10-PL-572-501	Tenth Floor Adults Hospital Fire Evacuation Plan		22/04/2013	1		BMCE-TRANSMIT-015546 09/05/2013	30/05/2013	13/06/201	B	BMCE-TRANSMIT-016550 01/07/2013		13/02/2014	A
			NA	NA-XX-10-PL-572-502	Tenth Floor Adults Hospital Fire Evacuation Plan		22/04/2013	1		BMCE-TRANSMIT-015546 09/05/2013	30/05/2013	13/06/201	B	BMCE-TRANSMIT-016550 01/07/2013		13/02/2014	A
			NA	NA-XX-10-PL-572-503	Tenth Floor Adults Hospital Fire Evacuation Plan		22/04/2013	1		BMCE-TRANSMIT-015546 09/05/2013	30/05/2013	13/06/201	B	BMCE-TRANSMIT-016550 01/07/2013		13/02/2014	A
			NA	NA-XX-10-PL-572-504	Tenth Floor Adults Hospital Fire Evacuation Plan		22/04/2013	1		BMCE-TRANSMIT-015546 09/05/2013	30/05/2013	13/06/201	B	BMCE-TRANSMIT-016550 01/07/2013		13/02/2014	A
			NA	NA-XX-11-PL-572-500	Eleventh Floor Adults Hospital Fire Evacuation Plan		22/04/2013	1		BMCE-TRANSMIT-015546 09/05/2013	30/05/2013	13/06/201	A	BMCE-TRANSMIT-016550 01/07/2013		13/02/2014	A
			NA	NA-XX-11-PL-572-501	Eleventh Floor Adults Hospital Fire Evacuation Plan		22/04/2013	1		BMCE-TRANSMIT-015546 09/05/2013	30/05/2013	13/06/201	B	BMCE-TRANSMIT-016550 01/07/2013		13/02/2014	A
			NA	NA-XX-11-PL-572-502	Eleventh Floor Adults Hospital Fire Evacuation Plan		22/04/2013	1		BMCE-TRANSMIT-015546 09/05/2013	30/05/2013	13/06/201	B	BMCE-TRANSMIT-016550 01/07/2013		13/02/2014	A

6BCL-AC-XX-SH-001			1st Submission														
			Action By	Drawing Number	Drawing Title	Date Required from Consultant	Date Submitted by Consultant	Document Revision	Planned Date to be Submitted to Board	Date Submitted to Board	Date Response Required from Board (+3 Weeks)	Date Returned from Board	Board Status	Date returned to Consultant	Date Required from Consultant	Date Submitted by Consultant	Document Revision
Item	Submission	Comments															
			NA	NA-XX-11-PL-572-503	Eleventh Floor Adults Hospital Fire Evacuation Plan		22/04/2013	1		BMCE-TRANSMIT-015546 09/05/2013	30/05/2013	13/06/201	B	BMCE-TRANSMIT-016550 01/07/2013		13/02/2014	A
			NA	NA-XX-11-PL-572-504	Eleventh Floor Adults Hospital Fire Evacuation Plan		22/04/2013	1		BMCE-TRANSMIT-015546 09/05/2013	30/05/2013	13/06/201	B	BMCE-TRANSMIT-016550 01/07/2013		13/02/2014	A
			NA	NA-XX-12-PL-572-500	Twelfth Floor Adults Hospital Fire Evacuation Plan		22/04/2013	1		BMCE-TRANSMIT-015546 09/05/2013	30/05/2013	13/06/201	B	BMCE-TRANSMIT-016550 01/07/2013		13/02/2014	A
			NA	NA-XX-12-PL-572-501	Twelfth Floor Adults Hospital Fire Evacuation Plan		22/04/2013	1		BMCE-TRANSMIT-015546 09/05/2013	30/05/2013	13/06/201	B	BMCE-TRANSMIT-016550 01/07/2013		13/02/2014	A
			NA	NA-XX-12-PL-572-502	Twelfth Floor Adults Hospital Fire Evacuation Plan		22/04/2013	1		BMCE-TRANSMIT-015546 09/05/2013	30/05/2013	13/06/201	B	BMCE-TRANSMIT-016550 01/07/2013		13/02/2014	A
			NA	NA-XX-12-PL-572-503	Twelfth Floor Adults Hospital Fire Evacuation Plan		22/04/2013	1		BMCE-TRANSMIT-015546 09/05/2013	30/05/2013	13/06/201	B	BMCE-TRANSMIT-016550 01/07/2013		13/02/2014	A
			NA	NA-XX-12-PL-572-504	Twelfth Floor Adults Hospital Fire Evacuation Plan		22/04/2013	1		BMCE-TRANSMIT-015546 09/05/2013	30/05/2013	13/06/201	B	BMCE-TRANSMIT-016550 01/07/2013		13/02/2014	A
			NA	NA-XX-B1-PI-572-500	Basement Floor Adults Hospital Fire Evacuation Plan		26/11/2012	1		BMCE-TRANSMIT-012751 05/12/2012	03/01/2013	03/01/2013	B	BMCE-TRANSMIT-013295 14/01/2013		13/02/2014	A
			NA	NA-XX-B1-PI-572-501	Basement Floor Adults Hospital Fire Evacuation Plan		26/11/2012	1		BMCE-TRANSMIT-012751 05/12/2012	03/01/2013	03/01/2013	C	BMCE-TRANSMIT-013295 14/01/2013		13/02/2014	A
			NA	NA-XX-B1-PI-572-502	Basement Floor Adults Hospital Fire Evacuation Plan		26/11/2012	1		BMCE-TRANSMIT-012751 05/12/2012	03/01/2013	03/01/2013	A	BMCE-TRANSMIT-013295 14/01/2013		13/02/2014	A
		Childrens Fire Evacuation Plans															
			NA	NA-XX-00-PL-572-504	Ground Floor Childrens Hospital Fire Evacuation Plan		13/05/2013	1		BMCE-TRANSMIT-015956 29/05/2013	19/06/2013	13/06/2013	B	BMCE-TRANSMIT-016357 19/06/2013		13/02/2014	A
			NA	NA-XX-00-PL-572-505	Ground Floor Childrens Hospital Fire Evacuation Plan		13/05/2013	2		BMCE-TRANSMIT-015956 29/05/2013	19/06/2013	13/06/2013	B	BMCE-TRANSMIT-016357 19/06/2013		13/02/2014	A
			NA	NA-XX-01-PL-572-504	First Floor Childrens Hospital Fire Evacuation Plan		13/05/2013	1		BMCE-TRANSMIT-015956 29/05/2013	19/06/2013	13/06/2013	B	BMCE-TRANSMIT-016357 19/06/2013		13/02/2014	A
			NA	NA-XX-01-PL-572-505	First Floor Childrens Hospital Fire Evacuation Plan		13/05/2013	2		BMCE-TRANSMIT-015956 29/05/2013	19/06/2013	13/06/2013	B	BMCE-TRANSMIT-016357 19/06/2013		13/02/2014	A
			NA	NA-XX-02-PL-572-504	Second Floor Childrens Hospital Fire Evacuation Plan		13/05/2013	1		BMCE-TRANSMIT-015956 29/05/2013	19/06/2013	13/06/2013	B	BMCE-TRANSMIT-016357 19/06/2013		13/02/2014	A
			NA	NA-XX-02-PL-572-505	Second Floor Childrens Hospital Fire Evacuation Plan		13/05/2013	1		BMCE-TRANSMIT-015956 29/05/2013	19/06/2013	13/06/2013	A	BMCE-TRANSMIT-016357 19/06/2013		13/02/2014	A
			NA	NA-XX-03-PL-572-504	Third Floor Childrens Hospital Fire Evacuation Plan		13/05/2013	1		BMCE-TRANSMIT-015956 29/05/2013	19/06/2013	13/06/2013	B	BMCE-TRANSMIT-016357 19/06/2013		13/02/2014	A
			NA	NA-XX-03-PL-572-505	Third Floor Childrens Hospital Fire Evacuation Plan		13/05/2013	1		BMCE-TRANSMIT-015956 29/05/2013	19/06/2013	13/06/2013	B	BMCE-TRANSMIT-016357 19/06/2013		13/02/2014	A
			NA	NA-XX-04-PL-572-505	Fourth Floor Childrens Hospital Fire Evacuation Plan		13/05/2013	1		BMCE-TRANSMIT-015956 29/05/2013	19/06/2013	13/06/2013	B	BMCE-TRANSMIT-016357 19/06/2013		13/02/2014	A
			NA	NA-XX-04-PL-572-506	Fourth Floor Childrens Hospital Fire Evacuation Plan		13/05/2013	1		BMCE-TRANSMIT-015956 29/05/2013	19/06/2013	13/06/2013	B	BMCE-TRANSMIT-016357 19/06/2013		13/02/2014	A
		FIRE ENGINEERING	WSP	WSP-SZ-XX-DC-572-043	Atrium Fire Loads		12/07/2013	1		BMCE-TRANSMIT-017323 16/08/2013	06/09/2013	01/10/2013	A	BMCE-TRANSMIT-018220 25/10/2013			
			WSP	WSP-SZ-XX-DC-572-200	Fire Safety Design Strategy		12/07/2013	9		BMCE-TRANSMIT-017323 16/08/2013	06/09/2013	01/10/2013	B	BMCE-TRANSMIT-018220 25/10/2013			

6BCL-AC-XX-SH-001			1st Submission														
			Action By	Drawing Number	Drawing Title	Date Required from Consultant	Date Submitted by Consultant	Document Revision	Planned Date to be Submitted to Board	Date Submitted to Board	Date Response Required from Board (+3 Weeks)	Date Returned from Board	Board Status	Date returned to Consultant	Date Required from Consultant	Date Submitted by Consultant	Document Revision
Item	Submission	Comments															
			MER	ME-XX-00-PL-572-201	Level 00 - MCP & Fire Extinguisher Locations		25/05/2012		11/07/2012								
			MER	ME-XX-01-PL-572-202	Level 01 - MCP & Fire Extinguisher Locations		25/05/2012		11/07/2012								
			MER	ME-XX-02-PL-572-203	Level 02 - MCP & Fire Extinguisher Locations		25/05/2012		11/07/2012								

6BCL-AC-XX-SH-001			1st Submission														
			Action By	Drawing Number	Drawing Title	Date Required from Consultant	Date Submitted by Consultant	Document Revision	Planned Date to be Submitted to Board	Date Submitted to Board	Date Response Required from Board (+3 Weeks)	Date Returned from Board	Board Status	Date returned to Consultant	Date Required from Consultant	Date Submitted by Consultant	Document Revision
Item	Submission	Comments															
			MER	ME-XX-03-PL-572-204	Level 03 - MCP & Fire Extinguisher Locations		25/05/2012		11/07/2012								
			MER	ME-XX-04-PL-572-205	Level 04 - MCP & Fire Extinguisher Locations		25/05/2012		11/07/2012								
			MER	ME-XX-05-PL-572-206	Level 05 - MCP & Fire Extinguisher Locations		25/05/2012		11/07/2012								
			MER	ME-XX-06-PL-572-207	Level 06 - MCP & Fire Extinguisher Locations		25/05/2012		11/07/2012								
			MER	ME-XX-07-PL-572-208	Level 07 - MCP & Fire Extinguisher Locations		25/05/2012		11/07/2012								
			MER	ME-XX-08-PL-572-209	Level 08 - MCP & Fire Extinguisher Locations		25/05/2012		11/07/2012								
			MER	ME-XX-09-PL-572-210	Level 09 - MCP & Fire Extinguisher Locations		25/05/2012		11/07/2012								
			MER	ME-XX-10-PL-572-211	Level 10 - MCP & Fire Extinguisher Locations		25/05/2012		11/07/2012								
			MER	ME-XX-11-PL-572-212	Level 11 - MCP & Fire Extinguisher Locations		25/05/2012		11/07/2012								
			MER	ME-XX-00-PL-572-200	Level B1 - MCP & Fire Extinguisher Locations		25/05/2012		11/07/2012								
		Fire Signage & Emergency Lighting to be developed															

Brookfield Multiplex Europe

2nd Submission							OVERDUE
Planned Date to be Submitted to Board	Date Submitted to Board	BMCE Transmittal No	Date Response Required from Board (+2 Weeks)	Date Received from Board	Board Status	Date Returned to Consultant	OVERDUE
11/07/2012							
11/07/2012							
11/07/2012	Sent to Board for info only						
11/07/2012	17/04/2013	BMCE-TRANSMIT-015177	08/05/2013	30/04/2013	A	BMCE-TRANSMIT-015408 30/04/201	
11/07/2012	17/04/2013	BMCE-TRANSMIT-015177	08/05/2013	30/04/2013	A	BMCE-TRANSMIT-015408 30/04/201	
11/07/2012	17/04/2013	BMCE-TRANSMIT-015177	08/05/2013	30/04/2013	A	BMCE-TRANSMIT-015408 30/04/201	
11/07/2012							
10/10/2011	15/11/2011	BMCE-TRANSMIT-006708	29/11/2011	24/01/2012	B	23/02/2012 BMCE-TRANSMIT-007768	
10/10/2011	15/11/2011	BMCE-TRANSMIT-006708	29/11/2011	24/01/2012	A	23/02/2012 BMCE-TRANSMIT-007768	
10/10/2011	15/11/2011	BMCE-TRANSMIT-006708	29/11/2011	24/01/2012	B	23/02/2012 BMCE-TRANSMIT-007768	

Brookfield Multiplex Europe

2nd Submission							OVERDUE
Planned Date to be Submitted to Board	Date Submitted to Board	BMCE Transmittal No	Date Response Required from Board (+2 Weeks)	Date Received from Board	Board Status	Date Returned to Consultant	OVERDUE
10/10/2011	15/11/2011	BMCE-TRANSMIT-006708	29/11/2011	24/01/2012	A	23/02/2012 BMCE-TRANSMIT-007768	
10/10/2011	15/11/2011	BMCE-TRANSMIT-006708	29/11/2011	24/01/2012	A	23/02/2012 BMCE-TRANSMIT-007768	
10/10/2011	15/11/2011	BMCE-TRANSMIT-006708	29/11/2011	24/01/2012	C	23/02/2012 BMCE-TRANSMIT-007768	
10/10/2011	15/11/2011	BMCE-TRANSMIT-006708	29/11/2011	24/01/2012	B	23/02/2012 BMCE-TRANSMIT-007768	
10/10/2011	15/11/2011	BMCE-TRANSMIT-006708	29/11/2011	24/01/2012	A	23/02/2012 BMCE-TRANSMIT-007768	

Brookfield Multiplex Europe

2nd Submission							OVERDUE
Planned Date to be Submitted to Board	Date Submitted to Board	BMCE Transmittal No	Date Response Required from Board (+2 Weeks)	Date Received from Board	Board Status	Date Returned to Consultant	OVERDUE
10/10/2011	15/11/2011	BMCE-TRANSMIT-006708	29/11/2011	24/01/2012	B	23/02/2012 BMCE-TRANSMIT-007768	
10/10/2011	15/11/2011	BMCE-TRANSMIT-006708	29/11/2011	24/01/2012	A	23/02/2012 BMCE-TRANSMIT-007768	
10/10/2011	15/11/2011	BMCE-TRANSMIT-006708	29/11/2011	24/01/2012	C	23/02/2012 BMCE-TRANSMIT-007768	
10/10/2011	15/11/2011	BMCE-TRANSMIT-006708	29/11/2011	24/01/2012	B	23/02/2012 BMCE-TRANSMIT-007768	
10/10/2011	15/11/2011	BMCE-TRANSMIT-006708	29/11/2011	24/01/2012	A	23/02/2012 BMCE-TRANSMIT-007768	
10/10/2011	15/11/2011	BMCE-TRANSMIT-006708	29/11/2011	24/01/2012	B	23/02/2012 BMCE-TRANSMIT-007768	
10/10/2011	15/11/2011	BMCE-TRANSMIT-006708	29/11/2011	24/01/2012	A	23/02/2012 BMCE-TRANSMIT-007768	
10/10/2011	15/11/2011	BMCE-TRANSMIT-006708	29/11/2011	24/01/2012	B	23/02/2012 BMCE-TRANSMIT-007768	
10/10/2011	15/11/2011	BMCE-TRANSMIT-006708	29/11/2011	24/01/2012	B	23/02/2012 BMCE-TRANSMIT-007768	
10/10/2011	15/11/2011	BMCE-TRANSMIT-006708	29/11/2011	24/01/2012	A	23/02/2012 BMCE-TRANSMIT-007768	
10/10/2011	15/11/2011	BMCE-TRANSMIT-006708	29/11/2011	24/01/2012	B	23/02/2012 BMCE-TRANSMIT-007768	
10/10/2011	15/11/2011	BMCE-TRANSMIT-006708	29/11/2011	24/01/2012	B	23/02/2012 BMCE-TRANSMIT-007768	
10/10/2011	15/11/2011	BMCE-TRANSMIT-006708	29/11/2011	24/01/2012	A	23/02/2012 BMCE-TRANSMIT-007768	
10/10/2011	15/11/2011	BMCE-TRANSMIT-006708	29/11/2011	24/01/2012	B	23/02/2012 BMCE-TRANSMIT-007768	
10/10/2011	15/11/2011	BMCE-TRANSMIT-006708	29/11/2011	24/01/2012	B	23/02/2012 BMCE-TRANSMIT-007768	
10/10/2011	15/11/2011	BMCE-TRANSMIT-006708	29/11/2011	24/01/2012	A	23/02/2012 BMCE-TRANSMIT-007768	
10/10/2011	15/11/2011	BMCE-TRANSMIT-006708	29/11/2011	24/01/2012	B	23/02/2012 BMCE-TRANSMIT-007768	
10/10/2011	15/11/2011	BMCE-TRANSMIT-006708	29/11/2011	24/01/2012	B	23/02/2012 BMCE-TRANSMIT-007768	
10/10/2011	15/11/2011	BMCE-TRANSMIT-006708	29/11/2011	24/01/2012	B	23/02/2012 BMCE-TRANSMIT-007768	
10/10/2011	15/11/2011	BMCE-TRANSMIT-006708	29/11/2011	24/01/2012	C	23/02/2012 BMCE-TRANSMIT-007768	
10/10/2011	15/11/2011	BMCE-TRANSMIT-006708	29/11/2011	24/01/2012	B	23/02/2012 BMCE-TRANSMIT-007768	
10/10/2011	15/11/2011	BMCE-TRANSMIT-006708	29/11/2011	24/01/2012	B	23/02/2012 BMCE-TRANSMIT-007768	
10/10/2011	15/11/2011	BMCE-TRANSMIT-006708	29/11/2011	24/01/2012	B	23/02/2012 BMCE-TRANSMIT-007768	
10/10/2011	15/11/2011	BMCE-TRANSMIT-006708	29/11/2011	24/01/2012	B	23/02/2012 BMCE-TRANSMIT-007768	
10/10/2011	15/11/2011	BMCE-TRANSMIT-006708	29/11/2011	24/01/2012	A	23/02/2012 BMCE-TRANSMIT-007768	
10/10/2011	15/11/2011	BMCE-TRANSMIT-006708	29/11/2011	24/01/2012	B	23/02/2012 BMCE-TRANSMIT-007768	
10/10/2011	15/11/2011	BMCE-TRANSMIT-006708	29/11/2011	24/01/2012	B	23/02/2012 BMCE-TRANSMIT-007768	
10/10/2011	15/11/2011	BMCE-TRANSMIT-006708	29/11/2011	24/01/2012	B	23/02/2012 BMCE-TRANSMIT-007768	
10/10/2011	15/11/2011	BMCE-TRANSMIT-006708	29/11/2011	24/01/2012	A	23/02/2012 BMCE-TRANSMIT-007768	
10/10/2011	15/11/2011	BMCE-TRANSMIT-006708	29/11/2011	24/01/2012	B	23/02/2012 BMCE-TRANSMIT-007768	
10/10/2011	15/11/2011	BMCE-TRANSMIT-006708	29/11/2011	24/01/2012	A	23/02/2012 BMCE-TRANSMIT-007768	

Brookfield Multiplex Europe

2nd Submission							OVERDUE
Planned Date to be Submitted to Board	Date Submitted to Board	BMCE Transmittal No	Date Response Required from Board (+2 Weeks)	Date Received from Board	Board Status	Date Returned to Consultant	OVERDUE
10/10/2011	15/11/2011	BMCE-TRANSMIT-006708	29/11/2011	24/01/2012	A	23/02/2012 BMCE-TRANSMIT-007768	
10/10/2011	15/11/2011	BMCE-TRANSMIT-006708	29/11/2011	24/01/2012	A	23/02/2012 BMCE-TRANSMIT-007768	
10/10/2011	15/11/2011	BMCE-TRANSMIT-006708	29/11/2011	24/01/2012	A	23/02/2012 BMCE-TRANSMIT-007768	
10/10/2011	15/11/2011	BMCE-TRANSMIT-006708	29/11/2011	24/01/2012	B	23/02/2012 BMCE-TRANSMIT-007768	
10/10/2011	15/11/2011	BMCE-TRANSMIT-006708	29/11/2011	24/01/2012	B	23/02/2012 BMCE-TRANSMIT-007768	
10/10/2011	15/11/2011	BMCE-TRANSMIT-006708	29/11/2011	24/01/2012	B	23/02/2012 BMCE-TRANSMIT-007768	
10/10/2011	15/11/2011	BMCE-TRANSMIT-006708	29/11/2011	24/01/2012	B	23/02/2012 BMCE-TRANSMIT-007768	
10/10/2011	15/11/2011	BMCE-TRANSMIT-006708	29/11/2011	24/01/2012	B	23/02/2012 BMCE-TRANSMIT-007768	

Brookfield Multiplex Europe

2nd Submission							OVERDUE
Planned Date to be Submitted to Board	Date Submitted to Board	BMCE Transmittal No	Date Response Required from Board (+2 Weeks)	Date Received from Board	Board Status	Date Returned to Consultant	OVERDUE
10/10/2011	15/11/2011	BMCE-TRANSMIT-006708	29/11/2011	24/01/2012	B	23/02/2012 BMCE-TRANSMIT-007768	
	15/11/2011	BMCE-TRANSMIT-006708	29/11/2011	24/01/2012	B	23/02/2012 BMCE-TRANSMIT-007768	
10/10/2011	15/11/2011	BMCE-TRANSMIT-006708	29/11/2011	24/01/2012	B	23/02/2012 BMCE-TRANSMIT-007768	
10/10/2011	15/11/2011	BMCE-TRANSMIT-006708	29/11/2011	24/01/2012	B	23/02/2012 BMCE-TRANSMIT-007768	
10/10/2011	15/11/2011	BMCE-TRANSMIT-006708	29/11/2011	24/01/2012	B	23/02/2012 BMCE-TRANSMIT-007768	
10/10/2011	15/11/2011	BMCE-TRANSMIT-006708	29/11/2011	24/01/2012	B	23/02/2012 BMCE-TRANSMIT-007768	
10/10/2011	15/11/2011	BMCE-TRANSMIT-006708	29/11/2011	24/01/2012	B	23/02/2012 BMCE-TRANSMIT-007768	
	15/11/2011	BMCE-TRANSMIT-006708	29/11/2011	24/01/2012	A	23/02/2012 BMCE-TRANSMIT-007768	
10/10/2011	15/11/2011	BMCE-TRANSMIT-006708	29/11/2011	24/01/2012	B	23/02/2012 BMCE-TRANSMIT-007768	
10/10/2011	15/11/2011	BMCE-TRANSMIT-006708	29/11/2011	24/01/2012	B	23/02/2012 BMCE-TRANSMIT-007768	
Brookfield Multiplex Europe

2nd Submission							OVERDUE
Planned Date to be Submitted to Board	Date Submitted to Board	BMCE Transmittal No	Date Response Required from Board (+2 Weeks)	Date Received from Board	Board Status	Date Returned to Consultant	OVERDUE
10/10/2011	15/11/2011	BMCE-TRANSMIT-006708	29/11/2011	24/01/2012	B	23/02/2012 BMCE-TRANSMIT-007768	
10/10/2011	15/11/2011	BMCE-TRANSMIT-006708	29/11/2011	24/01/2012	B	23/02/2012 BMCE-TRANSMIT-007768	
Brookfield Multiplex Europe

2nd Submission							OVERDUE
Planned Date to be Submitted to Board	Date Submitted to Board	BMCE Transmittal No	Date Response Required from Board (+2 Weeks)	Date Received from Board	Board Status	Date Returned to Consultant	OVERDUE
10/10/2011	15/11/2011	BMCE-TRANSMIT-006708	29/11/2011	24/01/2012	B	23/02/2012 BMCE-TRANSMIT-007768	
10/10/2011	15/11/2011	BMCE-TRANSMIT-006708	29/11/2011	24/01/2012	B	23/02/2012 BMCE-TRANSMIT-007768	
10/10/2011	15/11/2011	BMCE-TRANSMIT-006708	29/11/2011	24/01/2012	B	23/02/2012 BMCE-TRANSMIT-007768	
10/10/2011	15/11/2011	BMCE-TRANSMIT-006708	29/11/2011	24/01/2012	B	23/02/2012 BMCE-TRANSMIT-007768	
10/10/2011	15/11/2011	BMCE-TRANSMIT-006708	29/11/2011	24/01/2012	A	23/02/2012 BMCE-TRANSMIT-007768	
10/10/2011	15/11/2011	BMCE-TRANSMIT-006708	29/11/2011	24/01/2012	A	23/02/2012 BMCE-TRANSMIT-007768	
10/10/2011	15/11/2011	BMCE-TRANSMIT-006708	29/11/2011	24/01/2012	A	23/02/2012 BMCE-TRANSMIT-007768	
10/10/2011	15/11/2011	BMCE-TRANSMIT-006708	29/11/2011	24/01/2012	A	23/02/2012 BMCE-TRANSMIT-007768	
10/10/2011	15/11/2011	BMCE-TRANSMIT-006708	29/11/2011	24/01/2012	A	23/02/2012 BMCE-TRANSMIT-007768	
	15/11/2011	BMCE-TRANSMIT-006708	29/11/2011	24/01/2012	A	23/02/2012 BMCE-TRANSMIT-007768	
	15/11/2011	BMCE-TRANSMIT-006708	29/11/2011	24/01/2012	A	23/02/2012 BMCE-TRANSMIT-007768	
	15/11/2011	BMCE-TRANSMIT-006708	29/11/2011	24/01/2012	A	23/02/2012 BMCE-TRANSMIT-007768	
	15/11/2011	BMCE-TRANSMIT-006708	29/11/2011	24/01/2012	B	23/02/2012 BMCE-TRANSMIT-007768	
	15/11/2011	BMCE-TRANSMIT-006708	29/11/2011	24/01/2012	A	23/02/2012 BMCE-TRANSMIT-007768	
	16/08/2013	BMCE-TRANSMIT-017323 16/08/2013	06/09/2013	01/10/2013	A	BMCE-TRANSMIT-018220 25/10/2013	

[illegible]

Brookfield Multiplex Europe

2nd Submission							OVERDUE
Planned Date to be Submitted to Board	Date Submitted to Board	BMCE Transmittal No	Date Response Required from Board (+2 Weeks)	Date Received from Board	Board Status	Date Returned to Consultant	OVERDUE
	03/03/2014	BMCE-TRANSMIT-019583	14/03/2014	24/03/2014	A	BMCE-TRANSMIT-019872 09/04/2014	
	03/03/2014	BMCE-TRANSMIT-019583	14/03/2014	24/03/2014	B	BMCE-TRANSMIT-019872 09/04/2014	
	03/03/2014	BMCE-TRANSMIT-019583	14/03/2014	24/03/2014	B	BMCE-TRANSMIT-019872 09/04/2014	
	03/03/2014	BMCE-TRANSMIT-019583	14/03/2014	24/03/2014	A	BMCE-TRANSMIT-019872 09/04/2014	
	03/03/2014	BMCE-TRANSMIT-019583	14/03/2014	24/03/2014	B	BMCE-TRANSMIT-019872 09/04/2014	
	03/03/2014	BMCE-TRANSMIT-019583	14/03/2014	24/03/2014	B	BMCE-TRANSMIT-019872 09/04/2014	
	03/03/2014	BMCE-TRANSMIT-019583	14/03/2014	24/03/2014	B	BMCE-TRANSMIT-019872 09/04/2014	
	03/03/2014	BMCE-TRANSMIT-019583	14/03/2014	24/03/2014	B	BMCE-TRANSMIT-019872 09/04/2014	
	03/03/2014	BMCE-TRANSMIT-019583	14/03/2014	24/03/2014	B	BMCE-TRANSMIT-019872 09/04/2014	
	03/03/2014	BMCE-TRANSMIT-019583	14/03/2014	24/03/2014	B	BMCE-TRANSMIT-019872 09/04/2014	
	03/03/2014	BMCE-TRANSMIT-019583	14/03/2014	24/03/2014	B	BMCE-TRANSMIT-019872 09/04/2014	
	03/03/2014	BMCE-TRANSMIT-019583	14/03/2014	24/03/2014	A	BMCE-TRANSMIT-019872 09/04/2014	
	03/03/2014	BMCE-TRANSMIT-019583	14/03/2014	24/03/2014	B	BMCE-TRANSMIT-019872 09/04/2014	
	03/03/2014	BMCE-TRANSMIT-019583	14/03/2014	24/03/2014	A	BMCE-TRANSMIT-019872 09/04/2014	
	03/03/2014	BMCE-TRANSMIT-019583	14/03/2014	24/03/2014	A	BMCE-TRANSMIT-019872 09/04/2014	
	03/03/2014	BMCE-TRANSMIT-019583	14/03/2014	24/03/2014	B	BMCE-TRANSMIT-019872 09/04/2014	
	03/03/2014	BMCE-TRANSMIT-019583	14/03/2014	24/03/2014	A	BMCE-TRANSMIT-019872 09/04/2014	
	03/03/2014	BMCE-TRANSMIT-019583	14/03/2014	24/03/2014	A	BMCE-TRANSMIT-019872 09/04/2014	
	03/03/2014	BMCE-TRANSMIT-019583	14/03/2014	24/03/2014	B	BMCE-TRANSMIT-019872 09/04/2014	
	03/03/2014	BMCE-TRANSMIT-019583	14/03/2014	24/03/2014	A	BMCE-TRANSMIT-019872 09/04/2014	
	03/03/2014	BMCE-TRANSMIT-019583	14/03/2014	24/03/2014	A	BMCE-TRANSMIT-019872 09/04/2014	
	03/03/2014	BMCE-TRANSMIT-019583	14/03/2014	24/03/2014	A	BMCE-TRANSMIT-019872 09/04/2014	
	03/03/2014	BMCE-TRANSMIT-019583	14/03/2014	24/03/2014	B	BMCE-TRANSMIT-019872 09/04/2014	
	03/03/2014	BMCE-TRANSMIT-019583	14/03/2014	24/03/2014	A	BMCE-TRANSMIT-019872 09/04/2014	
	03/03/2014	BMCE-TRANSMIT-019583	14/03/2014	24/03/2014	A	BMCE-TRANSMIT-019872 09/04/2014	

Brookfield Multiplex Europe

2nd Submission							OVERDUE
Planned Date to be Submitted to Board	Date Submitted to Board	BMCE Transmittal No	Date Response Required from Board (+2 Weeks)	Date Received from Board	Board Status	Date Returned to Consultant	OVERDUE
	03/03/2014	BMCE-TRANSMIT-019583	14/03/2014	24/03/2014	A	BMCE-TRANSMIT-019872 09/04/2014	
	03/03/2014	BMCE-TRANSMIT-019583	14/03/2014	24/03/2014	A	BMCE-TRANSMIT-019872 09/04/2014	
	03/03/2014	BMCE-TRANSMIT-019583	14/03/2014	24/03/2014	B	BMCE-TRANSMIT-019872 09/04/2014	
	03/03/2014	BMCE-TRANSMIT-019583	14/03/2014	24/03/2014	A	BMCE-TRANSMIT-019872 09/04/2014	
	03/03/2014	BMCE-TRANSMIT-019583	14/03/2014	24/03/2014	A	BMCE-TRANSMIT-019872 09/04/2014	
	03/03/2014	BMCE-TRANSMIT-019583	14/03/2014	24/03/2014	A	BMCE-TRANSMIT-019872 09/04/2014	
	03/03/2014	BMCE-TRANSMIT-019583	14/03/2014	24/03/2014	A	BMCE-TRANSMIT-019872 09/04/2014	
	03/03/2014	BMCE-TRANSMIT-019583	14/03/2014	24/03/2014	B	BMCE-TRANSMIT-019872 09/04/2014	
	03/03/2014	BMCE-TRANSMIT-019583	14/03/2014	24/03/2014	A	BMCE-TRANSMIT-019872 09/04/2014	
	03/03/2014	BMCE-TRANSMIT-019583	14/03/2014	24/03/2014	A	BMCE-TRANSMIT-019872 09/04/2014	
	03/03/2014	BMCE-TRANSMIT-019583	14/03/2014	24/03/2014	A	BMCE-TRANSMIT-019872 09/04/2014	
	03/03/2014	BMCE-TRANSMIT-019583	14/03/2014	24/03/2014	A	BMCE-TRANSMIT-019872 09/04/2014	
	03/03/2014	BMCE-TRANSMIT-019583	14/03/2014	24/03/2014	A	BMCE-TRANSMIT-019872 09/04/2014	
	03/03/2014	BMCE-TRANSMIT-019583	14/03/2014	24/03/2014	A	BMCE-TRANSMIT-019872 09/04/2014	
	03/03/2014	BMCE-TRANSMIT-019583	14/03/2014	24/03/2014	B	BMCE-TRANSMIT-019872 09/04/2014	
	03/03/2014	BMCE-TRANSMIT-019583	14/03/2014	24/03/2014	A	BMCE-TRANSMIT-019872 09/04/2014	
	03/03/2014	BMCE-TRANSMIT-019583	14/03/2014	24/03/2014	A	BMCE-TRANSMIT-019872 09/04/2014	
	03/03/2014	BMCE-TRANSMIT-019583	14/03/2014	24/03/2014	A	BMCE-TRANSMIT-019872 09/04/2014	
	03/03/2014	BMCE-TRANSMIT-019583	14/03/2014	24/03/2014	A	BMCE-TRANSMIT-019872 09/04/2014	
	03/03/2014	BMCE-TRANSMIT-019583	14/03/2014	24/03/2014	B	BMCE-TRANSMIT-019872 09/04/2014	
	03/03/2014	BMCE-TRANSMIT-019583	14/03/2014	24/03/2014	A	BMCE-TRANSMIT-019872 09/04/2014	
	03/03/2014	BMCE-TRANSMIT-019583	14/03/2014	24/03/2014	A	BMCE-TRANSMIT-019872 09/04/2014	
	03/03/2014	BMCE-TRANSMIT-019583	14/03/2014	24/03/2014	A	BMCE-TRANSMIT-019872 09/04/2014	
	03/03/2014	BMCE-TRANSMIT-019583	14/03/2014	24/03/2014	B	BMCE-TRANSMIT-019872 09/04/2014	
	03/03/2014	BMCE-TRANSMIT-019583	14/03/2014	24/03/2014	A	BMCE-TRANSMIT-019872 09/04/2014	
	03/03/2014	BMCE-TRANSMIT-019583	14/03/2014	24/03/2014	A	BMCE-TRANSMIT-019872 09/04/2014	
	03/03/2014	BMCE-TRANSMIT-019583	14/03/2014	24/03/2014	A	BMCE-TRANSMIT-019872 09/04/2014	
	03/03/2014	BMCE-TRANSMIT-019583	14/03/2014	24/03/2014	B	BMCE-TRANSMIT-019872 09/04/2014	
	03/03/2014	BMCE-TRANSMIT-019583	14/03/2014	24/03/2014	A	BMCE-TRANSMIT-019872 09/04/2014	

2nd Submission							OVERDUE
Planned Date to be Submitted to Board	Date Submitted to Board	BMCE Transmittal No	Date Response Required from Board (+2 Weeks)	Date Received from Board	Board Status	Date Returned to Consultant	OVERDUE
	03/03/2014	BMCE-TRANSMIT-019583	14/03/2014	24/03/2014	A	BMCE-TRANSMIT-019872 09/04/2014	
	03/03/2014	BMCE-TRANSMIT-019583	14/03/2014	24/03/2014	A	BMCE-TRANSMIT-019872 09/04/2014	
	03/03/2014	BMCE-TRANSMIT-019583	14/03/2014	24/03/2014	B	BMCE-TRANSMIT-019872 09/04/2014	
	03/03/2014	BMCE-TRANSMIT-019583	14/03/2014	24/03/2014	B	BMCE-TRANSMIT-019872 09/04/2014	
	03/03/2014	BMCE-TRANSMIT-019583	14/03/2014	24/03/2014	B	BMCE-TRANSMIT-019872 09/04/2014	
	03/03/2014	BMCE-TRANSMIT-019583	14/03/2014	24/03/2014	B	BMCE-TRANSMIT-019872 09/04/2014	
	03/03/2014	BMCE-TRANSMIT-019583	14/03/2014	24/03/2014	B	BMCE-TRANSMIT-019872 09/04/2014	
	03/03/2014	BMCE-TRANSMIT-019583	14/03/2014	24/03/2014	B	BMCE-TRANSMIT-019872 09/04/2014	
	03/03/2014	BMCE-TRANSMIT-019583	14/03/2014	24/03/2014	B	BMCE-TRANSMIT-019872 09/04/2014	
	03/03/2014	BMCE-TRANSMIT-019583	14/03/2014	24/03/2014	A	BMCE-TRANSMIT-019872 09/04/2014	
	03/03/2014	BMCE-TRANSMIT-019583	14/03/2014	24/03/2014	A	BMCE-TRANSMIT-019872 09/04/2014	
	03/03/2014	BMCE-TRANSMIT-019583	14/03/2014	24/03/2014	B	BMCE-TRANSMIT-019872 09/04/2014	
	03/03/2014	BMCE-TRANSMIT-019583	14/03/2014	24/03/2014	B	BMCE-TRANSMIT-019872 09/04/2014	
	03/03/2014	BMCE-TRANSMIT-019583	14/03/2014	24/03/2014	A	BMCE-TRANSMIT-019872 09/04/2014	
	03/03/2014	BMCE-TRANSMIT-019583	14/03/2014	24/03/2014	A	BMCE-TRANSMIT-019872 09/04/2014	
	03/03/2014	BMCE-TRANSMIT-019583	14/03/2014	24/03/2014	A	BMCE-TRANSMIT-019872 09/04/2014	
	03/03/2014	BMCE-TRANSMIT-019583	14/03/2014	24/03/2014	A	BMCE-TRANSMIT-019872 09/04/2014	
	03/03/2014	BMCE-TRANSMIT-019583	14/03/2014	24/03/2014	A	BMCE-TRANSMIT-019872 09/04/2014	
	03/03/2014	BMCE-TRANSMIT-019583	14/03/2014	24/03/2014	A	BMCE-TRANSMIT-019872 09/04/2014	

2nd Submission							OVERDUE
Planned Date to be Submitted to Board	Date Submitted to Board	BMCE Transmittal No	Date Response Required from Board (+2 Weeks)	Date Received from Board	Board Status	Date Returned to Consultant	OVERDUE

[illegible]

[illegible]

7 • External Finishes	77

BCLAC XX-SN 001			1st Submission														2nd Submission														Final Submission																																																																																																																																																																																																																																																																																																																																																																																																																																																																																																																																																																																																																																																																																																																																																																																																																																																																																																																																																																																																																																																																																																			
Item	Submission	Comments	Act on By	Drawing Number	Drawing Title	Date Required from Consultant	Date Submitted by Consultant	Document Revision	Planned Date to be Submitted to Board	Date Submitted to Board	Date Response Required from Board (3 Weeks)	Date Returned from Board	Board Status	Date returned to Consultant	Date Required from Consultant	Date Submitted by Consultant	Document Revision	Planned Date to be Submitted to Board	Date Submitted to Board	Date Response Required from Board (2 Weeks)	Date Received from Board	Board Status	Date Returned to Consultant	Date Required from Consultant	Date Submitted by Consultant	Document Revision	Planned Date to be Submitted to Board	Date Submitted to Board	Date Response Required from Board (2 Weeks)	Date Received from Board	Board Status	Date Returned to Consultant	Date Required from Consultant	Date Submitted by Consultant	Document Revision	Planned Date to be Submitted to Board	Date Submitted to Board	Date Response Required from Board (2 Weeks)	Date Received from Board	Board Status	Date Returned to Consultant	Date Required from Consultant	Date Submitted by Consultant	Document Revision	Planned Date to be Submitted to Board	Date Submitted to Board	Date Response Required from Board (2 Weeks)	Date Received from Board	Board Status	Date Returned to Consultant	Date Required from Consultant	Date Submitted by Consultant	Document Revision	Planned Date to be Submitted to Board	Date Submitted to Board	Date Response Required from Board (2 Weeks)	Date Received from Board	Board Status	Date Returned to Consultant	Date Required from Consultant	Date Submitted by Consultant	Document Revision	Planned Date to be Submitted to Board	Date Submitted to Board	Date Response Required from Board (2 Weeks)	Date Received from Board	Board Status	Date Returned to Consultant	Date Required from Consultant	Date Submitted by Consultant	Document Revision	Planned Date to be Submitted to Board	Date Submitted to Board	Date Response Required from Board (2 Weeks)	Date Received from Board	Board Status	Date Returned to Consultant	Date Required from Consultant	Date Submitted by Consultant	Document Revision	Planned Date to be Submitted to Board	Date Submitted to Board	Date Response Required from Board (2 Weeks)	Date Received from Board	Board Status	Date Returned to Consultant	Date Required from Consultant	Date Submitted by Consultant	Document Revision	Planned Date to be Submitted to Board	Date Submitted to Board	Date Response Required from Board (2 Weeks)	Date Received from Board	Board Status	Date Returned to Consultant	Date Required from Consultant	Date Submitted by Consultant	Document Revision	Planned Date to be Submitted to Board	Date Submitted to Board	Date Response Required from Board (2 Weeks)	Date Received from Board	Board Status	Date Returned to Consultant	Date Required from Consultant	Date Submitted by Consultant	Document Revision	Planned Date to be Submitted to Board	Date Submitted to Board	Date Response Required from Board (2 Weeks)	Date Received from Board	Board Status	Date Returned to Consultant	Date Required from Consultant	Date Submitted by Consultant	Document Revision	Planned Date to be Submitted to Board	Date Submitted to Board	Date Response Required from Board (2 Weeks)	Date Received from Board	Board Status	Date Returned to Consultant	Date Required from Consultant	Date Submitted by Consultant	Document Revision	Planned Date to be Submitted to Board	Date Submitted to Board	Date Response Required from Board (2 Weeks)	Date Received from Board	Board Status	Date Returned to Consultant	Date Required from Consultant	Date Submitted by Consultant	Document Revision	Planned Date to be Submitted to Board	Date Submitted to Board	Date Response Required from Board (2 Weeks)	Date Received from Board	Board Status	Date Returned to Consultant	Date Required from Consultant	Date Submitted by Consultant	Document Revision	Planned Date to be Submitted to Board	Date Submitted to Board	Date Response Required from Board (2 Weeks)	Date Received from Board	Board Status	Date Returned to Consultant	Date Required from Consultant	Date Submitted by Consultant	Document Revision	Planned Date to be Submitted to Board	Date Submitted to Board	Date Response Required from Board (2 Weeks)	Date Received from Board	Board Status	Date Returned to Consultant	Date Required from Consultant	Date Submitted by Consultant	Document Revision	Planned Date to be Submitted to Board	Date Submitted to Board	Date Response Required from Board (2 Weeks)	Date Received from Board	Board Status	Date Returned to Consultant	Date Required from Consultant	Date Submitted by Consultant	Document Revision	Planned Date to be Submitted to Board	Date Submitted to Board	Date Response Required from Board (2 Weeks)	Date Received from Board	Board Status	Date Returned to Consultant	Date Required from Consultant	Date Submitted by Consultant	Document Revision	Planned Date to be Submitted to Board	Date Submitted to Board	Date Response Required from Board (2 Weeks)	Date Received from Board	Board Status	Date Returned to Consultant	Date Required from Consultant	Date Submitted by Consultant	Document Revision	Planned Date to be Submitted to Board	Date Submitted to Board	Date Response Required from Board (2 Weeks)	Date Received from Board	Board Status	Date Returned to Consultant	Date Required from Consultant	Date Submitted by Consultant	Document Revision	Planned Date to be Submitted to Board	Date Submitted to Board	Date Response Required from Board (2 Weeks)	Date Received from Board	Board Status	Date Returned to Consultant	Date Required from Consultant	Date Submitted by Consultant	Document Revision	Planned Date to be Submitted to Board	Date Submitted to Board	Date Response Required from Board (2 Weeks)	Date Received from Board	Board Status	Date Returned to Consultant	Date Required from Consultant	Date Submitted by Consultant	Document Revision	Planned Date to be Submitted to Board	Date Submitted to Board	Date Response Required from Board (2 Weeks)	Date Received from Board	Board Status	Date Returned to Consultant	Date Required from Consultant	Date Submitted by Consultant	Document Revision	Planned Date to be Submitted to Board	Date Submitted to Board	Date Response Required from Board (2 Weeks)	Date Received from Board	Board Status	Date Returned to Consultant	Date Required from Consultant	Date Submitted by Consultant	Document Revision	Planned Date to be Submitted to Board	Date Submitted to Board	Date Response Required from Board (2 Weeks)	Date Received from Board	Board Status	Date Returned to Consultant	Date Required from Consultant	Date Submitted by Consultant	Document Revision	Planned Date to be Submitted to Board	Date Submitted to Board	Date Response Required from Board (2 Weeks)	Date Received from Board	Board Status	Date Returned to Consultant	Date Required from Consultant	Date Submitted by Consultant	Document Revision	Planned Date to be Submitted to Board	Date Submitted to Board	Date Response Required from Board (2 Weeks)	Date Received from Board	Board Status	Date Returned to Consultant	Date Required from Consultant	Date Submitted by Consultant	Document Revision	Planned Date to be Submitted to Board	Date Submitted to Board	Date Response Required from Board (2 Weeks)	Date Received from Board	Board Status	Date Returned to Consultant	Date Required from Consultant	Date Submitted by Consultant	Document Revision	Planned Date to be Submitted to Board	Date Submitted to Board	Date Response Required from Board (2 Weeks)	Date Received from Board	Board Status	Date Returned to Consultant	Date Required from Consultant	Date Submitted by Consultant	Document Revision	Planned Date to be Submitted to Board	Date Submitted to Board	Date Response Required from Board (2 Weeks)	Date Received from Board	Board Status	Date Returned to Consultant	Date Required from Consultant	Date Submitted by Consultant	Document Revision	Planned Date to be Submitted to Board	Date Submitted to Board	Date Response Required from Board (2 Weeks)	Date Received from Board	Board Status	Date Returned to Consultant	Date Required from Consultant	Date Submitted by Consultant	Document Revision	Planned Date to be Submitted to Board	Date Submitted to Board	Date Response Required from Board (2 Weeks)	Date Received from Board	Board Status	Date Returned to Consultant	Date Required from Consultant	Date Submitted by Consultant	Document Revision	Planned Date to be Submitted to Board	Date Submitted to Board	Date Response Required from Board (2 Weeks)	Date Received from Board	Board Status	Date Returned to Consultant	Date Required from Consultant	Date Submitted by Consultant	Document Revision	Planned Date to be Submitted to Board	Date Submitted to Board	Date Response Required from Board (2 Weeks)	Date Received from Board	Board Status	Date Returned to Consultant	Date Required from Consultant	Date Submitted by Consultant	Document Revision	Planned Date to be Submitted to Board	Date Submitted to Board	Date Response Required from Board (2 Weeks)	Date Received from Board	Board Status	Date Returned to Consultant	Date Required from Consultant	Date Submitted by Consultant	Document Revision	Planned Date to be Submitted to Board	Date Submitted to Board	Date Response Required from Board (2 Weeks)	Date Received from Board	Board Status	Date Returned to Consultant	Date Required from Consultant	Date Submitted by Consultant	Document Revision	Planned Date to be Submitted to Board	Date Submitted to Board	Date Response Required from Board (2 Weeks)	Date Received from Board	Board Status	Date Returned to Consultant	Date Required from Consultant	Date Submitted by Consultant	Document Revision	Planned Date to be Submitted to Board	Date Submitted to Board	Date Response Required from Board (2 Weeks)	Date Received from Board	Board Status	Date Returned to Consultant	Date Required from Consultant	Date Submitted by Consultant	Document Revision	Planned Date to be Submitted to Board	Date Submitted to Board	Date Response Required from Board (2 Weeks)	Date Received from Board	Board Status	Date Returned to Consultant	Date Required from Consultant	Date Submitted by Consultant	Document Revision	Planned Date to be Submitted to Board	Date Submitted to Board	Date Response Required from Board (2 Weeks)	Date Received from Board	Board Status	Date Returned to Consultant	Date Required from Consultant	Date Submitted by Consultant	Document Revision	Planned Date to be Submitted to Board	Date Submitted to Board	Date Response Required from Board (2 Weeks)	Date Received from Board	Board Status	Date Returned to Consultant	Date Required from Consultant	Date Submitted by Consultant	Document Revision	Planned Date to be Submitted to Board	Date Submitted to Board	Date Response Required from Board (2 Weeks)	Date Received from Board	Board Status	Date Returned to Consultant	Date Required from Consultant	Date Submitted by Consultant	Document Revision	Planned Date to be Submitted to Board	Date Submitted to Board	Date Response Required from Board (2 Weeks)	Date Received from Board	Board Status	Date Returned to Consultant	Date Required from Consultant	Date Submitted by Consultant	Document Revision	Planned Date to be Submitted to Board	Date Submitted to Board	Date Response Required from Board (2 Weeks)	Date Received from Board	Board Status	Date Returned to Consultant	Date Required from Consultant	Date Submitted by Consultant	Document Revision	Planned Date to be Submitted to Board	Date Submitted to Board	Date Response Required from Board (2 Weeks)	Date Received from Board	Board Status	Date Returned to Consultant	Date Required from Consultant	Date Submitted by Consultant	Document Revision	Planned Date to be Submitted to Board	Date Submitted to Board	Date Response Required from Board (2 Weeks)	Date Received from Board	Board Status	Date Returned to Consultant	Date Required from Consultant	Date Submitted by Consultant	Document Revision	Planned Date to be Submitted to Board	Date Submitted to Board	Date Response Required from Board (2 Weeks)	Date Received from Board	Board Status	Date Returned to Consultant	Date Required from Consultant	Date Submitted by Consultant	Document Revision	Planned Date to be Submitted to Board	Date Submitted to Board	Date Response Required from Board (2 Weeks)	Date Received from Board	Board Status	Date Returned to Consultant	Date Required from Consultant	Date Submitted by Consultant	Document Revision	Planned Date to be Submitted to Board	Date Submitted to Board	Date Response Required from Board (2 Weeks)	Date Received from Board	Board Status	Date Returned to Consultant	Date Required from Consultant	Date Submitted by Consultant	Document Revision	Planned Date to be Submitted to Board	Date Submitted to Board	Date Response Required from Board (2 Weeks)	Date Received from Board	Board Status	Date Returned to Consultant	Date Required from Consultant	Date Submitted by Consultant	Document Revision	Planned Date to be Submitted to Board	Date Submitted to Board	Date Response Required from Board (2 Weeks)	Date Received from Board	Board Status	Date Returned to Consultant	Date Required from Consultant	Date Submitted by Consultant	Document Revision	Planned Date to be Submitted to Board	Date Submitted to Board	Date Response Required from Board (2 Weeks)	Date Received from Board	Board Status	Date Returned to Consultant	Date Required from Consultant	Date Submitted by Consultant	Document Revision	Planned Date to be Submitted to Board	Date Submitted to Board	Date Response Required from Board (2 Weeks)	Date Received from Board	Board Status	Date Returned to Consultant	Date Required from Consultant	Date Submitted by Consultant	Document Revision	Planned Date to be Submitted to Board	Date Submitted to Board	Date Response Required from Board (2 Weeks)	Date Received from Board	Board Status	Date Returned to Consultant	Date Required from Consultant	Date Submitted by Consultant	Document Revision	Planned Date to be Submitted to Board	Date Submitted to Board	Date Response Required from Board (2 Weeks)	Date Received from Board	Board Status	Date Returned to Consultant	Date Required from Consultant	Date Submitted by Consultant	Document Revision	Planned Date to be Submitted to Board	Date Submitted to Board	Date Response Required from Board (2 Weeks)	Date Received from Board	Board Status	Date Returned to Consultant	Date Required from Consultant	Date Submitted by Consultant	Document Revision	Planned Date to be Submitted to Board	Date Submitted to Board	Date Response Required from Board (2 Weeks)	Date Received from Board	Board Status	Date Returned to Consultant	Date Required from Consultant	Date Submitted by Consultant	Document Revision	Planned Date to be Submitted to Board	Date Submitted to Board	Date Response Required from Board (2 Weeks)	Date Received from Board	Board Status	Date Returned to Consultant	Date Required from Consultant	Date Submitted by Consultant	Document Revision	Planned Date to be Submitted to Board	Date Submitted to Board	Date Response Required from Board (2 Weeks)	Date Received from Board	Board Status	Date Returned to Consultant	Date Required from Consultant	Date Submitted by Consultant	Document Revision	Planned Date to be Submitted to Board	Date Submitted to Board	Date Response Required from Board (2 Weeks)	Date Received from Board	Board Status	Date Returned to Consultant	Date Required from Consultant	Date Submitted by Consultant	Document Revision	Planned Date to be Submitted to Board	Date Submitted to Board	Date Response Required from Board (2 Weeks)	Date Received from Board	Board Status	Date Returned to Consultant	Date Required from Consultant	Date Submitted by Consultant	Document Revision	Planned Date to be Submitted to Board	Date Submitted to Board	Date Response Required from Board (2 Weeks)	Date Received from Board	Board Status	Date Returned to Consultant	Date Required from Consultant	Date Submitted by Consultant	Document Revision	Planned Date to be Submitted to Board	Date Submitted to Board	Date Response Required from Board (2 Weeks)	Date Received from Board	Board Status	Date Returned to Consultant	Date Required from Consultant	Date Submitted by Consultant	Document Revision	Planned Date to be Submitted to Board	Date Submitted to Board	Date Response Required from Board (2 Weeks)	Date Received from Board	Board Status	Date Returned to Consultant	Date Required from Consultant	Date Submitted by Consultant	Document Revision	Planned Date to be Submitted to Board	Date Submitted to Board	Date Response Required from Board (2 Weeks)	Date Received from Board	Board Status	Date Returned to Consultant	Date Required from Consultant	Date Submitted by Consultant	Document Revision	Planned Date to be Submitted to Board	Date Submitted to Board	Date Response Required from Board (2 Weeks)	Date Received from Board	Board Status	Date Returned to Consultant	Date Required from Consultant	Date Submitted by Consultant	Document Revision	Planned Date to be Submitted to Board	Date Submitted to Board	Date Response Required from Board (2 Weeks)	Date Received from Board	Board Status	Date Returned to Consultant	Date Required from Consultant	Date Submitted by Consultant	Document Revision	Planned Date to be Submitted to Board	Date Submitted to Board	Date Response Required from Board (2 Weeks)	Date Received from Board	Board Status	Date Returned to Consultant	Date Required from Consultant	Date Submitted by Consultant	Document Revision	Planned Date to be Submitted to Board	Date Submitted to Board	Date Response Required from Board (2 Weeks)	Date Received from Board	Board Status	Date Returned to Consultant	Date Required from Consultant	Date Submitted by Consultant	Document Revision	Planned Date to be Submitted to Board	Date Submitted to Board	Date Response Required from Board (2 Weeks)	Date Received from Board	Board Status	Date Returned to Consultant	Date Required from Consultant	Date Submitted by Consultant	Document Revision	Planned Date to be Submitted to Board	Date Submitted to Board	Date Response Required from Board (2 Weeks)	Date Received from Board	Board Status	Date Returned to Consultant	Date Required from Consultant	Date Submitted by Consultant	Document Revision	Planned Date to be Submitted to Board	Date Submitted to Board	Date Response Required from Board (2 Weeks)	Date Received from Board	Board Status	Date Returned to Consultant	Date Required from Consultant	Date Submitted by Consultant	Document Revision	Planned Date to be Submitted to Board	Date Submitted to Board	Date Response Required from Board (2 Weeks)	Date Received from Board	Board Status	Date Returned to Consultant	Date Required from Consultant	Date Submitted by Consultant	Document Revision	Planned Date to be Submitted to Board	Date Submitted to Board	Date Response Required from Board (2 Weeks)	Date Received from Board	Board Status	Date Returned to Consultant	Date Required from Consultant	Date Submitted by Consultant	Document Revision	Planned Date to be Submitted to Board	Date Submitted to Board	Date Response Required from Board (2 Weeks)	Date Received from Board	Board Status	Date Returned to Consultant	Date Required from Consultant	Date Submitted by Consultant	Document Revision	Planned Date to be Submitted to Board	Date Submitted to Board	Date Response Required from Board (2 Weeks)	Date Received from Board	Board Status	Date Returned to Consultant	Date Required from Consultant	Date Submitted by Consultant	Document Revision	Planned Date to be Submitted to Board	Date Submitted to Board	Date Response Required from Board (2 Weeks)	Date Received from Board	Board Status	Date Returned to Consultant	Date Required from Consultant	Date Submitted by Consultant	Document Revision	Planned Date to be Submitted to Board	Date Submitted to Board	Date Response Required from Board (2 Weeks)	Date Received from Board	Board Status	Date Returned to Consultant	Date Required from Consultant	Date Submitted by Consultant	Document Revision	Planned Date to be Submitted to Board	Date Submitted to Board	Date Response Required from Board (2 Weeks)	Date Received from Board	Board Status	Date Returned to Consultant	Date Required from Consultant	Date Submitted by Consultant	Document Revision	Planned Date to be Submitted to Board	Date Submitted to Board	Date Response Required from Board (2 Weeks)	Date Received from Board	Board Status	Date Returned to Consultant	Date Required from Consultant	Date Submitted by Consultant	Document Revision	Planned Date to be Submitted to Board	Date Submitted to Board	Date Response Required from Board (2 Weeks)	Date Received from Board	Board Status	Date Returned to Consultant	Date Required from Consultant	Date Submitted by Consultant	Document Revision	Planned Date to be Submitted to Board	Date Submitted to Board	Date Response Required from Board (2 Weeks)	Date Received from Board	Board Status	Date Returned to Consultant	Date Required from Consultant	Date Submitted by Consultant	Document Revision	Planned Date to be Submitted to Board	Date Submitted to Board	Date Response Required from Board (2 Weeks)	Date Received from Board	Board Status	Date Returned to Consultant	Date Required from Consultant	Date Submitted by Consultant	Document Revision	Planned Date to be Submitted to Board	Date Submitted to Board	Date Response Required from Board (2 Weeks)	Date Received from Board	Board Status	Date Returned to Consultant	Date Required from Consultant	Date Submitted by Consultant	Document Revision	Planned Date to be Submitted to Board	Date Submitted to Board	Date Response Required from Board (2 Weeks)	Date Received from Board	Board Status	Date Returned to Consultant	Date Required from Consultant	Date Submitted by Consultant	Document Revision	Planned Date to be Submitted to Board	Date Submitted to Board	Date Response Required from Board (2 Weeks)	Date Received from Board	Board Status	Date Returned to Consultant	Date Required from Consultant	Date Submitted by Consultant	Document Revision	Planned Date to be Submitted to Board	Date Submitted to Board	Date Response Required from Board (2 Weeks)	Date Received from Board	Board Status	Date Returned to Consultant	Date Required from Consultant	Date Submitted by Consultant	Document Revision	Planned Date to be Submitted to Board	Date Submitted to Board	Date Response Required from Board (2 Weeks)	Date Received from Board	Board Status	Date Returned to Consultant	Date Required from Consultant	Date Submitted by Consultant	Document Revision	Planned Date to be Submitted to Board	Date Submitted to Board	Date Response Required from Board (2 Weeks)	Date Received from Board	Board Status	Date Returned to Consultant	Date Required from Consultant	Date Submitted by Consultant	Document Revision	Planned Date to be Submitted to Board	Date Submitted to Board	Date Response Required from Board (2 Weeks)	Date Received from Board	Board Status	Date Returned to Consultant	Date Required from Consultant	Date Submitted by Consultant	Document Revision	Planned Date to be Submitted to Board	Date Submitted to Board	Date Response Required from Board (2 Weeks)	Date Received from Board	Board Status	Date Returned to Consultant	Date Required from Consultant	Date Submitted by Consultant	Document Revision	Planned Date to be Submitted to Board	Date Submitted to Board	Date Response Required from Board (2 Weeks)	Date Received from Board	Board Status	Date Returned to Consultant	Date Required from Consultant	Date Submitted by Consultant	Document Revision	Planned Date to be Submitted to Board	Date Submitted to Board	Date Response Required from Board (2 Weeks)	Date Received from Board	Board Status	Date Returned to Consultant	Date Required from Consultant	Date Submitted by Consultant	Document Revision	Planned Date to be Submitted to Board	Date Submitted to Board	Date Response Required from Board (2 Weeks)	Date Received from Board	Board Status	Date Returned to Consultant	Date Required from Consultant	Date Submitted by Consultant	Document Revision	Planned Date to be Submitted to Board	Date Submitted to Board	Date Response Required from Board (2 Weeks)	Date Received from Board	Board Status	Date Returned to Consultant	Date Required from Consultant	Date Submitted by Consultant	Document Revision	Planned Date to be Submitted to Board	Date Submitted to Board	Date Response Required from Board (2 Weeks)	Date Received from Board	Board Status	Date Returned to Consultant	Date Required from Consultant	Date Submitted by Consultant	Document Revision	Planned Date to be Submitted to Board	Date Submitted to Board	Date Response Required from Board (2 Weeks)	Date Received from Board	Board Status	Date Returned to Consultant	Date Required from Consultant	Date Submitted by Consultant	Document Revision	Planned Date to be Submitted to Board	Date Submitted to Board	Date Response Required from Board (2 Weeks)	Date Received from Board	Board Status	Date Returned to Consultant	Date Required from Consultant	Date Submitted by Consultant	Document Revision	Planned Date to be Submitted to Board	Date Submitted to Board	Date Response Required from Board (2 Weeks)	Date Received from Board	Board Status	Date Returned to Consultant	Date Required from Consultant	Date Submitted by Consultant	Document Revision	Planned Date to be Submitted to Board	Date Submitted to Board	Date Response Required from Board (2 Weeks)	Date Received from Board	Board Status	Date Returned to Consultant	Date Required from Consultant	Date Submitted by Consultant	Document Revision	Planned Date to be Submitted to Board	Date Submitted to Board	Date Response Required from Board (2 Weeks)	Date Received from Board	Board Status	Date Returned to Consultant	Date Required from Consultant	Date Submitted by Consultant	Document Revision	Planned Date to be Submitted to Board	Date Submitted to Board	Date Response Required from Board (2 Weeks)	Date Received from Board	Board Status	Date Returned to Consultant	Date Required from Consultant	Date Submitted by Consultant	Document Revision	Planned Date to be Submitted to Board	Date Submitted to Board	Date Response Required from Board (2 Weeks)	Date Received from Board	Board Status	Date Returned to Consultant	Date Required from Consultant	Date Submitted by Consultant	Document Revision	Planned Date to be Submitted to Board	Date Submitted to Board	Date Response Required from Board (2 Weeks)	Date Received from Board	Board Status	Date Returned to Consultant	Date Required from Consultant	Date Submitted by Consultant	Document Revision	Planned Date to be Submitted to Board	Date Submitted to Board	Date Response Required from Board (2 Weeks)	Date Received from Board	Board Status	Date Returned to Consultant	Date Required from Consultant	Date Submitted by Consultant	Document Revision	Planned Date to be Submitted to Board	Date Submitted to Board	Date Response Required from Board (2 Weeks)	Date Received from Board	Board Status	Date Returned to Consultant	Date Required from Consultant	Date Submitted by Consultant	Document Revision	Planned Date to be Submitted to Board	Date Submitted to Board	Date Response Required from Board (2 Weeks)	Date Received from Board	Board Status	Date Returned to Consultant	Date Required from Consultant	Date Submitted by Consultant	Document Revision	Planned Date to be Submitted to Board	Date Submitted to Board	Date Response Required from Board (2 Weeks)	Date Received from Board	Board Status	Date Returned to Consultant	Date Required from Consultant	Date Submitted by Consultant	Document Revision	Planned Date to be Submitted to Board	Date Submitted to Board	Date Response Required from Board (2 Weeks)	Date Received from Board	Board Status	Date Returned to Consultant	Date Required from Consultant	Date Submitted by Consultant	Document Revision	Planned Date to be Submitted to Board	Date Submitted to Board	Date Response Required from Board (2 Weeks)	Date Received from Board	Board Status	Date Returned to Consultant	Date Required from Consultant	Date Submitted by Consultant	Document Revision	Planned Date to be Submitted to Board	Date Submitted to Board	Date Response Required from Board (2 Weeks)	Date Received from Board	Board Status	Date Returned to Consultant	Date Required from Consultant	Date Submitted by Consultant	Document Revision	Planned Date to be Submitted to Board	Date Submitted to Board	Date Response Required from Board (2 Weeks)	Date Received from Board	Board Status	Date Returned to Consultant	Date Required from Consultant	Date Submitted by Consultant	Document Revision	Planned Date to be Submitted to Board	Date Submitted to Board	Date Response Required from Board (2 Weeks)	Date Received from Board	Board Status	Date Returned to Consultant	Date Required from Consultant	Date Submitted by Consultant	Document Revision	Planned Date to be Submitted to Board	Date Submitted to Board	Date Response Required from Board (2 Weeks)	Date Received from Board	Board Status	Date Returned to Consultant	Date Required from Consultant	Date Submitted by Consultant	Document Revision	Planned Date to be Submitted to Board	Date Submitted to Board	Date Response Required from Board (2 Weeks)	Date Received from Board	Board Status	Date Returned to Consultant	Date Required from Consultant	Date Submitted by Consultant	Document Revision	Planned Date to be Submitted to Board	Date Submitted to Board	Date Response Required from Board (2 Weeks)	Date Received from Board	Board Status	Date Returned to Consultant	Date Required from Consultant	Date Submitted by Consultant	Document Revision	Planned Date to be Submitted to Board	Date Submitted to Board	Date Response Required from Board (2 Weeks)	Date Received from Board	Board Status	Date Returned to Consultant	Date Required from Consultant	Date Submitted by Consultant	Document Revision	Planned Date to be Submitted to Board	Date Submitted to Board	Date Response Required from Board (2 Weeks)	Date Received from Board	Board Status	Date Returned to Consultant	Date Required from Consultant	Date Submitted by Consultant	Document Revision	Planned Date to be Submitted to Board	Date Submitted to Board	Date Response Required from Board (2 Weeks)	Date Received from Board	Board Status	Date Returned to Consultant	Date Required from Consultant	Date Submitted by Consultant	Document Revision	Planned Date to be Submitted to Board	Date Submitted to Board

ROD MASTER SCHEDULE - NHS Greater Glasgow & Clyde / New South Glasgow Hospitals (NSGH) Project - Adults & Childrens Hospital										Brookfield Multiplex Europe																																					
BCLAC XX-SN 001																																															
						1st Submission										2nd Submission										Final Submission										Final Submission											
Act on By	Drawing Number	Drawing Title	Date Required from Consultant	Date Submitted by Consultant	Document Revision	Planned Date to be Submitted to Board	Date Submitted to Board	Date Response Required from Board (3 Weeks)	Date Returned from Board	Board Status	Date returned to Consultant	Date Required from Consultant	Date Submitted by Consultant	Document Revision	Planned Date to be Submitted to Board	Date Submitted to Board	Date Response Required from Board (2 Weeks)	Date Received from Board	Board Status	Date Returned to Consultant	Date Required from Consultant	Date Submitted by Consultant	Document Revision	Planned Date to be Submitted to Board	Date Submitted to Board	Date Response Required from Board (2 Weeks)	Date Received from Board	Board Status	Date Returned to Consultant	Date Required from Consultant	Date Submitted by Consultant	Document Revision	Planned Date to be Submitted to Board	Date Submitted to Board	Date Response Required from Board (2 Weeks)	Date Received from Board	Board Status	Date Returned to Consultant									
Item	Submission	Comments																																													
			NA	NA SK-251-001			02/03/2012	2																																							
			NA	NA XX-14-SK-251-013	Locations of the load Equipment & PPE store		02/03/2012	1																																							
			NA	NA ZE-XX-AS-240-102	Helipad 3x150 ramp		02/03/2012	2																																							
					Helipad / Core G Cladding Details																																										
			NA	NA EC-XX-EL-251-110	Energy Centre Fastenings		18/04/2012	1			BMCE-TRANSMIT-000423-1000-110	08/03/2012	18/04/2012	A																																	
			NA	NA EC-XX-SE-251-208	Energy Centre External Wall Vertical Section Entrance Gate		03/07/2012	1			BMCE-TRANSMIT-000423-1000-110	08/03/2012	20/07/2012	B																																	
			NA	NA XX-12-AS-200-150	Twelfth Floor Plant Room - BMU Track & Temporary Glass Replacement Cradle Sections						App K Date		App K Status		11/09/2011																																
			NA	NA XX-12-AS-200-151	Twelfth Floor Plant Room - BMU Track						App K Date		App K Status		11/09/2011																																
			NA	NA XX-13-AS-200-150	Thirteenth Floor Plant Room - Core G BMU monorail						new drawing				11/09/2011																																

7 - External Finishes

8 - Hard Landscaping

8 - Hard Landscaping			1st Submission												2nd Submission																	
Item	Submitted on	Comments	Action By	Drawing Number	Drawing Title	Date Required from Consultant	Date Submitted by Consultant	Document Revision	Planned Date to be Submitted to Board	Date Submitted to Board	Date Response Required from Board (3 Weeks)	Date Returned from Board	Board Status	Date returned to Consultant	Date Required from Consultant	Date Submitted by Consultant	Document Revision	Planned Date to be Submitted to Board	Date Submitted to Board	Date Response Required from Board (2 Weeks)	Date Received from Board	Board Status	Date Returned Consultant	Date Required from Consultant	Date Submitted by Consultant	Document Revision	Planned Date to be Submitted to Board	Date Submitted to Board	Date Response Required from Board (2 Weeks)	Date Received from Board	Board Status	
				G L-EW XX SE-710 102	De a l Road Cross Sec ion KK	tdc			tdc																							
				G L-EW XX SE-710 110	Ch drens s Park Sec ions LL & MM	tdc			tdc																							
				G L-EW XX SE-710 111	Ch iden's Park Sections NN, OO & PP	tdc			tdc																							
				G L-EW XX SE-710 112	Central Park Sections QQ & RR	tdc			tdc																							
				G L-EW XX PL 711 120	Courtyard 1 P an and Section	tdc		5	14.02.12	BMCE-TRANSMIT-009219 30/07/12	03/04/2012	13/06/2012	B	BMCE-TRANSMIT-009204 21/06/12	02/07/2012 16/10/2012	6	8		BMCE-TRANSMIT-009633 02/07/12 BMCE-TRANSMIT-011684 18/10/2012	23/07/2012 06/11/2012	25/07/2012 18/10/2012	A B	BMCE-TRANSMIT-010089 30/07/2012 BMCE-TRANSMIT-011745 19/10/2012									
				G L-EW XX PL 711 121	Courtyard 2 and 3 Plan and Sect on		02/07/12	5		BMCE-TRANSMIT-009633 02/07/12	23/07/2012	25/07/2012	A	BMCE-TRANSMIT-010089 30/07/2012	16/10/2012	7			BMCE-TRANSMIT-011684 18/10/2012	06/11/2012	18/10/2012	B	BMCE-TRANSMIT-011745 19/10/2012									
				G L-EW XX PL 711 122	Courtyard 4 and 5 Plan and Sect on		02/07/12	5		BMCE-TRANSMIT-009633 02/07/12	23/07/2012	25/07/2012	A	BMCE-TRANSMIT-010089 30/07/2012	16/10/2012	7			BMCE-TRANSMIT-011684 18/10/2012	06/11/2012	18/10/2012	B	BMCE-TRANSMIT-011745 19/10/2012									
				G L-EW XX PL 711 123	Courtyard 6 and 7 Plan and Sect on		02/07/12	5		BMCE-TRANSMIT-009633 02/07/12	23/07/2012	25/07/2012	B	BMCE-TRANSMIT-010089 30/07/2012	16/10/2012	7			BMCE-TRANSMIT-011684 18/10/2012	06/11/2012	18/10/2012	A	BMCE-TRANSMIT-011745 19/10/2012									
				G L-EW XX PL 711 124	Courtyard 8 and 9 Plan and Sect on		02/07/12	5		BMCE-TRANSMIT-009633 02/07/12	23/07/2012	25/07/2012	B	BMCE-TRANSMIT-010089 30/07/2012	16/10/2012	7			BMCE-TRANSMIT-011684 18/10/2012	06/11/2012	18/10/2012	B	BMCE-TRANSMIT-011745 19/10/2012									
				G L-EW XX PL 711 125	Courtyard 10 Plan and Sect on		02/07/12	5		BMCE-TRANSMIT-009633 02/07/12	23/07/2012	25/07/2012	C	BMCE-TRANSMIT-010089 30/07/2012	16/10/2012	7			BMCE-TRANSMIT-011684 18/10/2012	06/11/2012	18/10/2012	A	BMCE-TRANSMIT-011745 19/10/2012	11/02/2014	A		BMCE-TRANSMIT-015463 18/02/2014	04/02/2014	24/02/2014	A		
				G L-EW XX PL 711 126	Courtyard 11 Plan and Sect on		02/07/12	5		BMCE-TRANSMIT-009633 02/07/12	23/07/2012	25/07/2012	A	BMCE-TRANSMIT-010089 30/07/2012	16/10/2012	5			BMCE-TRANSMIT-011684 18/10/2012	06/11/2012	18/10/2012	A	BMCE-TRANSMIT-011745 19/10/2012									
				G L-EW XX PL 711 130	DCFP Ch drens a Roof Garden P an Section AA	04/12/12	08/01/13	8		BMCE-TRANSMIT-010241 10/07/2013	31/01/2013	16/01/2013	C	BMCE-TRANSMIT-010306 12/02/2013																		
				G L-EW XX PL 711 131	Ch drens Roof Garden- Sec ions BB & CC	tdc			tdc																							
				G L-EW XX PL 711 132	Childrens Roof Garden- Sect ons DD & EE	tdc			tdc																							
				G L-EW XX PL 711 133	DCFP Ch ld ens Roof Garden P an and Sections	tdc	04/07/12	5	tdc	BMCE-TRANSMIT-009637 14/09/2013	25/07/2011	08/11/2012	B	BMCE-TRANSMIT-012268 22/11/2012																		
				G L-EW XX PL 711 134	Biodiverse roof plan		30/07/12	3		BMCE-TRANSMIT-010081 31/07/2013	21/08/2012	26/10/2012	B	BMCE-TRANSMIT-011063 31/10/2012	03/12/2012	4			BMCE-TRANSMIT-012815 06/12/2012	03/01/2013	12/12/2012	A	BMCE-TRANSMIT-012935 17/12/2012									
				G L-EW XX PL 711 138	DCFP - Ch ld en's Roof Garden Plan: Setting Out & Detail Locations		22/10/13	A		BMCE-TRANSMIT-010441 11/11/2013	13/01/1960	19/11/2013	A	BMCE-TRANSMIT-010577 22/11/2013																		
				GIL EW-XX DC-700-300	DCFP, Courtyards, Roof Garden		04/04/12	0		BMCE-TRANSMIT-008509 24/04/12	15/05/2012	13/06/2012	B	BMCE-TRANSMIT-009409 21/06/12																		
				GIL EW-XX DC-700-301	Arrival Space & Central Car Park		10/04/12	0		BMCE-TRANSMIT-008509 24/04/12	15/05/2012	13/06/2012	B	BMCE-TRANSMIT-009409 21/06/12																		
				GIL EW-XX DC-700-302	Childrens Car Park A & A & E		24/04/12	0		BMCE-TRANSMIT-008509 24/04/12	15/05/2012	13/06/2012	B	BMCE-TRANSMIT-009401 21/06/12																		
				GIL EW-XX DC-700-303	DCFP, Courtyards, Roof Garden		02/07/12	0		BMCE-TRANSMIT-009633 02/07/12	23/07/2012	08/11/2012	B	BMCE-TRANSMIT-012267 13/11/2012																		
				GIL EW-XX DC-700-300	Maintenance Hierarchy P an		28/03/12	0		BMCE-TRANSMIT-008278 04/04/2013	25/04/2012	18/10/2012	B	BMCE-TRANSMIT-011021 24/10/2012																		
				G L-EW XX PL 700 600	Arrival Space - Setting Out Plan	tdc			N/A																							
				G L-EW XX PL 700 601	Cent al Park - Set ing Out Plan	tdc			N/A																							
				G L-EW XX PL 700 602	Central Park Link Road - Set ing Out Plan	tdc			N/A																							
				G L-EW XX PL 700 603	Ch drens Park - Setting Out P an	tdc			N/A																							
				G L-EW XX PL 700 604	Entrance Boulevard - Setting Out Plan	tdc			N/A																							
				G L-EW XX PL 700 605	Ch drens A&E Entrance - Setting Out Plan	tdc			N/A																							
				G L-EW XX PL 700 606	Adu ts A&E Entrance - Set ing Out Plan	tdc			N/A																							
				G L-EW XX PL 700 607	Blue Light Road and Discharge Lounge - Setting Out Plan	tdc			N/A																							
				G L-EW XX PL 700 608	Cycle and Pedestr an Path - Se ing Out Plan	tdc			N/A																							
				G L-EW XX DT-720 100	P1 Granite paving type one	04/12/12	22/11/12	3	tdc	BMCE-RANSMI-013238 10/01/2013	31/01/2013	04/02/2013	A	BMCE-TRANSMIT-013086 12/02/2013																		
				G L-EW XX DT-720 101	P2 Exposed aggregate conc etc paving s abs	04/12/12	22/11/12	E	tdc	BMCE-RANSMI-013238 10/01/2013	31/01/2013	04/02/2013	B	BMCE-TRANSMIT-013086 12/02/2013																		
				G L-EW XX DT-720 102	P3 Coloured aspha t	04/12/12	22/11/12	3	tdc	BMCE-RANSMI-013238 10/01/2013	31/01/2013	04/02/2013	A	BMCE-TRANSMIT-013086 12/02/2013																		
				G L-EW XX DT-720 103	P5 Natural aggregate fin shed surface		23/07/12	3	27.07.12	BMCE-TRANSMIT-009961 23/07/2013	13/08/2012	25/07/2012	A	BMCE-TRANSMIT-010089 30/07/2012	04/12/12	22/11/12	4	tdc	BMCE-RANSMI-013238 10/01/2013	31/01/2013	04/02/2013	B	BMCE-TRANSMIT-013086 12/02/2013									
				G L-EW XX DT-720 104	P6 Self binding gravel	04/12/12	22/11/12	3	tdc	BMCE-RANSMI-013238 10/01/2013	31/01/2013	04/02/2013	A	BMCE-TRANSMIT-013086 12/02/2013																		
				G L-EW XX DT-720 105	P7 Pea g avel	04/12/12	22/11/12	3	tdc	BMCE-RANSMI-013238 10/01/2013	31/01/2013	04/02/2013	A	BMCE-TRANSMIT-013086 12/02/2013																		

ROO MASTER SCHEDULE - NHS Greater Glasgow & Clyde / New South Glasgow Hospitals (NSGH) Project - Adults & Children Hospital

8Hard Landscaping

			1st Submission											2nd Submission																	
			Action By	Drawing Number	Drawing Title	Date Required from Consultant	Date Submitted by Consultant	Document Revision	Planned Date to be Submitted to Board	Date Submitted to Board	Date Response Required from Board (3 Weeks)	Date Returned from Board	Board Status	Date returned to Consultant	Date Required from Consultant	Date Submitted by Consultant	Document Revision	Planned Date to be Submitted to Board	Date Submitted to Board	Date Response Required from Board (2 Weeks)	Date Received from Board	Board Status	Date Returned to Consultant	Date Required from Consultant	Date Submitted by Consultant	Document Revision	Planned Date to be Submitted to Board	Date Submitted to Board	Date Response Required from Board (2 Weeks)	Date Received from Board	Board Status
Item	Submitted on	Comments																													
				G L-EW XX 01-720 111	E1Aluminium edging 4mm	04/12/12	23/07/12	3	27.07.12	BMCE-TRANSMIT-009961 23/07/2012	13/08/2012	25/07/2012	A	BMCE-TRANSMIT-010069 30/07/2012	04/12/12	22/11/12	4	0cc	BMCE-RANSMB-013238 10/01/2013	31/01/2013	04/02/2013	B	BMCE-TRANSMIT-013896 12/02/2013								
				G L-EW XX 01-720 112	E2 Concrete Pin Kerb	04/12/12	23/07/12	C	27.07.12	BMCE-TRANSMIT-009961 23/07/2012	13/08/2012	25/07/2012	A	BMCE-TRANSMIT-010069 30/07/2012	04/12/12	22/11/12	D	0cc	BMCE-RANSMB-013238 10/01/2013	31/01/2013	04/02/2013	A	BMCE-TRANSMIT-013896 12/02/2013								
				G L-EW XX 01-720 113	E3 Aluminium Flat top profile 5mm	04/12/12	22/11/12	3	0cc	BMCE-RANSMB-013238 10/01/2013	31/01/2013	04/02/2013	A	BMCE-TRANSMIT-013896 12/02/2013																	
				G L-EW XX 01-720 114	K1 300mm wide Countryside Concrete Kerb	04/12/12	22/11/12	C	0cc	BMCE-RANSMB-013238 10/01/2013	31/01/2013	04/02/2013	A	BMCE-TRANSMIT-013896 12/02/2013																	

R00 MASTER SCHEDULE - NHS Greater Glasgow & Clyde / New South Glasgow Hospitals (NSGH) Project - Addn to & Chn drngs Hospital			Brookfield																																		
Hard Landscaping			1st Submission												2nd Submission																						
			Action By	Drawing Number	Drawing Title	Date Required from Consultant	Date Submitted by Consultant	Document Revision	Planned Date to be Submitted to Board	Date Submitted to Board	Date Response Required from Board (3 Weeks)	Date Returned from Board	Board Status	Date returned to Consultant	Date Required from Consultant	Date Submitted by Consultant	Document Revision	Planned Date to be Submitted to Board	Date Submitted to Board	Date Response Required from Board (2 Weeks)	Date Received from Board	Board Status	Date Returned to Consultant	Date Required from Consultant	Date Submitted by Consultant	Document Revision	Planned Date to be Submitted to Board	Date Submitted to Board	Date Response Required from Board (2 Weeks)	Date Received from Board	Board Status						
Item	Submitted on	Comments																																			
				G L-EW XX 01-726 115	K2 150mm wide Standard Concrete Kerb	04/12/12	22/11/12	C	0bc	BMCE-TRANSMT-013238 10/01/2013	31/01/2013	04/02/2013	A	BMCE-TRANSMT-013086 12/02/2013																							
				G L-EW XX 01-726 116	K3 150mm wide Standard Flush Concrete Kerb	04/12/12			0bc																												
				G L-EW XX 01-726 117	K4 300mm wide Kasenel Bus Kerb	04/12/12	22/11/12	3	0bc	BMCE-TRANSMT-013238 10/01/2013	31/01/2013	04/02/2013	A	BMCE-TRANSMT-013086 12/02/2013																							
				G L-EW XX 01-726 118	K5 300mm wide Countryside Flush Concrete Kerb	04/12/12	22/11/12	D	0bc	BMCE-TRANSMT-013238 10/01/2013	31/01/2013	04/02/2013	A	BMCE-TRANSMT-013086 12/02/2013																							
				G L-EW XX 01-726 119	K6 150mm wide Countryside Flush Concrete Kerb	04/12/12			0bc																												
				G L-EW XX 01-726 120	K7 150mm wide Standard Drop Concrete Kerb	04/12/12			0bc																												
				G L-EW XX 01-726 121	Roof P4	0bc			0bc																												
				G L-EW XX 01-726 122	Roof P6	0bc			0bc																												
				G L-EW XX 01-726 123	Roof P6 mound detail	0bc			0bc																												
				G L-EW XX 01-726 124	Roof P5		23/07/12	3	27.07.12	BMCE-TRANSMT-009961 23/07/2012	13/08/2012	25/07/2012	A	BMCE-TRANSMT-010069 30/07/2012																							
				G L-EW XX 01-726 125	Roof P7		23/07/12	3	27.07.12	BMCE-TRANSMT-009961 23/07/2012	13/08/2012	25/07/2012	A	BMCE-TRANSMT-010069 30/07/2012																							
				G L-EW XX 01-726 126	Red Granite Chippings P15		23/07/12	2	27.07.12	BMCE-TRANSMT-009961 23/07/2012	13/08/2012	25/07/2012	A	BMCE-TRANSMT-010069 30/07/2012																							
				G L-EW XX 01-726 127	P13 Granite slab paving	04/12/12	22/11/12	3	0bc	BMCE-TRANSMT-013238 10/01/2013	31/01/2013	04/02/2013	A	BMCE-TRANSMT-013086 12/02/2013																							
				G L-EW XX 01-726 128	T3 Concrete Contouring Tactile paving				0bc																												
				G L-EW XX 01-726 137	Manhole in 18 Cover details		23/07/12	1	27.07.12	BMCE-TRANSMT-009961 23/07/2012	13/08/2012	25/07/2012	A	BMCE-TRANSMT-010069 30/07/2012	04/12/12	22/11/12	3	0bc	BMCE-TRANSMT-013238 10/01/2013	31/01/2013	04/02/2013	A	BMCE-TRANSMT-013086 12/02/2013														
				G L-EW XX 01-726 138	P4v Concrete Block Paving	04/12/12	23/07/12	2	27.07.12	BMCE-TRANSMT-009961 23/07/2012	13/08/2012	25/07/2012	A	BMCE-TRANSMT-010069 30/07/2012	04/12/12	22/11/12	3	0bc	BMCE-TRANSMT-013238 10/01/2013	31/01/2013	04/02/2013	A	BMCE-TRANSMT-013086 12/02/2013														
				G L-EW XX 01-726 139	T3 Concrete Contouring Tactile Paving	04/12/12	22/11/12	2	0bc	BMCE-TRANSMT-013238 10/01/2013	31/01/2013	04/02/2013	B	BMCE-TRANSMT-013086 12/02/2013																							
				G L-EW XX 01-726 143	Scottish Pebbles and Cobblestones P17		23/07/12	0	27.07.12	BMCE-TRANSMT-009961 23/07/2012	13/08/2012	25/07/2012	A	BMCE-TRANSMT-010069 30/07/2012																							
				G L-EW XX 01-726 144	Loose Pebbles and Cobblestones P18		23/07/12	0	27.07.12	BMCE-TRANSMT-009961 23/07/2012	13/08/2012	25/07/2012	A	BMCE-TRANSMT-010069 30/07/2012																							
				G L-EW XX 01-726 147	Courtyard Access Step Details		05/12/12	A		BMCE-TRANSMT-012736 05/12/2012	03/01/2013	12/12/2012	A	BMCE-TRANSMT-012017 10/12/2012																							
				G L-EW-XX- M-700-001	Atterbury Granite Paving Mix		23/10/12	0	23/10/12	BMCE-TRANSMT-011195	13/11/2012	24/10/2012	A	BMCE-TRANSMT-011022																							
																						</															

Multiplex Europe



Date Returned to
Consult ant





Date Returned to
Consult ant

DNCE TRANSMIT
01540

Multiplex Europe



Date Returned to
Consult ant

Multiplex EuropeDate Returned to
Consul ant[illegible]

OVERDUE
OVERDUE

[illegible]

OVERDUE
OVERDUE

Item	Submission	Comments
9	Soft Landscaping	Colour, Layout, Maintenance, Lifecycle, U.P.S.

10	External Furniture
	BCL-AC-XX-SH-001

			Action By	Drawing Number	Drawing Title	Date Required from Consultant	Date Submitted by Consultant	Document Revision	Planned Date to be Submitted to Board	Date Submitted to Board	Date Response Required from Board (+3 Weeks)	Date Returned from Board	Board Status	Date returned to Consultant	Date Required from Consultant	Date Submitted by Consultant	Document Revision	Planned Date to be Submitted to Board	Date Submitted to Board	Date Response Required from Board (+2 Weeks)	Date Received from Board	Board Status	Date Returned to Consultant	OVERDUE		
Item	Submission	Comments																								
				G L-EW-XX-SP-700-404-Q40	Fencing		12/07/12	0		BMCE-TRANSMIT-010208 07/08/2012	28/08/2012		A	BMCE-TRANSMIT-010838 06 09/2012												
				G L-EW-XX-SP-700-404-Q50	Site/Street Furniture/Equipment		12/07/12	0		BMCE-TRANSMIT-010208 07/08/2012	28/08/2012		A	BMCE-TRANSMIT-010838 06 09/2012		22/11/2012	2		BMCE-TRANSMIT-013238 10/01/2013	24/01/2013		A	BMCE-TRANSMIT-013896 12/02/2013			
				G L-EW-XX-SP-700-404-Q52	Play & sports Equipment Systems		12/07/12	0		BMCE-TRANSMIT-010208 07/08/2012	28/08/2012		A	BMCE-TRANSMIT-010838 06 09/2012												
				GIL-EW-XX-SP-700-404-V90	Electrical Systems-Landscape		12/07/12	0		BMCE-TRANSMIT-010208 07/08/2012	28/08/2012		A	BMCE-TRANSMIT-010838 06 09/2012												
					Technical drawings will be issued following completion of pre RDD meetings and commencement of Externals Work Group meetings. Estimated start 9.05.12																					
		Aspect of review:	GIL	GIL-EW-XX-DT-730-100	Cycle Stands		04/12/2012	C		BMCE-TRANSMIT-013239 10/01/2013	31/01/2013	04/02/2013	A	BMCE-TRANSMIT-013887 12/02/2013												
		Colour		GIL-EW-XX-DT-730-101	Bo lard standard- Bolard removable-Bollard illuminated		04/07/12	D		BMCE-TRANSMIT-009567 04/07/2012	25/07/2012	25/07/2012	A	BMCE-TRANSMIT-010069 30/07/2012	07/10/11	04/12/2012	E		10/01/2013	31/01/2013	04/02/2013	A	BMCE-TRANSMIT-013887 12/02/2013			
		Maintenance		GIL-EW-XX-DT-730-102	Bin	07/10 11	04/12/2012	3		BMCE-TRANSMIT-013239 10/01/2013	31/01/2013	04/02/2013	B	BMCE-TRANSMIT-013887 12/02/2013												
		Lifecycle		GIL-EW-XX-DT-730-103	Pallassade fence detail	07/10 11			tbc																	
				GIL-EW-XX-DT-730-106	Labs Wall and Planter Detail 1	07/10 11			tbc																	
				GIL-EW-XX-DT-730-108	Free Standing Concrete Wall to Labs Building	07/10 11			tbc																	
				GIL-EW-XX-DT-730-109	Children's Park retaining and sea ing wall	04/12/12	22/11/12	4	tbc	BMCE TRANSMIT 013238 10/01/2013	31/01/2013	04/02/2013	A	BMCE-TRANSMIT-013896 12/02/2013												
				GIL-EW-XX-DT-730-110	W3 A & E Retaining Wall	04/12/12	22/11/12	2	tbc	BMCE TRANSMIT 013238 10.01.2013	31/01/2013	04/02/2013	A	BMCE-TRANSMIT-013896 12/02/2013												
				GIL-EW-XX-DT-730-111	W4 Gabion Wall	04/12/12	22/11/12	4	tbc	BMCE TRANSMIT 013238 10.01.2013	31/01/2013	04/02/2013	A	BMCE-TRANSMIT-013896 12/02/2013												
				GIL-EW-XX-DT-730-119	Childrens Park Shelter decking plan and section	04/12/12	22/11/12	2	tbc	BMCE TRANSMIT 013238 10/01/2013	31/01/2013	04/02/2013	A	BMCE-TRANSMIT-013896 12/02/2013												
				GIL-EW-XX-DT-730-120	Childrens Park Shelter decking detail	04/12/12	22/11/12	2	tbc	BMCE TRANSMIT 013238 10/01/2013	31/01/2013	04/02/2013	A	BMCE-TRANSMIT-013896 12/02/2013												
				GIL-EW-XX-DT-730-123	Seat 1 - Single Neoliviano Seat	07/10 11	04/12/2012	3		BMCE-TRANSMIT-013239 10/01/2013	31/01/2013	04/02/2013	A	BMCE-TRANSMIT-013887 12/02/2013												
				GIL-EW-XX-DT-730-124	Seat 3- Woodtop seating bench	07/10 11			tbc																	
				GIL-EW-XX-DT-730-125	Seat 4- Cargo' Seat	07/10 11	04/12/2012	3		BMCE-TRANSMIT-013239 10/01/2013	31/01/2013	04/02/2013	A	BMCE-TRANSMIT-013887 12/02/2013												
				GIL-EW-XX-DT-730-126	Seat 5- 'Flor' Bench	07/10 11	04/12/2012	3		BMCE-TRANSMIT-013239 10/01/2013	31/01/2013	04/02/2013	A	BMCE-TRANSMIT-013887 12/02/2013												
		Reclaim Stone Works Not Proceeding. PC Units to Be Used		GIL-EW-XX-DT-730-127	Seat 6-Reclaimed Sandstone Lintel	07/10 11	04/12/2012	3		BMCE-TRANSMIT-013239 10/01/2013	31/01/2013	04/02/2013	D	BMCE-TRANSMIT-013887 12/02/2013												
		BOARD TO CLARIFY WHAT LOW MAINTENANCE MEANS PRIOR TO RDD ISSUE		GIL-EW-XX-DT-730-129	Roof Tensile structure 1	31/08/11			14.02.12																	
				GIL-EW-XX-DT-730-130	Roof Tensile structure 2	31/08/11			14.02.12																	
				GIL-EW-XX-DT-730-131	Childrens Park Tensile structure 1	07/10 11			tbc																	
				GIL-EW-XX-DT-730-132	Childrens Park Tensile structure 2	07/10 11			tbc																	
				GIL-EW-XX-DT-730-133	Roof pergolas deta l	31/08/11			14.02.12																	
				GIL-EW-XX-DT-730-134	Seat 2- 1750 mm Neoliviano Bench	07/10 11	04/12/2012	3		BMCE-TRANSMIT-013239 10/01/2013	31/01/2013	04/02/2013	A	BMCE-TRANSMIT-013887 12/02/2013												
				GIL-EW-XX-DT-730-135	Street Lighting	07/10 11	04/12/2012	D		BMCE-TRANSMIT-013239 10/01/2013	31/01/2013	04/02/2013	A	BMCE-TRANSMIT-013887 12/02/2013												
				GIL-EW-XX-DT-730-136	Feature Lighting Mast	07/10 11	04/12/2012	3		BMCE-TRANSMIT-013239 10/01/2013	31/01/2013	04/02/2013	A	BMCE-TRANSMIT-013887 12/02/2013												
				GIL-EW-XX-DT-730-137	Feature lighting type A and F	07/10 11	04/12/2012	3		BMCE-TRANSMIT-013239 10/01/2013	31/01/2013	04/02/2013	A	BMCE-TRANSMIT-013887 12/02/2013												
				GIL-EW-XX-DT-730-138	Feature lighting type B and C	07/10 11	04/12/2012	3		BMCE-TRANSMIT-013239 10/01/2013	31/01/2013	04/02/2013	A	BMCE-TRANSMIT-013887 12/02/2013												
				GIL-EW-XX-DT-730-140	Wayfinding and Signs Location Plan	07/10 11	13/08/2012	3	tbc	BMCE-TRANSMIT-010438 21/08/2012	27/11/2012	31/10/2012	B	BMCE-TRANSMIT-012134 06/11/2012												
				GIL-EW-XX-DT-730-141	Signage Suite	07/10 11	13/08/2012	3	tbc	BMCE-TRANSMIT-010438 21/08/2012	27/11/2012	31/10/2012	B	BMCE-TRANSMIT-012134 06/11/2012												
				GIL-EW-XX-DT-730-142	Grapic Guide ines	07/10 11	13/08/2012	3	tbc	BMCE-TRANSMIT-010438 21/08/2012	27/11/2012	31/10/2012	B	BMCE-TRANSMIT-012134 06/11/2012												
				GIL-EW-XX-DT-730-143	Sign Type 1	07/10 11	13/08/2012	3	tbc	BMCE-TRANSMIT-010438 21/08/2012	27/11/2012	31/10/2012	B	BMCE-TRANSMIT-012134 06/11/2012												
				GIL-EW-XX-DT-730-144	Sign Type 2	07/10 11	13/08/2012	3	tbc	BMCE-TRANSMIT-010438 21/08/2012	27/11/2012	31/10/2012	B	BMCE-TRANSMIT-012134 06/11/2012												
				GIL-EW-XX-DT-730-145	Sign Type 3	07/10 11	13/08/2012	3	tbc	BMCE-TRANSMIT-010438 21/08/2012	27/11/2012	31/10/2012	B	BMCE-TRANSMIT-012134 06/11/2012												
				GIL-EW-XX-DT-730-146	Sign Type 4	07/10 11	13/08/2012	3	tbc	BMCE-TRANSMIT-010438 21/08/2012	27/11/2012	31/10/2012	B	BMCE-TRANSMIT-012134 06/11/2012												

RDD MASTER SCHEDULE - NHS Greater Glasgow & Clyde / New South Glasgow Hospitals (NSGH) Project - Adults & Childrens Hospital										Brookfield Multiplex Europe															
BCL-AC-XX-SH-001																									
10 External Furniture																									OVERDUE

BCL-AC-XX-SH-001			1st Submission														2nd Submission									
			Action By	Drawing Number	Drawing Title	Date Required from Consultant	Date Submitted by Consultant	Document Revision	Planned Date to be Submitted to Board	Date Submitted to Board	BMCE Transmittal No	Date Response Required from Board (+3 Weeks)	Date Received from Board	Board Status	Date Returned to Consultant	Date Required from Consultant	Date Submitted by Consultant	Document Revision	Planned Date to be Submitted to Board	Date Submitted to Board	Date Response Required from Board (+2 Weeks)	Date Received from Board	Board Status	Date Returned to Consultant		
Item	Submission	Comments																								
14	Wall Protection, Handrails Balustrades	Colour, Maintenance, Lifecycle H & S																								
	Wall Protection Strategy Plans (1:300)		NA	NA-xx-xx-DT-410-001	Balustrading, Handrail, Wall Protection Key (1 of 2)	09/12/2011	24/04/2013		23/12/2011	29/02/2012	BMCE-TRANSMIT-007873	21/03/2012	14/05/2012	A	BMCE-TRANSMIT-009085 25/05/2012		19/04/2013	8		BMCE-TRANSMIT-015238 25/04/2013	16/05/2013		A	BMCE-TRANSMIT-016401 20/06/2013		
			NA	NA-xx-xx-DT-410-002	Balustrading, Handrail, Wall Protection Key (2 of 2)	09/12/2011			23/12/2011	29/02/2012	BMCE-TRANSMIT-007873	21/03/2012	14/05/2012	A	TRANSMIT-009085 25/05/2012		19/04/2013	3		TRANSMIT-015238 25/04/2013	16/05/2013		A	TRANSMIT-016401 20/06/2013		
			NA	NA-XX-XX-DT-410-003	Typical Wall Protection Details		19/04/2013	1		25/04/2013	BMCE-TRANSMIT-015358	16/05/2013		A	BMCE-TRANSMIT-016401 20/06/2013		30/07/2013	2		BMCE-TRANSMIT-017394 22/08/2013	05/09/2013	27/08/2013	A	BMCE-TRANSMIT-017482 20/08/13		
	Aspect of review:																									
	Clinical functionality	NA	NA-XX-B1-PL-410-150		Basement - Wall Protection Strategy Plan	09/12/2011	09/12/2011	5	23/12/2011	29/02/2012	BMCE-TRANSMIT-007873	21/03/2012	14/05/2012	A	BMCE-TRANSMIT-009085 25/05/2012											
	Infection control	NA	NA-XX-00-PL-410-150		Ground Floor - Wall Protection Strategy Plan	09/12/2011	09/12/2011	5	23/12/2011	29/02/2012	BMCE-TRANSMIT-007873	21/03/2012	14/05/2012	B	BMCE-TRANSMIT-009085 25/05/2012		30/07/2013	6		BMCE-TRANSMIT-017394 22/08/2013	05/09/2013	27/08/2013	A	BMCE-TRANSMIT-017482 20/08/13		
	Colour	NA	NA-XX-01-PL-410-150		First Floor - Wall Protection Strategy Plan	09/12/2011	09/12/2011	5	23/12/2011	29/02/2012	BMCE-TRANSMIT-007873	21/03/2012	14/05/2012	B	BMCE-TRANSMIT-009085 25/05/2012		30/07/2013	7		BMCE-TRANSMIT-017394 22/08/2013	05/09/2013	27/08/2013	A	BMCE-TRANSMIT-017482 20/08/13		
	Maintenance	NA	NA-XX-02-PL-410-150		Second Floor - Wall Protection Strategy Plan	09/12/2011	09/12/2011	5	23/12/2011	29/02/2012	BMCE-TRANSMIT-007873	21/03/2012	14/05/2012	B	BMCE-TRANSMIT-009085 25/05/2012		30/07/2013	6		BMCE-TRANSMIT-017394 22/08/2013	05/09/2013	27/08/2013	A	BMCE-TRANSMIT-017482 20/08/13		
	Lifecycle	NA	NA-xx-03-PL-410-150		Third Floor - Wall Protection Strategy Plan	09/12/2011	09/12/2011	5	23/12/2011	29/02/2012	BMCE-TRANSMIT-007873	21/03/2012	14/05/2012	A	TRANSMIT-009085 25/05/2012		30/07/2013	7		TRANSMIT-017394 22/08/2013	05/09/2013	27/08/2013	B	TRANSMIT-017482 20/08/13		
	H&S	NA	NA-xx-04-PL-410-150		Fourth Floor - Wall Protection Strategy Plan	09/12/2011	09/12/2011	5	23/12/2011	29/02/2012	BMCE-TRANSMIT-007873	21/03/2012	14/05/2012	B	TRANSMIT-009085 25/05/2012		30/07/2013	6		TRANSMIT-017394 22/08/2013	05/09/2013	27/08/2013	B	TRANSMIT-017482 20/08/13		
		NA	NA-xx-05-PL-410-150		Fifth Floor - Wall Protection Strategy Plan	09/12/2011	09/12/2011	5	23/12/2011	29/02/2012	BMCE-TRANSMIT-007873	21/03/2012	14/05/2012	A	TRANSMIT-009085 25/05/2012		30/07/2013	6		TRANSMIT-017394 22/08/2013	05/09/2013	27/08/2013	A	TRANSMIT-017482 20/08/13		
		NA	NA-xx-06-PL-410-150		Sixth Floor - Wall Protection Strategy Plan	09/12/2011	09/12/2011	5	23/12/2011	29/02/2012	BMCE-TRANSMIT-007873	21/03/2012	14/05/2012	B	TRANSMIT-009085 25/05/2012		30/07/2013	6		TRANSMIT-017394 22/08/2013	05/09/2013	27/08/2013	A	TRANSMIT-017482 20/08/13		
	NA-XX-06-PL-410-150 USED AS TYPICAL STRATEGY FOR UPPER FLOORS, DRAWING DOESN'T EXIST	NA	NA-xx-07-PL-410-150		Seventh Floor - Wall Protection Strategy Plan																					
	NA-XX-06-PL-410-150 USED AS TYPICAL STRATEGY FOR UPPER FLOORS, DRAWING DOESN'T EXIST	NA	NA-xx-08-PL-410-150		Eighth Floor - Wall Protection Strategy Plan																					
	NA-XX-06-PL-410-150 USED AS TYPICAL STRATEGY FOR UPPER FLOORS, DRAWING DOESN'T EXIST	NA	NA-xx-09-PL-410-150		Ninth Floor - Wall Protection Strategy Plan																					
	NA-XX-06-PL-410-150 USED AS TYPICAL STRATEGY FOR UPPER FLOORS, DRAWING DOESN'T EXIST	NA	NA-xx-10-PL-410-150		Tenth Floor - Wall Protection Strategy Plan																					
	NA-XX-06-PL-410-150 USED AS TYPICAL STRATEGY FOR UPPER FLOORS, DRAWING DOESN'T EXIST	NA	NA-xx-11-PL-410-150		Eleventh Floor - Wall Protection Strategy Plan																					
		NA	NA-XX-B1-PL-410-100		Basement Plan - FM & Distribution / Stores / Bed Maintenance / AGV Charging - Wall Protection Strategy	09/12/2011	09/12/2011	3	23/12/2011	29/02/2012	BMCE-TRANSMIT-007873	21/03/2012	14/05/2012	A	BMCE-TRANSMIT-009085 25/05/2012											
		NA	NA-XX-B1-PL-410-101		Basement Plan - Kitchen / FM & Distribution / Stores - Wall Protection Strategy	09/12/2011	09/12/2011	3	23/12/2011	29/02/2012	BMCE-TRANSMIT-007873	21/03/2012	14/05/2012	A	BMCE-TRANSMIT-009085 25/05/2012											
		NA	NA-XX-00-PL-410-100		Ground Floor Plan - NSGH Entrance Reception and Atrium Space - Wall Protection Strategy	09/12/2011	09/12/2011	3	23/12/2011	29/02/2012	BMCE-TRANSMIT-007873	21/03/2012	14/05/2012	A	BMCE-TRANSMIT-009085 25/05/2012											
		NA	NA-XX-00-PL-410-101		Ground Floor Plan - NCH Rehab - Wall Protection Strategy	09/12/2011	09/12/2011	3	23/12/2011	29/02/2012	BMCE-TRANSMIT-007873	21/03/2012	14/05/2012	A	BMCE-TRANSMIT-009085 25/05/2012											
		NA	NA-XX-00-PL-410-102		Ground Floor Plan - NCH Entrance and OPD - Wall Protection Strategy	09/12/2011	09/12/2011	3	23/12/2011	29/02/2012	BMCE-TRANSMIT-007873	21/03/2012	14/05/2012	A	BMCE-TRANSMIT-009085 25/05/2012											
		NA	NA-XX-00-PL-410-103		Ground Floor Plan - NCH Observation Ward / Child Protection / Sanctuary - Wall Protection Strategy	09/12/2011	09/12/2011	3	23/12/2011	29/02/2012	BMCE-TRANSMIT-007873	21/03/2012	14/05/2012	A	BMCE-TRANSMIT-009085 25/05/2012											
		NA	NA-XX-00-PL-410-104		Ground Floor Plan - NCH Emergency Department / Decontamination Unit - Wall Protection Strategy	09/12/2011	09/12/2011	3	23/12/2011	29/02/2012	BMCE-TRANSMIT-007873	21/03/2012	14/05/2012	B	BMCE-TRANSMIT-009085 25/05/2012											
		NA	NA-XX-00-PL-410-105		Ground Floor Plan - NSGH Emergency Department - Wall Protection Strategy	09/12/2011	09/12/2011	3	23/12/2011	29/02/2012	BMCE-TRANSMIT-007873	21/03/2012	14/05/2012	B	BMCE-TRANSMIT-009085 25/05/2012											
		NA	NA-XX-00-PL-410-106		Ground Floor Plan - NSGH Acute Assessment - Wall Protection Strategy	09/12/2011	09/12/2011	3	23/12/2011	29/02/2012	BMCE-TRANSMIT-007873	21/03/2012	14/05/2012	A	BMCE-TRANSMIT-009085 25/05/2012											
		NA	NA-XX-00-PL-410-107		Ground Floor Plan - NSGH Radiology / Medical Illustration - Wall Protection Strategy	09/12/2011	09/12/2011	3	23/12/2011	29/02/2012	BMCE-TRANSMIT-007873	21/03/2012	14/05/2012	B	BMCE-TRANSMIT-009085 25/05/2012											
		NA	NA-XX-00-PL-410-108		Ground Floor Plan - NCH Radiology - Wall Protection Strategy	09/12/2011	09/12/2011	3	23/12/2011	29/02/2012	BMCE-TRANSMIT-007873	21/03/2012	14/05/2012	A	BMCE-TRANSMIT-009085 25/05/2012											
		NA	NA-XX-00-PL-410-109		Ground Floor Plan - NSGH OPD / Rehab & Therapies - Wall Protection Strategy	09/12/2011	09/12/2011	3	23/12/2011	29/02/2012	BMCE-TRANSMIT-007873	21/03/2012	14/05/2012	B	BMCE-TRANSMIT-009085 25/05/2012											
		NA	NA-XX-01-PL-410-100		First Floor Plan - NSGH Restaurant, Sanctuary and Atrium Space - Wall Protection Strategy	09/12/2011	09/12/2011	3	23/12/2011	29/02/2012	BMCE-TRANSMIT-007873	21/03/2012	14/05/2012	A	BMCE-TRANSMIT-009085 25/05/2012											
14	Wall Protection, Handrails							115																		

BCL-AC-XX-SH-001			1st Submission													2nd Submission								
			Action By	Drawing Number	Drawing Title	Date Required from Consultant	Date Submitted by Consultant	Document Revision	Planned Date to be Submitted to Board	Date Submitted to Board	BMCE Transmittal No	Date Response Required from Board (+3 Weeks)	Date Received from Board	Board Status	Date Returned to Consultant	Date Required from Consultant	Date Submitted by Consultant	Document Revision	Planned Date to be Submitted to Board	Date Submitted to Board	Date Response Required from Board (+2 Weeks)	Date Received from Board	Board Status	Date Returned to Consultant
Item	Submission	Comments																						
			NA	NA-XX-01-PL-410-101	First Floor Plan - NCH Theatres / Interventional Radiology and Radiology - WaI Protection Strategy	09/12/2011	09/12/2011	3	23/12/2011	29/02/2012	BMCE-TRANSMIT-007873	21/03/2012	14/05/2012	A	BMCE-TRANSMIT-009085 25/05/2012									
			NA	NA-XX-01-PL-410-102	First Floor Plan - NCH 23 Hour Unit - Wall Protection Strategy	09/12/2011	09/12/2011	3	23/12/2011	29/02/2012	BMCE-TRANSMIT-007873	21/03/2012	14/05/2012	B	BMCE-TRANSMIT-009085 25/05/2012									
			NA	NA-XX-01-PL-410-103	Floor Plan - NCH Critical Care (PICU) / Cardiology Ward / Support / MDU and Special Feeds - Wall Protection Str	09/12/2011	09/12/2011	3	23/12/2011	29/02/2012	BMCE-TRANSMIT-007873	21/03/2012	14/05/2012	A	BMCE-TRANSMIT-009085 25/05/2012									
			NA	NA-XX-01-PL-410-104	First Floor Plan - NSGH CCU and Critical Care (1 of 2) - Wall Protection Strategy	09/12/2011	09/12/2011	3	23/12/2011	29/02/2012	BMCE-TRANSMIT-007873	21/03/2012	14/05/2012	A	BMCE-TRANSMIT-009085 25/05/2012									
			NA	NA-XX-01-PL-410-105	First Floor Plan - NSGH Critical Care (2 of 2) - Wall Protection Strategy	09/12/2011	09/12/2011	3	23/12/2011	29/02/2012	BMCE-TRANSMIT-007873	21/03/2012	14/05/2012	B	TRANSMIT-009085 25/05/2012									
			NA	NA-XX-01-PL-410-106	First Floor Plan - NSGH Stroke Ward / MDU - Wall Protection Strategy	09/12/2011	09/12/2011	3	23/12/2011	29/02/2012	BMCE-TRANSMIT-007873	21/03/2012	14/05/2012	B	BMCE-TRANSMIT-009085 25/05/2012									
			NA	NA-XX-01-PL-410-107	First Floor Plan - NSGH Radiology - WaI Protection Strategy	09/12/2011	09/12/2011	3	23/12/2011	29/02/2012	BMCE-TRANSMIT-007873	21/03/2012	14/05/2012	A	TRANSMIT-009085 25/05/2012									
			NA	NA-XX-01-PL-410-108	First Floor Plan - NSGH Nuclear Medicine - Wall Protection Strategy	09/12/2011	09/12/2011	3	23/12/2011	29/02/2012	BMCE-TRANSMIT-007873	21/03/2012	14/05/2012	B	BMCE-TRANSMIT-009085 25/05/2012									
			NA	NA-XX-01-PL-410-109	First Floor Plan - NSGH OPD & Pre-op Assessment - Wall Protection Strategy	09/12/2011	09/12/2011	3	23/12/2011	29/02/2012	BMCE-TRANSMIT-007873	21/03/2012	14/05/2012	B	TRANSMIT-009085 25/05/2012									
			NA	NA-XX-02-PL-410-100	Second Floor Plan - NSGH Atrium - Wall Protection Strategy	09/12/2011	09/12/2011	3	23/12/2011	29/02/2012	BMCE-TRANSMIT-007873	21/03/2012	14/05/2012	A	BMCE-TRANSMIT-009085 25/05/2012									
			NA	NA-XX-02-PL-410-101	Second Floor Plan - NSGH Dermatology Ward Plant - Wall Protection Strategy	09/12/2011	09/12/2011	3	23/12/2011	29/02/2012	BMCE-TRANSMIT-007873	21/03/2012	14/05/2012	A	TRANSMIT-009085 25/05/2012									
			NA	NA-XX-02-PL-410-102	Floor Plan - NCH Schiehallion Ward / Day Case Unit / Theatres and Anaesthetic Service Offices - Wall Protection	09/12/2011	09/12/2011	3	23/12/2011	29/02/2012	BMCE-TRANSMIT-007873	21/03/2012	14/05/2012	A	BMCE-TRANSMIT-009085 25/05/2012									
			NA	NA-XX-02-PL-410-103	Second Floor Plan - NCH Acute Receiving Ward / Aseptic Suite - Wall Protection Strategy	09/12/2011	09/12/2011	3	23/12/2011	29/02/2012	BMCE-TRANSMIT-007873	21/03/2012	14/05/2012	A	TRANSMIT-009085 25/05/2012									
			NA	NA-XX-02-PL-410-104	Second Floor Plan - NSGH Endoscopy / Decontamination / Medical Physics / Stores - Wall Protection Strategy	09/12/2011	09/12/2011	3	23/12/2011	29/02/2012	BMCE-TRANSMIT-007873	21/03/2012	14/05/2012	A	BMCE-TRANSMIT-009085 25/05/2012									
			NA	NA-XX-02-PL-410-105	Second Floor Plan - NSGH Theatres (1 of 2) Plant - Wall Protection Strategy	09/12/2011	09/12/2011	3	23/12/2011	29/02/2012	BMCE-TRANSMIT-007873	21/03/2012	14/05/2012	B	TRANSMIT-009085 25/05/2012									
			NA	NA-XX-02-PL-410-106	Second Floor Plan - NSGH Theatres (2 of 2) Plant - Wall Protection Strategy	09/12/2011	09/12/2011	3	23/12/2011	29/02/2012	BMCE-TRANSMIT-007873	21/03/2012	14/05/2012	A	BMCE-TRANSMIT-009085 25/05/2012									
			NA	NA-XX-02-PL-410-109	Second Floor Plan - NSGH Dermatology OPD / Renal Dialysis - Wall Protection Strategy	09/12/2011	09/12/2011	3	23/12/2011	29/02/2012	BMCE-TRANSMIT-007873	21/03/2012	14/05/2012	A	TRANSMIT-009085 25/05/2012									
			NA	NA-xx-03-PL-410-100	Third Floor Plan - NSGH Atrium / Health Records / FM /Staff Change - Wall Protection Strategy	09/12/2011	09/12/2011	3	23/12/2011	29/02/2012	BMCE-TRANSMIT-007873	21/03/2012	14/05/2012	A	BMCE-TRANSMIT-009085 25/05/2012									
		WALL PROTECTION NOT REQUIRED IN PLANTROOMS, PART OF M&E	NA	NA-xx-03-PL-410-101	Third Floor Plan - PLANT - Wall Protection Strategy																			
			NA	NA-xx-03-PL-410-102	Third Floor Plan - NCH In-Patient Ward / Medicinema - Wall Protection Strategy	09/12/2011	09/12/2011	3	23/12/2011	29/02/2012	BMCE-TRANSMIT-007873	21/03/2012	14/05/2012	A	BMCE-TRANSMIT-009085 25/05/2012									
			NA	NA-xx-03-PL-410-103	Third Floor Plan - NCH In-Patient Ward / Ward Support / Renal Day Case - Wall Protection Strategy	09/12/2011	09/12/2011	3	23/12/2011	29/02/2012	BMCE-TRANSMIT-007873	21/03/2012	14/05/2012	A	TRANSMIT-009085 25/05/2012									
			NA	NA-xx-03-PL-410-105	Third Floor Plan - PLANT - Wall Protection Strategy	09/12/2011	09/12/2011	3	23/12/2011	29/02/2012	BMCE-TRANSMIT-007873	21/03/2012	14/05/2012	A	BMCE-TRANSMIT-009085 25/05/2012									
		WALL PROTECTION NOT REQUIRED IN PLANTROOMS, PART OF M&E	NA	NA-xx-03-PL-410-106	Third Floor Plan - PLANT - Wall Protection Strategy																			
		WALL PROTECTION NOT REQUIRED IN PLANTROOMS, PART OF M&E	NA	NA-xx-03-PL-410-109	Third Floor Plan - PLANT - Wall Protection Strategy																			
			NA	NA-xx-04-PL-410-100	Fourth Floor Plan - NSGH Atrium Lift Core / Generic Ward Support - Wall Protection Strategy	09/12/2011	09/12/2011	3	23/12/2011	29/02/2012	BMCE-TRANSMIT-007873	21/03/2012	14/05/2012	A	BMCE-TRANSMIT-009085 25/05/2012									
			NA	NA-xx-04-PL-410-101	Fourth Floor Plan - Higher Acuity Renal Ward - Wall Protection Strategy	09/12/2011	09/12/2011	3	23/12/2011	29/02/2012	BMCE-TRANSMIT-007873	21/03/2012	14/05/2012	B	BMCE-TRANSMIT-009085 25/05/2012									
			NA	NA-xx-04-PL-410-102	Fourth Floor Plan - NCH DCFP - Wall Protection Strategy	09/12/2011	09/12/2011	3	23/12/2011	29/02/2012	BMCE-TRANSMIT-007873	21/03/2012	14/05/2012	B	TRANSMIT-009085 25/05/2012									
			NA	NA-xx-04-PL-410-103	Fourth Floor Plan - NSGH Haemo-Oncology Ward - Wall Protection Strategy	09/12/2011	09/12/2011	3	23/12/2011	29/02/2012	BMCE-TRANSMIT-007873	21/03/2012	14/05/2012	A	BMCE-TRANSMIT-009085 25/05/2012									
			NA	NA-xx-04-PL-410-104	Fourth Floor Plan - NSGH Renal Ward & Daycase (1 of 2) - Wall Protection Strategy	09/12/2011	09/12/2011	3	23/12/2011	29/02/2012	BMCE-TRANSMIT-007873	21/03/2012	14/05/2012	A	TRANSMIT-009085 25/05/2012									
			NA	NA-xx-04-PL-410-105	Fourth Floor Plan - NSGH Renal Ward & Daycase (2 of 2) - Wall Protection Strategy	09/12/2011	09/12/2011	3	23/12/2011	29/02/2012	BMCE-TRANSMIT-007873	21/03/2012	14/05/2012	A	BMCE-TRANSMIT-009085 25/05/2012									
			NA	NA-xx-04-PL-410-106	Fourth Floor Plan - NCH Plant - Wall Protection Strategy	09/12/2011	09/12/2011	3	23/12/2011	29/02/2012	BMCE-TRANSMIT-007873	21/03/2012	14/05/2012	A	TRANSMIT-009085 25/05/2012									

RDD MASTER SCHEDULE - NHS Greater Glasgow & Clyde / New South Glasgow Hospitals (NSGH) Project - Adults & Childrens Hospital																										
14		BCL-AC-XX-SH-001			1st Submission										2nd Submission											
					Action By	Drawing Number	Drawing Title	Date Required from Consultant	Date Submitted by Consultant	Document Revision	Planned Date to be Submitted to Board	Date Submitted to Board	BMCE Transmittal No	Date Response Required from Board (+3 Weeks)	Date Received from Board	Board Status	Date Returned to Consultant	Date Required from Consultant	Date Submitted by Consultant	Document Revision	Planned Date to be Submitted to Board	Date Submitted to Board	Date Response Required from Board (+2 Weeks)	Date Received from Board	Board Status	Date Returned to Consultant
Item	Submission	Comments																								
			NA	NA-xx-05-PL-410-100	Fifth Floor Plan - NSGH Atrium Lift Core / Generic Ward Support - Wa I Protection Strategy	09/12/2011	09/12/2011	3	23/12/2011	29/02/2012	BMCE-TRANSMIT-007873	21/03/2012	14/05/2012	A	BMCE-TRANSMIT-009085 25/05/2012											
			NA	NA-xx-05-PL-410-101	Fifth Floor Plan - NSGH Generic Ward (1 of 4) - Wall Protection Strategy	09/12/2011	09/12/2011	3	23/12/2011	29/02/2012	BMCE-TRANSMIT-007873	21/03/2012	14/05/2012	A	BMCE-TRANSMIT-009085 25/05/2012											
			NA	NA-xx-05-PL-410-102	Fifth Floor Plan - NSGH Generic Ward (2 of 4) - Wall Protection Strategy	09/12/2011	09/12/2011	3	23/12/2011	29/02/2012	BMCE-TRANSMIT-007873	21/03/2012	14/05/2012	A	BMCE-TRANSMIT-009085 25/05/2012											
			NA	NA-xx-05-PL-410-103	Fifth Floor Plan - NSGH Generic Ward (3 of 4) - Wall Protection Strategy	09/12/2011	09/12/2011	3	23/12/2011	29/02/2012	BMCE-TRANSMIT-007873	21/03/2012	14/05/2012	A	BMCE-TRANSMIT-009085 25/05/2012											
			NA	NA-xx-05-PL-410-104	Fifth Floor Plan - NSGH Generic Ward (4 of 4) - Wall Protection Strategy	09/12/2011	09/12/2011	3	23/12/2011	29/02/2012	BMCE-TRANSMIT-007873	21/03/2012	14/05/2012	A	BMCE-TRANSMIT-009085 25/05/2012											
		NA not issued	NA	NA-xx-05-PL-410-106	Fifth Floor Plan - NCH Plant - Wall Protection Strategy																					
			NA	NA-xx-06-PL-410-100	Sixth Floor Plan - NSGH Atrium Lift Core / Generic Ward Support - Wall Protection Strategy	09/12/2011	09/12/2011	3	23/12/2011	29/02/2012	BMCE-TRANSMIT-007873	21/03/2012	14/05/2012	A	BMCE-TRANSMIT-009085 25/05/2012											
			NA	NA-xx-06-PL-410-101	Sixth Floor Plan - NSGH Generic Ward (1 of 4) - Wall Protection Strategy	09/12/2011	09/12/2011	3	23/12/2011	29/02/2012	BMCE-TRANSMIT-007873	21/03/2012	14/05/2012	B	BMCE-TRANSMIT-009085 25/05/2012											
			NA	NA-xx-07-PL-410-100	Seventh Floor Plan - NSGH Atrium Lift Core / Generic Ward Support - Wall Protection Strategy	09/12/2011	09/12/2011	3	23/12/2011	29/02/2012	BMCE-TRANSMIT-007873	21/03/2012	14/05/2012	B	BMCE-TRANSMIT-009085 25/05/2012											
			NA	NA-xx-08-PL-410-100	Eighth Floor Plan - NSGH Atrium Lift Core / Generic Ward Support - Wall Protection Strategy	09/12/2011	09/12/2011	3	23/12/2011	29/02/2012	BMCE-TRANSMIT-007873	21/03/2012	14/05/2012	B	TRANSMIT-009085 25/05/2012											
			NA	NA-xx-09-PL-410-100	Ninth Floor Plan - NSGH Atrium Lift Core / Generic Ward Support - Wall Protection Strategy	09/12/2011	09/12/2011	3	23/12/2011	29/02/2012	BMCE-TRANSMIT-007873	21/03/2012	14/05/2012	A	BMCE-TRANSMIT-009085 25/05/2012											
			NA	NA-xx-10-PL-410-100	Tenth Floor Plan - NSGH Atrium Lift Core / Generic Ward Support - Wall Protection Strategy	09/12/2011	09/12/2011	3	23/12/2011	29/02/2012	BMCE-TRANSMIT-007873	21/03/2012	14/05/2012	B	TRANSMIT-009085 25/05/2012											
			NA	NA-xx-11-PL-410-100	Eleventh Floor Plan - NSGH Atrium Lift Core / Generic Ward Support - Wall Protection Strategy	09/12/2011	09/12/2011	3	23/12/2011	29/02/2012	BMCE-TRANSMIT-007873	21/03/2012	14/05/2012	A	BMCE-TRANSMIT-009085 25/05/2012											
			NA	NA-xx-11-PL-410-102	Eleventh Floor Plan - NSGH E.N.T Ward - Wall Protection Strategy	09/12/2011	09/12/2011	3	23/12/2011	29/02/2012	BMCE-TRANSMIT-007873	21/03/2012	14/05/2012	B	TRANSMIT-009085 25/05/2012											
			NA	NA-xx-12-PL-410-100	Twelfth Floor Plan - NSGH Atrium Lift Core / Generic Ward Support - Wall Protection Strategy	09/12/2011	09/12/2011	3	23/12/2011	29/02/2012	BMCE-TRANSMIT-007873	21/03/2012	14/05/2012	A	BMCE-TRANSMIT-009085 25/05/2012											
			NA	NA-xx-12-PL-410-102	Twelfth Floor Plan - Plant & Lift to Helipad; Wall Protection Strategy	09/12/2011	09/12/2011	3	23/12/2011	29/02/2012	BMCE-TRANSMIT-007873	21/03/2012	14/05/2012	A	BMCE-TRANSMIT-009085 25/05/2012											
			NA	NA-xx-13-PL-410-102	Thirteenth Floor Plan - Ramp Access to Helipad; Wa I Protection Strategy	09/12/2011	09/12/2011	3	23/12/2011	29/02/2012	BMCE-TRANSMIT-007873	21/03/2012	14/05/2012	A	BMCE-TRANSMIT-009085 25/05/2012											
	Wall Protection Detail Plans (1:50)	These will be co-ordinated onto the 1:50 fixtures & fittings plans	NA	refer to Item 3	refer to Item 3																					
		Refer to Item 3 for full drawing list																								
	Stairs and Balustrading Details		NA	tbc	tbc																					
	Specifications		NA	NA-SP-L30	Stairs - ladders - walkways - handrails - balustrades																					

15 - Plumbing Fittings	118

RDD MASTER SCHEDULE - NHS Greater Glasgow & Clyde / New South Glasgow Hospitals (NSGH) Project - Adults & Childrens Hospital										Drawing Information										Brookfield Multiplex Europe													
15	BCL-AC-XX-SH-001		1st Submission										2nd Submission										2nd Submission										OVERDUE
	Action By	Drawing Number	Drawing Title	Date Required from Consultant	Date Submitted by Consultant	Document Revision	Planned Date to be Submitted to Board	Date Submitted to Board	BMCE Transmittal No	Date Response Required from Board (+3 Weeks)	Date Returned from Board	Board Status	Date returned to Consultant	Date Required from Consultant	Date Submitted by Consultant	Document Revision	Planned Date to be Submitted to Board	Date Submitted to Board	Date Response Required from Board (+2 Weeks)	Date Received from Board	Board Status	Date Returned to Consultant	Date Required from Consultant	Date Submitted by Consultant	Document Revision	Planned Date to be Submitted to Board	Date Submitted to Board	Date Response Required from Board (+2 Weeks)	Date Received from Board	Board Status	Date Returned to Consultant	OVERDUE	
	BMCE	BMCE-XX-XX-DC-045	BAT007			0	18/09/2012		BMCE-TRANSMIT-011012	08/10 2012		B	BMCE-TRANSMIT-012296 14 11/2013		05/02/2013	1	05 02/2013	BMCE-TRANSMIT-013717 05 02/2013	19/02 2013		A	BMCE-TRANSMIT-014899 20/03/201											
	BMCE	BMCE-XX-XX-DC-046	BAT8000			0	18/09/2012		BMCE-TRANSMIT-011012	08/10 2012		B	BMCE-TRANSMIT-012296 14 11/2013		05/02/2013	1	05 02/2013	BMCE-TRANSMIT-013717 05 02/2013	19/02 2013		B	BMCE-TRANSMIT-014899 20/03/201	15/05/2013	1	15 05/2013	BMCE-TRANSMIT-015071 15/05/2013	29/05 2013		A	BMCE-TRANSMIT-016333 18 06/2013			
	BMCE	BMCE-XX-XX-DC-047	SHOW1002, SHOW1003, SHOO18 & SHOO26			0	18/09/2012		BMCE-TRANSMIT-011012	08/10 2012		A	BMCE-TRANSMIT-012296 14 11/2013																				
	BMCE	BMCE-XX-XX-DC-048	SHO1004			0	18/09/2012		BMCE-TRANSMIT-011012	08/10 2012		A	BMCE-TRANSMIT-012296 14 11/2013																				
	BMCE	BMCE-XX-XX-DC-049	DSU001			0	18/09/2012		BMCE-TRANSMIT-011012	08/10 2012		A	BMCE-TRANSMIT-012296 14 11/2013																				
	BMCE	BMCE-XX-XX-DC-050	DISU1000R,DISU1000L, DSU006 (SHTM64 DUHS)			0	18/09/2012		BMCE-TRANSMIT-011012	08/10 2012		A	BMCE-TRANSMIT-012296 14 11/2013																				
	BMCE	BMCE-XX-XX-DC-051	BATH1003			0	18/09/2012		BMCE-TRANSMIT-011012	08/10 2012		A	BMCE-TRANSMIT-012296 14 11/2013																				
	BMCE	BMCE-XX-XX-DC-052	SPR007			0	18/09/2012		BMCE-TRANSMIT-011012	08/10 2012		A	BMCE-TRANSMIT-012296 14 11/2013																				

BCL-AC-XX-SH-001			1st Submission												2nd Submission										OVERDUE	
			Action By	Drawing Number	Drawing Title	Date Required from Consultant	Date Submitted by Consultant	Document Revision	Planned Date to be Submitted to Board	Date Submitted to Board	Date Response Required from Board (+3 Weeks)	Date Returned from Board	Board Status	Date returned to Consultant	Date Required from Consultant	Date Submitted by Consultant	Document Revision	Planned Date to be Submitted to Board	Date Submitted to Board	Date Response Required from Board (+2 Weeks)	Date Received from Board	Board Status	Date Returned to Consultant	OVERDUE		
Item	Submission	Comments																								
16	Sanitaryware / IPS Panel	Colour, Maintenance, Lifecycle, H & S																								
	Specifications		NA	NA-SP-N13	Sanitary appliances and equipment																					
	Sanitary Room Strategy Drawings	Aspect of review:	NA	NA-SZ-XX-AS-440-001	Sanitary Room Type Key (1 of 2)		05/09/11																			
		Clinical functionality	NA	NA-SZ-XX-AS-440-002	Sanitary Room Type Key (2 of 2)		05/09/11																			
		Infection control																								
		Colour	NA	NA-XX-00-SC-440-150	Ground Floor Plan - Sanitary Room Type Locations	02/12/11																				
		Maintenance	NA	NA-XX-01-SC-440-150	First Floor Plan - Sanitary Room Type Locations	02/12/11																				
		Lifecycle	NA	NA-XX-02-SC-440-150	Second Floor Plan - Sanitary Room Type Locations	02/12/11																				
		H&S	NA	NA-XX-03-SC-440-150	Third Floor Plan - Sanitary Room Type Locations	02/12/11																				
			NA	NA-XX-04-SC-440-150	Fourth Floor Plan - Sanitary Room Type Locations	02/12/11																				
			NA	NA-XX-05-SC-440-150	Fifth Floor Plan - Sanitary Room Type Locations	02/12/11																				
			NA	NA-XX-06-SC-440-150	Sixth Floor Plan - Sanitary Room Type Locations	02/12/11																				
			NA	NA-XX-07-SC-440-150	Seventh Floor Plan - Sanitary Room Type Locations	02/12/11																				
			NA	NA-XX-08-SC-440-150	Eighth Floor Plan - Sanitary Room Type Locations	02/12/11																				
			NA	NA-XX-09-SC-440-150	Ninth Floor Plan - Sanitary Room Type Locations	02/12/11																				
			NA	NA-XX-10-SC-440-150	Tenth Floor Plan - Sanitary Room Type Locations	02/12/11																				
			NA	NA-XX-11-SC-440-150	Eleventh Floor Plan - Sanitary Room Type Locations	02/12/11																				
			NA	NA-XX-B1-SC-440-150	Basement Plan - Sanitary Room Type Locations	02/12/11																				
		omit drawing - covered in whole floor plans above	NA	NA-XX-B1-SC-440-101	Basement Plan—Kitchen / FM & Distribution / Stores—Sanitary Room Types	2012-tbc			2012-tbc																	
		omit drawing - covered in whole floor plans above	NA	NA-XX-00-SC-440-100	Ground Floor Plan—NSGH Entrance Reception and Atrium Space—Sanitary Room Types	2012-tbc			2012-tbc																	
		omit drawing - covered in whole floor plans above	NA	NA-XX-00-SC-440-101	Ground Floor Plan—NCH Rehab—Sanitary Room Types	2012-tbc			2012-tbc																	
		omit drawing - covered in whole floor plans above	NA	NA-XX-00-SC-440-102	Ground Floor Plan—NCH Entrance and OPD—Sanitary Room Types	2012-tbc			2012-tbc																	
		omit drawing - covered in whole floor plans above	NA	NA-XX-00-SC-440-103	Ground Floor Plan—NCH Observation Ward / Child Protection / Sanctuary—Sanitary Room Types	2012-tbc			2012-tbc																	
		omit drawing - covered in whole floor plans above	NA	NA-XX-00-SC-440-104	Ground Floor Plan—NCH Emergency Department / Decontamination Unit—Sanitary Room Types	2012-tbc			2012-tbc																	
		omit drawing - covered in whole floor plans above	NA	NA-XX-00-SC-440-105	Ground Floor Plan—NSGH Emergency Department—Sanitary Room Types	2012-tbc			2012-tbc																	
		omit drawing - covered in whole floor plans above	NA	NA-XX-00-SC-440-106	Ground Floor Plan—NSGH Acute Assessment—Sanitary Room Types	2012-tbc			2012-tbc																	
		omit drawing - covered in whole floor plans above	NA	NA-XX-00-SC-440-107	Ground Floor Plan—NSGH Radiology / Medical Illustration—Sanitary Room Types	2012-tbc			2012-tbc																	
		omit drawing - covered in whole floor plans above	NA	NA-XX-00-SC-440-108	Ground Floor Plan—NCH Radiology—Sanitary Room Types	2012-tbc			2012-tbc																	
		omit drawing - covered in whole floor plans above	NA	NA-XX-00-SC-440-109	Ground Floor Plan—NSCH OPD / Rehab & Therapies—Sanitary Room Types	2012-tbc			2012-tbc																	
		omit drawing - covered in whole floor plans above	NA	NA-XX-01-SC-440-100	First Floor Plan—NSCH Restaurant, Sanctuary and Atrium Space—Sanitary Room Types	2012-tbc			2012-tbc																	

BCL-AC-XX-SH-001			1st Submission												2nd Submission										OVERDUE
			Action By	Drawing Number	Drawing Title	Date Required from Consultant	Date Submitted by Consultant	Document Revision	Planned Date to be Submitted to Board	Date Submitted to Board	Date Response Required from Board (+3 Weeks)	Date Returned from Board	Board Status	Date returned to Consultant	Date Required from Consultant	Date Submitted by Consultant	Document Revision	Planned Date to be Submitted to Board	Date Submitted to Board	Date Response Required from Board (+2 Weeks)	Date Received from Board	Board Status	Date Returned to Consultant	OVERDUE	
Item	Submission	Comments																							
		omit drawing - covered in whole floor plans above	NA	NA-XX-01-SC-440-101	First Floor Plan – NCH Theatres / Inter-entional Radiology and Radiology – Sanitary Room Types	2012-tbc			2012-tbc																
		omit drawing - covered in whole floor plans above	NA	NA-XX-01-SC-440-102	First Floor Plan – NCH 23-Hour Unit – Sanitary Room Types	2012-tbc			2012-tbc																
		omit drawing - covered in whole floor plans above	NA	NA-XX-01-SC-440-103	Floor Plan – NCH Critical Care (PICU) / Cardiology Ward / Support / MDU and Special Feeds – Sanitary Room Types	2012-tbc			2012-tbc																
		omit drawing - covered in whole floor plans above	NA	NA-XX-01-SC-440-104	First Floor Plan – NSGH CCU and Critical Care (1 of 2) – Sanitary Room Types	2012-tbc			2012-tbc																
		omit drawing - covered in whole floor plans above	NA	NA-XX-01-SC-440-105	First Floor Plan – NSGH Critical Care (2 of 2) – Sanitary Room Types	2012-tbc			2012-tbc																
		omit drawing - covered in whole floor plans above	NA	NA-XX-01-SC-440-106	First Floor Plan – NSGH Stroke Ward / MDU – Sanitary Room Types	2012-tbc			2012-tbc																
		omit drawing - covered in whole floor plans above	NA	NA-XX-01-SC-440-107	First Floor Plan – NSGH Radiology – Sanitary Room Types	2012-tbc			2012-tbc																
		omit drawing - covered in whole floor plans above	NA	NA-XX-01-SC-440-108	First Floor Plan – NSGH Nuclear Medicine – Sanitary Room Types	2012-tbc			2012-tbc																
		omit drawing - covered in whole floor plans above	NA	NA-XX-01-SC-440-109	First Floor Plan – NSGH OPD & Pre-op Assessment – Sanitary Room Types	2012-tbc			2012-tbc																
		omit drawing - covered in whole floor plans above	NA	NA-XX-02-SC-440-100	Second Floor Plan – NSGH Atrium – Sanitary Room Types	2012-tbc			2012-tbc																
		omit drawing - covered in whole floor plans above	NA	NA-XX-02-SC-440-101	Second Floor Plan – NSGH Dermatology Ward – Plant – Sanitary Room Types	2012-tbc			2012-tbc																
		omit drawing - covered in whole floor plans above	NA	NA-XX-02-SC-440-102	Floor Plan – NCH Schiehallion Ward / Day Case Unit / Theatres and Anaesthetic Services Offices – Sanitary Room Types	2012-tbc			2012-tbc																
		omit drawing - covered in whole floor plans above	NA	NA-XX-02-SC-440-103	Second Floor Plan – NCH Acute Receiving Ward / Aseptic Suite – Sanitary Room Types	2012-tbc			2012-tbc																
		omit drawing - covered in whole floor plans above	NA	NA-XX-02-SC-440-104	Second Floor Plan – NSGH Endoscopy / Decontamination / Medical Physics / Stores – Sanitary Room Types	2012-tbc			2012-tbc																
		omit drawing - covered in whole floor plans above	NA	NA-XX-02-SC-440-105	Second Floor Plan – NSGH Theatres (1 of 2) – Plant – Sanitary Room Types	2012-tbc			2012-tbc																
		omit drawing - covered in whole floor plans above	NA	NA-XX-02-SC-440-106	Second Floor Plan – NSGH Theatres (2 of 2) – Plant – Sanitary Room Types	2012-tbc			2012-tbc																
		omit drawing - covered in whole floor plans above	NA	NA-XX-02-SC-440-109	Second Floor Plan – NSGH Dermatology OPD / Renal Dialysis – Sanitary Room Types	2012-tbc			2012-tbc																
		omit drawing - covered in whole floor plans above	NA	NA-xx-03-SC-440-100	Third Floor Plan – NSGH Atrium / Health Records / FM / Staff Change – Sanitary Room Types	2012-tbc			2012-tbc																
		omit drawing - covered in whole floor plans above	NA	NA-xx-03-SC-440-102	Third Floor Plan – NCH In-Patient Ward / Medicinema – Sanitary Room Types	2012-tbc			2012-tbc																
		omit drawing - covered in whole floor plans above	NA	NA-xx-03-SC-440-103	Third Floor Plan – NCH In-Patient Ward / Ward Support / Renal Day Case – Sanitary Room Types	2012-tbc			2012-tbc																
		omit drawing - covered in whole floor plans above	NA	NA-xx-04-SC-440-100	Fourth Floor Plan – NSGH Atrium – Lift Core / Generic Ward Support – Sanitary Room Types	2012-tbc			2012-tbc																
		omit drawing - covered in whole floor plans above	NA	NA-xx-04-SC-440-101	Fourth Floor Plan – Higher Acuity Renal Ward – Sanitary Room Types	2012-tbc			2012-tbc																
		omit drawing - covered in whole floor plans above	NA	NA-xx-04-SC-440-102	Fourth Floor Plan – NCH DCFP – Sanitary Room Types	2012-tbc			2012-tbc																
		omit drawing - covered in whole floor plans above	NA	NA-xx-04-SC-440-103	Fourth Floor Plan – NSGH Haemo-Oncology Ward – Sanitary Room Types	2012-tbc			2012-tbc																
		omit drawing - covered in whole floor plans above	NA	NA-xx-04-SC-440-104	Fourth Floor Plan – NSGH Renal Ward & Daycase (1 of 2) – Sanitary Room Types	2012-tbc			2012-tbc																
		omit drawing - covered in whole floor plans above	NA	NA-xx-04-SC-440-105	Fourth Floor Plan – NSGH Renal Ward & Daycase (2 of 2) – Sanitary Room Types	2012-tbc			2012-tbc																
		omit drawing - covered in whole floor plans above	NA	NA-xx-05-SC-440-100	Fifth Floor Plan – NSGH Atrium – Lift Core / Generic Ward Support – Sanitary Room Types	2012-tbc			2012-tbc																
		omit drawing - covered in whole floor plans above	NA	NA-xx-05-SC-440-101	Fifth Floor Plan – NSGH Generic Ward (1 of 4) – Sanitary Room Types	2012-tbc			2012-tbc																
		omit drawing - covered in whole floor plans above	NA	NA-xx-05-SC-440-102	Fifth Floor Plan – NSGH Generic Ward (2 of 4) – Sanitary Room Types	2012-tbc			2012-tbc																
		omit drawing - covered in whole floor plans above	NA	NA-xx-05-SC-440-103	Fifth Floor Plan – NSGH Generic Ward (3 of 4) – Sanitary Room Types	2012-tbc			2012-tbc																
		omit drawing - covered in whole floor plans above	NA	NA-xx-05-SC-440-104	Fifth Floor Plan – NSGH Generic Ward (4 of 4) – Sanitary Room Types	2012-tbc			2012-tbc																
		Sample signed off By NHS	NA	NA-SZ-XX-AS-440-010	Sanitary Room Detailed Drawing - Type WC A	2012-tbc			2012-tbc																

RDD MASTER SCHEDULE - NHS Greater Glasgow & Clyde / New South Glasgow Hospitals (NSGH) Project - Adults & Childrens Hospital																									Brookfield Multiplex Europe				
16		BCL-AC-XX-SH-001			1st Submission										2nd Submission										OVERDUE				
					Action By	Drawing Number	Drawing Title	Date Required from Consultant	Date Submitted by Consultant	Document Revision	Planned Date to be Submitted to Board	Date Submitted to Board	Date Response Required from Board (+3 Weeks)	Date Returned from Board	Board Status	Date returned to Consultant	Date Required from Consultant	Date Submitted by Consultant	Document Revision	Planned Date to be Submitted to Board	Date Submitted to Board	Date Response Required from Board (+2 Weeks)	Date Received from Board	Board Status	Date Returned to Consultant	OVERDUE			
Item	Submission		Comments																										
			Sample signed off By NHS	NA	NA-SZ-XX-AS-440-011	Sanitary Room Detailed Drawing - Type WC B		2012 tbc			2012 tbc																		
			Sample signed off By NHS	NA	NA-SZ-XX-AS-440-012	Sanitary Room Detailed Drawing - Type WC C(R)		2012 tbc			2012 tbc																		
			Sample signed off By NHS	NA	NA-SZ-XX-AS-440-013	Sanitary Room Detailed Drawing - Type WC C(L)		2012 tbc			2012 tbc																		
			Sample signed off By NHS	NA	NA-SZ-XX-AS-440-014	Sanitary Room Detailed Drawing - Type WC D		2012 tbc			2012 tbc																		
			Sample signed off By NHS	NA	NA-SZ-XX-AS-440-015	Sanitary Room Detailed Drawing - Type WC E		2012 tbc			2012 tbc																		
			Sample signed off By NHS	NA	NA-SZ-XX-AS-440-016	Sanitary Room Detailed Drawing - Type WC F		2012 tbc			2012 tbc																		
			Sample signed off By NHS	NA	NA-SZ-XX-AS-440-017	Sanitary Room Detailed Drawing - Type WC G		2012 tbc			2012 tbc																		
			Sample signed off By NHS	NA	NA-SZ-XX-AS-440-018	Sanitary Room Detailed Drawing - Type WC H		2012 tbc			2012 tbc																		
			Sample signed off By NHS	NA	NA-SZ-XX-AS-440-019	Sanitary Room Detailed Drawing - Type WC I		2012 tbc			2012 tbc																		
			Sample signed off By NHS	NA	NA-SZ-XX-AS-440-020	Sanitary Room Detailed Drawing - Type WC J		2012 tbc			2012 tbc																		
			Sample signed off By NHS	NA	NA-SZ-XX-AS-440-021	Sanitary Room Detailed Drawing - Type WC K		2012 tbc			2012 tbc																		
			Sample signed off By NHS	NA	NA-SZ-XX-AS-440-022	Sanitary Room Detailed Drawing - Type WC L		2012 tbc			2012 tbc																		
			Sample signed off By NHS	NA	NA-SZ-XX-AS-440-023	Sanitary Room Detailed Drawing - Type WC M		2012 tbc			2012 tbc																		
			Sample signed off By NHS	NA	NA-SZ-XX-AS-440-024	Sanitary Room Detailed Drawing - Type EN 1		2012 tbc			2012 tbc																		
			Sample signed off By NHS	NA	NA-SZ-XX-AS-440-025	Sanitary Room Detailed Drawing - Type EN 2		2012 tbc			2012 tbc																		
			Sample signed off By NHS	NA	NA-SZ-XX-AS-440-026	Sanitary Room Detailed Drawing - Type EN 3		2012 tbc			2012 tbc																		
			Sample signed off By NHS	NA	NA-SZ-XX-AS-440-027	Sanitary Room Detailed Drawing - Type EN 4		2012 tbc			2012 tbc																		
			Sample signed off By NHS	NA	NA-SZ-XX-AS-440-028	Sanitary Room Detailed Drawing - Type S1		2012 tbc			2012 tbc																		
			Sample signed off By NHS	NA	NA-SZ-XX-AS-440-029	Sanitary Room Detailed Drawing - Type S2		2012 tbc			2012 tbc																		
			Sample signed off By NHS	NA	NA-SZ-XX-AS-440-030	Sanitary Room Detailed Drawing - Type S3		2012 tbc			2012 tbc																		
			Sample signed off By NHS	NA	NA-SZ-XX-AS-440-031	Sanitary Room Detailed Drawing - Type S3		2012 tbc			2012 tbc																		
			These will be co-ordinated onto the 1:50 fixtures & fittings plans and room elevations		refer to Items 3 and 5	refer to Items 3 and 5																							
			Refer to Item 3 for full drawing list																										
	Detailed Drawings	See tab 15 - Plumbing fittings	MER	tbc	tbc																								

17			BCL-AC-XX-SH-001			Drawing Information										Drawing Review													
						Action By	Drawing Number	Drawing Title	1st Submission								2nd Submission												
									Date Required from Consultant	Date Submitted by Consultant	Document Revision	Planned Date to be Submitted to Board	Date Submitted to Board	Date Response Required from Board (+3 Weeks)	Date Returned from Board	Board Status	Date returned to Consultant	Date Required from Consultant	Date Submitted by Consultant	Document Revision	Planned Date to be Submitted to Board	Date Submitted to Board	Date Response Required from Board (+2 Weeks)	Date Received from Board	Board Status	Date Returned to Consultant			
Item	Submission		Comments																										
17	WC Cubicles & Prefab Partitions		Colour, Maintenance, Lifecycle, H & S																										
	Specifications			NA-SP-K32	Panel cubicles/ duct and wall linings/ screens																								
			Aspect of review:																										
			Colour																										
			Maintenance																										
			Lifecycle																										
			H&S																										
	Detailed Drawings		These will be co-ordinated onto the 1:50 fixtures & fittings plans and room elevations		refer to Items 3 and 5	refer to Items 3 and 5																							
			Refer to Item 3 for full drawing list																										

RDD MASTER SCHEDULE - NHS Greater Glasgow & Clyde / New South Glasgow Hospitals (NSGH) Project

<u>18a</u>	BCL-AC-XX-SH-001		
Item	Submission	Comments	Action By
18a	External & Internal Doors, Door Furniture & Ironmongery including Schedules	Glazing, Door Protection, Door Configuration	
	Specifications		NA
		Aspect of review:	NA
		Colour	
		Maintenance	
		Lifecycle	

		H&S	NA
			NA
			NA
			NA
			NA
	Internal Door Type Strategy Plans (1:300)		NA
	NOTE: propose to update to 1:200 detailed strategy		NA
			NA
			NA

[illegible]

[illegible]

[illegible]

[illegible]

[illegible]

[illegible]

[illegible]

			NA
			NA
			NA
			NA
	Internal Door Privacy Strategy Plans (1:300)	STATUS: These are approved under Appendix K.	NA
	NOTE: propose to update to 1:200 detailed strategy		NA
			NA
			NA
		This Information on this drawing is included on the 332-500 series signed off by the Board	NA

[illegible]

[illegible]

[illegible]

[illegible]

[illegible]

			NA
			NA
			NA
			NA
			NA
			NA
			NA
	Access Control & Locking Strategy Plans (1:300)		NA
	NOTE: propose to update to 1:200 detailed strategy		NA

[illegible]

[illegible]

[illegible]

[illegible]

[illegible]

[illegible]

		This Information on this drawing is included on the 332-500 series signed off by the Board	NA
		This Information on this drawing is included on the 332-500 series signed off by the Board	NA
		This Information on this drawing is included on the 332-500 series signed off by the Board	NA
	Door Protection Strategy Plans (1:300)		NA
			NA
			NA
	Door Protection Strategy Plans (1:200)		NA

[illegible]

[illegible]

	Internal Door & Ironmongery Schedules	To be developed by Subcontractor based on agreed Strategy Drawings	Sub-Contractor

t - Adults & Childrens Hospita

Drawing Number	Drawing Title	Date Required from Consultant	Date Submitted by Consultant
NA-SP-L20			
NA-SP-L40	General glazing		

NA-xx-xx-DT-322-001	Internal Door Elevation Types and Details (Sheet 1 of 2)		
NA-xx-xx-DT-322-002	Internal Door Elevation Types and Details (Sheet 2 of 2)		
NA-XX-XX-DT-322-003	Internal Door Elevation Types and Details (Sheet 3 of 5)		
NA-XX-XX-DT-322-004	Internal Door Elevation Types and Details (Sheet 4 of 5)		
NA-XX-XX-DT-322-005	Internal Door Elevation Types and Details (Sheet 5 of 5)		
NA-XX-B1-PL-322-150	Basement - Door Type Strategy Plan		
NA-XX-00-PL-322-150	Ground Floor - Door Type Strategy Plan		
NA-XX-01-PL-322-150	First Floor - Door Type Strategy Plan		
NA-XX-02-PL-322-150	Second Floor - Door Type Strategy Plan		

NA-xx-03-PL-322-150	Third Floor - Door Type Strategy Plan		
NA-xx-04-PL-322-150	Fourth Floor - Door Type Strategy Plan		
NA-xx-05-PL-322-150	Fifth Floor - Door Type Strategy Plan		
NA-xx-06-PL-322-150	Sixth Floor - Door Type Strategy Plan		
NA-xx-07-PL-322-150	Seventh Floor - Door Type Strategy Plan	14/11/2011	
NA-xx-08-PL-322-150	Eighth Floor - Door Type Strategy Plan	14/11/2011	
NA-xx-09-PL-322-150	Ninth Floor - Door Type Strategy Plan	14/11/2011	
NA-xx-10-PL-322-150	Tenth Floor - Door Type Strategy Plan	14/11/2011	
NA-xx-11-PL-322-150	Eleventh Floor - Door Type Strategy Plan	14/11/2011	
NA-xx-12-PL-322-150	Twelfth Floor - Door Type Strategy Plan	14/11/2011	

NA-XX-B1-PL-322-100	Basement Plan - FM & Distribution / Stores / Bed Maintenance / AGV Charging - Door Type Strategy Plan	14/11/2011	
NA-XX-B1-PL-322-101	Basement Plan - Kitchen / FM & Distribution / Stores - Door Type Strategy Plan	14/11/2011	
NA-XX-00-PL-322-100	Ground Floor Plan - NSGH Entrance Reception and Atrium Space - Door Type Strategy Plan	14/11/2011	
NA-XX-00-PL-322-101	Ground Floor Plan - NCH Rehab - Door Type Strategy Plan	14/11/2011	
NA-XX-00-PL-322-102	Ground Floor Plan - NCH Entrance and OPD - Door Type Strategy Plan	14/11/2011	
NA-XX-00-PL-322-103	Ground Floor Plan - NCH Observation Ward / Child Protection / Sanctuary - Door Type Strategy Plan	14/11/2011	
NA-XX-00-PL-322-104	Ground Floor Plan - NCH Emergency Department / Decontamination Unit - Door Type Strategy Plan	14/11/2011	
NA-XX-00-PL-322-105	Ground Floor Plan - NSGH Emergency Department - Door Type Strategy Plan	14/11/2011	
NA-XX-00-PL-322-106	Ground Floor Plan - NSGH Acute Assessment - Door Type Strategy Plan	14/11/2011	

NA-XX-00-PL-322-107	Ground Floor Plan - NSGH Radiology / Medical Illustration- Door Type Strategy Plan	14/11/2011	
NA-XX-00-PL-322-108	Ground Floor Plan - NCH Radiology - Door Type Strategy Plan	14/11/2011	
NA-XX-00-PL-322-109	Ground Floor Plan - NSGH OPD / Rehab & Therapies - Door Type Strategy Plan	14/11/2011	
NA-XX-01-PL-322-100	First Floor Plan - NSGH Restaurant, Sanctuary and Atrium Space - Door Type Strategy Plan	14/11/2011	
NA-XX-01-PL-322-101	First Floor Plan - NCH Theatres / Interventional Radiology and Radiology - Door Type Strategy Plan	14/11/2011	
NA-XX-01-PL-322-102	First Floor Plan - NCH 23 Hour Unit - Door Type Strategy Plan	14/11/2011	
NA-XX-01-PL-322-103	First Floor Plan - NCH Critical Care (PICU) / Cardiology Ward / Support / MDU and Special Feeds - Door Type Strategy Plan	14/11/2011	
NA-XX-01-PL-322-104	First Floor Plan - NSGH CCU and Critical Care (1 of 2) - Door Type Strategy Plan	14/11/2011	
NA-XX-01-PL-322-105	First Floor Plan - NSGH Critical Care (2 of 2) - Door Type Strategy Plan	14/11/2011	
NA-XX-01-PL-322-106	First Floor Plan - NSGH Stroke Ward / MDU - Door Type Strategy Plan	14/11/2011	

NA-XX-01-PL-322-107	First Floor Plan - NSGH Radiology - Door Type Strategy Plan	14/11/2011	
NA-XX-01-PL-322-108	First Floor Plan - NSGH Nuclear Medicine - Door Type Strategy Plan	14/11/2011	
NA-XX-01-PL-322-109	First Floor Plan - NSGH OPD & Pre-op Assessment - Door Type Strategy Plan	14/11/2011	
NA-XX-02-PL-322-100	Second Floor Plan - NSGH Atrium - Door Type Strategy Plan	14/11/2011	
NA-XX-02-PL-322-101	Second Floor Plan - NSGH Dermatology Ward + Plant - Door Type Strategy Plan	14/11/2011	
NA-XX-02-PL-322-102	Second Floor Plan - NCH Schiehallion Ward / Day Case Unit / Theatres and Anaesthetic Service Offices - Door Type Strategy Plan	14/11/2011	
NA-XX-02-PL-322-103	Second Floor Plan - NCH Acute Receiving Ward / Aseptic Suite - Door Type Strategy Plan	14/11/2011	
NA-XX-02-PL-322-104	Second Floor Plan - NSGH Endoscopy / Decontamination / Medical Physics / Stores - Door Type Strategy Plan	14/11/2011	
NA-XX-02-PL-322-105	Second Floor Plan - NSGH Theatres (1 of 2) + Plant - Door Type Strategy Plan	14/11/2011	
NA-XX-02-PL-322-106	Second Floor Plan - NSGH Theatres (2 of 2) + Plant - Door Type Strategy Plan	14/11/2011	

NA-XX-02-PL-322-109	Second Floor Plan - NSGH Dermatology OPD / Renal Dialysis - Door Type Strategy Plan	14/11/2011	
NA-xx-03-PL-322-100	Third Floor Plan - NSGH Atrium / Health Records / FM /Staff Change - Door Type Strategy Plan	14/11/2011	
NA-xx-03-PL-322-101	Third Floor Plan - PLANT - Door Type Strategy Plan	14/11/2011	
NA-xx-03-PL-322-102	Third Floor Plan - NCH In-Patient Ward / Medicinema - Door Type Strategy Plan	14/11/2011	
NA-xx-03-PL-322-103	Third Floor Plan - NCH In-Patient Ward / Ward Support / Renal Day Case - Door Type Strategy Plan	14/11/2011	
NA-xx-03-PL-322-105	Third Floor Plan - PLANT - Door Type Strategy Plan	14/11/2011	
NA-xx-03-PL-322-106	Third Floor Plan - PLANT - Door Type Strategy Plan	14/11/2011	
NA-xx-03-PL-322-109	Third Floor Plan - PLANT - Door Type Strategy Plan	14/11/2011	
NA-xx-04-PL-322-100	Fourth Floor Plan - NSGH Atrium + Lift Core / Generic Ward Support - Door Type Strategy Plan	14/11/2011	
NA-xx-04-PL-322-101	Fourth Floor Plan - Higher Acuity Renal Ward - Door Type Strategy Plan	14/11/2011	

NA-xx-04-PL-322-102	Fourth Floor Plan - NCH DCFP - Door Type Strategy Plan	14/11/2011	
NA-xx-04-PL-322-103	Fourth Floor Plan - NSGH Haemo-Oncology Ward - Door Type Strategy Plan	14/11/2011	
NA-xx-04-PL-322-104	Fourth Floor Plan - NSGH Renal Ward & Daycase (1 of 2) - Door Type Strategy Plan	14/11/2011	
NA-xx-04-PL-322-105	Fourth Floor Plan - NSGH Renal Ward & Daycase (2 of 2) - Door Type Strategy Plan	14/11/2011	
NA-xx-04-PL-322-106	Fourth Floor Plan - NCH Plant - Door Type Strategy Plan	14/11/2011	
NA-xx-05-PL-322-100	Fifth Floor Plan - NSGH Atrium + Lift Core / Generic Ward Support Door Type Strategy Plan	14/11/2011	
NA-xx-05-PL-322-101	Fifth Floor Plan - NSGH Generic Ward (1 of 4) - Door Type Strategy Plan	14/11/2011	
NA-xx-05-PL-322-102	Fifth Floor Plan - NSGH Generic Ward (2 of 4) - Door Type Strategy Plan	14/11/2011	
NA-xx-05-PL-322-103	Fifth Floor Plan - NSGH Generic Ward (3 of 4) - Door Type Strategy Plan	14/11/2011	
NA-xx-05-PL-322-104	Fifth Floor Plan - NSGH Generic Ward (4 of 4) - Door Type Strategy Plan	14/11/2011	

NA-xx-05-PL-322-106	Fifth Floor Plan - NCH Plant - Door Type Strategy Plan	14/11/2011	
NA-XX-06-PL-322-100	Sixth Floor Plan - NSGH Atrium, Generic Ward Support and Lift Cores: Door Type Strategy Plan		
NA-XX-06-PL-322-101	Floor Plan: NSGH Rheumatology Ward - Door Type Strategy Plan		
NA-XX-07-PL-322-100	Floor Plan: NSGH Atium, Generic ward Support and Lift Cores: Door Type Strategy Plan		
NA-XX-08-PL-322-100	Floor Plan: NSGH Atium, Generic ward Support and Lift Cores: Door Type Strategy Plan		
NA-XX-09-PL-322-100	Floor Plan: NSGH Atium, Generic ward Support and Lift Cores: Door Type Strategy Plan		
NA-XX-10-PL-322-100	Floor Plan: NSGH Atium, Generic ward Support and Lift Cores: Door Type Strategy Plan		
NA-xx-11-PL-322-100	Floor Plan: NSGH Atium, Generic ward Support and Lift Cores: Door Type Strategy Plan		
NA-XX-11-PL-322-102	Floor Plan: NSGH E.N.T Ward: Door Type Strategy Plan		
NA-XX-12-PL-322-100	Twelfth Floor Plan: NSGH Atrium and Lift Cores: Door Type Strategy Plan		

NA-XX-12-PL-322-101	Twelfth Floor Plan: Plant (1 of 4) Door Type Strategy Plan		
NA-XX-12-PL-322-102	Twelfth Floor Plan: Plan (2 of 4) Door Type Strategy Plan		
NA-XX-12-PL-322-103	Twelfth Floor Plan: Plan (3 of 4) Door Type Strategy Plan		
NA-XX-12-PL-322-104	Twelfth Floor Plan: Plant (4 of 4) Door Type Strategy Plan		
NA-XX-00-PL-322-160	Ground Floor - Door Privacy Strategy Plan		
NA-XX-01-PL-322-160	First Floor - Door Privacy Strategy Plan		
NA-XX-02-PL-322-160	Second Floor - Door Privacy Strategy Plan		
NA-xx-03-PL-322-160	Third Floor - Door Privacy Strategy Plan		
NA-xx-04-PL-322-160	Fourth Floor - Door Privacy Strategy Plan		

NA-xx-05-PL-322-160	Fifth Floor - Door Privacy Strategy Plan		
NA-xx-06-PL-322-160	Sixth Floor - Door Privacy Strategy Plan		
NA-xx-07-PL-322-160	Seventh Floor - Door Privacy Strategy Plan	13/11/2011	
NA-xx-08-PL-322-160	Eighth Floor - Door Privacy Strategy Plan	13/11/2011	
NA-xx-09-PL-322-160	Ninth Floor - Door Privacy Strategy Plan	13/11/2011	
NA-xx-10-PL-322-160	Tenth Floor - Door Privacy Strategy Plan	13/11/2011	
NA-xx-11-PL-322-160	Eleventh Floor - Door Privacy Strategy Plan	13/11/2011	
NA-xx-12-PL-322-160	Twelfth Floor - Door Privacy Strategy Plan	13/11/2011	
NA-XX-B1-PL-322-400	Basement Plan - FM & Distribution / Stores / Bed Maintenance / AGV Charging - Door Privacy Strategy Plan	13/11/2011	

NA-XX-B1-PL-322-401	Basement Plan - Kitchen / FM & Distribution / Stores - Door Privacy Strategy Plan	13/11/2011	
NA-XX-00-PL-322-400	Ground Floor Plan - NSGH Entrance Reception and Atrium Space - Door Privacy Strategy Plan	13/11/2011	
NA-XX-00-PL-322-401	Ground Floor Plan - NCH Rehab - Door Privacy Strategy Plan	13/11/2011	
NA-XX-00-PL-322-402	Ground Floor Plan - NCH Entrance and OPD - Door Privacy Strategy Plan	13/11/2011	
NA-XX-00-PL-322-403	Ground Floor Plan - NCH Observation Ward / Child Protection / Sanctuary - Door Privacy Strategy Plan	13/11/2011	
NA-XX-00-PL-322-404	Ground Floor Plan - NCH Emergency Department / Decontamination Unit - Door Privacy Strategy Plan	13/11/2011	
NA-XX-00-PL-322-405	Ground Floor Plan - NSGH Emergency Department - Door Privacy Strategy Plan	13/11/2011	
NA-XX-00-PL-322-406	Ground Floor Plan - NSGH Acute Assessment - Door Privacy Strategy Plan	13/11/2011	
NA-XX-00-PL-322-407	Ground Floor Plan - NSGH Radiology / Medical Illustration - Door Privacy Strategy Plan	13/11/2011	
NA-XX-00-PL-322-408	Ground Floor Plan - NCH Radiology - Door Privacy Strategy Plan	13/11/2011	

NA-XX-00-PL-322-409	Ground Floor Plan - NSGH OPD / Rehab & Therapies - Door Privacy Strategy Plan	13/11/2011	
NA-XX-01-PL-322-400	First Floor Plan - NSGH Restaurant, Sanctuary and Atrium Space - Door Privacy Strategy Plan	13/11/2011	
NA-XX-01-PL-322-401	First Floor Plan - NCH Theatres / Interventional Radiology and Radiology - Door Privacy Strategy Plan	13/11/2011	
NA-XX-01-PL-322-402	First Floor Plan - NCH 23 Hour Unit - Door Privacy Strategy Plan	13/11/2011	
NA-XX-01-PL-322-403	First Floor Plan - NCH Critical Care (PICU) / Cardiology Ward / Support / MDU and Special Feeds - Door Privacy Strategy Plan	13/11/2011	
NA-XX-01-PL-322-404	First Floor Plan - NSGH CCU and Critical Care (1 of 2) - Door Privacy Strategy Plan	13/11/2011	
NA-XX-01-PL-322-405	First Floor Plan - NSGH Critical Care (2 of 2) - Door Privacy Strategy Plan	13/11/2011	
NA-XX-01-PL-322-406	First Floor Plan - NSGH Stroke Ward / MDU - Door Privacy Strategy Plan	13/11/2011	
NA-XX-01-PL-322-407	First Floor Plan - NSGH Radiology - Door Privacy Strategy Plan	13/11/2011	
NA-XX-01-PL-322-408	First Floor Plan - NSGH Nuclear Medicine - Door Privacy Strategy Plan	13/11/2011	

NA-XX-01-PL-322-409	First Floor Plan - NSGH OPD & Pre-op Assessment - Door Privacy Strategy Plan	13/11/2011	
NA-XX-02-PL-322-400	Second Floor Plan - NSGH Atrium - Door Privacy Strategy Plan	13/11/2011	
NA-XX-02-PL-322-401	Second Floor Plan - NSGH Dermatology Ward + Plant - Door Privacy Strategy Plan	13/11/2011	
NA-XX-02-PL-322-402	Second Floor Plan - NCH Schiehallion Ward / Day Case Unit / Theatres and Anaesthetic Service Offices - Door Privacy Strategy Plan	13/11/2011	
NA-XX-02-PL-322-403	Second Floor Plan - NCH Acute Receiving Ward / Aseptic Suite - Door Privacy Strategy Plan	13/11/2011	
NA-XX-02-PL-322-404	Second Floor Plan - NSGH Endoscopy / Decontamination / Medical Physics / Stores - Door Privacy Strategy Plan	13/11/2011	
NA-XX-02-PL-322-405	Second Floor Plan - NSGH Theatres (1 of 2) + Plant - Door Privacy Strategy Plan	13/11/2011	
NA-XX-02-PL-322-406	Second Floor Plan - NSGH Theatres (2 of 2) + Plant - Door Privacy Strategy Plan	13/11/2011	
NA-XX-02-PL-322-409	Second Floor Plan - NSGH Dermatology OPD / Renal Dialysis - Door Privacy Strategy Plan	13/11/2011	
NA-xx-03-PL-322-400	Third Floor Plan - NSGH Atrium / Health Records / FM /Staff Change - Door Privacy Strategy Plan	13/11/2011	

NA-xx-03-PL-322-401	Third Floor Plan - PLANT - Door Privacy Strategy Plan	13/11/2011	
NA-xx-03-PL-322-402	Third Floor Plan - NCH In-Patient Ward / Medicinema - Door Privacy Strategy Plan	13/11/2011	
NA-xx-03-PL-322-403	Third Floor Plan - NCH In-Patient Ward / Ward Support / Renal Day Case - Door Privacy Strategy Plan	13/11/2011	
NA-xx-03-PL-322-405	Third Floor Plan - PLANT - Door Privacy Strategy Plan	13/11/2011	
NA-xx-03-PL-322-406	Third Floor Plan - PLANT - Door Privacy Strategy Plan	13/11/2011	
NA-xx-03-PL-322-409	Third Floor Plan - PLANT - Door Privacy Strategy Plan	13/11/2011	
NA-xx-04-PL-322-400	Fourth Floor Plan - NSGH Atrium + Lift Core / Generic Ward Support - Door Privacy Strategy Plan	13/11/2011	
NA-xx-04-PL-322-401	Fourth Floor Plan - Higher Acuity Renal Ward - Door Privacy Strategy Plan	13/11/2011	
NA-xx-04-PL-322-402	Fourth Floor Plan - NCH DCFP - Door Privacy Strategy Plan	13/11/2011	
NA-xx-04-PL-322-403	Fourth Floor Plan - NSGH Haemo-Oncology Ward - Door Privacy Strategy Plan	13/11/2011	

NA-xx-04-PL-322-404	Fourth Floor Plan - NSGH Renal Ward & Daycase (1 of 2) - Door Privacy Strategy Plan	13/11/2011	
NA-xx-04-PL-322-405	Fourth Floor Plan - NSGH Renal Ward & Daycase (2 of 2) - Door Privacy Strategy Plan	13/11/2011	
NA-xx-04-PL-322-406	Fourth Floor Plan - NCH Plant - Door Privacy Strategy Plan	13/11/2011	
NA-xx-05-PL-322-400	Fifth Floor Plan - NSGH Atrium + Lift Core / Generic Ward Support Door Privacy Strategy Plan	13/11/2011	
NA-xx-05-PL-322-401	Fifth Floor Plan - NSGH Generic Ward (1 of 4) - Door Privacy Strategy Plan	13/11/2011	
NA-xx-05-PL-322-402	Fifth Floor Plan - NSGH Generic Ward (2 of 4) - Door Privacy Strategy Plan	13/11/2011	
NA-xx-05-PL-322-403	Fifth Floor Plan - NSGH Generic Ward (3 of 4) - Door Privacy Strategy Plan	13/11/2011	
NA-xx-05-PL-322-404	Fifth Floor Plan - NSGH Generic Ward (4 of 4) - Door Privacy Strategy Plan	13/11/2011	
NA-xx-05-PL-322-406	Fifth Floor Plan - NCH Plant - Door Privacy Strategy Plan	13/11/2011	
NA-XX-06-PL-322-400	Sixth Floor Plan: NSGH Atrium Generic Ward Support and Lift Cores: Door Privacy Strategy Plan		

NA-XX-06-PL-322-401	Sixth Floor Plan: NSGH Rheumatology Ward: Door Privacy Strategy Plan		
NA-XX-07-PL-322-400	Seventh Floor Plan: NSGH Atrium, Generic Ward Support and Lift Cores: Door Privacy Strategy Plan		
NA-XX-08-PL-322-400	Eighth Floor Plan: NSGH Atrium, Generic Ward Support and Lift Cores: Door Privacy Strategy Plan		
NA-XX-09-PL-322-400	Ninth Floor Plan: NSGH Atrium, Generic Ward Support and Lift Cores: Door Privacy Strategy Plan		
NA-XX-10-PL-322-400	Tenth Floor Plan: NSGH Atrium, Generic Ward Support and Lift Cores: Door Privacy Strategy Plan		
NA-XX-11-PL-322-400	Eleventh Floor Plan: NSGH Atrium, Generic Ward Support and Lift Cores: Door Privacy Strategy Plan		
NA-XX-11-PL-322-402	Eleventh Floor Plan: NSGH E.N.T. Ward: Door Privacy Strategy Plan		
NA-XX-B1-PL-322-250	Basement - Access Control & Locking Strategy Plan		
NA-XX-00-PL-322-250	Ground Floor - Access Control & Locking Strategy Plan		

NA-XX-01-PL-322-250	First Floor - Access Control & Locking Strategy Plan		
NA-XX-02-PL-322-250	Second Floor - Access Control & Locking Strategy Plan		
NA-xx-03-PL-322-250	Third Floor - Access Control & Locking Strategy Plan		
NA-xx-04-PL-322-250	Fourth Floor - Access Control & Locking Strategy Plan		
NA-xx-05-PL-322-250	Fifth Floor - Access Control & Locking Strategy Plan		
NA-xx-06-PL-322-250	Sixth Floor - Access Control & Locking Strategy Plan		
NA-xx-07-PL-322-250	Seventh Floor - Access Control & Locking Strategy Plan	25/11/2011	
NA-xx-08-PL-322-250	Eighth Floor - Access Control & Locking Strategy Plan	25/11/2011	
NA-xx-09-PL-322-250	Ninth Floor - Access Control & Locking Strategy Plan	25/11/2011	
NA-xx-10-PL-322-250	Tenth Floor - Access Control & Locking Strategy Plan	25/11/2011	

NA-xx-11-PL-322-250	Eleventh Floor - Access Control & Locking Strategy Plan	25/11/2011	
NA-xx-12-PL-322-250	Twelfth Floor - Access Control & Locking Strategy Plan	25/11/2011	
		25/11/2011	
NA-XX-B1-PL-322-200	Basement Plan - FM & Distribution / Stores / Bed Maintenance / AGV Charging - Access Control & Locking Strategy Plan	25/11/2011	
NA-XX-B1-PL-322-201	Basement Plan - Kitchen / FM & Distribution / Stores - Access Control & Locking Strategy Plan	25/11/2011	
NA-XX-00-PL-322-200	Ground Floor Plan - NSGH Entrance Reception and Atrium Space - Access Control & Locking Strategy Plan	25/11/2011	
NA-XX-00-PL-322-201	Ground Floor Plan - NCH Rehab - Access Control & Locking Strategy Plan	25/11/2011	
NA-XX-00-PL-322-202	Ground Floor Plan - NCH Entrance and OPD - Access Control & Locking Strategy Plan	25/11/2011	
NA-XX-00-PL-322-203	Ground Floor Plan - NCH Observation Ward / Child Protection / Sanctuary - Access Control & Locking Strategy Plan	25/11/2011	
NA-XX-00-PL-322-204	Ground Floor Plan - NCH Emergency Department / Decontamination Unit - Access Control & Locking Strategy Plan	25/11/2011	

NA-XX-00-PL-322-205	Ground Floor Plan - NSGH Emergency Department - Access Control & Locking Strategy Plan	25/11/2011	
NA-XX-00-PL-322-206	Ground Floor Plan - NSGH Acute Assessment - Access Control & Locking Strategy Plan	25/11/2011	
NA-XX-00-PL-322-207	Ground Floor Plan - NSGH Radiology / Medical Illustration - Access Control & Locking Strategy Plan	25/11/2011	
NA-XX-00-PL-322-208	Ground Floor Plan - NCH Radiology - Access Control & Locking Strategy Plan	25/11/2011	
NA-XX-00-PL-322-209	Ground Floor Plan - NSGH OPD / Rehab & Therapies - Access Control & Locking Strategy Plan	25/11/2011	
NA-XX-01-PL-322-200	First Floor Plan - NSGH Restaurant, Sanctuary and Atrium Space - Access Control & Locking Strategy Plan	25/11/2011	
NA-XX-01-PL-322-201	First Floor Plan - NCH Theatres / Interventional Radiology and Radiology - Access Control & Locking Strategy Plan	25/11/2011	
NA-XX-01-PL-322-202	First Floor Plan - NCH 23 Hour Unit - Access Control & Locking Strategy Plan	25/11/2011	
NA-XX-01-PL-322-203	First Floor Plan - NCH Critical Care (PICU) / Cardiology Ward / Support / MDU and Special Feeds - Access Control & Locking Strategy Plan	25/11/2011	
NA-XX-01-PL-322-204	First Floor Plan - NSGH CCU and Critical Care (1 of 2) - Access Control & Locking Strategy Plan	25/11/2011	

NA-XX-01-PL-322-205	First Floor Plan - NSGH Critical Care (2 of 2) - Access Control & Locking Strategy Plan	25/11/2011	
NA-XX-01-PL-322-206	First Floor Plan - NSGH Stroke Ward / MDU - Access Control & Locking Strategy Plan	25/11/2011	
NA-XX-01-PL-322-207	First Floor Plan - NSGH Radiology - Access Control & Locking Strategy Plan	25/11/2011	
NA-XX-01-PL-322-208	First Floor Plan - NSGH Nuclear Medicine - Access Control & Locking Strategy Plan	25/11/2011	
NA-XX-01-PL-322-209	First Floor Plan - NSGH OPD & Pre-op Assessment - Access Control & Locking Strategy Plan	25/11/2011	
NA-XX-02-PL-322-200	Second Floor Plan - NSGH Atrium - Access Control & Locking Strategy Plan	25/11/2011	
NA-XX-02-PL-322-201	Second Floor Plan - NSGH Dermatology Ward + Plant - Access Control & Locking Strategy Plan	25/11/2011	
NA-XX-02-PL-322-202	Second Floor Plan - NCH Schiehallion Ward / Day Case Unit / Theatres and Anaesthetic Service Offices - Access Control & Locking Strategy Plan	25/11/2011	
NA-XX-02-PL-322-203	Second Floor Plan - NCH Acute Receiving Ward / Aseptic Suite - Access Control & Locking Strategy Plan	25/11/2011	
NA-XX-02-PL-322-204	Second Floor Plan - NSGH Endoscopy / Decontamination / Medical Physics / Stores - Access Control & Locking Strategy Plan	25/11/2011	

NA-XX-02-PL-322-205	Second Floor Plan - NSGH Theatres (1 of 2) + Plant - Access Control & Locking Strategy Plan	25/11/2011	
NA-XX-02-PL-322-206	Second Floor Plan - NSGH Theatres (2 of 2) + Plant - Access Control & Locking Strategy Plan	25/11/2011	
NA-XX-02-PL-322-209	Second Floor Plan - NSGH Dermatology OPD / Renal Dialysis - Access Control & Locking Strategy Plan	25/11/2011	
NA-xx-03-PL-322-200	Third Floor Plan - NSGH Atrium / Health Records / FM /Staff Change - Access Control & Locking Strategy Plan	25/11/2011	
NA-xx-03-PL-322-201	Third Floor Plan - PLANT - Access Control & Locking Strategy Plan	25/11/2011	
NA-xx-03-PL-322-202	Third Floor Plan - NCH In-Patient Ward / Medicinema - Access Control & Locking Strategy Plan	25/11/2011	
NA-xx-03-PL-322-203	Third Floor Plan - NCH In-Patient Ward / Ward Support / Renal Day Case - Access Control & Locking Strategy Plan	25/11/2011	
NA-xx-03-PL-322-205	Third Floor Plan - PLANT - Access Control & Locking Strategy Plan	25/11/2011	
NA-xx-03-PL-322-206	Third Floor Plan - PLANT - Access Control & Locking Strategy Plan	25/11/2011	
NA-xx-03-PL-322-209	Third Floor Plan - PLANT - Access Control & Locking Strategy Plan	02/12/2011	

NA-xx-04-PL-322-200	Fourth Floor Plan - NSGH Atrium + Lift Core / Generic Ward Support - Access Control & Locking Strategy Plan	25/11/2011	
NA-xx-04-PL-322-201	Fourth Floor Plan - Higher Acuity Renal Ward - Access Control & Locking Strategy Plan	25/11/2011	
NA-xx-04-PL-322-202	Fourth Floor Plan - NCH DCFP - Access Control & Locking Strategy Plan	25/11/2011	
NA-xx-04-PL-322-203	Fourth Floor Plan - NSGH Haemo-Oncology Ward - Access Control & Locking Strategy Plan	25/11/2011	
NA-xx-04-PL-322-204	Fourth Floor Plan - NSGH Renal Ward & Daycase (1 of 2) - Access Control & Locking Strategy Plan	25/11/2011	
NA-xx-04-PL-322-205	Fourth Floor Plan - NSGH Renal Ward & Daycase (2 of 2) - Access Control & Locking Strategy Plan	25/11/2011	
NA-xx-04-PL-322-206	Fourth Floor Plan - NCH Plant - Access Control & Locking Strategy Plan	25/11/2011	
NA-xx-05-PL-322-200	Fifth Floor Plan - NSGH Atrium + Lift Core / Generic Ward Support Access Control & Locking Strategy Plan	25/11/2011	
NA-xx-05-PL-322-201	Fifth Floor Plan - NSGH Generic Ward (1 of 4) - Access Control & Locking Strategy Plan	25/11/2011	
NA-xx-05-PL-322-202	Fifth Floor Plan - NSGH Generic Ward (2 of 4) - Access Control & Locking Strategy Plan	25/11/2011	

NA-xx-05-PL-322-203	Fifth Floor Plan - NSGH Generic Ward (3 of 4) - Access Control & Locking Strategy Plan	25/11/2011	
NA-xx-05-PL-322-204	Fifth Floor Plan - NSGH Generic Ward (4 of 4) - Access Control & Locking Strategy Plan	25/11/2011	
NA-xx-05-PL-322-206	Fifth Floor Plan - NCH Plant - Access Control & Locking Strategy Plan	25/11/2011	
NA-XX-B1-PL-322-350	Basement - Door Protection Strategy	09/12/2011	
NA-XX-00-PL-322-350	Ground Floor - Door Protection Strategy	09/12/2011	
NA-XX-01-PL-322-350	First Floor - Door Protection Strategy	09/12/2011	
NA-XX-02-PL-322-350	Second Floor - Door Protection Strategy	09/12/2011	
NA-xx-03-PL-322-350	Third Floor - Door Protection Strategy	09/12/2011	
NA-xx-04-PL-322-350	Fourth Floor - Door Protection Strategy	09/12/2011	

NA-xx-05-PL-322-350	Fifth Floor - Door Protection Strategy	09/12/2011	
NA-xx-06-PL-322-350	Sixth Floor - Door Protection Strategy	09/12/2011	
NA-xx-07-PL-322-350	Seventh Floor - Door Protection Strategy	09/12/2011	
NA-xx-08-PL-322-350	Eighth Floor - Door Protection Strategy	09/12/2011	
NA-xx-09-PL-322-350	Ninth Floor - Door Protection Strategy	09/12/2011	
NA-xx-10-PL-322-350	Tenth Floor - Door Protection Strategy	09/12/2011	
NA-xx-11-PL-322-350	Eleventh Floor - Door Protection Strategy	09/12/2011	
NA-xx-12-PL-322-350	Twelfth Floor - Door Protection Strategy	09/12/2011	
		09/12/2011	
NA-XX-B1-PL-322-300	Basement Plan - FM & Distribution / Stores / Bed Maintenance / AGV Charging - Door Protection Strategy	09/12/2011	

NA-XX-B1-PL-322-301	Basement Plan - Kitchen / FM & Distribution / Stores - Door Protection Strategy	09/12/2011	
NA-XX-00-PL-322-300	Ground Floor Plan - NSGH Entrance Reception and Atrium Space - Door Protection Strategy	09/12/2011	
NA-XX-00-PL-322-301	Ground Floor Plan - NCH Rehab - Door Protection Strategy	09/12/2011	
NA-XX-00-PL-322-302	Ground Floor Plan - NCH Entrance and OPD - Door Protection Strategy	09/12/2011	
NA-XX-00-PL-322-303	Ground Floor Plan - NCH Observation Ward / Child Protection / Sanctuary - Door Protection Strategy	09/12/2011	
NA-XX-00-PL-322-304	Ground Floor Plan - NCH Emergency Department / Decontamination Unit - Door Protection Strategy	09/12/2011	
NA-XX-00-PL-322-305	Ground Floor Plan - NSGH Emergency Department - Door Protection Strategy	09/12/2011	
NA-XX-00-PL-322-306	Ground Floor Plan - NSGH Acute Assessment - Door Protection Strategy	09/12/2011	
NA-XX-00-PL-322-307	Ground Floor Plan - NSGH Radiology / Medical Illustration - Door Protection Strategy	09/12/2011	
NA-XX-00-PL-322-308	Ground Floor Plan - NCH Radiology - Door Protection Strategy	09/12/2011	

NA-XX-00-PL-322-309	Ground Floor Plan - NSGH OPD / Rehab & Therapies - Door Protection Strategy	09/12/2011	
NA-XX-01-PL-322-300	First Floor Plan - NSGH Restaurant, Sanctuary and Atrium Space - Door Protection Strategy	09/12/2011	
NA-XX-01-PL-322-301	First Floor Plan - NCH Theatres / Interventional Radiology and Radiology - Door Protection Strategy	09/12/2011	
NA-XX-01-PL-322-302	First Floor Plan - NCH 23 Hour Unit - Door Protection Strategy	09/12/2011	
NA-XX-01-PL-322-303	First Floor Plan - NCH Critical Care (PICU) / Cardiology Ward / Support / MDU and Special Feeds - Door Protection Strategy	09/12/2011	
NA-XX-01-PL-322-304	First Floor Plan - NSGH CCU and Critical Care (1 of 2) - Door Protection Strategy	09/12/2011	
NA-XX-01-PL-322-305	First Floor Plan - NSGH Critical Care (2 of 2) - Door Protection Strategy	09/12/2011	
NA-XX-01-PL-322-306	First Floor Plan - NSGH Stroke Ward / MDU - Door Protection Strategy	09/12/2011	
NA-XX-01-PL-322-307	First Floor Plan - NSGH Radiology - Door Protection Strategy	09/12/2011	
NA-XX-01-PL-322-308	First Floor Plan - NSGH Nuclear Medicine - Door Protection Strategy	09/12/2011	

NA-XX-01-PL-322-309	First Floor Plan - NSGH OPD & Pre-op Assessment - Door Protection Strategy	09/12/2011	
NA-XX-02-PL-322-300	Second Floor Plan - NSGH Atrium - Door Protection Strategy	09/12/2011	
NA-XX-02-PL-322-301	Second Floor Plan - NSGH Dermatology Ward + Plant - Door Protection Strategy	09/12/2011	
NA-XX-02-PL-322-302	Second Floor Plan - NCH Schiehallion Ward / Day Case Unit / Theatres and Anaesthetic Service Offices - Door Protection Strategy	09/12/2011	
NA-XX-02-PL-322-303	Second Floor Plan - NCH Acute Receiving Ward / Aseptic Suite - Door Protection Strategy	09/12/2011	
NA-XX-02-PL-322-304	Second Floor Plan - NSGH Endoscopy / Decontamination / Medical Physics / Stores - Door Protection Strategy	09/12/2011	
NA-XX-02-PL-322-305	Second Floor Plan - NSGH Theatres (1 of 2) + Plant - Door Protection Strategy	09/12/2011	
NA-XX-02-PL-322-306	Second Floor Plan - NSGH Theatres (2 of 2) + Plant - Door Protection Strategy	09/12/2011	
NA-XX-02-PL-322-309	Second Floor Plan - NSGH Dermatology OPD / Renal Dialysis - Door Protection Strategy	09/12/2011	
NA-xx-03-PL-322-300	Third Floor Plan - NSGH Atrium / Health Records / FM /Staff Change - Door Protection Strategy	09/12/2011	

NA-xx-03-PL-322-301	Third Floor Plan - PLANT - Door Protection Strategy	09/12/2011	
NA-xx-03-PL-322-302	Third Floor Plan - NCH In-Patient Ward / Medicinema - Door Protection Strategy	09/12/2011	
NA-xx-03-PL-322-303	Third Floor Plan - NCH In-Patient Ward / Ward Support / Renal Day Case - Door Protection Strategy	09/12/2011	
NA-xx-03-PL-322-305	Third Floor Plan - PLANT - Door Protection Strategy	09/12/2011	
NA-xx-03-PL-322-306	Third Floor Plan - PLANT - Door Protection Strategy	09/12/2011	
NA-xx-03-PL-322-309	Third Floor Plan - PLANT - Door Protection Strategy	09/12/2011	
NA-xx-04-PL-322-300	Fourth Floor Plan - NSGH Atrium + Lift Core / Generic Ward Support - Door Protection Strategy	09/12/2011	
NA-xx-04-PL-322-301	Fourth Floor Plan - Higher Acuity Renal Ward - Door Protection Strategy	09/12/2011	
NA-xx-04-PL-322-302	Fourth Floor Plan - NCH DCFP - Door Protection Strategy	09/12/2011	
NA-xx-04-PL-322-303	Fourth Floor Plan - NSGH Haemo-Oncology Ward - Door Protection Strategy	09/12/2011	

NA-xx-04-PL-322-304	Fourth Floor Plan - NSGH Renal Ward & Daycase (1 of 2) - Door Protection Strategy	09/12/2011	
NA-xx-04-PL-322-305	Fourth Floor Plan - NSGH Renal Ward & Daycase (2 of 2) - Door Protection Strategy	09/12/2011	
NA-xx-04-PL-322-306	Fourth Floor Plan - NCH Plant - Door Protection Strategy	09/12/2011	
NA-xx-05-PL-322-300	Fifth Floor Plan - NSGH Atrium + Lift Core / Generic Ward Support Door Protection Strategy	09/12/2011	
NA-xx-05-PL-322-301	Fifth Floor Plan - NSGH Generic Ward (1 of 4) - Door Protection Strategy	09/12/2011	
NA-xx-05-PL-322-302	Fifth Floor Plan - NSGH Generic Ward (2 of 4) - Door Protection Strategy	09/12/2011	
NA-xx-05-PL-322-303	Fifth Floor Plan - NSGH Generic Ward (3 of 4) - Door Protection Strategy	09/12/2011	
NA-xx-05-PL-322-304	Fifth Floor Plan - NSGH Generic Ward (4 of 4) - Door Protection Strategy	09/12/2011	
NA-xx-05-PL-322-306	Fifth Floor Plan - NCH Plant - Door Protection Strategy	09/12/2011	
NA-XX-06-PL-322-300	Sixth Floor Plan: Atrium, Generic Ward Support and Lift Core, Door Protection Strategy Plan		

NA-XX-06-PL-322-301	Sixth Floor Plan, NSGH Rheumatology Ward, Door Protection Strategy Plan		
NA-XX-07-PL-322-300	Seventh Floor Plan: NSGH Atrium, Generic Ward Support and Lift Cores, Door Protection Strategy Plan		
NA-XX-08-PL-322-300	Eighth Floor Plan: NSGH Atrium, Generic Ward Support and Lift Cores, Door Protection Strategy Plan		
NA-XX-09-PL-322-300	Ninth Floor Plan: NSGH Atrium, Generic Ward Support and Lift Cores, Door Protection Strategy Plan		
NA-XX-10-PL-322-300	Tenth Floor Plan: NSGH Atrium, Generic Ward Support and Lift Cores, Door Protection Strategy Plan		
NA-XX-11-PL-322-300	Eleventh Floor Plan: NSGH Atrium, Generic Ward Support and Lift Cores, Door Protection Strategy		
NA-XX-11-PL-322-302	Eleventh Floor Plan: NSGH E.N.T. Ward Door Protection Strategy Plan		
NA-XX-12-PL-322-300	Twelfth Floor Plan: NSGH Atrium and Lift Cores Door Protection Strategy Plan		
NA-XX-12-PL-322-301	Twelfth Floor Plan: Plant (1 of 4) Door Protection Strategy Plan		
NA-XX-12-PL-322-302	Twelfth Floor Plan: Plant (2 of 4) Door Protection Strategy Plan		

NA-XX-12-PL-322-303	Twelfth Floor Plan: Plant (3 of 4) Door Protection Strategy Plan		
NA-XX-12-PL-322-304	Twelfth Floor Plan: Plant (4 of 4) Door Protection Strategy Plan		
NA-XX-00-PL-322-500	Ground floor plan - Door types strategy plan		
NA-XX-00-PL-322-501	Ground floor plan - Door types strategy plan		
NA-XX-00-PL-322-502	Ground Floor Plan - Door types, Timber Galzed screens & Tertiary Glazing Strategy Plan		
NA-XX-00-PL-322-503	Ground Floor Plan - Door types, Timber Galzed screens & Tertiary Glazing Strategy Plan		
NA-XX-00-PL-322-504	Ground floor plan - Door types strategy plan		
NA-XX-00-PL-322-505	Ground Floor Plan - Door types, Timber Galzed screens & Tertiary Glazing Strategy Plan		
NA-XX-00-PL-322-506	Ground Floor Plan - Door types, Timber Galzed screens & Tertiary Glazing Strategy Plan		

NA-XX-00-PL-322-507	Ground Floor Plan - Door types, Timber Galzed screens & Tertiary Glazing Strategy Plan		
NA-XX-00-PL-322-508	Ground Floor Plan - Door types, Timber Galzed screens & Tertiary Glazing Strategy Plan		
NA-XX-00-PL-322-509	Ground floor plan - Door types strategy plan		
NA-XX-01-PL-322-500	First floor plan - Door types strategy plan		
NA-XX-01-PL-322-501	First Floor Plan - Door types, Timber Galzed screens & Tertiary Glazing Strategy Plan		
NA-XX-01-PL-322-502	First Floor Plan - Door types, Timber Galzed screens & Tertiary Glazing Strategy Plan		
NA-XX-01-PL-322-503	First floor plan - Door types strategy plan		
NA-XX-01-PL-322-504	First floor plan - Door types strategy plan		
NA-XX-01-PL-322-505	First Floor Plan - Door types, Timber Galzed screens & Tertiary Glazing Strategy Plan		
NA-XX-01-PL-322-506	First Floor Plan - Door types, Timber Galzed screens & Tertiary Glazing Strategy Plan		

NA-XX-01-PL-322-507	First Floor Plan - Door types, Timber Galzed screens & Tertiary Glazing Strategy Plan		
NA-XX-01-PL-322-508	First Floor Plan - Door types, Timber Galzed screens & Tertiary Glazing Strategy Plan		
NA-XX-01-PL-322-509	First floor plan - Door types strategy plan		
NA-XX-02-PL-322-500	Second floor plan - Door types strategy plan		
NA-XX-02-PL-322-501	Second floor plan - Door types strategy plan		
NA-XX-02-PL-322-502	Second floor plan - Door types strategy plan		
NA-XX-02-PL-322-503	Second Floor Plan - Door types, Timber Galzed screens & Tertiary Glazing Strategy Plan		
NA-XX-02-PL-322-504	Second Floor Plan - Door types, Timber Galzed screens & Tertiary Glazing Strategy Plan		
NA-XX-02-PL-322-505	Second Floor Plan - Door types, Timber Galzed screens & Tertiary Glazing Strategy Plan		
NA-XX-02-PL-322-506	Second Floor Plan - Door types, Timber Galzed screens & Tertiary Glazing Strategy Plan		

NA-XX-02-PL-322-507	Second Floor Plan - Door types, Timber Galzed screens & Tertiary Glazing Strategy Plan		
NA-XX-02-PL-322-508	Second Floor Plan - Door types, Timber Galzed screens & Tertiary Glazing Strategy Plan		
NA-XX-02-PL-322-509	Second floor plan - Door types strategy plan		
NA-XX-03-PL-322-500	Third floor plan - Door types strategy plan		
NA-XX-03-PL-322-501	Third Floor Plan - Door types, Timber Galzed screens & Tertiary Glazing Strategy Plan		
NA-XX-03-PL-322-502	Third Floor Plan - Door types, Timber Galzed screens & Tertiary Glazing Strategy Plan		
NA-XX-03-PL-322-503	Third Floor Plan - Door types, Timber Galzed screens & Tertiary Glazing Strategy Plan		
NA-XX-03-PL-322-505	Third floor plan - Door types strategy plan		
NA-XX-03-PL-322-506	Third Floor Plan - Door types, Timber Galzed screens & Tertiary Glazing Strategy Plan		
NA-XX-03-PL-322-509	Third Floor Plan - Door types, Timber Galzed screens & Tertiary Glazing Strategy Plan		

NA-XX-04-PL-322-500	Fourth Floor Plan - Door types, Timber Galzed screens & Tertiary Glazing Strategy Plan		
NA-XX-04-PL-322-501	Fourth Floor Plan - Door types, Timber Galzed screens & Tertiary Glazing Strategy Plan		
NA-XX-04-PL-322-502	Fourth Floor Plan - Door types, Timber Galzed screens & Tertiary Glazing Strategy Plan		
NA-XX-04-PL-322-503	Fourth Floor Plan - Door types, Timber Galzed screens & Tertiary Glazing Strategy Plan		
NA-XX-04-PL-322-507	Fourth Floor Plan Door Typed Strategy Plan		
NA-XX-04-PL-322-508	Fourth Floor Plan Door Types, Glazed Screens & Tertiary Glazing Strategy Plan		
NA-XX-04-PL-322-509	Fourth Floor Plan - Door types, Timber Galzed screens & Tertiary Glazing Strategy Plan		
NA-XX-05-PL-322-500	Fifth Floor Plan - Door types, Timber Galzed screens & Tertiary Glazing Strategy Plan		
NA-XX-05-PL-322-501	Fifth Floor Plan - Door types, Timber Galzed screens & Tertiary Glazing Strategy Plan		
NA-XX-05-PL-322-502	Fifth Floor Plan Door Typed Strategy Plan		

NA-XX-05-PL-322-507	Fifth Floor Plan - Door types, Timber Galzed screens & Tertiary Glazing Strategy Plan		
NA-XX-05-PL-322-508	Fifth Floor Plan - Door types, Timber Galzed screens & Tertiary Glazing Strategy Plan		
NA-XX-05-PL-322-509	Fifth Floor Plan - Door types, Timber Galzed screens & Tertiary Glazing Strategy Plan		
NA-XX-06-PL-322-500	Sixth Floor Plan - Door types, Timber Galzed screens & Tertiary Glazing Strategy Plan		
NA-XX-06-PL-322-501	Sixth Floor Plan - Door types, Timber Galzed screens & Tertiary Glazing Strategy Plan		
NA-XX-06-PL-322-507	Sixth Floor Plan - Door types, Timber Galzed screens & Tertiary Glazing Strategy Plan		
NA-XX-06-PL-322-508	Sixth Floor Plan - Door types, Timber Galzed screens & Tertiary Glazing Strategy Plan		
NA-XX-06-PL-322-509	Sixth Floor Plan - Door types, Timber Galzed screens & Tertiary Glazing Strategy Plan		
NA-XX-07-PL-322-500	Seventh Floor Plan - Door types, Timber Galzed screens & Tertiary Glazing Strategy Plan		
NA-XX-07-PL-322-501	Seventh Floor Plan - Door types, Timber Galzed screens & Tertiary Glazing Strategy Plan		

NA-XX-07-PL-322-507	Seventh Floor Plan - Door types, Timber Galzed screens & Tertiary Glazing Strategy Plan		
NA-XX-07-PL-322-508	Seventh Floor Plan - Door types, Timber Galzed screens & Tertiary Glazing Strategy Plan		
NA-XX-07-PL-322-509	Seventh Floor Plan - Door types, Timber Galzed screens & Tertiary Glazing Strategy Plan		
NA-XX-08-PL-322-500	Eighth Floor Plan - Door types, Timber Galzed screens & Tertiary Glazing Strategy Plan		
NA-XX-08-PL-322-501	Eighth Floor Plan - Door types, Timber Galzed screens & Tertiary Glazing Strategy Plan		
NA-XX-08-PL-322-507	Eighth Floor Plan - Door types, Timber Galzed screens & Tertiary Glazing Strategy Plan		
NA-XX-08-PL-322-508	Eighth Floor Plan - Door types, Timber Galzed screens & Tertiary Glazing Strategy Plan		
NA-XX-08-PL-322-509	Eighth Floor Plan - Door types, Timber Galzed screens & Tertiary Glazing Strategy Plan		
NA-XX-09-PL-322-500	Ninth Floor Plan - Door types, Timber Galzed screens & Tertiary Glazing Strategy Plan		
NA-XX-09-PL-322-501	Ninth Floor Plan - Door types, Timber Galzed screens & Tertiary Glazing Strategy Plan		

NA-XX-09-PL-322-507	Ninth Floor Plan - Door types, Timber Galzed screens & Tertiary Glazing Strategy Plan		
NA-XX-09-PL-322-508	Ninth Floor Plan - Door types, Timber Galzed screens & Tertiary Glazing Strategy Plan		
NA-XX-09-PL-322-509	Ninth Floor Plan - Door types, Timber Galzed screens & Tertiary Glazing Strategy Plan		
NA-XX-10-PL-322-500	Tenth Floor Plan - Door types, Timber Galzed screens & Tertiary Glazing Strategy Plan		
NA-XX-10-PL-322-501	Tenth Floor Plan - Door types, Timber Galzed screens & Tertiary Glazing Strategy Plan		
NA-XX-10-PL-322-507	Tenth Floor Plan - Door types, Timber Galzed screens & Tertiary Glazing Strategy Plan		
NA-XX-10-PL-322-508	Tenth Floor Plan - Door types, Timber Galzed screens & Tertiary Glazing Strategy Plan		
NA-XX-10-PL-322-509	Tenth Floor Plan - Door types, Timber Galzed screens & Tertiary Glazing Strategy Plan		
NA-XX-11-PL-322-500	Eleventh Floor Plan - Door types, Timber Galzed screens & Tertiary Glazing Strategy Plan		
NA-XX-11-PL-322-501	Eleventh Floor Plan - Door types, Timber Galzed screens & Tertiary Glazing Strategy Plan		

NA-XX-11-PL-322-507	Eleventh Floor Plan - Door types, Timber Galzed screens & Tertiary Glazing Strategy Plan		
NA-XX-11-PL-322-508	Eleventh Floor Plan - Door types, Timber Galzed screens & Tertiary Glazing Strategy Plan		
NA-XX-11-PL-322-509	Eleventh Floor Plan - Door types, Timber Galzed screens & Tertiary Glazing Strategy Plan		
NA-XX-12-PL-322-500	Twelfth Floor Plan - Door types Strategy Plan		
NA-XX-12-PL-322-508	Twelfth Floor Plan - Door types Strategy Plan		
NA-XX-B1-PL-322-500	Basement Floor Plan - Door types Strategy Plan		
NA-XX-B1-PL-322-502	Basement Floor Plan - Door types Strategy Plan		
NA-XX-B1-PL-322-503	Basement Floor Plan - Door types Strategy Plan		
NA-XX-B1-PL-322-505	Basement Floor Plan - Door types Strategy Plan		

TDS-XX-XX-SH-322-021	SSG Master Lock Schedule		03/10/2013
tbc	tbc		

Submission
1st Submission

[illegible]

		App K Date			App K Status
		App K Date			App K Status
		App K Date			App K Status
		App K Date			App K Status
		App K Date			App K Status
		App K Date			App K Status

[illegible]

[illegible]

[illegible]

[illegible]

[illegible]

[illegible]

[illegible]

		App K Date			App K Status
		App K Date			App K Status
		App K Date			App K Status
		App K Date			App K Status
		App K Date			App K Status

		App K Date			App K Status
		App K Date			App K Status
	21/11/2011				
	21/11/2011				
	21/11/2011				
	21/11/2011				
	21/11/2011				
	21/11/2011				
	21/11/2011				

[illegible]

[illegible]

[illegible]

[illegible]

	21/11/2011				
	21/11/2011				
		App K Date			App K Status
		App K Date			App K Status

		App K Date			App K Status
		App K Date			App K Status
		App K Date			App K Status
		App K Date			App K Status
		App K Date			App K Status
		App K Date			App K Status
	02/12/2011				
	02/12/2011				
	02/12/2011				
	02/12/2011				

[illegible]

[illegible]

[illegible]

	02/12/2011				
	02/12/2011				
	16/12/2011				

[illegible]

[illegible]

[illegible]


[illegible]

[illegible]

[illegible]

[illegible]

	16/12/2011				
	16/12/2011				
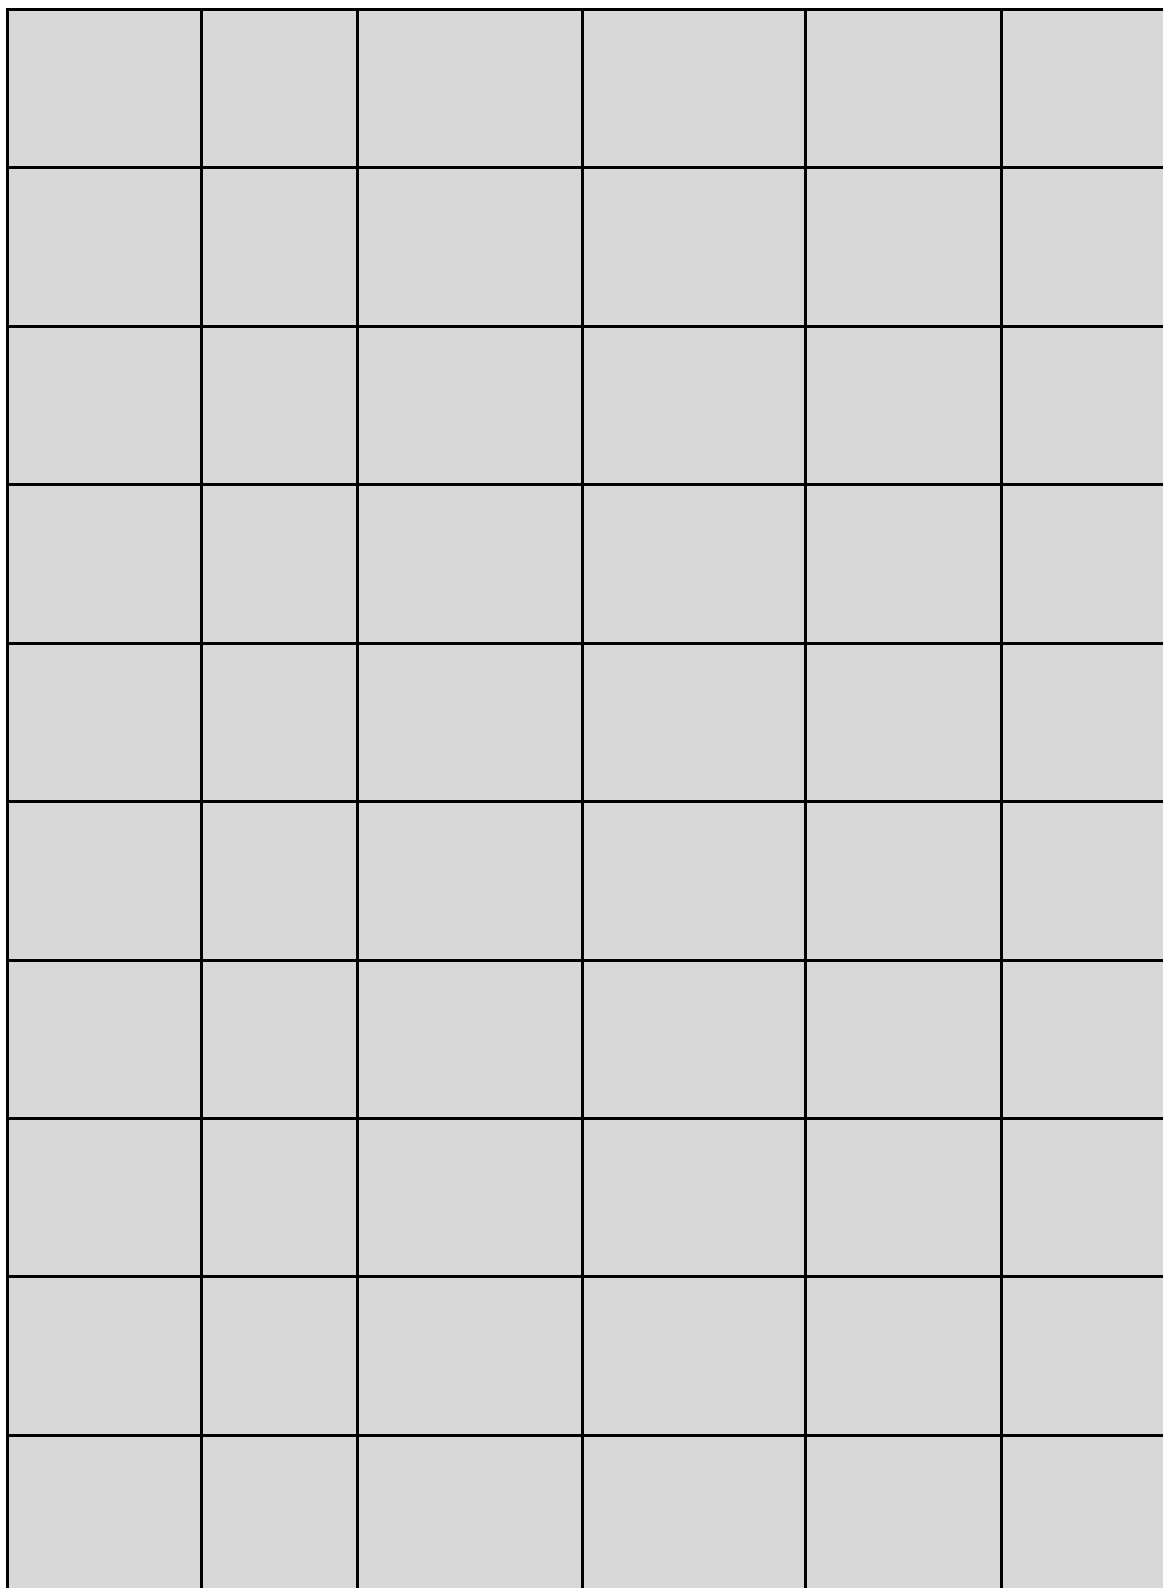



[illegible]


[illegible]


[illegible]

[illegible]

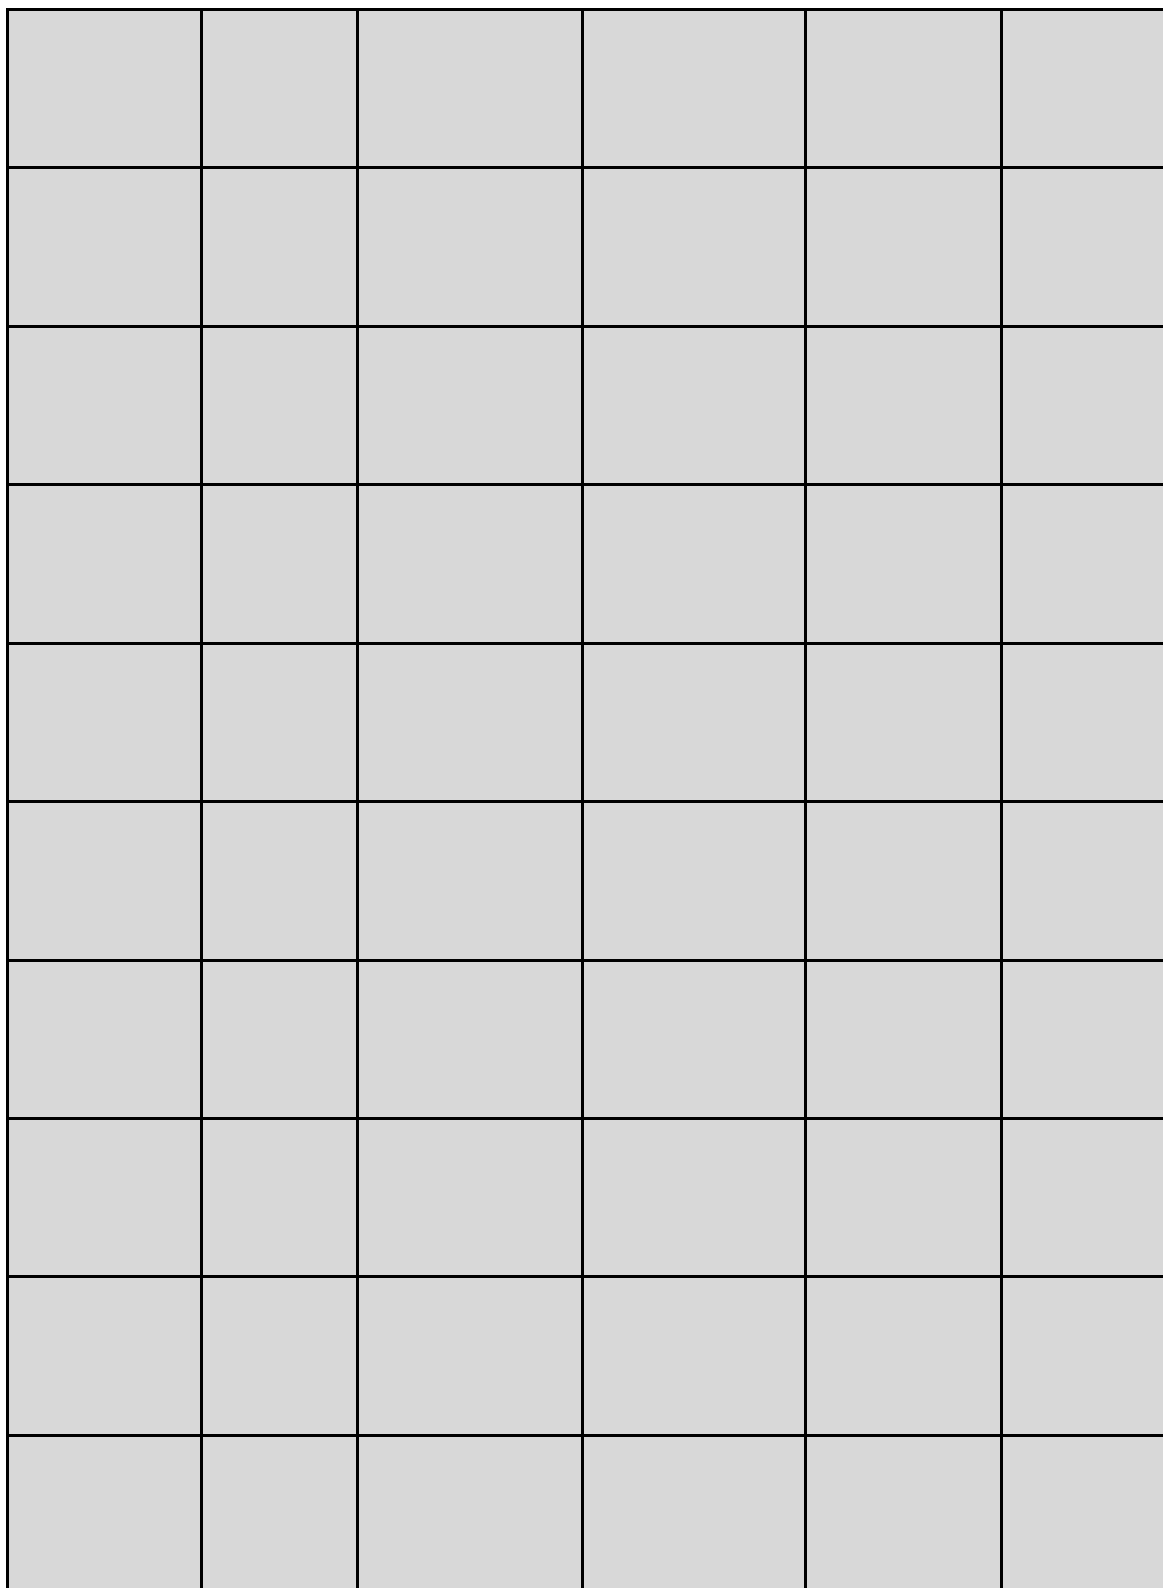

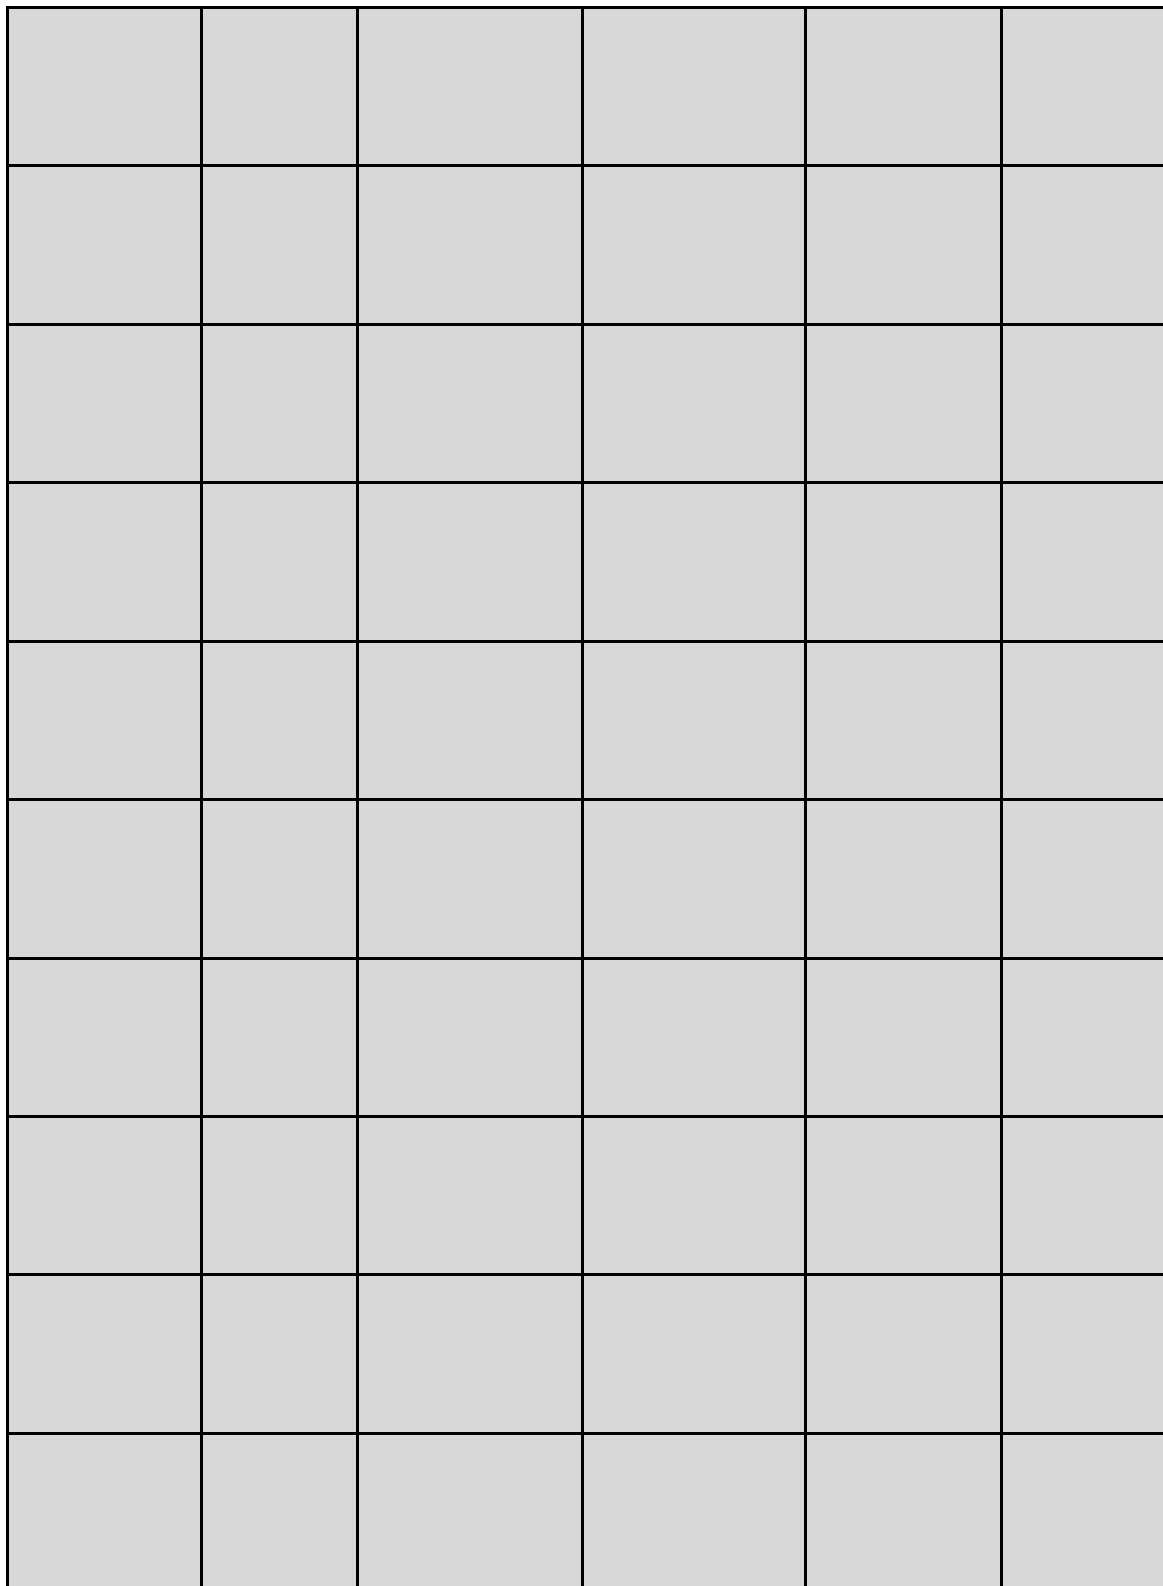

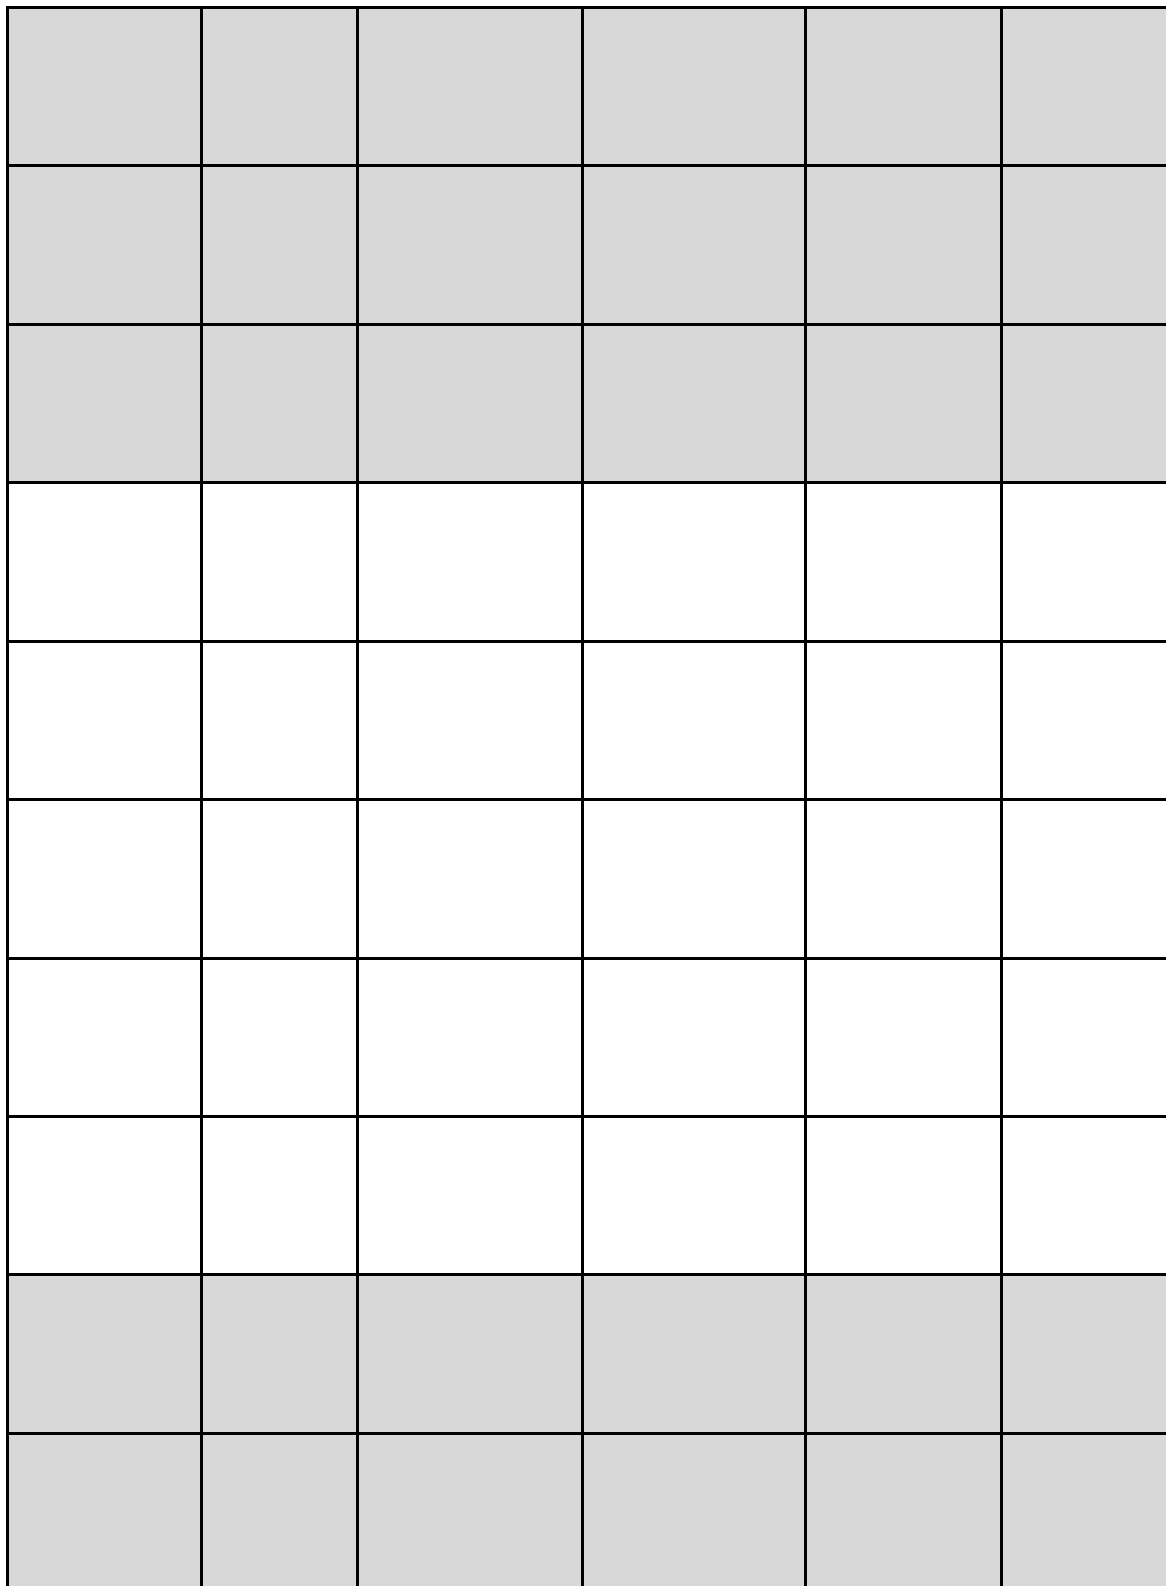

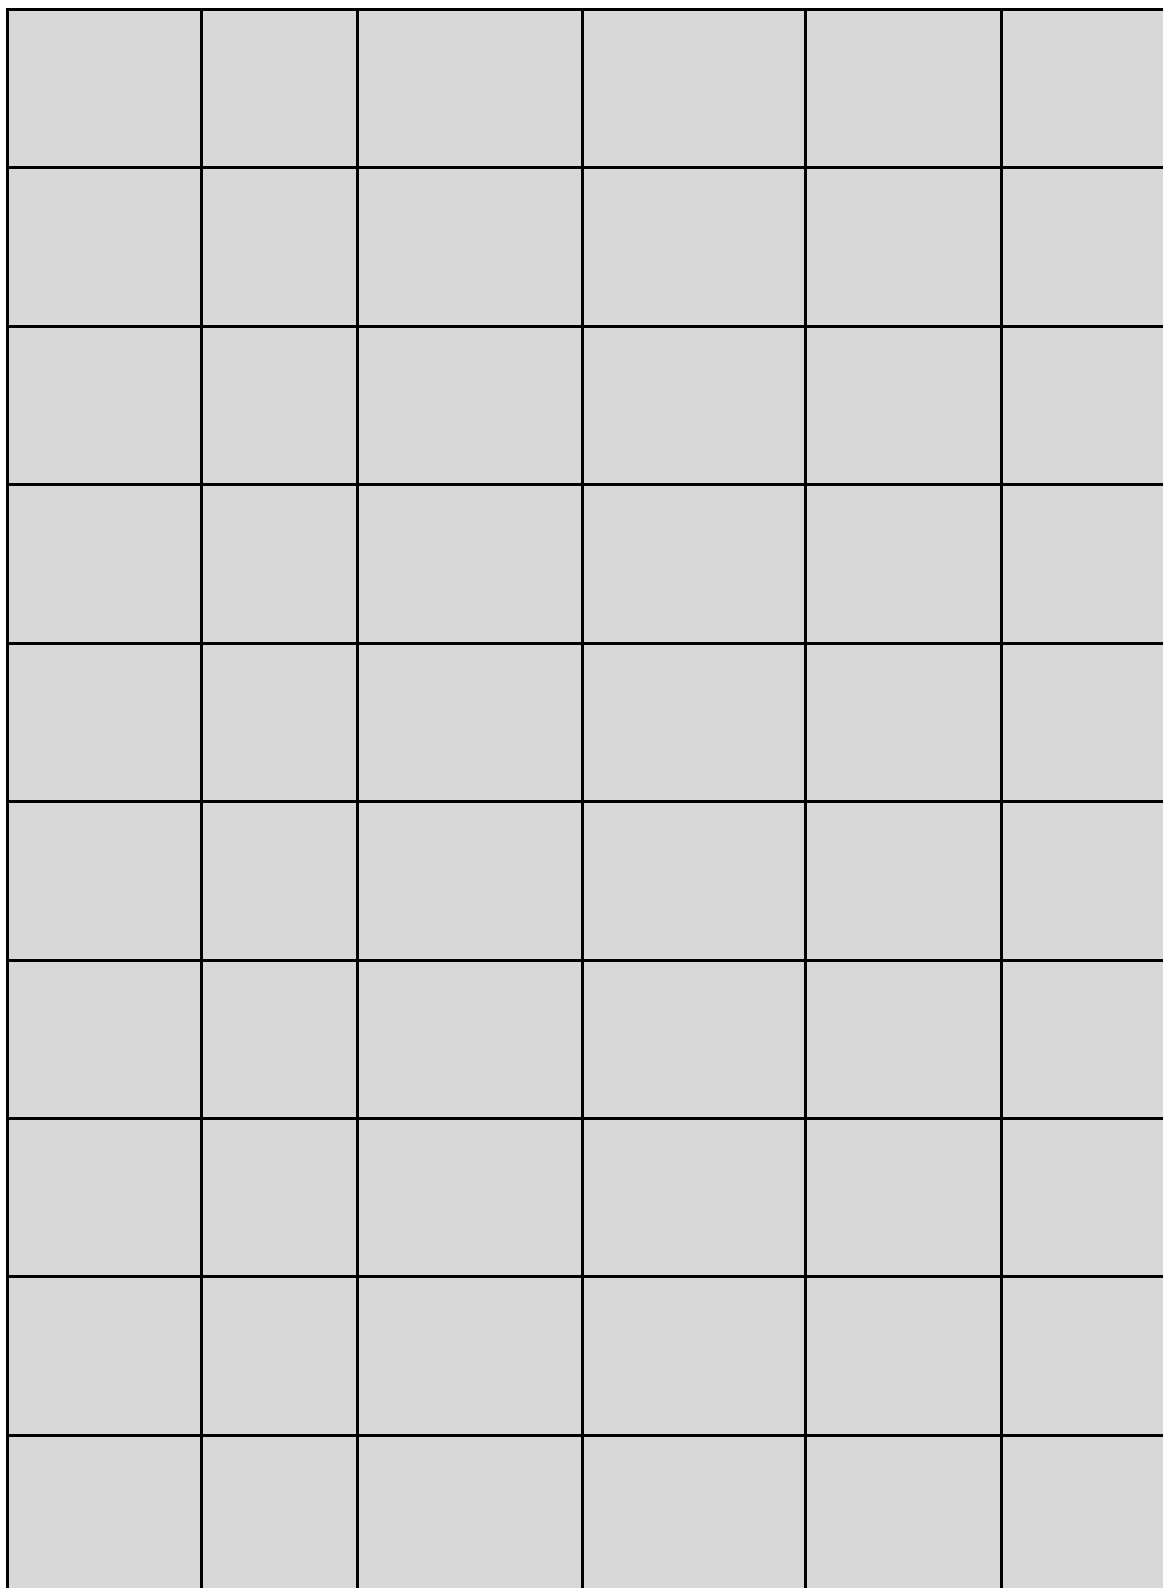

[illegible]

4		BMCE-TRANSMIT- 018042 11/10/2013	02/11/2013	28/10/2013	B

Drawing Information

	2nd Submission					
Date returned to Consultant	Date Required from Consultant	Date Submitted by Consultant	Document Revision	Planned Date to be Submitted to Board	Date Submitted to Board	BMCE Transmittal No
	30/04/2012					
	30/04/2012					

	02/12/2011	06/12/2011	5	16/12/2011	14/12/2011	BMCE-TRANSMIT-007119
	02/12/2011	06/12/2011	5	16/12/2011	14/12/2011	BMCE-TRANSMIT-007119
		06/12/2011	3		14/12/2011	BMCE-TRANSMIT-007119
		06/12/2011	1		14/12/2011	BMCE-TRANSMIT-007119
		06/12/2011	1		14/12/2011	BMCE-TRANSMIT-007119
	02/12/2011	06/12/2011	5	16/12/2011	14/12/2011 16/02/2012	BMCE-TRANSMIT-007119 resubmitted BMCE-TRANSMIT-002586
	02/12/2011	06/12/2011	6	16/12/2011	14/12/2011 16/02/2012	BMCE-TRANSMIT-007119 resubmitted BMCE-TRANSMIT-002586
	02/12/2011	06/12/2011	6	16/12/2011	14/12/2011 16/02/2012	BMCE-TRANSMIT-007119 resubmitted BMCE-TRANSMIT-002586
	02/12/2011	06/12/2011	5	16/12/2011	14/12/2011 16/02/2012	BMCE-TRANSMIT-007119 resubmitted BMCE-TRANSMIT-002586

[illegible]

[illegible]

[illegible]

[illegible]

[illegible]

[illegible]

[illegible]

		06/12/2011	2		14/12/2011 16/02/2012	BMCE-TRANSMIT-007119 resubmitted BMCE-TRANSMIT-002586
		06/12/2011	2		14/12/2011 16/02/2012	BMCE-TRANSMIT-007119 resubmitted BMCE-TRANSMIT-002586
		06/12/2011	2		14/12/2011 16/02/2012	BMCE-TRANSMIT-007119 resubmitted BMCE-TRANSMIT-002586
		06/12/2011	2		14/12/2011 16/02/2012	BMCE-TRANSMIT-007119 resubmitted BMCE-TRANSMIT-002586
	02/12/2011	02/12/2011	4 5	16/12/2011	06/12/2011 13/12/2011	BMCE-TRANSMIT-006994 BMCE-TRANSMIT-007100
	02/12/2011	02/12/2011	4	16/12/2011	06/12/2011	BMCE-TRANSMIT-006994
	02/12/2011	02/12/2011	4	16/12/2011	06/12/2011	BMCE-TRANSMIT-006994
	02/12/2011	02/12/2011	4	16/12/2011	06/12/2011	BMCE-TRANSMIT-006994
	02/12/2011	02/12/2011	4	16/12/2011	06/12/2011	BMCE-TRANSMIT-006994

	02/12/2011	02/12/2011	4	16/12/2011	06/12/2011	BMCE-TRANSMIT-006994
	02/12/2011	02/12/2011	4	16/12/2011	06/12/2011	BMCE-TRANSMIT-006994
	02/12/2011	02/12/2011	2	16/12/2011	06/12/2011	BMCE-TRANSMIT-006994
	02/12/2011	02/12/2011	2	16/12/2011	06/12/2011	BMCE-TRANSMIT-006994
	02/12/2011	02/12/2011	2	16/12/2011	06/12/2011	BMCE-TRANSMIT-006994
	02/12/2011	02/12/2011	2	16/12/2011	06/12/2011	BMCE-TRANSMIT-006994
	02/12/2011	02/12/2011	2	16/12/2011	06/12/2011	BMCE-TRANSMIT-006994
	02/12/2011			16/12/2011		
	02/12/2011			16/12/2011		

[illegible]

[illegible]

[illegible]

[illegible]

	02/12/2011	02/12/2011	2	16/12/2011	06/12/2011	BMCE-TRANSMIT-006994
	02/12/2011	02/12/2011	2	16/12/2011	06/12/2011	BMCE-TRANSMIT-006994
		02/12/2011	2		06/12/2011	BMCE-TRANSMIT-006994

		02/12/2011	2		06/12/2011	BMCE-TRANSMIT-006994
	02/12/2011	11/05/2012	5	16/12/2011	24/07/2012	BMCE-TRANSMIT-008786
	02/12/2011	07/12/2011	8	16/12/2011	13/12/2011	BMCE-TRANSMIT-007099

	02/12/2011	07/12/2011	8	16/12/2011	13/12/2011	BMCE-TRANSMIT-007099
	02/12/2011	07/12/2011	8	16/12/2011	13/12/2011	BMCE-TRANSMIT-007099
	02/12/2011	07/12/2011	8	16/12/2011	13/12/2011	BMCE-TRANSMIT-007099
	02/12/2011	07/12/2011	8	16/12/2011	13/12/2011	BMCE-TRANSMIT-007099
	02/12/2011	07/12/2011	8	16/12/2011	13/12/2011	BMCE-TRANSMIT-007099
	02/12/2011	07/12/2011	8	16/12/2011	13/12/2011	BMCE-TRANSMIT-007099
	02/12/2011	07/12/2011	5	16/12/2011	13/12/2011	BMCE-TRANSMIT-007099
	02/12/2011	07/12/2011	5	16/12/2011	13/12/2011	BMCE-TRANSMIT-007099
	02/12/2011	07/12/2011	5	16/12/2011	13/12/2011	BMCE-TRANSMIT-007099
	02/12/2011	07/12/2011	5	16/12/2011	13/12/2011	BMCE-TRANSMIT-007099

[illegible]

[illegible]

[illegible]

[illegible]

[illegible]

[illegible]

	02/12/2011	06/12/2011	2	16/12/2011	13/12/2011	BMCE-TRANSMIT-007098
	02/12/2011	06/12/2011	2	16/12/2011	13/12/2011	BMCE-TRANSMIT-007098
[illegible]

[illegible]

[illegible]


[illegible]

	02/12/2011	06/12/2011	2	16/12/2011	13/12/2011	BMCE-TRANSMIT-007098
	02/12/2011	06/12/2011	2	16/12/2011	13/12/2011	BMCE-TRANSMIT-007098
		06/12/2011	2		13/12/2011	BMCE-TRANSMIT-007098


[illegible]


[illegible]


[illegible]

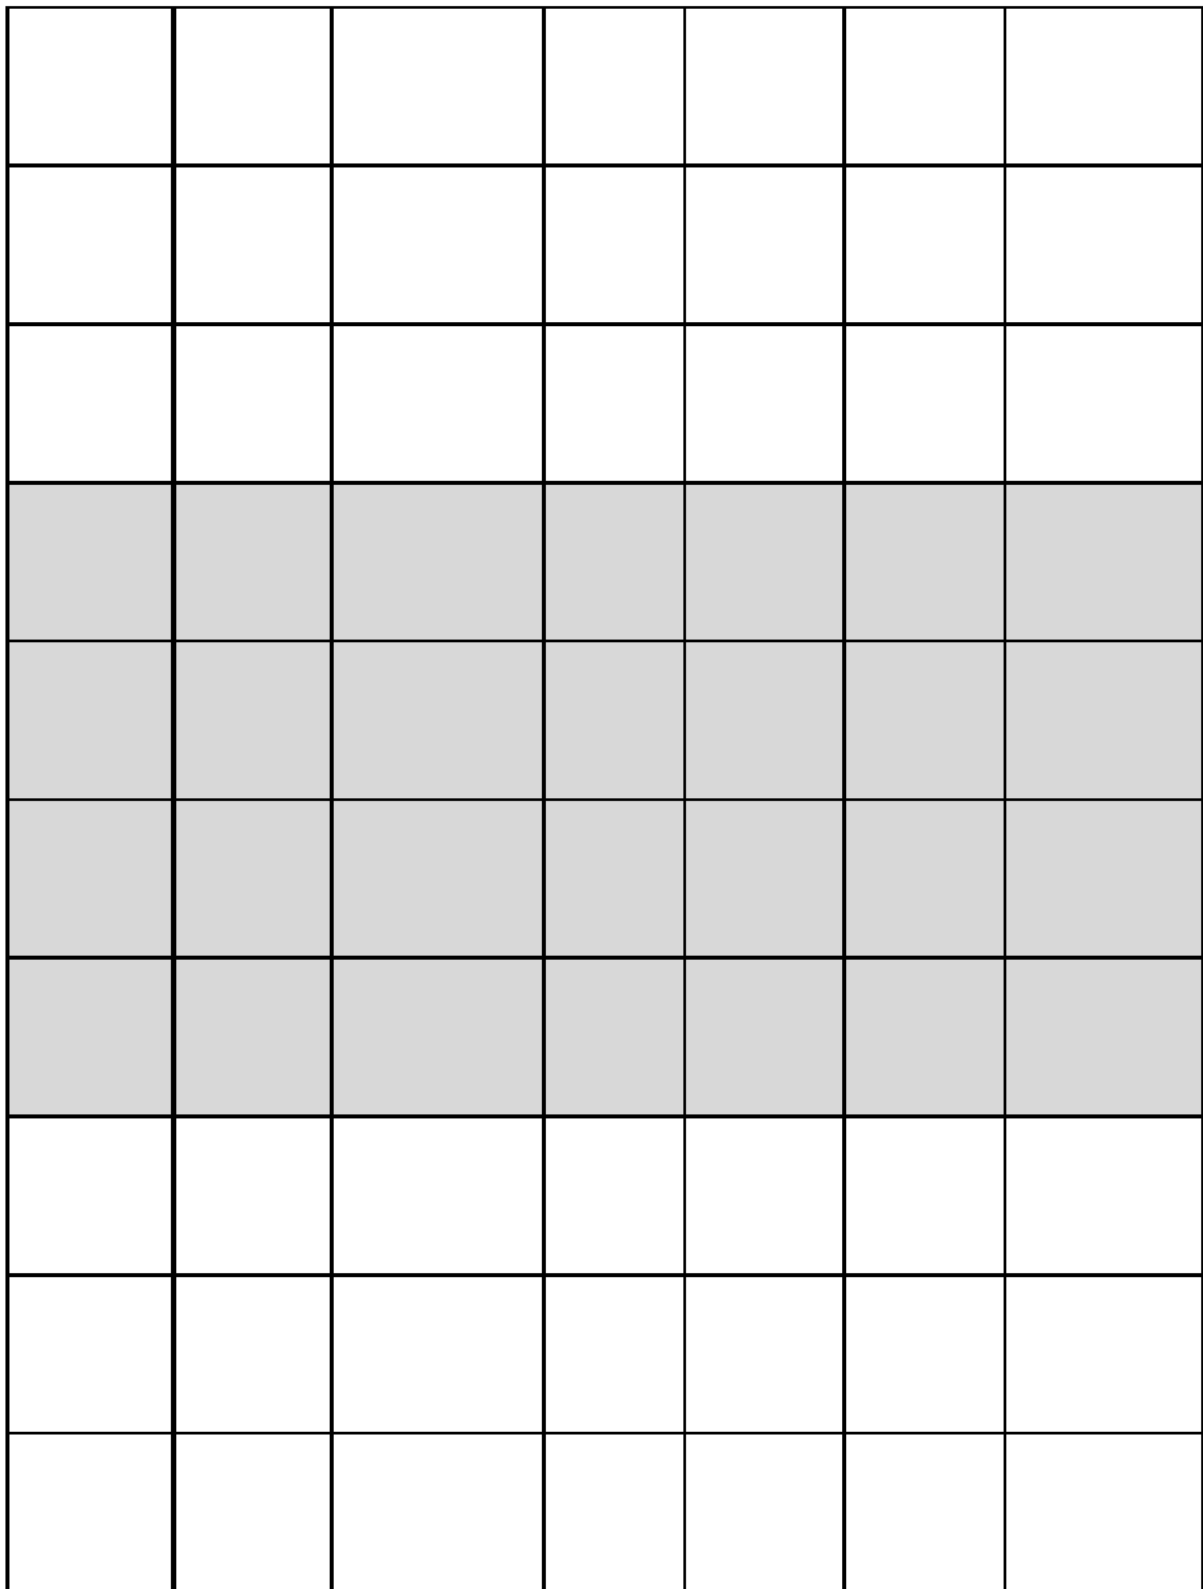

		05.09.2013	G		06/09/2013	BMCE-TRANSMIT-017621
		21/08/2013	D		05/09/2013	BMCE-TRANSMIT-017599

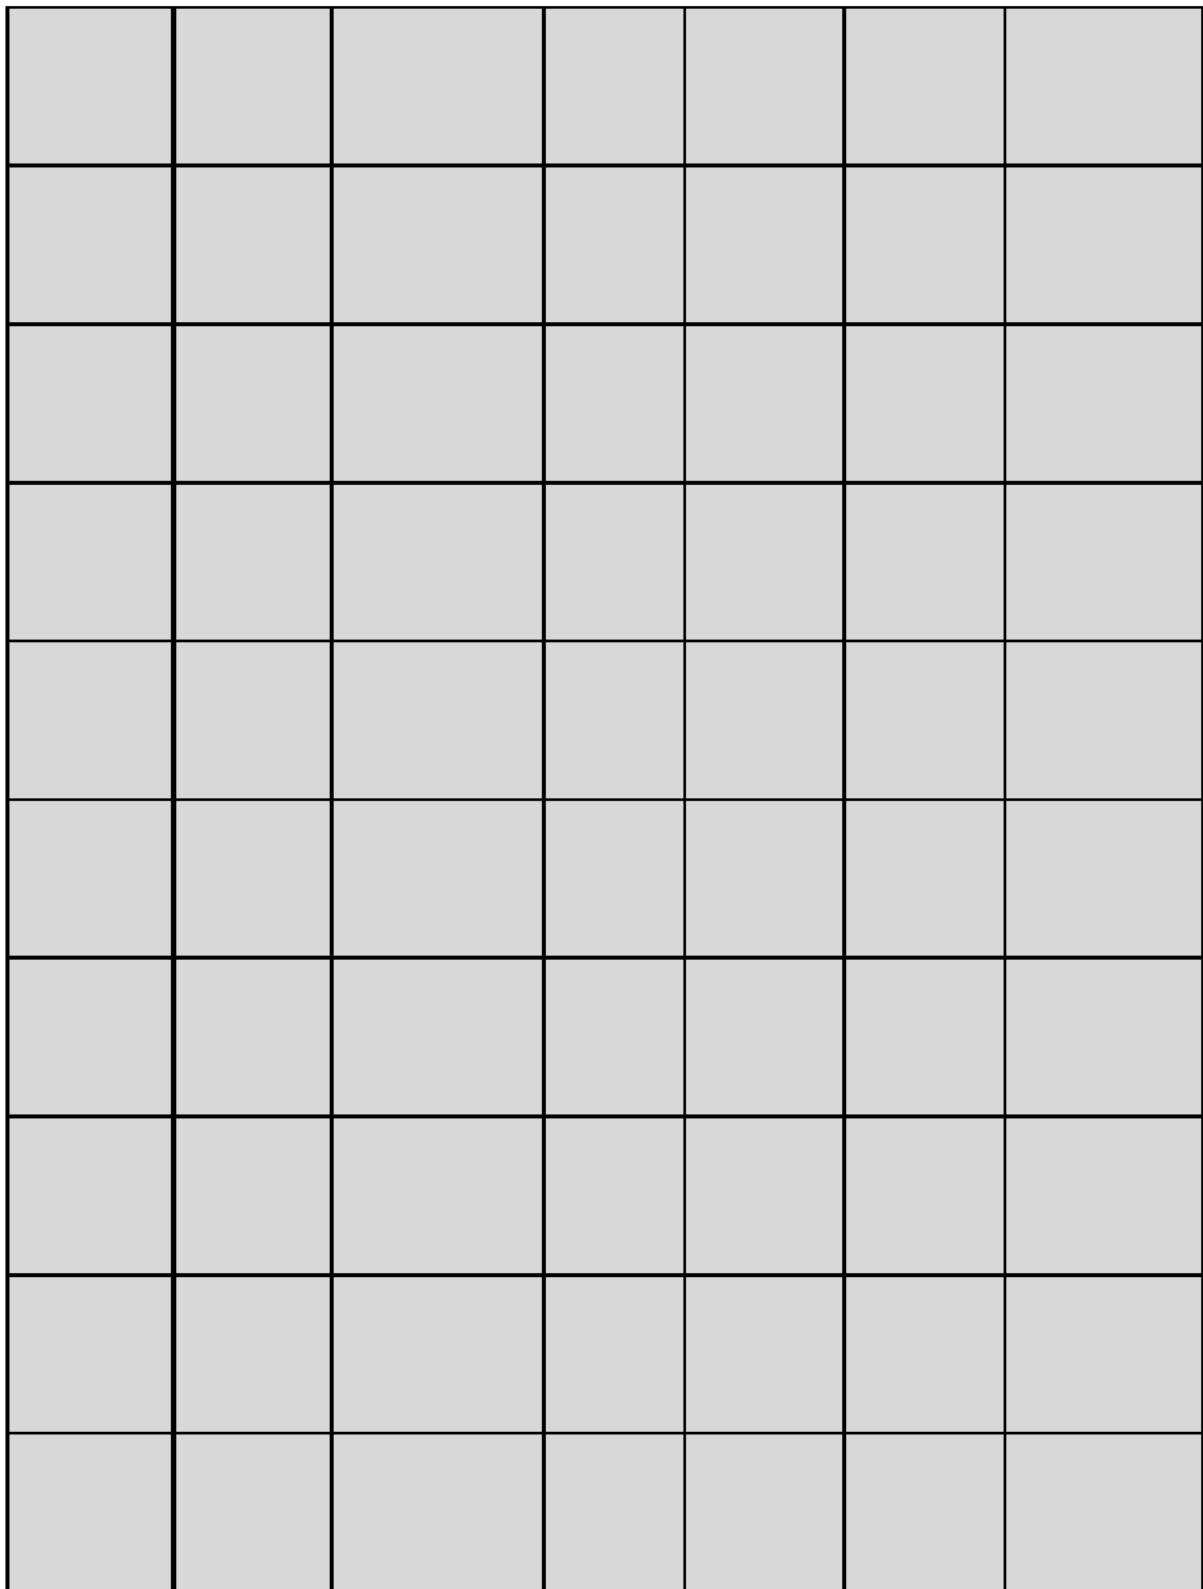

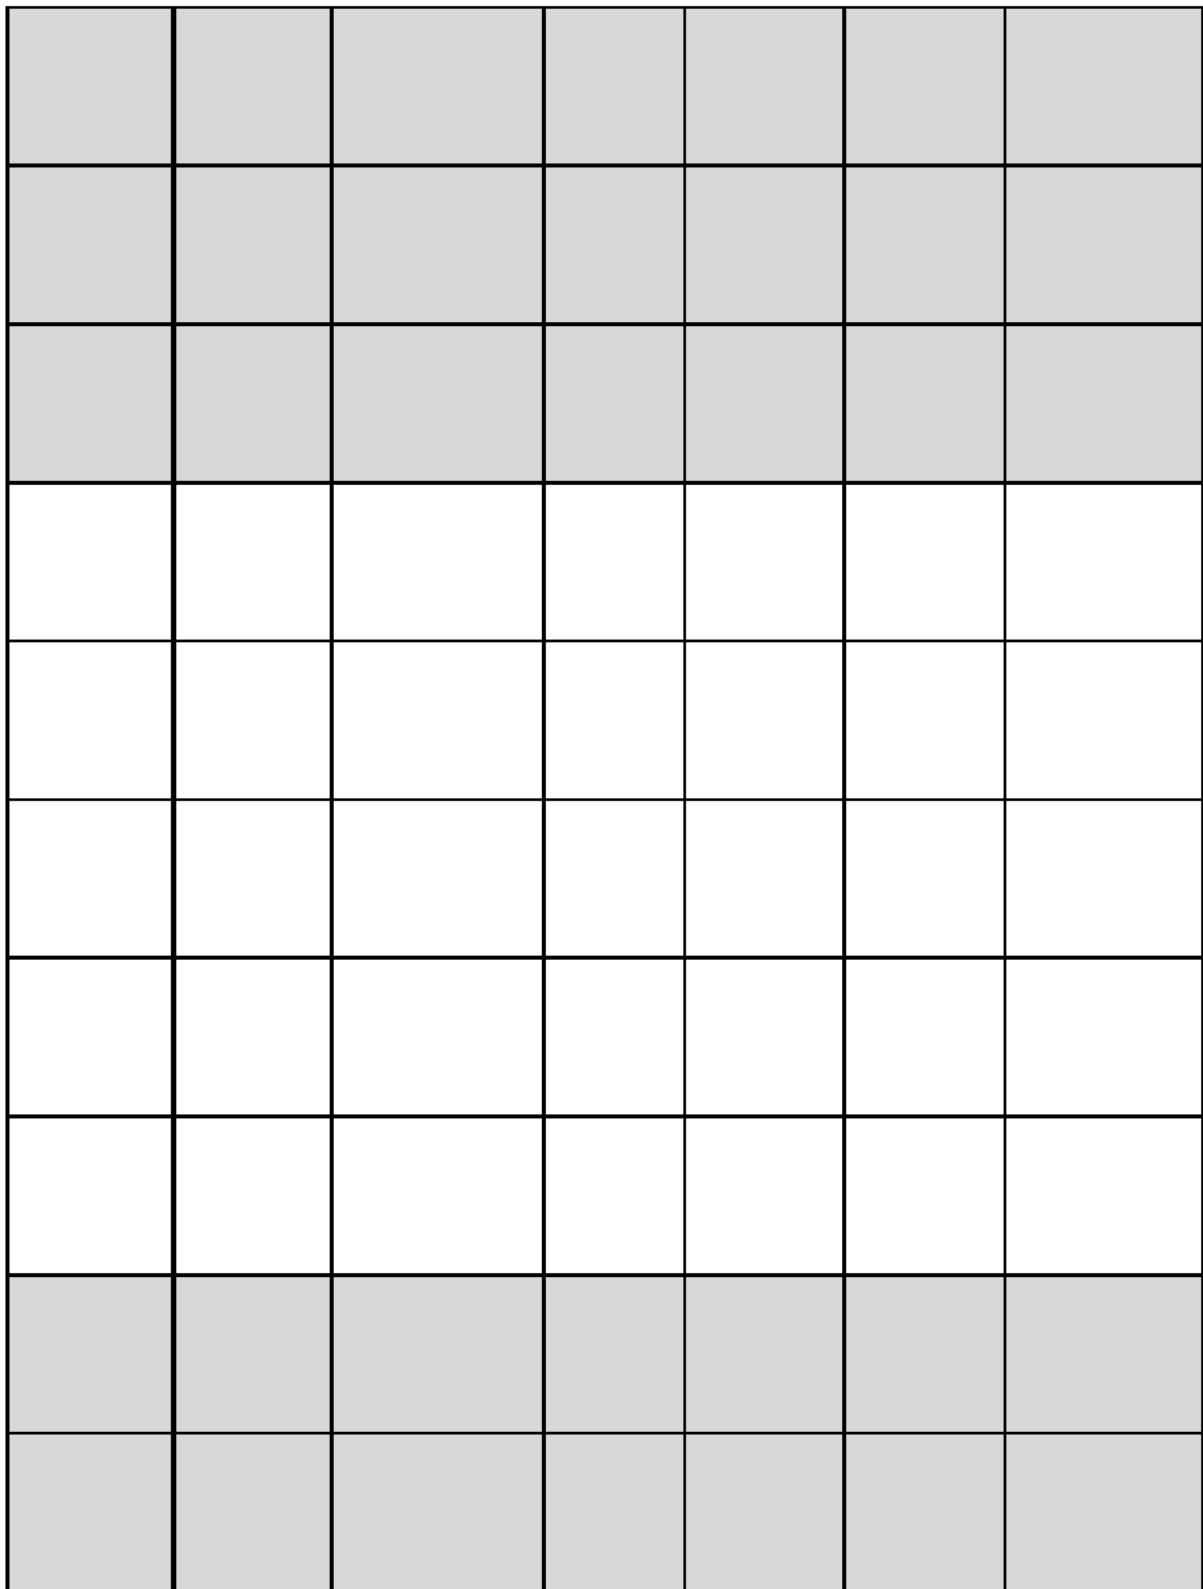

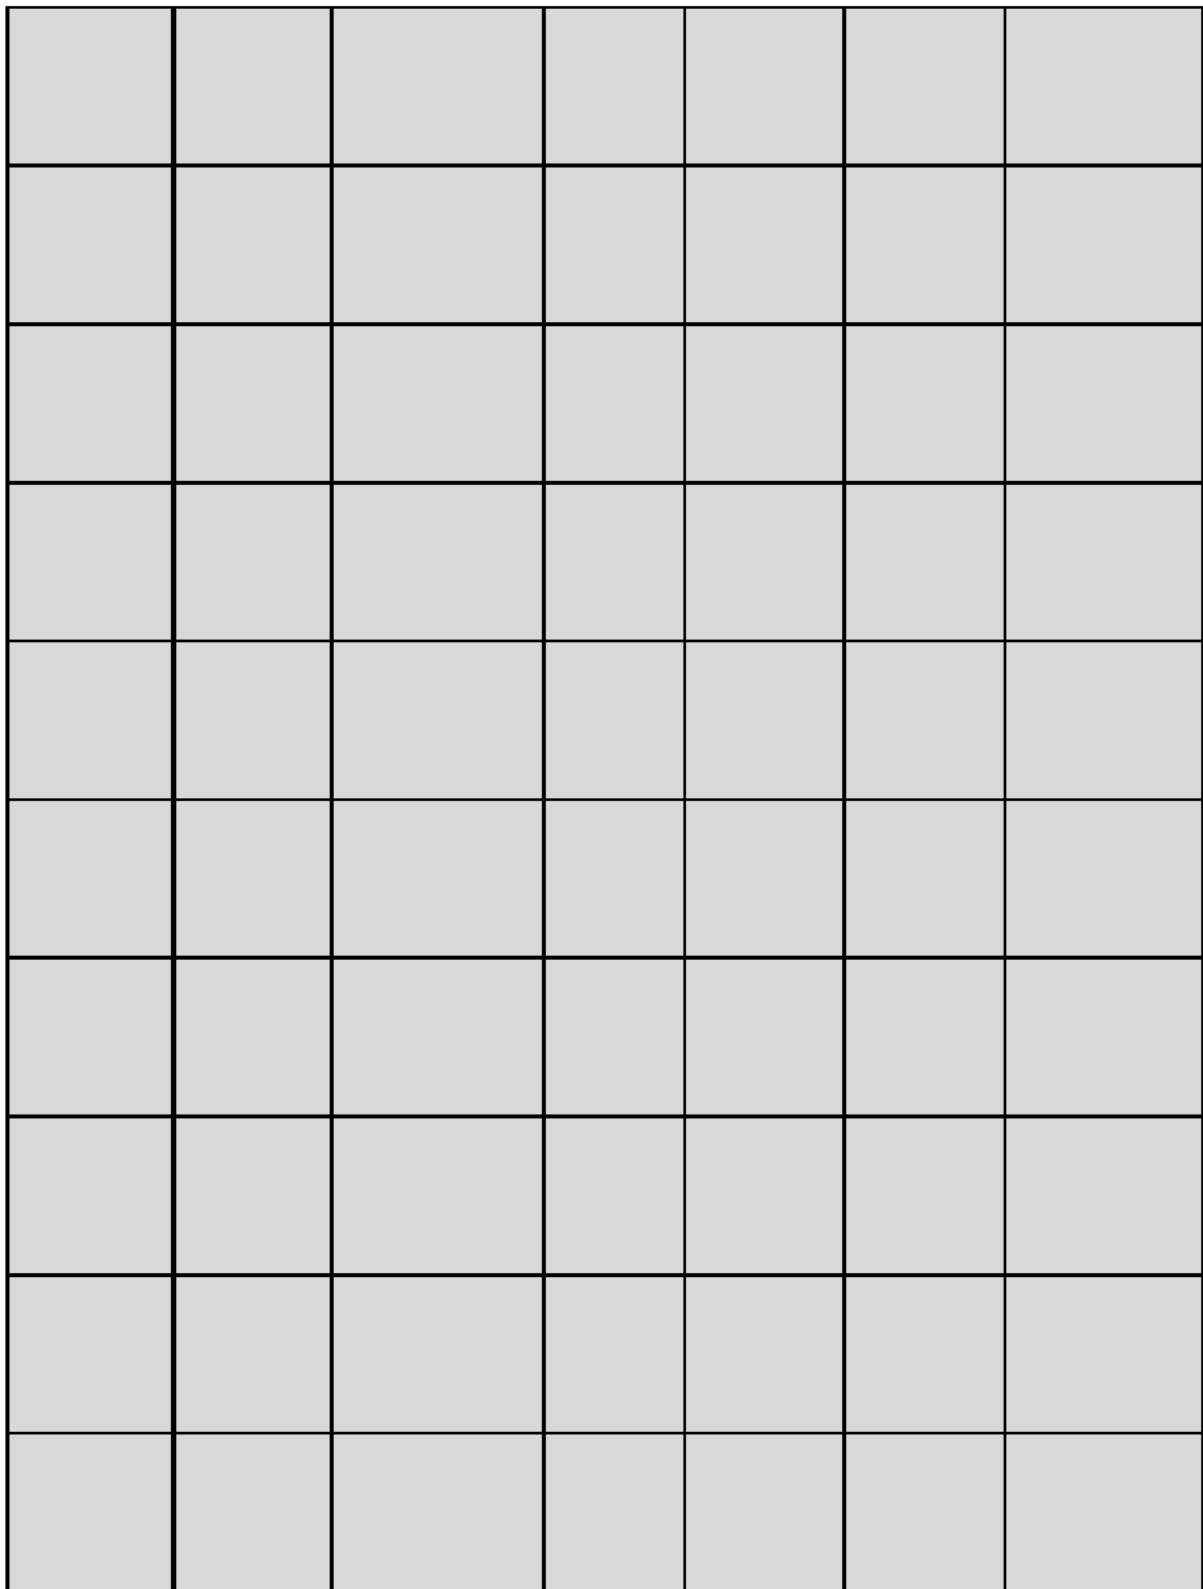

[illegible]

BMCE-TRANSMIT 018308 01/11/2013		06/02/2014	7		12/02/2014	BMCE-TRANSMIT- 019401

Brookfield Multiplex Europe

[illegible]

04/01/2012	24/04/2012	B	BMCE-TRANSMIT- 008654 03/05/12			
04/01/2012	24/04/2012	B	BMCE-TRANSMIT- 008654 03/05/12			
04/01/2012	24/04/2012	B	BMCE-TRANSMIT- 008654 03/05/12			
04/01/2012	24/04/2012	B	BMCE-TRANSMIT- 008654 03/05/12			
04/01/2012	24/04/2012	B	BMCE-TRANSMIT- 008654 03/05/12			
08/03/2012	24/04/2012	A	BMCE-TRANSMIT- 008654 03/05/12			
08/03/2012	24/04/2012	B	BMCE-TRANSMIT- 008654 03/05/12			
08/03/2012	24/03/2012	B	BMCE-TRANSMIT- 008654 03/05/12			
08/03/2012	24/03/2012	B	BMCE-TRANSMIT- 008654 03/05/12			

08/03/2012	24/03/2012	B	BMCE-TRANSMIT- 008654 03/05/12			
08/03/2012	24/03/2012	B	BMCE-TRANSMIT- 008654 03/05/12			
08/03/2012	24/03/2012	A	BMCE-TRANSMIT- 008654 03/05/12			
08/03/2012	24/03/2012	B	BMCE-TRANSMIT- 008654 03/05/12			
08/03/2012	24/03/2012	A	BMCE-TRANSMIT- 008654 03/05/12			
08/03/2012	24/03/2012	B	BMCE-TRANSMIT- 008654 03/05/12			
08/03/2012	24/03/2012	A	BMCE-TRANSMIT- 008654 03/05/12			
08/03/2012	24/03/2012	A	BMCE-TRANSMIT- 008654 03/05/12			
08/03/2012	24/03/2012	B	BMCE-TRANSMIT- 008654 03/05/12			
08/03/2012	24/03/2012	A	BMCE-TRANSMIT- 008654 03/05/12			

08/03/2012	24/03/2012	A	BMCE-TRANSMIT-008654 03/05/12			
08/03/2012	24/03/2012	A	BMCE-TRANSMIT-008654 03/05/12			
08/03/2012	24/03/2012	A	BMCE-TRANSMIT-008654 03/05/12			
08/03/2012	24/03/2012	B	BMCE-TRANSMIT-008654 03/05/12			
08/03/2012	24/03/2012	B	BMCE-TRANSMIT-008654 03/05/12			
08/03/2012	24/03/2012	B	BMCE-TRANSMIT-008654 03/05/12			
08/03/2012	24/03/2012	A	BMCE-TRANSMIT-008654 03/05/12			
08/03/2012	24/03/2012	B	BMCE-TRANSMIT-008654 03/05/12			
08/03/2012	24/03/2012	A	BMCE-TRANSMIT-008654 03/05/12			

08/03/2012	24/03/2012	B	BMCE-TRANSMIT- 008654 03/05/12			
08/03/2012	24/03/2012	B	BMCE-TRANSMIT- 008654 03/05/12			
08/03/2012	24/03/2012	A	BMCE-TRANSMIT- 008654 03/05/12			
08/03/2012	24/03/2012	A	BMCE-TRANSMIT- 008654 03/05/12			
08/03/2012	24/03/2012	B	BMCE-TRANSMIT- 008654 03/05/12			
08/03/2012	24/03/2012	A	BMCE-TRANSMIT- 008654 03/05/12			
08/03/2012	24/03/2012	B	BMCE-TRANSMIT- 008654 03/05/12			
08/03/2012	24/03/2012	B	BMCE-TRANSMIT- 008654 03/05/12			
08/03/2012	24/03/2012	B	BMCE-TRANSMIT- 008654 03/05/12			
08/03/2012	24/03/2012	B	BMCE-TRANSMIT- 008654 03/05/12			

08/03/2012	24/03/2012	A	BMCE-TRANSMIT- 008654 03/05/12			
08/03/2012	24/03/2012	B	BMCE-TRANSMIT- 008654 03/05/12			
08/03/2012	24/03/2012	B	BMCE-TRANSMIT- 008654 03/05/12			
08/03/2012	24/03/2012	A	BMCE-TRANSMIT- 008654 03/05/12			
08/03/2012	24/03/2012	A	BMCE-TRANSMIT- 008654 03/05/12			
08/03/2012	24/03/2012	B	BMCE-TRANSMIT- 008654 03/05/12			
08/03/2012	24/03/2012	B	BMCE-TRANSMIT- 008654 03/05/12			
08/03/2012	24/03/2012	A	BMCE-TRANSMIT- 008654 03/05/12			
08/03/2012	24/03/2012	B	BMCE-TRANSMIT- 008654 03/05/12			
08/03/2012	24/03/2012	A	BMCE-TRANSMIT- 008654 03/05/12			

[illegible]

[illegible]

08/03/2012	24/03/2012	A	BMCE-TRANSMIT- 008654 03/05/12			
08/03/2012	24/03/2012	A	BMCE-TRANSMIT- 008654 03/05/12			
08/03/2012	24/03/2012	B	BMCE-TRANSMIT- 008654 03/05/12			
08/03/2012	24/03/2012	A	BMCE-TRANSMIT- 008654 03/05/12			
08/03/2012	24/03/2012	B	BMCE-TRANSMIT- 008654 03/05/12			
08/03/2012	24/03/2012	A	BMCE-TRANSMIT- 008654 03/05/12			
08/03/2012	24/03/2012	A	BMCE-TRANSMIT- 008654 03/05/12			
08/03/2012	24/03/2012	A	BMCE-TRANSMIT- 008654 03/05/12			
08/03/2012	24/03/2012	B	BMCE-TRANSMIT- 008654 03/05/12			
08/03/2012	24/03/2012	A	BMCE-TRANSMIT- 008654 03/05/12			

08/03/2012	24/03/2012	A	BMCE-TRANSMIT- 008654 03/05/12			
08/03/2012	24/03/2012	A	BMCE-TRANSMIT- 008654 03/05/12			
08/03/2012	24/03/2012	A	BMCE-TRANSMIT- 008654 03/05/12			
08/03/2012	24/03/2012	A	BMCE-TRANSMIT- 008654 03/05/12			
27/12/2011 03/01/2012	28/03/2012 28/03/2012	B	BMCE-TRANSMIT- 008654 03/05/12			
27/12/2011	28/03/2012	B	BMCE-TRANSMIT- 008654 03/05/12			
27/12/2011	28/03/2012	B	BMCE-TRANSMIT- 008654 03/05/12			
27/12/2011	28/03/2012	B	BMCE-TRANSMIT- 008654 03/05/12			
27/12/2011	28/03/2012	B	BMCE-TRANSMIT- 008654 03/05/12			

27/12/2011	28/03/2012	A	BMCE-TRANSMIT-008654 03/05/12			
27/12/2011	28/03/2012	B	BMCE-TRANSMIT-008654 03/05/12			
27/12/2011	28/03/2012	A	BMCE-TRANSMIT-008654 03/05/12			
27/12/2011	28/03/2012	A	BMCE-TRANSMIT-008654 03/05/12			
27/12/2011	28/03/2012	A	BMCE-TRANSMIT-008654 03/05/12			
27/12/2011	28/03/2012	B	BMCE-TRANSMIT-008654 03/05/12			
27/12/2011	28/03/2012	B	BMCE-TRANSMIT-008654 03/05/12			

27/12/2011	28/03/2012	A	BMCE-TRANSMIT- 008654 03/05/12			
27/12/2011	28/03/2012	A	BMCE-TRANSMIT- 008654 03/05/12			
27/12/2011	28/03/2012	B	BMCE-TRANSMIT- 008654 03/05/12			
27/12/2011	28/03/2012	B	BMCE-TRANSMIT- 008654 03/05/12			
27/12/2011	28/03/2012	A	BMCE-TRANSMIT- 008654 03/05/12			
27/12/2011	28/03/2012	B	BMCE-TRANSMIT- 008654 03/05/12			
27/12/2011	28/03/2012	A	BMCE-TRANSMIT- 008654 03/05/12			
27/12/2011	28/03/2012	A	BMCE-TRANSMIT- 008654 03/05/12			
27/12/2011	28/03/2012	B	BMCE-TRANSMIT- 008654 03/05/12			

27/12/2011	28/03/2012	B	BMCE-TRANSMIT- 008654 03/05/12			
27/12/2011	28/03/2012	A	BMCE-TRANSMIT- 008654 03/05/12			
27/12/2011	28/03/2012	B	BMCE-TRANSMIT- 008654 03/05/12			
27/12/2011	28/03/2012	A	BMCE-TRANSMIT- 008654 03/05/12			
27/12/2011	28/03/2012	B	BMCE-TRANSMIT- 008654 03/05/12			
27/12/2011	28/03/2012	B	BMCE-TRANSMIT- 008654 03/05/12			
27/12/2011	28/03/2012	A	BMCE-TRANSMIT- 008654 03/05/12			
27/12/2011	28/03/2012	A	BMCE-TRANSMIT- 008654 03/05/12			
27/12/2011	28/03/2012	B	BMCE-TRANSMIT- 008654 03/05/12			
27/12/2011	28/03/2012	A	BMCE-TRANSMIT- 008654 03/05/12			

27/12/2011	28/03/2012	B	BMCE-TRANSMIT- 008654 03/05/12			
27/12/2011	28/03/2012	A	BMCE-TRANSMIT- 008654 03/05/12			
27/12/2011	28/03/2012	A	BMCE-TRANSMIT- 008654 03/05/12			
27/12/2011	28/03/2012	B	BMCE-TRANSMIT- 008654 03/05/12			
27/12/2011	28/03/2012	B	BMCE-TRANSMIT- 008654 03/05/12			
27/12/2011	28/03/2012	B	BMCE-TRANSMIT- 008654 03/05/12			
27/12/2011	28/03/2012	B	BMCE-TRANSMIT- 008654 03/05/12			
27/12/2011	28/03/2012	B	BMCE-TRANSMIT- 008654 03/05/12			
27/12/2011	28/03/2012	A	BMCE-TRANSMIT- 008654 03/05/12			
27/12/2011	28/03/2012	B	BMCE-TRANSMIT- 008654 03/05/12			
27/12/2011	28/03/2012	A	BMCE-TRANSMIT- 008654 03/05/12			

27/12/2011	28/03/2012	A	BMCE-TRANSMIT- 008654 03/05/12			
27/12/2011	28/03/2012	B	BMCE-TRANSMIT- 008654 03/05/12			
27/12/2011	28/03/2012	B	BMCE-TRANSMIT- 008654 03/05/12			
27/12/2011	28/03/2012	A	BMCE-TRANSMIT- 008654 03/05/12			
27/12/2011	28/03/2012	A	BMCE-TRANSMIT- 008654 03/05/12			
27/12/2011	28/03/2012	A	BMCE-TRANSMIT- 008654 03/05/12			
27/12/2011	28/03/2012	A	BMCE-TRANSMIT- 008654 03/05/12			
27/12/2011	28/03/2012	B	BMCE-TRANSMIT- 008654 03/05/12			
27/12/2011	28/03/2012	B	BMCE-TRANSMIT- 008654 03/05/12			
27/12/2011	28/03/2012	B	BMCE-TRANSMIT- 008654 03/05/12			

27/12/2011	28/03/2012	B	BMCE-TRANSMIT- 008654 03/05/12			
27/12/2011	28/03/2012	B	BMCE-TRANSMIT- 008654 03/05/12			
27/12/2011	28/03/2012	A	BMCE-TRANSMIT- 008654 03/05/12			
27/12/2011	28/03/2012	A	BMCE-TRANSMIT- 008654 03/05/12			
27/12/2011	28/03/2012	A	BMCE-TRANSMIT- 008654 03/05/12			
27/12/2011	28/03/2012	A	BMCE-TRANSMIT- 008654 03/05/12			
27/12/2011	28/03/2012	A	BMCE-TRANSMIT- 008654 03/05/12			
27/12/2011	28/03/2012	A	BMCE-TRANSMIT- 008654 03/05/12			
27/12/2011	28/03/2012	A	BMCE-TRANSMIT- 008654 03/05/12			
27/12/2011	28/03/2012	A	BMCE-TRANSMIT- 008654 03/05/12			
27/12/2011	28/03/2012	B	BMCE-TRANSMIT- 008654 03/05/12			

27/12/2011	28/03/2012	B	BMCE-TRANSMIT- 008654 03/05/12			
27/12/2011	28/03/2012	A	BMCE-TRANSMIT- 008654 03/05/12			
27/12/2011	28/03/2012	A	BMCE-TRANSMIT- 008654 03/05/12			
27/12/2011	28/03/2012	A	BMCE-TRANSMIT- 008654 03/05/12			
27/12/2011	28/03/2012	B	BMCE-TRANSMIT- 008654 03/05/12			
27/12/2011	28/03/2012	A	BMCE-TRANSMIT- 008654 03/05/12			
27/12/2011	28/03/2012	B	BMCE-TRANSMIT- 008654 03/05/12			
14/08/2012		A	BMCE-TRANSMIT- 009912 19/07/12			
03/01/2012	04/05/2012	B	BMCE-TRANSMIT- 008666 04/05/12			

03/01/2012	04/05/2012	B	BMCE-TRANSMIT- 008666 04/05/12			
03/01/2012	04/05/2012	A	BMCE-TRANSMIT- 008666 04/05/12			
03/01/2012	04/05/2012	B	BMCE-TRANSMIT- 008666 04/05/12			
03/01/2012	04/05/2012	B	BMCE-TRANSMIT- 008666 04/05/12			
03/01/2012	04/05/2012	A	BMCE-TRANSMIT- 008666 04/05/12			
03/01/2012	04/05/2012	A	BMCE-TRANSMIT- 008666 04/05/12			
03/01/2012	04/05/2012	A	BMCE-TRANSMIT- 008666 04/05/12			
03/01/2012	04/05/2012	B	BMCE-TRANSMIT- 008666 04/05/12			
03/01/2012	04/05/2012	A	BMCE-TRANSMIT- 008666 04/05/12			
03/01/2012	04/05/2012	A	BMCE-TRANSMIT- 008666 04/05/12			

[illegible]

[illegible]

[illegible]

[illegible]

[illegible]

[illegible]

02/01/2012	27/03/2012	A	BMCE-TRANSMIT-008331 11/04/12			
02/01/2012	27/03/2012	A	BMCE-TRANSMIT-008331 11/04/12			
02/01/2012	27/03/2012	B	BMCE-TRANSMIT-008331 11/04/12			
02/01/2012	27/03/2012	A	BMCE-TRANSMIT-008331 11/04/12			
02/01/2012	27/03/2012	A	BMCE-TRANSMIT-008331 11/04/12			
02/01/2012	27/03/2012	A	BMCE-TRANSMIT-008331 11/04/12			
02/01/2012	27/03/2012	B	BMCE-TRANSMIT-008331 11/04/12			
02/01/2012	27/03/2012	B	BMCE-TRANSMIT-008331 11/04/12			
03/01/2012	27/03/2012	B	BMCE-TRANSMIT-008331 11/04/12			

[illegible]

[illegible]

03/01/2012	27/03/2012	A	BMCE-TRANSMIT- 008331 11/04/12			
03/01/2012	27/03/2012	A	BMCE-TRANSMIT- 008331 11/04/12			
03/01/2012	27/03/2012	A	BMCE-TRANSMIT- 008331 11/04/12			
03/01/2012	27/03/2012	B	BMCE-TRANSMIT- 008331 11/04/12			
03/01/2012	27/03/2012	A	BMCE-TRANSMIT- 008331 11/04/12			
03/01/2012	27/03/2012	B	BMCE-TRANSMIT- 008331 11/04/12			
03/01/2012	27/03/2012	A	BMCE-TRANSMIT- 008331 11/04/12			
03/01/2012	27/03/2012	A	BMCE-TRANSMIT- 008331 11/04/12			
03/01/2012	27/03/2012	A	BMCE-TRANSMIT- 008331 11/04/12			
03/01/2012	27/03/2012	A	BMCE-TRANSMIT- 008331 11/04/12			

03/01/2012	27/03/2012	B	BMCE-TRANSMIT- 008331 11/04/12			
03/01/2012	27/03/2012	B	BMCE-TRANSMIT- 008331 11/04/12			
03/01/2012	27/03/2012	A	BMCE-TRANSMIT- 008331 11/04/12			
03/01/2012	27/03/2012	A	BMCE-TRANSMIT- 008331 11/04/12			
03/01/2012	27/03/2012	B	BMCE-TRANSMIT- 008331 11/04/12			
03/01/2012	27/03/2012	B	BMCE-TRANSMIT- 008331 11/04/12			
03/01/2012	27/03/2012	A	BMCE-TRANSMIT- 008331 11/04/12			
03/01/2012	27/03/2012	A	BMCE-TRANSMIT- 008331 11/04/12			
03/01/2012	27/03/2012	A	BMCE-TRANSMIT- 008331 11/04/12			
03/01/2012	27/03/2012	A	BMCE-TRANSMIT- 008331 11/04/12			

03/01/2012	27/03/2012	A	BMCE-TRANSMIT- 008331 11/04/12			
03/01/2012	27/03/2012	A	BMCE-TRANSMIT- 008331 11/04/12			
03/01/2012	27/03/2012	B	BMCE-TRANSMIT- 008331 11/04/12			
03/01/2012	27/03/2012	A	BMCE-TRANSMIT- 008331 11/04/12			
03/01/2012	27/03/2012	A	BMCE-TRANSMIT- 008331 11/04/12			
03/01/2012	27/03/2012	A	BMCE-TRANSMIT- 008331 11/04/12			
03/01/2012	27/03/2012	A	BMCE-TRANSMIT- 008331 11/04/12			
03/01/2012	27/03/2012	A	BMCE-TRANSMIT- 008331 11/04/12			
03/01/2012	27/03/2012	A	BMCE-TRANSMIT- 008331 11/04/12			
03/01/2012	27/03/2012	A	BMCE-TRANSMIT- 008331 11/04/12			
03/01/2011	27/03/2012	A	BMCE-TRANSMIT- 008331 11/04/12			

03/01/2011	27/03/2012	A	BMCE-TRANSMIT- 008331 11/04/12			
03/01/2011	27/03/2012	B	BMCE-TRANSMIT- 008331 11/04/12			
03/01/2011	27/03/2012	A	BMCE-TRANSMIT- 008331 11/04/12			
03/01/2011	27/03/2012	A	BMCE-TRANSMIT- 008331 11/04/12			
03/01/2011	27/03/2012	A	BMCE-TRANSMIT- 008331 11/04/12			
03/01/2011	27/03/2012	B	BMCE-TRANSMIT- 008331 11/04/12			
03/01/2011	27/03/2012	A	BMCE-TRANSMIT- 008331 11/04/12			
03/01/2011	27/03/2012	A	BMCE-TRANSMIT- 008331 11/04/12			
03/01/2011	27/03/2012	B	BMCE-TRANSMIT- 008331 11/04/12			
03/01/2011	27/03/2012	B	BMCE-TRANSMIT- 008331 11/04/12			

03/01/2011	27/03/2012	B	BMCE-TRANSMIT-008331 11/04/12			
	27/03/2012	B	BMCE-TRANSMIT-008331 11/04/12			
					29/05/2013	C
					19/03/2013	E

					29/05/2013	C
					29/05/2013	F

						F
						H
					29/05/2013	C
					29/05/2013	C

						E
						A
						B
					29/05/2013	C
					29/05/2013	C

					19/04/2013	B
					19/04/2013	B
					29/05/2013	D
					12/06/2013	C
20.09.2013	06/09/2013	A	BMCE-TRANSMIT-017961 08/10/2012			
19/09/2013	06/09/2013	B	BMCE-TRANSMIT-017967 08/10/2012		25/10/2013	E
					19/04/2013	B
					28/02/2013	B
					28/02/2013	B
					20/05/2013	A

[illegible]

					01/03/2013	B
					01/03/2013	B
					08/01/2013	A
					22/04/2013	B
					22/04/2013	B

					22/04/2013	B
					22/04/2013	B
					22/04/2013	B
					08/07/2013	B
					08/07/2013	B
					08/07/2013	B
					08/07/2013	B
					08/07/2013	B
					09/07/2013	B
					09/07/2013	B

					09/07/2013	C
					09/07/2013	B
					09/07/2013	B
					09/07/2013	A
					09/07/2013	A
					25/04/2013	B
					25/04/2013	B
					25/04/2013	B
					25/04/2013	B

26/02/2014	06/03/2014	B	BMCE-TRANSMIT- 019780 26/03/2014			

FINAL SWEEP

[illegible]

[illegible]

	05/06/2013		06/06/2013	B	BMCE-TRANSMIT- 016338 18/06/2013
	24/04/2013		24/04/2013		

	05/06/2013		06/06/2013	B	BMCE-TRANSMIT-016338 18/06/2013
	05/06/2013		06/06/2013	B	BMCE-TRANSMIT-016338 18/06/2013

				B	
				B	
	05/06/2013		06/06/2013	B	BMCE-TRANSMIT-016338 18/06/2013
	05/06/2013		06/06/2013	B	BMCE-TRANSMIT-016338 18/06/2013

				B	BMCE-TRANSMIT
			13/06/2013	B	BMCE-TRANSMIT-016465 24/06/2013
			13/06/2013	B	BMCE-TRANSMIT-016465 24/06/2013
	05/06/2013		06/06/2013	B	BMCE-TRANSMIT-016338 18/06/2013
	05/06/2013		06/06/2013	B	BMCE-TRANSMIT-016338 18/06/2013

	01/05/2013		02/05/2013	B	BMCE-TRANSMIT-015451 02/05/2013
	01/05/2013		02/05/2013	B	BMCE-TRANSMIT-015451 02/05/2013
	05/06/2013		06/06/2013	B	BMCE-TRANSMIT-016338 18/06/2013
	18/07/2013		19/07/2013	B	BMCE-TRANSMIT-016884 22/07/2013
	BMCE-TRANSMIT-018394 07/11/2013	21/11/2013	19/11/2014	A	BMCE-TRANSMIT-018666 03/12/2013
	01/05/2013		02/05/2013	B	BMCE-TRANSMIT-015451 02/05/2013
	15/05/2013		16/05/2013	B	BMCE-TRANSMIT-015818 20/05/2013
	15/05/2013		16/05/2013	B	BMCE-TRANSMIT-015818 20/05/2013
	29/05/2013			B	BMCE-TRANSMIT-016008 31/05/2013

	15/05/2013		16/05/2013	B	BMCE-TRANSMIT-015818 20/05/2013
	15/05/2013		16/05/2013	B	BMCE-TRANSMIT-015818 20/05/2013
	15/05/2013		16/05/2013	B	BMCE-TRANSMIT-015818 20/05/2013
	08/05/2013		09/05/2013	B	BMCE-TRANSMIT-015661 15/05/2013
	08/05/2013		09/05/2013	B	BMCE-TRANSMIT-015661 15/05/2013
	08/05/2013		09/05/2013	B	BMCE-TRANSMIT-015661 15/05/2013
	08/05/2013		09/05/2013	B	BMCE-TRANSMIT-015661 15/05/2013
	08/05/2013		09/05/2013	B	BMCE-TRANSMIT-015661 15/05/2013
	12/06/2013		13/06/2013	B	BMCE-TRANSMIT-016465 24/06/2013
	12/06/2013		13/06/2013	B	BMCE-TRANSMIT-016465 24/06/2013

	12/06/2013		13/06/2013	B	BMCE-TRANSMIT-016465 24/06/2013
	12/06/2013		13/06/2013	B	BMCE-TRANSMIT-016465 24/06/2013
	12/06/2013		13/06/2013	B	BMCE-TRANSMIT-016465 24/06/2013
	15/05/2013		16/05/2013	B	BMCE-TRANSMIT-015712 16/05/2013
	15/05/2013		16/05/2013	B	BMCE-TRANSMIT-015712 16/05/2013

	15/05/2013		16/05/2013	B	BMCE-TRANSMIT-015712 16/05/2013
	15/05/2013		16/05/2013	B	BMCE-TRANSMIT-015712 16/05/2013
	15/05/2013		16/05/2013	B	BMCE-TRANSMIT-015712 16/05/2013
	10/07/2013		11/07/2013	A	BMCE-TRANSMIT-016851 18/07/2013
	10/07/2013		11/07/2013	B	BMCE-TRANSMIT-016851 18/07/2013
	10/07/2013		11/07/2013	A	BMCE-TRANSMIT-016851 18/07/2013
	10/07/2013		11/07/2013	B	BMCE-TRANSMIT-016851 18/07/2013
	10/07/2013		11/07/2013	A	BMCE-TRANSMIT-016851 18/07/2013
	10/07/2013		11/07/2013	A	BMCE-TRANSMIT-016843 18/07/2013
	10/07/2013		11/07/2013	A	BMCE-TRANSMIT-016843 18/07/2013

	10/07/2013		11/07/2013	B	BMCE-TRANSMIT-016843 18/07/2013
	10/07/2013		11/07/2013	B	BMCE-TRANSMIT-016843 18/07/2013
	10/07/2013		11/07/2013	A	BMCE-TRANSMIT-016843 18/07/2013
	10/07/2013		11/07/2013	B	BMCE-TRANSMIT-016842 18/07/2013
	10/07/2013		11/07/2013	A	BMCE-TRANSMIT-016842 18/07/2013
	29/05/2014		30/05/2013	B	BMCE-TRANSMIT-016001 30/05/2013
	29/05/2014		30/05/2013	B	BMCE-TRANSMIT-016001 30/05/2013
	29/05/2014		30/05/2013	B	BMCE-TRANSMIT-016001 30/05/2013
	29/05/2014		30/05/2013	B	BMCE-TRANSMIT-016001 30/05/2013

[illegible]

[illegible]

18b BCL-AC-XX-SH-001

Drawing Information

1st Submission

			Action By	Drawing Number	Drawing Title	Date Required from Consultant	Date Submitted by Consultant	Document Revision	Planned Date to be Submitted to Board	Date Submitted to Board	BMCE Transmittal No	Date Response Required from Board (+3 Weeks)	Date Received from Board	Board Status	Date Returned to Consultant	
Item	Submission	Comments														
	Glazed Screen Strategy Plans (1:300)		NA	NA-xx-xx-DT-321-001	Internal Glazed Screen Types - Elevations Sheet 1 of 2	09/03/2011	12/03/2012	4	23/03/2012	20/03/2012	BMCE-TRANSMIT-008088	10/04/2012	11/06/2012	A	BMCE-TRANSMIT-009465 22/06/12	
			NA	NA-xx-xx-DT-321-002	Internal Glazed Screen Types - Elevations Sheet 2 of 2	09/03/2011	12/03/2012	4	23/03/2012	20/03/2012	BMCE-TRANSMIT-008088	10/04/2012	11/06/2012	A	BMCE-TRANSMIT-009465 22/06/12	
				NA-xx-xx-DT-321-100	Internal Glazed Screen Details		02/07/2012	2		29/06/2012	BMCE-TRANSMIT-009607	23/07/2012	02/07/2012	B	BMCE-TRANSMIT-009867 16/07/12	
			NA	NA-xx-00-PL-321-150	Ground Floor Plan - Glazed Screen Types Strategy Plan	09/03/2011	12/03/2012	4	23/03/2012	20/03/2012	BMCE-TRANSMIT-008088	10/04/2012	11/06/2012	B	BMCE-TRANSMIT-009465 22/06/12	
			NA	NA-xx-01-PL-321-150	First Floor Plan - Glazed Screen Types Strategy Plan	09/03/2011	12/03/2012	5	23/03/2012	20/03/2012	BMCE-TRANSMIT-008088	10/04/2012	11/06/2012	B	BMCE-TRANSMIT-009465 22/06/12	
			NA	NA-XX-02-PL-321-150	Second Floor Plan - Glazed Screen Types Strategy Plan	09/03/2011	12/03/2012	4	23/03/2012	20/03/2012	BMCE-TRANSMIT-008088	10/04/2012	11/06/2012	B	BMCE-TRANSMIT-009465 22/06/12	
			NA	NA-xx-03-PL-321-150	Third Floor Plan - Glazed Screen Types Strategy Plan	09/03/2011	12/03/2012	4	23/03/2012	20/03/2012	BMCE-TRANSMIT-008088	10/04/2012	11/06/2012	B	BMCE-TRANSMIT-009465 22/06/12	
			NA	NA-xx-04-PL-321-150	Fourth Floor Plan - Glazed Screen Types Strategy Plan	09/03/2011	12/03/2012	4	23/03/2012	20/03/2012	BMCE-TRANSMIT-008088	10/04/2012	11/06/2012	B	BMCE-TRANSMIT-009465 22/06/12	
			NA	NA-xx-05-PL-321-150	Fifth Floor Plan - Glazed Screen Types Strategy Plan	09/03/2011	12/03/2012	4	23/03/2012	20/03/2012	BMCE-TRANSMIT-008088	10/04/2012	11/06/2012	B	BMCE-TRANSMIT-009465 22/06/12	
			NA	NA-xx-06-PL-321-150	Sixth Floor Plan - Glazed Screen Types Strategy Plan	09/03/2011	12/03/2012	2	23/03/2012	20/03/2012	BMCE-TRANSMIT-008088	10/04/2012	11/06/2012	B	BMCE-TRANSMIT-009465 22/06/12	
			NA	NA-xx-07-PL-321-150	Seventh Floor Plan - Glazed Screen Types Strategy Plan	09/03/2011	12/03/2012	2	23/03/2012	20/03/2012	BMCE-TRANSMIT-008088	10/04/2012	11/06/2012	B	BMCE-TRANSMIT-009465 22/06/12	
			NA	NA-xx-08-PL-321-150	Eighth Floor Plan - Glazed Screen Types Strategy Plan	09/03/2011	12/03/2012	2	23/03/2012	20/03/2012	BMCE-TRANSMIT-008088	10/04/2012	11/06/2012	B	BMCE-TRANSMIT-009465 22/06/12	
			NA	NA-xx-09-PL-321-150	Ninth Floor Plan - Glazed Screen Types Strategy Plan	09/03/2011	12/03/2012	2	23/03/2012	20/03/2012	BMCE-TRANSMIT-008088	10/04/2012	11/06/2012	A	BMCE-TRANSMIT-009465 22/06/12	
			NA	NA-xx-10-PL-321-150	Tenth Floor Plan - Glazed Screen Types Strategy Plan	09/03/2011	12/03/2012	2	23/03/2012	20/03/2012	BMCE-TRANSMIT-008088	10/04/2012	11/06/2012	B	BMCE-TRANSMIT-009465 22/06/12	
			NA	NA-xx-11-PL-321-150	Eleventh Floor Plan - Glazed Screen Types Strategy Plan	09/03/2011	12/03/2012	2	23/03/2012	20/03/2012	BMCE-TRANSMIT-008088	10/04/2012	11/06/2012	B	BMCE-TRANSMIT-009465 22/06/12	
	Glazed Screen Strategy Plans (1:200)		NA	NA-XX-00-PL-321-100	Ground Floor Plan - NSGH Entrance Reception and Atrium Space - Glazed Screen Types Strategy Plan	09/03/2011	12/03/2012	2	23/03/2012	20/03/2012 02/07/12	BMCE-TRANSMIT-008088 BMCE-TRANSMIT-009629	10/04/2012 23/07/12	11/06/2012	B	BMCE-TRANSMIT-009465 22/06/12	
			NA	NA-XX-00-PL-321-101	Ground Floor Plan - NCH Rehab - Glazed Screen Types Strategy Plan	09/03/2011	12/03/2012	2	23/03/2012	20/03/2012	BMCE-TRANSMIT-008088	10/04/2012	11/06/2012	B	BMCE-TRANSMIT-009465 22/06/12	
			NA	NA-XX-00-PL-321-102	Ground Floor Plan - NCH Entrance and OPD - Glazed Screen Types Strategy Plan	09/03/2011	12/03/2012	2	23/03/2012	20/03/2012	BMCE-TRANSMIT-008088	10/04/2012	11/06/2012	B	BMCE-TRANSMIT-009465 22/06/12	

BCL-AC-XX-SH-001			Action By	Drawing Number	Drawing Title	1st Submission										P C
Date Required from Consultant	Date Submitted by Consultant	Document Revision				Planned Date to be Submitted to Board	Date Submitted to Board	BMCE Transmittal No	Date Response Required from Board (+3 Weeks)	Date Received from Board	Board Status	Date Returned to Consultant				
Item	Submission	Comments														
			NA	NA-XX-01-PL-321-101	First Floor Plan - NCH Theatres / Interventional Radiology and Radiology - Glazed Screen Types Strategy Plan	09/03/2011	12/03/2012	2	23/03/2012	20/03/2012	BMCE-TRANSMIT-008088	10/04/2012	11/06/2012	B	BMCE-TRANSMIT-009465 22/06/12	
			NA	NA-XX-01-PL-321-102	First Floor Plan - NCH 23 Hour Unit - Glazed Screen Types Strategy Plan	09/03/2011	12/03/2012	2	23/03/2012	20/03/2012	BMCE-TRANSMIT-008088	10/04/2012	11/06/2012	B	BMCE-TRANSMIT-009465 22/06/12	
			NA	NA-XX-01-PL-321-103	First Floor Plan - NCH Critical Care (PICU) / Cardiology Ward / Support / MDU and Special Feeds - Glazed Screen Types Strategy Plan	09/03/2011	12/03/2012	2	23/03/2012	20/03/2012	BMCE-TRANSMIT-008088	10/04/2012	11/06/2012	B	BMCE-TRANSMIT-009465 22/06/12	
			NA	NA-XX-01-PL-321-104	First Floor Plan - NSGH CCU and Critical Care (1 of 2) - Glazed Screen Types Strategy Plan	09/03/2011	12/03/2012	2	23/03/2012	20/03/2012	BMCE-TRANSMIT-008088	10/04/2012	11/06/2012	A	BMCE-TRANSMIT-009465 22/06/12	
			NA	NA-XX-01-PL-321-105	First Floor Plan - NSGH Critical Care (2 of 2) - Glazed Screen Types Strategy Plan	09/03/2011	12/03/2012	2	23/03/2012	20/03/2012	BMCE-TRANSMIT-008088	10/04/2012	11/06/2012	A	BMCE-TRANSMIT-009465 22/06/12	
			NA	NA-XX-01-PL-321-106	First Floor Plan - NSGH Stroke Ward / MDU - Glazed Screen Types Strategy Plan	09/03/2011	12/03/2012	2	23/03/2012	20/03/2012	BMCE-TRANSMIT-008088	10/04/2012	11/06/2012	B	BMCE-TRANSMIT-009465 22/06/12	
			NA	NA-XX-01-PL-321-107	First Floor Plan - NSGH Radiology - Glazed Screen Types Strategy Plan	09/03/2011	12/03/2012	2	23/03/2012	20/03/2012	BMCE-TRANSMIT-008088	10/04/2012	11/06/2012	B	BMCE-TRANSMIT-009465 22/06/12	
			NA	NA-XX-01-PL-321-108	First Floor Plan - NSGH Nuclear Medicine - Glazed Screen Types Strategy Plan	09/03/2011	12/03/2012	2	23/03/2012	20/03/2012	BMCE-TRANSMIT-008088	10/04/2012	11/06/2012	B	BMCE-TRANSMIT-009465 22/06/12	
			NA	NA-XX-01-PL-321-109	First Floor Plan - NSGH OPD & Pre-op Assessment - Glazed Screen Types Strategy Plan	09/03/2011	12/03/2012	2	23/03/2012	20/03/2012	BMCE-TRANSMIT-008088	10/04/2012	11/06/2012	B	BMCE-TRANSMIT-009465 22/06/12	
			NA	NA-XX-02-PL-321-100	Second Floor Plan - NSGH Atrium - Glazed Screen Types Strategy Plan	09/03/2011	12/03/2012	2	23/03/2012	20/03/2012	BMCE-TRANSMIT-008088	10/04/2012	11/06/2012	A	BMCE-TRANSMIT-009465 22/06/12	
			NA	NA-XX-02-PL-321-101	Second Floor Plan - NSGH Dermatology Ward Plant - Glazed Screen Types Strategy Plan	09/03/2011	12/03/2012	2	23/03/2012	20/03/2012	BMCE-TRANSMIT-008088	10/04/2012	11/06/2012	B	BMCE-TRANSMIT-009465 22/06/12	
			NA	NA-XX-02-PL-321-102	Second Floor Plan - NCH Schiehallion Ward / Day Case Unit / Theatres and Anaesthetic Service Offices - Glazed Screen Types Strategy Plan	09/03/2011	12/03/2012	2	23/03/2012	20/03/2012	BMCE-TRANSMIT-008088	10/04/2012	11/06/2012	B	BMCE-TRANSMIT-009465 22/06/12	
			NA	NA-XX-02-PL-321-103	Second Floor Plan - NCH Acute Receiving Ward / Aseptic Suite - Glazed Screen Types Strategy Plan	09/03/2011	12/03/2012	2	23/03/2012	20/03/2012	BMCE-TRANSMIT-008088	10/04/2012	11/06/2012	A	BMCE-TRANSMIT-009465 22/06/12	
			NA	NA-XX-02-PL-321-104	Second Floor Plan - NSGH Endoscopy / Decontamination / Medical Physics / Stores - Glazed Screen Types Strategy Plan	09/03/2011	12/03/2012	2	23/03/2012	20/03/2012	BMCE-TRANSMIT-008088	10/04/2012	11/06/2012	B	BMCE-TRANSMIT-009465 22/06/12	
			NA	NA-XX-02-PL-321-105	Second Floor Plan - NSGH Theatres (1 of 2) Plant - Glazed Screen Types Strategy Plan	09/03/2011	12/03/2012	2	23/03/2012	20/03/2012	BMCE-TRANSMIT-008088	10/04/2012	11/06/2012	B	BMCE-TRANSMIT-009465 22/06/12	
			NA	NA-XX-02-PL-321-106	Second Floor Plan - NSGH Theatres (2 of 2) Plant - Glazed Screen Types Strategy Plan	09/03/2011	12/03/2012	2	23/03/2012	20/03/2012	BMCE-TRANSMIT-008088	10/04/2012	11/06/2012	B	BMCE-TRANSMIT-009465 22/06/12	
			NA	NA-XX-02-PL-321-109	Second Floor Plan - NSGH Dermatology OPD / Renal Dialysis - Glazed Screen Types Strategy Plan	09/03/2011	12/03/2012	2	23/03/2012	20/03/2012	BMCE-TRANSMIT-008088	10/04/2012	11/06/2012	B	BMCE-TRANSMIT-009465 22/06/12	
			NA	NA-xx-03-PL-321-100	Third Floor Plan - NSGH Atrium / Health Records / FM /Staff Change - Glazed Screen Types Strategy Plan	09/03/2011	12/03/2012	2	23/03/2012	20/03/2012	BMCE-TRANSMIT-008088	10/04/2012	11/06/2012	B	BMCE-TRANSMIT-009465 22/06/12	
			NA	NA-xx-03-PL-321-102	Third Floor Plan - NCH In-Patient Ward / Medicinema - Glazed Screen Types Strategy Plan	09/03/2011	12/03/2012	2	23/03/2012	20/03/2012	BMCE-TRANSMIT-008088	10/04/2012	11/06/2012	A	BMCE-TRANSMIT-009465 22/06/12	
			NA	NA-xx-03-PL-321-103	Third Floor Plan - NCH In-Patient Ward / Ward Support / Renal Day Case - Glazed Screen Types Strategy Plan	09/03/2011	12/03/2012	2	23/03/2012	20/03/2012	BMCE-TRANSMIT-008088	10/04/2012	11/06/2012	B	BMCE-TRANSMIT-009465	

[illegible]

19		BCL-AC-XX-SH-001				1st Submission														
						Action By	Zone	Drawing Number	Drawing Title	Date Required from Consultant	Date Submitted by Consultant	Document Revision	Planned Date to be Submitted to Board	Date Submitted to Board	Date Response Required from Board (+3 Weeks)	Date Returned from Board	Board Status	Date returned to Consultant	Date Required from Consultant	Date Submitted by Consultant
Item	Submission	Comments																		
19	Light Fittings all Areas	Colour, Maintenance, Lifecycle, H & S																		
		Mercury Lighting Calculations	MER	A	ME-XX-XX-SP-541-101	Lighting Calculations - Zone A			A					31/01/2014	21/02/14 BMCE-TRANSMIT-019243 /BMCF-WTRAN-019243	03/03/2014	C	17/03/14 BMCE-TRANSMIT-019698		
					ME-XX-XX-SP-541-102	Lighting Calculations - Zone B			A					31/01/2014	21/02/14 BMCE-TRANSMIT-019243 /BMCF-WTRAN-019243	03/03/2014	C	17/03/14 BMCE-TRANSMIT-019698		
					ME-XX-XX-SP-541-103	Lighting Calculations - Zone C			A					31/01/2014	21/02/14 BMCE-TRANSMIT-019243 /BMCF-WTRAN-019243	03/03/2014	C	17/03/14 BMCE-TRANSMIT-019698		
					ME-XX-XX-SP-541-104	Lighting Calculations - Zone D			A					31/01/2014	21/02/14 BMCE-TRANSMIT-019243 /BMCF-WTRAN-019243	03/03/2014	C	17/03/14 BMCE-TRANSMIT-019698		
					ME-XX-XX-SP-541-105	Lighting Calculations - Zone E			A					31/01/2014	21/02/14 BMCE-TRANSMIT-019243 /BMCF-WTRAN-019243	03/03/2014	C	17/03/14 BMCE-TRANSMIT-019698		
					ME-XX-XX-SP-541-106	Lighting Calculations - Zone F			A					31/01/2014	21/02/14 BMCE-TRANSMIT-019243 /BMCF-WTRAN-019243	03/03/2014	C	17/03/14 BMCE-TRANSMIT-019698		
					ME-XX-XX-SP-541-107	Lighting Calculations - Zone G			A					31/01/2014	21/02/14 BMCE-TRANSMIT-019243 /BMCF-WTRAN-019243	03/03/2014	C	17/03/14 BMCE-TRANSMIT-019698		
		H&S			ME-XX-XX-SP-541-108	Lighting Calculations - Zone H			A					31/01/2014	21/02/14 BMCE-TRANSMIT-019243 /BMCF-WTRAN-019243	03/03/2014	C	17/03/14 BMCE-TRANSMIT-019698		
					ME-XX-XX-SP-541-109	Lighting Calculations - Zone J			A					31/01/2014	21/02/14 BMCE-TRANSMIT-019243 /BMCF-WTRAN-019243	03/03/2014	C	17/03/14 BMCE-TRANSMIT-019698		
					ME-XX-XX-SP-541-110	Lighting Calculations - Zone K			A					31/01/2014	21/02/14 BMCE-TRANSMIT-019243 /BMCF-WTRAN-019243	03/03/2014	C	17/03/14 BMCE-TRANSMIT-019698		
					ME-XX-XX-SP-541-111	Lighting Calculations - Adults Atria			A					31/01/2014	21/02/14 BMCE-TRANSMIT-019243 /BMCF-WTRAN-019243	03/03/2014	C	17/03/14 BMCE-TRANSMIT-019698		
					ME-XX-XX-SP-541-112	Lighting Calculations - Childrens Atria			A					31/01/2014	21/02/14 BMCE-TRANSMIT-019243 /BMCF-WTRAN-019243	03/03/2014	C	17/03/14 BMCE-TRANSMIT-019698		
					ME-XX-XX-SP-541-113	Lighting Calculations - External Lighting			A					31/01/2014	21/02/14 BMCE-TRANSMIT-019243 /BMCF-WTRAN-019243	03/03/2014	C	17/03/14 BMCE-TRANSMIT-019698		
					ME-XX-XX-SP-541-114	Lighting Calculations - Generic Calculations			A					31/01/2014	21/02/14 BMCE-TRANSMIT-019243 /BMCF-WTRAN-019243	03/03/2014	C	17/03/14 BMCE-TRANSMIT-019698		
	LUMINAIRES TECHINCAL		MER		ME-XX-XX-DC-541-100	LUM NAIRES TECH NCAL SUBMITTAL			A					10/02/12	10/02/12 BMCE-TRANSMIT-008066	01/03/12	B	15/03/12 BMCE-TRANSMIT-008066		
	ZBP Lighting		ZBP		ZBP-XX-XX-SP-541-205	Lighting Installation		03/02/12	B	24/02/12	29/02/12			21/03/12 BMCE-TRANSMIT-007868 /BMCF-WTRAN-007868	11/05/12	B	24/05/12 BMCE-TRANSMIT-009066			
			ZBP		ZBP-XX-XX-SP-541-248	Lighting Calcs & Lumiaire Selection		03/02/12	B	24/02/12	29/02/12			21/03/12 BMCE-TRANSMIT-007868 /BMCF-WTRAN-007868	11/05/12	A	24/05/12 BMCE-TRANSMIT-009066			
	Aspect of review:		MER																	
	Colour																			
	Maintenance																			
	Lifecycle																			

20
Item

[illegible]

20
Item

[illegible]

[illegible]

RDD MASTER SCHEDULE - NHS Greater Glasgow & Clyde / New South Glasgow Hospitals (NSGH) Project - Adults & Childrens Hospital					Brookfield Multiplex Europe									
					Drawing Information									
BCL-AC-XX-SH-001					1st Submission									
		Action By	Drawing Number	Drawing Title	Date Required from Consultant	Date Submitted by Consultant	Document Revision	Planned Date to be Submitted to Board	Date Submitted to Board	BMCE Transmittal No	Date Response Required from Board	Date Received from Board	Board Status	Date Returned to Consultant
Submission	Comments													
Ceiling Layouts	Colour, Maintenance, Lifecycle, H & S													
Ceiling Types & Finishes Strategy Plans (1:300)	BM to meet with Board to agree final sign off. Darren Pike to organise	NA	NA-XX-B1-PL-332-150	Basement - Ceiling Strategy Plan	13/01/2012	13/01/2012	4	27/01/2012	29/02/2012	BMCE-TRANSMIT-007869	21/03/2012		B	BMCE-TRANSMIT-009650 03/07/12
		NA	NA-XX-00-PL-332-150	Ground Floor - Ceiling Finishes Strategy Plan	13/01/2012	13/01/2012	4	27/01/2012	29/02/2012	BMCE-TRANSMIT-007869	21/03/2012		B	BMCE-TRANSMIT-009650 03/07/12
		NA	NA-XX-01-PL-332-150	First Floor - Ceiling Finishes Strategy Plan	13/01/2012	13/01/2012	4	27/01/2012	29/02/2012	BMCE-TRANSMIT-007869	21/03/2012		B	BMCE-TRANSMIT-009650 03/07/12
(Note: NHS Board to identify specific rooms where 1:20 ceiling plans are required)		NA	NA-XX-02-PL-332-150	Second Floor - Ceiling Finishes Strategy Plan	13/01/2012	13/01/2012	4	27/01/2012	29/02/2012	BMCE-TRANSMIT-007869	21/03/2012		B	BMCE-TRANSMIT-009650 03/07/12
		NA	NA-xx-03-PL-332-150	Third Floor - Ceiling Finishes Strategy Plan	13/01/2012	13/01/2012	4	27/01/2012	29/02/2012	BMCE-TRANSMIT-007869	21/03/2012		B	BMCE-TRANSMIT-009650 03/07/12
		NA	NA-xx-04-PL-332-150	Fourth Floor - Ceiling Finishes Strategy Plan	13/01/2012	13/01/2012	4	27/01/2012	29/02/2012	BMCE-TRANSMIT-007869	21/03/2012		B	BMCE-TRANSMIT-009650 03/07/12
		NA	NA-xx-05-PL-332-150	Fifth Floor - Ceiling Finishes Strategy Plan	13/01/2012	13/01/2012	4	27/01/2012	29/02/2012	BMCE-TRANSMIT-007869	21/03/2012		B	BMCE-TRANSMIT-009650 03/07/12
		NA	NA-xx-06-PL-332-150	Sixth Floor - Ceiling Finishes Strategy Plan	13/01/2012	13/01/2012	4	27/01/2012	29/02/2012	BMCE-TRANSMIT-007869	21/03/2012		B	BMCE-TRANSMIT-009650 03/07/12
	NA-XX-06-PL-332-150 Used as typical strategy plan for upper floors, drawing does not exist	NA	NA-xx-07-PL-332-150	Seventh Floor - Ceiling Finishes Strategy Plan	13/01/2012			27/01/2012						
	NA-XX-06-PL-332-150 Used as typical strategy plan for upper floors, drawing does not exist	NA	NA-xx-08-PL-332-150	Eighth Floor - Ceiling Finishes Strategy Plan	13/01/2012			27/01/2012						
	NA-XX-06-PL-332-150 Used as typical strategy plan for upper floors, drawing does not exist	NA	NA-xx-09-PL-332-150	Ninth Floor - Ceiling Finishes Strategy Plan	13/01/2012			27/01/2012						
	NA-XX-06-PL-332-150 Used as typical strategy plan for upper floors, drawing does not exist	NA	NA-xx-10-PL-332-150	Tenth Floor - Ceiling Finishes Strategy Plan	13/01/2012			27/01/2012						
	NA-XX-06-PL-332-150 Used as typical strategy plan for upper floors, drawing does not exist	NA	NA-xx-11-PL-332-150	Eleventh Floor - Ceiling Finishes Strategy Plan	13/01/2012			27/01/2012						
		NA	NA-XX-B1-PL-332-100	Basement Plan - FM & Distribution / Stores / Bed Maintenance / AGV Charging - Ceiling Finishes Strategy Plan	13/01/2012	13/01/2012	2	27/01/2012	29/02/2012	BMCE-TRANSMIT-007869	21/03/2012		B	BMCE-TRANSMIT-009650 03/07/12
		NA	NA-XX-B1-PL-332-101	Basement Plan - Kitchen / FM & Distribution / Stores - Ceiling Finishes Strategy Plan	13/01/2012	13/01/2012	2	27/01/2012	29/02/2012	BMCE-TRANSMIT-007869	21/03/2012		B	BMCE-TRANSMIT-009650 03/07/12
		NA	NA-XX-00-PL-332-100	Ground Floor Plan - NSGH Entrance Reception and Atrium Space - Ceiling Finishes Strategy Plan	13/01/2012	13/01/2012	2	27/01/2012	29/02/2012	BMCE-TRANSMIT-007869	21/03/2012		B	BMCE-TRANSMIT-009650 03/07/12
		NA	NA-XX-00-PL-332-101	Ground Floor Plan - NCH Rehab - Ceiling Finishes Strategy Plan	13/01/2012	13/01/2012	2	27/01/2012	29/02/2012	BMCE-TRANSMIT-007869	21/03/2012		B	BMCE-TRANSMIT-009651 04/07/12
		NA	NA-XX-00-PL-332-102	Ground Floor Plan - NCH Entrance and OPD - Ceiling Finishes Strategy Plan	13/01/2012	13/01/2012	2	27/01/2012	29/02/2012	BMCE-TRANSMIT-007869	21/03/2012		B	BMCE-TRANSMIT-009650 03/07/12
		NA	NA-XX-00-PL-332-103	Ground Floor Plan - NCH Observation Ward / Child Protection / Sanctuary - Ceiling Finishes Strategy Plan	13/01/2012	13/01/2012	2	27/01/2012	29/02/2012	BMCE-TRANSMIT-007869	21/03/2012		B	BMCE-TRANSMIT-009651 04/07/12
		NA	NA-XX-00-PL-332-104	Ground Floor Plan - NCH Emergency Department / Decontamination Unit - Ceiling Finishes Strategy Plan	13/01/2012	13/01/2012	2	27/01/2012	29/02/2012	BMCE-TRANSMIT-007869	21/03/2012		B	BMCE-TRANSMIT-009650 03/07/12

RDD MASTER SCHEDULE - NHS Greater Glasgow & Clyde / New South Glasgow Hospitals (NSGH) Project - Adults & Childrens Hospital					Brookfield Multiplex Europe									
BCL-AC-XX-SH-001					Drawing Information									
					1st Submission									
					Date Required from Consultant	Date Submitted by Consultant	Document Revision	Planned Date to be Submitted to Board	Date Submitted to Board	BMCE Transmittal No	Date Response Required from Board	Date Received from Board	Board Status	Date Returned to Consultant
Submission	Comments													
		NA	NA-XX-01-PL-332-105	First Floor Plan - NSGH Critical Care (2 of 2) - Ceiling Finishes Strategy Plan	13/01/2012	13/01/2012	2	27/01/2012	29/02/2012	BMCE-TRANSMIT-007869	21/03/2012		B	BMCE-TRANSMIT-009651 04/07/12
		NA	NA-XX-01-PL-332-106	First Floor Plan - NSGH Stroke Ward / MDU - Ceiling Finishes Strategy Plan	13/01/2012	13/01/2012	2	27/01/2012	29/02/2012	BMCE-TRANSMIT-007869	21/03/2012		B	BMCE-TRANSMIT-009650 03/07/12
		NA	NA-XX-01-PL-332-107	First Floor Plan - NSGH Radiology - Ceiling Finishes Strategy Plan	13/01/2012	13/01/2012	3	27/01/2012	29/02/2012	BMCE-TRANSMIT-007869	21/03/2012		B	BMCE-TRANSMIT-009650 03/07/12
		NA	NA-XX-01-PL-332-108	First Floor Plan - NSGH Nuclear Medicine - Ceiling Finishes Strategy Plan	13/01/2012	13/01/2012	3	27/01/2012	29/02/2012	BMCE-TRANSMIT-007869	21/03/2012		B	BMCE-TRANSMIT-009650 03/07/12
		NA	NA-XX-01-PL-332-109	First Floor Plan - NSGH OPD & Pre-op Assessment - Ceiling Finishes Strategy Plan	13/01/2012	13/01/2012	2	27/01/2012	29/02/2012	BMCE-TRANSMIT-007869	21/03/2012		B	BMCE-TRANSMIT-009650 03/07/12
		NA	NA-XX-02-PL-332-100	Second Floor Plan - NSGH Atrium - Ceiling Finishes Strategy Plan	13/01/2012	13/01/2012	2	27/01/2012	29/02/2012	BMCE-TRANSMIT-007869	21/03/2012		B	BMCE-TRANSMIT-009650 03/07/12
		NA	NA-XX-02-PL-332-101	Second Floor Plan - NSGH Dermatology Ward Plant - Ceiling Finishes Strategy Plan	13/01/2012	13/01/2012	2	27/01/2012	29/02/2012	BMCE-TRANSMIT-007869	21/03/2012		B	BMCE-TRANSMIT-009650 03/07/12
		NA	NA-XX-02-PL-332-102	Second Floor Plan - NCH Schiehallion Ward / Day Case Unit / Theatres and Anaesthetic Service Offices - Ceiling Finishes Strategy Plan	13/01/2012	13/01/2012	2	27/01/2012	29/02/2012	BMCE-TRANSMIT-007869	21/03/2012		B	BMCE-TRANSMIT-009650 03/07/12
		NA	NA-XX-02-PL-332-103	Second Floor Plan - NCH Acute Receiving Ward / Aseptic Suite - Ceiling Finishes Strategy Plan	13/01/2012	13/01/2012	2	27/01/2012	29/02/2012	BMCE-TRANSMIT-007869	21/03/2012		B	BMCE-TRANSMIT-009651 04/07/12
		NA	NA-XX-02-PL-332-104	Second Floor Plan - NSGH Endoscopy / Decontamination / Medical Physics / Stores - Ceiling Finishes Strategy Plan	13/01/2012	13/01/2012	2	27/01/2012	29/02/2012	BMCE-TRANSMIT-007869	21/03/2012		B	BMCE-TRANSMIT-009650 03/07/12
		NA	NA-XX-02-PL-332-105	Second Floor Plan - NSGH Theatres (1 of 2) Plant - Ceiling Finishes Strategy Plan	13/01/2012	13/01/2012	2	27/01/2012	29/02/2012	BMCE-TRANSMIT-007869	21/03/2012		B	BMCE-TRANSMIT-009650 03/07/12
		NA	NA-XX-02-PL-332-106	Second Floor Plan - NSGH Theatres (2 of 2) Plant - Ceiling Finishes Strategy Plan	13/01/2012	13/01/2012	2	27/01/2012	29/02/2012	BMCE-TRANSMIT-007869	21/03/2012		B	BMCE-TRANSMIT-009650 03/07/12
		NA	NA-XX-02-PL-332-109	Second Floor Plan - NSGH Dermatology OPD / Renal Dialysis - Ceiling Finishes Strategy Plan	13/01/2012	13/01/2012	2	27/01/2012	29/02/2012	BMCE-TRANSMIT-007869	21/03/2012		B	BMCE-TRANSMIT-009650 03/07/12
		NA	NA-xx-03-PL-332-100	Third Floor Plan - NSGH Atrium / Health Records / FM / Staff Change - Ceiling Finishes Strategy Plan	13/01/2012	13/01/2012	2	27/01/2012	29/02/2012	BMCE-TRANSMIT-007869	21/03/2012		B	BMCE-TRANSMIT-009650 03/07/12
		NA	NA-xx-03-PL-332-101	Third Floor Plan - PLANT - Ceiling Finishes Strategy Plan	13/01/2012	13/01/2012	2	27/01/2012	29/02/2012	BMCE-TRANSMIT-007869	21/03/2012		B	BMCE-TRANSMIT-009650 03/07/12
		NA	NA-xx-03-PL-332-102	Third Floor Plan - NCH In-Patient Ward / Medicinema - Ceiling Finishes Strategy Plan	13/01/2012	13/01/2012	2	27/01/2012	29/02/2012	BMCE-TRANSMIT-007869	21/03/2012		B	BMCE-TRANSMIT-009650 03/07/12
		NA	NA-xx-03-PL-332-103	Third Floor Plan - NCH In-Patient Ward / Ward Support / Renal Day Case - Ceiling Finishes Strategy Plan	13/01/2012	13/01/2012	2	27/01/2012	29/02/2012	BMCE-TRANSMIT-007869	21/03/2012		B	BMCE-TRANSMIT-009650 03/07/12
		NA	NA-xx-03-PL-332-105	Third Floor Plan - PLANT - Ceiling Finishes Strategy Plan	13/01/2012	13/01/2012	2	27/01/2012	29/02/2012	BMCE-TRANSMIT-007869	21/03/2012		B	BMCE-TRANSMIT-009650 03/07/12
		NA	NA-xx-03-PL-332-106	Third Floor Plan - PLANT - Ceiling Finishes Strategy Plan	13/01/2012	13/01/2012	2	27/01/2012	29/02/2012	BMCE-TRANSMIT-007869	21/03/2012		B	BMCE-TRANSMIT-009650 03/07/12
		NA	NA-xx-03-PL-332-109	Third Floor Plan - PLANT - Ceiling Finishes Strategy Plan	13/01/2012	13/01/2012	2	27/01/2012	29/02/2012	BMCE-TRANSMIT-007869	21/03/2012		B	BMCE-TRANSMIT-009650 03/07/12
		NA	NA-xx-04-PL-332-100	Fourth Floor Plan - NSGH Atrium Lift Core / Generic Ward Support - Ceiling Finishes Strategy Plan	13/01/2012	13/01/2012	2	27/01/2012	29/02/2012	BMCE-TRANSMIT-007869	21/03/2012		B	BMCE-TRANSMIT-009651 04/07/12
		NA	NA-xx-04-PL-332-101	Fourth Floor Plan - Higher Acuity Renal Ward - Ceiling Finishes Strategy Plan	13/01/2012	13/01/2012	2	27/01/2012	29/02/2012	BMCE-TRANSMIT-007869	21/03/2012		B	BMCE-TRANSMIT-009650

RDD MASTER SCHEDULE - NHS Greater Glasgow & Clyde / New South Glasgow Hospitals (NSGH) Project - Adults & Childrens Hospital					Brookfield Multiplex Europe									
BCL-AC-XX-SH-001					Drawing Information									
					1st Submission									
		Action By	Drawing Number	Drawing Title	Date Required from Consultant	Date Submitted by Consultant	Document Revision	Planned Date to be Submitted to Board	Date Submitted to Board	BMCE Transmittal No	Date Response Required from Board	Date Received from Board	Board Status	Date Returned to Consultant
Submission	Comments													
		NA	NA-xx-05-PL-332-104	Fifth Floor Plan - NSGH Generic Ward (4 of 4) - Ceiling Finishes Strategy Plan	13/01/2012	13/01/2012	2	27/01/2012	29/02/2012	BMCE-TRANSMIT-007869	21/03/2012		B	BMCE-TRANSMIT-009650 03/07/12
		NA	NA-xx-05-PL-332-106	Fifth Floor Plan - NCH Plant - Ceiling Finishes Strategy Plan	13/01/2012	13/01/2012	2	27/01/2012	29/02/2012	BMCE-TRANSMIT-007869	21/03/2012		B	BMCE-TRANSMIT-009650 03/07/12
			NA-xx-06-PL-332-100	Sixth Floor Plan - NCH Plant - Ceiling Finishes Strategy Plan	13/01/2012	13/01/2012	2	27/01/2012	29/02/2012	BMCE-TRANSMIT-007869	21/03/2012		B	BMCE-TRANSMIT-009651 04/07/12
			NA-xx-06-PL-332-101	Sixth Floor Plan - NCH Plant - Ceiling Finishes Strategy Plan	13/01/2012	13/01/2012	2	27/01/2012	29/02/2012	BMCE-TRANSMIT-007869	21/03/2012		B	BMCE-TRANSMIT-009651 04/07/12
			NA-xx-07-PL-332-100	Seventh Floor Plan - NCH Plant - Ceiling Finishes Strategy Plan	13/01/2012	13/01/2012	2	27/01/2012	29/02/2012	BMCE-TRANSMIT-007869	21/03/2012		B	BMCE-TRANSMIT-009651 04/07/12

RDD MASTER SCHEDULE - NHS Greater Glasgow & Clyde / New South Glasgow Hospitals (NSGH) Project - Adults & Childrens Hospital					Brookfield Multiplex Europe									
BCL-AC-XX-SH-001					Drawing Information									
					1st Submission									
		Action By	Drawing Number	Drawing Title	Date Required from Consultant	Date Submitted by Consultant	Document Revision	Planned Date to be Submitted to Board	Date Submitted to Board	BMCE Transmittal No	Date Response Required from Board	Date Received from Board	Board Status	Date Returned to Consultant
Submission	Comments													
			NA-xx-08-PL-332-100	Eighth Floor Plan - NCH Plant - Ceiling Finishes Strategy Plan	13/01/2012	13/01/2012	2	27/01/2012	29/02/2012	BMCE-TRANSMIT-007869	21/03/2012		B	BMCE-TRANSMIT-009651 04/07/12
			NA-xx-09-PL-332-100	Ninth Floor Plan - NCH Plant - Ceiling Finishes Strategy Plan	13/01/2012	13/01/2012	2	27/01/2012	29/02/2012	BMCE-TRANSMIT-007869	21/03/2012		B	BMCE-TRANSMIT-009651 04/07/12
			NA-xx-10-PL-332-100	Tenth Floor Plan - NCH Plant - Ceiling Finishes Strategy Plan	13/01/2012	13/01/2012	2	27/01/2012	29/02/2012	BMCE-TRANSMIT-007869	21/03/2012		B	BMCE-TRANSMIT-009651 04/07/12
			NA-xx-11-PL-332-100	Eleventh Floor Plan - NCH Plant - Ceiling Finishes Strategy Plan	13/01/2012	13/01/2012	2	27/01/2012	29/02/2012	BMCE-TRANSMIT-007869	21/03/2012		B	BMCE-TRANSMIT-009651 04/07/12
			NA-xx-11-PL-332-101	Eleventh Floor Plan - NCH Plant - Ceiling Finishes Strategy Plan	13/01/2012	13/01/2012	2	27/01/2012	29/02/2012	BMCE-TRANSMIT-007869	21/03/2012		B	BMCE-TRANSMIT-009651 04/07/12
			NA-xx-12-PL-332-100	Twelfth Floor Plan - NCH Plant - Ceiling Finishes Strategy Plan	13/01/2012	13/01/2012	2	27/01/2012	29/02/2012	BMCE-TRANSMIT-007869	21/03/2012		B	BMCE-TRANSMIT-009651 04/07/12
			NA-xx-12-PL-332-101	Twelfth Floor Plan - NCH Plant - Ceiling Finishes Strategy Plan	13/01/2012	13/01/2012	2	27/01/2012	29/02/2012	BMCE-TRANSMIT-007869	21/03/2012		B	BMCE-TRANSMIT-009651 04/07/12
			NA-xx-12-PL-332-102	Twelfth Floor Plan - NCH Plant - Ceiling Finishes Strategy Plan	13/01/2012	13/01/2012	2	27/01/2012	29/02/2012	BMCE-TRANSMIT-007869	21/03/2012		B	BMCE-TRANSMIT-009651 04/07/12
			NA-xx-12-PL-332-103	Twelfth Floor Plan - NCH Plant - Ceiling Finishes Strategy Plan	13/01/2012	13/01/2012	2	27/01/2012	29/02/2012	BMCE-TRANSMIT-007869	21/03/2012		B	BMCE-TRANSMIT-009651 04/07/12
			NA-xx-12-PL-332-104	Twelfth Floor Plan - NCH Plant - Ceiling Finishes Strategy Plan	13/01/2012	13/01/2012	2	27/01/2012	29/02/2012	BMCE-TRANSMIT-007869	21/03/2012		B	BMCE-TRANSMIT-009651 04/07/12
			NA-xx-13-PL-332-102	Thirteenth Floor Plan - NCH Plant - Ceiling Finishes Strategy Plan	13/01/2012	13/01/2012	2	27/01/2012	29/02/2012	BMCE-TRANSMIT-007869	21/03/2012		B	BMCE-TRANSMIT-009651 04/07/12
			NA-XX-B1-PL-332-100	Basement Floor Plan - NCH Plant - Ceiling Finishes Strategy Plan	13/01/2012	13/01/2012	2	27/01/2012	29/02/2012	BMCE-TRANSMIT-007869	21/03/2012		B	BMCE-TRANSMIT-009651 04/07/12

RDD MASTER SCHEDULE - NHS Greater Glasgow & Clyde / New South Glasgow Hospitals (NSGH) Project - Adults & Childrens Hospital					Brookfield Multiplex Europe									
BCL-AC-XX-SH-001					Drawing Information									
					1st Submission									
		Action By	Drawing Number	Drawing Title	Date Required from Consultant	Date Submitted by Consultant	Document Revision	Planned Date to be Submitted to Board	Date Submitted to Board	BMCE Transmittal No	Date Response Required from Board	Date Received from Board	Board Status	Date Returned to Consultant
Submission	Comments													
			NA-XX-B1-PL-332-101	Basement Floor Plan - NCH Plant - Ceiling Finishes Strategy Plan	13/01/2012	13/01/2012	2	27/01/2012	29/02/2012	BMCE-TRANSMIT-007869	21/03/2012		B	BMCE-TRANSMIT-009651 04/07/12
1:50 Reflected Ceiling Plans	The following matters are shown on the 1:50 scale ceiling plans:	NA/ZBP/IMER	NA-ZK-B1-PL-332-501	Basement Ceiling Plan - Food Waste, Renal Tanks & FM Core D	08/11/2013	22/07/2013	C		08/08/2013	BMCE-TRANSMIT-017207	29/08/2013	19/08/2013	B	BMCE-TRANSMIT-017463 26/08/2013

RDD MASTER SCHEDULE - NHS Greater Glasgow & Clyde / New South Glasgow Hospitals (NSGH) Project - Adults & Childrens Hospital					Brookfield Multiplex Europe									
BCL-AC-XX-SH-001					Drawing Information									
					1st Submission									
		Action By	Drawing Number	Drawing Title	Date Required from Consultant	Date Submitted by Consultant	Document Revision	Planned Date to be Submitted to Board	Date Submitted to Board	BMCE Transmittal No	Date Response Required from Board	Date Received from Board	Board Status	Date Returned to Consultant
Submission	Comments													
	(1) The locations and setting-out of each ceiling type and height agreed in the Strategy Drawings	NA/ZBP/MER	NA-SZ-B1-PL-332-502	Basement Ceiling Plan - AGV Charging & FM Core C	08/11/2013	22/07/2013	C		08/08/2013	BMCE-TRANSMIT-017463	29/08/2013	19/08/2013	B	BMCE-TRANSMIT-017463 26/08/2013
	(1) The locations and setting-out of ceiling void cavity barriers as required in the Fire Strategy	NA/ZBP/MER	NA-SZ-B1-PL-332-503	Basement Ceiling Plan - Pharmacy Holding Area & FM Core M	08/11/2013	31/10/2013	C		04/12/2013	BMCE-TRANSMIT-0186874	08/01/2014	03/01/2014	A	BMCE-TRANSMIT-018984 09/01/2014
	(3) The locations and setting-out of feature bulkheads and dropped ceiling bulkheads	NA/ZBP/MER	NA-ZF-B1-PL-332-504	Basement Ceiling Plan - Catering (1 of 2)	08/11/2013	28/06/2013	B		17/02/2014	BMCE-TRANSMIT-019437	10/03/2014	03/03/2014	A	BMCE-TRANSMIT-019626 10/03/2014
	(4) The co-ordinated location and setting-out of all ceiling mounted equipment and hospital services	NA/ZBP/MER	NA-SZ-B1-PL-332-505	Basement Ceiling Plan - Catering (2 of 2)	08/11/2013	28/06/2013	B		17/02/2014	BMCE-TRANSMIT-019437	10/03/2014	03/03/2014	A	BMCE-TRANSMIT-019626 10/03/2014
	(5) The co-ordinated location and setting-out of ceiling mounted lighting services to all areas	NA/ZBP/MER	NA-SZ-B1-PL-332-506	Basement Ceiling Plan - Tunnel, FM Stores & FM Core G	08/11/2013	28/06/2013	B		17/02/2014	BMCE-TRANSMIT-019437	10/03/2014	03/03/2014	A	BMCE-TRANSMIT-019626 10/03/2014
	(6) The co-ordinated location and setting-out of ceiling mounted mechanical services to all areas	NA/ZBP/MER	NA-SZ-B1-PL-332-507	Basement Ceiling Plan - Sprinkler Tanks	08/11/2013	28/06/2013	B		17/02/2014	BMCE-TRANSMIT-019437	10/03/2014	03/03/2014	A	BMCE-TRANSMIT-019626 10/03/2014
	(7) The co-ordinated location and setting-out of ceiling mounted fire alarm/sprinkler systems to all areas	NA/ZBP/MER	NA-ZB-B1-PL-332-508	Basement Ceiling Plan - Water Tanks	08/11/2013	28/06/2013	B		17/02/2014	BMCE-TRANSMIT-019437	10/03/2014	03/03/2014	A	BMCE-TRANSMIT-019626 10/03/2014
		NA/ZBP/MER	NA-ZC-B1-PL-332-509	Basement Ceiling Plan - Pump Room & Plant	08/11/2013	28/06/2013	B		17/02/2014	BMCE-TRANSMIT-019437	10/03/2014	03/03/2014	A	BMCE-TRANSMIT-019626 10/03/2014
	Aspect of review:	NA/ZBP/MER	NA-SZ-B1-PL-332-510	Basement Ceiling Plan - Tunnel & FM Core F	08/11/2013	28/06/2013	B		17/02/2014	BMCE-TRANSMIT-019437	10/03/2014	03/03/2014	A	BMCE-TRANSMIT-019626 10/03/2014
	Clinical functionality	NA/ZBP/MER	NA-ZC-B1-PL-332-511	Basement Ceiling Plan - Tunnel Link to Labs	08/11/2013	28/06/2013	B		17/02/2014	BMCE-TRANSMIT-019437	10/03/2014	03/03/2014	A	BMCE-TRANSMIT-019626 10/03/2014
Infection control		NA/ZBP/MER	NA-SZ-00-PL-332-501	Ground Floor Ceiling Plan - NSGH Main Entrance & Public Areas (1 of 5)	24/07/2013	18/10/2013	B		04/11/2013	BMCE-TRANSMIT-018350 04/11/2013	25/11/2013	18/11/2013	B	BMCE-TRANSMIT-018542 21/11/2013
Colour		NA/ZBP/MER	NA-SZ-00-PL-332-502	Ground Floor Ceiling Plan - NSGH Main Entrance & Public Areas (2 of 5)	24/07/2013	09/12/2013	B		18/12/2013	BMCE-TRANSMIT-018896	08/01/2014	13/01/2014	A	BMCE-TRANSMIT-019143 22/01/2014
Maintenance	Waiting on NA to update re-issue	NA/ZBP/MER	NA-ZK-00-PL-332-503	Ground Floor Ceiling Plan - NSGH Main Entrance & Public Areas (3 of 5)	24/07/2013									
Lifecycle	Waiting on NA to update re-issue	NA/ZBP/MER	NA-ZK-00-PL-332-504	Ground Floor Ceiling Plan - NSGH Main Entrance & Public Areas (4 of 5)	24/07/2013	04/03/2004	C		25/03/2014	BMCE-TRANSMIT-019769	15/04/2014			
H&S		NA/ZBP/MER	NA-ZK-00-PL-332-505	Ground Floor Ceiling Plan - NSGH Main Entrance & Public Areas (5 of 5)		23/10/2013	C		06/11/2013	BMCE-TRANSMIT-018391	20/11/2013	18/11/2013	A	BMCE-TRANSMIT-018553 21/11/2013
		NA/ZBP/MER	NA-ZH-00-PL-332-506	Ground Floor Ceiling Plan - NSGH Main Entrance - Discharge Lounge	24/07/2013	11/10/2013	B		04/11/2013	BMCE-TRANSMIT-018351	18/11/2013	19/11/2013	B	BMCE-TRANSMIT-018537 21/11/2013
		NA/ZBP/MER	NA-ZF-00-PL-332-507	Ground Floor Ceiling Plan - Pharmacy Dispensary (NSGH & NCH)		23/10/2013	C		06/11/2013	BMCE-TRANSMIT-018391	20/11/2013	18/11/2013	B	BMCE-TRANSMIT-018553 21/11/2013
		NA/ZBP/MER	NA-ZF-00-PL-332-508	Ground Floor Ceiling Plan - NCH Rehabilitation Suite & Therapies	24/07/2013	20/02/2014	B		24/02/2014	BMCE-TRANSMIT-019522	17/03/2014	03/03/2014	A	BMCE-TRANSMIT-019627 10/03/2014
		NA/ZBP/MER	NA-ZC-00-PL-332-509	Ground Floor Ceiling Plan - NCH OPD (1 of 5)	13/02/2013	19/03/2013	A		16/04/2013	BMCE-TRANSMIT-015139	07/05/2013	13/05/2013	B	BMCE-TRANSMIT-015821 21/05/2013
NHS Board to identify any specifi rooms that require a 1:20 layout)		NA/ZBP/MER	NA-ZC-00-PL-332-510	Ground Floor Ceiling Plan - NCH Main Entrance & Public Areas (1 of 2)	13/02/2013	19/03/2013	B		16/04/2013	BMCE-TRANSMIT-015139	07/05/2013	13/05/2013	B	BMCE-TRANSMIT-015821 21/05/2013
		NA/ZBP/MER	NA-ZC-00-PL-332-511	Ground Floor Ceiling Plan - NCH Main Entrance & Public Areas (2 of 2)	13/02/2013	19/03/2013	A		16/04/2013	BMCE-TRANSMIT-015139	07/05/2013	13/05/2013	B	BMCE-TRANSMIT-015821 21/05/2013
		NA/ZBP/MER	NA-ZB-00-PL-332-512	Ground Floor Ceiling Plan - NCH OPD (2 of 5)	13/02/2013	19/03/2013	A		16/04/2013	BMCE-TRANSMIT-015139	07/05/2013	13/05/2013	B	BMCE-TRANSMIT-015821

RDD MASTER SCHEDULE - NHS Greater Glasgow & Clyde / New South Glasgow Hospitals (NSGH) Project - Adults & Childrens Hospital					Brookfield Multiplex Europe									
BCL-AC-XX-SH-001					Drawing Information									
					1st Submission									
		Action By	Drawing Number	Drawing Title	Date Required from Consultant	Date Submitted by Consultant	Document Revision	Planned Date to be Submitted to Board	Date Submitted to Board	BMCE Transmittal No	Date Response Required from Board	Date Received from Board	Board Status	Date Returned to Consultant
Submission	Comments													
		NA/ZBP/MER	NA-SZ-00-PL-332-522	Ground Floor Ceiling Plan - NSGH Emergency Department (2 of 4)	24/07/2013	04/07/2012	D		05/07/2012	BMCE-TRANSMIT-009684 05/07/12	26/07/2012	15/08/2012	B	BMCE-TRANSMIT-010520 27/08/12
		NA/ZBP/MER	NA-SZ-00-PL-332-523	Ground Floor Ceiling Plan - NSGH Emergency Department (3 of 4)	24/07/2013	04/07/2012	D		05/07/2012	BMCE-TRANSMIT-009684 05/07/12	26/07/2012	15/08/2012	B	BMCE-TRANSMIT-010520 27/08/12
		NA/ZBP/MER	NA-SZ-00-PL-332-524	Ground Floor Ceiling Plan - NSGH Emergency Department (4 of 4)	24/07/2013	04/07/2012	D		05/07/2012	BMCE-TRANSMIT-009684 05/07/12	26/07/2012	15/08/2012	B	BMCE-TRANSMIT-010520 27/08/12
		NA/ZBP/MER	NA-ZG-00-PL-332-525	Ground Floor Ceiling Plan - NSGH Acute Assessment Unit (1 of 6)	24/07/2013	04/07/2012	D		05/07/2012	BMCE-TRANSMIT-009684 05/07/12	26/07/2012	15/08/2012	A	BMCE-TRANSMIT-010520 27/08/12
		NA/ZBP/MER	NA-SZ-00-PL-332-526	Ground Floor Ceiling Plan - NSGH Acute Assessment Unit (2 of 6)	24/07/2013	04/07/2012	D		05/07/2012	BMCE-TRANSMIT-009684 05/07/12	26/07/2012	15/08/2012	B	BMCE-TRANSMIT-010520 27/08/12
		NA/ZBP/MER	NA-ZH-00-PL-332-527	Ground Floor Ceiling Plan - NSGH Acute Assessment Unit (3 of 6)	24/07/2013	19/02/2013	F		28/02/2013	BMCE-TRANSMIT-014266	21/03/2013	01/04/2013	A	BMCE-TRANSMIT-014986 08/04/2013
		NA/ZBP/MER	NA-ZG-00-PL-332-528	Ground Floor Ceiling Plan - NSGH Acute Assessment Unit (4 of 6)	24/07/2013	04/07/2012	D		05/07/2012	BMCE-TRANSMIT-009684 05/07/12	26/07/2012	15/08/2012	B	BMCE-TRANSMIT-010520 27/08/12
		NA/ZBP/MER	NA-SZ-00-PL-332-529	Ground Floor Ceiling Plan - NSGH Acute Assessment Unit (5 of 6)	24/07/2013	04/07/2012	D		05/07/2012	BMCE-TRANSMIT-009684 05/07/12	26/07/2012	15/08/2012	B	BMCE-TRANSMIT-010520 27/08/12
		NA/ZBP/MER	NA-ZH-00-PL-332-530	Ground Floor Ceiling Plan - NSGH Acute Assessment Unit (6 of 6)	02/03/2012	20/12/2012	A		07/02/2014	BMCE-TRANSMIT-019335	28/02/2014	03/03/2014	B	BMCE-TRANSMIT-019646 11/03/22014
		NA/ZBP/MER	NA-SZ-00-PL-332-531	Ground Floor Ceiling Plan - NSGH Radiology (1 of 3)	26/10/2012	21/12/2012	A		08/03/2012	BMCE-TRANSMIT-014427	29/03/2012	07/05/2013	B	BMCE-TRANSMIT-015559 10/05/2013
		NA/ZBP/MER	NA-ZE-00-PL-332-532	Ground Floor Ceiling Plan - NSGH Radiology (2 of 3)	26/10/2012	21/12/2012	A		08/03/2012	BMCE-TRANSMIT-014427	29/03/2012	07/05/2013	B	BMCE-TRANSMIT-015559 10/05/2013
		NA/ZBP/MER	NA-ZE-00-PL-332-533	Ground Floor Ceiling Plan - NSGH Radiology (3 of 3)	26/10/2012	21/12/2012	A		08/03/2012	BMCE-TRANSMIT-014427	29/03/2012	07/05/2013	B	BMCE-TRANSMIT-015559 10/05/2013
		NA/ZBP/MER	NA-ZE-00-PL-332-534	Ground Floor Ceiling Plan - Medical Illustration (NSGH & NCH)	26/10/2012	21/12/2012	A		08/03/2012	BMCE-TRANSMIT-014427	29/03/2012	07/05/2013	B	BMCE-TRANSMIT-015559 10/05/2013
	Waiting on NA to update re-issue	NA/ZBP/MER	NA-ZE-00-PL-332-535	Ground Floor Ceiling Plan - NCH Radiology (1 of 2)	24/07/2013									
		NA/ZBP/MER	NA-ZE-00-PL-332-536	Ground Floor Ceiling Plan - NCH Radiology (2 of 2)	24/07/2013	21/10/2013	B		04/11/2013	BMCE-TRANSMIT-018355	25/11/2013	18/11/2013	B	BMCE-TRANSMIT-018545 21/11/2013
		NA/ZBP/MER	NA-ZJ-00-PL-332-537	Ground Floor Ceiling Plan - NSGH Rehabilitation & Therapies (1 of 2)	26/10/2012	21/12/2012	A		08/03/2012	BMCE-TRANSMIT-014427	29/03/2012	07/05/2013	B	BMCE-TRANSMIT-015559 10/05/2013
		NA/ZBP/MER	NA-ZJ-00-PL-332-538	Ground Floor Ceiling Plan - NSGH Rehabilitation & Therapies (2 of 2)	26/10/2012	21/12/2012	A		08/03/2012	BMCE-TRANSMIT-014427	29/03/2012	07/05/2013	B	BMCE-TRANSMIT-015559 10/05/2013
		NA/ZBP/MER	NA-ZJ-00-PL-332-539	Ground Floor Ceiling Plan - NSGH OPD (1 of 2)	26/10/2012	21/12/2012	A		08/03/2012	BMCE-TRANSMIT-014427	29/03/2012	07/05/2013	B	BMCE-TRANSMIT-015559 10/05/2013
		NA/ZBP/MER	NA-ZJ-00-PL-332-540	Ground Floor Ceiling Plan - NSGH OPD (2 of 2)	26/10/2012	21/12/2012	A		08/03/2012	BMCE-TRANSMIT-014427	29/03/2012	07/05/2013	B	BMCE-TRANSMIT-015559 10/05/2013
			NA-ZJ-00-PL-332-541	Ground Floor Ceiling Plan - NCH Sanctuary Ceiling & Soffit Plan	13/02/2013	19/03/2013	B		16/04/2013	BMCE-TRANSMIT-015139	07/05/2013	13/05/2013	B	BMCE-TRANSMIT-015821 21/05/2013
		NA/ZBP/MER	NA-SZ-01-PL-332-501	First Floor Ceiling Plan - Restaurant, Dining & Servery (1 of 2)	24/07/2013	18/12/2013	B		12/02/2014	BMCE-TRANSMIT-019406	05/03/2014	24/02/2014	A	BMCE-TRANSMIT-019548 26/02/2014
		NA/ZBP/MER	NA-ZK-01-PL-332-502	First Floor Ceiling Plan - Restaurant, Dining & Servery (2 of 2)	24/07/2013	23/10/2013	C		06/11/2013	BMCE-TRANSMIT-018388	20/11/2013	18/11/2013	B	BMCE-TRANSMIT-018539

RDD MASTER SCHEDULE - NHS Greater Glasgow & Clyde / New South Glasgow Hospitals (NSGH) Project - Adults & Childrens Hospital					Brookfield Multiplex Europe									
BCL-AC-XX-SH-001					Drawing Information									
					1st Submission									
		Action By	Drawing Number	Drawing Title	Date Required from Consultant	Date Submitted by Consultant	Document Revision	Planned Date to be Submitted to Board	Date Submitted to Board	BMCE Transmittal No	Date Response Required from Board	Date Received from Board	Board Status	Date Returned to Consultant
Submission	Comments													
		NA/ZBP/MER	NA-ZC-01-PL-332-512	First Floor Ceiling Plan - NCH Day & 23 Hour Unit (2 of 2)	13/02/2013	19/03/2013	A		16/04/2013	BMCE-TRANSMIT-015139	07/05/2013	13/05/2013	A	BMCE-TRANSMIT-015821 21/05/2013
		NA/ZBP/MER	NA-ZB-01-PL-332-513	First Floor Ceiling Plan - NCH Cardiology Ward (1 of 2)	13/02/2013	19/03/2013	A		16/04/2013	BMCE-TRANSMIT-015139	07/05/2013	13/05/2013	B	BMCE-TRANSMIT-015821 21/05/2013
		NA/ZBP/MER	NA-ZB-01-PL-332-514	First Floor Ceiling Plan - NCH Cardiology Ward (2 of 2)	13/02/2013	19/03/2013	A		16/04/2013	BMCE-TRANSMIT-015139	07/05/2013	13/05/2013	B	BMCE-TRANSMIT-015821 21/05/2013
		NA/ZBP/MER	NA-ZB-01-PL-332-515	First Floor Ceiling Plan - NCH Special Feeds	13/02/2013	19/03/2013	A		16/04/2013	BMCE-TRANSMIT-015139	07/05/2013	13/05/2013	B	BMCE-TRANSMIT-015821 21/05/2013
		NA/ZBP/MER	NA-SZ-01-PL-332-516	First Floor Ceiling Plan - NCH Critical Care - PICU (1 of 4)	13/02/2013	19/03/2013	B		16/04/2013	BMCE-TRANSMIT-015139	07/05/2013	13/05/2013	B	BMCE-TRANSMIT-015821 21/05/2013
		NA/ZBP/MER	NA-ZA-01-PL-332-517	First Floor Ceiling Plan - NCH Critical Care - PICU (2 of 4)	13/02/2013	19/03/2013	B		16/04/2013	BMCE-TRANSMIT-015139	07/05/2013	13/05/2013	B	BMCE-TRANSMIT-015821 21/05/2013
		NA/ZBP/MER	NA-ZA-01-PL-332-518	First Floor Ceiling Plan - NCH Critical Care - PICU (3 of 4)	13/02/2013	19/03/2013	A		16/04/2013	BMCE-TRANSMIT-015139	07/05/2013	13/05/2013	B	BMCE-TRANSMIT-015821 21/05/2013
		NA/ZBP/MER	NA-SZ-01-PL-332-519	First Floor Ceiling Plan - NCH Critical Care - PICU (4 of 4)	13/02/2013	19/03/2013	A		16/04/2013	BMCE-TRANSMIT-015139	07/05/2013	13/05/2013	B	BMCE-TRANSMIT-015821 21/05/2013
		NA/ZBP/MER	NA-SZ-01-PL-332-520	First Floor Ceiling Plan - NCH Medical Day Unit	13/02/2013	19/03/2013	A		16/04/2013	BMCE-TRANSMIT-015139	07/05/2013	13/05/2013	B	BMCE-TRANSMIT-015821 21/05/2013
		NA/ZBP/MER	NA-ZD-01-PL-332-521	First Floor Ceiling Plan - NSGH Coronary Care Unit - CCU (1 of 2)	24/07/2013	04/07/2012	D		05/07/2012	BMCE-TRANSMIT-009684 05/07/12	26/07/2012	15/08/2012	B	BMCE-TRANSMIT-010520 27/08/12
		NA/ZBP/MER	NA-ZD-01-PL-332-522	First Floor Ceiling Plan - NSGH Coronary Care Unit - CCU (2 of 2)	24/07/2013	04/07/2012	D		05/07/2012	BMCE-TRANSMIT-009684 05/07/12	26/07/2012	15/08/2012	B	BMCE-TRANSMIT-010520 27/08/12
		NA/ZBP/MER	NA-ZD-01-PL-332-523	First Floor Ceiling Plan - NSGH Critical Care (1 of 6)	24/07/2013	04/07/2012	D		05/07/2012	BMCE-TRANSMIT-009684 05/07/12	26/07/2012	15/08/2012	A	BMCE-TRANSMIT-010520 27/08/12
		NA/ZBP/MER	NA-ZD-01-PL-332-524	First Floor Ceiling Plan - NSGH Critical Care (2 of 6)	24/07/2013	04/07/2012	D		05/07/2012	BMCE-TRANSMIT-009684 05/07/12	26/07/2012	15/08/2012	B	BMCE-TRANSMIT-010520 27/08/12
		NA/ZBP/MER	NA-ZG-01-PL-332-525	First Floor Ceiling Plan - NSGH Critical Care (3 of 6)	24/07/2013	04/07/2012	D		05/07/2012	BMCE-TRANSMIT-009684 05/07/12	26/07/2012	15/08/2012	B	BMCE-TRANSMIT-010520 27/08/12
		NA/ZBP/MER	NA-ZG-01-PL-332-526	First Floor Ceiling Plan - NSGH Critical Care (4 of 6)	24/07/2013	04/07/2012	D		05/07/2012	BMCE-TRANSMIT-009684 05/07/12	26/07/2012	15/08/2012	B	BMCE-TRANSMIT-010520 27/08/12
		NA/ZBP/MER	NA-ZG-01-PL-332-527	First Floor Ceiling Plan - NSGH Critical Care (5 of 6)	24/07/2013	04/07/2012	D		05/07/2012	BMCE-TRANSMIT-009684 05/07/12	26/07/2012	15/08/2012	B	BMCE-TRANSMIT-010520 27/08/12
		NA/ZBP/MER	NA-ZG-01-PL-332-528	First Floor Ceiling Plan - NSGH Critical Care (6 of 6)	24/07/2013	04/07/2012	D		05/07/2012	BMCE-TRANSMIT-009684 05/07/12	26/07/2012	15/08/2012	B	BMCE-TRANSMIT-010520 27/08/12
		NA/ZBP/MER	NA-ZH-01-PL-332-529	First Floor Ceiling Plan - NSGH Stroke Ward (1 of 2)	08/06/2012	04/07/2012	B		18/07/2012	BMCE-TRANSMIT-009888	08/08/2012		B	BMCE-TRANSMIT-011043 20/09/2012
		NA/ZBP/MER	NA-ZH-01-PL-332-530	First Floor Ceiling Plan - NSGH Stroke Ward (2 of 2)	08/06/2012	04/07/2012	B		18/07/2012	BMCE-TRANSMIT-009888	08/08/2012		B	BMCE-TRANSMIT-011043 20/09/2012
		NA/ZBP/MER	NA-ZH-01-PL-332-531	First Floor Ceiling Plan - NSGH MDU/Clinical Investigations Unit	08/06/2012	04/07/2012	B		18/07/2012	BMCE-TRANSMIT-009888	08/08/2012		A	BMCE-TRANSMIT-011043 20/09/2012
		NA/ZBP/MER	NA-ZH-01-PL-332-532	First Floor Ceiling Plan - NSGH OPD - Pre Assessment Unit	08/06/2012	04/07/2012	B		18/07/2012	BMCE-TRANSMIT-009888	08/08/2012		B	BMCE-TRANSMIT-011043 20/09/2012
		NA/ZBP/MER	NA-SZ-01-PL-332-533	First Floor Ceiling Plan - NSGH Radiology (1 of 3)	08/06/2012	04/07/2012	B		18/07/2012	BMCE-TRANSMIT-009888	08/08/2012		B	BMCE-TRANSMIT-011043

RDD MASTER SCHEDULE - NHS Greater Glasgow & Clyde / New South Glasgow Hospitals (NSGH) Project - Adults & Childrens Hospital					Brookfield Multiplex Europe									
BCL-AC-XX-SH-001					Drawing Information									
					1st Submission									
		Action By	Drawing Number	Drawing Title	Date Required from Consultant	Date Submitted by Consultant	Document Revision	Planned Date to be Submitted to Board	Date Submitted to Board	BMCE Transmittal No	Date Response Required from Board	Date Received from Board	Board Status	Date Returned to Consultant
Submission	Comments													
		NA/ZBP/MER	NA-ZK-02-PL-332-503	Second Floor Ceiling Plan - NSGH Public Core B & Support	21/06/2013	29/10/2013	C		06/11/2013	BMCE-TRANSMIT-018389	20/11/2013	18/11/2013	A	BMCE-TRANSMIT-018549 21/11/2013
	Waiting on NA to update re-issue	NA/ZBP/MER	NA-ZK-02-PL-332-504	Second Floor Ceiling Plan - NSGH Bed Management Operations Centre	21/06/2013									
		NA/ZBP/MER	NA-ZF-02-PL-332-505	Second Floor Ceiling Plan - NSGH Dermatology Ward (1 of 3)	21/06/2013	14/05/201	A		04/06/2013	BMCE-TRANSMIT-016107	25/06/2013	09/01/2013	B	BMCE-TRANSMIT-016760 11/07/2013
		NA/ZBP/MER	NA-ZF-02-PL-332-506	Second Floor Equipment Plan - NSGH Dermatology Ward (2 of 3)	21/06/2013	14/05/201	A		04/06/2013	BMCE-TRANSMIT-016107	25/06/2013	09/01/2013	A	BMCE-TRANSMIT-016760 11/07/2013
		NA/ZBP/MER	NA-ZF-02-PL-332-507	Second Floor Ceiling Plan - NSGH Dermatology Ward (3 of 3)	21/06/2013	14/05/201	A		04/06/2013	BMCE-TRANSMIT-016107	25/06/2013	09/01/2013	B	BMCE-TRANSMIT-016760 11/07/2013
		NA/ZBP/MER	NA-ZC-02-PL-332-508	Second Floor Ceiling Plan - NCH Schiehallion Ward, Day Case & TCT (1 of 2)	21/06/2013	14/05/201	A		04/06/2013	BMCE-TRANSMIT-016107	25/06/2013	09/01/2013	B	BMCE-TRANSMIT-016760 11/07/2013
		NA/ZBP/MER	NA-ZC-02-PL-332-509	Second Floor Ceiling Plan - NCH Schiehallion Ward, Day Case & TCT (2 of 2)	21/06/2013	14/05/201	A		04/06/2013	BMCE-TRANSMIT-016107	25/06/2013	09/01/2013	B	BMCE-TRANSMIT-016760 11/07/2013
		NA/ZBP/MER	NA-ZB-02-PL-332-510	Second Floor Ceiling Plan - NCH Anaesthetic Offices, Hospital at Night & Admin Support	21/06/2013	14/05/201	A		04/06/2013	BMCE-TRANSMIT-016107	25/06/2013	09/01/2013	A	BMCE-TRANSMIT-016760 11/07/2013
		NA/ZBP/MER	NA-ZB-02-PL-332-511	Second Floor Ceiling Plan - NCH Day Case Unit	21/06/2013	14/05/201	A		04/06/2013	BMCE-TRANSMIT-016107	25/06/2013	09/01/2013	B	BMCE-TRANSMIT-016760 11/07/2013
		NA/ZBP/MER	NA-ZB-02-PL-332-512	Second Floor Ceiling Plan - NCH Acute Receiving Unit (1 of 3)	21/06/2013	14/05/201	A		04/06/2013	BMCE-TRANSMIT-016107	25/06/2013	09/01/2013	B	BMCE-TRANSMIT-016760 11/07/2013
		NA/ZBP/MER	NA-ZA-02-PL-332-513	Second Floor Ceiling Plan - NCH Acute Receiving Unit (2 of 3)	21/06/2013	14/05/201	A		04/06/2013	BMCE-TRANSMIT-016107	25/06/2013	09/01/2013	B	BMCE-TRANSMIT-016760 11/07/2013
		NA/ZBP/MER	NA-ZA-02-PL-332-514	Second Floor Ceiling Plan - NCH Acute Receiving Unit (3 of 3)	21/06/2013	14/05/201	A		04/06/2013	BMCE-TRANSMIT-016107	25/06/2013	09/01/2013	B	BMCE-TRANSMIT-016760 11/07/2013
		NA/ZBP/MER	NA-SZ-02-PL-332-515	Second Floor Ceiling Plan - Aseptic Suite (NSGH & NCH)	21/06/2013	07/06/2013	B		10/06/2013	BMCE-TRANSMIT-016181	24/06/2013	08/07/2013	C	BMCE-TRANSMIT-016860 19/07/2013
		NA/ZBP/MER	NA-SZ-02-PL-332-516	Second Floor Ceiling Plan - NSGH Telephone Services, Renal Plant & FM Emergency Linen	26/10/2012	03/07/2013	A		27/06/201	BMCE-TRANSMIT-016520	18/07/2013	10/07/2013	B	BMCE-TRANSMIT-016821 17/07/2013
		NA/ZBP/MER	NA-ZE-02-PL-332-517	Second Floor Ceiling Plan - Medical Physics & Bio-Engineering (NSGH & NCH)	26/10/2012	21/12/2012	A		08/03/2012	BMCE-TRANSMIT-014427	29/03/2012	07/05/2013	B	BMCE-TRANSMIT-015559 10/05/2013
		NA/ZBP/MER	NA-ZE-02-PL-332-518	Second Floor Equipment Plan - NSGH Decontamination Suite	26/10/2012	21/12/2012	A		08/03/2012	BMCE-TRANSMIT-014427	29/03/2012	07/05/2013	B	BMCE-TRANSMIT-015559 10/05/2013
		NA/ZBP/MER	NA-ZE-02-PL-332-519	Second Floor Ceiling Plan - NSGH Endoscopy	26/10/2012	21/12/2012	A		08/03/2012	BMCE-TRANSMIT-014427	29/03/2012	07/05/2013	B	BMCE-TRANSMIT-015559 10/05/2013
		NA/ZBP/MER	NA-SZ-02-PL-332-520	Second Floor Ceiling Plan - NSGH Operating Theatres AODOS & Recovery (1 of 9)	08/06/2012	04/07/2012	B		18/07/2012	BMCE-TRANSMIT-009888	08/08/2012		B	BMCE-TRANSMIT-011043 20/09/2012
		NA/ZBP/MER	NA-SZ-02-PL-332-521	Second Floor Ceiling Plan - NSGH Operating Theatres AODOS & Recovery (2 of 9)	08/06/2012	04/07/2012	B		18/07/2012	BMCE-TRANSMIT-009888	08/08/2012		B	BMCE-TRANSMIT-011043 20/09/2012
		NA/ZBP/MER	NA-SZ-02-PL-332-522	Second Floor Ceiling Plan - NSGH Operating Theatres AODOS & Recovery (3 of 9)	08/06/2012	04/07/2012	B		18/07/2012	BMCE-TRANSMIT-009888	08/08/2012		B	BMCE-TRANSMIT-011043 20/09/2012
		NA/ZBP/MER	NA-ZE-02-PL-332-523	Second Floor Ceiling Plan - NSGH Operating Theatres AODOS & Recovery (4 of 9)	08/06/2012	04/07/2012	C		18/07/2012	BMCE-TRANSMIT-009888	08/08/2012		B	BMCE-TRANSMIT-011043 20/09/2012
		NA/ZBP/MER	NA-ZG-02-PL-332-524	Second Floor Ceiling Plan - NSGH Operating Theatres AODOS & Recovery (5 of 9)	08/06/2012	04/07/2012	B		18/07/2012	BMCE-TRANSMIT-009888	08/08/2012		A	BMCE-TRANSMIT-011043

RDD MASTER SCHEDULE - NHS Greater Glasgow & Clyde / New South Glasgow Hospitals (NSGH) Project - Adults & Childrens Hospital					Brookfield Multiplex Europe									
					Drawing Information									
BCL-AC-XX-SH-001					1st Submission									
		Action By	Drawing Number	Drawing Title	Date Required from Consultant	Date Submitted by Consultant	Document Revision	Planned Date to be Submitted to Board	Date Submitted to Board	BMCE Transmittal No	Date Response Required from Board	Date Received from Board	Board Status	Date Returned to Consultant
Submission	Comments													
		NA/ZBP/MER	NA-ZJ-02-PL-332-531	Second Floor Ceiling Plan - NSGH Renal Dialysis (1 of 3)	21/06/2013	14/05/201	A		04/06/2013	BMCE-TRANSMIT-016107	25/06/2013	09/01/7/2013	B	BMCE-TRANSMIT-016760 11/07/2013
		NA/ZBP/MER	NA-ZJ-02-PL-332-532	Second Floor Ceiling Plan - NSGH Renal Dialysis (2 of 3)	21/06/2013	14/05/201	A		04/06/2013	BMCE-TRANSMIT-016107	25/06/2013	09/01/7/2013	B	BMCE-TRANSMIT-016760 11/07/2013
		NA/ZBP/MER	NA-ZJ-02-PL-332-533	Second Floor Ceiling Plan - NSGH Renal Dialysis (3 of 3)	21/06/2013	14/05/201	A		04/06/2013	BMCE-TRANSMIT-016107	25/06/2013	09/01/7/2013	B	BMCE-TRANSMIT-016760 11/07/2013
		NA/ZBP/MER	NA-ZE-02-PL-332-534	Second Floor Ceiling Plan - NCH Transport Base	26/10/2012	03/07/2013	A		27/06/201	BMCE-TRANSMIT-016520	18/07/2013	10/07/2013	A	BMCE-TRANSMIT-016821 17/07/2013
		NA/ZBP/MER	NA-ZK-03-PL-332-501	Third Floor Ceiling Plan - NSGH Admin, Training, Health Records & Staff Facilities (1 of 2)	27/09/2013	29/10/2013	C		06/11/2013	BMCE-TRANSMIT-018390	20/11/2013	18/11/2013	B	BMCE-TRANSMIT-018554 21/11/2013
		NA/ZBP/MER	NA-ZF-03-PL-332-502	Third Floor Ceiling Plan - NSGH Admin, Training, Health Records & Staff Facilities (2 of 2)	27/09/2013	29/10/2013	C		06/11/2013	BMCE-TRANSMIT-018390	20/11/2013	18/11/2013	B	BMCE-TRANSMIT-018554 21/11/2013
	Waiting on NA to update re-issue	NA/ZBP/MER	NA-ZK-03-PL-332-503	Third Floor Ceiling Plan - Staff Change/Hotel Services/Staff Accommodation (1 of 2)	24/07/2013									
	Waiting on NA to update re-issue	NA/ZBP/MER	NA-ZE-03-PL-332-504	Third Floor Ceiling Plan - Staff Change/Hotel Services/Staff Accommodation (2 of 2)	24/07/2013									
		NA/ZBP/MER	NA-ZC-03-PL-332-505	Third Floor Ceiling Plan - NCH Inpatient Wards - Medicinema	27/09/2013	05/09/2013	A		26/09/2013	BMCE-TRANSMIT-017831	17/10/2013	17/10/2013	A	BMCE-TRANSMIT-018164 21/10/2013
		NA/ZBP/MER	NA-ZC-03-PL-332-506	Third Floor Ceiling Plan - NCH Inpatient Wards (1 of 7)	27/09/2013	05/09/2013	A		26/09/2013	BMCE-TRANSMIT-017831	17/10/2013	17/10/2013	B	BMCE-TRANSMIT-018164 21/10/2013
		NA/ZBP/MER	NA-ZC-03-PL-332-507	Third Floor Ceiling Plan - NCH Inpatient Wards (2 of 7)	27/09/2013	05/09/2013	A		26/09/2013	BMCE-TRANSMIT-017831	17/10/2013	17/10/2013	B	BMCE-TRANSMIT-018164 21/10/2013
		NA/ZBP/MER	NA-SZ-03-PL-332-508	Third Floor Ceiling Plan - NCH Inpatient Wards (3 of 7)	27/09/2013	05/09/2013	A		26/09/2013	BMCE-TRANSMIT-017831	17/10/2013	17/10/2013	B	BMCE-TRANSMIT-018164 21/10/2013
		NA/ZBP/MER	NA-ZB-03-PL-332-509	Third Floor Ceiling Plan - NCH Inpatient Wards (4 of 7)	27/09/2013	05/09/2013	A		26/09/2013	BMCE-TRANSMIT-017831	17/10/2013	17/10/2013	B	BMCE-TRANSMIT-018164 21/10/2013
		NA/ZBP/MER	NA-SZ-03-PL-332-510	Third Floor Ceiling Plan - NCH Inpatient Wards (5 of 7)	27/09/2013	05/09/2013	A		26/09/2013	BMCE-TRANSMIT-017831	17/10/2013	17/10/2013	B	BMCE-TRANSMIT-018164 21/10/2013
		NA/ZBP/MER	NA-ZA-03-PL-332-511	Third Floor Ceiling Plan - NCH Inpatient Wards (6 of 7)	27/09/2013	05/09/2013	A		26/09/2013	BMCE-TRANSMIT-017831	17/10/2013	17/10/2013	B	BMCE-TRANSMIT-018164 21/10/2013
		NA/ZBP/MER	NA-ZA-03-PL-332-512	Third Floor Ceiling Plan - NCH Inpatient Wards (7 of 7)	27/09/2013	05/09/2013	A		26/09/2013	BMCE-TRANSMIT-017831	17/10/2013	17/10/2013	B	BMCE-TRANSMIT-018164 21/10/2013
		NA/ZBP/MER	NA-ZA-03-PL-332-513	Third Floor Ceiling Plan - NCH Inpatient Wards & Renal Services	27/09/2013	05/09/2013	A		26/09/2013	BMCE-TRANSMIT-017831	17/10/2013	17/10/2013	A	BMCE-TRANSMIT-018164 21/10/2013
		NA/ZBP/MER	NA-ZB-03-PL-332-514	Third Floor Ceiling Plan - NCH Inpatient Ward Support (1 of 2)	27/09/2013	05/09/2013	A		26/09/2013	BMCE-TRANSMIT-017831	17/10/2013	17/10/2013	B	BMCE-TRANSMIT-018164 21/10/2013
		NA/ZBP/MER	NA-ZB-03-PL-332-515	Third Floor Ceiling Plan - NCH Inpatient Ward Support (2 of 2)	27/09/2013	05/09/2013	A		26/09/2013	BMCE-TRANSMIT-017831	17/10/2013	17/10/2013	A	BMCE-TRANSMIT-018164 21/10/2013
		NA/ZBP/MER	NA-ZB-03-PL-332-516	Third Floor NSGH Plant Room Lift & Stair Cores E, F & G	27/09/2013	29/10/2013	C		06/11/2013	BMCE-TRANSMIT-018390	20/11/2013	18/11/2013	A	BMCE-TRANSMIT-018554 21/11/2013
		NA/ZBP/MER	NA-ZK-04-PL-332-501	Fourth Floor Ceiling Plan - NSGH Renal Inpatients & Day Unit (1 of 12)	20/07/2012	25/07/2012	A		02/08/2012	BMCE-TRANSMIT-010132	23/08/2012	22/10/2012	B	BMCE-TRANSMIT-011975 31/10/2012
		NA/ZBP/MER	NA-ZK-04-PL-332-502	Fourth Floor Ceiling Plan - NSGH Renal Inpatients & Day Unit (2 of 12)	20/07/2012	25/07/2012	A		02/08/2012	BMCE-TRANSMIT-010132	23/08/2012	22/10/2012	B	BMCE-TRANSMIT-011975

RDD MASTER SCHEDULE - NHS Greater Glasgow & Clyde / New South Glasgow Hospitals (NSGH) Project - Adults & Childrens Hospital					Brookfield Multiplex Europe									
BCL-AC-XX-SH-001					Drawing Information									
					1st Submission									
		Action By	Drawing Number	Drawing Title	Date Required from Consultant	Date Submitted by Consultant	Document Revision	Planned Date to be Submitted to Board	Date Submitted to Board	BMCE Transmittal No	Date Response Required from Board	Date Received from Board	Board Status	Date Returned to Consultant
Submission	Comments													
		NA/ZBP/MER	NA-ZF-04-PL-332-503	Fourth Floor Ceiling Plan - NSGH Renal Inpatients & Day Unit (3 of 12)	20/07/2012	25/07/2012	A		02/08/2012	BMCE-TRANSMIT-010132	23/08/2012	22/10/2012	B	BMCE-TRANSMIT-011975 31/10/2012
		NA/ZBP/MER	NA-ZF-04-PL-332-504	Fourth Floor Ceiling Plan - NSGH Renal Inpatients & Day Unit (4 of 12)	20/07/2012	25/07/2012	A		02/08/2012	BMCE-TRANSMIT-010132	23/08/2012	22/10/2012	B	BMCE-TRANSMIT-011975 31/10/2012
		NA/ZBP/MER	NA-ZF-04-PL-332-505	Fourth Floor Ceiling Plan - NSGH Renal Inpatients & Day Unit (5 of 12)	20/07/2012	25/07/2012	A		02/08/2012	BMCE-TRANSMIT-010132	23/08/2012	22/10/2012	B	BMCE-TRANSMIT-011975 31/10/2012
		NA/ZBP/MER	NA-ZJ-04-PL-332-506	Fourth Floor Ceiling Plan - NSGH Renal Inpatients & Day Unit (6 of 12)	20/07/2012	25/07/2012	A		02/08/2012	BMCE-TRANSMIT-010132	23/08/2012	22/10/2012	B	BMCE-TRANSMIT-011975 31/10/2012
		NA/ZBP/MER	NA-ZJ-04-PL-332-507	Fourth Floor Ceiling Plan - NSGH Renal Inpatients & Day Unit (7 of 12)	20/07/2012	25/07/2012	A		02/08/2012	BMCE-TRANSMIT-010132	23/08/2012	22/10/2012	B	BMCE-TRANSMIT-011975 31/10/2012
		NA/ZBP/MER	NA-ZJ-04-PL-332-508	Fourth Floor Ceiling Plan - NSGH Renal Inpatients & Day Unit (8 of 12)	20/07/2012	25/07/2012	A		02/08/2012	BMCE-TRANSMIT-010132	23/08/2012	22/10/2012	B	BMCE-TRANSMIT-011975 31/10/2012
		NA/ZBP/MER	NA-ZH-04-PL-332-509	Fourth Floor Ceiling Plan - NSGH Renal Inpatients & Day Unit (9 of 12)	20/07/2012	25/07/2012	A		02/08/2012	BMCE-TRANSMIT-010132	23/08/2012	22/10/2012	B	BMCE-TRANSMIT-011975 31/10/2012
		NA/ZBP/MER	NA-ZH-04-PL-332-510	Fourth Floor Ceiling Plan - NSGH Renal Inpatients & Day Unit (10 of 12)	20/07/2012	25/07/2012	A		02/08/2012	BMCE-TRANSMIT-010132	23/08/2012	22/10/2012	B	BMCE-TRANSMIT-011975 31/10/2012
		NA/ZBP/MER	NA-ZH-04-PL-332-511	Fourth Floor Ceiling Plan - NSGH Renal Inpatients & Day Unit (11 of 12)	20/07/2012	25/07/2012	A		02/08/2012	BMCE-TRANSMIT-010132	23/08/2012	22/10/2012	B	BMCE-TRANSMIT-011975 31/10/2012
		NA/ZBP/MER	NA-ZE-04-PL-332-512	Fourth Floor Ceiling Plan - NSGH Renal Inpatients & Day Unit (12 of 12)	20/07/2012	25/07/2012	A		02/08/2012	BMCE-TRANSMIT-010132	23/08/2012	22/10/2012	B	BMCE-TRANSMIT-011975 31/10/2012
		NA/ZBP/MER	NA-ZE-04-PL-332-513	Fourth Floor Ceiling Plan - NSGH Haemato-oncology Inpatient Ward (1 of 2)	20/07/2012	25/07/2012	A		02/08/2012	BMCE-TRANSMIT-010132	23/08/2012	22/10/2012	B	BMCE-TRANSMIT-011975 31/10/2012
		NA/ZBP/MER	NA-ZE-04-PL-332-514	Fourth Floor Ceiling Plan - NSGH Haemato-oncology Inpatient Ward (2 of 2)	20/07/2012	25/07/2012	A		02/08/2012	BMCE-TRANSMIT-010132	23/08/2012	22/10/2012	B	BMCE-TRANSMIT-011975 31/10/2012
		NA/ZBP/MER	NA-SZ-04-PL-332-515	Fourth Floor Ceiling Plan - NCH Psychiatry / DCFP (1 of 3)	27/09/2013	05/09/2013	A		26/09/2013	BMCE-TRANSMIT-017831	17/10/2013	17/10/2013	A	BMCE-TRANSMIT-018164 21/10/2013
		NA/ZBP/MER	NA-ZC-04-PL-332-516	Fourth Floor Ceiling Plan - NCH Psychiatry / DCFP (2 of 3)	27/09/2013	05/09/2013	A		26/09/2013	BMCE-TRANSMIT-017831	17/10/2013	17/10/2013	B	BMCE-TRANSMIT-018164 21/10/2013
		NA/ZBP/MER	NA-ZC-04-PL-332-517	Fourth Floor Ceiling Plan - NCH Psychiatry / DCFP (3 of 3)	27/09/2013	05/09/2013	A		26/09/2013	BMCE-TRANSMIT-017831	17/10/2013	17/10/2013	B	BMCE-TRANSMIT-018164 21/10/2013
		NA/ZBP/MER	NA-ZC-04-PL-332-518	Fourth Floor Ceiling Plan -Plantroom Stair, Lift Core H & Computer Room	27/09/2013	05/09/2013	A		26/09/2013	BMCE-TRANSMIT-017831	17/10/2013	17/10/2013	B	BMCE-TRANSMIT-018164 21/10/2013
		NA/ZBP/MER	NA-ZK-05-PL-332-501	Fifth Floor Ceiling Plan - NSGH Inpatient Wards (1 of 14)	31/08/2012	31/01/2013	A		12/02/2013	BMCE-TRANSMIT-013880	05/03/2013	11/03/2013	B	BMCE-TRANSMIT-014577 14/03/2013
		NA/ZBP/MER	NA-ZK-05-PL-332-502	Fifth Floor Ceiling Plan - NSGH Inpatient Wards (2 of 14)	31/08/2012	31/01/2013	A		12/02/2013	BMCE-TRANSMIT-013880	05/03/2013	11/03/2013	A	BMCE-TRANSMIT-014577 14/03/2013
		NA/ZBP/MER	NA-ZF-05-PL-332-503	Fifth Floor Ceiling Plan - NSGH Inpatient Wards (3 of 14)	31/08/2012	31/01/2013	A		12/02/2013	BMCE-TRANSMIT-013880	05/03/2013	11/03/2013	B	BMCE-TRANSMIT-014577 14/03/2013
		NA/ZBP/MER	NA-ZF-05-PL-332-504	Fifth Floor Ceiling Plan - NSGH Inpatient Wards (4 of 14)	31/08/2012	31/01/2013	A		12/02/2013	BMCE-TRANSMIT-013880	05/03/2013	11/03/2013	B	BMCE-TRANSMIT-014577 14/03/2013
		NA/ZBP/MER	NA-ZF-05-PL-332-505	Fifth Floor Ceiling Plan - NSGH Inpatient Wards (5 of 14)	31/08/2012	31/01/2013	A		12/02/2013	BMCE-TRANSMIT-013880	05/03/2013	11/03/2013	B	BMCE-TRANSMIT-014577 14/03/2013
		NA/ZBP/MER	NA-ZJ-05-PL-332-506	Fifth Floor Ceiling Plan - NSGH Inpatient Wards (6 of 14)	31/08/2012	31/01/2013	A		12/02/2013	BMCE-TRANSMIT-013880	05/03/2013	11/03/2013	B	BMCE-TRANSMIT-014577

RDD MASTER SCHEDULE - NHS Greater Glasgow & Clyde / New South Glasgow Hospitals (NSGH) Project - Adults & Childrens Hospital					Brookfield Multiplex Europe									
BCL-AC-XX-SH-001					Drawing Information									
					1st Submission									
		Action By	Drawing Number	Drawing Title	Date Required from Consultant	Date Submitted by Consultant	Document Revision	Planned Date to be Submitted to Board	Date Submitted to Board	BMCE Transmittal No	Date Response Required from Board	Date Received from Board	Board Status	Date Returned to Consultant
Submission	Comments													
		NA/ZBP/MER	NA-ZH-05-PL-332-510	Fifth Floor Ceiling Plan - NSGH Inpatient Wards (10 of 14)	31/08/2012	31/01/2013	A		12/02/2013	BMCE-TRANSMIT-013880	05/03/2013	11/03/2013	B	BMCE-TRANSMIT-014577 14/03/2013
		NA/ZBP/MER	NA-ZH-05-PL-332-511	Fifth Floor Ceiling Plan - NSGH Inpatient Wards (11 of 14)	31/08/2012	31/01/2013	A		12/02/2013	BMCE-TRANSMIT-013880	05/03/2013	11/03/2013	B	BMCE-TRANSMIT-014577 14/03/2013
		NA/ZBP/MER	NA-ZE-05-PL-332-512	Fifth Floor Ceiling Plan - NSGH Inpatient Wards (12 of 14)	31/08/2012	31/01/2013	A		12/02/2013	BMCE-TRANSMIT-013880	05/03/2013	11/03/2013	B	BMCE-TRANSMIT-014577 14/03/2013
		NA/ZBP/MER	NA-ZE-05-PL-332-513	Fifth Floor Ceiling Plan - NSGH Inpatient Wards (13 of 14)	31/08/2012	31/01/2013	A		12/02/2013	BMCE-TRANSMIT-013880	05/03/2013	11/03/2013	B	BMCE-TRANSMIT-014577 14/03/2013
		NA/ZBP/MER	NA-ZE-05-PL-332-514	Fifth Floor Ceiling Plan - NSGH Inpatient Wards (14 of 14)	31/08/2012	31/01/2013	A		12/02/2013	BMCE-TRANSMIT-013880	05/03/2013	11/03/2013	A	TRANSMIT-014577 14/03/2013
		NA/ZBP/MER	NA-ZK-06-PL-332-501	Sixth Floor Ceiling Plan - NSGH Inpatient Wards (1 of 14)	02/01/2013	19/01/2013	A		28/02/2013	BMCE-TRANSMIT-014263	21/03/2013	26/03/2013	A	BMCE-TRANSMIT-014859 01/04/2013
		NA/ZBP/MER	NA-ZK-06-PL-332-502	Sixth Floor Ceiling Plan - NSGH Inpatient Wards (2 of 14)	02/01/2013	19/01/2013	A		28/02/2013	BMCE-TRANSMIT-014263	21/03/2013	26/03/2013	B	BMCE-TRANSMIT-014859 01/04/2013
		NA/ZBP/MER	NA-ZF-06-PL-332-503	Sixth Floor Ceiling Plan - NSGH Inpatient Wards (3 of 14)	02/01/2013	19/01/2013	A		28/02/2013	BMCE-TRANSMIT-014263	21/03/2013	26/03/2013	B	BMCE-TRANSMIT-014859 01/04/2013
		NA/ZBP/MER	NA-ZF-06-PL-332-504	Sixth Floor Ceiling Plan - NSGH Inpatient Wards (4 of 14)	02/01/2013	19/01/2013	A		28/02/2013	BMCE-TRANSMIT-014263	21/03/2013	26/03/2013	A	TRANSMIT-014859 01/04/2013
		NA/ZBP/MER	NA-ZF-06-PL-332-505	Sixth Floor Ceiling Plan - NSGH Inpatient Wards (5 of 14)	02/01/2013	19/01/2013	A		28/02/2013	BMCE-TRANSMIT-014263	21/03/2013	26/03/2013	A	TRANSMIT-014859 01/04/2013
		NA/ZBP/MER	NA-ZJ-06-PL-332-506	Sixth Floor Ceiling Plan - NSGH Inpatient Wards (6 of 14)	02/01/2013	19/01/2013	A		28/02/2013	BMCE-TRANSMIT-014263	21/03/2013	26/03/2013	A	TRANSMIT-014859 01/04/2013
		NA/ZBP/MER	NA-ZJ-06-PL-332-507	Sixth Floor Ceiling Plan - NSGH Inpatient Wards (7 of 14)	02/01/2013	19/01/2013	A		28/02/2013	BMCE-TRANSMIT-014263	21/03/2013	26/03/2013	A	TRANSMIT-014859 01/04/2013
		NA/ZBP/MER	NA-ZJ-06-PL-332-508	Sixth Floor Ceiling Plan - NSGH Inpatient Wards (8 of 14)	02/01/2013	19/01/2013	A		28/02/2013	BMCE-TRANSMIT-014263	21/03/2013	26/03/2013	B	TRANSMIT-014859 01/04/2013
		NA/ZBP/MER	NA-ZH-06-PL-332-509	Sixth Floor Ceiling Plan - NSGH Inpatient Wards (9 of 14)	02/01/2013	19/01/2013	A		28/02/2013	BMCE-TRANSMIT-014263	21/03/2013	26/03/2013	A	TRANSMIT-014859 01/04/2013
		NA/ZBP/MER	NA-ZH-06-PL-332-510	Sixth Floor Ceiling Plan - NSGH Inpatient Wards (10 of 14)	02/01/2013	19/01/2013	A		28/02/2013	BMCE-TRANSMIT-014263	21/03/2013	26/03/2013	A	TRANSMIT-014859 01/04/2013
		NA/ZBP/MER	NA-ZH-06-PL-332-511	Sixth Floor Ceiling Plan - NSGH Inpatient Wards (11 of 14)	02/01/2013	19/01/2013	A		28/02/2013	BMCE-TRANSMIT-014263	21/03/2013	26/03/2013	A	TRANSMIT-014859 01/04/2013
		NA/ZBP/MER	NA-ZE-06-PL-332-512	Sixth Floor Ceiling Plan - NSGH Inpatient Wards (12 of 14)	02/01/2013	19/01/2013	A		28/02/2013	BMCE-TRANSMIT-014263	21/03/2013	26/03/2013	A	TRANSMIT-014859 01/04/2013
		NA/ZBP/MER	NA-ZE-06-PL-332-513	Sixth Floor Ceiling Plan - NSGH Inpatient Wards (13 of 14)	02/01/2013	19/01/2013	A		28/02/2013	BMCE-TRANSMIT-014263	21/03/2013	26/03/2013	A	TRANSMIT-014859 01/04/2013
		NA/ZBP/MER	NA-ZE-06-PL-332-514	Sixth Floor Ceiling Plan - NSGH Inpatient Wards (14 of 14)	02/01/2013	19/01/2013	A		28/02/2013	BMCE-TRANSMIT-014263	21/03/2013	26/03/2013	A	TRANSMIT-014859 01/04/2013
		NA/ZBP/MER	NA-ZK-07-PL-332-501	Seventh Floor Ceiling Plan - NSGH Inpatient Wards (1 of 14)	02/01/2013	26/03/201	A		08/04/2013	BMCE-TRANSMIT-014985	29/04/201	07/05/2013	A	TRANSMIT-015561 10/05/2013
		NA/ZBP/MER	NA-ZK-07-PL-332-502	Seventh Floor Ceiling Plan - NSGH Inpatient Wards (2 of 14)	02/01/2013	26/03/201	A		08/04/2013	BMCE-TRANSMIT-014985	29/04/201	07/05/2013	B	TRANSMIT-015561 10/05/2013
		NA/ZBP/MER	NA-ZF-07-PL-332-503	Seventh Floor Ceiling Plan - NSGH Inpatient Wards (3 of 14)	02/01/2013	26/03/201	A		08/04/2013	BMCE-TRANSMIT-014985	29/04/201	07/05/2013	C	TRANSMIT-015561

RDD MASTER SCHEDULE - NHS Greater Glasgow & Clyde / New South Glasgow Hospitals (NSGH) Project - Adults & Childrens Hospital					Brookfield Multiplex Europe									
BCL-AC-XX-SH-001					Drawing Information									
					1st Submission									
		Action By	Drawing Number	Drawing Title	Date Required from Consultant	Date Submitted by Consultant	Document Revision	Planned Date to be Submitted to Board	Date Submitted to Board	BMCE Transmittal No	Date Response Required from Board	Date Received from Board	Board Status	Date Returned to Consultant
Submission	Comments													
		NA/ZBP/MER	NA-ZE-07-PL-332-513	Seventh Floor Ceiling Plan - NSGH Inpatient Wards (13 of 14)	02/01/2013	26/03/201	A		08/04/2013	BMCE-TRANSMIT-014985	29/04/201	07/05/2013	A	BMCE-TRANSMIT-015561 10/05/2013
		NA/ZBP/MER	NA-ZE-07-PL-332-514	Seventh Floor Ceiling Plan - NSGH Inpatient Wards (14 of 14)	02/01/2013	26/03/201	A		08/04/2013	BMCE-TRANSMIT-014985	29/04/201	07/05/2013	A	BMCE-TRANSMIT-015561 10/05/2013
		NA/ZBP/MER	NA-ZK-08-PL-332-501	Eighth Floor Ceiling Plan - NSGH Inpatient Wards (1 of 14)	09/05/2013	02/04/2013	A		17/04/2013	BMCE-TRANSMIT-015178	08/05/2013	13/05/2013	B	BMCE-TRANSMIT-015730 17/05/2013
		NA/ZBP/MER	NA-ZK-08-PL-332-502	Eighth Floor Ceiling Plan - NSGH Inpatient Wards (2 of 14)	09/05/2013	02/04/2013	A		17/04/2013	BMCE-TRANSMIT-015178	08/05/2013	13/05/2013	B	BMCE-TRANSMIT-015730 17/05/2013
		NA/ZBP/MER	NA-ZF-08-PL-332-503	Eighth Floor Ceiling Plan - NSGH Inpatient Wards (3 of 14)	09/05/2013	02/04/2013	A		17/04/2013	BMCE-TRANSMIT-015178	08/05/2013	13/05/2013	C	BMCE-TRANSMIT-015730 17/05/2013
		NA/ZBP/MER	NA-ZF-08-PL-332-504	Eighth Floor Ceiling Plan - NSGH Inpatient Wards (4 of 14)	09/05/2013	02/04/2013	A		17/04/2013	BMCE-TRANSMIT-015178	08/05/2013	13/05/2013	B	BMCE-TRANSMIT-015730 17/05/2013
		NA/ZBP/MER	NA-ZF-08-PL-332-505	Eighth Floor Ceiling Plan - NSGH Inpatient Wards (5 of 14)	09/05/2013	02/04/2013	A		17/04/2013	BMCE-TRANSMIT-015178	08/05/2013	13/05/2013	B	BMCE-TRANSMIT-015730 17/05/2013
		NA/ZBP/MER	NA-ZJ-08-PL-332-506	Eighth Floor Ceiling Plan - NSGH Inpatient Wards (6 of 14)	09/05/2013	02/04/2013	A		17/04/2013	BMCE-TRANSMIT-015178	08/05/2013	13/05/2013	B	BMCE-TRANSMIT-015730 17/05/2013
		NA/ZBP/MER	NA-ZJ-08-PL-332-507	Eighth Floor Ceiling Plan - NSGH Inpatient Wards (7 of 14)	09/05/2013	02/04/2013	A		17/04/2013	BMCE-TRANSMIT-015178	08/05/2013	13/05/2013	A	BMCE-TRANSMIT-015730 17/05/2013
		NA/ZBP/MER	NA-ZJ-08-PL-332-508	Eighth Floor Ceiling Plan - NSGH Inpatient Wards (8 of 14)	09/05/2013	02/04/2013	A		17/04/2013	BMCE-TRANSMIT-015178	08/05/2013	13/05/2013	B	BMCE-TRANSMIT-015730 17/05/2013
		NA/ZBP/MER	NA-ZH-08-PL-332-509	Eighth Floor Ceiling Plan - NSGH Inpatient Wards (9 of 14)	09/05/2013	02/04/2013	A		17/04/2013	BMCE-TRANSMIT-015178	08/05/2013	13/05/2013	B	BMCE-TRANSMIT-015730 17/05/2013
		NA/ZBP/MER	NA-ZH-08-PL-332-510	Eighth Floor Ceiling Plan - NSGH Inpatient Wards (10 of 14)	09/05/2013	02/04/2013	A		17/04/2013	BMCE-TRANSMIT-015178	08/05/2013	13/05/2013	A	BMCE-TRANSMIT-015730 17/05/2013
		NA/ZBP/MER	NA-ZH-08-PL-332-511	Eighth Floor Ceiling Plan - NSGH Inpatient Wards (11 of 14)	09/05/2013	02/04/2013	A		17/04/2013	BMCE-TRANSMIT-015178	08/05/2013	13/05/2013	B	BMCE-TRANSMIT-015730 17/05/2013
		NA/ZBP/MER	NA-ZE-08-PL-332-512	Eighth Floor Ceiling Plan - NSGH Inpatient Wards (12 of 14)	09/05/2013	02/04/2013	A		17/04/2013	BMCE-TRANSMIT-015178	08/05/2013	13/05/2013	B	BMCE-TRANSMIT-015730 17/05/2013
		NA/ZBP/MER	NA-ZE-08-PL-332-513	Eighth Floor Ceiling Plan - NSGH Inpatient Wards (13 of 14)	09/05/2013	02/04/2013	A		17/04/2013	BMCE-TRANSMIT-015178	08/05/2013	13/05/2013	B	BMCE-TRANSMIT-015730 17/05/2013
		NA/ZBP/MER	NA-ZE-08-PL-332-514	Eighth Floor Ceiling Plan - NSGH Inpatient Wards (14 of 14)	09/05/2013	02/04/2013	A		17/04/2013	BMCE-TRANSMIT-015178	08/05/2013	13/05/2013	B	BMCE-TRANSMIT-015730 17/05/2013
		NA/ZBP/MER	NA-ZK-09-PL-332-501	Ninth Floor Ceiling Plan - NSGH Inpatient Wards (1 of 14)	02/08/2013	17/05/201	A		04/06/2013	BMCE-TRANSMIT-016097	25/06/2013	08/07/201	B	BMCE-TRANSMIT-016885 22/07/2013
		NA/ZBP/MER	NA-ZK-09-PL-332-502	Ninth Floor Ceiling Plan - NSGH Inpatient Wards (2 of 14)	02/08/2013	17/05/201	A		04/06/2013	BMCE-TRANSMIT-016097	25/06/2013	08/07/201	B	BMCE-TRANSMIT-016885 22/07/2013
		NA/ZBP/MER	NA-ZF-09-PL-332-503	Ninth Floor Ceiling Plan - NSGH Inpatient Wards (3 of 14)	02/08/2013	17/05/201	A		04/06/2013	BMCE-TRANSMIT-016097	25/06/2013	08/07/201	C	BMCE-TRANSMIT-016885 22/07/2013
		NA/ZBP/MER	NA-ZF-09-PL-332-504	Ninth Floor Ceiling Plan - NSGH Inpatient Wards (4 of 14)	02/08/2013	17/05/201	A		04/06/2013	BMCE-TRANSMIT-016097	25/06/2013	08/07/201	B	BMCE-TRANSMIT-016885 22/07/2013
		NA/ZBP/MER	NA-ZF-09-PL-332-505	Ninth Floor Ceiling Plan - NSGH Inpatient Wards (5 of 14)	02/08/2013	17/05/201	A		04/06/2013	BMCE-TRANSMIT-016097	25/06/2013	08/07/201	B	BMCE-TRANSMIT-016885 22/07/2013
		NA/ZBP/MER	NA-ZJ-09-PL-332-506	Ninth Floor Ceiling Plan - NSGH Inpatient Wards (6 of 14)	02/08/2013	24/07/2013	B		02/07/2013	BMCE-TRANSMIT-016588	23/07/2013	08/07/2013	A	BMCE-TRANSMIT-016792

RDD MASTER SCHEDULE - NHS Greater Glasgow & Clyde / New South Glasgow Hospitals (NSGH) Project - Adults & Childrens Hospital					Brookfield Multiplex Europe									
BCL-AC-XX-SH-001					Drawing Information									
					1st Submission									
		Action By	Drawing Number	Drawing Title	Date Required from Consultant	Date Submitted by Consultant	Document Revision	Planned Date to be Submitted to Board	Date Submitted to Board	BMCE Transmittal No	Date Response Required from Board	Date Received from Board	Board Status	Date Returned to Consultant
Submission	Comments													
		NA/ZBP/MER	NA-ZK-10-PL-332-502	Tenth Floor Ceiling Plan - NSGH Inpatient Wards (2 of 14)	02/08/2013	01/07/2013	A		12/07/2013	BMCE-TRANSMIT-017244	02/08/2013	31/07/2013	A	BMCE-TRANSMIT-017244 13/08/2013
		NA/ZBP/MER	NA-ZF-10-PL-332-503	Tenth Floor Ceiling Plan - NSGH Inpatient Wards (3 of 14)	02/08/2013	01/07/2013	A		12/07/2013	BMCE-TRANSMIT-016775	02/08/2013	31/07/2013	A	BMCE-TRANSMIT-017244 13/08/2013
		NA/ZBP/MER	NA-ZF-10-PL-332-504	Tenth Floor Ceiling Plan - NSGH Inpatient Wards (4 of 14)	02/08/2013	01/07/2013	A		12/07/2013	BMCE-TRANSMIT-016775	02/08/2013	31/07/2013	B	BMCE-TRANSMIT-017244 13/08/2013
		NA/ZBP/MER	NA-ZF-10-PL-332-505	Tenth Floor Ceiling Plan - NSGH Inpatient Wards (5 of 14)	02/08/2013	01/07/2013	A		12/07/2013	BMCE-TRANSMIT-016775	02/08/2013	31/07/2013	A	BMCE-TRANSMIT-017244 13/08/2013
		NA/ZBP/MER	NA-ZJ-10-PL-332-506	Tenth Floor Ceiling Plan - NSGH Inpatient Wards (6 of 14)	02/08/2013	01/07/2013	A		12/07/2013	BMCE-TRANSMIT-016775	02/08/2013	31/07/2013	B	BMCE-TRANSMIT-017244 13/08/2013
		NA/ZBP/MER	NA-ZJ-10-PL-332-507	Tenth Floor Ceiling Plan - NSGH Inpatient Wards (7 of 14)	02/08/2013	01/07/2013	A		12/07/2013	BMCE-TRANSMIT-016775	02/08/2013	31/07/2013	B	BMCE-TRANSMIT-017244 13/08/2013
		NA/ZBP/MER	NA-ZJ-10-PL-332-508	Tenth Floor Ceiling Plan - NSGH Inpatient Wards (8 of 14)	02/08/2013	01/07/2013	A		12/07/2013	BMCE-TRANSMIT-016775	02/08/2013	31/07/2013	B	BMCE-TRANSMIT-017244 13/08/2013
		NA/ZBP/MER	NA-ZH-10-PL-332-509	Tenth Floor Ceiling Plan - NSGH Inpatient Wards (9 of 14)	02/08/2013	01/07/2013	A		12/07/2013	BMCE-TRANSMIT-016775	02/08/2013	31/07/2013	B	BMCE-TRANSMIT-017244 13/08/2013
		NA/ZBP/MER	NA-ZH-10-PL-332-510	Tenth Floor Ceiling Plan - NSGH Inpatient Wards (10 of 14)	02/08/2013	01/07/2013	A		12/07/2013	BMCE-TRANSMIT-016775	02/08/2013	31/07/2013	B	BMCE-TRANSMIT-017244 13/08/2013
		NA/ZBP/MER	NA-ZH-10-PL-332-511	Tenth Floor Ceiling Plan - NSGH Inpatient Wards (11 of 14)	02/08/2013	01/07/2013	A		12/07/2013	BMCE-TRANSMIT-016775	02/08/2013	31/07/2013	A	BMCE-TRANSMIT-017244 13/08/2013
		NA/ZBP/MER	NA-ZE-10-PL-332-512	Tenth Floor Ceiling Plan - NSGH Inpatient Wards (12 of 14)	02/08/2013	01/07/2013	A		12/07/2013	BMCE-TRANSMIT-016775	02/08/2013	31/07/2013	B	BMCE-TRANSMIT-017244 13/08/2013
		NA/ZBP/MER	NA-ZE-10-PL-332-513	Tenth Floor Ceiling Plan - NSGH Inpatient Wards (13 of 14)	02/08/2013	01/07/2013	A		12/07/2013	BMCE-TRANSMIT-016775	02/08/2013	31/07/2013	B	BMCE-TRANSMIT-017244 13/08/2013
		NA/ZBP/MER	NA-ZE-10-PL-332-514	Tenth Floor Ceiling Plan - NSGH Inpatient Wards (14 of 14)	02/08/2013	01/07/2013	A		12/07/2013	BMCE-TRANSMIT-016775	02/08/2013	31/07/2013	B	BMCE-TRANSMIT-017244 13/08/2013
		NA/ZBP/MER	NA-ZK-11-PL-332-501	Eleventh Floor Ceiling Plan - NSGH Inpatient Wards (1 of 14)	24/07/2013	01/07/2013	A		12/07/2013	BMCE-TRANSMIT-016769	02/08/2013	02/08/2013	B	BMCE-TRANSMIT-017248 13/08/2013
		NA/ZBP/MER	NA-ZK-11-PL-332-502	Eleventh Floor Ceiling Plan - NSGH Inpatient Wards (2 of 14)	24/07/2013	01/07/2013	A		12/07/2013	BMCE-TRANSMIT-016769	02/08/2013	02/08/2013	B	BMCE-TRANSMIT-017248 13/08/2013
		NA/ZBP/MER	NA-ZF-11-PL-332-503	Eleventh Floor Ceiling Plan - NSGH Inpatient Wards (3 of 14)	24/07/2013	01/07/2013	A		12/07/2013	BMCE-TRANSMIT-016769	02/08/2013	02/08/2013	A	BMCE-TRANSMIT-017248 13/08/2013
		NA/ZBP/MER	NA-ZF-11-PL-332-504	Eleventh Floor Ceiling Plan - NSGH Inpatient Wards (4 of 14)	24/07/2013	01/07/2013	A		12/07/2013	BMCE-TRANSMIT-016769	02/08/2013	02/08/2013	B	BMCE-TRANSMIT-017248 13/08/2013
		NA/ZBP/MER	NA-ZF-11-PL-332-505	Eleventh Floor Ceiling Plan - NSGH Inpatient Wards (5 of 14)	24/07/2013	01/07/2013	A		12/07/2013	BMCE-TRANSMIT-016769	02/08/2013	02/08/2013	A	BMCE-TRANSMIT-017248 13/08/2013
		NA/ZBP/MER	NA-ZJ-11-PL-332-506	Eleventh Floor Ceiling Plan - NSGH Inpatient Wards (6 of 14)	24/07/2013	01/07/2013	A		12/07/2013	BMCE-TRANSMIT-016769	02/08/2013	02/08/2013	A	BMCE-TRANSMIT-017248 13/08/2013
		NA/ZBP/MER	NA-ZJ-11-PL-332-507	Eleventh Floor Ceiling Plan - NSGH Inpatient Wards (7 of 14)	24/07/2013	01/07/2013	A		12/07/2013	BMCE-TRANSMIT-016769	02/08/2013	02/08/2013	B	BMCE-TRANSMIT-017248 13/08/2013
		NA/ZBP/MER	NA-ZJ-11-PL-332-508	Eleventh Floor Ceiling Plan - NSGH Inpatient Wards (8 of 14)	24/07/2013	01/07/2013	A		12/07/2013	BMCE-TRANSMIT-016769	02/08/2013	02/08/2013	A	BMCE-TRANSMIT-017248 13/08/2013
		NA/ZBP/MER	NA-ZH-11-PL-332-509	Eleventh Floor Ceiling Plan - NSGH Inpatient Wards (9 of 14)	24/07/2013	01/07/2013	A		12/07/2013	BMCE-TRANSMIT-016769	02/08/2013	02/08/2013	A	BMCE-TRANSMIT-017248

RDD MASTER SCHEDULE - NHS Greater Glasgow & Clyde / New South Glasgow Hospitals (NSGH) Project - Adults & Childrens Hospital					Brookfield Multiplex Europe									
BCL-AC-XX-SH-001					Drawing Information									
					1st Submission									
		Action By	Drawing Number	Drawing Title	Date Required from Consultant	Date Submitted by Consultant	Document Revision	Planned Date to be Submitted to Board	Date Submitted to Board	BMCE Transmittal No	Date Response Required from Board	Date Received from Board	Board Status	Date Returned to Consultant
Submission	Comments													
			NA-XX-SL-DT-332-300	Typical MF & Plasterboard Tile Ceiling Details Sheet 1 of 4		18/05/2012	3		29/06/2012	BMCE-TRANSMIT-009615	20/07/2012		A	BMCE-TRANSMIT-009681 05/07/12
			NA-XX-SL-DT-332-301	Typical MF & Plasterboard Tile Ceiling Details Sheet 2 of 4		07/03/2012	2		29/06/2012	BMCE-TRANSMIT-009618	20/07/2012		A	BMCE-TRANSMIT-009692 05/07/2012
			NA-XX-SL-DT-332-302	Typical MF & Plasterboard Tile Ceiling Details Sheet 3 of 4		18/05/2012	3		29/06/2012	BMCE-TRANSMIT-009615	20/07/2012		A	BMCE-TRANSMIT-009681 05/07/12
			NA-XX-SL-DT-332-303	Typical MF & Plasterboard Tile Ceiling Details Sheet4 of 4		18/05/2012	3		29/06/2012	BMCE-TRANSMIT-009615	20/07/2012		A	BMCE-TRANSMIT-009681 05/07/12
Specifications	Speciofication relates only to partition walls and not ceilings.	NA	NA-SP-K10	Plasterboard dry linings/ partitions/ ceilings	07/03/2012									
		NA	NA-SP-K40	Demountable suspended ceilings	07/03/2012	18/05/2012	4		29/06/2012	BMCE-TRANSMIT-009615	20/07/2012		A	BMCE-TRANSMIT-009681 05/07/12
			NA-XX-XX-SC-400-001	Standard Fixing Heights (1 of 2)		26/07/2012	B		03/08/2012	BMCE TRANSMIT-010142	24/08/2012	15/08/2012	B	BMCE-TRANSMIT-010482 23/08/2012
			NA-XX-XX-SC-400-001	Standard Fixing Heights (2 of 2)		26/07/2012	B		03/08/2012	BMCE TRANSMIT-010142	24/08/2012	15/08/2012	B	BMCE-TRANSMIT-010482 23/08/2012
			Unistrut Ceiling Drawings											
			PFP-SZ-01-PL-480-001	Plan & Details Of Unistrut X-Ray System (Rooms RAF-077 & RAF 080)		18/03/2013	0		27/03/2013	BMCE-TRANSMIT-014832	17/04/2013	25/05/2013	B	BMCE-TRANSMIT-015961 30/05/2013
			PFP-SZ-01-PL-480-002	Plan & Details Of Unistrut X-Ray System (Room 009)		18/03/2013	0		27/03/2013	BMCE-TRANSMIT-014832	17/04/2013	25/05/2013	B	BMCE-TRANSMIT-015961 30/05/2013
			PFP-SZ-01-PL-480-003	Plan & Details Of Unistrut X-Ray System (Room 135)		18/03/2013	0		27/03/2013	BMCE-TRANSMIT-014832	17/04/2013	25/05/2013	B	BMCE-TRANSMIT-015961 30/05/2013
			PFP-SZ-02-PL-480-001	Plan & Details Of Unistrut X-Ray System (Room THE-228)		30/01/2013	0		12/02/2013	BMCE-TRANSMIT-013889	05/03/2013	06/03/2013	C	BMCE-TRANSMIT-014426 08/03/2013
			PFP-SZ-02-PL-480-002	Plan & Details Of Unistrut X-Ray System (Room THE-232)		30/01/2013	0		12/02/2013	BMCE-TRANSMIT-013889	05/03/2013	06/03/2013	C	BMCE-TRANSMIT-014426 08/03/2013
			PFP-ZA-00-PL-480-001	Plan & Details Of Unistrut X-Ray System (Resus Room EMC-018 Bays 1,2,3 & 4)		30/01/2013	0		12/02/2013	BMCE-TRANSMIT-013889	05/03/2013	06/03/2013	C	BMCE-TRANSMIT-014426 08/03/2013
			PFP-ZD-00-PL-480-001	Plan & Details Of Unistrut X-Ray System (Resus Room EMC-105 Resus)		30/01/2013	1		12/02/2013	BMCE-TRANSMIT-013889	05/03/2013	06/03/2013	C	BMCE-TRANSMIT-014426 08/03/2013
			PFP-ZE-00-PL-480-001	Plan & Details Of Unistrut X-Ray System (Rooms RAG-029, 031, 032, 046, 047, 056, 060)		12/03/2013	A		13/03/2013	BMCE-TRANSMIT-014522	03/04/2013		A	BMCE-TRANSMIT-015951 29/05/2013
			PFP-ZE-00-PL-480-002	Plan & Details Of Unistrut X-Ray System (Rooms RAG 012)		12/03/2013	A		13/03/2013	BMCE-TRANSMIT-014522	03/04/2013		B	BMCE-TRANSMIT-015951 29/05/2013
			PFP-ZE-00-PL-480-003	Plan & Details Of Unistrut X-Ray System (Rooms RCG-043, 053, 077, 082)		18/03/2013	0		19/03/2013	BMCE-TRANSMIT-015952	09/04/2013	22/05/2013	B	BMCE-TRANSMIT-015952 29/05/2013
			PFP-ZE-01-PL-480-001	Plan & Deta ls Of Unistrut X-Ray System (Rooms RAF 128 & 131)		30/01/2013	0		12/02/2013	BMCE-TRANSMIT-013889	05/03/2013	06/03/2013	C	BMCE-TRANSMIT-014426

[illegible]

[illegible]

[illegible]

[illegible]

[illegible]

[illegible]

[illegible]

2nd Submission									2nd Submission									2nd Submission									
Date Required from Consultant	Date Submitted by Consultant	Document Revision	Planned Date to be Submitted to Board	Date Submitted to Board	Date Response Required from Board	Date Received from Board	Board Status	Date Returned to Consultant	Date Required from Consultant	Date Submitted by Consultant	Document Revision	Planned Date to be Submitted to Board	Date Submitted to Board	Date Response Required from Board	Date Received from Board	Board Status	Date Returned to Consultant	Date Required from Consultant	Date Submitted by Consultant	Document Revision	Planned Date to be Submitted to Board	Date Submitted to Board	Date Response Required from Board	Date Received from Board	Board Status		
	04/12/2014	D		BMCE-TRANSMIT-019017 13/01/2014	27/01/2014	28/01/2014	B	BMCE-TRANSMIT-019270 03/02/2014																			
	19/06/2013	B		BMCE-TRANSMIT-016526 27/06/2013	11/07/2013	09/07/2013	B	BMCE-TRANSMIT-016758 11/07/2013																			
	19/06/2013	C		BMCE-TRANSMIT-016526 27/06/2013	11/07/2013	09/07/2013	B	BMCE-TRANSMIT-016758 11/07/2013		18/07/2013	D		BMCE-TRANSMIT-017148 06/08/2013	20/08/2013	09/08/2013	A	BMCE-TRANSMIT-017332 16/08/2013		01/11/2013	E		BMCE-TRANSMIT-018681 04/12/2013	18/12/2013	03/01/2014	A		
	19/06/2013	B		BMCE-TRANSMIT-016526 27/06/2013	11/07/2013	09/07/2013	B	BMCE-TRANSMIT-016758 11/07/2013																			
	19/06/2013	B		BMCE-TRANSMIT-016526 27/06/2013	11/07/2013	09/07/2013	A	BMCE-TRANSMIT-016758 11/07/2013		02/08/2013	C		BMCE-TRANSMIT-017325 16/08/2013	30/08/2013	16/09/2013	A	BMCE-TRANSMIT-017753 19/09/2013		23/10/2013	E		BMCE-TRANSMIT-018388 06/11/2013	20/11/2013	18/11/2013	A		
	19/06/2013	B		BMCE-TRANSMIT-016526 27/06/2013	11/07/2013	09/07/2013	B	BMCE-TRANSMIT-016758 11/07/2013		23/10/2013	E		BMCE-TRANSMIT-018388 06/11/2013	20/11/2013	18/11/2013	B	TRANSMIT-018539 21/11/2013		04/12/2014	F		BMCE-TRANSMIT-019017 13/01/2014	27/01/2014	28/01/2014	A		
24/07/2013	19/02/2013	F		BMCE-TRANSMIT-014266 28/02/2013	21/03/2013	01/04/2013	A	BMCE-TRANSMIT-014986 08/04/2013																			
24/07/2013	19/02/2013	F		BMCE-TRANSMIT-014266 28/02/2013	21/03/2013	01/04/2013	B	BMCE-TRANSMIT-014986 08/04/2013																			
24/07/2013	19/02/2013	F		BMCE-TRANSMIT-014266 28/02/2013	21/03/2013	01/04/2013	B	BMCE-TRANSMIT-014986 08/04/2013																			
24/07/2013	19/02/2013	F		BMCE-TRANSMIT-014266 28/02/2013	21/03/2013	01/04/2013	B	BMCE-TRANSMIT-014986 08/04/2013																			
24/07/2013	19/02/2013	F		BMCE-TRANSMIT-014266 28/02/2013	21/03/2013	01/04/2013	A	BMCE-TRANSMIT-014986 08/04/2013																			
24/07/2013	19/02/2013	F		BMCE-TRANSMIT-014266 28/02/2013	21/03/2013	01/04/2013	A	BMCE-TRANSMIT-014986 08/04/2013																			
24/07/2013	19/02/2013	F		BMCE-TRANSMIT-014266 28/02/2013	21/03/2013	01/04/2013	A	BMCE-TRANSMIT-014986 08/04/2013																			
24/07/2013	19/02/2013	F		BMCE-TRANSMIT-014266 28/02/2013	21/03/2013	01/04/2013	A	BMCE-TRANSMIT-014986 08/04/2013		10/10/2013	G		BMCE-TRANSMIT-018110 17/10/2013	31/10/2013	01/11/2013	A	BMCE-TRANSMIT-018397 07/11/2013										
	22/01/2013	C		BMCE-TRANSMIT-014181 27/02/2013	13/03/2103	13/04/2013	B	BMCE-TRANSMIT-015436 01/05/2013																			
	22/01/2013	C		BMCE-TRANSMIT-014181 27/02/2013	13/03/2103	13/04/2013	B	BMCE-TRANSMIT-015436 01/05/2013		22/07/2013	E		BMCE-TRANSMIT-017147 06/08/201	20/08/2013	09/08/2013	A	BMCE-TRANSMIT-017329 16/08/2013										
	22/01/2013	C		BMCE-TRANSMIT-014181 27/02/2013	13/03/2103	13/04/2013	B	BMCE-TRANSMIT-015436 01/05/2013																			
	22/01/2013	C		BMCE-TRANSMIT-014181 27/02/2013	13/03/2103	13/04/2013	A	BMCE-TRANSMIT-015436 01/05/2013		20/06/2013	D		BMCE-TRANSMIT-016586 02/07/2013	16/07/2013	11/07/2013	B	BMCE-TRANSMIT-016801 16/07/2013										
	22/01/2013	C		BMCE-TRANSMIT-014181	13/03/2103	13/04/2013	B	BMCE-TRANSMIT-015436 01/05/2013		14/06/2013	D		BMCE-TRANSMIT-016488	09/07/2013	10/07/2013	A	BMCE-016789 12/07/2013		23/10/2013	F		BMCE-TRANSMIT-018388	20/11/2013	18/11/2013	A		

2nd Submission									2nd Submission									2nd Submission								
Date Required from Consultant	Date Submitted by Consultant	Document Revision	Planned Date to be Submitted to Board	Date Submitted to Board	Date Response Required from Board	Date Received from Board	Board Status	Date Returned to Consultant	Date Required from Consultant	Date Submitted by Consultant	Document Revision	Planned Date to be Submitted to Board	Date Submitted to Board	Date Response Required from Board	Date Received from Board	Board Status	Date Returned to Consultant	Date Required from Consultant	Date Submitted by Consultant	Document Revision	Planned Date to be Submitted to Board	Date Submitted to Board	Date Response Required from Board	Date Received from Board	Board Status	
	04/12/2013	D		BMCE-TRANSMIT-019016 13/01/2014	27/01/2014	28/01/2014	A	BMCE-TRANSMIT-019271 19/02/2014																		
	15/07/2013	C		BMCE-TRANSMIT-017151 06/08/2013	20/08/2013	09/08/2013	B	BMCE-TRANSMIT-017321 16/08/201																		
	18/07/2013	D		BMCE-TRANSMIT-017149 06/08/2013	20/08/2013	09/08/2013	B	BMCE-TRANSMIT-017349 19/08/2013		29/10/2013	F		BMCE-TRANSMIT-018389 06/11/2013	20/11/2013	18/11/2013	B	BMCE-TRANSMIT-018549 21/11/2013		08/11/2013	G		BMCE-TRANSMIT-018685 04/12/2013	18/12/2013			
	22/11/2013	B		BMCE-TRANSMIT-018810 12/12/2013	08/01/2014	13/01/2014	A	BMCE-TRANSMIT-019159 22/01/2014																		
	18/07/2013	C		BMCE-TRANSMIT-017149 06/08/2013	20/08/2013	09/08/2013	A	BMCE-TRANSMIT-017349 19/08/2013		29/10/2013	E		BMCE-TRANSMIT-018389 06/11/2013	20/11/2013	18/11/2013	A	BMCE-TRANSMIT-018549 21/11/2013									
	15/07/2013	B		BMCE-TRANSMIT-017151 06/08/2013	20/08/2013	09/08/2013	B	BMCE-TRANSMIT-017321 16/08/201		11/10/2013	C		BMCE-TRANSMIT-018351 04/11/201	18/11/2013	19/11/2013	A	BMCE-TRANSMIT-018537 21/11/2013									
	15/07/2013	B		BMCE-TRANSMIT-017151 06/08/2013	20/08/2013	09/08/2013	A	BMCE-TRANSMIT-017321 16/08/201		21/03/2014	D		BMCE-TRANSMIT-019910 11/04/2014	21/04/2014	22/04/2014	A	BMCE-TRANSMIT-020031 01/05/2014									
	15/07/2013	B		BMCE-TRANSMIT-017151 06/08/2013	20/08/2013	09/08/2013	B	BMCE-TRANSMIT-017321 16/08/201																		
	29/10/2013	D		BMCE-TRANSMIT-018389 06/11/2013	20/11/2013	18/11/2013	B	BMCE-TRANSMIT-018549 21/11/2013		28/01/2014	F		BMCE-TRANSMIT-019465 18/02/2014	04/03/2014	26/03/2014	A	BMCE-TRANSMIT-019827 01/04/2014									
	18/09/2013	B		BMCE-TRANSMIT-018108 17/10/2013	31/10/2013	28/10/2013	A	BMCE-TRANSMIT-018309 01/11/2013																		
	04/12/2013	B		BMCE-TRANSMIT-019016 13/01/2014	27/01/2014	28/01/2014	B	BMCE-TRANSMIT-019271 19/02/2014																		
	05/08/2013	B		BMCE-TRANSMIT-017326 16/08/2013	30/08/2013	16/09/2013	B	BMCE-TRANSMIT-017755 19/09/2013																		
	22/01/2013	C		BMCE-TRANSMIT-014181 27/02/2013	13/03/2103	13/04/2013	A	BMCE-TRANSMIT-015436 01/05/2013		20/06/2013	D		BMCE-TRANSMIT-016586 02/02/2013	16/07/2013	11/07/2013	B	BMCE-TRANSMIT-016801 16/02/2013									
	22/01/2013	C		BMCE-TRANSMIT-014181 27/02/2013	13/03/2103	13/04/2013	B	BMCE-TRANSMIT-015436 01/05/2013		17/04/2013	D		BMCE-TRANSMIT-015562 15/05/2013	29/05/2013	28/05/2013	A	BMCE-TRANSMIT-015971 30/05/2013		29/10/2013	F		BMCE-TRANSMIT-018389 06/11/2013	20/11/2013	18/11/2013	A	
	22/01/2013	C		BMCE-TRANSMIT-014181 27/02/2013	13/03/2103	13/04/2013	B	BMCE-TRANSMIT-015436 01/05/2013		17/04/2013	D		BMCE-TRANSMIT-015562 15/05/2013	29/05/2013	28/05/2013	B	BMCE-TRANSMIT-015971 30/05/2013		20/06/2013	E		BMCE-TRANSMIT-016586 02/07/2013	16/07/2013	11/07/2013	B	
	22/01/2013	D		BMCE-TRANSMIT-014181 27/02/2013	13/03/2103	13/04/2013	B	BMCE-TRANSMIT-015436 01/05/2013																		
	22/01/2013	C		BMCE-TRANSMIT-014181	13/03/2103	13/04/2013	A	BMCE-TRANSMIT-015436 01/05/2013																		

2nd Submission									2nd Submission									2nd Submission								
Date Required from Consultant	Date Submitted by Consultant	Document Revision	Planned Date to be Submitted to Board	Date Submitted to Board	Date Response Required from Board	Date Received from Board	Board Status	Date Returned to Consultant	Date Required from Consultant	Date Submitted by Consultant	Document Revision	Planned Date to be Submitted to Board	Date Submitted to Board	Date Response Required from Board	Date Received from Board	Board Status	Date Returned to Consultant	Date Required from Consultant	Date Submitted by Consultant	Document Revision	Planned Date to be Submitted to Board	Date Submitted to Board	Date Response Required from Board	Date Received from Board	Board Status	
	02/08/2013	B		BMCE-TRANSMIT-017325 16/08/2013	30/08/2013	16/09/2013	B	BMCE-TRANSMIT-017753 19/09/2013																		
	15/07/2013	B		BMCE-TRANSMIT-017151 06/08/2013	20/08/2013	09/08/2013	A	BMCE-TRANSMIT-017321 16/08/201																		
	17/01/2014	B		BMCE-TRANSMIT-019410 12/02/2014	26/02/2014	03/03/2014	A	BMCE-TRANSMIT-019648 11/03/2014																		
	29/10/2013	C		BMCE-TRANSMIT-018390 06/11/2013	20/11/2013	18/11/2013	B	BMCE-TRANSMIT-018554 21/11/2013																		
	29/10/2013	C		BMCE-TRANSMIT-018390 06/11/2013	20/11/2013	18/11/2013	B	BMCE-TRANSMIT-018554 21/11/2013		22/11/2013	E		BMCE-TRANSMIT-018810 12/12/2013	08/01/2014	13/01/2014	A	BMCE-TRANSMIT-019159 22/01/2014									
	22/11/2013	C		BMCE-TRANSMIT-018810 12/12/2013	08/01/2014	13/01/2014	B	BMCE-TRANSMIT-019159 22/01/2014																		
	29/10/2013	C		BMCE-TRANSMIT-018390 06/11/2013	20/11/2013	18/11/2013	B	BMCE-TRANSMIT-018554 21/11/2013		22/11/2013	E		BMCE-TRANSMIT-018810 12/12/2013	08/01/2014	13/01/2014	A	BMCE-TRANSMIT-019159 22/01/2014									
	22/11/2013	B		BMCE-TRANSMIT-018810 12/12/2013	08/01/2014	13/01/2014	A	BMCE-TRANSMIT-019159 22/01/2014																		
	22/11/2013	B		BMCE-TRANSMIT-018810 12/12/2013	08/01/2014	13/01/2014	A	BMCE-TRANSMIT-019159 22/01/2014																		
	10/06/2013	C		BMCE-TRANSMIT-016522 27/06/2013	11/07/2013	10/07/2013	A	BMCE-TRANSMIT-016790 12/07/2013		11/10/2013	D		BMCE-TRANSMIT-018387 06/11/2013	20/11/2013	18/11/2013	B	BMCE-TRANSMIT-018541 21/11/2013									
	10/06/2013	C		BMCE-TRANSMIT-016522	11/07/2013	10/07/2013	B	BMCE-TRANSMIT-016790 12/07/2013		11/10/2013	D		BMCE-TRANSMIT-018387	20/11/2013	18/11/2013	B	BMCE-TRANSMIT-018541									

2nd Submission									2nd Submission									2nd Submission								
Date Required from Consultant	Date Submitted by Consultant	Document Revision	Planned Date to be Submitted to Board	Date Submitted to Board	Date Response Required from Board	Date Received from Board	Board Status	Date Returned to Consultant	Date Required from Consultant	Date Submitted by Consultant	Document Revision	Planned Date to be Submitted to Board	Date Submitted to Board	Date Response Required from Board	Date Received from Board	Board Status	Date Returned to Consultant	Date Required from Consultant	Date Submitted by Consultant	Document Revision	Planned Date to be Submitted to Board	Date Submitted to Board	Date Response Required from Board	Date Received from Board	Board Status	
	06/03/2014	E		BMCE-TRANSMIT-019771 25/03/2014	08/04/2014																					
	10/06/2013	C		BMCE-TRANSMIT-016522 27/06/2013	11/07/2013	10/07/2013	B	BMCE-TRANSMIT-016790 12/07/2013		04/03/2014	E		BMCE-TRANSMIT-019689 13/03/2014	27/03/2014	24/03/2014	A	BMCE-TRANSMIT-019779 26/03/2014									
	06/03/2014	D		BMCE-TRANSMIT-019771 25/03/2014	08/04/2014																					
	10/06/2013	C		BMCE-TRANSMIT-016522 27/06/2013	11/07/2013	10/07/2013	B	BMCE-TRANSMIT-016790 12/07/2013																		
	10/06/2013	C		BMCE-TRANSMIT-016522 27/06/2013	11/07/2013	10/07/2013	A	BMCE-TRANSMIT-016790 12/07/2013		21/08/2013	D		BMCE-TRANSMIT-017599 05/09/2013	19/09/2013	19/11/2014	A	BMCE-TRANSMIT-018666 03/12/2013									
	10/06/2013	C		BMCE-TRANSMIT-016522 27/06/2013	11/07/2013	10/07/2013	B	BMCE-TRANSMIT-016790 12/07/2013																		
	10/06/2013	C		BMCE-TRANSMIT-016522 27/06/2013	11/07/2013	10/07/2013	A	BMCE-TRANSMIT-016790 12/07/2013																		
	12/09/2013	C		BMCE-TRANSMIT-017722 16/09/2013	30/09/2013	01/10/2013	A	BMCE-TRANSMIT-017988 09/10/2013		25/10/2013	D		BMCE-TRANSMIT-018394 07/11/2013	21/11/2013	19/11/2014	B	BMCE-TRANSMIT-018666 03/12/2013									
	12/09/2013	C		BMCE-TRANSMIT-017722 16/09/2013	30/09/2013	01/10/2013	A	BMCE-TRANSMIT-017988 09/10/2013		25/10/2013	D		BMCE-TRANSMIT-018394 07/11/2013	21/11/2013	19/11/2014	B	BMCE-TRANSMIT-018666 03/12/2013									
	10/06/2013	C		BMCE-TRANSMIT-016522 27/06/2013	11/07/2013	10/07/2013	A	BMCE-TRANSMIT-016790 12/07/2013		12/09/2013	D		BMCE-TRANSMIT-017722 16/09/2013	30/09/2013	01/10/2013	A	BMCE-TRANSMIT-017988 09/10/2013		11/10/2013	E		BMCE-TRANSMIT-018387 06/11/2013	20/11/2013	18/11/2013	B	
	12/09/2013	C		BMCE-TRANSMIT-017722 16/09/2013	30/09/2013	01/10/2013	B	BMCE-TRANSMIT-017988 09/10/2013		25/10/2013	D		BMCE-TRANSMIT-018394 07/11/2013	21/11/2013	19/11/2014	B	BMCE-TRANSMIT-018666 03/12/2013									
	11/10/2013	E		BMCE-TRANSMIT-018387 06/11/2013	20/11/2013	18/11/2013	A	BMCE-TRANSMIT-018541 21/11/2013																		
	25/10/2013	B		BMCE-TRANSMIT-018394 07/11/2013	21/11/2013	18/11/2013	B	BMCE-TRANSMIT-018541 21/11/2013		18/02/2014	D		BMCE-TRANSMIT-019615 06/03/2014	20/03/2014	11/03/2014	B	BMCE-TRANSMIT-019717 18/03/2014									
	11/10/2013	E		BMCE-TRANSMIT-018387 06/11/2013	20/11/2013	18/11/2013	B	BMCE-TRANSMIT-018541 21/11/2013																		
	13/03/2013	B		BMCE-TRANSMIT-014980 08/04/2013	22/04/2013	07/05/2013	B	BMCE-TRANSMIT-015563 10/05/2013		10/06/2013	C		BMCE-TRANSMIT-016487 25/06/2013	09/07/2013	11/07/2013	A	BMCE-TRANSMIT-016802 16/07/2013		14/10/2013	D		BMCE-TRANSMIT-018384 06/11/2013	20/11/2013	18/11/2013	B	
	13/03/2013	B		BMCE-TRANSMIT-014980 08/04/2013	22/04/2013	07/05/2013	B	BMCE-TRANSMIT-015563 10/05/2013		10/06/2013	C		BMCE-TRANSMIT-016487 25/06/2013	09/07/2013	11/07/2013	A	BMCE-TRANSMIT-016802 16/07/2013		14/10/2013	D		BMCE-TRANSMIT-018384 06/11/2013	20/11/2013	18/11/2013	B	
	13/03/2013	B		BMCE-TRANSMIT-014980 08/04/2013	22/04/2013	07/05/2013	B	BMCE-TRANSMIT-015563 10/05/2013																		
	06/03/2014	C		BMCE-TRANSMIT-019771 25/03/2014	08/04/2014																					
	04/03/2014	C		BMCE-TRANSMIT-019689	27/03/2014	24/03/2014	A	BMCE-TRANSMIT-019779 26/03/2014																		

2nd Submission									2nd Submission									2nd Submission								
Date Required from Consultant	Date Submitted by Consultant	Document Revision	Planned Date to be Submitted to Board	Date Submitted to Board	Date Response Required from Board	Date Received from Board	Board Status	Date Returned to Consultant	Date Required from Consultant	Date Submitted by Consultant	Document Revision	Planned Date to be Submitted to Board	Date Submitted to Board	Date Response Required from Board	Date Received from Board	Board Status	Date Returned to Consultant	Date Required from Consultant	Date Submitted by Consultant	Document Revision	Planned Date to be Submitted to Board	Date Submitted to Board	Date Response Required from Board	Date Received from Board	Board Status	
	13/03/2013	B		BMCE-TRANSMIT-014980 08/04/2013	22/04/2013	07/05/2013	A	BMCE-TRANSMIT-015563 10/05/2013																		
	04/03/2014	C		BMCE-TRANSMIT-019689 13/03/2014	27/03/2014	24/03/2014	A	BMCE-TRANSMIT-019779 26/03/2014																		
	06/03/2014	C		BMCE-TRANSMIT-019771 25/03/2014	08/04/2014																					
	13/03/2013	B		BMCE-TRANSMIT-014980 08/04/2013	22/04/2013	07/05/2013	B	BMCE-TRANSMIT-015563 10/05/2013		06/09/2013	C		BMCE-TRANSMIT-017786 23/09/2013	07/10/2013	16/10/2013	A	BMCE-TRANSMIT-018162 21/10/2013		14/10/2013	D		BMCE-TRANSMIT-018384 06/11/2013	20/11/2013	18/11/2013	B	
	06/03/2014	C		BMCE-TRANSMIT-019771 25/03/2014	08/04/2014																					
	10/06/2013	B		BMCE-TRANSMIT-016487 25/06/2013	09/07/2013	11/07/2013	A	BMCE-TRANSMIT-016802 16/07/2013		14/10/2013	B		BMCE-TRANSMIT-018384 06/11/2013	20/11/2013	18/11/2013	B	BMCE-TRANSMIT-018576 22/11/2013		11/11/2013	D		BMCE-TRANSMIT-018759 10/12/2013	24/12/2013	03/01/2014	A	
	10/06/2013	B		BMCE-TRANSMIT-016487 25/06/2013	09/07/2013	11/07/2013	A	BMCE-TRANSMIT-016802 16/07/2013		14/10/2013	B		BMCE-TRANSMIT-018384 06/11/2013	20/11/2013	18/11/2013	B	BMCE-TRANSMIT-018576 22/11/2013		11/11/2013	D		BMCE-TRANSMIT-018759 10/12/2013	24/12/2013	03/01/2014	A	
	04/03/2014	C		BMCE-TRANSMIT-019700 18/03/2014	01/04/2014																					
	04/03/2014	C		BMCE-TRANSMIT-019700 18/03/2014	01/04/2014																					
	04/03/2014	C		BMCE-TRANSMIT-019700 18/03/2014	01/04/2014																					
	04/03/2014	B		BMCE-TRANSMIT-019700 18/03/2014	01/04/2014																					
	04/03/2014	C		BMCE-TRANSMIT-019700 18/03/2014	01/04/2014																					
	04/03/2014	D		BMCE-TRANSMIT-019700 18/03/2014	01/04/2014																					
	04/03/2014	C		BMCE-TRANSMIT-019700 18/03/2014	01/04/2014																					
	04/03/2014	C		BMCE-TRANSMIT-019700 18/03/2014	01/04/2014																					
	14/10/2013	B		BMCE-TRANSMIT-018384 06/11/2013	20/11/2013	18/11/2013	B	BMCE-TRANSMIT-018576 22/11/2013		11/11/2013	C		BMCE-TRANSMIT-018759 10/12/2013	24/12/2013	03/01/2014	A	BMCE-TRANSMIT-018980 09/01/2014		04/03/2014	D		BMCE-TRANSMIT-019700 18/03/2014	01/04/2014			
	04/03/2014	E		BMCE-TRANSMIT-019700 18/03/2014	01/04/2014																					
	10/06/2013	B		BMCE-TRANSMIT-016487 25/06/2013	09/07/2013	11/07/2013	A	BMCE-TRANSMIT-016802 16/07/2013		14/10/2013	C		BMCE-TRANSMIT-018384 06/11/2013	20/11/2013	18/11/2013	B	BMCE-TRANSMIT-018576 22/11/2013		11/11/2013	D		BMCE-TRANSMIT-018759 10/12/2013	24/12/2013	03/01/2014	A	
	10/06/2013	B		BMCE-TRANSMIT-016487 25/06/2013	09/07/2013	11/07/2013	A	BMCE-TRANSMIT-016802 16/07/2013		14/10/2013	C		BMCE-TRANSMIT-018384 06/11/2013	20/11/2013	18/11/2013	B	BMCE-TRANSMIT-018576 22/11/2013		11/11/2013	D		BMCE-TRANSMIT-018759 10/12/2013	24/12/2013	03/01/2014	A	
	11/10/2013	B		BMCE-TRANSMIT-018351	18/11/2013	19/11/2013	B	BMCE-TRANSMIT-018537 21/11/2013		04/03/2014	D		BMCE-TRANSMIT-019693	28/03/2014												

2nd Submission									2nd Submission									2nd Submission								
Date Required from Consultant	Date Submitted by Consultant	Document Revision	Planned Date to be Submitted to Board	Date Submitted to Board	Date Response Required from Board	Date Received from Board	Board Status	Date Returned to Consultant	Date Required from Consultant	Date Submitted by Consultant	Document Revision	Planned Date to be Submitted to Board	Date Submitted to Board	Date Response Required from Board	Date Received from Board	Board Status	Date Returned to Consultant	Date Required from Consultant	Date Submitted by Consultant	Document Revision	Planned Date to be Submitted to Board	Date Submitted to Board	Date Response Required from Board	Date Received from Board	Board Status	
	14/10/2013	B		BMCE-TRANSMIT-018384 06/11/2013	20/11/2013	18/11/2013	B	BMCE-TRANSMIT-018576 22/11/2013		15/11/2013	C		BMCE-TRANSMIT-018748 09/12/2013	23/12/2013	03/01/2014	A	BMCE-TRANSMIT-018982 09/01/2004									
	06.03.2014	C		BMCE-TRANSMIT-019826 01.04.2014	22.04.2014	22.04.2014	A	BMCE-TRANSMIT-020018 29.04.2014																		
	06/09/2013	B		BMCE-TRANSMIT-017786 23/09/2013	07/10/2013	16/10/2013	B	BMCE-TRANSMIT-018162 21/10/2013																		
	06.03.2014	C		BMCE-TRANSMIT-019826 01.04.2014	22.04.2014	22.04.2014	A	BMCE-TRANSMIT-020018 29.04.2014																		
	06.03.2014	C		BMCE-TRANSMIT-019826 01.04.2014	22.04.2014	22.04.2014	A	BMCE-TRANSMIT-020018 29.04.2014																		
	06/09/2013	B		BMCE-TRANSMIT-017786 23/09/2013	07/10/2013	16/10/2013	B	BMCE-TRANSMIT-018162 21/10/2013		06.03.2014	C		BMCE-TRANSMIT-019826 01.04.2014	22.04.2014	22.04.2014	A	BMCE-TRANSMIT-020018 29.04.2014									
	06.03.2014	C		BMCE-TRANSMIT-019826 01.04.2014	22.04.2014	22.04.2014	A	BMCE-TRANSMIT-020018 29.04.2014																		
	06.03.2014	C		BMCE-TRANSMIT-019826 01.04.2014	22.04.2014	22.04.2014	A	BMCE-TRANSMIT-020018 29.04.2014																		
	06/09/2013	B		BMCE-TRANSMIT-017786 23/09/2013	07/10/2013	16/10/2013	B	BMCE-TRANSMIT-018162 21/10/2013																		
	06.03.2014	C		BMCE-TRANSMIT-019826 01.04.2014	22.04.2014	22.04.2014	A	BMCE-TRANSMIT-020018 29.04.2014																		
	06.03.2014	C		BMCE-TRANSMIT-019826 01.04.2014	22.04.2014	22.04.2014	A	BMCE-TRANSMIT-020018 29.04.2014																		
	14/10/2013	B		BMCE-TRANSMIT-018384 06/11/2013	20/11/2013	18/11/2013	B	BMCE-TRANSMIT-018576 22/11/2013		15/11/2013	C		BMCE-TRANSMIT-018748 09/12/2013	23/12/2013	03/01/2014	A	BMCE-TRANSMIT-018982 09/01/2004		06.03.2014	D		BMCE-TRANSMIT-019826 01.04.2014	22.04.2014	22.04.2014	A	
	06.03.2014	C		BMCE-TRANSMIT-019826 01.04.2014	22.04.2014	22.04.2014	A	BMCE-TRANSMIT-020018 29.04.2014																		
	14/10/2013	B		BMCE-TRANSMIT-018384 06/11/2013	20/11/2013	18/11/2013	B	BMCE-TRANSMIT-018576 22/11/2013		15/11/2013	C		BMCE-TRANSMIT-018748 09/12/2013	23/12/2013	03/01/2014	A	BMCE-TRANSMIT-018982 09/01/2004									
	14/10/2013	B		BMCE-TRANSMIT-018384 06/11/2013	20/11/2013	18/11/2013	B	BMCE-TRANSMIT-018576 22/11/2013		15/11/2013	C		BMCE-TRANSMIT-018748 09/12/2013	23/12/2013	03/01/2014	A	BMCE-TRANSMIT-018982 09/01/2004									
	06.03.2014	C		BMCE-TRANSMIT-019829 01.04.2014	22.04.2014	22.04.2014	A	BMCE-TRANSMIT-020022 29.04.2014																		
	06.03.2014	C		BMCE-TRANSMIT-019829 01.04.2014	22.04.2014	22.04.2014	A	BMCE-TRANSMIT-020022 29.04.2014																		
	06.03.2014	C		BMCE-TRANSMIT-019829 01.04.2014	22.04.2014	22.04.2014	A	BMCE-TRANSMIT-020022 29.04.2014																		
	06.03.2014	B		BMCE-TRANSMIT-019829 01.04.2014	22.04.2014	22.04.2014	A	BMCE-TRANSMIT-020022 29.04.2014																		
	06.03.2014	C		BMCE-TRANSMIT-019829 01.04.2014	22.04.2014	22.04.2014	A	BMCE-TRANSMIT-020022 29.04.2014																		
	06.03.2014	C		BMCE-TRANSMIT-019829 01.04.2014	22.04.2014	22.04.2014	A	BMCE-TRANSMIT-020022 29.04.2014																		

[illegible]

[illegible]

Date Returned to Consultant

[illegible]

Date Returned to Consultant

[illegible]

Date Returned to Consultant
BMC-TRANSMIT-018980 09/01/2014 BMC-TRANSMIT-018980 09/01/2014

[illegible]

[illegible]

[illegible]

[illegible]

[illegible]

2nd Submission								
Date Required from Consultant	Date Submitted by Consultant	Document Revision	Planned Date to be Submitted to Board	Date Submitted to Board	Date Response Required from Board	Date Received from Board	Board Status	Date Returned to Consultant

[illegible]

[illegible]

21 BCL-AC-XX-SH-001

Item	Submission	Comments															
21	Reception Desks & Nurses Stations	Colour, Layout, Maintenance, Lifecycle, H & S															
	Specifications		NA	NA-SP-Z10	Purpose made Joinery	25/05/2012	11/05/2012	5			BMCE-TRANSMIT-009659	25/07/2012	24/10/2012	B	BMCE-TRANSMIT-011965		
	Reception Desk & Staff Base Details	Aspect of review:	NA	NA-SZ-XX-DT-401-100	Desk Module Key	25/05/2012	11/05/2012	6			BMCE-TRANSMIT-009659	25/07/2012	25/10/2012	B	BMCE-TRANSMIT-011967		
		Colour	NA	NA-SZ-00-DT-401-101	Desk Type 1 - Adult Main Reception Desk	tbc 2012											
		Layout	NA	NA-SZ-00-DT-401-102	Desk Type 2 - Typical Department Reception Desk	25/05/2012	11/05/2012	4			BMCE-TRANSMIT-009659	25/07/2012	25/10/2012	B	BMCE-TRANSMIT-011967		
		Clinical Functionality	NA	NA-SZ-XX-DT-401-103	Desk Type 3 - Typical Department Staff Base	25/05/2012											
		Maintenance	NA	NA-SZ-XX-DT-401-104	Desk Type 4 - Typical Touchdown Base	25/05/2012	11/05/2012	6			BMCE-TRANSMIT-009659	25/07/2012	25/10/2012	B	BMCE-TRANSMIT-011967		
		Lifecycle	NA	NA-SZ-XX-DT-401-105	Desk Type 5 - A&E Reception Desk	25/05/2012	11/05/2012	4			BMCE-TRANSMIT-009659	25/07/2012	25/10/2012	B	BMCE-TRANSMIT-011967		
		H&S	NA	NA-SZ-XX-DT-401-106	Desk Type 2 - Typical Department Reception Desk (with privacy screen)	25/05/2012	30/01/2013	4			BMCE-TRANSMIT-018195	14/11/2013	22/11/2013	A	BMCE-TRANSMIT-018596		
			NA	NA-SZ-XX-DT-401-107	Desk Type 1a - Children's Main Reception Desk	25/05/2012	30/01/2013	3			BMCE-TRANSMIT-018195	14/11/2013	22/11/2013	A	BMCE-TRANSMIT-018596		19/02/2014
		NHS have viewed and approved Mock Up Sample. Further RDD review not required	NA	NA-SZ-xx-DT-401-108	Desk Type 6 - Cashiers Desk	tbc 2012	11/05/2012	2			BMCE-TRANSMIT-009660 04/07/12	25/07/2012	24/10/2012	C	BMCE-TRANSMIT-011965		
		NHS have viewed and approved Mock Up Sample. Further RDD review not required	NA	NA-SZ-xx-DT-401-109	Worktops & Linen Store (Critical Care)	tbc 2012	11/05/2012	2			BMCE-TRANSMIT-009660 04/07/12	25/07/2012	24/10/2012	C	BMCE-TRANSMIT-011965		
				NA-SZ-xx-DT-401-110	Reception Desks Type 2 & 3 NCH	25/05/2012	30/01/2013	2			BMCE-TRANSMIT-018195	14/11/2013	22/11/2013	A	BMCE-TRANSMIT-018596		
#####	11/05/2012		NA	NA-SZ-XX-DT-401-112	Pharmacy Reception Desk	tbc 2012	11/05/2012	2			BMCE-TRANSMIT-009659 04/07/12	25/07/2012	25/10/2012	B	BMCE-TRANSMIT-011967		
	Desk Type Location Plans (1:200)		NA	NA-XX-00-PL-401-100	Ground Floor Plan - NSGH Entrance Reception and Atrium Space - Desk Type Location	tbc 2012	11/05/2012	4			BMCE-TRANSMIT-009659 04/07/12	25/07/2012	25/10/2012	A	BMCE-TRANSMIT-011967		
			NA	NA-XX-00-PL-401-101	Ground Floor Plan - NCH Rehab - Desk Type Location	tbc 2012											
			NA	NA-XX-00-PL-401-102	Ground Floor Plan - NCH Entrance and OPD - Desk Type Location	tbc 2012	10/12/2013	5			BMCE-TRANSMIT-018825	08/01/2013	09/01/2014	A	BMCE-TRANSMIT-019015		
			NA	NA-XX-00-PL-401-103	Ground Floor Plan - NCH Observation Ward / Ch Id Protection / Sanctuary - Desk Type Location	tbc 2012											
			NA	NA-XX-00-PL-401-104	Ground Floor Plan - NCH Emergency Department / Decontamination Unit - Desk Type Location	25/05/2012											
			NA	NA-XX-00-PL-401-105	Ground Floor Plan - NSGH Emergency Department - Desk Type Location	25/05/2012	11/05/2012	3			BMCE-TRANSMIT-009660 04/07/12	25/07/2012	24/10/2012	A	BMCE-TRANSMIT-011965		
			NA	NA-XX-00-PL-401-106	Ground Floor Plan - NSGH Acute Assessment - Desk Type Location	25/05/2012	11/05/2012	4			BMCE-TRANSMIT-009660 04/07/12	25/07/2012	24/10/2012	A	BMCE-TRANSMIT-011965		
			NA	NA-XX-00-PL-401-107	Ground Floor Plan - NSGH Radiology / Medical Illustration - Desk Type Location	tbc 2012	11/05/2012	4			BMCE-TRANSMIT-009660 04/07/12	25/07/2012	24/10/2012	A	BMCE-TRANSMIT-011965		
			NA	NA-XX-00-PL-401-108	Ground Floor Plan - NCH Radiology - Desk Type Location	25/05/2012											
			NA	NA-XX-00-PL-401-109	Ground Floor Plan - NSGH OPD / Rehab & Therapies - Desk Type Location	tbc 2012	11/05/2012	3			BMCE-TRANSMIT-009660 04/07/12	25/07/2012	24/10/2012	A	BMCE-TRANSMIT-011965		
			NA	NA-XX-01-PL-401-100	First Floor Plan - NSGH Restaurant, Sanctuary and Atrium Space - Desk Type Location	tbc 2012	11/05/2012	3			BMCE-TRANSMIT-009660 04/07/12	25/07/2012	24/10/2012	C	BMCE-TRANSMIT-011965		20/11/2013
			NA	NA-XX-01-PL-401-101	First Floor Plan - NCH Theatres / Interventional Radiology and Radiology - Desk Type Location	tbc 2012											

21

BCL-AC-XX-SH-001

			1st Submission													
			Action By	Drawing Number	Drawing Title	Date Required from Consultant	Date Submitted by Consultant	Document Revision	Planned Date to be Submitted to Board	Date Submitted to Board	Date Response Required from Board (+3 Weeks)	Date Returned from Board	Board Status	Date returned to Consultant	Date Required from Consultant	D Subm Cons
Item	Submission	Comments														
			NA	NA-XX-02-PL-401-103	Second Floor Plan - NCH Acute Receiving Ward - Desk Type Location	25/05/2012										
			NA	NA-XX-02-PL-401-104	Second Floor Plan - NSGH Endoscopy / Decontamination / Medical Physics / Stores - Desk Type Location	25/05/2012	11/05/2012	3		BMCE-TRANSMIT-009660 04/07/12	25/07/2012	24/10/2012	A	BMCE-TRANSMIT-011965 24/10/12		
			NA	NA-XX-02-PL-401-105	Second Floor Plan - NSGH Theatres (1 of 2) Plant - Desk Type Location	25/05/2012	11/05/2012	4		BMCE-TRANSMIT-009660 04/07/12	25/07/2012	24/10/2012	B	BMCE-TRANSMIT-011965 24/10/12		

RDD MASTER SCHEDULE - NHS Greater Glasgow & Clyde / New South Glasgow Hospitals (NSGH) Project - Adults & Childrens Hospitals

[illegible]

[illegible]

[illegible]

BCL-AC-XX-SH-001			1st Submission													
			Action By	Drawing Number	Drawing Title	Date Required from Consultant	Date Submitted by Consultant	Document Revision	Planned Date to be Submitted to Board	Date Submitted to Board	Date Response Required from Board (+3 Weeks)	Date Returned from Board	Board Status	Date returned to Consultant	Date Required from Consultant	
Item	Submission	Comments														
24	Group 1 Fitted Furniture	Design, Materials for Construction, Colour, etc.														
	Specification		NA	NA-SP-N10	General fixtures/ furnishings/ equipment											
	Aspect of review:															
	Design															
	Materials for Construction															
	Colour															
	Maintenance															
	Lifecycle															
	Note:															
	See also sample schedule															
	Group 1 Detail Plans (1:50)	These are shown on the 150 fixtures & fittings plans	NA	Refer to Item 3	Refer to Item 3											
				JTC-XX-XX-SH-400-001	JTC Proposed Key Suiting Schedule		11/04/2013	1		BMCE-TRANSMIT-015247 19/04/2013	10/05/2013	09/05/2013	B	BMCE-TRANSMIT-015620 14/05/2013		
				JTC-XX-XX-SH-400-003	Storage Unit		10/10/2012	0		This was not issued to the Board I t i II		08/10/2012	A	TRANSMIT-016165 08/05/2013		
				JTC-XX-XX-DC-400-021	CAB160 (dental,1door,under bench)		31/01/2013	0		BMCE-TRANSMIT-014816 27/03/2013	17/04/2013		B	BMCE-TRANSMIT-016380 09/06/2013		
				JTC-XX-XX-DC-400-022	CAB162 cabinet/drawer unit, dental under bench		31/01/2013	0		BMCE-TRANSMIT-014816 27/03/2013	17/04/2013		B	BMCE-TRANSMIT-016380 19/06/2013		
				JTC-XX-XX-DC-400-054	CUP1008 cupboard roller shutter door 1000 x 500 x 1800H		20/11/2013	0		BMCE-TRANSMIT-013474 22/01/2013	12/02/2013		B	TRANSMIT-014819 27/03/2013		
				JTC-XX-XX-DC-400-056	CUP1020 cupboard, roller shutter door 800W 500D 1800H		20/11/2013	0		BMCE-TRANSMIT-013474 22/01/2013	12/02/2013		B	TRANSMIT-014819 27/03/2013		
				JTC-XX-XX-DC-400-067	CUP1038 cupboard, implant storage			0		BMCE-TRANSMIT-013480 22/01/2013	12/02/2013		B	TRANSMIT-013480 22/04/2013		
				JTC-XX-XX-DC-400-073	DEN010 dental unit, with multi services terminal		31/01/2013	0		BMCE-TRANSMIT-014816 27/03/2013	17/04/2013		B	BMCE-TRANSMIT-016380 09/06/2013		
				JTC-XX-XX-DC-400-127	MSC501 pharmacy cabinet, 600 facing, 4 shelves, 1 pull-out prep, shelf, 1 door R/H, security lock, o/a 1200H		20/11/2013	0		BMCE-TRANSMIT-013474 22/01/2013	12/02/2013		A	TRANSMIT-014819 27/03/2013		
				JTC-XX-XX-DC-400-128	MSC503 pharmacy cabinet, 600 facing, 4 shelves, 1 pull-out prep, contolled drugs cup'd, 1 door R/H, security lock, o/a 1200H		20/11/2013	0		BMCE-TRANSMIT-013474 22/01/2013	12/02/2013		A	TRANSMIT-014819 27/03/2013		
				JTC-XX-XX-DC-400-129	MSC504 pharmacy cabinet, 600 facing, 4 shelves, 1 pull-out prep, controlled drugs cup'd, 1 door L/H, security lock, o/a 1200H		20/11/2013	0		BMCE-TRANSMIT-013474 22/01/2013	12/02/2013		A	TRANSMIT-014819 27/03/2013		
				JTC-XX-XX-DC-400-135	MSC1011 pharmacy cabinet, 600 facing, 4 shelves, 1 pull-out prep, 2 doors, security lock		20/11/2013	0		BMCE-TRANSMIT-013474 22/01/2013	12/02/2013		A	TRANSMIT-014819 27/03/2013		
				JTC-XX-XX-DC-400-245	ALT7520 ALTAR; with built-in storage		31/01/2013	0		BMCE-TRANSMIT-014816 27/03/2013	17/04/2013		B	TRANSMIT-016380 19/06/2013		

			1st Submission												
			Action By	Drawing Number	Drawing Title	Date Required from Consultant	Date Submitted by Consultant	Document Revision	Planned Date to be Submitted to Board	Date Submitted to Board	Date Response Required from Board (+3 Weeks)	Date Returned from Board	Board Status	Date returned to Consultant	Date Required from Consultant
Item	Submission	Comments													
				JTC-XX-XX-DC-400-274	DRA063 DRAWER UNIT, under worktop, 6 drawer, cut-out to front for film envelopes, 550H 500W 450D		21/01/2013	0		BMCE-TRANSMIT-013562 25/01/2013	08/02/2013	08/02/2013	B	BMCE-TRANSMIT-013891 12/02/2013	
		Omitted On PMI		JTC-XX-XX-DC-400-275	FRA023 FRAME, suspended, mesh infill, 10D tilt top fix, wall mounted, 655H 685W		12/02/2013	0		BMCE-TRANSMIT-014818 27/03/2013	17/04/2013	19/06/2013	C	BMCE-TRANSMIT-016439 17/06/2013	
		Rev 01 Signed off By Peter Moir NHSGG&C-GC-001077		JTC-XX-XX-DC-400-276	FRA024 FRAME, suspended, mesh infill, ceiling mounted, 700W 1900D		12/02/2013	0		BMCE-TRANSMIT-014818 27/03/2013	17/04/2013	19/06/2013	C	BMCE-TRANSMIT-016439 17/06/2013	
				JTC-XX-XX-DC-400-282	LWB073 WORKBENCH laboratory, C-frame, freestanding, 920H 1300W 750D		21/01/2013	0		BMCE-TRANSMIT-013562 25/01/2013	08/02/2013	08/02/2013	B	BMCE-TRANSMIT-013891 12/02/2013	
				JTC-XX-XX-DC-400-283	LWB075 WORKBENCH laboratory, C-frame, freestanding, 920H 1500W 750D		21/01/2013	0		BMCE-TRANSMIT-013562 25/01/2013	08/02/2013	08/02/2013	B	BMCE-TRANSMIT-013891 12/02/2013	
				JTC-XX-XX-DC-400-284	LWB078 WORKBENCH laboratory, C-frame, freestanding, 920H 1800W 750D		21/01/2013	0		BMCE-TRANSMIT-013562 25/01/2013	08/02/2013	08/02/2013	B	BMCE-TRANSMIT-013891 12/02/2013	
				JTC-XX-XX-DC-400-285	LWB1000 WORKBENCH laboratory, length as drawn, 920H x 750D		21/01/2013	0		BMCE-TRANSMIT-013562 25/01/2013	08/02/2013	08/02/2013	B	BMCE-TRANSMIT-013891 12/02/2013	
				JTC-XX-XX-DC-400-286	LWS081L WORKBENCH laboratory with inset sink, left (sink size 150x500x400), 920H 2100W 750D		21/01/2013	0		BMCE-TRANSMIT-013562 25/01/2013	08/02/2013	08/02/2013	B	BMCE-TRANSMIT-013891 12/02/2013	
				JTC-XX-XX-DC-400-287	LWS1000 WORKBENCH laboratory with polypropylene inset sink, left (sink size 400x400x300), 920H 2100W 750D		21/01/2013	0		BMCE-TRANSMIT-013562 25/01/2013	08/02/2013	08/02/2013	B	BMCE-TRANSMIT-013891 12/02/2013	
		Removed By PMI 208 & 211		JTC-XX-XX-DC-400-289	MSC1000-Pharmacy Cabinet, 400mm facing, Gel Warne4r, O/A height 1200		26/03/2013	1		BMCE-TRANSMIT-016140 05/06/2013	26/06/2013	16/01/2014	D	BMCE-TRANSMIT-019126 21/01/2014	
		Moved To Group 3 Equipment. RDD Not Required.		JTC-XX-XX-DC-400-291	MSC1015 Catheter Cupboard, formed pkastic liners, catheter hanging shelf, catheter rail, 1 shelf		26/03/2013	0		BMCE-TRANSMIT-016140 05/06/2013	26/06/2013		C	BMCE-TRANSMIT-017150 06/08/2013	
		Moved To Group 3 Equipment. RDD Not Required.		JTC-XX-XX-DC-400-292	MSC1017 Catheter Cupboard, formed pkastic liners, catheter hanging shelf, catheter rail, 1 shelf		26/03/2013	0		BMCE-TRANSMIT-016140 05/06/2013	26/06/2013		C	BMCE-TRANSMIT-017150 06/08/2013	
				JTC-XX-XX-DC-400-298	PEG001 PEGS, equipment, small, 2, wall mounted		21/01/2013	0		BMCE-TRANSMIT-013562 25/01/2013	08/02/2013	08/02/2013	A	BMCE-TRANSMIT-013891 12/02/2013	
				JTC-XX-XX-DC-400-299	PEG002 PEGS, equipment, medium, 2, wide spacing, wall mounted		21/01/2013	0		BMCE-TRANSMIT-013562 25/01/2013	08/02/2013	08/02/2013	A	BMCE-TRANSMIT-013891 12/02/2013	
				JTC-XX-XX-DC-400-301	PEG005 PEGS, equipment, 3 (500mm spacing), wall mounted		21/01/2013	0		BMCE-TRANSMIT-013562 25/01/2013	08/02/2013	08/02/2013	A	BMCE-TRANSMIT-013891 12/02/2013	
				JTC-XX-XX-DC-400-303	RAC1012 - Mop rack		20/11/2013	0		BMCE-TRANSMIT-013474 22/01/2013	12/02/2013		A	BMCE-TRANSMIT-014819 27/03/2013	
				JTC-XX-XX-DC-400-304	RAC1019 RACK, grid, wall-mounted, 500mm wide		21/01/2013	0		BMCE-TRANSMIT-013562 25/01/2013	12/02/2013	08/02/2013	A	BMCE-TRANSMIT-013891 12/02/2013	
				JTC-XX-XX-DC-400-305	RAC1020 RACK, grid, wall-mounted		21/01/2013	0		BMCE-TRANSMIT-013562 25/01/2013	12/02/2013	08/02/2013	A	BMCE-TRANSMIT-013891 12/02/2013	
				JTC-XX-XX-DC-400-307	RAC1032 RACK, spinal board		12/02/2013	0		BMCE-TRANSMIT-014818 27/03/2013	17/04/2013	19/06/2013	A	BMCE-TRANSMIT-016439 17/06/2013	
				JTC-XX-XX-DC-400-309	RAC1041 RACK shoe, double, surgical clogs & shoes with hooks (holds 6-8 pairs), 200H 600W 305D		12/02/2013	0		BMCE-TRANSMIT-014818 27/03/2013	17/04/2013	19/06/2013	A	BMCE-TRANSMIT-016439 17/06/2013	
				JTC-XX-XX-DC-400-310	RAC1041 - RACK, for horizontal storage, gas cylinders.		20/11/2013	0		BMCE-TRANSMIT-013474 22/01/2013	12/02/2013		A	BMCE-TRANSMIT-014819 27/03/2013	
				JTC-XX-XX-DC-400-311	RAC1043 - RACK, for vertical storage, gas cylinders.		20/11/2013	0		BMCE-TRANSMIT-013474 22/01/2013	12/02/2013		A	BMCE-TRANSMIT-014819 27/03/2013	
		Returned To JTC For Resubmission		JTC-XX-XX-DC-400-312	RAC1055 - RACK, 6 Shelves, Wall Mounted		25/11/2013	1		BMCE-TRANSMIT-018806 12/12/2013	08/01/2014	09/01/2013	C	BMCE-TRANSMIT-019008 10/01/2014	
		Specification & Location Clarification Requested By NA		JTC-XX-XX-DC-400-313	RAC420 - RACK, metal, 1 bay, 4 shelves, 2000H 914W 600D		20/11/2013	0		BMCE-TRANSMIT-013474 22/01/2013	12/02/2013		C	BMCE-TRANSMIT-014819 27/03/2013	
		Specification & Location Clarification Requested By NA		JTC-XX-XX-DC-400-314	RAC422 - RACK, metal, 2 bays, 4 shelves, 2000H 1800W 600D		20/11/2013	0		BMCE-TRANSMIT-013474 22/01/2013	12/02/2013		C	BMCE-TRANSMIT-014819 27/03/2013	
				JTC-XX-XX-DC-400-323	SCR043 - SCREEN, projection, ceiling mounted, 1800H 1800W		20/11/2013	0		BMCE-TRANSMIT-013474 22/01/2013	12/02/2013		A	BMCE-TRANSMIT-014819 27/03/2013	

[illegible]

[illegible]

26 BCL-AC-XX-SH-001			1st Submission												
			Action By	Drawing Number	Drawing Title	Date Required from Consultant	Date Submitted by Consultant	Document Revision	Planned Date to be Submitted to Board	Date Submitted to Board	Date Response Required from Board (+3 Weeks)	Date Returned from Board	Board Status	Date returned to Consultant	Date Required from Consultant
Item	Submission	Comments													
26	Bedhead Layouts	Colour, Service Layout, Maintenance, Lifecycle, H & S													
	Refer to Sections 3, 4 and 5	Note: NA to develope deliverable schedule	NA	NA-xx-xx-AS-400-100	Schedule of Equipment Unions - Bedheads 1	05/11/2011	13/05/2012	6		BMCE-TRANSMIT-008425 18/04/12	09/05/2012	17/07/2012	B	BMCE-TRANSMIT-009995 26/07/2012	
			NA	NA-xx-xx-AS-400-101	Schedule of Equipment Unions - Bedheads 2	05/11/2011	13/05/2012	6		BMCE-TRANSMIT-008425 18/04/12	09/05/2012	17/07/2012	B	BMCE-TRANSMIT-009995 26/07/2012	
			NA	NA-xx-xx-AS-400-102	Schedule of Equipment Unions - Bedheads 3	05/11/2011	13/05/2012	6		BMCE-TRANSMIT-008425 18/04/12	09/05/2012	17/07/2012	B	BMCE-TRANSMIT-009995 26/07/2012	

26BCL-AC-XX-SH-001			1st Submission												
			Action By	Drawing Number	Drawing Title	Date Required from Consultant	Date Submitted by Consultant	Document Revision	Planned Date to be Submitted to Board	Date Submitted to Board	Date Response Required from Board (+3 Weeks)	Date Returned from Board	Board Status	Date returned to Consultant	Date Required from Consultant
Item	Submission	Comments													
			NA	NA-xx-xx-AS-400-103	Schedule of Equipment Unions - Bedheads 4	05/11/2011	13/05/2012	6		BMCE-TRANSMIT-008425 18/04/12	09/05/2012	17/07/2012	B	BMCE-TRANSMIT-009995 26/07/2012	
			NA	NA-xx-xx-AS-400-104	Schedule of Equipment Unions - Bedheads 5	05/11/2011	13/05/2012	7		BMCE-TRANSMIT-008425 18/04/12	09/05/2012	17/07/2012	B	BMCE-TRANSMIT-009995 26/07/2012	
			NA	NA-xx-xx-AS-400-105	Schedule of Equipment Unions - Bedheads 6	05/11/2011	13/05/2012	7		BMCE-TRANSMIT-008425 18/04/12	09/05/2012	17/07/2012	B	BMCE-TRANSMIT-009995 26/07/2012	
			NA	NA-xx-xx-AS-400-106	Schedule of Equipment Unions - PC/Power/Data	05/11/2011	13/05/2012	6		BMCE-TRANSMIT-008425 18/04/12	09/05/2012	17/07/2012	A	BMCE-TRANSMIT-009995 26/07/2012	
			NA	NA-xx-xx-AS-400-107	Schedule of Equipment Unions - Baths	05/11/2011	13/05/2012	6		BMCE-TRANSMIT-008425 18/04/12	09/05/2012	17/07/2012	A	BMCE-TRANSMIT-009995 26/07/2012	
			NA	NA-xx-xx-AS-400-108	Schedule of Equipment Unions - Showers	05/11/2011	13/05/2012	6		BMCE-TRANSMIT-008425 18/04/12	09/05/2012	17/07/2012	A	BMCE-TRANSMIT-009995 26/07/2012	
			NA	NA-xx-xx-AS-400-109	Schedule of Equipment Unions - Basins 1	05/11/2011	13/05/2012	8		BMCE-TRANSMIT-008425 18/04/12	09/05/2012	17/07/2012	B	BMCE-TRANSMIT-009995 26/07/2012	
			NA	NA-xx-xx-AS-400-110	Schedule of Equipment Unions - Basins 2	05/11/2011	13/05/2012	7		BMCE-TRANSMIT-008425 18/04/12	09/05/2012	17/07/2012	B	BMCE-TRANSMIT-009995 26/07/2012	
			NA	NA-xx-xx-AS-400-111	Schedule of Equipment Unions - Sinks/DSU 1	05/11/2011	13/05/2012	6		BMCE-TRANSMIT-008425 18/04/12	09/05/2012	17/07/2012	B	BMCE-TRANSMIT-009995 26/07/2012	
			NA	NA-xx-xx-AS-400-112	Schedule of Equipment Unions - Sinks/DSU 2	05/11/2011	13/05/2012	6		BMCE-TRANSMIT-008425 18/04/12	09/05/2012	17/07/2012	B	BMCE-TRANSMIT-009995 26/07/2012	
			NA	NA-xx-xx-AS-400-113	Schedule of Equipment Unions - Sinks/DSU 3	05/11/2011	13/05/2012	7		BMCE-TRANSMIT-008425 18/04/12	09/05/2012	17/07/2012	B	BMCE-TRANSMIT-009995 26/07/2012	
			NA	NA-xx-xx-AS-400-114	Schedule of Equipment Unions - Scrubs	05/11/2011	13/05/2012	7		BMCE-TRANSMIT-008425 18/04/12	09/05/2012	17/07/2012	B	BMCE-TRANSMIT-009995 26/07/2012	
			NA	NA-xx-xx-AS-400-115	Schedule of Equipment Unions - WC's	05/11/2011	13/05/2012	8		BMCE-TRANSMIT-008425 18/04/12	09/05/2012	17/07/2012	B	BMCE-TRANSMIT-009995 26/07/2012	
			NA	NA-xx-xx-AS-400-116	Schedule of Equipment Unions - Bedheads 7	05/11/2011	13/05/2012	7		BMCE-TRANSMIT-008425 18/04/12	09/05/2012	17/07/2012	B	BMCE-TRANSMIT-009995 26/07/2012	

27 BCL-AC-XX-SH-001

Art Location Detailed Plans (1:50)	These will be co-ordinated on the 1:50 fixtures & fittings plans and Room Elevations
	NOTE: Issue dates to be co-ordinated with the Master Programme

29	BCL-AC-XX-SH-001																	
								1st Submission										
				Action By	Drawing Number	Drawing Title		Date Required from Consultant	Date Submitted by Consultant	Document Revision	Planned Date to be Submitted to Board	Date Submitted to Board	Date Response Required from Board (+3 Weeks)	Date Returned from Board	Board Status	Date returned to Consu tant	Date Required from Consultant	Dat by
Item	Submission		Comments															
29	External & Internal Signage		Colour, Maintenance, Lifecycle, H & S															
	Specifications	GLASGOW SIGNS/SIGN BRAND INFORMATION TO BE REVIEWED AND AGREED WITH THE BOARD IF REQUIRED		NA/GIL	NA-SP-N15	Internal fire and safety signage systems												
				N/A	NA-SZ-SCH-410-200	Signage Location Schedule - Exemplar Departments			09/01/2013	1		BMCE-TRANSMIT-013274 11/01/2013	01/02/2013	11/04/2013	C	BMCE-TRANSMIT-015292 23/04/2013		
				N/A	NA-SZ-SCH-410-201	Signage Design Schedule			09/01/2013	1		BMCE-TRANSMIT-013274 11/01/2013	01/02/2013	11/04/2013	B	BMCE-TRANSMIT-015292 23/04/2013		
	Internal Signage Key Schedule	NOT REQUIRED. INCLUDED IN GLASGOW SIGNS/SIGN BRAND PACKAGE		NA	NA-XX-XX-SH-410-300	Internal Signage Strategy Key												
		Circulation Routes		N/A	NA-XX-00-PL-252-030	Ground Floor Plan - Circulation Routes			09/01/2013	3		BMCE-TRANSMIT-013274 11/01/2013	01/02/2013	11/04/2013	B	BMCE-TRANSMIT-015292 23/04/2013		
				N/A	NA-XX-01-PL-252-030	First Floor Plan - Main Circulation Routes			09/01/2013	3		BMCE-TRANSMIT-013274 11/01/2013	01/02/2013	11/04/2013	B	BMCE-TRANSMIT-015292 23/04/2013		
				N/A	NA-XX-02-PL-252-030	Second Floor Plan - Main Circulation Routes			09/01/2013	3		BMCE-TRANSMIT-013274 11/01/2013	01/02/2013	11/04/2013	B	BMCE-TRANSMIT-015292 23/04/2013		
				N/A	NA-XX-03-PL-252-030	Third Floor Plan - Main Circulation Routes			09/01/2013	3		BMCE-TRANSMIT-013274 11/01/2013	01/02/2013	11/04/2013	B	BMCE-TRANSMIT-015292 23/04/2013		
				N/A	NA-XX-04-PL-252-030	Fourth Floor Plan - Main Circulation Routes			09/01/2013	3		BMCE-TRANSMIT-013274 11/01/2013	01/02/2013	11/04/2013	A	BMCE-TRANSMIT-015292 23/04/2013		
				N/A	NA-XX-05-PL-252-030	Fifth Floor Plan -Main Circulation Routes (Generic Ward)			09/01/2013	3		BMCE-TRANSMIT-013274 11/01/2013	01/02/2013	11/04/2013	A	BMCE-TRANSMIT-015292 23/04/2013		
				N/A	N/A-xx-00-PL-410-200	Ground Floor Plan Main Entrance Atrium Pharmacy FM Offices & Discharge Lounge Internal Signage Plan			09/01/2013	1		BMCE-TRANSMIT-013274 11/01/2013	01/02/2013	11/04/2013	B	BMCE-TRANSMIT-015292 23/04/2013		
				N/A	N/A-xx-00-PL-410-205	Ground Floor Plan - NSGH Emergency Department - Internal Signage Plan			09/01/2013	1		BMCE-TRANSMIT-013274 11/01/2013	01/02/2013	11/04/2013	B	BMCE-TRANSMIT-015292 23/04/2013		
				N/A	N/A-xx-00-PL-410-209	Ground Floor Plan NSGH OPD/Rehab & Therapies Internal Signage Plan			09/01/2013	1		BMCE-TRANSMIT-013274 11/01/2013	01/02/2013	11/04/2013	B	BMCE-TRANSMIT-015292 23/04/2013		
	Internal Signage Location Plans (1:200)	ALL LATEST WAYFINDING SIGNAGE DRAWINGS TO BE SUBMITTED BY GLASGOW SIGNS/SIGN BRAND		NA	NA-XX-00-PL-410-300	Ground Floor Plan - NSGH Entrance Reception and Atrium Space - Signage Strategy					2012 tbc							
		Aspect of review:		NA	NA-XX-00-PL-410-301	Ground Floor Plan - NCH Rehab - Signage Strategy					2012 tbc							
		Wayfinding		NA	NA-XX-00-PL-410-302	Ground Floor Plan - NCH Entrance and OPD - Signage Strategy					2012 tbc							

29 BCL-AC-XX-SH-001			1st Submission												Drawing Information	
Item	Submission	Comments	Action By	Drawing Number	Drawing Title	Date Required from Consultant	Date Submitted by Consultant	Document Revision	Planned Date to be Submitted to Board	Date Submitted to Board	Date Response Required from Board (+3 Weeks)	Date Returned from Board	Board Status	Date returned to Consultant	Date Required from Consultant	Date Submitted by Consultant
			NA	NA-XX-01-PL-410-302	First Floor Plan - NCH 23 Hour Unit - Signage Strategy				2012 tbc							
			NA	NA-XX-01-PL-410-303	First Floor Plan - NCH Critical Care (PICU) / Cardiology Ward / Support / MDU and Special Feeds - Signage Strategy				2012 tbc							
			NA	NA-XX-01-PL-410-304	First Floor Plan - NSGH CCU and Critical Care (1 of 2) - Signage Strategy				2012 tbc							
			NA	NA-XX-01-PL-410-305	First Floor Plan - NSGH Critical Care (2 of 2) - Signage Strategy				2012 tbc							
			NA	NA-XX-01-PL-410-306	First Floor Plan - NSGH Stroke Ward / MDU / Pre Assessment - Signage Strategy				2012 tbc							
			NA	NA-XX-01-PL-410-307	First Floor Plan - NSGH Radiology - Signage Strategy				2012 tbc							
			NA	NA-XX-01-PL-410-308	First Floor Plan - NSGH Nuclear Medicine - Signage Strategy				2012 tbc							
			NA	NA-XX-01-PL-410-309	First Floor Plan - NSGH OPD & Pre-op Assessment - Signage Strategy				2012 tbc							
			NA	NA-XX-02-PL-410-300	Second Floor Plan - NSGH Atrium - Signage Strategy				2012 tbc							
			NA	NA-XX-02-PL-410-301	Second Floor Plan - NSGH Dermatology Ward + Plant - Signage Strategy				2012 tbc							
			NA	NA-XX-02-PL-410-302	Second Floor Plan - NCH Schiehallion Ward / Day Case Unit / Theatres and Anaesthetic Service Offices - Signage Strategy				2012 tbc							
			NA	NA-XX-02-PL-410-303	Second Floor Plan - NCH Acute Receiving Ward - Signage Strategy				2012 tbc							
			NA	NA-XX-02-PL-410-304	Second Floor Plan - NSGH Endoscopy / Decontamination / Medical Physics / Stores - Signage Strategy				2012 tbc							
			NA	NA-XX-02-PL-410-305	Second Floor Plan - NSGH Theatres (1 of 2) + Plant - Signage Strategy				2012 tbc							
			NA	NA-XX-02-PL-410-306	Second Floor Plan - NSGH Theatres (2 of 2) + Plant - Signage Strategy				2012 tbc							
			NA	NA-XX-02-PL-410-309	Second Floor Plan - NSGH Dermatology OPD / Renal Dialysis - Signage Strategy				2012 tbc							
			NA	NA-xx-03-PL-410-302	Third Floor Plan - NCH In-Patient Ward - Signage Strategy				2012 tbc							
			NA	NA-xx-03-PL-410-303	Third Floor Plan - NCH In-Patient Ward / Ward Support - Signage Strategy				2012 tbc							
			NA	NA-xx-04-PL-410-301	Fourth Floor Plan - Higher Acuity Renal Ward - Signage Strategy				2012 tbc							
			NA	NA-xx-04-PL-410-302	Fourth Floor Plan - NCH DCFP - Signage Strategy				2012 tbc							
			NA	NA-xx-04-PL-410-303	Fourth Floor Plan - Haemo-Oncology Ward - Signage Strategy				2012 tbc							
			NA	NA-xx-04-PL-410-304	Fourth Floor Plan - NSGH Generic Ward (1 of 2) - Signage Strategy				2012 tbc							

29		BCL-AC-XX-SH-001				1st Submission											
		Action By	Drawing Number	Drawing Title	Date Required from Consultant	Date Submitted by Consultant	Document Revision	Planned Date to be Submitted to Board	Date Submitted to Board	Date Response Required from Board (+3 Weeks)	Date Returned from Board	Board Status	Date returned to Consu tant	Date Required from Consultant	Dat by		
Item	Submission	Comments															
	External Signage Location Plans		GIL	tbc	tbc												
	Glasgow Signs			GS-XX-XX-DC-410-004	NSGH Wayfinding Strategy Summary Document		03/02/2014	B	BMCE-TRANSMIT-019821 04/02/2014	25/02/2014	24/02/2014	A	BMCE-TRANSMIT-019561 27/02/2014				
				GS-XX-XX-DC-410-006	NSGH Wayfinding Strategy Summary Document Appendix A		03/02/2014	A	BMCE-TRANSMIT-019821 04/02/2014	25/02/2014	24/02/2014	B	BMCE-TRANSMIT-019561 27/02/2014				
				GS-XX-XX-DC-410-007	NSGH Wayfinding Strategy Summary Document Appendix B		03/02/2014	A	BMCE-TRANSMIT-019821 04/02/2014	25/02/2014	24/02/2014	B	BMCE-TRANSMIT-019561 27/02/2014				
				GS-XX-XX-DC-410-008	NSGH Wayfinding Strategy Summary Document Appendix C		03/02/2014	A	BMCE-TRANSMIT-019821 04/02/2014	25/02/2014	24/02/2014	A	BMCE-TRANSMIT-019561 27/02/2014				
				GS-XX-XX-DC-410-009	NSGH Wayfinding Strategy Summary Document Appendix D		03/02/2014	A	BMCE-TRANSMIT-019821 04/02/2014	25/02/2014	24/02/2014	B	BMCE-TRANSMIT-019561 27/02/2014				
				GS-XX-XX-DC-410-010	NSGH Wayfinding Strategy Summary Document Appendix E		03/02/2014	A	BMCE-TRANSMIT-019821 04/02/2014	25/02/2014	24/02/2014	B	BMCE-TRANSMIT-019561 27/02/2014				
				GS-XX-XX-DC-410-011	NSGH Wayfinding Strategy Summary Document Appendix F		03/02/2014	A	BMCE-TRANSMIT-019821 04/02/2014	25/02/2014	24/02/2014	A	BMCE-TRANSMIT-019561 27/02/2014				
				GS-XX-XX-DC-410-012	NSGH Wayfinding Strategy Summary Document Appendix G		03/02/2014	A	BMCE-TRANSMIT-019821 04/02/2014	25/02/2014	24/02/2014	A	BMCE-TRANSMIT-019561 27/02/2014				
				GS-XX-XX-DC-410-013	NSGH Wayfinding Strategy Summary Document Appendix I		03/02/2014	A	BMCE-TRANSMIT-019821 04/02/2014	25/02/2014	24/02/2014	A	BMCE-TRANSMIT-019561 27/02/2014				
				GS-XX-XX-DC-410-014	NSGH Wayfinding Strategy Summary Document Appendix J		03/02/2014	A	BMCE-TRANSMIT-019821 04/02/2014	25/02/2014	24/02/2014	A	BMCE-TRANSMIT-019561 27/02/2014				
				GS-SZ-SL-SC-410-001	Wayfinding Sign Design Guide Within Departments		05/03/2014	0	BMCE-TRANSMIT-019690 14/03/2014	07/04/2014	14.04.2014	B	BMCE-TRANSMIT-020026 30.04.2014				
				GS-SZ-SL-PL-410-011	Departmental Wayfinding Strategy Production Zone 1		05/03/2014	0	BMCE-TRANSMIT-019690 14/03/2014	04/04/2014	14.04.2015	B	BMCE-TRANSMIT-020026 30.04.2015				
				GS-SZ-SL-SH-410-011	Departmental Wayfinding Signage Shedule Production Group 1		05/03/2014	0	BMCE-TRANSMIT-019690 14/03/2014	04/04/2014	14.04.2016	B	BMCE-TRANSMIT-020026 30.04.2016				
				GS-SZ-SL-SH-410-012	FM & Door Signage Schedule Production Group 1		05/03/2014	0	BMCE-TRANSMIT-019690 14/03/2014	04/04/2014	14.04.2017	B	BMCE-TRANSMIT-020026 30.04.2017				
				GS-SZ-SL-PL-410-021	Departmental Wayfinding Strategy Production Zone 2		18/03/2014	0	BMCE-TRANSMIT-019731 19/03/2014	09/04/2014							
				GS-SZ-SL-SH-410-021	Departmental Wayfinding Signage Shedule Production Group 2		18/03/2014	0	BMCE-TRANSMIT-019731 19/03/2014	09/04/2014							
				GS-SZ-SL-SH-410-022	FM & Door Signage Schedule Production Group 2		18/03/2014	0	BMCE-TRANSMIT-019731 19/03/2014	09/04/2014							
				GS-SZ-SL-PL-410-031	Departmental Wayfinding Strategy Production Zone 3		18/03/2014	0	BMCE-TRANSMIT-019280	17/04/2014							

RDD MASTER SCHEDULE - NHS Greater Glasgow & Clyde / New South Glasgow Hospitals (NSGH) Project - Adults & Childrens Hospital

Drawing Information

[illegible]

Drawing Information

31

BCL-AC-XX-SH-001

1st Submission

2nd Submission

			Action By	Zone	Drawing Number	Drawing Title	Date Required from Consultant	Date Submitted by Consultant	Document Revision	Planned Date to be Submitted to Board	Date Submitted to Board	BMCE Transmittal No	Date Response Required from Board	Date Returned from Board	Board Status	Date returned to Consultant	Date Required from Consultant	Date Submitted by Consultant
Item	Submission	Comments																
			ZBP	A	ZBP-ZA-02-PL-571-021	Security Layout Second	18/11/11		A	21/12/11	20/12/11	BMCE-TRANSMIT-007154	10/01/12	11/05/2012	A	24/05/12 BMCE-TRANSMIT-009652		
			ZBP	A	ZBP-ZA-03-PL-571-031	Security Layout Third	18/11/11		A	21/12/11	20/12/11	BMCE-TRANSMIT-007154	10/01/12	11/05/2012	A	24/05/12 BMCE-TRANSMIT-009652		
		Removed By ZBP	ZBP	A	ZBP-ZA-04-PL-571-041	Security Layout Fourth				-			-					
	Public Health Services Drawings	This was issued for information on BMCE-TRANSMIT-018798 12/12/13	ZBP	A	ZBP-ZA-00-PL-500-001	Water Services Layout Ground	18/11/11		A	21/12/11	20/12/11	BMCE-TRANSMIT-007152	10/01/12	02/02/12	B	14/02/12 BMCE-TRANSMIT-007596		
		This was issued for information on BMCE-TRANSMIT-018798 12/12/13	ZBP	A	ZBP-ZA-01-PL-500-011	Water & Gas Services Layout First	18/11/11		A	21/12/11	20/12/11	BMCE-TRANSMIT-007152	10/01/12	02/02/12	B	14/02/12 BMCE-TRANSMIT-007596		
		This was issued for information on BMCE-TRANSMIT-018798 12/12/13	ZBP	A	ZBP-ZA-02-PL-500-021	Water & Gas Services Layout Second	18/11/11		A	21/12/11	20/12/11	BMCE-TRANSMIT-007152	10/01/12	02/02/12	B	14/02/12 BMCE-TRANSMIT-007596		
		This was issued for information on BMCE-TRANSMIT-018798 12/12/13	ZBP	A	ZBP-ZA-03-PL-500-031	Water & Gas Services Layout Third	18/11/11		A	21/12/11	20/12/11	BMCE-TRANSMIT-007152	10/01/12	02/02/12	B	14/02/12 BMCE-TRANSMIT-007596		
		This was issued for information on BMCE-TRANSMIT-018798 12/12/13	ZBP	A	ZBP-ZA-00-PL-581-001	Sanitation and Rainwater Layout Ground	18/11/11		B	21/12/11	20/12/11	BMCE-TRANSMIT-007152	10/01/12	02/02/12	B	14/02/12 BMCE-TRANSMIT-007596		
		This was issued for information on BMCE-TRANSMIT-018798 12/12/13	ZBP	A	ZBP-ZA-01-PL-581-011	Sanitation and Rainwater Layout First	18/11/11		B	21/12/11	20/12/11	BMCE-TRANSMIT-007152	10/01/12	02/02/12	B	14/02/12 BMCE-TRANSMIT-007596		
		This was issued for information on BMCE-TRANSMIT-018798 12/12/13	ZBP	A	ZBP-ZA-02-PL-581-021	Sanitation and Rainwater Layout Second	18/11/11		B	21/12/11	20/12/11	BMCE-TRANSMIT-007152	10/01/12	02/02/12	B	14/02/12 BMCE-TRANSMIT-007596		
		This was issued for information on BMCE-TRANSMIT-018798 12/12/13	ZBP	A	ZBP-ZA-03-PL-581-031	Sanitation and Rainwater Layout Third	18/11/11		B	21/12/11	20/12/11	B,CE-TRANSMIT-007152	10/01/12	02/02/12	B	14/02/12 BMCE-TRANSMIT-007596		
		Removed By ZBP	ZBP	A	ZBP-ZA-04-PL-581-041	Sanitation and Rainwater Layout Fourth				-			-					
			ZBP	A	ZBP-ZA-05-PL-581-051	Sanitation and Rainwater Layout Fifth				-			-					
	Riser Drawings	This was issued for information on BMCE-TRANSMIT-018798 12/12/13	ZBP	A	ZBP-ZA-XX-PL-520-660	Riser M16	18/11/11		A	21/12/11	20/12/11	BMCE-TRANSMIT-007153	10/01/12	14/02/12	B	14/02/12 BMCE-TRANSMIT-007607		
		This was issued for information on BMCE-TRANSMIT-018798 12/12/13	ZBP	A	ZBP-ZA-XX-PL-520-661	Riser M38	18/11/11		A	21/12/11	20/12/11	BMCE-TRANSMIT-007153	10/01/12	14/02/12	B	14/02/12 BMCE-TRANSMIT-007607		
	Plantroom 41 Mechanical Services Drawings	Removed By ZBP	ZBP	A	ZBP-ZA-03-PL-512-151	Plantroom 41 Medical Gases	17/08/12			21/09/12			-					
		Removed By ZBP	ZBP	A	ZBP-ZA-03-PL-512-152	Plantroom 41 Medical Gases	17/08/12			21/09/12			-					
		This was issued for information on BMCE-TRANSMIT-018798 12/12/13	ZBP	A	ZBP-ZA-04-PL-523-151	Plantroom 41 Pipework	17/08/12			21/09/12	14/11/12	BMCE-TRANSMIT-012286 (BMCE-WTRAN-004573)	05/12/12	07/12/12	B	18/12/12 BMCE-TRANSMIT-012964		
		This was issued for information on BMCE-TRANSMIT-018798 12/12/13	ZBP	A	ZBP-ZA-04-PL-523-152	Plantroom 41 Pipework	17/08/12		C	21/09/12	14/11/12	BMCE-TRANSMIT-012286 (BMCE-WTRAN-004573)	05/12/12	07/12/12	B	18/12/12 BMCE-TRANSMIT-012964		
		This was issued for information on BMCE-TRANSMIT-018798 12/12/13	ZBP	A	ZBP-ZA-04-PL-524-151	Plantroom 41 Ventilation	17/08/12		A	21/09/12	19/11/12	BMCE-TRANSMIT-012345 (BMCE-WTRAN-004618)	10/12/12	03/12/12	B	07/12/12 BMCE-TRANSMIT-012824		
		This was issued for information on BMCE-TRANSMIT-018798 12/12/13	ZBP	A	ZBP-ZA-04-PL-524-152	Plantroom 41 Ventilation	17/08/12		A	21/09/12	19/11/12	BMCE-TRANSMIT-012345 (BMCE-WTRAN-004618)	10/12/12	03/12/12	B	07/12/12 BMCE-TRANSMIT-012824		
	Electrical Services Drawings		ZBP	A	ZBP-ZA-04-PL-532-151	Plantroom 41 LV Power	17/08/12		A	21/09/12	20/09/12	BMCE-TRANSMIT-011053 (BMCE-WTRAN-004013)	11/10/12	01/10/12	A	05/10/12 BMCE-TRANSMIT-011417		
		This was issued for information on BMCE-TRANSMIT-018797 12/12/13	ZBP	C	ZBP-SZ-04-SE-590-002	Plantroom 41 DCFP Level 04			A		28/01/13	BMCE-TRANSMIT-013572 (BMCE-WTRAN-005845)	18/02/13	30/01/13	B	04/02/13 BMCE-TRANSMIT-013714		
	Public Health Services Drawings		ZBP	A	ZBP-ZA-04-PL-500-151	Plantroom 41 Water Services	17/08/12			21/09/12			-					

Drawing Information

31 BCL-AC-XX-SH-001

1st Submission2nd Submission

			Action By	Zone	Drawing Number	Drawing Title	Date Required from Consultant	Date Submitted by Consultant	Document Revision	Planned Date to be Submitted to Board	Date Submitted to Board	BMCE Transmittal No	Date Response Required from Board	Date Returned from Board	Board Status	Date returned to Consultant	Date Required from Consultant	Date Submitted by Consultant
Item	Submission	Comments																
		This was issued for information on BMCE-TRANSMIT-018798 12/12/13	ZBP	A	ZBP-XX-XX-SC-524-872	Ventilation Schematic (PR41) - AHU 03	17/08/12		A	21/09/12	09/11/12	BMCE-TRANSMIT-012215 (BMCE-WTRAN-004545)	30/11/12	07/12/12	B	18/12/12 BMCE-TRANSMIT-012952		
		No longer in Use ZBP instruction	ZBP	A	ZBP-XX-XX-SC-524-873	Ventilation Schematic (PR41) - AHU 04	17/08/12			21/09/12			-					
			ZBP	A	ZBP-XX-XX-SC-524-874	Ventilation Schematic (PR41) - AHU 05	17/08/12		A	21/09/12	09/11/12	BMCE-TRANSMIT-012216 (BMCE-WTRAN-004546)	30/11/12	03/12/12	A	06/12/12 BMCE-TRANSMIT-012805		
			ZBP	A	ZBP-XX-XX-SC-524-875	Ventilation Schematic (PR41) - AHU 06	17/08/12		A	21/09/12	09/11/12	BMCE-TRANSMIT-012215 (BMCE-WTRAN-004545)	30/11/12	07/12/12	A	18/12/12 BMCE-TRANSMIT-012952		
			ZBP	A	ZBP-XX-XX-SC-524-876	Ventilation Schematic (PR41) - AHU 07	17/08/12		A	21/09/12	09/11/12	BMCE-TRANSMIT-012215 (BMCE-WTRAN-004545)	30/11/12	07/12/12	A	18/12/12 BMCE-TRANSMIT-012952		
		This was issued for information on BMCE-TRANSMIT-018798 12/12/13	ZBP	A	ZBP-XX-XX-SC-524-877	Ventilation Schematic (PR41) - AHU 08	17/08/12		A	21/09/12	09/11/12	BMCE-TRANSMIT-012215 (BMCE-WTRAN-004545)	30/11/12	07/12/12	B	18/12/12 BMCE-TRANSMIT-012952		
		Removed by XBP	ZBP	A	ZBP-XX-XX-SC-524-878	Ventilation Schematic (PR41) - AHU 09	17/08/12			21/09/12			-					
			ZBP	A	ZBP-XX-XX-SC-524-879	Ventilation Schematic (PR41) - AHU 10	17/08/12		A	21/09/12	09/11/12	BMCE-TRANSMIT-012216 (BMCE-WTRAN-004546)	30/11/12	03/12/12	A	06/12/12 BMCE-TRANSMIT-012805		
		This was issued for information on BMCE-TRANSMIT-018798 12/12/13	ZBP	A	ZBP-XX-XX-SC-524-880	Ventilation Schematic (PR41) - AHU 11	17/08/12		A	21/09/12	09/11/12	BMCE-TRANSMIT-012215 (BMCE-WTRAN-004545)	30/11/12	07/12/12	B	18/12/12 BMCE-TRANSMIT-012952		
		Removed by XBP	ZBP	A	ZBP-XX-XX-SC-524-881	Ventilation Schematic (PR41) - AHU 12	17/08/12			21/09/12			-					
		This was issued for information on BMCE-TRANSMIT-018798 12/12/13	ZBP	A	ZBP-XX-XX-SC-524-882	Ventilation Schematic (PR41) - AHU 14	17/08/12		A	21/09/12	09/11/12	BMCE-TRANSMIT-012215 (BMCE-WTRAN-004545)	30/11/12	07/12/12	B	18/12/12 BMCE-TRANSMIT-012952		
			ZBP	A	ZBP-XX-XX-SC-524-883	Ventilation Schematic (PR41) - AHU 17	17/08/12		A	21/09/12	09/11/12	BMCE-TRANSMIT-012215 (BMCE-WTRAN-004545)	30/11/12	07/12/12	A	18/12/12 BMCE-TRANSMIT-012952		
			ZBP	A	ZBP-XX-XX-SC-524-884	Ventilation Schematic (PR41) - AHU 20	17/08/12		A	21/09/12	09/11/12	BMCE-TRANSMIT-012215 (BMCE-WTRAN-004545)	30/11/12	07/12/12	A	18/12/12 BMCE-TRANSMIT-012952		
		This was issued for information on BMCE-TRANSMIT-018798 12/12/13	ZBP	A	ZBP-XX-XX-SC-524-885	Ventilation Schematic (PR41) - AHU 21	17/08/12		A	21/09/12	09/11/12	BMCE-TRANSMIT-012216 (BMCE-WTRAN-004546)	30/11/12	03/12/12	B	06/12/12 BMCE-TRANSMIT-012805		
		This was issued for information on BMCE-TRANSMIT-018798 12/12/13	ZBP	A	ZBP-XX-XX-SC-524-886	Ventilation Schematic (PR41) - AHU 22	17/08/12		A	21/09/12	09/11/12	BMCE-TRANSMIT-012216 (BMCE-WTRAN-004546)	30/11/12	03/12/12	B	06/12/12 BMCE-TRANSMIT-012805		
			ZBP	A	ZBP-XX-XX-SC-524-887	Ventilation Schematic (PR41) - AHU 24	17/08/12		A	21/09/12	09/11/12	BMCE-TRANSMIT-012215 (BMCE-WTRAN-004545)	30/11/12	07/12/12	A	18/12/12 BMCE-TRANSMIT-012952		
		This was issued for information on BMCE-TRANSMIT-018798 12/12/13	ZBP	A	ZBP-XX-XX-SC-524-888	Ventilation Schematic (PR41) - AHU 25	17/08/12		A	21/09/12	09/11/12	BMCE-TRANSMIT-012215 (BMCE-WTRAN-004545)	30/11/12	07/12/12	B	18/12/12 BMCE-TRANSMIT-012952		
			ZBP	A	ZBP-XX-XX-SC-524-889	Ventilation Schematic (PR41) - AHU 27	17/08/12		A	21/09/12	09/11/12	BMCE-TRANSMIT-012215 (BMCE-WTRAN-004545)	30/11/12	07/12/12	A	18/12/12 BMCE-TRANSMIT-012952		
		Removed by XBP	ZBP	A	ZBP-XX-XX-SC-524-890	Ventilation Schematic (PR41) - AHU 28	17/08/12			21/09/12			-					
			ZBP	A	ZBP-XX-XX-SC-524-891	Ventilation Schematic (PR41) - AHU 29	17/08/12		A	21/09/12	09/11/12	BMCE-TRANSMIT-012215 (BMCE-WTRAN-004545)	30/11/12	07/12/12	A	18/12/12 BMCE-TRANSMIT-012952		
		This was issued for information on BMCE-TRANSMIT-018798 12/12/13	ZBP	A	ZBP-XX-XX-SC-524-892	Ventilation Schematic (PR41) - AHU 30	17/08/12		A	21/09/12	09/11/12	BMCE-TRANSMIT-012216 (BMCE-WTRAN-004546)	30/11/12	03/12/12	B	06/12/12 BMCE-TRANSMIT-012805		
		No longer in Use ZBP instruction	ZBP	A	ZBP-XX-XX-SC-524-893	Ventilation Schematic (PR41) - AHU 31	17/08/12			21/09/12			-					
		No longer in Use ZBP instruction	ZBP	A	ZBP-XX-XX-SC-524-894	Ventilation Schematic (PR41) - AHU 32	17/08/12			21/09/12			-					
		No longer in Use ZBP instruction	ZBP	A	ZBP-XX-XX-SC-524-895	Ventilation Schematic (PR41) - AHU 33	17/08/12			21/09/12			-					
		No longer in Use ZBP instruction	ZBP	A	ZBP-XX-XX-SC-524-896	Ventilation Schematic (PR41) - AHU 34	17/08/12			21/09/12			-					
		No longer in Use ZBP instruction	ZBP	A	ZBP-XX-XX-SC-524-897	Ventilation Schematic (PR41) - AHU 37	17/08/12			21/09/12			-					
		No longer in Use ZBP instruction	ZBP	A	ZBP-XX-XX-SC-524-898	Ventilation Schematic (PR41) - AHU 38	17/08/12			21/09/12			-					
		No longer in Use ZBP instruction	ZBP	A	ZBP-XX-XX-SC-524-899	Ventilation Schematic (PR41) - AHU 39	17/08/12			21/09/12			-					
			ZBP	A	ZBP-XX-XX-SC-524-900	Ventilation Schematic (PR41) - AHU 40	17/08/12			21/09/12			-					
			ZBP	A	ZBP-XX-XX-SC-524-901	Ventilation Schematic (PR41) - AHU 41	17/08/12		A	21/09/12	09/11/12	BMCE-TRANSMIT-012216 (BMCE-WTRAN-004546)	30/11/12	03/12/12	A	06/12/12 BMCE-TRANSMIT-012805		
			ZBP	A	ZBP-XX-XX-SC-524-902	Ventilation Schematic (PR41) - AHU 45	17/08/12		A	21/09/12	09/11/12	BMCE-TRANSMIT-012216 (BMCE-WTRAN-004546)	30/11/12	03/12/12	A	06/12/12 BMCE-TRANSMIT-		

Drawing Information

31 BCL-AC-XX-SH-001

			Action By	Zone	Drawing Number	Drawing Title	Date Required from Consultant	Date Submitted by Consultant	Document Revision	Planned Date to be Submitted to Board	Date Submitted to Board	BMCE Transmittal No	Date Response Required from Board	Date Returned from Board	Board Status	Date returned to Consultant	Date Required from Consultant	Date Submitted by Consultant
Item	Submission	Comments																
		This was issued for information on BMCE-TRANSMIT-018798 12/12/13	ZBP	A	ZBP-XX-XX-SC-525-551	Secondary Ch lled Water Schematic Plantroom 41	24/08/12			21/09/12	09/11/12	BMCE-TRANSMIT-012216 (BMCE-WTRAN-04546)	30/11/12	03/12/12	B	06/12/12 BMCE-TRANSMIT-012805		
			ZBP	A	ZBP-ZA-04-SE-590-001	Sections Plantroom 41			A	18/10/12	19/10/12	BMCE-TRANSMIT-011716 (BMCE-WTRAN-004265)	09/11/12	06/11/12	A	08/11/12 BMCE-TRANSMIT-012180		
			ZBP	A	ZBP-XX-XX-SC-525-552	Secondary Chilled Water Distribution Schematic Plantroom 41	24/08/12		A	21/09/12	09/11/12	BMCE-TRANSMIT-012189 (BMCE-WTRAN-004530)	30/11/12	07/12/12	A	18/12/12 BMCE-TRANSMIT-012968		
Electrical Services Schematics		Issued for information on BMCE-TRANSMIT-019793 27/03/14	ZBP	A	ZBP-XX-XX-SC-532-011	Low Voltage Schematic - Substation 1A	17/08/12		A	21/09/12	06/08/12	BMCE-TRANSMIT-010033 (BMCE-WTRAN-003609)	27/08/12		B	03/09/12 BMCE-TRANSMIT-010675		
			ZBP	A	ZBP-XX-XX-SC-532-012	Low Voltage Schematic - Substation 1B	17/08/12		A	21/09/12	06/08/12	BMCE-TRANSMIT-010033 (BMCE-WTRAN-003609)	27/08/12		B	03/09/12 BMCE-TRANSMIT-010675		
Public Health Services Schematics		This was issued for information on BMCE-TRANSMIT-018798 12/12/1	ZBP	A	ZBP-XX-XX-SC-500-041	Domestic Water Services Schematic Plantroom 41	17/08/12			21/09/12	10/09/12	BMCE-TRANSMIT-010868 (BMCE-WTRAN-003928)	01/10/12	17/09/12	B	21/09/12 BMCE-TRANSMIT-011098		
LIGHTING		This was issued for information on BMCE-TRANSMIT-018663 19/12/13	MER	A	ME-ZA-00-PL-541-516	Ground Floor Plan NCH - Child Protection Suite Lighting Layout	18/11/11	16/09/11	A	21/12/11	20/12/11	BMCE-TRANSMIT-007164	10/01/12	14/02/12	B	14/02/12 BMCE-TRANSMIT-007634		
			MER	A	ME-ZA-00-PL-541-517	Ground Floor Plan NCH - Observation Ward Lighting Layout	18/11/11		A	21/12/11	20/12/11	BMCE-TRANSMIT-007164	10/01/12	15/02/12	A	14/02/12 BMCE-TRANSMIT-007634		
		This was issued for information on BMCE-TRANSMIT-018663 19/12/13	MER	A	ME-ZA-00-PL-541-518	Ground Floor Plan NCH - Observation Ward Lighting Layout	18/11/11		A	21/12/11	20/12/11	BMCE-TRANSMIT-007164	10/01/12	16/02/12	B	14/02/12 BMCE-TRANSMIT-007634		
			MER	A	ME-ZA-00-PL-541-541	Ground Floor Plan NCH - Sanctuary Lighting Layout	18/11/11		A	21/12/11	20/12/11	BMCE-TRANSMIT-007164	10/01/12	17/02/12	A	14/02/12 BMCE-TRANSMIT-007634		
			MER	A	ME-ZA-01-PL-541-517	First Floor Plan NCH - Critical Care Lighting Layout	18/11/11		A	21/12/11	20/12/11	BMCE-TRANSMIT-007164	10/01/12	18/02/12	C	14/02/12 BMCE-TRANSMIT-007634		
		This was issued for information on BMCE-TRANSMIT-018663 19/12/13	MER	A	ME-ZA-01-PL-541-518	First Floor Plan NCH - Critical Care Lighting Layout	18/11/11		A	21/12/11	20/12/11	BMCE-TRANSMIT-007164	10/01/12	19/02/12	B	14/02/12 BMCE-TRANSMIT-007634		
		This was issued for information on BMCE-TRANSMIT-018730 19/12/13	MER	A	ME-SZ-01-PL-541-519	First Floor NCH Critical Care (PICU) Lighting Layout Zone A/B	18/11/11		A		06/03/12	BMCE-TRANSMIT-007981	27/03/12	27/03/12	B			
			MER	A	ME-ZA-02-PL-541-513	Second Floor Plan NCH ARU Lighting Layout	18/11/11		A	21/12/11	20/12/11	BMCE-TRANSMIT-007164	10/01/12	20/02/12	A	14/02/12 BMCE-TRANSMIT-007634		
		This was issued for information on BMCE-TRANSMIT-018663 19/12/13	MER	A	ME-ZA-02-PL-541-514	Second Floor Plan NCH ARU Lighting Layout	18/11/11		A	21/12/11	20/12/11	BMCE-TRANSMIT-007164	10/01/12	21/02/12	B	14/02/12 BMCE-TRANSMIT-007634		
		This was issued for information on BMCE-TRANSMIT-018667 03/12/13	MER	A	ME-SZ-02-PL-541-515	Second Floor Plan. NSGH/NCH Aspetic Suite Lighting Layout Zone A/B	18/11/11		A		06/03/12	BMCE-TRANSMIT-007981	27/03/12	27/03/12	B			
			MER	A	ME-ZA-03-PL-541-511	Third Floor Plan NCH Inpatient Wards Lighting Layout	18/11/11		A	21/12/11	20/12/11	BMCE-TRANSMIT-007164	10/01/12	22/02/12	A	14/02/12 BMCE-TRANSMIT-007634		
			MER	A	ME-ZA-03-PL-541-512	Third Floor Plan NCH Inpatient Ward Lighting Layout	18/11/11		A	21/12/11	20/12/11	BMCE-TRANSMIT-007164	10/01/12	23/02/12	A	14/02/12 BMCE-TRANSMIT-007634		
		This was issued for information on BMCE-TRANSMIT-018663 19/12/13	MER	A	ME-ZA-03-PL-541-513	Third Floor Plan NCH Inpatient Ward & Renal Services Lighting Layout	18/11/11		A	21/12/11	20/12/11	BMCE-TRANSMIT-007164	10/01/12	24/02/12	B	14/02/12 BMCE-TRANSMIT-007634		
		REMOVED BY MERCURY - WRONG DRAWING NUMBER	MER	A	ME-XX-XX-SP-541-100	Lighting Calculations - Zone A	Error in Drawing Number			-			-					
		This was issued for information on BMCE-TRANSMIT-018730 19/12/13	MER	A	ME-SZ-01-PL-541-516	First Floor Plan NCH Critical Care (PICU) Lighting Layout	18/11/11			21/12/11	20/12/11	BMCE-TRANSMIT-007164	10/01/12	14/02/12	B	14/02/12 BMCE-TRANSMIT-007634		
		This was issued for information on BMCE-TRANSMIT-018730 19/12/13	MER	A	ME-SZ-03-PL-541-510	Third Floor Layout NCH Inpatient Wards & Ward Support Lighting Layout	18/11/11			21/12/11	20/12/11	BMCE-TRANSMIT-007164	10/01/12	14/02/12	B	14/02/12 BMCE-TRANSMIT-007634		
		This was issued for information on BMCE-TRANSMIT-018891 18.12.13	MER	A	ME-SZ-04-PL-541-101	Fourth Floor Plan - Plantroom 41 Lighting Layout Zone A/B			A	10/09/12	10/09/12	BMCE-TRANSMIT-010869 (BMCE-WTRAN-003929)	01/10/12	18/09/12	B	01/10/12 BMCE-TRANSMIT-011253		
		This was issued for information on BMCE-TRANSMIT-018891 18.12.13	MER	A	ME-SZ-04-PL-541-102	Fourth Floor Plan - Plantroom 41 Lighting Layout Zone A/B			A	10/09/12	10/09/12	BMCE-TRANSMIT-010869 (BMCE-WTRAN-003929)	01/10/12	18/09/12	B	01/10/12 BMCE-TRANSMIT-011253		

			Action By		Zone	Drawing Number	Drawing Title	Date Required from Consultant	Date Submitted by Consultant	Document Revision	Planned Date to be Submitted to Board	Date Submitted to Board	BMCE Transmittal No	Date Response Required from Board	Date Returned from Board	Board Status	Date returned to Consultant	Date Required from Consultant	Date Submitted by Consultant
Item	Submission	Comments																	
ELV-SYSTEMS-HIGH-LEVEL		Removed By Mercury - NOT REQUIRED FOR RDO (SMALL POWER SHOWN ON NA 400 SERIES DRAWINGS)	MER	A	ME-2A-00-PL-532-516	Ground Floor Plan NCH - Child Play Area - High Level Layout	18/11/11				21/12/11			-					
		Removed By Mercury - NOT REQUIRED FOR RDO (SMALL POWER SHOWN ON NA 400 SERIES DRAWINGS)	MER	A	ME-2A-00-PL-532-517	Ground Floor Plan NCH - Observation Ward High Level Layout	18/11/11				21/12/11			-					
		Removed By Mercury - NOT REQUIRED FOR RDO (SMALL POWER SHOWN ON NA 400 SERIES DRAWINGS)	MER	A	ME-2A-00-PL-532-518	Ground Floor Plan NCH - Observation Ward High Level Layout	18/11/11				21/12/11			-					
		Removed By Mercury - NOT REQUIRED FOR RDO (SMALL POWER SHOWN ON NA 400 SERIES DRAWINGS)	MER	A	ME-2A-00-PL-532-519	Ground Floor Plan NCH - Observation Ward High Level Layout	18/11/11				21/12/11			-					

Drawing Information

31 BCL-AC-XX-SH-001

1st Submission2nd Submission

			Action By	Zone	Drawing Number	Drawing Title	Date Required from Consultant	Date Submitted by Consultant	Document Revision	Planned Date to be Submitted to Board	Date Submitted to Board	BMCE Transmittal No	Date Response Required from Board	Date Returned from Board	Board Status	Date returned to Consultant	Date Required from Consultant	Date Submitted by Consultant
Item	Submission	Comments																
		Removed By Mercury - NOT REQUIRED FOR ROD (SMALL POWER SHOWN ON NA 400 SERIES DRAWINGS)	MER	A	ME-ZA-00-PL-532-544	Ground Floor Plan NCH - Sanctuary High Level Layout	18/11/11			21/12/11			-					
		Removed By Mercury - NOT REQUIRED FOR ROD (SMALL POWER SHOWN ON NA 400 SERIES DRAWINGS)	MER	A	ME-ZA-01-PL-532-517	First Floor Plan NCH - Critical Care High Level Layout	18/11/11			21/12/11			-					
		Removed By Mercury - NOT REQUIRED FOR ROD (SMALL POWER SHOWN ON NA 400 SERIES DRAWINGS)	MER	A	ME-ZA-01-PL-532-518	First Floor Plan NCH - Critical Care High Level Layout	18/11/11			21/12/11			-					
		Removed By Mercury - NOT REQUIRED FOR ROD (SMALL POWER SHOWN ON NA 400 SERIES DRAWINGS)	MER	A	ME-ZA-02-PL-532-513	Second Floor Plan NCH ARU High Level Layout	18/11/11			21/12/11			-					
		Removed By Mercury - NOT REQUIRED FOR ROD (SMALL POWER SHOWN ON NA 400 SERIES DRAWINGS)	MER	A	ME-ZA-02-PL-532-514	Second Floor Plan NCH ARU High Level Layout	18/11/11			21/12/11			-					
		Removed By Mercury - NOT REQUIRED FOR ROD (SMALL POWER SHOWN ON NA 400 SERIES DRAWINGS)	MER	A	ME-ZA-03-PL-532-511	Third Floor Plan NCH Inpatient Wards High Level Layout	18/11/11			21/12/11			-					
		Removed By Mercury - NOT REQUIRED FOR ROD (SMALL POWER SHOWN ON NA 400 SERIES DRAWINGS)	MER	A	ME-ZA-03-PL-532-512	Third Floor Plan NCH Inpatient Ward High Level Layout	18/11/11			21/12/11			-					
		Removed By Mercury - NOT REQUIRED FOR ROD (SMALL POWER SHOWN ON NA 400 SERIES DRAWINGS)	MER	A	ME-ZA-03-PL-532-513	Third Floor Plan NCH Inpatient Ward & Renal Services High Level Layout	18/11/11			21/12/11			-					
	ELV SYSTEMS LOW LEVEL	Removed By Mercury - NOT REQUIRED FOR ROD (SMALL POWER SHOWN ON NA 400 SERIES DRAWINGS)	MER	A	ME-ZA-00-PL-532-516	Ground Floor Plan NCH - Child Protection Suite ELV Systems low level Layout	18/11/11			21/12/11			-					
		Removed By Mercury - NOT REQUIRED FOR ROD (SMALL POWER SHOWN ON NA 400 SERIES DRAWINGS)	MER	A	ME-ZA-00-PL-532-517	Ground Floor Plan NCH - Observation Ward ELV Systems low level Layout	18/11/11			21/12/11			-					
		Removed By Mercury - NOT REQUIRED FOR ROD (SMALL POWER SHOWN ON NA 400 SERIES DRAWINGS)	MER	A	ME-ZA-00-PL-532-518	Ground Floor Plan NCH - Observation Ward ELV Systems low level Layout	18/11/11			21/12/11			-					
		Removed By Mercury - NOT REQUIRED FOR ROD (SMALL POWER SHOWN ON NA 400 SERIES DRAWINGS)	MER	A	ME-ZA-00-PL-532-541	Ground Floor Plan NCH - Sanctuary ELV Systems low level Layout	18/11/11			21/12/11			-					
		Removed By Mercury - NOT REQUIRED FOR ROD (SMALL POWER SHOWN ON NA 400 SERIES DRAWINGS)	MER	A	ME-ZA-01-PL-532-517	First Floor Plan NCH - Critical Care ELV Systems low level Layout	18/11/11			21/12/11			-					
		Removed By Mercury - NOT REQUIRED FOR ROD (SMALL POWER SHOWN ON NA 400 SERIES DRAWINGS)	MER	A	ME-ZA-01-PL-532-518	First Floor Plan NCH - Critical Care ELV Systems low level Layout	18/11/11			21/12/11			-					
		Removed By Mercury - NOT REQUIRED FOR ROD (SMALL POWER SHOWN ON NA 400 SERIES DRAWINGS)	MER	A	ME-ZA-02-PL-532-513	Second Floor Plan NCH ARU ELV Systems low level Layout	18/11/11			21/12/11			-					
		Removed By Mercury - NOT REQUIRED FOR ROD (SMALL POWER SHOWN ON NA 400 SERIES DRAWINGS)	MER	A	ME-ZA-02-PL-532-514	Second Floor Plan NCH ARU ELV Systems low level Layout	18/11/11			21/12/11			-					
		Removed By Mercury - NOT REQUIRED FOR ROD (SMALL POWER SHOWN ON NA 400 SERIES DRAWINGS)	MER	A	ME-ZA-03-PL-532-511	Third Floor Plan NCH Inpatient Wards ELV Systems low level Layout	18/11/11			21/12/11			-					
		Removed By Mercury - NOT REQUIRED FOR ROD (SMALL POWER SHOWN ON NA 400 SERIES DRAWINGS)	MER	A	ME-ZA-03-PL-532-512	Third Floor Plan NCH Inpatient Ward ELV Systems low level Layout	18/11/11			21/12/11			-					
		Removed By Mercury - NOT REQUIRED FOR ROD (SMALL POWER SHOWN ON NA 400 SERIES DRAWINGS)	MER	A	ME-ZA-03-PL-532-513	Third Floor Plan NCH Inpatient Ward & Renal Services ELV Systems low level Layout	18/11/11			21/12/11			-					
	DATA COMMS	This Was issued for information on BMCE-TRANSMIT-018729 09/12/13	MER	A	ME-SZ-00-PL-556-513	Ground Floor Plan NCH - OPD Data Comms Layout	06/02/12	06/03/12	C		06/09/12	BMCE-TRANSMIT-010733 (BMCE-WTRAN-003911)	27/09/12	17/09/12	B	20/09/12 BMCE-TRANSMIT-011081		
		This was issued for information on BMCE-TRANSMIT-018730 19/12/13	MER	A	ME-SZ-01-PL-556-516	First Floor Plan. NCH Critical Care (PICU). Layout of Data Outlets Zone A/Zone B	06/02/12	06/03/12	A		20/12/11	BMCE-TRANSMIT-007162 (RE-ISSUED ON BMCE-TRANSMIT-009325 12 06 12)	10/01/12	06/07/12	B	12/07/12 BMCE-TRANSMIT-009799		
			MER	A	ME-SZ-01-PL-556-519	First Floor Plan NCH Critical Care (PICU) - Layout of Data Outlets	06/02/12	06/03/12	B		26/02/13	BMCE-TRANSMIT-0014130 (BMCE-WTRAN-006180)	19/03/13	25/03/13	A	03/05/13 BMCE-TRANSMIT-014906		
			MER	A	ME-SZ-01-PL-556-520	First Floor Plan Medical Day Unit - Layout of Data Outlets	06/02/12	06/03/12	B		26/02/13	BMCE-TRANSMIT-0014130 (BMCE-WTRAN-006180)	19/03/13	25/03/13	A	03/05/13 BMCE-TRANSMIT-014906		
			MER	A	ME-SZ-02-PL-556-515	Second Floor Plan NSGH/NCH Aseptic Suite - Layout of Data Outlets	06/02/12	06/03/12	B		26/02/13	BMCE-TRANSMIT-0014130 (BMCE-WTRAN-006180)	19/03/13	25/03/13	A	03/05/13 BMCE-TRANSMIT-014909		
		This was issued for information on BMCE-TRANSMIT-018891 18.12.13	MER	A	ME-SZ-03-PL-556-510	Third Floor Plan. NCH Inpatient Wards & Ward Support. Layout of Data Outlets Zone A/Zone B	06/02/12	06/03/12			20/12/11	BMCE-TRANSMIT-007162 (RE-ISSUED ON BMCE-TRANSMIT-009325 12 06 12)	10/01/12	06/07/12	B	12/07/12 BMCE-TRANSMIT-009799		
		This was issued for information on BMCE-TRANSMIT-018663 19/12/13	MER	A	ME-ZA-00-PL-556-516	Ground Floor Plan NCH - Child Protection Suite Data Comms Layout	18/11/11		A	21/12/11	20/12/11	BMCE-TRANSMIT-007162 (RE-ISSUED ON BMCE-TRANSMIT-009325 12 06 12)	10/01/12	06/07/12	B	12/07/12 BMCE-TRANSMIT-009799		
			MER	A	ME-ZA-00-PL-556-517	Ground Floor Plan NCH - Observation Ward Data Comms Layout	18/11/11		A	21/12/11	20/12/11	BMCE-TRANSMIT-007162 (RE-ISSUED ON BMCE-TRANSMIT-009325 12 06 12)	10/01/12	06/07/12	A	12/07/12 BMCE-TRANSMIT-009799		
			MER	A	ME-ZA-00-PL-556-518	Ground Floor Plan NCH - Observation Ward Data Comms Layout	18/11/11		A	21/12/11	20/12/11	BMCE-TRANSMIT-007162 (RE-ISSUED ON BMCE-TRANSMIT-009325 12 06 12)	10/01/12	06/07/12	A	12/07/12 BMCE-TRANSMIT-009799		
			MER	A	ME-ZA-00-PL-556-541	Ground Floor Plan NCH - Sanctuary Data Comms Layout	18/11/11		A	21/12/11	20/12/11	BMCE-TRANSMIT-007162 (RE-ISSUED ON BMCE-TRANSMIT-	10/01/12	06/07/12	A	12/07/12 BMCE-TRANSMIT-		

Drawing Information

31BCL-AC-XX-SH-001		1st Submission2nd Submission															
		Action By	Zone	Drawing Number	Drawing Title	Date Required from Consultant	Date Submitted by Consultant	Document Revision	Planned Date to be Submitted to Board	Date Submitted to Board	BMCE Transmittal No	Date Response Required from Board	Date Returned from Board	Board Status	Date returned to Consultant	Date Required from Consultant	Date Submitted by Consultant
Item	Submission	Comments															
		Removed By Mercury - NOT REQUIRED FOR RDD (PART OF BMS DETAIL DESIGN)		MER	A	ME-ZA-00-PL-660-544	Ground Floor Plan NCH - Sanctuary BMS Layout	18/11/11		21/12/11		-					
		Removed By Mercury - NOT REQUIRED FOR RDD (PART OF BMS DETAIL DESIGN)		MER	A	ME-ZA-01-PL-660-517	First Floor Plan NCH - Critical Care BMS Layout	18/11/11		21/12/11		-					

Drawing Information

31

BCL-AC-XX-SH-001

1st Submission

2nd Submission

Item	Submission	Comments	Action By		Zone	Drawing Number	Drawing Title	Date Required from Consultant	Date Submitted by Consultant	Document Revision	Planned Date to be Submitted to Board	Date Submitted to Board	BMCE Transmittal No	Date Response Required from Board	Date Returned from Board	Board Status	Date returned to Consultant	Date Required from Consultant	Date Submitted by Consultant
		Removed By Mercury - NOT REQUIRED FOR RDD (PART OF BMS DETAIL DESIGN)	MER		A	ME-ZA-01-PL-660-518	First Floor Plan NCH – Critical Care BMS Layout	18/11/11			21/12/11			-					
		Removed By Mercury - NOT REQUIRED FOR RDD (PART OF BMS DETAIL DESIGN)	MER		A	ME-ZA-02-PL-660-513	Second Floor Plan NCH- ARU BMS Layout	18/11/11			21/12/11			-					
		Removed By Mercury - NOT REQUIRED FOR RDD (PART OF BMS DETAIL DESIGN)	MER		A	ME-ZA-02-PL-660-514	Second Floor Plan NCH-ARU BMS Layout	18/11/11			21/12/11			-					
		Removed By Mercury - NOT REQUIRED FOR RDD (PART OF BMS DETAIL DESIGN)	MER		A	ME-ZA-03-PL-660-511	Third Floor Plan NCH Inpatient Wards BMS Layout	18/11/11			21/12/11			-					
		Removed By Mercury - NOT REQUIRED FOR RDD (PART OF BMS DETAIL DESIGN)	MER		A	ME-ZA-03-PL-660-512	Third Floor Plan NCH Inpatient Ward BMS Layout	18/11/11			21/12/11			-					
		Removed By Mercury - NOT REQUIRED FOR RDD (PART OF BMS DETAIL DESIGN)	MER		A	ME-ZA-03-PL-660-513	Third Floor Plan NCH Inpatient Ward & Renal Services BMS Layout	18/11/11			21/12/11			-					
	MEDICAL GASES																		
		Issued to the board for information only BMCE-TRANSMIT-017701			A	ME-ZA-00-DC-H512-001	Le-el-0, Childrens Obser- ation Ward												
		Issued to the board for information only BMCE-TRANSMIT-017701			A	ME-ZA-00-DC-H512-002	Level 0, EMCC Resus & Mains												
		Issued to the board for information only BMCE-TRANSMIT-017701			A	ME-ZA-00-DC-H512-003	Le-el-0, Childrens EMC Treatment rooms (from EMC 055) to Mains												
		Issued to the board for information only BMCE-TRANSMIT-017701			A	ME-ZA-01-DC-H512-001	Le-el-1, Childrens Critical Care – CCW-086 to Mains												
		Issued to the board for information only BMCE-TRANSMIT-017701			A	ME-ZA-01-DC-512-002	Level 1, Childrens Critical Care – CCW-088 to Mains												
		Issued to the board for information only BMCE-TRANSMIT-017701			A	ME-ZA-02-DC-512-001	Le-el-2, Childrens Ward-ARU LHS from room-ARU-026 to Mains												
		Issued to the board for information only BMCE-TRANSMIT-017701			A	ME-ZA-02-DC-H512-002	Le-el-2, Childrens Ward-ARU Top/RHS from room-ARU-099 to Riser-M38												
		Issued to the board for information only BMCE-TRANSMIT-017701			A	ME-ZA-03-DC-H512-001	Le-el-3, Childrens Ward-GW1 from (GWS-014) to Riser-M38												
		Issued for information on BMCE-TRANSMIT-019817 31/03/14	MER		A	ME-ZA-00-PL-H512-001	Medical Gas Installation, Level 0, Zone A			1		29/05/12	BMCE-TRANSMIT-009131 (BMCE-WTRAN-003175)	19/06/12	24/09/12	C	27/09/12 BMCE-TRANSMIT-011199		
			MER		A	ME-ZA-00-PL-H512-002	Medical Gas Installation, Level 0, Zone A - AGSS			1		29/05/12	BMCE-TRANSMIT-009131 (BMCE-WTRAN-003175)	19/06/12	24/09/12	C	27/09/12 BMCE-TRANSMIT-011199		
			MER		A	ME-ZA-01-PL-H512-001	Medical Gas Installation, Level 1, Zone A			1		29/05/12	BMCE-TRANSMIT-009127 (BMCE-WTRAN-003174)	19/06/12	24/09/12	C	27/09/12 BMCE-TRANSMIT-011196		
			MER		A	ME-ZA-01-PL-H512-002	Medical Gas Installation, Level 1, Zone A - AGSS			1		29/05/12	BMCE-TRANSMIT-009127 (BMCE-WTRAN-003174)	19/06/12	24/09/12	C	27/09/12 BMCE-TRANSMIT-011196		
			MER		A	ME-ZA-02-PL-H512-001	Medical Gas Installation, Level 2, Zone A			1		29/05/12	BMCE-TRANSMIT-009123 (BMCE-WTRAN-003172)	19/06/12	24/09/12	C	27/09/12 BMCE-TRANSMIT-011202		
			MER		A	ME-ZA-03-PL-H512-001	Medical Gas Installation, Level 3, Zone A			1		29/05/12	BMCE-TRANSMIT-009125 (BMCE-WTRAN-003173)	19/06/12	01/10/12	C	04/10/12 BMCE-TRANSMIT-011325		
			MER		A	ME-ZA-04-PL-H512-002	Medical Gas Installation, Level 4, Zone A - AGSS			1		29/05/12	BMCE-TRANSMIT-009122 (BMCE-WTRAN-003171)	19/06/12	01/10/12	C	04/10/12 BMCE-TRANSMIT-011324		
	MEDICAL GASES																		
		Removed By Mercury - NOT REQUIRED FOR RDD (REFER TO HPI H512 SERIES DESIGN DRAWINGS)	MER		A	ME-ZA-00-PL-512-516	Ground Floor Plan NCH – Child Protection Suite Medical Gas Layout	18/11/11			21/12/11			-					
		Removed By Mercury - NOT REQUIRED FOR RDD (REFER TO HPI H512 SERIES DESIGN DRAWINGS)	MER		A	ME-ZA-00-PL-512-517	Ground Floor Plan NCH – Obser- ation Ward Medical Gases Layout	18/11/11			21/12/11			-					
		Removed By Mercury - NOT REQUIRED FOR RDD (REFER TO HPI H512 SERIES DESIGN DRAWINGS)	MER		A	ME-ZA-00-PL-512-518	Ground Floor Plan NCH – Observation Ward Medical Gases Layout	18/11/11			21/12/11			-					
		Removed By Mercury - NOT REQUIRED FOR RDD (REFER TO HPI H512 SERIES DESIGN DRAWINGS)	MER		A	ME-ZA-00-PL-512-544	Ground Floor Plan NCH – Sanctuary Medical Gases Layout	18/11/11			21/12/11			-					
		Removed By Mercury - NOT REQUIRED FOR RDD (REFER TO HPI H512 SERIES DESIGN DRAWINGS)	MER		A	ME-ZA-01-PL-512-517	First Floor Plan NCH – Critical Care Medical Gases Layout	18/11/11			21/12/11			-					
		Removed By Mercury - NOT REQUIRED FOR RDD (REFER TO HPI H512 SERIES DESIGN DRAWINGS)	MER		A	ME-ZA-01-PL-512-518	First Floor Plan NCH – Critical Care Medical Gases Layout	18/11/11			21/12/11			-					

Drawing Information

31 BCL-AC-XX-SH-001

1st Submission2nd Submission

			Action By	Zone	Drawing Number	Drawing Title	Date Required from Consultant	Date Submitted by Consultant	Document Revision	Planned Date to be Submitted to Board	Date Submitted to Board	BMCE Transmittal No	Date Response Required from Board	Date Returned from Board	Board Status	Date returned to Consultant	Date Required from Consultant	Date Submitted by Consultant
Item	Submission	Comments																
		This was issued for information on BMCE-TRANSMIT-018663 19/12/13	MER	A	ME-ZA-01-PL-572-517	First Floor Plan NCH - Critical Care Fire Detection	18/11/11		A	21/12/11	31/01/12	BMCE-TRANSMIT-007462	21/02/12	29/02/12	B	05/03/12 BMCE-TRANSMIT-007939		
		This was issued for information on BMCE-TRANSMIT-018663 19/12/13	MER	A	ME-ZA-01-PL-572-518	First Floor Plan NCH - Critical Care Fire Detection	18/11/11		A	21/12/11	31/01/12	BMCE-TRANSMIT-007462	21/02/12	29/02/12	B	05/03/12 BMCE-TRANSMIT-007939		
		This was issued for information on BMCE-TRANSMIT-018730 19/12/13	MER	A	ME-SZ-01-PL-572-519	First Floor Plan - Critical Care Fire Detection			A		06/03/12	BMCE-TRANSMIT-007983	27/03/12	14/05/12	B			
		This was issued for information on BMCE-TRANSMIT-018663 19/12/13	MER	A	ME-ZA-02-PL-572-513	Second Floor Plan NCH ARU Fire Detection	18/11/11		A	21/12/11	31/01/12	BMCE-TRANSMIT-007462	21/02/12	29/02/12	B	05/03/12 BMCE-TRANSMIT-007939		
		This was issued for information on BMCE-TRANSMIT-018663 19/12/13	MER	A	ME-ZA-02-PL-572-514	Second Floor Plan NCH ARU Fire Detection	18/11/11		A	21/12/11	31/01/12	BMCE-TRANSMIT-007462	21/02/12	29/02/12	B	05/03/12 BMCE-TRANSMIT-007939		
		Removed By Mercury - Duplicate	MER	A	ME-SZ-02-PL-572-515	Second Floor Plan NSGH/NCH Aseptic Suite - Fire Detection Layout - Zone A/B												
		Removed By Mercury - Duplicate/Wrong drawing number	MER	A	ME-ZA-03-PL-572-510	Third Floor Plan NCH Inpatient Wards Fire Detection & Smoke Control Layout	18/11/11			21/12/11								
		This was issued for information on BMCE-TRANSMIT-018730 19/12/13	MER	A	ME-SZ-03-PL-572-510	Third Floor Plan NCH Inpatient Wards Fire Detection & Smoke Control Layout	18/11/11		A	21/12/11	31/01/12	BMCE-TRANSMIT-007462	21/02/12	29/02/12	B	05/03/12 BMCE-TRANSMIT-007939		
			MER	A	ME-ZA-03-PL-572-511	Third Floor Plan NCH Inpatient Wards Fire Detection	18/11/11		A	21/12/11	31/01/12	BMCE-TRANSMIT-007462	21/02/12	29/02/12	A	05/03/12 BMCE-TRANSMIT-007939		
		This was issued for information on BMCE-TRANSMIT-018663 19/12/13	MER	A	ME-ZA-03-PL-572-512	Third Floor Plan NCH Inpatient Ward Fire Detection	18/11/11		A	21/12/11	31/01/12	BMCE-TRANSMIT-007462	21/02/12	29/02/12	B	05/03/12 BMCE-TRANSMIT-007939		
			MER	A	ME-ZA-03-PL-572-513	Third Floor Plan NCH Inpatient Ward & Renal Services Fire Detection	18/11/11		A	21/12/11	31/01/12	BMCE-TRANSMIT-007462	21/02/12	29/02/12	A	05/03/12 BMCE-TRANSMIT-007939		
		This was issued for information on BMCE-TRANSMIT-018891 18/12/13	MER	A	ME-SZ-04-PL-572-101	Fourth Floor Plan - Plantroom 41 Fire Detection Layout Zone A/B			A	10/09/12	10/09/12	BMCE-TRANSMIT-010869 (BMCE-WTRAN-003929)	01/10/12	18/09/12	B	01/10/12 BMCE-TRANSMIT-011253		
		This was issued for information on BMCE-TRANSMIT-018891 18/12/13	MER	A	ME-SZ-04-PL-572-102	Fourth Floor Plan - Plantroom 41 Fire Detection Layout Zone A/B			A	10/09/12	10/09/12	BMCE-TRANSMIT-010869 (BMCE-WTRAN-003929)	01/10/12	18/09/12	B	01/10/12 BMCE-TRANSMIT-011253		
Pneumatic Tube Distribution		Drawing superseded by ME-XX-00-PL-569-001	MER	A	ME-ZA-00-PL-569-001	Ground Floor Plan Pneumatic Tube Distribution	18/11/11		A	21/12/11	20/12/11	BMCE-TRANSMIT-007160	10/01/12	31/01/12	B	13/02/12 BMCE-TRANSMIT-007564		
			MER	A	ME-ZA-01-PL-569-002	First Floor Plan Pneumatic Tube Distribution	18/11/11		A	21/12/11	20/12/11	BMCE-TRANSMIT-007160	10/01/12	31/01/12	A	13/02/12 BMCE-TRANSMIT-007564		
			MER	A	ME-ZA-02-PL-569-003	Second Floor Plan Pneumatic Tube Distribution	18/11/11		A	21/12/11	20/12/11	BMCE-TRANSMIT-007160	10/01/12	31/01/12	A	13/02/12 BMCE-TRANSMIT-007564		
			MER	A	ME-ZA-03-PL-569-004	Third Floor Plan Pneumatic Tube Distribution	18/11/11		A	21/12/11	20/12/11	BMCE-TRANSMIT-007160	10/01/12	31/01/12	A	13/02/12 BMCE-TRANSMIT-007564		
Nurses Call		This drawing was issued for Review on BMCE-TRANSMIT-018664 03/12/13 Please see Zone B	MER	A	ME-SZ-01-PL-538-516	First Floor NCH Critical Care (PICU) Nurse Call Layout	18/11/11		A	21/12/11	20/12/11	BMCE-TRANSMIT-007163	10/01/12	13/07/12	B	15/08/12 BMCE-TRANSMIT-010329		
			MER	A	ME-SZ-03-PL-538-510	Third Floor NCH Inpatient Wards & Renal Services - Nurse Call Layout	18/11/11		A	21/12/11	20/12/11	BMCE-TRANSMIT-007163	10/01/12	13/07/12	A	15/08/12 BMCE-TRANSMIT-010329		
			MER	A	ME-ZA-00-PL-538-517	Ground Floor Plan NCH Observation Ward Nurse Call Layout	18/11/11		A	21/12/11	20/12/11	BMCE-TRANSMIT-007163	10/01/12	13/07/12	A	15/08/12 BMCE-TRANSMIT-010329		
			MER	A	ME-ZA-00-PL-538-518	Ground Floor Plan NCH Observation Ward Nurse Call Layout	18/11/11		A	21/12/11	20/12/11	BMCE-TRANSMIT-007163	10/01/12	13/07/12	A	15/08/12 BMCE-TRANSMIT-010329		
			MER	A	ME-ZA-01-PL-538-517	First Floor Plan NCH Critical Care (PICU) Nurses Call Layout	18/11/11		A	21/12/11	20/12/11	BMCE-TRANSMIT-007163	10/01/12	13/07/12	A	15/08/12 BMCE-TRANSMIT-010329		
			MER	A	ME-ZA-01-PL-538-518	First Floor Plan CNH Critical Care (PICU) Nurses Call Layout	18/11/11		A	21/12/11	20/12/11	BMCE-TRANSMIT-007163	10/01/12	13/07/12	A	15/08/12 BMCE-TRANSMIT-010329		
			MER	A	ME-SZ-01-PL-538-519	First Floor Plan CNH Critical Care (PICU) Nurses Call Layout Zone A/B			C		26/02/13	BMCE-TRANSMIT-0014130 (BMCE-WTRAN-006180)	19/03/13	25/03/13	A	03/05/13 BMCE-TRANSMIT-014905		
			MER	A	ME-ZA-02-PL-538-513	Second Floor Plan NCH Acute Receiving Unit Nurses Call Layout	18/11/11		A	21/12/11	20/12/11	BMCE-TRANSMIT-007163	10/01/12	13/07/12	A	15/08/12 BMCE-TRANSMIT-010329		
		This was issued for information on BMCE-TRANSMIT-018663 19/12/13	MER	A	ME-ZA-02-PL-538-514	Second Floor Plan NCH Acute Receiving Unit Nurses Call Layout	18/11/11		A	21/12/11	20/12/11	BMCE-TRANSMIT-007163	10/01/12	13/07/12	B	15/08/12 BMCE-TRANSMIT-010329		
		REMOVED BY MERCURY - DUPLICATE	MER	A	ME-SZ-02-PL-538-515	Second Floor Plan NSGH/NCH Aseptic Suite Unit - Nurses Call Layout - Zone B/A												
		This was issued for information on BMCE-TRANSMIT-018663 19/12/13	MER	A	ME-ZA-03-PL-538-511	Third Floor Plan NCH Inpatient Wards & Ward Support Nurse Call Layout	18/11/11		A	21/12/11	20/12/11	BMCE-TRANSMIT-007163	10/01/12	13/07/12	B	15/08/12 BMCE-TRANSMIT-010329		
			MER	A	ME-ZA-03-PL-538-512	Third Floor Plan NCH Inpatient Wards & Ward Support Nurse Call Layout	18/11/11		A	21/12/11	20/12/11	BMCE-TRANSMIT-007163	10/01/12	13/07/12	A	15/08/12 BMCE-TRANSMIT-		

Drawing Information

31 BCL-AC-XX-SH-001

			Action By		Zone	Drawing Number	Drawing Title	Date Required from Consultant	Date Submitted by Consultant	Document Revision	Planned Date to be Submitted to Board	Date Submitted to Board	BMCE Transmittal No	Date Response Required from Board	Date Returned from Board	Board Status	Date returned to Consultant	Date Required from Consultant	Date Submitted by Consultant
Item	Submission	Comments																	
		Removed By Mercury - DUPLICATE	MER	A	ME-SZ-02-PL-571-515	Second Floor Plan NCH Aspetic Suite CCTV & Door Access Layout													
		This was issued for information on BMCE-TRANSMIT-018667 03/12/13	MER	A	ME-ZA-03-PL-571-511	Thid Floor Plan NCH Inpatient Wards & Ward Support CCTV & Door Access	18/11/11		A	21/12/11	20/12/11	BMCE-TRANSMIT-007161	10/01/12	12/07/12	B	19/07/12 BMCE-TRANSMIT-009929			
			MER	A	ME-ZA-03-PL-571-512	Third Floor Plan NCH Inpatient Wards & RenalServices CCTV & Door Access Layout	18/11/11		A	21/12/11	20/12/11	BMCE-TRANSMIT-007161	10/01/12	12/07/12	A	19/07/12 BMCE-TRANSMIT-009929			
		This was issued for information on BMCE-TRANSMIT-018663 19/12/13	MER	A	ME-ZA-03-PL-571-513	Second Floor Plan NCH Acute Receiving Unit CCTV & Door Access Layout	18/11/11		A	21/12/11	20/12/11	BMCE-TRANSMIT-007161	10/01/12	12/07/12	B	19/07/12 BMCE-TRANSMIT-009929			
		Removed By Mercury - DUPLICATE	MER	A	ME-SZ-03-PL-571-519	Third Floor Plan NCH Inpatient Wards & Ward Support CCTV & Door Access Layout	18/11/11		A	21/12/11	20/12/11	BMCE-TRANSMIT-007161							
			MER	A	ME-SZ-04-PL-571-101	Fourth Floor Plan - Plantroom 41 CCTV & Door Access Layout			A	10/09/12	10/09/12	BMCE-TRANSMIT-010869 (BMCE-WTRAN-003929)	01/10/12	18/19/12	A	01/10/12 BMCE-TRANSMIT-011253			
		This was issued for information on BMCE-TRANSMIT-018891 18/12/13 -	MER	A	ME-SZ-04-PL-571-102				A	10/09/12	10/09/12	BMCE-TRANSMIT-010869 (BMCE-WTRAN-003929)	01/10/12	18/09/12	B	01/10/12 BMCE-TRANSMIT-011253			
	Sprinkler System		MER	A	ME-ZA-B1-PL-575-314	Basement Level Void Layout			A		07/06/12	BMCE-TRANSMIT-009260 V(BMCE-WTRAN-003224)	28/06/12	06/07/12	A	18/07/12 BMCE-TRANSMIT-009899			
			MER	A	ME-ZA-B1-PL-575-315	Basement Level Ceiling Layout			A		07/06/12	BMCE-TRANSMIT-009260 V(BMCE-WTRAN-003224)	28/06/12	06/07/12	A	18/07/12 BMCE-TRANSMIT-009899			
			MER	A	ME-ZA-00-PL-575-314	Ground floor Void Layout	18/11/11		A	21/12/11	20/12/11	BMCE-TRANSMIT-007166	10/01/12	31/01/12	A	13.02.12 BMCE-TRANSMIT-007565			
			MER	A	ME-ZA-00-PL-575-315	Ground Floor Ceiling Layout	18/11/11		A	21/12/11	20/12/11	BMCE-TRANSMIT-007166	10/01/12	31/01/12	A	13.02.12 BMCE-TRANSMIT-007565			
		Issued for information on BMCE-TRANSMIT-019734 20/03/14	MER	A	ME-ZA-01-PL-575-314	First Floor Void Layout	18/11/11		A	21/12/11	20/12/11	BMCE-TRANSMIT-007166	10/01/12	31/01/12	B	13.02.12 BMCE-TRANSMIT-007565			
		Issued for information on BMCE-TRANSMIT-019712 18/03/14	MER	A	ME-ZA-01-PL-575-315	First Floor Ceiling Layout	18/11/11		A	21/12/11	20/12/11	BMCE-TRANSMIT-007166	10/01/12	31/01/12	B	13.02.12 BMCE-TRANSMIT-007565			
		Issued for information on BMCE-TRANSMIT-019816 31/03/14	MER	A	ME-ZA-02-PL-575-314	Second Floor Void Layout	18/11/11		A	21/12/11	20/12/11	BMCE-TRANSMIT-007166	10/01/12	31/01/12	B	13.02.12 BMCE-TRANSMIT-007565			
		Issued for information on BMCE-TRANSMIT-019816 31/03/14	MER	A	ME-ZA-02-PL-575-315	Second Floor Ceiling Layout	18/11/11		A	21/12/11	20/12/11	BMCE-TRANSMIT-007166	10/01/12	31/01/12	B	13.02.12 BMCE-TRANSMIT-007565			
		Issued for information on BMCE-TRANSMIT-019816 31/03/14	MER	A	ME-ZA-03-PL-575-314	Third Floor Void Layout	18/11/11		A	21/12/11	20/12/11	BMCE-TRANSMIT-007166	10/01/12	31/01/12	B	13.02.12 BMCE-TRANSMIT-007565			
		Issued for information on BMCE-TRANSMIT-019816 31/03/14	MER	A	ME-ZA-03-PL-575-315	Third floor Ceiling Layout	18/11/11		A	21/12/11	20/12/11	BMCE-TRANSMIT-007166	10/01/12	31/01/12	B	13.02.12 BMCE-TRANSMIT-007565			
		Issued for information on BMCE-TRANSMIT-019816 31/03/14	MER	A	ME-ZA-04-PL-575-314	Fourth Floor Void Layout	18/11/11		A	21/12/11	20/12/11	BMCE-TRANSMIT-007166	10/01/12	31/01/12	B	13.02.12 BMCE-TRANSMIT-007565			
		Issued for information on BMCE-TRANSMIT-019816 31/03/14	MER	A	ME-ZA-04-PL-575-315	Fourth Floor Ceiling Layout	18/11/11		A	21/12/11	20/12/11	BMCE-TRANSMIT-007166	10/01/12	31/01/12	B	13.02.12 BMCE-TRANSMIT-007565			
	Hospital Drawings - Zone B		ZBP	B	ZBP-ZB-00-PL-512-002	Medical Gases Layout Ground	06/02/12	06/03/12	A	07/03/12	07/03/12	BMCE TRANSMIT 007976	28/03/12	11/05/12	A	21/05/12 BMCE-TRANSMIT-008965			
	MEchanical Services Drawings		ZBP	B	ZBP-ZB-01-PL-512-012	Medical Gases Layout First	06/02/12	06/03/12	A	07/03/12	07/03/12	BMCE TRANSMIT 007976	28/03/12	11/05/12	A	21/05/12 BMCE-TRANSMIT-008965			
			ZBP	B	ZBP-ZB-02-PL-512-022	Medical Gases Layout Second	06/02/12	06/03/12	A	07/03/12	07/03/12	BMCE TRANSMIT 007976	28/03/12	11/05/12	A	21/05/12 BMCE-TRANSMIT-008965			
			ZBP	B	ZBP-ZB-03-PL-512-032	Medical Gases Layout Third	06/02/12	06/03/12	A	07/03/12	07/03/12	BMCE TRANSMIT 007976	28/03/12	11/05/12	A	21/05/12 BMCE-TRANSMIT-008965			
			ZBP	B	ZBP-ZB-00-PL-523-002	HTG & CHW Layout Ground	06/02/12	06/03/12	A	07/03/12	07/03/12	BMCE TRANSMIT 007976	28/03/12	11/05/12	A	21/05/12 BMCE-TRANSMIT-008965			
		This was issued for information on BMCE-TRANSMIT-018820 13/12/13	ZBP	B	ZBP-ZB-01-PL-523-012	HTG & CHW Layout First	06/02/12	06/03/12	A	07/03/12	07/03/12	BMCE TRANSMIT 007976	28/03/12	11/05/12	B	21/05/12 BMCE-TRANSMIT-008965			
			ZBP	B	ZBP-ZB-02-PL-523-022	HTG & CHW Layout Second	06/02/12	06/03/12	A	07/03/12	07/03/12	BMCE TRANSMIT 007976	28/03/12	11/05/12	B	21/05/12 BMCE-TRANSMIT-008965			
		This was issued for information on BMCE-TRANSMIT-018820 13/12/13	ZBP	B	ZBP-ZB-03-PL-523-032	HTG & CHW Layout Third	06/02/12	06/03/12	A	07/03/12	07/03/12	BMCE TRANSMIT 007976	28/03/12	11/05/12	B	21/05/12 BMCE-TRANSMIT-008965			

Drawing Information

31 BCL-AC-XX-SH-001

			Action By		Zone	Drawing Number	Drawing Title	Date Required from Consultant	Date Submitted by Consultant	Document Revision	Planned Date to be Submitted to Board	Date Submitted to Board	BMCE Transmittal No	Date Response Required from Board	Date Returned from Board	Board Status	Date returned to Consultant	Date Required from Consultant	Date Submitted by Consultant
Item	Submission	Comments																	
			ZBP	B	ZBP-ZB-03-PL-531-032	Small Power Layout Third	06/02/12	06/03/12	A	05/03/12	07/03/12	BMCE TRANSMIT 007975 (BMCE-WTRAN-002673)	28/03/12	11/05/12	A	21/05/12 BMCE-TRANSMIT-008967			
			ZBP	B	ZBP-ZB-00-PL-532-002	Containment/Sub-Main Layout Ground	06/02/12	06/03/12	A	07/03/12	07/03/12	BMCE TRANSMIT 007975 (BMCE-WTRAN-002673)	28/03/12	11/05/12	A	21/05/12 BMCE-TRANSMIT-008967			
			ZBP	B	ZBP-ZB-01-PL-532-012	Containment/Sub-Main Layout First	06/02/12	06/03/12	A	07/03/12	07/03/12	BMCE TRANSMIT 007975 (BMCE-WTRAN-002673)	28/03/12	11/05/12	A	21/05/12 BMCE-TRANSMIT-008967			
			ZBP	B	ZBP-ZB-02-PL-532-022	Containment/Sub-Main Layout Second	06/02/12	06/03/12	A	07/03/12	07/03/12	BMCE TRANSMIT 007975 (BMCE-WTRAN-002673)	28/03/12	11/05/12	A	21/05/12 BMCE-TRANSMIT-008967			
			ZBP	B	ZBP-ZB-03-PL-532-032	Containment/Sub-Main Layout Third	06/02/12	06/03/12	A	07/03/12	07/03/12	BMCE TRANSMIT 007975 (BMCE-WTRAN-002673)	28/03/12	11/05/12	A	21/05/12 BMCE-TRANSMIT-008967			
			ZBP	B	ZBP-ZB-00-PL-571-002	Security Layout Ground	06/02/12	06/03/12	A	07/03/12	07/03/12	BMCE TRANSMIT 007975 (BMCE-WTRAN-002673)	28/03/12	11/05/12	A	21/05/12 BMCE-TRANSMIT-008967			
			ZBP	B	ZBP-ZB-01-PL-571-012	Security Layout First	06/02/12	06/03/12	A	07/03/12	07/03/12	BMCE TRANSMIT 007975 (BMCE-WTRAN-002673)	28/03/12	11/05/12	A	21/05/12 BMCE-TRANSMIT-008967			
			ZBP	B	ZBP-ZB-02-PL-571-022	Security Layout Second	06/02/12	06/03/12	A	07/03/12	07/03/12	BMCE TRANSMIT 007975 (BMCE-WTRAN-002673)	28/03/12	11/05/12	A	21/05/12 BMCE-TRANSMIT-008967			
			ZBP	B	ZBP-ZB-03-PL-571-032	Security Layout Third	06/02/12	06/03/12	A	07/03/12	07/03/12	BMCE TRANSMIT 007975 (BMCE-WTRAN-002673)	28/03/12	11/05/12	A	21/05/12 BMCE-TRANSMIT-008967			
	Public Health Services Drawings	This was issued for information on BMCE-TRANSMIT-018820 13/12/13	ZBP	B	ZBP-ZB-00-PL-500-002	Water & Gas Services Layout Ground	06/02/12				07/03/12	06/03/12	BMCE-TRANSMIT-007977 (BMCE-WTRAN-002675)	27/03/12	19/04/12	B	20/04/12 BMCE-TRANSMIT-008463		
		This was issued for information on BMCE-TRANSMIT-018820 13/12/13	ZBP	B	ZBP-ZB-01-PL-500-012	Water & Gas Services Layout First	06/02/12				07/03/12	06/03/12	BMCE-TRANSMIT-007977 (BMCE-WTRAN-002675)	27/03/12	19/04/12	B	20/04/12 BMCE-TRANSMIT-008463		
	This was issued for information on BMCE-TRANSMIT-018820 13/12/13	ZBP	B	ZBP-ZB-02-PL-500-022	Water & Gas Services Layout Second	06/02/12				07/03/12	06/03/12	BMCE-TRANSMIT-007977 (BMCE-WTRAN-002675)	27/03/12	19/04/12	B	20/04/12 BMCE-TRANSMIT-008463			
	This was issued for information on BMCE-TRANSMIT-018820 13/12/13	ZBP	B	ZBP-ZB-03-PL-500-032	Water & Gas Services Layout Third	06/02/12				07/03/12	06/03/12	BMCE-TRANSMIT-007977 (BMCE-WTRAN-002675)	27/03/12	19/04/12	B	20/04/12 BMCE-TRANSMIT-008463			
			ZBP	B	ZBP-ZB-00-PL-581-002	Sanitation and Rainwater Layout Ground	06/02/12				07/03/12	06/03/12	BMCE-TRANSMIT-007977 (BMCE-WTRAN-002675)	27/03/12	19/04/12	A	20/04/12 BMCE-TRANSMIT-008463		
			ZBP	B	ZBP-ZB-01-PL-581-012	Sanitation and Rainwater Layout First	06/02/12				07/03/12	06/03/12	BMCE-TRANSMIT-007977 (BMCE-WTRAN-002675)	27/03/12	19/04/12	A	20/04/12 BMCE-TRANSMIT-008463		
	ADDED		ZBP	B	ZBP-ZB-02-PL-581-022	Sanitation and Rainwater Layout Second	06/02/12				07/03/12	06/03/12	BMCE-TRANSMIT-007977 (BMCE-WTRAN-002675)	27/03/12	19/04/12	A	20/04/12 BMCE-TRANSMIT-008463		
	ADDED		ZBP	B	ZBP-ZB-03-PL-581-032	Sanitation and Rainwater Layout Third	06/02/12				07/03/12	06/03/12	BMCE-TRANSMIT-007977 (BMCE-WTRAN-002675)	27/03/12	19/04/12	A	20/04/12 BMCE-TRANSMIT-008463		
	REMOVED BY ZBP		ZBP	B	ZBP-ZB-04-PL-581-042	Sanitation and Rainwater Layout Second								-					
			ZBP	B	ZBP-ZB-05-PL-581-052	Sanitation and Rainwater Layout Fifth						14/11/12	BMCE-TRANSMIT-012288 (BMCE-WTRAN-004575)	05/12/12	07/12/12	A	18/12/12 BMCE-TRANSMIT-012269		
Plantroom 41	REMOVED BY ZBP		ZBP	B	ZBP-ZB-03-PL-512-153	Plantroom-41 Medical Gases	17/08/12				21/09/12			-					
	REMOVED BY ZBP		ZBP	B	ZBP-ZB-03-PL-512-154	Plantroom-41 Medical Gases	17/08/12				21/09/12			-					
	REMOVED BY ZBP		ZBP	B	ZBP-ZB-03-PL-512-155	Plantroom-41 Medical Gases	17/08/12				21/09/12			-					
	This was issued for information on BMCE-TRANSMIT-018820 13/12/13		ZBP	B	ZBP-ZB-04-PL-523-153	Plantroom 41 Pipework	17/08/12		A	21/09/12	11/10/12	BMCE-TRANSMIT-0011492 (BMCE-WTRAN-004185)	01/11/12		B	08/11/12 BMCE-TRANSMIT-012192			
			ZBP	B	ZBP-ZB-04-PL-523-154	Plantroom 41 Pipework	17/08/12		A	21/09/12	19/10/12	BMCE-TRANSMIT-011716 (BMCE-WTRAN-004265)	09/11/12	06/11/12	A	08/11/12 BMCE-TRANSMIT-012180			
	This was issued for information on BMCE-TRANSMIT-018820 13/12/13		ZBP	B	ZBP-ZB-04-PL-523-155	Plantroom 41 Pipework	17/08/12		A	21/09/12	11/10/12	BMCE-TRANSMIT-0011492 (BMCE-WTRAN-004185)	01/11/12		B	08/11/12 BMCE-TRANSMIT-012192			
			ZBP	B	ZBP-ZB-04-PL-523-156	Plantroom 41 Pipework	17/08/12		A	21/09/12	11/10/12	BMCE-TRANSMIT-0011492 (BMCE-WTRAN-004185)	01/11/12		B	08/11/12 BMCE-TRANSMIT-			

Drawing Information

31 BCL-AC-XX-SH-001

1st Submission2nd Submission

			Action By	Zone	Drawing Number	Drawing Title	Date Required from Consultant	Date Submitted by Consultant	Document Revision	Planned Date to be Submitted to Board	Date Submitted to Board	BMCE Transmittal No	Date Response Required from Board	Date Returned from Board	Board Status	Date returned to Consultant	Date Required from Consultant	Date Submitted by Consultant
Item	Submission	Comments																
		REMOVED BY ZBP	ZBP	B	ZBP-ZB-03-PL-500-164	Plantroom-41-Water-Ser-ices-	17/08/12			21/09/12								
		REMOVED BY ZBP	ZBP	B	ZBP-ZB-03-PL-500-165	Plantroom-41-Water-Ser-ices-	17/08/12			21/09/12								
		DRAWING NUMBER CHANGED REMOVED BY ZBP	ZBP	B	ZBP-ZB-04-PL-581-412	Plantroom-41-Sanitation-and-Rainwater-Layout	17/08/12			21/09/12								
		DRAWING NUMBER CHANGED REMOVED BY ZBP	ZBP	B	ZBP-ZB-06-PL-581-422	Plantroom-41-Sanitation-and-Rainwater-Layout	17/08/12			21/09/12								
			ZBP	B	ZBP-ZB-04-PL-581-042	Plantroom 41 Sanitation and Rainwater Layout					14/11/12	BMCE-TRANSMIT-012288 BMCE-WTRAN-004575	05/12/12	07/12/12	A	18/12/12 BMCE-TRANSMIT-012369		
			ZBP	B	ZBP-ZB-06-PL-581-063	Plantroom-41-Sanitation-and-Rainwater-Layout												
	Riser Drawings	This was issued for information on BMCE-TRANSMIT-018820 13/12/13	ZBP	B	ZBP-ZB-XX-PL-520-665	Riser M17	24/02/12		A	30/03/12	04/04/12	BMCE-TRANSMIT-008283 (BME-WTRAN-007296)	25/04/12	25/06/12	B	05/07/12 BMCE-TRANSMIT-009682		
			ZBP	B	ZBP-ZB-XX-PL-520-666	Riser M18	24/02/12		A	30/03/12	04/04/12	BMCE-TRANSMIT-008283 (BME-WTRAN-007296)	25/04/12	25/06/12	A	05/07/12 BMCE-TRANSMIT-009682		
			ZBP	B	ZBP-ZB-XX-PL-520-667	Riser M19	24/02/12		A	30/03/12	04/04/12	BMCE-TRANSMIT-008283 (BME-WTRAN-007296)	25/04/12	25/06/12	A	05/07/12 BMCE-TRANSMIT-009682		
			ZBP	B	ZBP-ZB-XX-PL-520-668	Riser M20	24/02/12		A	30/03/12	04/04/12	BMCE-TRANSMIT-008283 (BME-WTRAN-007296)	25/04/12	25/06/12	A	05/07/12 BMCE-TRANSMIT-009682		
		This was issued for information on BMCE-TRANSMIT-018820 13/12/13	ZBP	B	ZBP-ZB-XX-PL-520-669	Riser M32	24/02/12		A	30/03/12	04/04/12	BMCE-TRANSMIT-008283 (BME-WTRAN-007296)	25/04/12	25/06/12	B	05/07/12 BMCE-TRANSMIT-009682		
			ZBP	B	ZBP-ZB-XX-PL-520-670	Riser M34	24/02/12		A	30/03/12	04/04/12	BMCE-TRANSMIT-008283 (BME-WTRAN-007296)	25/04/12	25/06/12	A	05/07/12 BMCE-TRANSMIT-009682		
			ZBP	B	ZBP-ZB-XX-PL-520-671	Riser M39	24/02/12		A	30/03/12	04/04/12	BMCE-TRANSMIT-008283 (BME-WTRAN-007296)	25/04/12	25/06/12	A	05/07/12 BMCE-TRANSMIT-009682		
	LIGHTING	This Was issued for information on BMCE-TRANSMIT-018729 09/12/13	MER	B	ME-SZ-00-PL-541-513	Ground Floor Plan NCH - OPD Lighting Layout	06/02/12		A	07/03/12	06/03/12	BMCE-TRANSMIT-007981	27/03/12	11/05/12	B	25/05/12 BMCE-TRANSMIT-009075		
		This was issued for information on BMCE-TRANSMIT-018730 19/12/13	MER	B	ME-SZ-01-PL-541-516	First Floor Plan NCH Critical Care (PICU) Lighting Layout	06/02/12		C	07/03/12	06/03/12	BMCE-TRANSMIT-007981	27/03/12	11/05/12	B	25/05/12 BMCE-TRANSMIT-009075		
		This was issued for information on BMCE-TRANSMIT-018730 19/12/13	MER	B	ME-SZ-01-PL-541-519	First Floor Plan NCH Critical Care (PICU) - Lighting Layout	06/02/12	06/03/12	A	07/03/12	06/03/12	BMCE-TRANSMIT-007981	27/03/12	11/05/12	B	25/05/12 BMCE-TRANSMIT-009075		
		This was issued for information on BMCE-TRANSMIT-018667 03/12/13	MER	B	ME-SZ-02-PL-541-515	Second Floor Plan NSGH/NCH Aseptic Suite - Lighting Layout	06/02/12	06/03/12	A	07/03/12	06/03/12	BMCE-TRANSMIT-007981	27/03/12	11/05/12	B	25/05/12 BMCE-TRANSMIT-009075		
		This was issued for information on BMCE-TRANSMIT-018730 19/12/13	MER	B	ME-SZ-03-PL-541-508	Third Floor Plan NCH Inpatients Wards & Ward Support - Lighting Layout	06/02/12			07/03/12	06/03/12	BMCE-TRANSMIT-007981	27/03/12	11/05/12	B	25/05/12 BMCE-TRANSMIT-009075		
		This was issued for information on BMCE-TRANSMIT-018730 19/12/13	MER	B	ME-SZ-03-PL-541-510	Third Floor Plan NCH Inpatient Wards & Ward Support Lighting Layout Zone A / Zone B	07/02/12	06/03/12	A	08/03/12	06/03/12	BMCE-TRANSMIT-007981	27/03/12	11/05/12	B	25/05/12 BMCE-TRANSMIT-009075		
			MER	B	ME-SZ-04-PL-541-515	Fourth Floor Plan NCH Psychiatry / DCFP - Lighting Layout	06/02/12		C	07/03/12	26/02/13	BMCE-TRANSMIT-014130 (BMCE-WTRAN-006182)	19/03/13	25/03/13	A	03/05/13 BMCE-TRANSMIT-014609		
		This was issued for information on BMCE-TRANSMIT-018730 19/12/13	MER	B	ME-SZ-B1-PL-541-507	Basement Floor Plan NCH Basement Plant-Sprinkler Tanks - Lighting Layout	06/02/12		A	07/03/12	06/06/12	BMCE-TRANSMIT-009244 (BMCE-WTRAN-003216)	27/06/12	11/07/12	B	16/07/12 BMCE-TRANSMIT-009682		
		This was issued for information on BMCE-TRANSMIT-018730 19/12/13	MER	B	ME-ZB-00-PL-541-512	Ground Floor Plan NCH - OPD Lighting Layout	06/02/12	06/03/12	A	07/03/12	06/03/12	BMCE-TRANSMIT-007981	27/03/12	11/05/12	B	25/05/12 BMCE-TRANSMIT-009075		
		This was issued for information on BMCE-TRANSMIT-018730 19/12/13	MER	B	ME-ZB-00-PL-541-514	Ground Floor Plan NCH - OPD Lighting Layout	06/02/12	06/03/12	A	07/03/12	06/03/12	BMCE-TRANSMIT-007981	27/03/12	11/05/12	B	25/05/12 BMCE-TRANSMIT-009075		
		This was issued for information on BMCE-TRANSMIT-018730 19/12/13	MER	B	ME-ZB-00-PL-541-515	Ground Floor Plan NCH - OPD Lighting Layout	06/02/12	06/03/12	A	07/03/12	06/03/12	BMCE-TRANSMIT-007981	27/03/12	11/05/12	B	25/05/12 BMCE-TRANSMIT-009075		
		This was issued for information on BMCE-TRANSMIT-018730 19/12/13	MER	B	ME-ZB-01-PL-541-513	First Floor Plan NCH - Cardiology Ward Lighting Layout	06/02/12	06/03/12	A	07/03/12	06/03/12	BMCE-TRANSMIT-007981	27/03/12	11/05/12	B	25/05/12 BMCE-TRANSMIT-009075		
			MER	B	ME-ZB-01-PL-541-514	First Floor Plan NCH - Cardiology Ward Lighting Layout	06/02/12	06/03/12	A	07/03/12	06/03/12	BMCE-TRANSMIT-007981	27/03/12	11/05/12	A	25/05/12 BMCE-TRANSMIT-009075		
			MER	B	ME-ZB-01-PL-541-515	First Floor Plan NCH - Special Feeds Lighting Layout	06/02/12	06/03/12	A	07/03/12	06/03/12	BMCE-TRANSMIT-007981	27/03/12	11/05/12	A	25/05/12 BMCE-TRANSMIT-009075		
		This was issued for information on BMCE-TRANSMIT-018730 19/12/13	MER	B	ME-SZ-01-PL-541-520	First Floor Plan. Medical Day Unit. Lighting Layout. Zone B	06/02/12	06/03/12	A	07/03/12	06/03/12	BMCE-TRANSMIT-007981	27/03/12	11/05/12	B	25/05/12 BMCE-TRANSMIT-009075		
		This was issued for information on BMCE-TRANSMIT-018730 19/12/13	MER	B	ME-ZB-02-PL-541-510	Second Floor Plan NCH Anaesthetic Offices/Hospital At Night/ Admin Support Lighting Layout	06/02/12	06/03/12	A	07/03/12	06/03/12	BMCE-TRANSMIT-007981	27/03/12	11/05/12	B	25/05/12 BMCE-TRANSMIT-009075		

Drawing Information

31 BCL-AC-XX-SH-001

			Action By		Zone	Drawing Number		Drawing Title		Date Required from Consultant	Date Submitted by Consultant	Document Revision	Planned Date to be Submitted to Board	Date Submitted to Board	BMCE Transmittal No	Date Response Required from Board	Date Returned from Board	Board Status	Date returned to Consultant	Date Required from Consultant	Date Submitted by Consultant
Item	Submission	Comments																			
	Small Power-	Removed By Mercury - NOT REQUIRED FOR RDD (SMALL POWER SHOWN ON NA 400 SERIES DRAWINGS)	MER	B		ME-ZB-00-PL-531-512	Ground Floor Plan NCH – OPD Small Power & General Ser-ices Layout	06/02/12					06/03/12			-					
		Removed By Mercury - NOT REQUIRED FOR RDD (SMALL POWER SHOWN ON NA 400 SERIES DRAWINGS)	MER	B		ME-ZB-00-PL-531-514	Ground Floor Plan NCH – OPD Small Power & General Ser-ices Layout	06/02/12					06/03/12			-					
		Removed By Mercury - NOT REQUIRED FOR RDD (SMALL POWER SHOWN ON NA 400 SERIES DRAWINGS)	MER	B		ME-ZB-00-PL-531-515	Ground Floor Plan NCH – OPD Small Power & General Services Layout	06/02/12					06/03/12			-					
		Removed By Mercury - NOT REQUIRED FOR RDD (SMALL POWER SHOWN ON NA 400 SERIES DRAWINGS)	MER	B		ME-ZB-01-PL-531-513	First Floor Plan NCH – Cardiology Ward Small Power & General Ser-ices Layout	06/02/12					06/03/12			-					
		Removed By Mercury - NOT REQUIRED FOR RDD (SMALL POWER SHOWN ON NA 400 SERIES DRAWINGS)	MER	B		ME-ZB-01-PL-531-514	First Floor Plan NCH – Cardiology Ward Small Power & General Services Layout	06/02/12					06/03/12			-					
		Removed By Mercury - NOT REQUIRED FOR RDD (SMALL POWER SHOWN ON NA 400 SERIES DRAWINGS)	MER	B		ME-ZB-01-PL-531-515	First Floor Plan NCH – Special Feeds Small Power & General Ser-ices Layout	06/02/12					06/03/12			-					
		Removed By Mercury - NOT REQUIRED FOR RDD (SMALL POWER SHOWN ON NA 400 SERIES DRAWINGS)	MER	B		ME-ZB-02-PL-531-510	Second Floor Plan NCH – Anaesthetic Offices/Hospital At Night/ Admin- Support Small Power & General Ser-ices Layout	06/02/12					06/03/12			-					
		Removed By Mercury - NOT REQUIRED FOR RDD (SMALL POWER SHOWN ON NA 400 SERIES DRAWINGS)	MER	B		ME-ZB-02-PL-531-511	Second Floor Plan NCH Day In- vestigation Unit/ Medical Day Unit Small Power & General Ser-ices Layout	06/02/12					06/03/12			-					
		Removed By Mercury - NOT REQUIRED FOR RDD (SMALL POWER SHOWN ON NA 400 SERIES DRAWINGS)	MER	B		ME-ZB-02-PL-531-512	Second Floor Plan NCH ARU Small Power & General Ser-ices Layout	06/02/12					06/03/12			-					
		Removed By Mercury - NOT REQUIRED FOR RDD (SMALL POWER SHOWN ON NA 400 SERIES DRAWINGS)	MER	B		ME-ZB-03-PL-531-509	Third Floor Plan NCH Inpatient Wards Small Power & General Services Layout	06/02/12					06/03/12			-					
		Removed By Mercury - NOT REQUIRED FOR RDD (SMALL POWER SHOWN ON NA 400 SERIES DRAWINGS)	MER	B		ME-ZB-03-PL-531-514	Third Floor Plan NCH Inpatient Wards Small Power & General Ser-ices Layout	06/02/12					06/03/12			-					
		Removed By Mercury - NOT REQUIRED FOR RDD (SMALL POWER SHOWN ON NA 400 SERIES DRAWINGS)	MER	B		ME-ZB-03-PL-531-515	Third Floor Plan NCH Inpatient Wards Small Power & General Ser-ices Layout	06/02/12					06/03/12			-					
		Removed By Mercury - NOT REQUIRED FOR RDD (SMALL POWER SHOWN ON NA 400 SERIES DRAWINGS)	MER	B		ME-ZB-B1-PL-531-508	Basement Floor Plan NCH Core J Small Power & General Ser-ices Layout									-					
		Removed By Mercury - NOT REQUIRED FOR RDD (SMALL POWER SHOWN ON NA 400 SERIES DRAWINGS)	MER	B		ME-ZB-00-PL-532-512	Ground Floor Plan NCH – OPD High Le- el Layout	06/02/12					06/03/12			-					
		Removed By Mercury - NOT REQUIRED FOR RDD (SMALL POWER SHOWN ON NA 400 SERIES DRAWINGS)	MER	B		ME-ZB-00-PL-532-514	Ground Floor Plan NCH – OPD High Le- el Layout	06/02/12					06/03/12			-					
		Removed By Mercury - NOT REQUIRED FOR RDD (SMALL POWER SHOWN ON NA 400 SERIES DRAWINGS)	MER	B		ME-ZB-00-PL-532-515	Ground Floor Plan NCH – OPD High Le- el Layout	06/02/12					06/03/12			-					
		Removed By Mercury - NOT REQUIRED FOR RDD (SMALL POWER SHOWN ON NA 400 SERIES DRAWINGS)	MER	B		ME-ZB-01-PL-532-513	First Floor Plan NCH – Cardiology Ward High Level Layout	06/02/12					06/03/12			-					
		Removed By Mercury - NOT REQUIRED FOR RDD (SMALL POWER SHOWN ON NA 400 SERIES DRAWINGS)	MER	B		ME-ZB-01-PL-532-514	First Floor Plan NCH – Cardiology Ward High Le- el Layout	06/02/12					06/03/12			-					
		Removed By Mercury - NOT REQUIRED FOR RDD (SMALL POWER SHOWN ON NA 400 SERIES DRAWINGS)	MER	B		ME-ZB-01-PL-532-515	First Floor Plan NCH – Special Feeds High Le- el Layout	06/02/12					06/03/12			-					
		Removed By Mercury - NOT REQUIRED FOR RDD (SMALL POWER SHOWN ON NA 400 SERIES DRAWINGS)	MER	B		ME-ZB-02-PL-532-510	Second Floor Plan NCH – Anaesthetic Offices/Hospital At Night/ Admin- Support High Level Layout	06/02/12					06/03/12			-					
		Removed By Mercury - NOT REQUIRED FOR RDD (SMALL POWER SHOWN ON NA 400 SERIES DRAWINGS)	MER	B		ME-ZB-02-PL-532-511	Second Floor Plan NCH Day Investigation Unit/ Medical Day Unit High Le- el Layout	06/02/12					06/03/12			-					
		Removed By Mercury - NOT REQUIRED FOR RDD (SMALL POWER SHOWN ON NA 400 SERIES DRAWINGS)	MER	B		ME-ZB-02-PL-532-512	Second Floor Plan NCH ARU High Le- el Layout	06/02/12					06/03/12			-					
		Removed By Mercury - NOT REQUIRED FOR RDD (SMALL POWER SHOWN ON NA 400 SERIES DRAWINGS)	MER	B		ME-ZB-03-PL-532-509	Third Floor Plan NCH Inpatient Wards High Le- el Layout	06/02/12					06/03/12			-					
		Removed By Mercury - NOT REQUIRED FOR RDD (SMALL POWER SHOWN ON NA 400 SERIES DRAWINGS)	MER	B		ME-ZB-03-PL-532-514	Third Floor Plan NCH Inpatient Wards High Level Layout	06/02/12					06/03/12			-					
		Removed By Mercury - NOT REQUIRED FOR RDD (SMALL POWER SHOWN ON NA 400 SERIES DRAWINGS)	MER	B		ME-ZB-03-PL-532-515	Third Floor Plan NCH Inpatient Wards High Le- el Layout	06/02/12					06/03/12			-					
		Removed By Mercury - NOT REQUIRED FOR RDD (SMALL POWER SHOWN ON NA 400 SERIES DRAWINGS)	MER	B		ME-ZB-B1-PL-532-508	Basement Floor Plan NCH Core J High Le- el Layout									-					
		Removed By Mercury - NOT REQUIRED FOR RDD (SMALL POWER SHOWN ON NA 400 SERIES DRAWINGS)	MER	B		ME-ZB-00-PL-532-512	Ground Floor Plan NCH – OPD ELV Systems low le- el Layout	06/02/12					06/03/12			-					
		Removed By Mercury - NOT REQUIRED FOR RDD (SMALL POWER SHOWN ON NA 400 SERIES DRAWINGS)	MER	B		ME-ZB-00-PL-532-514	Ground Floor Plan NCH – OPD ELV Systems low level Layout	06/02/12					06/03/12			-					
		Removed By Mercury - NOT REQUIRED FOR RDD (SMALL POWER SHOWN ON NA 400 SERIES DRAWINGS)	MER	B		ME-ZB-00-PL-532-515	Ground Floor Plan NCH – OPD ELV Systems low le- el Layout	06/02/12					06/03/12			-					
		Removed By Mercury - NOT REQUIRED FOR RDD (SMALL POWER SHOWN ON NA 400 SERIES DRAWINGS)	MER	B		ME-ZB-01-PL-532-513	First Floor Plan NCH – Cardiology Ward ELV Systems low le- el Layout	06/02/12					06/03/12			-					
		Removed By Mercury - NOT REQUIRED FOR RDD (SMALL POWER SHOWN ON NA 400 SERIES DRAWINGS)	MER	B		ME-ZB-01-PL-532-514	First Floor Plan NCH – Cardiology Ward ELV Systems low level Layout	06/02/12					06/03/12			-					

Drawing Information

31

BCL-AC-XX-SH-001

1st Submission

2nd Submission

			Action By	Zone	Drawing Number	Drawing Title	Date Required from Consultant	Date Submitted by Consultant	Document Revision	Planned Date to be Submitted to Board	Date Submitted to Board	BMCE Transmittal No	Date Response Required from Board	Date Returned from Board	Board Status	Date returned to Consultant	Date Required from Consultant	Date Submitted by Consultant
Item	Submission	Comments																
			MER	B	ME-SZ-03-PL-556-508	Third Floor Plan NCH Inpatient Wards & Ward Support - Layout of Data Outlets	06/02/12	06/03/12	A	07/03/12	06/03/12	BMCE-TRANSMIT-007982	27/03/12	06/07/12	A	12/07/12 BMCE-TRANSMIT-009794		
			MER	B	ME-SZ-03-PL-556-510	Third Floor Plan. NCH Inpatient Wards & Ward Support. Layout of Data Outlets Zone A/Zone B	06/02/12	06/03/12	C	07/03/12	06/03/12	BMCE-TRANSMIT-007982	27/03/12	06/07/12	A	12/07/12 BMCE-TRANSMIT-009794		
			MER	B	ME-SZ-04-PL-556-515	Fourth Floor Plan NCH Psychiatry / DCFP - Layout of Data Outlets	06/02/12		B	07/03/12	26/02/13	BMCE-TRANSMIT-014130 (BMCE-WTRAN-006180)	19/03/13	25/03/13	A	25/05/12 BMCE-TRANSMIT-009075		
		This was issued for information on BMCE-TRANSMIT-018730 19/12/13	MER	B	ME-SZ-B1-PL-556-507	Basement Floor Plan NCH Basement Plan-Sprinkler Tanks - Layout of Data Outlets	06/02/12		A	07/03/12	06/06/12	BMCE-TRANSMIT-009245 (BMCE-WTRAN-003217)	27/06/12	06/07/12	B	18/07/12 BMCE-TRANSMIT-009803		
		This was issued for information on BMCE-TRANSMIT-018730 19/12/13	MER	B	ME-ZB-B1-PL-556-508	Basement Floor Plan NCH Basement Plant-Water Tanks			A		06/06/12	BMCE-TRANSMIT-009245 (BMCE-WTRAN-003217)	27/06/12	06/07/12	B	18/07/12 BMCE-TRANSMIT-009803		
			MER	B	ME-ZB-00-PL-556-512	Ground Floor Plan NCH - OPD Data Comms Layout	06/02/12	06/03/12	A	07/03/12	06/03/12	BMCE-TRANSMIT-007982	27/03/12	06/07/12	A	12/07/12 BMCE-TRANSMIT-009794		
		This was issued for information on BMCE-TRANSMIT-018730 19/12/13	MER	B	ME-ZB-00-PL-556-514	Ground Floor Plan NCH - OPD Data Comms Layout	06/02/12	06/03/12	A	07/03/12	06/03/12	BMCE-TRANSMIT-007982	27/03/12	06/07/12	B	12/07/12 BMCE-TRANSMIT-009794		
		This was issued for information on BMCE-TRANSMIT-018730 19/12/13	MER	B	ME-ZB-00-PL-556-515	Ground Floor Plan NCH - OPD Data Comms Layout	06/02/12	06/03/12	A	07/03/12	06/03/12	BMCE-TRANSMIT-007982	27/03/12	06/07/12	B	12/07/12 BMCE-TRANSMIT-009794		
			MER	B	ME-ZB-01-PL-556-513	First Floor Plan NCH - Cardiology Ward Data Comms Layout	06/02/12	06/03/12	A	07/03/12	06/03/12	BMCE-TRANSMIT-007982	27/03/12	06/07/12	A	12/07/12 BMCE-TRANSMIT-009794		
			MER	B	ME-ZB-01-PL-556-514	First Floor Plan NCH - Cardiology Ward Data Comms Layout	06/02/12	06/03/12	A	07/03/12	06/03/12	BMCE-TRANSMIT-007982	27/03/12	06/07/12	A	12/07/12 BMCE-TRANSMIT-009794		
			MER	B	ME-ZB-01-PL-556-515	First Floor Plan NCH - Special Feeds Data Comms Layout	06/02/12	06/03/12	A	07/03/12	06/03/12	BMCE-TRANSMIT-007982	27/03/12	06/07/12	A	12/07/12 BMCE-TRANSMIT-009794		
			MER	B	ME-ZB-02-PL-556-510	Second Floor Plan NCH Anaesthetic Offices/Hospital At Night/ Admin Support Data Comms Layout	06/02/12	06/03/12	A	07/03/12	06/03/12	BMCE-TRANSMIT-007982	27/03/12	06/07/12	A	12/07/12 BMCE-TRANSMIT-009794		
			MER	B	ME-ZB-02-PL-556-511	Second Floor Plan NCH Day Investigation Unit/ Medical Day Unit Data Comms Layout	06/02/12	06/03/12	A	07/03/12	06/03/12	BMCE-TRANSMIT-007982	27/03/12	06/07/12	A	12/07/12 BMCE-TRANSMIT-009794		
		This was issued for information on BMCE-TRANSMIT-018730 19/12/13	MER	B	ME-ZB-02-PL-556-512	Second Floor Plan NCH ARU Data Comms Layout	06/02/12	06/03/12	A	07/03/12	06/03/12	BMCE-TRANSMIT-007982	27/03/12	06/07/12	B	12/07/12 BMCE-TRANSMIT-009794		
			MER	B	ME-ZB-03-PL-556-509	Third Floor Plan NCH Inpatient Wards Data Comms Layout	06/02/12	06/03/12	A	07/03/12	06/03/12	BMCE-TRANSMIT-007982	27/03/12	06/07/12	A	12/07/12 BMCE-TRANSMIT-009794		
			MER	B	ME-ZB-03-PL-556-514	Third Floor Plan NCH Inpatient Wards Data Comms Layout	06/02/12	06/03/12	A	07/03/12	06/03/12	BMCE-TRANSMIT-007982	27/03/12	06/07/12	A	12/07/12 BMCE-TRANSMIT-009794		
		This was issued for information on BMCE-TRANSMIT-018730 19/12/13	MER	B	ME-ZB-03-PL-556-515	Third Floor Plan NCH Inpatient Wards Data Comms Layout	06/02/12	06/03/12	A	07/03/12	06/03/12	BMCE-TRANSMIT-007982	27/03/12	06/07/12	B	12/07/12 BMCE-TRANSMIT-009794		
		DUPLICATE ON THE RDD SCHEDULE	MER	B	ME-ZB-B1-PL-556-508	Basement Floor Plan NCH Core J Data Comms Layout	06/02/12			07/03/12			-					
		This was issued for information on BMCE-TRANSMIT-018891 18/12/13	MER	B	ME-SZ-04-PL-556-103	Fourth Floor Plan - plantroom 41 Layout of Data Outlets Zone B/A			A	10/09/12	10/09/12	BMCE-TRANSMIT-010869 (BMCE-WRTAN-003929)	01/10/12	18/09/12	B	01/10/12 BMCE-TRANSMIT-011253		
		This was issued for information on BMCE-TRANSMIT-018891 18/12/13	MER	B	ME-SZ-04-PL-556-104	Fourth Floor Plan - plantroom 41 Layout of Data Outlets Zone B/A			A	10/09/12	10/09/12	BMCE-TRANSMIT-010869 (BMCE-WRTAN-003929)	01/10/12	18/09/12	B	01/10/12 BMCE-TRANSMIT-011253		
	BMS	Removed By Mercury - NOT REQUIRED FOR RDD (PART OF BMS DETAIL DESIGN)	MER	B	ME-ZB-00-PL-660-512	Ground Floor Plan NCH - OPD BMS Layout	06/02/12			06/03/12			-					
		Removed By Mercury - NOT REQUIRED FOR RDD (PART OF BMS DETAIL DESIGN)	MER	B	ME-ZB-00-PL-660-514	Ground Floor Plan NCH - OPD BMS Layout	06/02/12			06/03/12			-					
		Removed By Mercury - NOT REQUIRED FOR RDD (PART OF BMS DETAIL DESIGN)	MER	B	ME-ZB-00-PL-660-515	Ground Floor Plan NCH - OPD BMS Layout	06/02/12			06/03/12			-					
		Removed By Mercury - NOT REQUIRED FOR RDD (PART OF BMS DETAIL DESIGN)	MER	B	ME-ZB-01-PL-660-513	First Floor Plan NCH - Cardiology Ward BMS Layout	06/02/12			06/03/12			-					
		Removed By Mercury - NOT REQUIRED FOR RDD (PART OF BMS DETAIL DESIGN)	MER	B	ME-ZB-01-PL-660-514	First Floor Plan NCH - Cardiology Ward BMS Layout	06/02/12			06/03/12			-					
		Removed By Mercury - NOT REQUIRED FOR RDD (PART OF BMS DETAIL DESIGN)	MER	B	ME-ZB-01-PL-660-515	First Floor Plan NCH - Special Feeds BMS Layout	06/02/12			06/03/12			-					
		Removed By Mercury - NOT REQUIRED FOR RDD (PART OF BMS DETAIL DESIGN)	MER	B	ME-ZB-02-PL-660-510	Second Floor Plan NCH Anaesthetic Offices/Hospital At Night/ Admin Support BMS Layout	06/02/12			06/03/12			-					
		Removed By Mercury - NOT REQUIRED FOR RDD (PART OF BMS DETAIL DESIGN)	MER	B	ME-ZB-02-PL-660-511	Second Floor Plan NCH Day Investigation Unit/ Medical Day Unit BMS Layout	06/02/12			06/03/12			-					
		Removed By Mercury - NOT REQUIRED FOR RDD (PART OF BMS DETAIL DESIGN)	MER	B	ME-ZB-02-PL-660-512	Second Floor Plan NCH ARU BMS Layout	06/02/12			06/03/12			-					
		Removed By Mercury - NOT REQUIRED FOR RDD (PART OF BMS DETAIL DESIGN)	MER	B	ME-ZB-03-PL-660-509	Third Floor Plan NCH Inpatient Wards BMS Layout	06/02/12			06/03/12			-					

Drawing Information

31 BCL-AC-XX-SH-001

1st Submission2nd Submission

			Action By	Zone	Drawing Number	Drawing Title	Date Required from Consultant	Date Submitted by Consultant	Document Revision	Planned Date to be Submitted to Board	Date Submitted to Board	BMCE Transmittal No	Date Response Required from Board	Date Returned from Board	Board Status	Date returned to Consultant	Date Required from Consultant	Date Submitted by Consultant
Item	Submission	Comments																
			MER	B	ME-ZB-01-PL-H512-002	Medical Gas Installation, Level 1, Zone B - AGSS			1		29/05/12	BMCE-TRANSMIT-009127 (BMCE-WTRAN-003174)	19/06/12	24/09/12	C	27/09/12 BMCE-TRANSMIT-011196		
			MER	B	ME-ZB-02-PL-H512-001	Medical Gas Installation, Level 2, Zone B			1		29/05/12	BMCE-TRANSMIT-009123 (BMCE-WTRAN-003172)	19/06/12	24/09/12	C	27/09/12 BMCE-TRANSMIT-011202		
			MER	B	ME-ZB-02-PL-H512-002	Medical Gas Installation, Level 2, Zone B - AGSS			1		29/05/12	BMCE-TRANSMIT-009123 (BMCE-WTRAN-003172)	19/06/12	24/09/12	C	27/09/12 BMCE-TRANSMIT-011202		
		Issued for information on BMCE-TRANSMIT-019817 31/03/14	MER	B	ME-ZB-03-PL-H512-001	Medical Gas Installation, Level 3, Zone B			1		29/05/12	BMCE-TRANSMIT-009127 (BMCE-WTRAN-003173)	19/06/12	01/10/12	C	27/09/12 BMCE-TRANSMIT-011196		
			MER	B	ME-ZB-03-PL-H512-002	Medical Gas Installation, Level 3, Zone B - AGSS			1		29/05/12	BMCE-TRANSMIT-009127 (BMCE-WTRAN-003173)	19/06/12	01/10/12	C	27/09/12 BMCE-TRANSMIT-011196		
			MER	B	ME-ZB-04-PL-H512-001	Medical Gas Installation, Level 4, Zone B			1		29/05/12	BMCE-TRANSMIT-009122 (BMCE-WTRAN-003171)	19/06/12	01/10/12	C	04/10/12 BMCE-TRANSMIT-011324		
			MER	B	ME-ZB-04-PL-H512-002	Medical Gas Installation, Level 4, Zone B - AGSS			1		29/05/12	BMCE-TRANSMIT-009122 (BMCE-WTRAN-003171)	19/06/12	01/10/12	C	04/10/12 BMCE-TRANSMIT-011324		
	Medical Gases	Removed By Mercury - NOT REQUIRED FOR RDD (PART OF BMS DETAIL DESIGN)	MER	B	ME-ZB-B1-PL-660-508	Basement Floor Plan NCH Core J Layout							-					
		Removed By Mercury - NOT REQUIRED FOR RDD (PART OF BMS DETAIL DESIGN)	MER	B	ME-ZB-00-PL-512-512	Ground Floor Plan NCH - OPD Medical Gases Layout	06/02/12			06/03/12			-					
		Removed By Mercury - NOT REQUIRED FOR RDD (PART OF BMS DETAIL DESIGN)	MER	B	ME-ZB-00-PL-512-514	Ground Floor Plan NCH - OPD Medical Gases Layout	06/02/12			06/03/12			-					
		Removed By Mercury - NOT REQUIRED FOR RDD (PART OF BMS DETAIL DESIGN)	MER	B	ME-ZB-00-PL-512-515	Ground Floor Plan NCH - OPD Medical Gases Layout	06/02/12			06/03/12			-					
		Removed By Mercury - NOT REQUIRED FOR RDD (PART OF BMS DETAIL DESIGN)	MER	B	ME-ZB-01-PL-512-513	First Floor Plan NCH - Cardiology Ward Medical Gases Layout	06/02/12			06/03/12			-					
		Removed By Mercury - NOT REQUIRED FOR RDD (PART OF BMS DETAIL DESIGN)	MER	B	ME-ZB-01-PL-512-514	First Floor Plan NCH - Cardiology Ward Medical Gases Layout	06/02/12			06/03/12			-					
		Removed By Mercury - NOT REQUIRED FOR RDD (PART OF BMS DETAIL DESIGN)	MER	B	ME-ZB-01-PL-512-515	First Floor Plan NCH - Special Feeds Medical Gases Layout	06/02/12			06/03/12			-					
		Removed By Mercury - NOT REQUIRED FOR RDD (PART OF BMS DETAIL DESIGN)	MER	B	ME-ZB-02-PL-512-510	Second Floor Plan NCH - Anaesthetic Offices/Hospital At Night/ Admin Support Medical Gases Layout	06/02/12			06/03/12			-					
		Removed By Mercury - NOT REQUIRED FOR RDD (PART OF BMS DETAIL DESIGN)	MER	B	ME-ZB-02-PL-512-511	Second Floor Plan NCH Day Investigation Unit/ Medical Day Unit Medical Gases Layout	06/02/12			06/03/12			-					
		Removed By Mercury - NOT REQUIRED FOR RDD (PART OF BMS DETAIL DESIGN)	MER	B	ME-ZB-02-PL-512-512	Second Floor Plan NCH ARU Medical Gases Layout	06/02/12			06/03/12			-					
		Removed By Mercury - NOT REQUIRED FOR RDD (PART OF BMS DETAIL DESIGN)	MER	B	ME-ZB-03-PL-512-509	Third Floor Plan NCH Inpatient Wards Medical Gases Layout	06/02/12			06/03/12			-					
		Removed By Mercury - NOT REQUIRED FOR RDD (PART OF BMS DETAIL DESIGN)	MER	B	ME-ZB-03-PL-512-514	Third Floor Plan NCH Inpatient Wards Medical Gases Layout	06/02/12			06/03/12			-					
		Removed By Mercury - NOT REQUIRED FOR RDD (PART OF BMS DETAIL DESIGN)	MER	B	ME-ZB-03-PL-512-515	Third Floor Plan NCH Inpatient Wards Medical Gases Layout	06/02/12			06/03/12			-					
		Removed By Mercury - NOT REQUIRED FOR RDD (PART OF BMS DETAIL DESIGN)	MER	B	ME-ZB-B1-PL-512-508	Basement Floor Plan NCH Core J Medical Gases Layout							-					
	FIRE DETECTION & SMOKE CONTROL		MER	B	ME-SZ-00-PL-572-513	Ground Floor Plan NCH - OPD Fire Detection & Smoke Control Layout	06/02/12	06/03/12	A	07/03/12	06/03/12	BMCE-TRANSMIT-007983	27/03/12	11/05/12	A	21/05/12 BMCE-TRANSMIT-008961		
		This was issued for information on BMCE-TRANSMIT-018730 19/12/13	MER	B	ME-SZ-01-PL-572-516	First Floor Plan NCH - Critical Care (PICU) Fire Detection Layout Zone A / Zone B (Note: Zone A submitted 31/1/12 BMCE Transmit 007462)		06/03/12	C	07/03/12	06/03/12	BMCE-TRANSMIT-007983	27/03/12	11/05/12	B	21/05/12 BMCE-TRANSMIT-008961		
		This was issued for information on BMCE-TRANSMIT-018730 19/12/13	MER	B	ME-SZ-01-PL-572-519	First Floor Plan NCH Critical Care (PICU), Fire Detection & Smoke Control Layout	06/02/12	06/03/12	A	07/03/12	06/03/12	BMCE-TRANSMIT-007983	27/03/12	11/05/12	B	21/05/12 BMCE-TRANSMIT-008961		
			MER	B	ME-SZ-01-PL-572-520	First Floor Plan, NCH Medical Day Unit, Fire Detection Layout Zone B	06/02/12	06/03/12	A	07/03/12	06/03/12	BMCE-TRANSMIT-007983	27/03/12	11/05/12	A	21/05/12 BMCE-TRANSMIT-008961		
		Issued for information only on BMCE-TRANSMIT-019333 07/02/14	MER	B	ME-SZ-02-PL-572-515	Second Floor Plan, NSGH/NCH Aseptic Suite, Fire Detection & Smoke Control Layout	06/02/12	06/03/12	A	07/03/12	06/03/12	BMCE-TRANSMIT-007983	27/03/12	11/05/12	C	21/05/12 BMCE-TRANSMIT-008961		
		This was issued for information on BMCE-TRANSMIT-018730 19/12/13	MER	B	ME-SZ-03-PL-572-508	Third Floor Plan NCH Inpatient Wards & Ward Support, Fire Detection & Smoke Control Layout	06/02/12	06/03/12	A	07/03/12	06/03/12	BMCE-TRANSMIT-007983	27/03/12	11/05/12	B	21/05/12 BMCE-TRANSMIT-008961		
		This was issued for information on BMCE-TRANSMIT-018730 19/12/13	MER	B	ME-SZ-03-PL-572-510	Third Floor Plan NCH Inpatient Wards Fire Detection Layout Zone A / Zone B (Note: Zone A submitted 31/1/12 BMCE Transmit 007462)		06/03/12	C		06/03/12	BMCE-TRANSMIT-007983	27/03/12	11/05/12	B	21/05/12 BMCE-TRANSMIT-008961		
		REMOVED BY MERCURY	MER	B	ME-ZC-04-PL-572-515	Fourth Floor Plan NCH Psychiatry / DCFP - Fire Detection & Smoke Control Layout	06/02/12			07/03/12								

Drawing Information

31

BCL-AC-XX-SH-001

1st Submission

2nd Submission

			Action By	Zone	Drawing Number	Drawing Title	Date Required from Consultant	Date Submitted by Consultant	Document Revision	Planned Date to be Submitted to Board	Date Submitted to Board	BMCE Transmittal No	Date Response Required from Board	Date Returned from Board	Board Status	Date returned to Consultant	Date Required from Consultant	Date Submitted by Consultant
Item	Submission	Comments																
		This was issued for information on BMCE-TRANSMIT-018730 19/12/13	MER	B	ME-ZB-01-PL-572-513	First Floor Plan NCH - Cardiology Ward Fire Detection & Smoke Control Layout	06/02/12	06/03/12	A	07/03/12	06/03/12	BMCE-TRANSMIT-007983	27/03/12	11/05/12	B	21/05/12 BMCE-TRANSMIT-008961		
			MER	B	ME-ZB-01-PL-572-514	First Floor Plan NCH - Cardiology Ward Fire Detection & Smoke Control Layout	06/02/12	06/03/12	A	07/03/12	06/03/12	BMCE-TRANSMIT-007983	27/03/12	11/05/12	A	21/05/12 BMCE-TRANSMIT-008961		
		This was issued for information on BMCE-TRANSMIT-018730 19/12/13	MER	B	ME-ZB-01-PL-572-515	First Floor Plan NCH - Special Feeds Fire Detection & Smoke Control Layout	06/02/12	06/03/12	A	07/03/12	06/03/12	BMCE-TRANSMIT-007983	27/03/12	11/05/12	B	21/05/12 BMCE-TRANSMIT-008961		
			MER	B	ME-ZB-02-PL-572-510	Second Floor Plan NCH Anaesthetic Offices/Hospital At Night/ Admin Support Fire Detection & Smoke Control Layout	06/02/12	06/03/12	A	07/03/12	06/03/12	BMCE-TRANSMIT-007983	27/03/12	11/05/12	A	21/05/12 BMCE-TRANSMIT-008961		
		This was issued for information on BMCE-TRANSMIT-018730 19/12/13	MER	B	ME-ZB-02-PL-572-511	Second Floor Plan NCH Day Investigation Unit/ Medical Day Unit Fire Detection & Smoke Control Layout	06/02/12	06/03/12	A	07/03/12	06/03/12	BMCE-TRANSMIT-007983	27/03/12	11/05/12	B	21/05/12 BMCE-TRANSMIT-008961		
		This was issued for information on BMCE-TRANSMIT-018730 19/12/13	MER	B	ME-ZB-02-PL-572-512	Second Floor Plan NCH ARU Fire Detection & Smoke Control Layout	06/02/12	06/03/12	A	07/03/12	06/03/12	BMCE-TRANSMIT-007983	27/03/12	11/05/12	B	21/05/12 BMCE-TRANSMIT-008961		
			MER	B	ME-ZB-03-PL-572-509	Third Floor Plan NCH Inpatient Wards Fire Detection & Smoke Control Layout	06/02/12	06/03/12	A	07/03/12	06/03/12	BMCE-TRANSMIT-007983	27/03/12	11/05/12	A	21/05/12 BMCE-TRANSMIT-008961		
		This was issued for information on BMCE-TRANSMIT-018730 19/12/13	MER	B	ME-ZB-03-PL-572-514	Third Floor Plan NCH Inpatient Wards Fire Detection & Smoke Control Layout	06/02/12	06/03/12	A	07/03/12	06/03/12	BMCE-TRANSMIT-007983	27/03/12	11/05/12	B	21/05/12 BMCE-TRANSMIT-008961		
		This was issued for information on BMCE-TRANSMIT-018730 19/12/13	MER	B	ME-ZB-03-PL-572-515	Third Floor Plan NCH Inpatient Wards Fire Detection & Smoke Control Layout	06/02/12	06/03/12	A	07/03/12	06/03/12	BMCE-TRANSMIT-007983	27/03/12	11/05/12	B	21/05/12 BMCE-TRANSMIT-008961		
		Removed by Mercury		B	ME-ZB-B1-PL-572-508	Basement Floor Plan NCH Core J Fire Detection & Smoke Control Layout							-					
		This was issued for information on BMCE-TRANSMIT-018730 19/12/13	MER	B	ME-ZB-B1-PL-572-508	Basement Floor Plan NCH Basement Plant-Water tanks. Fire Detection & Smoke Control Layout	06/02/12		A	07/03/12	07/06/12	BMCE-TRANSMIT-009266 (BMCE-WTRAN-003230)	28/06/12	10/07/12	B	17/07/12 BMCE-TRANSMIT-009876		
		This was issued for information on BMCE-TRANSMIT-018891 18/12/13	MER	B	ME-SZ-04-PL-572-103	Fourth Floor Plan - Plantroom 41 Fire Detection Layout			A	10/09/12	10/09/12	BMCE-TRANSMIT-010869 (BMCE-WTRAN-003929)	01/10/12	18/09/12	B	01/10/12 BMCE-TRANSMIT-011253		
		This was issued for information on BMCE-TRANSMIT-018891 18/12/13	MER	B	ME-SZ-04-PL-572-104	Fourth Floor Plan - Plantroom 41 Fire Detection Layout			A	10/09/12	10/09/12	BMCE-TRANSMIT-010869 (BMCE-WTRAN-003929)	01/10/12	18/09/12	B	01/10/12 BMCE-TRANSMIT-011253		
		This was issued for information on BMCE-TRANSMIT-018891 18/12/13	MER	B	ME-SZ-04-PL-572-105	Fourth Floor Plan - Plantroom 41 Fire Detection Layout			A	10/09/12	10/09/12	BMCE-TRANSMIT-010869 (BMCE-WTRAN-003929)	01/10/12	18/09/12	B	01/10/12 BMCE-TRANSMIT-011253		
		This was issued for information on BMCE-TRANSMIT-018891 18/12/13	MER	B	ME-SZ-04-PL-572-106	Fourth Floor Plan - Plantroom 41 Fire Detection Layout			A	10/09/12	10/09/12	BMCE-TRANSMIT-010869 (BMCE-WTRAN-003929)	01/10/12	18/09/12	B	01/10/12 BMCE-TRANSMIT-011253		
Pneumatic Tube Distribution		Drawing superseded by ME-XX-00-PL-569-001	MER	B	ME-ZB-00-PL-569-001	Ground Floor Plan Pneumatic Tube Distribution	06/02/12	06/03/12	A	07/03/12	06/03/12	BMCE-TRANSMIT-007984 (BMCE-WTRAN-002684)	27/03/12	09/05/12	B	10/05/12 BMCE-TRANSMIT-008767		
			MER	B	ME-ZB-01-PL-569-002	First Floor Plan Pneumatic Tube Distribution	06/02/12	06/03/12	A	07/03/12	06/03/12	BMCE-TRANSMIT-007984 (BMCE-WTRAN-002684)	27/03/12	09/05/12	A	10/05/12 BMCE-TRANSMIT-008767		
			MER	B	ME-ZB-02-PL-569-003	Second Floor Plan Pneumatic Tube Distribution	06/02/12	06/03/12	A	07/03/12	06/03/12	BMCE-TRANSMIT-007984 (BMCE-WTRAN-002684)	27/03/12	09/05/12	A	10/05/12 BMCE-TRANSMIT-008767		
			MER	B	ME-ZB-03-PL-569-004	Third Floor Plan Pneumatic Tube Distribution	06/02/12	06/03/12	A	07/03/12	06/03/12	BMCE-TRANSMIT-007984 (BMCE-WTRAN-002684)	27/03/12	09/05/12	A	10/05/12 BMCE-TRANSMIT-008767		
Sprinkler System			MER	B	ME-ZB-B1-PL-575-316	Basement Level Void Layout			B		07/06/12	BMCE-TRANSMIT-009260 (BMCE-WTRAN-003224)	28/06/12	06/07/12	A	18/07/12 BMCE-TRANSMIT-009899		
		Issued for information on BMCE-TRANSMIT-019712 18/03/14	MER	B	ME-ZB-00-PL-575-316	Ground floor Void Layout	06/02/12	06/03/12	A	07/03/12	06/03/12	BMCE-TRANSMIT-007979	27/03/12	12/04/12	B	20/04/12 BMCE-TRANSMIT-008462		
		Issued for information on BMCE-TRANSMIT-019712 18/03/14	MER	B	ME-ZB-00-PL-575-317	Ground Floor Ceiling Layout	06/02/12	06/03/12	A	07/03/12	06/03/12	BMCE-TRANSMIT-007979	27/03/12	12/04/12	B	20/04/12 BMCE-TRANSMIT-008462		
		Issued for information on BMCE-TRANSMIT-019712 18/03/14	MER	B	ME-ZB-01-PL-575-316	First Floor Void Layout	06/02/12	06/03/12	A	07/03/12	06/03/12	BMCE-TRANSMIT-007979	27/03/12	12/04/12	B	20/04/12 BMCE-TRANSMIT-008462		
		Issued for information on BMCE-TRANSMIT-019712 18/03/14	MER	B	ME-ZB-01-PL-575-317	First Floor Ceiling Layout	06/02/12	06/03/12	A	07/03/12	06/03/12	BMCE-TRANSMIT-007979	27/03/12	12/04/12	B	20/04/12 BMCE-TRANSMIT-008462		
		Issued for information on BMCE-TRANSMIT-019712 18/03/14	MER	B	ME-ZB-02-PL-575-316	Second Floor Void Layout	06/02/12	06/03/12	A	07/03/12	06/03/12	BMCE-TRANSMIT-007979	27/03/12	12/04/12	B	20/04/12 BMCE-TRANSMIT-008462		
		Issued for information on BMCE-TRANSMIT-019712 18/03/14	MER	B	ME-ZB-02-PL-575-317	Second Floor Ceiling Layout	06/02/12	06/03/12	A	07/03/12	06/03/12	BMCE-TRANSMIT-007979	27/03/12	12/04/12	B	20/04/12 BMCE-TRANSMIT-008462		
			MER	B	ME-ZB-03-PL-575-316	Third Floor Void Layout	06/02/12	06/03/12	A	07/03/12	06/03/12	BMCE-TRANSMIT-007979	27/03/12	12/04/12	A	20/04/12 BMCE-TRANSMIT-008462		
			MER	B	ME-ZB-03-PL-575-317	Third floor Ceiling Layout	06/02/12	06/03/12	A	07/03/12	06/03/12	BMCE-TRANSMIT-007979	27/03/12	12/04/12	A	20/04/12 BMCE-TRANSMIT-008462		
		Issued for information on BMCE-TRANSMIT-019712 18/03/14	MER	B	ME-ZB-04-PL-575-316	Fourth Floor Void Layout			A	10/09/12	10/09/12	BMCE-TRANSMIT-010869 (BMCE-WTRAN-003929)	01/10/12	18/09/12	B	01/10/12 BMCE-TRANSMIT-011253		

			Action By		Zone	Drawing Number	Drawing Title	Date Required from Consultant	Date Submitted by Consultant	Document Revision	Planned Date to be Submitted to Board	Date Submitted to Board	BMCE Transmittal No	Date Response Required from Board	Date Returned from Board	Board Status	Date returned to Consultant	Date Required from Consultant	Date Submitted by Consultant
Item	Submission	Comments																	
			MER	B	ME-ZB-02-PL-571-511	Second Floor Plan NCH Day Investigation Unit Medical Day Unit CCTV & Door Access Layout	06/02/12	06/03/12	A	07/03/12	06/03/12	BMCE-TRANSMIT-007978	27/03/12	10/07/12	A	19/07/12 BMCE-TRANSMIT-009918			
	This was issued for information on BMCE-TRANSMIT-018730 19/12/13		MER	B	ME-ZB-02-PL-571-512	Second Floor Plan NCH Acute Receiving Unit CCTV & Door Access Layout	06/02/12	06/03/12	A	07/03/12	06/03/12	BMCE-TRANSMIT-007978	27/03/12	10/07/12	B	19/07/12 BMCE-TRANSMIT-009918			
	This was issued for information on BMCE-TRANSMIT-018730 19/12/13		MER	B	ME-SZ-02-PL-571-515	Second Floor Plan NSGH/NCH Aseptic Suite CCTV & Door Access Layout	06/02/12		A	07/03/12	06/03/12	BMCE-TRANSMIT-007978	27/03/12	10/07/12	B	19/07/12 BMCE-TRANSMIT-009918			
			MER	B	ME-SZ-03-PL-571-508	Third Floor Plan NCH Inpatient Wards & Support CCTV Door & Access Layout	06/02/12	06/03/12	A	07/03/12	06/03/12	BMCE-TRANSMIT-007978	27/03/12	10/07/12	A	19/07/12 BMCE-TRANSMIT-009918			
			MER	B	ME-ZB-03-PL-571-509	Third Floor Plan NCH Inpatient Wards & Support CCTV Door & Access Layout	06/02/12	06/03/12	A	07/03/12	06/03/12	BMCE-TRANSMIT-007978	27/03/12	10/07/12	A	19/07/12 BMCE-TRANSMIT-009918			
			MER	B	ME-SZ-03-PL-571-510	Third Floor Plan NCH Inpatient Wards & Support CCTV Door & Access Layout	06/02/12	06/03/12	C	07/03/12	06/03/12	BMCE-TRANSMIT-007978	27/03/12	10/07/12	A	19/07/12 BMCE-TRANSMIT-009918			
	This was issued for information on BMCE-TRANSMIT-018730 19/12/13		MER	B	ME-ZB-03-PL-571-514	Third Floor Plan NCH Inpatient Wards & Support CCTV Door & Access Layout	06/02/12	06/03/12	A	07/03/12	06/03/12	BMCE-TRANSMIT-007978	27/03/12	10/07/12	B	19/07/12 BMCE-TRANSMIT-009918			
			MER	B	ME-ZB-03-PL-571-515	Third Floor Plan NCH Inpatient Wards & Support CCTV Door & Access Layout	06/02/12	06/03/12	A	07/03/12	06/03/12	BMCE-TRANSMIT-007978	27/03/12	10/07/12	A	19/07/12 BMCE-TRANSMIT-009918			
			MER	B	ME-SZ-04-PL-571-103	Fourth Floor Plan - Planroom 41 CCTV & Door Access Layout Zone B/A			A	10/09/12	10/09/12	BMCE-TRANSMIT-010869 (BMCE-WTRAN-003929)	01/10/12	18/09/12	A	01/10/12 BMCE-TRANSMIT-011253			
			MER	B	ME-SZ-04-PL-571-104	Fourth Floor Plan - Planroom 41 CCTV & Door Access Layout Zone B/A			A	10/09/12	10/09/12	BMCE-TRANSMIT-010869 (BMCE-WTRAN-003929)	01/10/12	18/09/12	A	01/10/12 BMCE-TRANSMIT-011253			
	This was issued for information on BMCE-TRANSMIT-018891 18/12/13		MER	B	ME-SZ-04-PL-571-105	Fourth Floor Plan - Planroom 41 CCTV & Door Access Layout Zone B/A			A	10/09/12	10/09/12	BMCE-TRANSMIT-010869 (BMCE-WTRAN-003929)	01/10/12	18/09/12	B	01/10/12 BMCE-TRANSMIT-011253			
	This was issued for information on BMCE-TRANSMIT-018891 18/12/13		MER	B	ME-SZ-04-PL-571-106	Fourth Floor Plan - Planroom 41 CCTV & Door Access Layout Zone B/A			A	10/09/12	10/09/12	BMCE-TRANSMIT-010869 (BMCE-WTRAN-003929)	01/10/12	18/09/12	B	01/10/12 BMCE-TRANSMIT-011253			
Nurses Call	This Was issued for information on BMCE-TRANSMIT-018730 09/12/13		MER	B	ME-SZ-00-PL-538-513	Ground Floor Plan NCH OPD Nurse Call layout	06/02/12	06/03/12	A	07/03/12	06/03/12	BMCE-TRANSMIT-007980 (BMCE-WTRAN-002678)	27/03/12	11/07/12	B	18/07/12 BMCE-TRANSMIT-009890			
	Issued for information on BMCE-TRANSMIT-019288 04/02/14		MER	B	ME-ZB-00-PL-538-512	Ground Floor Plan NCH OPD Lung Function Suite. Nurse Call Layout	06/02/12	06/03/12	A	07/03/12	06/03/12	BMCE-TRANSMIT-007980 (BMCE-WTRAN-002678)	27/03/12	11/07/12	C	18/07/12 BMCE-TRANSMIT-009890			
			MER	B	ME-ZB-00-PL-538-514	Ground Floor Plan NCH OPD Nurse Call layout	06/02/12	06/03/12	A	07/03/12	06/03/12	BMCE-TRANSMIT-007980 (BMCE-WTRAN-002678)	27/03/12	11/07/12	C	18/07/12 BMCE-TRANSMIT-009890			
			MER	B	ME-ZB-00-PL-538-515	Ground Floor Plan NCH OPD Nurse Call layout	06/02/12	06/03/12	A	07/03/12	06/03/12	BMCE-TRANSMIT-007980 (BMCE-WTRAN-002678)	27/03/12	11/07/12	C	18/07/12 BMCE-TRANSMIT-009890			
			MER	B	ME-ZB-01-PL-538-513	First Floor Plan NCH Cardiology Ward Nurse Call Layout	06/02/12	06/03/12	A	07/03/12	06/03/12	BMCE-TRANSMIT-007980 (BMCE-WTRAN-002678)	27/03/12	11/07/12	C	18/07/12 BMCE-TRANSMIT-009890			
			MER	B	ME-ZB-01-PL-538-514	First Floor Plan NCH Cardiology Ward Nurse Call Layout	06/02/12	06/03/12	A	07/03/12	06/03/12	BMCE-TRANSMIT-007980 (BMCE-WTRAN-002678)	27/03/12	11/07/12	C	18/07/12 BMCE-TRANSMIT-009890			
			MER	B	ME-SZ-01-PL-538-516	First Floor Plan NCH Critical Care (PICU) Nurse Call Layout. Zone A/Zone B	06/02/12	06/03/12	C	07/03/12	06/03/12	BMCE-TRANSMIT-007980 (BMCE-WTRAN-002678)	27/03/12	11/07/12	C	18/07/12 BMCE-TRANSMIT-009890			
	This was issued for information on BMCE-TRANSMIT-018891 18/12/13		MER	B	ME-SZ-01-PL-538-519	First Floor Plan NCH Critical Care (PICU) Nurse Call Layout	06/02/12	06/03/12	A	07/03/12	06/03/12	BMCE-TRANSMIT-007980 (BMCE-WTRAN-002678)	27/03/12	11/07/12	B	18/07/12 BMCE-TRANSMIT-009890			
			MER	B	ME-SZ-01-PL-538-520	First Floor Plan Medical Day Unit - Nurse Call Layout	06/02/12	06/03/12	A	07/03/12	06/03/12	BMCE-TRANSMIT-007980 (BMCE-WTRAN-002678)	27/03/12	11/07/12	C	18/07/12 BMCE-TRANSMIT-009890			
			MER	B	ME-ZB-02-PL-538-511	Second Floor Plan NCH Day Investigation Unit Medical day Unit Nurse Call Layout	06/02/12	06/03/12	A	07/03/12	06/03/12	BMCE-TRANSMIT-007980 (BMCE-WTRAN-002678)	27/03/12	11/07/12	C	18/07/12 BMCE-TRANSMIT-009890			
			MER	B	ME-ZB-02-PL-538-512	Second Floor Plan NCH Acute Receiving Unit Nurse Call Layout	06/02/12	06/03/12	A	07/03/12	06/03/12	BMCE-TRANSMIT-007980 (BMCE-WTRAN-002678)	27/03/12	11/07/12	C	18/07/12 BMCE-TRANSMIT-009890			
	This was issued for information on BMCE-TRANSMIT-018730 19/12/13		MER	B	ME-SZ-02-PL-538-515	Second Floor Plan NSGH/NCH Aseptic Suite Unit Nurse Call Layout	06/02/12	06/03/12	A	07/03/12	06/03/12	BMCE-TRANSMIT-007980 (BMCE-WTRAN-002678)	27/03/12	11/07/12	B	18/07/12 BMCE-TRANSMIT-009890			
	This was previously given a status A on 21/09/12 Please refer to BMCE-TRANSMIT-011091		MER	B	ME-SZ-03-PL-538-508	Third Floor Plan NCH Inpatient Wards & Ward Support Nurse Call Layout	06/02/12	06/03/12	A	07/03/12	06/03/12	BMCE-TRANSMIT-007980 (BMCE-WTRAN-002678)	27/03/12	11/07/12	C	18/07/12 BMCE-TRANSMIT-009890			
			MER	B	ME-ZB-03-PL-538-509	Third Floor Plan NCH Inpatient Wards & Ward Support Nurse Call Layout	06/02/12	06/03/12	A	07/03/12	06/03/12	BMCE-TRANSMIT-007980 (BMCE-WTRAN-002678)	27/03/12	11/07/12	C	18/07/12 BMCE-TRANSMIT-009890			
	Issued for information on BMCE-TRANSMIT-019288 04/02/14		MER	B	ME-SZ-03-PL-538-510	Third Floor Plan NCH Inpatient Wards & Ward Support Nurse Call Layout. Zone A/Zone B	06/02/12	06/03/12	C	07/03/12	06/03/12	BMCE-TRANSMIT-007980 (BMCE-WTRAN-002678)	27/03/12	11/07/12	C	18/07/12 BMCE-TRANSMIT-009890			
	This drawing is a duplicate of above		MER	B	ME-SZ-03-PL-538-510	Third Floor Plan NCH Inpatient Wards & Ward Support Nurse Call Layout	06/02/12	06/03/12	A	07/03/12	06/03/12	BMCE-TRANSMIT-007980 (BMCE-WTRAN-002678)	27/03/12	11/07/12	C	18/07/12 BMCE-TRANSMIT-009890			
			MER	B	ME-ZB-03-PL-538-515	3rd floor plan Nurse call layout Zone B			A		06/03/12	BMCE-TRANSMIT-001846	27/03/12	11/07/12	C				

Drawing Information

31 BCL-AC-XX-SH-001

1st Submission2nd Submission

			Action By	Zone	Drawing Number	Drawing Title	Date Required from Consultant	Date Submitted by Consultant	Document Revision	Planned Date to be Submitted to Board	Date Submitted to Board	BMCE Transmittal No	Date Response Required from Board	Date Returned from Board	Board Status	Date returned to Consultant	Date Required from Consultant	Date Submitted by Consultant
Item	Submission	Comments																
		This was issued for information on BMCE-TRANSMIT-018797 12/12/13	ZBP	C	ZBP-ZC-01-PL-524-013	Ventilation Layout First	13/07/12		A	17/08/12	30/05/12	BMCE-TRANSMIT-009107 (BMCE-WTRAN-003161)	20/06/12	19/07/12	B	28/07/12 BMCE-TRANSMIT-010043 07/08/12		
			ZBP	C	ZBP-ZC-02-PL-524-023	Ventilation Layout Second	13/07/12		A	17/08/12	21/08/12	BMCE-TRANSMIT-010420 (BMCE-WTRAN-003794) re-issued 20.09.12	11/09/12	01/10/12	A	04/10/12 BMCE-TRANSMIT-011332		
			ZBP	C	ZBP-ZC-03-PL-524-033	Ventilation Layout Third	13/07/12		A	17/08/12	21/08/12	BMCE-TRANSMIT-010420 (BMCE-WTRAN-003794) re-issued 20.09.12	11/09/12	01/10/12	A	04/10/12 BMCE-TRANSMIT-011332		
		This was issued for information on BMCE-TRANSMIT-018797 12/12/13	ZBP	C	ZBP-ZC-04-PL-524-043	Ventilation Layout Fourth	13/07/12		A	17/08/12	21/08/12	BMCE-TRANSMIT-010420 (BMCE-WTRAN-003794) re-issued 20.09.12	11/09/12	01/10/12	A	04/10/12 BMCE-TRANSMIT-011332		
		This was issued for information on BMCE-TRANSMIT-018797 12/12/13	ZBP	C	ZBP-ZC-00-PL-526-003	Environmental StrategyGround	13/07/12		A	17/08/12	29/08/12	BMCE-TRANSMIT-010508 (BMCE-WTRAN-003826)	19/09/12	28/09/12	B	05/10/12 BMCE-TRANSMIT-011389		
			ZBP	C	ZBP-ZC-01-PL-526-013	Environmental Strategy First	13/07/12		A	17/08/12	29/08/12	BMCE-TRANSMIT-010508 (BMCE-WTRAN-003826)	19/09/12	28/09/12	A	05/10/12 BMCE-TRANSMIT-011389		
		This was issued for information on BMCE-TRANSMIT-018797 12/12/13	ZBP	C	ZBP-ZC-02-PL-526-023	Environmental Strategy Second	13/07/12		A	17/08/12	29/08/12	BMCE-TRANSMIT-010508 (BMCE-WTRAN-003826)	19/09/12	28/09/12	B	05/10/12 BMCE-TRANSMIT-011389		
		This was issued for information on BMCE-TRANSMIT-018797 12/12/13	ZBP	C	ZBP-ZC-03-PL-526-033	Environmental Strategy Third	13/07/12		A	17/08/12	29/08/12	BMCE-TRANSMIT-010508 (BMCE-WTRAN-003826)	19/09/12	28/09/12	B	05/10/12 BMCE-TRANSMIT-011389		
		This was issued for information on BMCE-TRANSMIT-018797 12/12/13	ZBP	C	ZBP-ZC-04-PL-526-043	Environmental Strategy Fourth	13/07/12		A	17/08/12	29/08/12	BMCE-TRANSMIT-010508 (BMCE-WTRAN-003826)	19/09/12	28/09/12	B	05/10/12 BMCE-TRANSMIT-011389		
Electrical Services Drawings		This was issued for information on BMCE-TRANSMIT-018797 12/12/13	ZBP	C	ZBP-ZC-00-PL-531-003	Small Power Layout Ground	13/07/12		A	17/08/12	21/08/12	BMCE-TRANSMIT-010405 (BMCE-WTRAN-003785)	11/09/12	27/08/12	B	03/09/12 BMCE-TRANSMIT-010690		
			ZBP	C	ZBP-ZC-01-PL-531-013	Small Power Layout First	13/07/12		A	17/08/12	02/05/12	BMCE-TRANSMIT-008653 (BMCE-WTRAN-002981)	23/05/12	02/08/12	A	23/08/12 BMCE-TRANSMIT-010489		
		This was issued for information on BMCE-TRANSMIT-018797 12/12/13	ZBP	C	ZBP-ZC-02-PL-531-023	Small Power Layout Second	13/07/12		A	17/08/12	21/08/12	BMCE-TRANSMIT-010405 (BMCE-WTRAN-003785)	11/09/12	27/08/12	B	03/09/12 BMCE-TRANSMIT-010690		

BCL-AC-XX-SH-001

2nd Submission

			Action By		Zone	Drawing Number	Drawing Title	Date Required from Consultant	Date Submitted by Consultant	Document Revision	Planned Date to be Submitted to Board	Date Submitted to Board	BMCE Transmittal No	Date Response Required from Board	Date Returned from Board	Board Status	Date returned to Consultant	Date Required from Consultant	Date Submitted by Consultant	
Item	Submission	Comments																		
		This was issued for information on BMCE-TRANSMIT-018797 12/12/13	ZBP	C	ZBP-ZC-03-PL-531-033	Small Power Layout Third	13/07/12			A	17/08/12	21/08/12	BMCE-TRANSMIT-010405 (BMCE-WTRAN-003785)	11/09/12	27/08/12	B	03/09/12 BMCE-TRANSMIT-010690			
		This was issued for information on BMCE-TRANSMIT-018797 12/12/13	ZBP	C	ZBP-ZC-04-PL-531-043	Small Power Layout Fourth	13/07/12			A	17/08/12	21/08/12	BMCE-TRANSMIT-010405 (BMCE-WTRAN-003785)	11/09/12	27/08/12	B	03/09/12 BMCE-TRANSMIT-010690			
			ZBP	C	ZBP-ZC-00-PL-532-003	Containment/Sub-Main Layout Ground	13/07/12			A	17/08/12	21/08/12	BMCE-TRANSMIT-010405 (BMCE-WTRAN-003785)	11/09/12	27/08/12	A	03/09/12 BMCE-TRANSMIT-010690			
			ZBP	C	ZBP-ZC-01-PL-532-013	Containment/Sub-Main Layout First	13/07/12			A	17/08/12	02/05/12	BMCE-TRANSMIT-008653 (BMCE-WTRAN-002981)	23/05/12	02/08/12	A	23/08/12 BMCE-TRANSMIT-010489			
			ZBP	C	ZBP-ZC-02-PL-532-023	Containment/Sub-Main Layout Second	13/07/12			A	17/08/12	21/08/12	BMCE-TRANSMIT-010405 (BMCE-WTRAN-003785)	11/09/12	27/08/12	A	03/09/12 BMCE-TRANSMIT-010690			
			ZBP	C	ZBP-ZC-03-PL-532-033	Containment/Sub-Main Layout Third	13/07/12			A	17/08/12	21/08/12	BMCE-TRANSMIT-010405 (BMCE-WTRAN-003785)	11/09/12	27/08/12	A	03/09/12 BMCE-TRANSMIT-010690			
			ZBP	C	ZBP-ZC-04-PL-532-043	Containment/Sub-Main Layout Fourth	13/07/12			A	17/08/12	21/08/12	BMCE-TRANSMIT-010405 (BMCE-WTRAN-003785)	11/09/12	27/08/12	A	03/09/12 BMCE-TRANSMIT-010690			
			ZBP	C	ZBP-ZC-00-PL-571-003	Security Layout Ground	13/07/12			A	17/08/12	21/08/12	BMCE-TRANSMIT-010405 (BMCE-WTRAN-003785)	11/09/12	27/08/12	A	03/09/12 BMCE-TRANSMIT-010690			
		This was issued for information on BMCE-TRANSMIT-018797 12/12/13	ZBP	C	ZBP-ZC-01-PL-571-013	Security Layout First	13/07/12			A	17/08/12	02/05/12	BMCE-TRANSMIT-008653 (BMCE-WTRAN-002981)	23/05/12	02/08/12	B	23/08/12 BMCE-TRANSMIT-010489			
			ZBP	C	ZBP-ZC-02-PL-571-023	Security Layout Second	13/07/12			A	17/08/12	21/08/12	BMCE-TRANSMIT-010405 (BMCE-WTRAN-003785)	11/09/12	27/08/12	A	03/09/12 BMCE-TRANSMIT-010690			
		This was issued for information on BMCE-TRANSMIT-018797 12/12/13	ZBP	C	ZBP-ZC-03-PL-571-033	Security Layout Third	13/07/12			A	17/08/12	21/08/12	BMCE-TRANSMIT-010405 (BMCE-WTRAN-003785)	11/09/12	27/08/12	B	03/09/12 BMCE-TRANSMIT-010690			
		This was issued for information on BMCE-TRANSMIT-018797 12/12/13	ZBP	C	ZBP-ZC-04-PL-571-043	Security Layout Fourth	13/07/12			A	17/08/12	21/08/12	BMCE-TRANSMIT-010405 (BMCE-WTRAN-003785)	11/09/12	27/08/12	B	03/09/12 BMCE-TRANSMIT-010690			
		Public Health Services Drawings		ZBP	C	ZBP-ZC-00-PL-500-003	Water & Gas Services Layout Ground	13/07/12			A	17/08/12	29/08/12	BMCE-TRANSMIT-010512 (BMCE-WTRAN-003828)	19/09/12	28/09/12	A	11/10/12 BMCE-TRANSMIT-011563		
			ZBP	C	ZBP-ZC-01-PL-500-013	Water & Gas Services Layout First	13/07/12			A	17/08/12	30/05/12	BMCE-TRANSMIT-009108 (BMCE-WTRAN-003162)	20/06/12	19/07/12	A	02/08/12 BMCE-TRANSMIT-010119 15/08/12			
			ZBP	C	ZBP-ZC-02-PL-500-023	Water & Gas Services Layout Second	13/07/12			A	17/08/12	29/08/12	BMCE-TRANSMIT-010512 (BMCE-WTRAN-003828)	19/09/12	28/09/12	A	11/10/12 BMCE-TRANSMIT-011563			
		This was issued for information on BMCE-TRANSMIT-018797 12/12/13	ZBP	C	ZBP-ZC-03-PL-500-033	Water & Gas Services Layout Third	13/07/12			A	17/08/12	29/08/12	BMCE-TRANSMIT-010512 (BMCE-WTRAN-003828)	19/09/12	28/09/12	B	11/10/12 BMCE-TRANSMIT-011563			
		This was issued for information on BMCE-TRANSMIT-018797 12/12/13	ZBP	C	ZBP-ZC-04-PL-500-043	Water & Gas Services Layout Fourth	13/07/12			A	17/08/12	29/08/12	BMCE-TRANSMIT-010512 (BMCE-WTRAN-003828)	19/09/12	28/09/12	A	11/10/12 BMCE-TRANSMIT-011563			
		ZBP	C	ZBP-ZC-00-PL-581-003	Sanitation and Rainwater Layout Ground	13/07/12			A	17/08/12	21/08/12	BMCE-TRANSMIT-010421 (BMCE-WTRAN-003795)	11/09/12	18/09/12	A	01/10/12 BMCE-TRANSMIT-011252				
		ZBP	C	ZBP-ZC-01-PL-581-013	Sanitation and Rainwater Layout First	13/07/12			A	17/08/12	21/08/12	BMCE-TRANSMIT-010421 (BMCE-WTRAN-003795)	11/09/12	18/09/12	A	01/10/12 BMCE-TRANSMIT-011252				
		ZBP	C	ZBP-ZC-02-PL-581-023	Sanitation and Rainwater Layout Second	13/07/12			A	17/08/12	21/08/12	BMCE-TRANSMIT-010421 (BMCE-WTRAN-003795)	11/09/12	18/09/12	A	01/10/12 BMCE-TRANSMIT-011252				
	DRAWING NUMBER CHANGED DRAWING REMOVED BY ZBP	ZBP	C	ZBP-ZC-03-PL-581-032	Sanitation and Rainwater Layout Third	13/07/12			A	17/08/12										
		ZBP	C	ZBP-ZC-03-PL-581-033	Sanitation and Rainwater Layout Third	13/07/12			E	17/08/12	21/08/12	BMCE-TRANSMIT-010421 (BMCE-WTRAN-003795)	11/09/12	18/09/12	A	01/10/12 BMCE-TRANSMIT-011252				
		ZBP	C	ZBP-ZC-04-PL-581-043	Sanitation and Rainwater Layout Fourth	13/07/12			A	17/08/12	21/08/12	BMCE-TRANSMIT-010421 (BMCE-WTRAN-003795)	11/09/12	18/09/12	A	01/10/12 BMCE-TRANSMIT-011252				
	Error in drawing - Please refer to ZBP-ZC-05-PL-581-053 Below	ZBP	B	ZBP-ZC-04-PL-581-053	Sanitation and Rainwater Layout Fifth Floor	13/07/12			B		22/11/12	BMCE-TRANSMIT-012405 (BMCE-WTRAN-004634)	13/12/12	03/12/12	B	06/12/12 BMCE-TRANSMIT-012282				
	DRAWING NUMBER CHANGED DRAWING REMOVED BY ZBP	ZBP	C	ZBP-ZB-04-PL-581-064	Sanitation and Rainwater Layout Fourth	13/07/12				17/08/12				21/01/13						
		ZBP	C	ZBP-ZC-05-PL-581-053	Sanitation & Rainwater Layout Fifth Floor				C		04/06/13	BMCE-TRANSMIT-016094 (BMCE-WTRAN-007776)	25/06/13	08/07/13	A	BMCE-TRANSMIT-016914				

Drawing Information

31 BCL-AC-XX-SH-001

			Action By	Zone	Drawing Number	Drawing Title	Date Required from Consultant	Date Submitted by Consultant	Document Revision	Planned Date to be Submitted to Board	Date Submitted to Board	BMCE Transmittal No	Date Response Required from Board	Date Returned from Board	Board Status	Date returned to Consultant	Date Required from Consultant	Date Submitted by Consultant
Item	Submission	Comments																
		This Was issued for information on BMCE-TRANSMIT-018730 09/12/13	MER	C	ME-SZ-00-PL-541-513	Ground Floor Plan NCH - OPD Lighting Layout	13/07/12	06/03/12	D	17/08/12	21/08/12	BMCE-TRANSMIT-010419 (BMCE-WTRAN-003793)	11/09/12	24/08/12	B	03/09/12 BMCE-TRANSMIT-010681		
		This drawing was issued to the board for information only on BMCE-TRANSMIT-018592	MER	C	ME-SZ-01-PL-541-506	First Floor Plan. Nch Theatres, Endoscopy & Recovery. Lighting Layout	13/07/12		F	17/08/12	21/08/12	BMCE-TRANSMIT-010419 (BMCE-WTRAN-003793)	11/09/12	24/08/12	B	03/09/12 BMCE-TRANSMIT-010681		
			MER	C	ME-ZC-01-PL-541-511	First Floor Plan NCH - Day & 23 Hour Unit Lighting Layout	13/07/12		A	17/08/12	21/08/12	BMCE-TRANSMIT-010419 (BMCE-WTRAN-003793)	11/09/12	24/08/12	A	03/09/12 BMCE-TRANSMIT-010681		
		This Was issued for information on BMCE-TRANSMIT-018729 09/12/13	MER	C	ME-ZC-01-PL-541-512	First Floor Plan NCH - Day & 23 Hour Unit Lighting Layout	13/07/12		A	17/08/12	21/08/12	BMCE-TRANSMIT-010419 (BMCE-WTRAN-003793)	11/09/12	24/08/12	B	03/09/12 BMCE-TRANSMIT-010681		
		This Was issued for information on BMCE-TRANSMIT-018729 09/12/13	MER	C	ME-ZC-02-PL-541-508	Second Floor Plan NCH Schiehallion Ward, Day Case & TCT Lighting Layout	13/07/12		A	17/08/12	21/08/12	BMCE-TRANSMIT-010419 (BMCE-WTRAN-003793)	11/09/12	24/08/12	B	03/09/12 BMCE-TRANSMIT-010681		

Drawing Information

31 BCL-AC-XX-SH-001

1st Submission2nd Submission

			Action By		Zone	Drawing Number	Drawing Title	Date Required from Consultant	Date Submitted by Consultant	Document Revision	Planned Date to be Submitted to Board	Date Submitted to Board	BMCE Transmittal No	Date Response Required from Board	Date Returned from Board	Board Status	Date returned to Consultant	Date Required from Consultant	Date Submitted by Consultant	
Item	Submission	Comments																		
		This Was issued for information on BMCE-TRANSMIT-018729 09/12/13	MER	C	ME-ZC-02-PL-541-509	Second Floor Plan NCH Schiehallion Ward, Day Case & TCT Lighting Layout	13/07/12			A	17/08/12	21/08/12	BMCE-TRANSMIT-010419 (BMCE-WTRAN-003793)	11/09/12	24/08/12	B	03/09/12 BMCE-TRANSMIT-010681			
		This Was issued for information on BMCE-TRANSMIT-018729 09/12/13	MER	C	ME-ZC-03-PL-541-505	Third Floor Plan NCH Inpatient Wards Medicinema Lighting Layout	13/07/12			A	17/08/12	21/08/12	BMCE-TRANSMIT-010419 (BMCE-WTRAN-003793)	11/09/12	24/08/12	B	03/09/12 BMCE-TRANSMIT-010681			
		This Was issued for information on BMCE-TRANSMIT-018729 09/12/13	MER	C	ME-ZC-03-PL-541-506	Third Floor Plan NCH Inpatient Wards Lighting Layout	13/07/12			A	17/08/12	21/08/12	BMCE-TRANSMIT-010419 (BMCE-WTRAN-003793)	11/09/12	24/08/12	B	03/09/12 BMCE-TRANSMIT-010681			
		This Was issued for information on BMCE-TRANSMIT-018729 09/12/13	MER	C	ME-ZC-03-PL-541-507	Third Floor Plan NCH Inpatient Wards Lighting Layout	13/07/12			A	17/08/12	21/08/12	BMCE-TRANSMIT-010419 (BMCE-WTRAN-003793)	11/09/12	24/08/12	B	03/09/12 BMCE-TRANSMIT-010681			
			MER	C	ME-SZ-03-PL-541-508	Third Floor Plan NCH Inpatient Wards Lighting Layout	13/07/12			D	17/08/12	21/08/12	BMCE-TRANSMIT-010419 (BMCE-WTRAN-003793)	11/09/12	24/08/12	A	03/09/12 BMCE-TRANSMIT-010681			
		Removed by Mercury - DUPLICATE	MER	C	ME-SZ-04-PL-541-515	Fourth Floor Plan NCH Psychiatry/DCFP Lighting Layout	13/07/12					17/08/12			-					
		This was issued for information on BMCE-TRANSMIT-018891 18/12/13	MER	C	ME-SZ-04-PL-541-515	Fourth Floor Plan, NCH DCFP, Lighting Layout	13/07/12			A	17/08/12	21/08/12	BMCE-TRANSMIT-010419 (BMCE-WTRAN-003793)	11/09/12	24/08/12	B	03/09/12 BMCE-TRANSMIT-010681			
		Issued for informaton on BMCE-TRANSMIT-019288 04/02/14	MER	C	ME-ZC-04-PL-541-516	Fourth Floor Plan NCH Psychiatry/DCFP Lighting Layout	13/07/12			A	17/08/12	21/08/12	BMCE-TRANSMIT-010419 (BMCE-WTRAN-003793)	11/09/12	24/08/12	C	03/09/12 BMCE-TRANSMIT-010681			
		Issued for informaton on BMCE-TRANSMIT-019288 04/02/14	MER	C	ME-ZC-04-PL-541-517	Fourth Floor Plan NCH Psychiatry/DCFP Lighting Layout	13/07/12			A	17/08/12	21/08/12	BMCE-TRANSMIT-010419 (BMCE-WTRAN-003793)	11/09/12	24/08/12	C	03/09/12 BMCE-TRANSMIT-010681			
		This Was issued for information on BMCE-TRANSMIT-018729 09/12/13	MER	C	ME-ZC-B1-PL-541-509	Basement Floor Plan NCH Core K Lighting Layout	13/07/12			A	17/08/12	06/06/12	BMCE-TRANSMIT-009244 (BMCE-WTRAN-003216)	27/06/12	11/07/12	B	16/07/12 BMCE-TRANSMIT-009862			
		This Was issued for information on BMCE-TRANSMIT-018729 09/12/13	MER	C	ME-ZC-B1-PL-541-511	Basement Floor Plan NCH Tunnel Link to Labs Lighting Layout	13/07/12			A	17/08/12	06/06/12	BMCE-TRANSMIT-009244 (BMCE-WTRAN-003216)	27/06/12	12/07/12	B	16/07/12 BMCE-TRANSMIT-009862			
		Issued For information on BMCE-TRANSMIT-018891 18/12/13	MER	C	ME-ZC-05-PL-541-101	5th floor plan plantroom 41 a Lighting layout zone C				B		21/10/13	BMCE-TRANSMIT-018154 (BMCE-WTRAN-008190)	11/11/13	01/11/13	B	11/11/13 BMCE-TRANSMIT-018430			
		Removed by Mercury - WRONG DRAWING NO.	MER	C	ME-XX-XX-SP-541-100	Lighting Calculations - Zone C	13/07/12					17/08/12			-					
		Removed by Mercury - DUPLICATE	MER	C	ME-XX-XX-SP-541-101	Luminaire Schedule - Zone C	13/07/12					17/08/12			-					
	Small Power		Removed By Mercury - NOT REQUIRED FOR RDD (SMALL POWER SHOWN ON NA 400 SERIES DRAWINGS)	MER	C	ME-ZC-00-PL-531-509	Ground Floor Plan NCH - OPD Small Power & General Services Layout	13/07/12					17/08/12			-				
			Removed By Mercury - NOT REQUIRED FOR RDD (SMALL POWER SHOWN ON NA 400 SERIES DRAWINGS)	MER	C	ME-ZC-00-PL-531-510	Ground Floor Plan NCH - Main Entrance & Public Area Small Power & General Services Layout	13/07/12					17/08/12			-				
			Removed By Mercury - NOT REQUIRED FOR RDD (SMALL POWER SHOWN ON NA 400 SERIES DRAWINGS)	MER	C	ME-ZC-00-PL-531-511	Ground Floor Plan NCH - Main Entrance & Public Area Small Power & General Services Layout	13/07/12					17/08/12			-				
			Removed By Mercury - NOT REQUIRED FOR RDD (SMALL POWER SHOWN ON NA 400 SERIES DRAWINGS)	MER	C	ME-ZC-01-PL-531-511	First Floor Plan NCH - Day & 23 Hour Unit Small Power & General Services Layout	13/07/12					17/08/12			-				
		Removed By Mercury - NOT REQUIRED FOR RDD (SMALL POWER SHOWN ON NA 400 SERIES DRAWINGS)	MER	C	ME-ZC-01-PL-531-512	First Floor Plan NCH - Day & 23 Hour Unit Small Power & General Services Layout	13/07/12					17/08/12			-					
		Removed By Mercury - NOT REQUIRED FOR RDD (SMALL POWER SHOWN ON NA 400 SERIES DRAWINGS)	MER	C	ME-ZC-02-PL-531-508	Second Floor Plan NCH - Schiehallion Ward, Day Case & TCT Small Power & General Services Layout	13/07/12					17/08/12			-					
		Removed By Mercury - NOT REQUIRED FOR RDD (SMALL POWER SHOWN ON NA 400 SERIES DRAWINGS)	MER	C	ME-ZC-02-PL-531-509	Second Floor Plan NCH Schiehallion Ward, Day Case & TCT Small Power & General Services Layout	13/07/12					17/08/12			-					
		Removed By Mercury - NOT REQUIRED FOR RDD (SMALL POWER SHOWN ON NA 400 SERIES DRAWINGS)	MER	C	ME-ZC-03-PL-531-505	Third Floor Plan NCH Inpatient Wards Medicinema Small Power & General Services Layout	13/07/12					17/08/12			-					
		Removed By Mercury - NOT REQUIRED FOR RDD (SMALL POWER SHOWN ON NA 400 SERIES DRAWINGS)	MER	C	ME-ZC-03-PL-531-506	Third Floor Plan NCH Inpatient Wards Small Power & General Services Layout	13/07/12					17/08/12			-					
		Removed By Mercury - NOT REQUIRED FOR RDD (SMALL POWER SHOWN ON NA 400 SERIES DRAWINGS)	MER	C	ME-ZC-03-PL-531-507	Third Floor Plan NCH Inpatient Wards Small Power & General Services Layout	13/07/12					17/08/12			-					
		Removed By Mercury - NOT REQUIRED FOR RDD (SMALL POWER SHOWN ON NA 400 SERIES DRAWINGS)	MER	C	ME-ZC-04-PL-531-516	Fourth Floor Plan NCH Psychiatry/DCFP Small Power & General Services Layout	13/07/12					17/08/12			-					
		Removed By Mercury - NOT REQUIRED FOR RDD (SMALL POWER SHOWN ON NA 400 SERIES DRAWINGS)	MER	C	ME-ZC-04-PL-531-517	Fourth Floor Plan NCH Psychiatry/DCFP Small Power & General Services Layout	13/07/12					17/08/12			-					
		Removed By Mercury - NOT REQUIRED FOR RDD (SMALL POWER SHOWN ON NA 400 SERIES DRAWINGS)	MER	C	ME-ZC-B1-PL-531-509	Basement Floor Plan NCH Core K Small Power & General Services Layout	13/07/12					17/08/12			-					
		Removed By Mercury - NOT REQUIRED FOR RDD (SMALL POWER SHOWN ON NA 400 SERIES DRAWINGS)	MER	C	ME-ZC-B1-PL-531-511	Basement Floor Plan NCH Tunnel Link to Labs Small Power & General Services Layout	13/07/12					17/08/12			-					
		Removed By Mercury - NOT REQUIRED FOR RDD (SMALL POWER SHOWN ON NA 400 SERIES DRAWINGS)	MER	C	ME-ZC-00-PL-532-509	Ground Floor Plan NCH - OPD High Level Layout	13/07/12					17/08/12			-					
		Removed By Mercury - NOT REQUIRED FOR RDD (SMALL POWER SHOWN ON NA 400 SERIES DRAWINGS)	MER	C	ME-ZC-00-PL-532-510	Ground Floor Plan NCH - Main Entrance & Public Area High Level	13/07/12					17/08/12			-					

Drawing Information

31	BCL-AC-XX-SH-001							1st Submission										2nd Submission				
			Action By		Zone	Drawing Number		Drawing Title		Date Required from Consultant	Date Submitted by Consultant	Document Revision	Planned Date to be Submitted to Board	Date Submitted to Board	BMCE Transmittal No	Date Response Required from Board	Date Returned from Board	Board Status	Date returned to Consultant	Date Required from Consultant	Date Submitted by Consultant	
Item	Submission	Comments																				
		Removed By Mercury - NOT REQUIRED FOR RDD (SMALL POWER SHOWN ON NA 400 SERIES DRAWINGS)	MER	C		ME-ZC-00-PL-532-511	Ground Floor Plan NCH - Main Entrance & Pub-ic Area ELV Systems-low-le-el-Layout	13/07/12					17/08/12			-						
		Removed By Mercury - NOT REQUIRED FOR RDD (SMALL POWER SHOWN ON NA 400 SERIES DRAWINGS)	MER	C		ME-ZC-01-PL-532-511	First Floor Plan NCH - Day & 23 Hour Unit ELV Systems-low-le-el-Layout	13/07/12					17/08/12			-						
		Removed By Mercury - NOT REQUIRED FOR RDD (SMALL POWER SHOWN ON NA 400 SERIES DRAWINGS)	MER	C		ME-ZC-01-PL-532-512	First Floor Plan NCH - Day & 23 Hour Unit ELV Systems-low-level-Layout	13/07/12					17/08/12			-						
		Removed By Mercury - NOT REQUIRED FOR RDD (SMALL POWER SHOWN ON NA 400 SERIES DRAWINGS)	MER	C		ME-ZC-02-PL-532-508	Second Floor Plan NCH-Schiehallion Ward-Day Case & TCT-ELV-Systems-low-le-el-Layout	13/07/12					17/08/12			-						
		Removed By Mercury - NOT REQUIRED FOR RDD (SMALL POWER SHOWN ON NA 400 SERIES DRAWINGS)	MER	C		ME-ZC-02-PL-532-509	Second Floor Plan NCH-Schiehallion Ward-Day Case & TCT-ELV-Systems-low-level-Layout	13/07/12					17/08/12			-						
		Removed By Mercury - NOT REQUIRED FOR RDD (SMALL POWER SHOWN ON NA 400 SERIES DRAWINGS)	MER	C		ME-ZC-03-PL-532-505	Third Floor Plan NCH Inpatient Wards-Medicinema-ELV-Systems-low-le-el-Layout	13/07/12					17/08/12			-						
		Removed By Mercury - NOT REQUIRED FOR RDD (SMALL POWER SHOWN ON NA 400 SERIES DRAWINGS)	MER	C		ME-ZC-03-PL-532-506	Third Floor Plan NCH Inpatient Wards-ELV-Systems-low-le-el-Layout	13/07/12					17/08/12			-						
		Removed By Mercury - NOT REQUIRED FOR RDD (SMALL POWER SHOWN ON NA 400 SERIES DRAWINGS)	MER	C		ME-ZC-03-PL-532-507	Third Floor Plan NCH Inpatient Wards-ELV-Systems-low-le-el-Layout	13/07/12					17/08/12			-						
		Removed By Mercury - NOT REQUIRED FOR RDD (SMALL POWER SHOWN ON NA 400 SERIES DRAWINGS)	MER	C		ME-ZC-04-PL-532-516	Fourth Floor Plan NCH Psychiatry/DCFP-ELV-Systems-low-le-el-Layout	13/07/12					17/08/12			-						
		Removed By Mercury - NOT REQUIRED FOR RDD (SMALL POWER SHOWN ON NA 400 SERIES DRAWINGS)	MER	C		ME-ZC-04-PL-532-517	Fourth Floor Plan NCH Psychiatry/DCFP-ELV-Systems-low-level-Layout	13/07/12					17/08/12			-						
		Removed By Mercury - NOT REQUIRED FOR RDD (SMALL POWER SHOWN ON NA 400 SERIES DRAWINGS)	MER	C		ME-ZC-B1-PL-532-509	Basement Floor Plan NCH Core K-ELV-Systems-low-le-el-Layout	13/07/12					17/08/12			-						
		Removed By Mercury - NOT REQUIRED FOR RDD (SMALL POWER SHOWN ON NA 400 SERIES DRAWINGS)	MER	C		ME-ZC-B1-PL-532-511	Basement Floor Plan NCH Tunnel Link to Labs-ELV-Systems-low-le-el-Layout	13/07/12					17/08/12			-						
	Data Comms		MER	C		ME-ZC-00-PL-556-509	Ground Floor Plan NCH - OPD Data Comms Layout	13/07/12			A	17/08/12	06/09/12	BMCE-TRANSMIT-010733 (BMCE-WTRAN-003911)	27/09/12	17/09/12	A	20/09/12 BMCE-TRANSMIT-011081				
	This Was issued for information on BMCE-TRANSMIT-018729 09/12/13		MER	C		ME-ZC-00-PL-556-510	Ground Floor Plan NCH - Main Entrance & Public Area Data Comms Layout	13/07/12			A	17/08/12	06/09/12	BMCE-TRANSMIT-010733 (BMCE-WTRAN-003911)	27/09/12	17/09/12	B	20/09/12 BMCE-TRANSMIT-011081				
			MER	C		ME-ZC-00-PL-556-511	Ground Floor Plan NCH - Main Entrance & Public Area Data Comms Layout	13/07/12			A	17/08/12	06/09/12	BMCE-TRANSMIT-010733 (BMCE-WTRAN-003911)	27/09/12	17/09/12	A	20/09/12 BMCE-TRANSMIT-011081				
	This Was issued for information on BMCE-TRANSMIT-018730 09/12/13		MER	C		ME-SZ-00-PL-556-513	Ground Floor Plan NCH - OPD Data Comms Layout	13/07/12			C	17/08/12	21/08/12	BMCE-TRANSMIT-010414 (BMCE-WTRAN-003790)	11/09/12		B	20/09/12 BMCE-TRANSMIT-011081				
			MER	C		ME-SZ-01-PL-556-506	First Floor Plan NCH Theatres, Endoscopy & Recovery. Data Comms Layout	13/07/12			E	17/08/12	06/09/12	BMCE-TRANSMIT-010733 (BMCE-WTRAN-003911)	27/09/12	17/09/12	A	20/09/12 BMCE-TRANSMIT-011081				
	REMOVED BY MERCURY - DUPLICATE		MER	C		ME-SZ-01-PL-556-520	first Floor Medical Day Unit-Layout of Data Outlets-Zone B/C	13/07/12				17/08/12										
			MER	C		ME-SZ-03-PL-556-508	Third Floor Plan NCH Inpatient Wards & Ward Support-Layout of Data Outlets Zone B/C	13/07/12			C	17/08/12	06/09/12	BMCE-TRANSMIT-010733 (BMCE-WTRAN-003911)	27/09/12	17/09/12	A	20/09/12 BMCE-TRANSMIT-011081				
			MER	C		ME-ZC-01-PL-556-511	First Floor Plan NCH - Day & 23 Hour Unit Data Comms Layout	13/07/12			A	17/08/12	06/09/12	BMCE-TRANSMIT-010733 (BMCE-WTRAN-003911)	27/09/12	17/09/12	A	20/09/12 BMCE-TRANSMIT-011081				
	This Was issued for information on BMCE-TRANSMIT-018729 09/12/13		MER	C		ME-ZC-01-PL-556-512	First Floor Plan NCH - Day & 23 Hour Unit Data Comms Layout	13/07/12			A	17/08/12	06/09/12	BMCE-TRANSMIT-010733 (BMCE-WTRAN-003911)	27/09/12	17/09/12	B	20/09/12 BMCE-TRANSMIT-011081				
	This Was issued for information on BMCE-TRANSMIT-018729 09/12/13		MER	C		ME-ZC-02-PL-556-508	Second Floor Plan NCH Schiehallion Ward, Day Case & TCT Data Comms Layout	13/07/12			A	17/08/12	06/09/12	BMCE-TRANSMIT-010733 (BMCE-WTRAN-003911)	27/09/12	17/09/12	B	20/09/12 BMCE-TRANSMIT-011081				
	This Was issued for information on BMCE-TRANSMIT-018729 09/12/13		MER	C		ME-ZC-02-PL-556-509	Second Floor Plan NCH Schiehallion Ward, Day Case & TCT Data Comms Layout	13/07/12			A	17/08/12	06/09/12	BMCE-TRANSMIT-010733 (BMCE-WTRAN-003911)	27/09/12	17/09/12	B	20/09/12 BMCE-TRANSMIT-011081				
	Not required Mercury Instruction - DUPLICATE		MER	C		ME-SZ-02-PL-556-515	Second Floor Plan NCH Inpatient Aseptic Suite-Data Comms Layout	13/07/12				17/08/12				-						
			MER	C		ME-ZC-03-PL-556-505	Third Floor Plan NCH Inpatient Wards Medicinema Data Comms Layout	13/07/12			A	17/08/12	06/09/12	BMCE-TRANSMIT-010733 (BMCE-WTRAN-003911)	27/09/12	17/09/12	A	20/09/12 BMCE-TRANSMIT-011081				
	This Was issued for information on BMCE-TRANSMIT-018729 09/12/13		MER	C		ME-ZC-03-PL-556-506	Third Floor Plan NCH Inpatient Wards Data Comms Layout	13/07/12			A	17/08/12	06/09/12	BMCE-TRANSMIT-010733 (BMCE-WTRAN-003911)	27/09/12	17/09/12	B	20/09/12 BMCE-TRANSMIT-011081				
	This was previously given a status A on 25/05/12 Please refer to BMCE-TRANSMIT-009075		MER	C		ME-SZ-04-PL-556-515	Fourth Floor NCH Psychiatry/DCFP Layout Data Outlets Zone C/B				A		06/09/12	BMCE-TRANSMIT-010733 (BMCE-WTRAN-003911)	27/09/12	17/09/12	B	20/09/12 BMCE-TRANSMIT-011081				
	REMOVED BY MERCURY - DRAWING DOES NOT EXIST		MER	C		ME-ZC-04-PL-556-515	Fourth Floor Plan NCH DCFP Layout of Data Outlets-Zone C															
	This Was issued for information on BMCE-TRANSMIT-018729 09/12/13		MER	C		ME-ZC-03-PL-556-507	Third Floor Plan NCH Inpatient Wards Data Comms Layout	13/07/12			A	17/08/12	06/09/12	BMCE-TRANSMIT-010733 (BMCE-WTRAN-003911)	27/09/12	17/09/12	B	20/09/12 BMCE-TRANSMIT-011081				
														BMCE-TRANSMIT-010733 (BMCE-WTRAN-003911)				20/09/12 BMCE-TRANSMIT-011081				

Drawing Information

31

BCL-AC-XX-SH-001

1st Submission

2nd Submission

Item	Submission	Comments	Action By Zone		Drawing Number	Drawing Title	Date Required from Consultant	Date Submitted by Consultant	Document Revision	Planned Date to be Submitted to Board	Date Submitted to Board	BMCE Transmittal No	Date Response Required from Board	Date Returned from Board	Board Status	Date returned to Consultant	Date Required from Consultant	Date Submitted by Consultant
		Removed By Mercury - NOT REQUIRED FOR RDD (PART OF BMS DETAIL DESIGN)	MER	G	ME-ZC-03-PL-660-506	Third Floor Plan NCH Inpatient Wards BMS Layout	13/07/12			17/08/12			-					
		Removed By Mercury - NOT REQUIRED FOR RDD (PART OF BMS DETAIL DESIGN)	MER	G	ME-ZC-03-PL-660-507	Third Floor Plan NCH Inpatient Wards BMS Layout	13/07/12			17/08/12			-					
		Removed By Mercury - NOT REQUIRED FOR RDD (PART OF BMS DETAIL DESIGN)	MER	G	ME-ZC-04-PL-660-516	Fourth Floor Plan NCH Psychiatry/DCFP BMS Layout	13/07/12			17/08/12			-					
		Removed By Mercury - NOT REQUIRED FOR RDD (PART OF BMS DETAIL DESIGN)	MER	C	ME-ZC-04-PL-660-517	Fourth Floor Plan NCH Psychiatry/DCFP BMS Layout	13/07/12			17/08/12			-					
		Removed By Mercury - NOT REQUIRED FOR RDD (PART OF BMS DETAIL DESIGN)	MER	C	ME-ZC-B1-PL-660-509	Basement Floor Plan NCH Core K BMS Layout	13/07/12			17/08/12			-					
		Removed By Mercury - NOT REQUIRED FOR RDD (PART OF BMS DETAIL DESIGN)	MER	C	ME-ZC-B1-PL-660-511	Basement Floor Plan NCH Tunnel Link to Labs BMS Layout	13/07/12			17/08/12			-					
	MEDICAL-GASES	Not required for RDD Review issued to board for information only BMCE-TRANSMIT-017701	MER	C	ME-ZC-01-DC-H512-001	Le-el 1, Childrens 23 hr ward & PGA Branch to Theatre Mains												
		Not required for RDD Review issued to board for information only BMCE-TRANSMIT-017701	MER	C	ME-ZC-01-DC-H512-002	Le-el 1, Childrens Post Acute recovery trolley bay to mains												
		Not required for RDD Review issued to board for information only BMCE-TRANSMIT-017701	MER	C	ME-ZC-02-DC-H512-001	Level 2, Childrens Schiehallion Ward from Room TCT-010 to Riser M32												
		Not required for RDD Review issued to board for information only BMCE-TRANSMIT-017701	MER	C	ME-ZC-03-DC-H512-001	Le-el 3, Childrens Ward GW3 from GW3-002 to Riser M32												
		Not required for RDD Review issued to board for information only BMCE-TRANSMIT-017701	MER	C	ME-ZC-04-DC-H512-001	Le-el 4, Childrens hospital, Physiatric unit room DCFP-052 to Riser M32												
		Issued for information on BMCE-TRANSMIT-019817 31/03/14	MER	C	ME-ZC-00-PL-H512-001	Medical Gas Installation, Level 0, Zone C			1		29/05/12	BMCE-TRANSMIT-009131 (BMCE-WTRAN-003175)	19/06/12	24/09/12	C	27/09/12 BMCE-TRANSMIT-011199		
			MER	C	ME-ZC-00-PL-H512-002	Medical Gas Installation, Level 0, Zone C - AGSS			1		29/05/12	BMCE-TRANSMIT-009131 (BMCE-WTRAN-003175)	19/06/12	24/09/12	C	27/09/12 BMCE-TRANSMIT-011199		
		Issued for information on BMCE-TRANSMIT-019817 31/03/14	MER	C	ME-ZC-01-PL-H512-001	Medical Gas Installation, Level 1, Zone C			1		29/05/12	BMCE-TRANSMIT-009127 (BMCE-WTRAN-003174)	19/06/12	24/09/12	C	27/09/12 BMCE-TRANSMIT-011199		
		Removed - Mercury Instruction - No longer in use	MER	G	ME-ZC-01-PL-H512-002	Medical Gas Installation, Le-el 1, Zone C - AGSS			1		29/05/12	BMCE-TRANSMIT-009127 (BMCE-WTRAN-003174)	19/06/12	24/09/12	C	27/09/12 BMCE-TRANSMIT-011199		
			MER	C	ME-ZC-02-PL-H512-001	Medical Gas Installation, Level 2, Zone C			1		29/05/12	BMCE-TRANSMIT-009123 (BMCE-WTRAN-003172)	19/06/12	24/09/12	C	27/09/12 BMCE-TRANSMIT-011202		
			MER	C	ME-ZC-03-PL-H512-001	Medical Gas Installation, Level 3, Zone C			1		29/05/12	BMCE-TRANSMIT-009125 (BMCE-WTRAN-003173)	19/06/12	01/10/12	C	04/10/12 BMCE-TRANSMIT-011125		
		Issued for information on BMCE-TRANSMIT-019817 31/03/14	MER	C	ME-ZC-04-PL-H512-001	Medical Gas Installation, Level 4, Zone C			1		29/05/12	BMCE-TRANSMIT-009122 (BMCE-WTRAN-003171)	19/06/12	01/10/12	C	04/10/12 BMCE-TRANSMIT-011324		
			MER	C	ME-ZC-04-PL-H512-002	Medical Gas Installation, Level 4, Zone C - AGSS			1		29/05/12	BMCE-TRANSMIT-009122 (BMCE-WTRAN-003171)	19/06/12	01/10/12	C	04/10/12 BMCE-TRANSMIT-011324		
		Removed By Mercury - NOT REQUIRED FOR RDD (REFER TO HPI H512 SERIES DESIGN DRAWINGS)	MER	C	ME-ZC-00-PL-512-509	Ground Floor Plan NCH - OPD Medical Gases Layout	13/07/12			17/08/12			-					
		Removed By Mercury - NOT REQUIRED FOR RDD (REFER TO HPI H512 SERIES DESIGN DRAWINGS)	MER	C	ME-ZC-00-PL-512-510	Ground Floor Plan NCH - Main Entrance & Public Area Medical Gases Layout	13/07/12			17/08/12			-					
		Removed By Mercury - NOT REQUIRED FOR RDD (REFER TO HPI H512 SERIES DESIGN DRAWINGS)	MER	C	ME-ZC-00-PL-512-511	Ground Floor Plan NCH - Main Entrance & Public Area Medical Gases Layout	13/07/12			17/08/12			-					
		Removed By Mercury - NOT REQUIRED FOR RDD (REFER TO HPI H512 SERIES DESIGN DRAWINGS)	MER	C	ME-ZC-01-PL-512-511	First Floor Plan NCH - Day & 23 Hour Unit Medical Gases Layout	13/07/12			17/08/12			-					
		Removed By Mercury - NOT REQUIRED FOR RDD (REFER TO HPI H512 SERIES DESIGN DRAWINGS)	MER	C	ME-ZC-01-PL-512-512	First Floor Plan NCH - Day & 23 Hour Unit Medical Gases Layout	13/07/12			17/08/12			-					
		Removed By Mercury - NOT REQUIRED FOR RDD (REFER TO HPI H512 SERIES DESIGN DRAWINGS)	MER	C	ME-ZC-02-PL-512-508	Second Floor Plan NCH - Schiehallion Ward, Day Case & TCT Medical Gases Layout	13/07/12			17/08/12			-					
		Removed By Mercury - NOT REQUIRED FOR RDD (REFER TO HPI H512 SERIES DESIGN DRAWINGS)	MER	C	ME-ZC-02-PL-512-509	Second Floor Plan NCH - Schiehallion Ward, Day Case & TCT Medical Gases Layout	13/07/12			17/08/12			-					
		Removed By Mercury - NOT REQUIRED FOR RDD (REFER TO HPI H512 SERIES DESIGN DRAWINGS)	MER	C	ME-ZC-03-PL-512-505	Third Floor Plan NCH Inpatient Wards Medicinema Medical Gases Layout	13/07/12			17/08/12			-					
		Removed By Mercury - NOT REQUIRED FOR RDD (REFER TO HPI H512 SERIES DESIGN DRAWINGS)	MER	C	ME-ZC-03-PL-512-506	Third Floor Plan NCH Inpatient Wards Medical Gases Layout	13/07/12			17/08/12			-					
		Removed By Mercury - NOT REQUIRED FOR RDD (REFER TO HPI H512 SERIES DESIGN DRAWINGS)	MER	C	ME-ZC-03-PL-512-507	Third Floor Plan NCH Inpatient Wards Medical Gases Layout	13/07/12			17/08/12			-					

Drawing Information

31 BCL-AC-XX-SH-001

			1st Submission																2nd Submission		
			Action By	Zone	Drawing Number	Drawing Title	Date Required from Consultant	Date Submitted by Consultant	Document Revision	Planned Date to be Submitted to Board	Date Submitted to Board	BMCE Transmittal No	Date Response Required from Board	Date Returned from Board	Board Status	Date returned to Consultant	Date Required from Consultant	Date Submitted by Consultant			
Item	Submission	Comments																			
		This Was issued for information on BMCE-TRANSMIT-018729 09/12/13	MER	C	ME-ZC-02-PL-572-509	Second Floor Plan NCH Schieha lion Ward, Day Case & TCT Fire Detection & Smoke Control Layout	13/07/12		A	17/08/12	21/08/12	BMCE-TRANSMIT-010418 (BMCE-WTRAN-003792)	11/09/12	27/08/12	B	03/09/12 BMCE-TRANSMIT-010682					
		This Was issued for information on BMCE-TRANSMIT-018729 09/12/13	MER	C	ME-ZC-03-PL-572-505	Third Floor Plan NCH Inpatient Wards Medicinema Fire Detection & Smoke Control Layout	13/07/12		A	17/08/12	21/08/12	BMCE-TRANSMIT-010418 (BMCE-WTRAN-003792)	11/09/12	27/08/12	B	03/09/12 BMCE-TRANSMIT-010682					
			MER	C	ME-ZC-03-PL-572-506	Third Floor Plan NCH Inpatient Wards Fire Detection & Smoke Control Layout	13/07/12		A	17/08/12	21/08/12	BMCE-TRANSMIT-010418 (BMCE-WTRAN-003792)	11/09/12	27/08/12	A	03/09/12 BMCE-TRANSMIT-010682					
		This Was issued for information on BMCE-TRANSMIT-018729 09/12/13	MER	C	ME-ZC-03-PL-572-507	Third Floor Plan NCH Inpatient Wards Fire Detection & Smoke Control Layout	13/07/12		A	17/08/12	21/08/12	BMCE-TRANSMIT-010418 (BMCE-WTRAN-003792)	11/09/12	27/08/12	B	03/09/12 BMCE-TRANSMIT-010682					
		This Was issued for information on BMCE-TRANSMIT-018729 09/12/13	MER	C	ME-SZ-03-PL-572-508	Third Floor plan NCH Inpatient Wards & Ward Support Fire Detection Layout Zone C/B			C	17/08/12	21/08/12	BMCE-TRANSMIT-010418 (BMCE-WTRAN-003792)	11/09/12	27/08/12	B	03/09/12 BMCE-TRANSMIT-010682					
		This Was issued for information on BMCE-TRANSMIT-018729 09/12/13	MER	C	ME-ZC-04-PL-572-515	Fourth Floor Plan NCH Psychiatry/DCFP Fire Detection & Smoke Control Layout	13/07/12		A	17/08/12	21/08/12	BMCE-TRANSMIT-010418 (BMCE-WTRAN-003792)	11/09/12	27/08/12	B	03/09/12 BMCE-TRANSMIT-010682					
		This Was issued for information on BMCE-TRANSMIT-018729 09/12/13	MER	C	ME-ZC-04-PL-572-516	Fourth Floor Plan NCH Psychiatry/DCFP Fire Detection & Smoke Control Layout	13/07/12		A	17/08/12	21/08/12	BMCE-TRANSMIT-010418 (BMCE-WTRAN-003792)	11/09/12	27/08/12	B	03/09/12 BMCE-TRANSMIT-010682					

Drawing Information

31 BCL-AC-XX-SH-001

1st Submission2nd Submission

			Action By	Zone	Drawing Number	Drawing Title	Date Required from Consultant	Date Submitted by Consultant	Document Revision	Planned Date to be Submitted to Board	Date Submitted to Board	BMCE Transmittal No	Date Response Required from Board	Date Returned from Board	Board Status	Date returned to Consultant	Date Required from Consultant	Date Submitted by Consultant
Item	Submission	Comments																
		This Was issued for information on BMCE-TRANSMIT-018729 09/12/13	MER	C	ME-ZC-04-PL-572-517	Fourth Floor Plan NCH Psychiatry/DCFP Fire Detection & Smoke Control Layout	13/07/12		A	17/08/12	21/08/12	BMCE-TRANSMIT-010418 (BMCE-WTRAN-003792)	11/09/12	27/08/12	B	03/09/12 BMCE-TRANSMIT-010682		
			MER	C	ME-ZC-05-PL-572-101	fifth floor plan plantroom 41a fir detection layout. ZC			B		21/10/13	BMCE-TRANSMIT-018154 (BMCE-WTRAN-009190)	11/11/13	01/11/13	A	11/11/13 BMCE-TRANSMIT-018430		
		This Was issued for information on BMCE-TRANSMIT-018729 09/12/13	MER	C	ME-ZC-B1-PL-572-509	Basement Floor Plan NCH Core K Fire Detection & Smoke Control Layout	13/07/12		A	17/08/12	07/06/12	BMCE-TRANSMIT-009266 (BMCE-WTRAN-003230)	28/06/12	10/07/12	B	17/07/12 BMCE-TRANSMIT-009876		
			MER	C	ME-ZC-B1-PL-572-511	Basement Floor Plan NCH Tunnel Link to Labs Fire Detection & Smoke Control Layout	13/07/12		A	17/08/12	07/06/12	BMCE-TRANSMIT-009266 (BMCE-WTRAN-003230)	28/06/12	10/07/12	C	17/07/12 BMCE-TRANSMIT-009876		
	Pneumatic Tube Distribution		MER	C	ME-ZC-00-PL-569-001	Ground Floor Plan Pneumatic Tube Distribution	13/07/12		A	17/08/12	21/08/12	BMCE-TRANSMIT-010409 (BMCE-WTRAN-003789)	11/09/12	22/08/12	A	03/09/12 BMCE-TRANSMIT-010680		
			MER	C	ME-ZC-01-PL-569-002	First Floor Plan Pneumatic Tube Distribution	13/07/12		A	17/08/12	21/08/12	BMCE-TRANSMIT-010409 (BMCE-WTRAN-003789)	11/09/12	22/08/12	A	03/09/12 BMCE-TRANSMIT-010680		
			MER	C	ME-ZC-02-PL-569-003	Second Floor Plan Pneumatic Tube Distribution	13/07/12		A	17/08/12	21/08/12	BMCE-TRANSMIT-010409 (BMCE-WTRAN-003789)	11/09/12	22/08/12	A	03/09/12 BMCE-TRANSMIT-010680		
			MER	C	ME-ZC-03-PL-569-004	Third Floor Pneumatic Tube Distribution	13/07/12		A	17/08/12	21/08/12	BMCE-TRANSMIT-010409 (BMCE-WTRAN-003789)	11/09/12	22/08/12	A	03/09/12 BMCE-TRANSMIT-010680		
	Sprinkler System		MER	C	ME-ZC-B1-PL-575-318	Basement Level Void Layout			A		07/06/12	BMCE-TRANSMIT-009260 (BMCE-WTRAN-003224)	28/06/12	06/07/12	A	18/07/12 BMCE-TRANSMIT-009899		
			MER	C	ME-ZC-B1-PL-575-319	Basement Level Ceiling Layout			A		07/06/12	BMCE-TRANSMIT-009260 (BMCE-WTRAN-003224)	28/06/12	06/07/12	A	18/07/12 BMCE-TRANSMIT-009899		
		Issued for information on BMCE-TRANSMIT-019712 18/03/14	MER	C	ME-ZC-00-PL-575-318	Ground floor Void Layout	13/07/12		A	17/08/12	21/08/12	BMCE-TRANSMIT-010395 (BMCE-WTRAN-003776)	11/09/12	28/08/12	B	03/09/12 BMCE-TRANSMIT-010683		
		Issued for information on BMCE-TRANSMIT-019712 18/03/14	MER	C	ME-ZC-00-PL-575-319	Ground Floor Ceiling Layout	13/07/12		A	17/08/12	21/08/12	BMCE-TRANSMIT-010395 (BMCE-WTRAN-003776)	11/09/12	28/08/12	B	03/09/12 BMCE-TRANSMIT-010683		
		Issued for information on BMCE-TRANSMIT-019712 18/03/14	MER	C	ME-ZC-01-PL-575-318	First Floor Void Layout	13/07/12		A	17/08/12	21/08/12	BMCE-TRANSMIT-010395 (BMCE-WTRAN-003776)	11/09/12	28/08/12	B	03/09/12 BMCE-TRANSMIT-010683		
		Issued for information on BMCE-TRANSMIT-019712 18/03/14	MER	C	ME-ZC-01-PL-575-319	First Floor Ceiling Layout	13/07/12		A	17/08/12	21/08/12	BMCE-TRANSMIT-010395 (BMCE-WTRAN-003776)	11/09/12	28/08/12	B	03/09/12 BMCE-TRANSMIT-010683		
		Issued for information on BMCE-TRANSMIT-019712 18/03/14	MER	C	ME-ZC-02-PL-575-318	Second Floor Void Layout	13/07/12		A	17/08/12	21/08/12	BMCE-TRANSMIT-010395 (BMCE-WTRAN-003776)	11/09/12	28/08/12	B	03/09/12 BMCE-TRANSMIT-010683		
		Issued for information on BMCE-TRANSMIT-019712 18/03/14	MER	C	ME-ZC-02-PL-575-319	Second Floor Ceiling Layout	13/07/12		A	17/08/12	21/08/12	BMCE-TRANSMIT-010395 (BMCE-WTRAN-003776)	11/09/12	28/08/12	B	03/09/12 BMCE-TRANSMIT-010683		
		Issued for information on BMCE-TRANSMIT-019712 18/03/14	MER	C	ME-ZC-03-PL-575-318	Third Floor Void Layout	13/07/12		A	17/08/12	21/08/12	BMCE-TRANSMIT-010395 (BMCE-WTRAN-003776)	11/09/12	28/08/12	B	03/09/12 BMCE-TRANSMIT-010683		
		Issued for information on BMCE-TRANSMIT-019712 18/03/14	MER	C	ME-ZC-03-PL-575-319	Third floor Ceiling Layout	13/07/12		A	17/08/12	21/08/12	BMCE-TRANSMIT-010395 (BMCE-WTRAN-003776)	11/09/12	28/08/12	B	03/09/12 BMCE-TRANSMIT-010683		
		Issued for information on BMCE-TRANSMIT-019712 18/03/14	MER	C	ME-ZC-04-PL-575-318	Fourth Floor Void Layout	13/07/12		A	17/08/12	21/08/12	BMCE-TRANSMIT-010395 (BMCE-WTRAN-003776)	11/09/12	28/08/12	B	03/09/12 BMCE-TRANSMIT-010683		
			MER	C	ME-ZC-04-PL-575-319	Fourth Floor Ceiling Layout	13/07/12		A	17/08/12	21/08/12	BMCE-TRANSMIT-010395 (BMCE-WTRAN-003776)	11/09/12	28/08/12	C	03/09/12 BMCE-TRANSMIT-010683		
	CCTV & Door Access	This Was issued for information on BMCE-TRANSMIT-018729 09/12/13	MER	C	ME-ZC-B1-PL-571-509	Basement Floor Plan. NCH Basement Plant Pump Room & Plant CCTV & Door Access	13/07/12		A	17/08/12	07/06/12	BMCE-TRANSMIT-009256 (BMCE-WTRAN-003221)	28/06/12	13/07/12	B	19/07/12 BMCE-TRANSMIT-009932		
		This Was issued for information on BMCE-TRANSMIT-018729 09/12/13	MER	C	ME-ZC-B1-PL-571-511	Basement Floor Plan. NCH Tunnel Link to Labs CCTV & Door Access	13/07/12		A	17/08/12	07/06/12	BMCE-TRANSMIT-009256 (BMCE-WTRAN-003221)	28/06/12	13/07/12	B	19/07/12 BMCE-TRANSMIT-009932		
		This Was issued for information on BMCE-TRANSMIT-018729 09/12/13	MER	C	ME-ZC-00-PL-571-509	Ground Floor Plan NCH OPD CCTV & Door Access Layout	13/07/12		C	17/08/12	21/08/12	BMCE-TRANSMIT-010416 (BMCE-WTRAN-003791)	11/09/12	28/08/12	B	03/09/12 BMCE-TRANSMIT-010687		
			MER	C	ME-ZC-00-PL-571-510	Ground Floor Plan NCH Main Entrance & Public Areas . CCTV & Door Access Layout	13/07/12		C	17/08/12	21/08/12	BMCE-TRANSMIT-010416 (BMCE-WTRAN-003791)	11/09/12	28/08/12	A	03/09/12 BMCE-TRANSMIT-010687		
			MER	C	ME-ZC-00-PL-571-511	Ground Floor Plan NCH Main Entrance & Public Areas . CCTV & Door Access Layout	13/07/12		C	17/08/12	21/08/12	BMCE-TRANSMIT-010416 (BMCE-WTRAN-003791)	11/09/12	28/08/12	A	03/09/12 BMCE-TRANSMIT-010687		
		This Was issued for information on BMCE-TRANSMIT-018729 09/12/13	MER	C	ME-SZ-00-PL-571-513	Ground Floor Plan NCH/OPD CCTV & Door Access Layout Zone C/B			E	17/08/12	21/08/12	BMCE-TRANSMIT-010416 (BMCE-WTRAN-003791)	11/09/12	28/08/12	B	03/09/12 BMCE-TRANSMIT-010687		
		This drawing was issue to the board for information only on BME-TRANSMIT-018592 26/11/13	MER	C	ME-SZ-01-PL-571-506	First Floor Plan. NCH Theatres, Endoscopy & Recovery. CCTV & Door Access Layout	13/07/12		F	17/08/12	21/08/12	BMCE-TRANSMIT-010416 (BMCE-WTRAN-003791)	11/09/12	28/08/12	B	03/09/12 BMCE-TRANSMIT-010687		
		This Was issued for information on BMCE-TRANSMIT-018729 09/12/13	MER	C	ME-ZC-01-PL-571-511	First Floor Plan NCH Day & 23 Hour Unit CCTV & Door Access Layout	13/07/12		C	17/08/12	21/08/12	BMCE-TRANSMIT-010416 (BMCE-WTRAN-003791)	11/09/12	28/08/12	B	03/09/12 BMCE-TRANSMIT-010687		

Drawing Information

31 BCL-AC-XX-SH-001

1st Submission2nd Submission

			Action By	Zone	Drawing Number	Drawing Title	Date Required from Consultant	Date Submitted by Consultant	Document Revision	Planned Date to be Submitted to Board	Date Submitted to Board	BMCE Transmittal No	Date Response Required from Board	Date Returned from Board	Board Status	Date returned to Consultant	Date Required from Consultant	Date Submitted by Consultant
Item	Submission	Comments																
	Nurses Call	This Was issued for information on BMCE-TRANSMIT-018729 09/12/13	MER	C	ME-ZC-00-PL-538-509	Ground Floor Plan NCH OPD Nurse Call layout	13/07/12		A	17/08/12	21/08/12	BMCE-TRANSMIT-010406 (BMCE-TRANSMIT-003786)	11/09/12	03/09/12	B	21/09/12 BMCE-TRANSMIT-011091		
			MER	C	ME-ZC-00-PL-538-510	Ground Floor Plan NCH Main Entrance & Pub ic Areas. Nurse Call Layout	13/07/12		A	17/08/12	21/08/12	BMCE-TRANSMIT-010406 (BMCE-TRANSMIT-003786)	11/09/12	03/09/12	A	21/09/12 BMCE-TRANSMIT-011091		
		This Was issued for information on BMCE-TRANSMIT-018729 09/12/13	MER	C	ME-ZC-00-PL-538-511	Ground Floor Plan NCH Main Entrance & Pub ic Areas. Nurse Call Layout	13/07/12		A	17/08/12	21/08/12	BMCE-TRANSMIT-010406 (BMCE-TRANSMIT-003786)	11/09/12	03/09/12	B	21/09/12 BMCE-TRANSMIT-011091		
			MER	C	ME-SZ-01-PL-538-506	First Floor Plan NCH Theatres, Endoscopy & Recovery Unit Nurse Call Layout	13/07/12		D	17/08/12	21/08/12	BMCE-TRANSMIT-010406 (BMCE-TRANSMIT-003786)	11/09/12	03/09/12	C	21/09/12 BMCE-TRANSMIT-011091		
		This Was issued for information on BMCE-TRANSMIT-018729 09/12/13	MER	C	ME-SZ-00-PL-538-513	Ground Floor Plan NCH OPD Nurse Call Layout Zone B/C			C	17/80/12	21/08/12	BMCE-TRANSMIT-010406 (BMCE-TRANSMIT-003786)	11/09/12	03/09/12	B	21/09/12 BMCE-TRANSMIT-011091		
		This Was issued for information on BMCE-TRANSMIT-018729 09/12/13	MER	C	ME-ZC-01-PL-538-511	First Floor Plan NCH Day & 23 Hour Unit Nurse Call Layout	13/07/12		A	17/08/12	21/08/12	BMCE-TRANSMIT-010406 (BMCE-TRANSMIT-003786)	11/09/12	03/09/12	B	21/09/12 BMCE-TRANSMIT-011091		
		This Was issued for information on BMCE-TRANSMIT-018729 09/12/13	MER	C	ME-ZC-01-PL-538-512	First Floor Plan NCH 23 Hour Recovery Nurse Call Layout	13/07/12		A	17/08/12	21/08/12	BMCE-TRANSMIT-010406 (BMCE-TRANSMIT-003786)	11/09/12	03/09/12	B	21/09/12 BMCE-TRANSMIT-011091		
			MER	C	ME-SZ-01-PL-538-520	First Floor Plan. Medical Day unit Nurse Call Layout Zone B/G			A		06/12/12		27/12/12					
			MER	C	ME-ZC-02-PL-538-508	Second Floor Plan NCH Schiehallion Ward (Haemato/Oncology) Day Case & TCT Nurse Call Layout	13/07/12		A	17/08/12	21/08/12	BMCE-TRANSMIT-010406 (BMCE-TRANSMIT-003786)	11/09/12	03/09/12	A	21/09/12 BMCE-TRANSMIT-011091		
		This Was issued for information on BMCE-TRANSMIT-018729 09/12/13	MER	C	ME-ZC-02-PL-538-509	Second Floor Plan NCH Schiehallion Ward (Haemato/Oncology) Day Case & TCT Nurse Call Layout	13/07/12		A	17/08/12	21/08/12	BMCE-TRANSMIT-010406 (BMCE-TRANSMIT-003786)	11/09/12	03/09/12	B	21/09/12 BMCE-TRANSMIT-011091		
			MER	C	ME-ZC-03-PL-538-505	Third Floor Plan NCH Inpatient Wards & Ward Support Nurse Ca l Layout	13/07/12		A	17/08/12	21/08/12	BMCE-TRANSMIT-010406 (BMCE-TRANSMIT-003786)	11/09/12	03/09/12	A	21/09/12 BMCE-TRANSMIT-011091		
		This Was issued for information on BMCE-TRANSMIT-018729 09/12/13	MER	C	ME-ZC-03-PL-538-506	Third Floor Plan NCH Inpatient Wards & Ward Support Nurse Ca l Layout	13/07/12		A	17/08/12	21/08/12	BMCE-TRANSMIT-010406 (BMCE-TRANSMIT-003786)	11/09/12	03/09/12	B	21/09/12 BMCE-TRANSMIT-011091		
		This Was issued for information on BMCE-TRANSMIT-018729 09/12/13	MER	C	ME-ZC-03-PL-538-507	Third Floor Plan NCH Inpatient Wards & Ward Support Nurse Ca l Layout	13/07/12		A	17/08/12	21/08/12	BMCE-TRANSMIT-010406 (BMCE-TRANSMIT-003786)	11/09/12	03/09/12	B	21/09/12 BMCE-TRANSMIT-011091		
			MER	C	ME-SZ-03-PL-538-508	Third Floor Plan. NCH Inpatient Wards & Ward Support Nurses Call Layout Zone B/C			C	17/08/12	21/08/12	BMCE-TRANSMIT-010406 (BMCE-TRANSMIT-003786)	11/09/12	03/09/12	A	21/09/12 BMCE-TRANSMIT-011091		
		This Was issued for information on BMCE-TRANSMIT-018729 09/12/13	MER	C	ME-ZC-04-PL-538-515	Fourth Floor Plan NCH DCFP Nurse Ca l Layout	13/07/12		A	17/08/12	21/08/12	BMCE-TRANSMIT-010406 (BMCE-TRANSMIT-003786)	11/09/12	03/09/12	B	21/09/12 BMCE-TRANSMIT-011091		
		This Was issued for information on BMCE-TRANSMIT-018729 09/12/13	MER	C	ME-ZC-04-PL-538-516	Fourth Floor Plan NCH DCFP Nurse Ca l Layout	13/07/12		A	17/08/12	21/08/12	BMCE-TRANSMIT-010406 (BMCE-TRANSMIT-003786)	11/09/12	03/09/12	B	21/09/12 BMCE-TRANSMIT-011091		
		This Was issued for information on BMCE-TRANSMIT-018729 09/12/13	MER	C	ME-ZC-04-PL-538-517	Fourth Floor Plan NCH DCFP Nurse Ca l Layout	13/07/12		A	17/08/12	21/08/12	BMCE-TRANSMIT-010406 (BMCE-TRANSMIT-003786)	11/09/12	03/09/12	B	21/09/12 BMCE-TRANSMIT-011091		
	Mechanical Service Drawings	Issued for information 15/10/13 BMCE-TRANSMIT-018068	ZBP	D	ZBP-ZD-00-PL-512-004	Medical Gases Layout Ground	26/06/11		A	05/10/11	11/10/11	BMCE-TRANSMIT-006203	01/11/11		B	11/10/11 BMCE-TRANSMIT-007082		
		Issued for information 15/10/13 BMCE-TRANSMIT-018068	ZBP	D	ZBP-ZD-01-PL-512-014	Medical Gases Layout First	26/06/11		A	05/10/11	11/10/11	BMCE-TRANSMIT-006203	01/11/11		B	11/10/11 BMCE-TRANSMIT-007082		
		Issued for information 15/10/13 BMCE-TRANSMIT-018068	ZBP	D	ZBP-ZD-02-PL-512-024	Medical Gases Layout 2nd Floor Adult Theatres	26/06/11		A	05/10/11	22/12/11	BMCE-TRANSMIT-007183		07/03/12	B	23/3/12 BMCE-TRANSMIT-008108		
		Issued for information 15/10/13 BMCE-TRANSMIT-018068	ZBP	D	ZBP-ZD-00-PL-523-004	HTG & CHW Layout Ground	26/06/11		A	05/10/11	11/10/11	BMCE-TRANSMIT-006203	01/11/11		B	12/12/2011 BMCE-TRANSMIT-12/12/2011 BMCE-TRANSMIT-		
		Issued for information 15/10/13 BMCE-TRANSMIT-018068	ZBP	D	ZBP-ZD-01-PL-523-014	HTG & CHW Layout First	26/06/11		A	05/10/11	11/10/11	BMCE-TRANSMIT-006203	01/11/11		B	12/12/2011 BMCE-TRANSMIT-		
		Issued for information 15/10/13 BMCE-TRANSMIT-018068	ZBP	D	ZBP-ZD-02-PL-523-024	HTG & CHW Layout 2nd Floor			A		22/12/11	BMCE-TRANSMIT-007183		07/03/12	B	23/3/12 BMCE-TRANSMIT-008108		
			ZBP	D	ZBP-ZD-00-PL-524-004	Ventilation Layout Ground	26/06/11		A	05/10/11	11/10/11	BMCE-TRANSMIT-006203	01/11/11		C	12/12/2011 BMCE-TRANSMIT-		
			ZBP	D	ZBP-ZD-01-PL-524-014	Ventilation Layout First	26/06/11		A	05/10/11	11/10/11	BMCE-TRANSMIT-006203	01/11/11		C	12/12/2011 BMCE-TRANSMIT-		
		Issued for information 15/10/13 BMCE-TRANSMIT-018068	ZBP	D	ZBP-ZD-02-PL-524-024	Ventilation Layout 2nd Floor NSGH Theatres			A		22/12/11	BMCE-TRANSMIT-007183		07/03/12	B	23/3/12 BMCE-TRANSMIT-008108		
		Issued for information 15/10/13 BMCE-TRANSMIT-018068	ZBP	D	ZBP-ZD-00-PL-526-004	Environmental Strategy Ground	26/06/11		A (B)	05/10/11	20/12/11	BMCE-TRANSMIT-007149 (REV B SUBMITTED 16.02.12	10/01/12	11/05/12	B (REV B)	21/05/12 BMCE-TRANSMIT-		

Drawing Information

31 BCL-AC-XX-SH-001

			Action By	Zone	Drawing Number	Drawing Title	Date Required from Consultant	Date Submitted by Consultant	Document Revision	Planned Date to be Submitted to Board	Date Submitted to Board	BMCE Transmittal No	Date Response Required from Board	Date Returned from Board	Board Status	Date returned to Consultant	Date Required from Consultant	Date Submitted by Consultant
Item	Submission	Comments																
	Public Health Services Drawings	Issued for information 15/10/13 BMCE-TRANSMIT-018068	ZBP	D	ZBP-ZD-00-PL-500-004	Water & Gas Services Layout Ground	26/06/11		A	05/10/11	11/10/11	BMCE-TRANSMIT-006204	01/11/11	27/01/12	B	BMCE-TRANSMIT-007446 27/01/12		
		Issued for information 15/10/13 BMCE-TRANSMIT-018068	ZBP	D	ZBP-ZD-01-PL-500-014	Water & Gas Services Layout First	26/06/11		A	05/10/11	11/10/11	BMCE-TRANSMIT-006204	01/11/11	27/01/12	B	BMCE-TRANSMIT-007446 27/01/12		
		Issued for information 15/10/13 BMCE-TRANSMIT-018068	ZBP	D	ZBP-ZD-02-PL-500-024	Water & Gas Services Layout Second	26/06/11		A	05/10/11	22/12/11	BMCE-TRANSMIT-007184	12/01/12		B	15/02/12 BMCE-TRANSMIT-007642		
			ZBP	D	ZBP-ZD-00-PL-581-004	Sanitation and Rainwater Layout Ground	26/06/11		C	05/10/11	09/02/12	BMCE-TRANSMIT-007409	01/03/12	12/03/12	A	23/3/2012 BMCE TRANSMIT-008110		
			ZBP	D	ZBP-ZD-01-PL-581-014	Sanitation and Rainwater Layout First	26/06/11		B	05/10/11					B	15/02/12 BMCE-TRANSMIT-007642		
			ZBP	D	ZBP-ZD-02-PL-581-024	Sanitation and Rainwater Layout Second	26/06/11		D	05/10/11	18/05/12	BMCE-TRANSMIT-008930 (BMCE-WTRAN-003105)	08/06/12	06/07/12	A	19/07/12 BMCE-TRANSMIT-009816		
			ZBP	D	ZBP-ZD-03-PL-581-034	Sanitation and Rainwater Layout Third			B		14/06/12	BMCE-TRNSMIT-009356 (BMCE-WTRAN-003280)	05/07/12	10/09/12	A	05/10/12 BMCE-TRANSMIT-011383		
		Removed by ZBP	ZBP	D	ZBP-ZD-04-PL-581-044	Sanitation and Rainwater Layout Fourth				-			21/01/00					
	Riser Drawings		ZBP	D	ZBP-ZD-XX-PL-520-601	Riser M3	26/08/11		A	05/10/11	11/10/11	BMCE-TRANSMIT-006205	01/11/11	27/01/12	C	BMCE-TRANSMIT-007447 27/01/12		
		This was issued for information on BMCE-TRANSMIT-018068	ZBP	D	ZBP-ZD-XX-PL-520-602	Riser M4	26/08/11		A	05/10/11	11/10/11	BMCE-TRANSMIT-006205	01/11/11	27/01/12	B	BMCE-TRANSMIT-007447 27/01/12		
		This was issued for information on BMCE-TRANSMIT-018068	ZBP	D	ZBP-ZD-XX-PL-520-603	Riser M5	26/08/11		A	05/10/11	11/10/11	BMCE-TRANSMIT-006205	01/11/11	27/01/12	B	BMCE-TRANSMIT-007447 27/01/12		

			Action By		Zone	Drawing Number	Drawing Title	Date Required from Consultant	Date Submitted by Consultant	Document Revision	Planned Date to be Submitted to Board	Date Submitted to Board	BMCE Transmittal No	Date Response Required from Board	Date Returned from Board	Board Status	Date returned to Consultant	Date Required from Consultant	Date Submitted by Consultant
Item	Submission	Comments																	
		This was issued for information on BMCE-TRANSMIT-018068	ZBP	D	ZBP-ZD-XX-PL-520-604	Riser M6	26/08/11			A	05/10/11	11/10/11	BMCE-TRANSMIT-006205	01/11/11	27/01/12	B	BMCE-TRANSMIT-007447 27/01/12		
		This was issued for information on BMCE-TRANSMIT-018068	ZBP	D	ZBP-ZD-XX-PL-520-605	Riser M15A	26/08/11			A	05/10/11	11/10/11	BMCE-TRANSMIT-006205	01/11/11	27/01/12	B	BMCE-TRANSMIT-007447 27/01/12		
			ZBP	D	ZBP-ZD-XX-PL-520-606	Riser M15B	26/08/11				05/10/11	17/10/12	BMCE-TRANSMIT-011677 (BMCE-WTRAN-004260)	07/11/12	22/10/12	A	BMCE-TRANSMIT-007447 27/01/12 25/10/12 BMCE-TRANSMIT-011879		
		Removed by ZBP	ZBP	D	ZBP-ZD-02-PL-512-024	Medical Gases Layout-Second-	26/06/11				05/10/11			-					
		Removed by ZBP	ZBP	D	ZBP-ZD-02-PL-523-024	HTG & CHW Layout-Second-	26/06/11				05/10/11			-					
		Removed by ZBP	ZBP	D	ZBP-ZD-02-PL-524-024	Ventilation Layout-Second-	26/06/11				05/10/11			-					
		Removed by ZBP	ZBP	D	ZBP-ZD-02-PL-526-024	En-ironmental Treatment-Second-	26/06/11				05/10/11			-					
		Removed by ZBP	ZBP	D	ZBP-ZD-02-PL-531-024	Small Power Layout-Second-	26/06/11			A	05/10/11	08/12/11	BMCE-TRANSMIT-007034	-					
		Removed by ZBP	ZBP	D	ZBP-ZD-02-PL-532-024	Containment/Sub-Main Layout-Second-	26/06/11			A	05/10/11	08/12/11	BMCE-TRANSMIT-007034	-					
		Removed by ZBP	ZBP	D	ZBP-ZD-02-PL-671-024	Security Layout-Second-	26/06/11			A	05/10/11	08/12/11	BMCE-TRANSMIT-007034	-					
		Removed by ZBP	ZBP	D	ZBP-ZD-02-PL-500-024	Water & Gas Services Layout-Second-	26/06/11			A	05/10/11	22/12/11	BMCE-TRANSMIT-007184	-					
		Removed by ZBP	ZBP	D	ZBP-ZD-02-PL-581-024	Sanitation and Rainwater Layout-Second Floor-Theatres				B		22/12/11	BMCE-TRANSMIT-007184						
		Removed by ZBP	ZBP	D	ZBP-ZG-02-PL-581-027	Sanitation and Rainwater Layout-Second-	15/06/11				05/10/11			-					
	Mechanical Services Drawings Plantroom 21	Removed by ZBP	ZBP	D	ZBP-ZD-02-PL-512-101	Plantroom 21-Medical Gases--	26/06/11				05/10/11								
		Removed by ZBP	ZBP	D	ZBP-ZD-02-PL-512-102	Plantroom 21-Medical Gases--	26/06/11				05/10/11								
		Issued for information 15/10/13 BMCE-TRANSMIT-018068	ZBP	D	ZBP-ZD-02-PL-523-101	Plantroom 21 Pipework	26/06/11			A	05/10/11	20/01/12	BMCE-TRANSMIT-007410 9RE ISSUED 28/05/12 BMCE-TRANSMIT-009102)	10/02/12	19/07/12	B	28/07/12 BMCE-TRANSMIT-010060		
		Issued for information 15/10/13 BMCE-TRANSMIT-018068	ZBP	D	ZBP-ZD-02-PL-523-102	Plantroom 21 HTG & CHW-	26/06/11			A	05/10/11	20/01/12	BMCE-TRANSMIT-007410 9RE ISSUED 28/05/12 BMCE-TRANSMIT-009102)	10/02/12	19/07/12	B	28/07/12 BMCE-TRANSMIT-010060		
		Issued for information 15/10/13 BMCE-TRANSMIT-018068	ZBP	D	ZBP-ZD-02-PL-524-101	Plantroom 21 Ventilation-	26/06/11			A	05/10/11	20/01/12	BMCE-TRANSMIT-007410 9RE ISSUED 28/05/12 BMCE-TRANSMIT-009102)	10/02/12	19/07/12	B	28/07/12 BMCE-TRANSMIT-010060		
		Issued for information 15/10/13 BMCE-TRANSMIT-018068	ZBP	D	ZBP-ZD-02-PL-524-102	Plantroom 21 Ventilation-	26/06/11			A	05/10/11	20/01/12	BMCE-TRANSMIT-007410 9RE ISSUED 28/05/12 BMCE-TRANSMIT-009102)	10/02/12	19/07/12	B	28/07/12 BMCE-TRANSMIT-010060		
	Electrical Services Drawings	Issued for information 15/10/13 BMCE-TRANSMIT-018068	ZBP	D	ZBP-ZD-02-PL-532-101	Plantroom 21 LV Power -	26/06/11			A	05/10/11	20/12/11	BMCE-TRANSMIT-007151	10/01/12	24/04/12	B	14/05/12 BMCE-TRANSMIT-008794		
		Removed by ZBP	ZBP	D	ZBP-ZD-02-PL-532-102	Plantroom 21-LV Power--	26/06/11				05/10/11			-					
	Public Health Services Drawings	Removed by ZBP	ZBP	D	ZBP-ZD-02-PL-500-101	Plantroom 21-Water Services--	26/06/11				05/10/11								
		Removed by ZBP	ZBP	D	ZBP-ZD-02-PL-500-102	Plantroom 21-Water Services--	26/06/11				05/10/11								
		Removed by ZBP	ZBP	D	ZBP-ZD-02-PL-581-024	Plantroom 21-Sanitation and Rainwater Layout-	03/11/11				05/10/11			-					
		Removed by ZBP	ZBP	D	ZBP-ZD-02-PL-581-034	Plantroom 21-Roof Sanitation and Rainwater Layout-	03/11/11				05/10/11			-					
		Removed by ZBP	ZBP	D	ZBP-ZD-02-PL-581-211	Plantroom 21-Sanitation and Rainwater Layout-	26/06/11				05/10/11			-					
		Removed by ZBP	ZBP	D	ZBP-ZD-02-PL-581-212	Plantroom 21-Sanitation and Rainwater Layout-	26/06/11				05/10/11			-					

Drawing Information

31

BCL-AC-XX-SH-001

1st Submission

2nd Submission

Item	Submission	Comments	Action By Zone		Drawing Number	Drawing Title	Date Required from Consultant	Date Submitted by Consultant	Document Revision	Planned Date to be Submitted to Board	Date Submitted to Board	BMCE Transmittal No	Date Response Required from Board	Date Returned from Board	Board Status	Date returned to Consultant	Date Required from Consultant	Date Submitted by Consultant
		Issued for information on BMCE-TRANSMIT-019288 04/02/14	MER	D	ME-ZD-01-PL-541-524	First Floor Plan. NSGH - Critical Care Lighting Layout	26/06/11	16/09/11	C	05/10/11				29/11/11	C	12/12/2011 BMCE-TRANSMIT-		
			MER	D	ME-ZD-02-PL-541-516	Second Floor Plan NSGH Telephone Services, Renal Plant & FM Emergency Linen Lighting Layout	26/06/11		B	05/10/11				29/11/11	D	12/12/2011 BMCE-TRANSMIT-		
			MER	D	ME-SZ-02-PL-541-520	Second Floor Plan, Theatres Lighting Layout		16/09/11	B					30/11/11	C	12/12/2011 BMCE-TRANSMIT-		
		Issued for information on BMCE-TRANSMIT-018737 09/12/13	MER	D	ME-SZ-02-PL-541-522	Second Floor Plan, Theatres Lighting Layout		16/09/11	B					30/11/11	B	12/12/2011 BMCE-TRANSMIT-		
		Issued for information on BMCE-TRANSMIT-018737 09/12/13	MER	D	ME-SZ-02-PL-541-521	Second Floor Plan, Theatres Lighting Layout		16/09/11	B					30/11/11	B	12/12/2011 BMCE-TRANSMIT-		
		Removed by Mercury - WRONG DRAWING NO.	MER	D	ME-XX-XX-SP-541-100	Lighting Calculations—Zone-D												
		Removed by Mercury - DUPLICATE	MER	D	ME-XX-XX-SP-541-101	Luminaire Schedule—Zone-D												
		Removed By Mercury - NOT REQUIRED FOR RDD (SMALL POWER SHOWN ON NA 400 SERIES DRAWINGS)	MER	D	ME-ZD-00-PL-531-521	Ground Floor Plan - NSGH - Emergency Dept Small Power & General Services Layout	26/06/11			05/10/11								
		Removed By Mercury - NOT REQUIRED FOR RDD (SMALL POWER SHOWN ON NA 400 SERIES DRAWINGS)	MER	D	ME-ZD-01-PL-531-521	First Floor Plan - NSGH - CCU Small Power & General Services Layout	26/06/11			05/10/11								
		Removed By Mercury - NOT REQUIRED FOR RDD (SMALL POWER SHOWN ON NA 400 SERIES DRAWINGS)	MER	D	ME-ZD-01-PL-531-522	First Floor Plan - NSGH - CCU Small Power & General Services Layout	26/06/11			05/10/11								
		Removed By Mercury - NOT REQUIRED FOR RDD (SMALL POWER SHOWN ON NA 400 SERIES DRAWINGS)	MER	D	ME-ZD-01-PL-531-523	First Floor Plan - NSGH - Critical Care Small Power & General Services Layout	26/06/11			05/10/11								
		Removed By Mercury - NOT REQUIRED FOR RDD (SMALL POWER SHOWN ON NA 400 SERIES DRAWINGS)	MER	D	ME-ZD-01-PL-531-524	First Floor Plan - NSGH - Critical Care Small Power & General Services Layout	26/06/11			05/10/11								
		Removed By Mercury - NOT REQUIRED FOR RDD (SMALL POWER SHOWN ON NA 400 SERIES DRAWINGS)	MER	D	ME-ZD-02-PL-531-516	Second Floor Plan NSGH Telephone Services, Renal Plant & FM Emergency Linen Small Power & General Services Layout	26/06/11			05/10/11								
		Removed By Mercury - NOT REQUIRED FOR RDD (SMALL POWER SHOWN ON NA 400 SERIES DRAWINGS)	MER	D	ME-ZD-00-PL-532-521	Ground Floor Plan - NSGH - Emergency Dept High Level Layout	26/06/11			05/10/11								
		Removed By Mercury - NOT REQUIRED FOR RDD (SMALL POWER SHOWN ON NA 400 SERIES DRAWINGS)	MER	D	ME-ZD-01-PL-532-521	First Floor Plan - NSGH - CCU High Level Layout	26/06/11			05/10/11								
		Removed By Mercury - NOT REQUIRED FOR RDD (SMALL POWER SHOWN ON NA 400 SERIES DRAWINGS)	MER	D	ME-ZD-01-PL-532-522	First Floor Plan - NSGH - CCU High Level Layout	26/06/11			05/10/11								
		Removed By Mercury - NOT REQUIRED FOR RDD (SMALL POWER SHOWN ON NA 400 SERIES DRAWINGS)	MER	D	ME-ZD-01-PL-532-523	First Floor Plan - NSGH - Critical Care High Level Layout	26/06/11			05/10/11								
		Removed By Mercury - NOT REQUIRED FOR RDD (SMALL POWER SHOWN ON NA 400 SERIES DRAWINGS)	MER	D	ME-ZD-01-PL-532-524	First Floor Plan - NSGH - Critical Care High Level Layout	26/06/11			05/10/11								
		Removed By Mercury - NOT REQUIRED FOR RDD (SMALL POWER SHOWN ON NA 400 SERIES DRAWINGS)	MER	D	ME-ZD-02-PL-532-516	Second Floor Plan NSGH Telephone Services, Renal Plant & FM Emergency Linen High Level Layout	26/06/11			05/10/11								
		Removed By Mercury - NOT REQUIRED FOR RDD (SMALL POWER SHOWN ON NA 400 SERIES DRAWINGS)	MER	D	ME-ZD-00-PL-532-521	Ground Floor Plan - NSGH - Emergency Dept ELV Systems low level Layout	26/06/11			05/10/11								
		Removed By Mercury - NOT REQUIRED FOR RDD (SMALL POWER SHOWN ON NA 400 SERIES DRAWINGS)	MER	D	ME-ZD-01-PL-532-521	First Floor Plan - NSGH - CCU ELV Systems low level Layout	26/06/11			05/10/11								
		Removed By Mercury - NOT REQUIRED FOR RDD (SMALL POWER SHOWN ON NA 400 SERIES DRAWINGS)	MER	D	ME-ZD-01-PL-532-522	First Floor Plan - NSGH - CCU ELV Systems low level Layout	26/06/11			05/10/11								
		Removed By Mercury - NOT REQUIRED FOR RDD (SMALL POWER SHOWN ON NA 400 SERIES DRAWINGS)	MER	D	ME-ZD-01-PL-532-523	First Floor Plan - NSGH - Critical Care ELV Systems low level Layout	26/06/11			05/10/11								
		Removed By Mercury - NOT REQUIRED FOR RDD (SMALL POWER SHOWN ON NA 400 SERIES DRAWINGS)	MER	D	ME-ZD-01-PL-532-524	First Floor Plan - NSGH - Critical Care ELV Systems low level Layout	26/06/11			05/10/11								
		Removed By Mercury - NOT REQUIRED FOR RDD (SMALL POWER SHOWN ON NA 400 SERIES DRAWINGS)	MER	D	ME-ZD-02-PL-532-516	Second Floor Plan NSGH Telephone Services, Renal Plant & FM Emergency Linen ELV Systems low level Layout	26/06/11			05/10/11								
	Data Comms	Issued for information on BMCE-TRANSMIT-019288 04/02/14	MER	D	ME-SZ-00-PL-556-519	Ground Floor Plan - NSGH Emergency Dept Data Comms Layout		16/09/11	A		07/10/11	BMCE-TRANSMIT-006148	28/10/11	19/11/11	C	12/12/2011 BMCE-TRANSMIT-		
			MER	D	ME-SZ-00-PL-556-520	Ground Floor Plan - NSGH Emergency Dept Data Comms Layout		16/09/11	A		07/10/11	BMCE-TRANSMIT-006148	28/10/11	19/11/11	C	12/12/2011 BMCE-TRANSMIT-		
			MER	D	ME-ZD-00-PL-556-521	Ground Floor Plan. NSGH - Emergency Dept Data Comms Layout	26/06/11	16/09/11	A	05/10/11	07/10/11	BMCE-TRANSMIT-006148	28/10/11	19/11/11	D	12/12/2011 BMCE-TRANSMIT-		
			MER	D	ME-SZ-00-PL-556-522	Ground Floor Plan NSGH - Emergency Dept Data Comms Layout		16/09/11	A		07/10/11	BMCE-TRANSMIT-006148	28/10/11	19/11/11	D	12/12/2011 BMCE-TRANSMIT-		
		This was issued for information on BMCE-TRANSMIT-018891 18/12/13	MER	D	ME-SZ-00-PL-556-523	Ground Floor Plan NSGH - Emergency Dept Data Comms Layout		16/09/11	A		07/10/11	BMCE-TRANSMIT-006148	28/10/11	19/11/11	B	12/12/2011 BMCE-		

Drawing Information

31 BCL-AC-XX-SH-001

			Action By	Zone	Drawing Number	Drawing Title	Date Required from Consultant	Date Submitted by Consultant	Document Revision	Planned Date to be Submitted to Board	Date Submitted to Board	BMCE Transmittal No	Date Response Required from Board	Date Returned from Board	Board Status	Date returned to Consultant	Date Required from Consultant	Date Submitted by Consultant
Item	Submission	Comments																
			MER	D	ME-ZD-02-PL-575-302	Second Floor Void Layout			2		07/10/11	BMCE-TRANSMIT-006144	28/10/11	14/11/11	B	23/02/12 BMCE-TRANSMIT-007774		
			MER	D	ME-ZD-02-PL-575-303	Second Floor Ceiling layout			2		07/10/11	BMCE-TRANSMIT-006144	28/10/11	14/11/11	B	23/02/12 BMCE-TRANSMIT-007774		
			MER	D	ME-ZD-03-PL-575-302	Third Floor Void Layout			2		07/10/11	BMCE-TRANSMIT-006144	28/10/11	14/11/11	A	23/02/12 BMCE-TRANSMIT-007774		
BMS		Removed By Mercury - NOT REQUIRED FOR RDD (PART OF BMS DETAIL DESIGN)	MER	D	ME-ZD-00-PL-660-521	Ground Floor Plan- NSGH – Emergency Dept BMS Layout	26/06/11			06/10/11								
		Removed By Mercury - NOT REQUIRED FOR RDD (PART OF BMS DETAIL DESIGN)	MER	D	ME-ZD-01-PL-660-521	First Floor Plan- NSGH – CCU BMS Layout	26/06/11			06/10/11								
		Removed By Mercury - NOT REQUIRED FOR RDD (PART OF BMS DETAIL DESIGN)	MER	D	ME-ZD-01-PL-660-522	First Floor Plan- NSGH – CCU BMS Layout	26/06/11			06/10/11								
		Removed By Mercury - NOT REQUIRED FOR RDD (PART OF BMS DETAIL DESIGN)	MER	D	ME-ZD-01-PL-660-523	First Floor Plan- NSGH – Critical Care BMS Layout	26/06/11			06/10/11								
		Removed By Mercury - NOT REQUIRED FOR RDD (PART OF BMS DETAIL DESIGN)	MER	D	ME-ZD-01-PL-660-524	First Floor Plan- NSGH – Critical Care BMS Layout	26/06/11			06/10/11								

Drawing Information

31 BCL-AC-XX-SH-001

1st Submission2nd Submission

			Action By	Zone	Drawing Number	Drawing Title	Date Required from Consultant	Date Submitted by Consultant	Document Revision	Planned Date to be Submitted to Board	Date Submitted to Board	BMCE Transmittal No	Date Response Required from Board	Date Returned from Board	Board Status	Date returned to Consultant	Date Required from Consultant	Date Submitted by Consultant
Item	Submission	Comments																
		Removed By Mercury - NOT REQUIRED FOR RDD (PART OF BMS DETAIL DESIGN)	MER	D	ME-ZD-02-PL-660-516	Second Floor Plan-NSGH -Telephone Services, Renal Plant & FM- Emergency Linen Layout	26/06/11			06/10/11								
	MEDICAL GASES	Not required for RDD Review Issued to board for information only BMCE-TRANSMIT-017701	MER	D	ME-ZD-00-DC-H512-001	Level 0, Adults EMC Treatment rooms from EMC-008												
		Not required for RDD Review Issued to board for information only BMCE-TRANSMIT-017701	MER	D	ME-ZD-00-DC-H512-002	Level 0, Adults EMC Resus (Room EMC-105), Major Treatment rooms & mains												
		Not required for RDD Review Issued to board for information only BMCE-TRANSMIT-017701	MER	D	ME-ZD-01-DC-H512-001	Level 1, CCU from CCU-070, Mains & GCW												
		Not required for RDD Review Issued to board for information only BMCE-TRANSMIT-017701	MER	D	ME-ZD-03-DC-H512-001	SAT/MAT From L3 to PRVs			A		14/08/13	BMCE-TRANSMIT-017263 (BMCE-WTRAN-008566)	04/09/13	16/10/13	D	16/10/13 BMCE-TRANSMIT-018131		
			MER	D	ME-ZD-00-PL-H512-001	Medical Gas Installation, Level 0, Zone D			1		29/05/12	BMCE-TRANSMIT-009131 (BMCE-WTRAN-003175)	19/06/12	24/09/12	C	27/09/12 BMCE-TRANSMIT-011192		
			MER	D	ME-ZD-00-PL-H512-002	Medical Gas Installation, Level 0, Zone D - AGSS			1		29/05/12	BMCE-TRANSMIT-009131 (BMCE-WTRAN-003175)	19/06/12	24/09/12	C	27/09/12 BMCE-TRANSMIT-011199		
		Issued for information on BMCE-TRANSMIT-019817 31/03/14	MER	D	ME-ZD-01-PL-H512-001	Medical Gas Installation, Level 1, Zone D			1		29/05/12	BMCE-TRANSMIT-009127 (BMCE-WTRAN-003174)	19/06/12	24/09/12	C	27/09/12 BMCE-TRANSMIT-011196		
			MER	D	ME-ZD-01-PL-H512-002	Medical Gas Installation, Level 1, Zone D - AGSS			1		29/05/12	BMCE-TRANSMIT-009127 (BMCE-WTRAN-003174)	19/06/12	24/09/12	C	27/09/12 BMCE-TRANSMIT-011196		
		Issued for information on BMCE-TRANSMIT-019817 31/03/14	MER	D	ME-ZD-02-PL-H512-001	Medical Gas Installation, Level 2, Zone D			1		29/05/12	BMCE-TRANSMIT-009123 (BMCE-WTRAN-003172)	19/06/12	15/08/12	C	20/08/12 BMCE-TRANSMIT-010372		
			MER	D	ME-ZD-02-PL-H512-002	Medical Gas Installation, Level 2, Zone D - AGSS			1		29/05/12	BMCE-TRANSMIT-009123 (BMCE-WTRAN-003172)	19/06/12	24/09/12	C	27/09/12 BMCE-TRANSMIT-011202		
			MER	D	ME-ZD-03-PL-H512-001	Medical Gas Installation, Level 3, Zone D			1		29/05/12	BMCE-TRANSMIT-009125 (BMCE-WTRAN-003173)	19/06/12	01/10/12	C	04/10/12 BMCE-TRANSMIT-011325		
			MER	D	ME-ZD-03-PL-H512-002	Medical Gas Installation, Level 3, Zone D - AGSS			1		29/05/12	BMCE-TRANSMIT-009125 (BMCE-WTRAN-003173)	19/06/12	01/10/12	C	04/10/12 BMCE-TRANSMIT-011325		
			MER	D	ME-ZD-04-PL-H512-001	Medical Gas Installation, Level 4, Zone D			1		29/05/12	BMCE-TRANSMIT-009122 (BMCE-WTRAN-003171)	19/06/12	01/10/12	C	04/10/12 BMCE-TRANSMIT-011324		
		Removed By Mercury - NOT REQUIRED FOR RDD (REFER TO HPI H512 SERIES DESIGN DRAWINGS)	MER	D	ME-ZD-00-PL-512-521	Ground Floor Plan-NSGH -Emergency Dept-Medical Gases Layout	26/06/11			06/10/11								
		Removed By Mercury - NOT REQUIRED FOR RDD (REFER TO HPI H512 SERIES DESIGN DRAWINGS)	MER	D	ME-ZD-01-PL-512-521	First Floor Plan-NSGH -CCU-Medical Gases Layout	26/06/11			06/10/11								
		Removed By Mercury - NOT REQUIRED FOR RDD (REFER TO HPI H512 SERIES DESIGN DRAWINGS)	MER	D	ME-ZD-01-PL-512-522	First Floor Plan-NSGH -CCU-Medical Gases Layout	26/06/11			06/10/11								
		Removed By Mercury - NOT REQUIRED FOR RDD (REFER TO HPI H512 SERIES DESIGN DRAWINGS)	MER	D	ME-ZD-01-PL-512-523	First Floor Plan-NSGH -Critical Care-Medical Gases Layout	26/06/11			06/10/11								
		Removed By Mercury - NOT REQUIRED FOR RDD (REFER TO HPI H512 SERIES DESIGN DRAWINGS)	MER	D	ME-ZD-01-PL-512-524	First Floor Plan-NSGH -Critical Care-Medical Gases Layout	26/06/11			06/10/11								
		Removed By Mercury - NOT REQUIRED FOR RDD (REFER TO HPI H512 SERIES DESIGN DRAWINGS)	MER	D	ME-ZD-02-PL-512-516	Second Floor Plan-NSGH -Telephone Services, Renal Plant & FM- Emergency Linen Medical Gases Layout	26/06/11			06/10/11								
	FIRE DETECTION Install	Issued for information on BMCE-TRANSMIT-018737 09/12/13	MER	D	ME-SZ-00-PL-572-519	Ground Floor Plan, NSGH - Emergency Dept Fire Detection & Smoke Control Layout		16/09/11	A		07/10/11	BMCE-TRANSMIT-006149	28/10/11	14/11/11	B	12/12/2011 BMCE-TRANSMIT-		
		Issued for information on BMCE-TRANSMIT-018737 09/12/13	MER	D	ME-SZ-00-PL-572-520	Ground Floor Plan, NSGH - Emergency Dept Fire Detection & Smoke Control Layout		16/09/11	A		07/10/11	BMCE-TRANSMIT-006149	28/10/11	14/11/11	A	12/12/2011 BMCE-TRANSMIT-		
			MER	D	ME-ZD-00-PL-572-521	Ground Floor Plan, NSGH - Emergency Dept Fire Detection & Smoke Control Layout	26/06/11	16/09/11	A	05/10/11	07/10/11	BMCE-TRANSMIT-006149	28/10/11	14/11/11	B	12/12/2011 BMCE-TRANSMIT-		
		Issued for information on BMCE-TRANSMIT-018737 09/12/13	MER	D	ME-SZ-00-PL-572-522	Ground Floor Plan, NSGH - Emergency Dept Fire Detection & Smoke Control Layout		16/09/11	A		07/10/11	BMCE-TRANSMIT-006149	28/10/11	14/11/11	B	12/12/2011 BMCE-TRANSMIT-		
		Issued for information on BMCE-TRANSMIT-018737 09/12/13	MER	D	ME-SZ-00-PL-572-523	Ground Floor Plan, NSGH - Emergency Dept Fire Detection & Smoke Control Layout		16/09/11	A		07/10/11	BMCE-TRANSMIT-006149	28/10/11	14/11/11	B	12/12/2011 BMCE-TRANSMIT-		
		Issued for information on BMCE-TRANSMIT-018737 09/12/13	MER	D	ME-SZ-00-PL-572-524	Ground Floor Plan, NSGH - Emergency Dept Fire Detection & Smoke Control Layout		16/09/11	A		07/10/11	BMCE-TRANSMIT-006149	28/10/11	14/11/11	B	12/12/2011 BMCE-TRANSMIT-		
			MER	D	ME-ZD-01-PL-572-521	First Floor Plan, NSGH - CCU Fire Detection & Smoke Control Layout	26/06/11	16/09/11	A	05/10/11	07/10/11	BMCE-TRANSMIT-006149	28/10/11	14/11/11	A	12/12/2011 BMCE-TRANSMIT-		
			MER	D	ME-ZD-01-PL-572-522	First Floor Plan, NSGH - CCU Fire Detection & Smoke Control Layout	26/06/11	16/09/11	A	05/10/11	07/10/11	BMCE-TRANSMIT-006149	28/10/11	14/11/11	A	12/12/2011 BMCE-TRANSMIT-		
		Issued for information on BMCE-TRANSMIT-018737 09/12/13	MER	D	ME-ZD-01-PL-572-523	First Floor Plan, NSGH - Critical Care Fire Detection & Smoke Control Layout	26/06/11	16/09/11	A	05/10/11	07/10/11	BMCE-TRANSMIT-006149	28/10/11	14/11/11	B	12/12/2011 BMCE-		

Drawing Information

31 BCL-AC-XX-SH-001

1st Submission2nd Submission

			Action By	Zone	Drawing Number	Drawing Title	Date Required from Consultant	Date Submitted by Consultant	Document Revision	Planned Date to be Submitted to Board	Date Submitted to Board	BMCE Transmittal No	Date Response Required from Board	Date Returned from Board	Board Status	Date returned to Consultant	Date Required from Consultant	Date Submitted by Consultant
Item	Submission	Comments																
		Issued for information on BMCE-TRANSMIT-018737 09/12/13	MER	D	ME-ZD-01-PL-571-521	First Floor Plan, NSGH - CCU CCTV & Door Access Layout	26/08/11	16/09/11	A	06/10/11	07/10/11	BMCE-TRANSMIT-006145	28/10/11	03/07/12	B			
			MER	D	ME-ZD-01-PL-571-522	First Floor Plan, NSGH - CCU CCTV & Door Access Layout	26/08/11	16/09/11	A	06/10/11	07/10/11	BMCE-TRANSMIT-006145	28/10/11	03/07/12	A			
		Issued for information on BMCE-TRANSMIT-018737 09/12/13	MER	D	ME-ZD-01-PL-571-523	First Floor Plan, NSGH - CCU CCTV & Door Access Layout	26/08/11	16/09/11	A	06/10/11	07/10/11	BMCE-TRANSMIT-006145	28/10/11	03/07/12	B			
		Issued for information on BMCE-TRANSMIT-018737 09/12/13	MER	D	ME-ZD-01-PL-571-524	First Floor Plan, NSGH - CCU CCTV & Door Access Layout	26/08/11	16/09/11	A	06/10/11	07/10/11	BMCE-TRANSMIT-006145	28/10/11	03/07/12	B			
			MER	D	ME-ZD-02-PL-571-516	Second Floor Plan NSGH Telephone Services, Renal Plant & FM Emergency Linen CCTV & Door Access Layout	26/08/11	16/09/11	A	06/10/11	07/10/11	BMCE-TRANSMIT-006145	28/10/11	03/07/12	A			
		Issued for information on BMCE-TRANSMIT-018737 09/12/13	MER	D	ME-SZ-02-PL-571-520	Second Floor Plan, Theatres, CCTV & Door Access Layout	26/08/11			06/10/11	07/10/11	BMCE-TRANSMIT-006145	28/10/11	03/07/12	B			
			MER	D	ME-SZ-02-PL-571-521	Second Floor Plan, Theatres, CCTV & Door Access Layout	26/08/11			06/10/11	07/10/11	BMCE-TRANSMIT-006145	28/10/11	03/07/12	A			
			MER	D	ME-SZ-02-PL-571-522	Second Floor Plan, Theatres, CCTV & Door Access Layout	26/08/11			06/10/11	07/10/11	BMCE-TRANSMIT-006145	28/10/11	03/07/12	A			
	Nurses Call		MER	D	ME-SZ-00-PL-538-519	Ground Floor Plan, NSGH - Emergency Dept Nurse Call Layout	26/08/11		A	06/10/11	07/10/11	BMCE-TRANSMIT-006147 RE- ISSUED TO BOARD 08/08/12 BMCE-TRANSMIT-010166	28/10/11	10/08/12	A	03/09/12 BMCE-TRANSMIT-010692		
			MER	D	ME-SZ-00-PL-538-520	Ground Floor Plan, NSGH - Emergency Dept Nurse Call Layout	26/08/11		A	06/10/11	07/10/11	BMCE-TRANSMIT-006147 RE- ISSUED TO BOARD 08/08/12 BMCE-TRANSMIT-010166	28/10/11	10/08/12	A	03/09/12 BMCE-TRANSMIT-010692		
			MER	D	ME-ZD-00-PL-538-521	Ground Floor Plan, NSGH - Emergency Dept Nurse Call Layout	26/08/11			06/10/11	07/10/11	BMCE-TRANSMIT-006147 RE- ISSUED TO BOARD 08/08/12 BMCE-TRANSMIT-010166	28/10/11	10/08/12	A	03/09/12 BMCE-TRANSMIT-010692		
			MER	D	ME-SZ-00-PL-538-522	Ground Floor Plan, NSGH - Emergency Dept Nurse Call Layout	26/08/11		A	06/10/11	07/10/11	BMCE-TRANSMIT-006147 RE- ISSUED TO BOARD 08/08/12 BMCE-TRANSMIT-010166	28/10/11	10/08/12	A	03/09/12 BMCE-TRANSMIT-010692		
			MER	D	ME-SZ-00-PL-538-523	Ground Floor Plan, NSGH - Emergency Dept Nurse Call Layout	26/08/11		A	06/10/11	07/10/11	BMCE-TRANSMIT-006147 RE- ISSUED TO BOARD 08/08/12 BMCE-TRANSMIT-010166	28/10/11	10/08/12	A	03/09/12 BMCE-TRANSMIT-010692		
			MER	D	ME-SZ-00-PL-538-524	Ground Floor Plan, NSGH - Emergency Dept Nurse Call Layout	26/08/11		A	06/10/11	07/10/11	BMCE-TRANSMIT-006147 RE- ISSUED TO BOARD 08/08/12 BMCE-TRANSMIT-010166	28/10/11	10/08/12	A	03/09/12 BMCE-TRANSMIT-010692		

Drawing Information

31 BCL-AC-XX-SH-001

			Action By		Zone	Drawing Number	Drawing Title	Date Required from Consultant	Date Submitted by Consultant	Document Revision	Planned Date to be Submitted to Board	Date Submitted to Board	BMCE Transmittal No	Date Response Required from Board	Date Returned from Board	Board Status	Date returned to Consultant	Date Required from Consultant	Date Submitted by Consultant
Item	Submission	Comments																	
			MER	D	ME-ZD-01-PL-538-521	First Floor Plan, NSGH - CCU Nurse Call Layout	26/08/11			A	06/10/11	07/10/11	BMCE-TRANSMIT-006147 RE- ISSUED TO BOARD 08/08/12 BMCE-TRANSMIT-010166	28/10/11	10/08/12	A	03/09/12 BMCE- TRANSMIT- 010692		
			MER	D	ME-ZD-01-PL-538-522	First Floor Plan, NSGH - CCU Nurse Call Layout	26/08/11			A	06/10/11	07/10/11	BMCE-TRANSMIT-006147 RE- ISSUED TO BOARD 08/08/12 BMCE-TRANSMIT-010166	28/10/11	10/08/12	A	03/09/12 BMCE- TRANSMIT- 010692		
			MER	D	ME-ZD-01-PL-538-523	First Floor Plan, NSGH - Critical Care Nurse Call Layout	26/08/11			A	06/10/11	07/10/11	BMCE-TRANSMIT-006147 RE- ISSUED TO BOARD 08/08/12 BMCE-TRANSMIT-010166	28/10/11	10/08/12	A	03/09/12 BMCE- TRANSMIT- 010692		
			MER	D	ME-ZD-01-PL-538-524	First Floor Plan, NSGH - Critical Care Nurse Call Layout	26/08/11			A	06/10/11	07/10/11	BMCE-TRANSMIT-006147 RE- ISSUED TO BOARD 08/08/12 BMCE-TRANSMIT-010166	28/10/11	10/08/12	A	03/09/12 BMCE- TRANSMIT- 010692		
			MER	D	ME-ZD-02-PL-538-516	Second Floor Plan NSGH Telephone Services, Renal Plant & FM Emergency Linen CCTV & Door Access Layout	26/08/11			A	06/10/11	07/10/11	BMCE-TRANSMIT-006147 RE- ISSUED TO BOARD 08/08/12 BMCE-TRANSMIT-010166	28/10/11	10/08/12	A	03/09/12 BMCE- TRANSMIT- 010692		
			MER	D	ME-SZ-02-PL-538-520	Second Floor Plan, Theatres, Nurse Call Layout	26/08/11			A	06/10/11	07/10/11	BMCE-TRANSMIT-006147 RE- ISSUED TO BOARD 08/08/12 BMCE-TRANSMIT-010166	28/10/11	10/08/12	A	03/09/12 BMCE- TRANSMIT- 010692		
			MER	D	ME-SZ-02-PL-538-521	Second Floor Plan, Theatres, Nurse Call Layout	26/08/11			A	06/10/11	07/10/11	BMCE-TRANSMIT-006147 RE- ISSUED TO BOARD 08/08/12 BMCE-TRANSMIT-010166	28/10/11	10/08/12	A	03/09/12 BMCE- TRANSMIT- 010692		
			MER	D	ME-SZ-02-PL-538-522	Second Floor Plan, Theatres CCTV & Door Access Layout	26/08/11			A	06/10/11	07/10/11	BMCE-TRANSMIT-006147 RE- ISSUED TO BOARD 08/08/12 BMCE-TRANSMIT-010166	28/10/11	10/08/12	A	03/09/12 BMCE- TRANSMIT- 010692		
	PTS	Removed by Mercury	MER	D	ME-ZD-00-PL-569-104	Ground Floor Plan, Pneumatic Tube Distribution Zone D		07/10/11		A		10/10/11	BMCE-TRANSMIT-006150	31/10/11	18/11/11	B	12/11/11 BMCE- TRANSMIT- 007280		
		Removed by Mercury	MER	D	ME-ZD-01-PL-569-105	First Floor Plan, Pneumatic Tube Distribution, Zone D		07/10/11		A		10/10/11	BMCE-TRANSMIT-006150	31/10/11	18/11/11	A	12/11/11 BMCE- TRANSMIT- 007280		
	FIRE DETECTION INSTALL	Removed by Mercury - DUPLICATE	MER	D	ME-SZ-00-PL-572-519											14/11/11	B		
		Removed by Mercury - DUPLICATE	MER	D	ME-SZ-00-PL-572-520											14/11/11	A		
		Removed by Mercury - DUPLICATE	MER	D	ME-ZD-00-PL-572-521											14/11/11	B		
		Mechanical Services DrawingsHospital Drawings - Zone E																	
		Replaced by Mercury HPI drawings	ZBP	E	ZBP-ZE-00-PL-512-005	Medical Gases Layout Ground	23/01/12			A	24/02/12	24/02/12	BMCE-TRANSMIT-007783- (BMCE-WTRAN-002616)	16/03/12	09/05/12	C	10/05/12 BMCE- TRANSMIT- 008768		
			ZBP	E	ZBP-ZE-01-PL-512-015	Medical Gases Layout First	23/01/12			A	24/02/12	24/02/12	BMCE-TRANSMIT-007783 (BMCE-WTRAN-002616)	16/03/12	09/05/12	A	10/05/12 BMCE- TRANSMIT- 008768		
		Removed from Schedule - Replaced by Mercury HPI	ZBP	E	ZBP-ZE-02-PL-512-025	Medical Gases Layout Second	23/01/12			A	24/02/12	24/02/12	BMCE-TRANSMIT-007783- (BMCE-WTRAN-002616)	16/03/12	09/05/12	B	10/05/12 BMCE- TRANSMIT- 008770		
		Removed from Schedule - Replaced by Mercury HPI	ZBP	E	ZBP-ZE-04-PL-512-045	Medical Gases Layout Haemo-oncology Ward	16/03/12			A	03/05/12	18/05/12	BMCE-TRANSMIT-008915- (BMCE-WTRAN-003097)	06/06/12	28/09/12	C	06/10/12 BMCE- TRANSMIT- 011386		
		ZBP drawings not to be reviewed as not HPI drawings	ZBP	E	ZBP-ZE-XX-PL-512-055	Medical Gases Layout Generic Ward				A		11/12/12	BMCE-TRANSMIT-012841- (BMCE-WTRAN-006109)	07/01/12					
		DRAWING NUMBER CHANGED DRAWING REMOVED BY ZBP	ZBP	E	ZBP-ZE-XX-PL-512-065	Medical Gases Layout Generic Ward	16/03/12				03/05/12			21/01/09					
		Issued for information on BMCE-TRANSMIT-019160 21/01/2014	ZBP	E	ZBP-ZE-00-PL-523-005	HTG & CHW Layout Ground	23/01/12			A	24/02/12	24/02/12	BMCE-TRANSMIT-007783 (BMCE-WTRAN-002616)	16/03/12	09/05/12	B	10/05/12 BMCE- TRANSMIT- 008770		
		Issued for information on BMCE-TRANSMIT-019160 21/01/2014	ZBP	E	ZBP-ZE-01-PL-523-015	HTG & CHW Layout First	23/01/12			A	24/02/12	24/02/12	BMCE-TRANSMIT-007783 (BMCE-WTRAN-002616)	16/03/12	09/05/12	B	10/05/12 BMCE- TRANSMIT- 008770		
		This drawing is a duplicate of below	ZBP	E	ZBP-ZE-01-PL-523-025	HTG & CHW Layout Second	23/01/12			A	24/02/12	24/02/12	BMCE-TRANSMIT-007783- (BMCE-WTRAN-002616)	16/03/12	09/05/12	B	10/05/12 BMCE- TRANSMIT- 008770		
		Issued for information on BMCE-TRANSMIT-019160 21/01/2014	ZBP	E	ZBP-ZE-02-PL-523-025	HTG & CHW Layout Second				B	24/02/12	24/02/12	BMCE-TRANSMIT-007783 (BMCE-WTRAN-002616)	16/03/12	09/05/12	B	10/05/12 BMCE- TRANSMIT- 008770		
			ZBP	E	ZBP-ZE-04-PL-523-045	HTG & CHW Layout Haemo-Oncology Ward	16/03/12			A	03/05/12	08/05/12	BMCE-TRANSMIT-008690 (BMCE-WTRAN-002999)	29/05/12	09/07/12	B	18/07/12 BMCE- TRANSMIT- 009907		
		Issued for information on BMCE-TRANSMIT-019160 21/01/2014	ZBP	E	ZBP-ZE-11-PL-523-115	HTG & CHW Service Layout Eleventh Floor NSGH Ward				A		28/05/12	BMCE-TRANSMIT-009096 (BMCE-WTRAN-003156)	18/06/12	19/07/12	B	26/07/12 BMCE- TRANSMIT- 010101		
		Issued for information on BMCE-TRANSMIT-019160 21/01/2014	ZBP	E	ZBP-ZE-XX-PL-523-055	HTG & CHW Layout Generic Ward				A		28/05/12	BMCE-TRANSMIT-009096 (BMCE-WTRAN-003156)	18/06/12	19/07/12	B	26/07/12 BMCE- TRANSMIT- 010101		
		DRAWING NUMBER CHANGED DRAWING REMOVED BY ZBP	ZBP	E	ZBP-ZE-XX-PL-523-065	HTG & CHW Layout Generic Ward	16/03/12				03/05/12								

1st Submission	2nd Submission

[illegible]

Drawing Information

31 BCL-AC-XX-SH-001

			Action By		Zone	Drawing Number	Drawing Title	Date Required from Consultant	Date Submitted by Consultant	Document Revision	Planned Date to be Submitted to Board	Date Submitted to Board	BMCE Transmittal No	Date Response Required from Board	Date Returned from Board	Board Status	Date returned to Consultant	Date Required from Consultant	Date Submitted by Consultant
Item	Submission	Comments																	
	Electrical Services Drawings		ZBP	E		ZBP-ZE-00-PL-531-005	Small Power Layout Ground	23/01/12		A	24/02/12	24/02/12	BMCE-TRANSMIT-007784 (BMCE-WTRAN-002617)	16/03/12	11/05/12	A	24/05/12 BMCE-TRANSMIT-009059		
			ZBP	E		ZBP-ZE-01-PL-531-015	Small Power Layout First	23/01/12		A	24/02/12	24/02/12	BMCE-TRANSMIT-007784 (BMCE-WTRAN-002617)	16/03/12	11/05/12	A	24/05/12 BMCE-TRANSMIT-009059		
			ZBP	E		ZBP-ZE-02-PL-531-025	Small Power Layout Second	23/01/12		A	24/02/12	24/02/12	BMCE-TRANSMIT-007784 (BMCE-WTRAN-002617)	16/03/12	11/05/12	A	24/05/12 BMCE-TRANSMIT-009059		
			ZBP	E		ZBP-ZE-04-PL-531-045	Small Power Layout Haemo-Oncology Ward	16/03/12		A	03/05/12	08/05/12	BMCE-TRANSMIT-008691 (BMCE-WTRAN-003000)	29/05/12	02/08/12	A	29/08/12 BMCE-TRANSMIT-010570		
			ZBP	E		ZBP-ZE-05-PL-531-055	Small Power Layout Fifth to Eleventh Floors NSGH Generic Wards			A		08/05/12	BMCE-TRANSMIT-008691 (BMCE-WTRAN-003000)	29/05/12	02/08/12	A	29/08/12 BMCE-TRANSMIT-010570		
		Issued for information on BMCE-TRANSMIT-019160 21/01/2014	ZBP	E		ZBP-ZE-05-PL-571-055	Small Power Layouts Fifth to Eleventh NSGH Generic Wards	16/03/12		A	03/05/12	08/05/12	BMCE-TRANSMIT-008691 (BMCE-WTRAN-003000)	29/05/12	02/08/12	B	29/08/12 BMCE-TRANSMIT-010570		
			ZBP	E		ZBP-ZE-13-PL-531-135	Small power layout 13th floor			A		18/10/13	BMCE-TRANSMIT-018120 (BMCE-WTRAN-009183)	08/11/13	11/11/13	B	20/11/13 BMCE-TRANSMIT-018517		
		Removed by ZBP	ZBP	E		ZBP-ZE-XX-PL-531-055	Small Power Layout Generic Ward	16/03/12						-	21/01/00				
		DRAWING NUMBER CHANGED DRAWING REMOVED BY ZBP	ZBP	E		ZBP-ZE-XX-PL-531-065	Small Power Layout Generic Ward	16/03/12							21/01/00				
			ZBP	E		ZBP-ZE-00-PL-532-005	Containment/Sub-Main Layout Ground	23/01/12		A	24/02/12	24/02/12	BMCE-TRANSMIT-007784 (BMCE-WTRAN-002617)	16/03/12	11/05/12	A	24/05/12 BMCE-TRANSMIT-009059		
			ZBP	E		ZBP-ZE-01-PL-532-015	Containment/Sub-Main Layout First	23/01/12		A	24/02/12	24/02/12	BMCE-TRANSMIT-007784 (BMCE-WTRAN-002617)	16/03/12	11/05/12	A	24/05/12 BMCE-TRANSMIT-009059		
			ZBP	E		ZBP-ZE-02-PL-532-025	Containment/Sub-Main Layout Second	23/01/12		A	24/02/12	24/02/12	BMCE-TRANSMIT-007784 (BMCE-WTRAN-002617)	16/03/12	11/05/12	A	24/05/12 BMCE-TRANSMIT-009059		
			ZBP	E		ZBP-ZE-04-PL-532-045	Containment/Sub-Main Layout Haemo-Oncology Ward	16/03/12		A	03/05/12	08/05/12	BMCE-TRANSMIT-008691 (BMCE-WTRAN-003000)	29/05/12	02/08/12	A	29/08/12 BMCE-TRANSMIT-010570		
			ZBP	E		ZBP-ZE-05-PL-532-055	Containment Layout Fifth to Eleventh Floors NSGH Generic Wards	16/03/12		A	03/05/12	08/05/12	BMCE-TRANSMIT-008691 (BMCE-WTRAN-003000)	29/05/12	02/08/12	A	29/08/12 BMCE-TRANSMIT-010570		
		Removed by ZBP	ZBP	E		ZBP-ZE-XX-PL-532-055	Containment/Sub-main Layout Generic Ward												
		DRAWING NUMBER CHANGED DRAWING REMOVED BY ZBP	ZBP	E		ZBP-ZE-XX-PL-532-065	Containment/Sub-main Layout Generic Ward	16/03/12				24/02/12		-					
			ZBP	E		ZBP-ZE-00-PL-571-005	Security Layout Ground	23/01/12		A	24/02/12	24/02/12	BMCE-TRANSMIT-007784 (BMCE-WTRAN-002617)	16/03/12	11/05/12	A	24/05/12 BMCE-TRANSMIT-009059		
			ZBP	E		ZBP-ZE-01-PL-571-015	Security Layout First	23/01/12		A	24/02/12	24/02/12	BMCE-TRANSMIT-007784 (BMCE-WTRAN-002617)	16/03/12	11/05/12	A	24/05/12 BMCE-TRANSMIT-009059		
			ZBP	E		ZBP-ZE-02-PL-571-025	Security Layout Second	23/01/12		A	24/02/12	24/02/12	BMCE-TRANSMIT-007784 (BMCE-WTRAN-002617)	16/03/12	11/05/12	A	24/05/12 BMCE-TRANSMIT-009059		
		Issued for information on BMCE-TRANSMIT-019160 21/01/2014	ZBP	E		ZBP-ZE-04-PL-571-045	Security Layout Fourth	16/03/12		A	03/05/12	08/05/12	BMCE-TRANSMIT-008691 (BMCE-WTRAN-003000)	29/05/12	02/08/12	B	29/08/12 BMCE-TRANSMIT-010570		
		Duplicate on RDD Schedule	ZBP	E		ZBP-ZE-04-PL-571-055	Security Layout Fifth to Eleventh Floors NSGH Generic Wards	16/03/12		A	03/05/12	08/05/12	BMCE-TRANSMIT-008691 (BMCE-WTRAN-003000)	29/05/12	02/08/12	B			
		Removed by ZBP	ZBP	E		ZBP-ZE-XX-PL-571-055	Security Layout Generic Ward												
		DRAWING NUMBER CHANGED DRAWING REMOVED BY ZBP	ZBP	E		ZBP-ZE-XX-PL-571-065	Security Layout Generic Ward	23/01/12				24/02/12		-					
	Public Health Services Drawings	Issued for information on BMCE-TRANSMIT-019160 21/01/2014	ZBP	E		ZBP-ZE-00-PL-500-005	Water & Gas Services Layout Ground	23/01/12		A	24/02/12	24/02/12	BMCE-TRANSMIT-007785 (BMCE-WTRAN-002618)	16/03/12	24/04/12	B	11/05/12 BMCE-TRANSMIT-008778		
		Issued for information on BMCE-TRANSMIT-019160 21/01/2014	ZBP	E		ZBP-ZE-01-PL-500-015	Water & Gas Services Layout First	23/01/12		A	24/02/12	24/02/12	BMCE-TRANSMIT-007785 (BMCE-WTRAN-002618)	16/03/12	24/04/12	B	11/05/12 BMCE-TRANSMIT-008778		
			ZBP	E		ZBP-ZE-02-PL-500-025	Water & Gas Services Layout Second	23/01/12		A	24/02/12	24/02/12	BMCE-TRANSMIT-007785 (BMCE-WTRAN-002618)	16/03/12	24/04/12	A	11/05/12 BMCE-TRANSMIT-008778		
			ZBP	E		ZBP-ZE-04-PL-500-045	Water & Gas Services Layout Haemo-Oncology Ward	16/03/12		A	03/05/12	18/05/12	BMCE-TRANSMIT-008916 (BMCE-WTRAN-003098)	08/06/12	14/08/12	A	04/09/12 BMCE-TRANSMIT-010772		
		ZBP	E		ZBP-ZE-XX-PL-500-055	Water & Gas Services Layout Generic Ward			A		30/05/12	BMCE-TRANSMIT-009098 (BMCE-WTRAN-003159)	20/06/12	19/07/12	A	28/07/12 BMCE-TRANSMIT-			

Drawing Information

31 BCL-AC-XX-SH-001

			Action By		Zone	Drawing Number	Drawing Title	Date Required from Consultant	Date Submitted by Consultant	Document Revision	Planned Date to be Submitted to Board	Date Submitted to Board	BMCE Transmittal No	Date Response Required from Board	Date Returned from Board	Board Status	Date returned to Consultant	Date Required from Consultant	Date Submitted by Consultant
Item	Submission	Comments																	
			ZBP	E	ZBP-ZE-12-PL-581-125	Sanitation and Rainwater Layout Twelfth			B		10/04/13	BMCE-TRANSMIT-015033 (BMCE-WTRAN-006931)	01/05/13	07/05/13	A	20/05/13 BMCE-TRANSMIT-015772			
			ZBP	E	ZBP-ZE-13-PL-581-135	Sanitation and Rainwater Layout Thirteenth			A		22/04/13	BMCE-TRANSMIT-015255 (BMCE-WTRAN-007116)	13/05/13	13/05/13	A	20/05/13 BMCE-TRANSMIT-015775			
		Issued for information on BMCE-TRANSMIT-019160 21/01/2014	ZBP	E	ZBP-ZE-14-PL-581-145	Sanitation and Rainwater Layout Fourteenth			A		22/04/13	BMCE-TRANSMIT-015255 (BMCE-WTRAN-007116)	13/05/13	13/05/13	B	20/05/13 BMCE-TRANSMIT-015775			
	Riser Drawings		ZBP	E	ZBP-ZE-XX-PL-520-609	Riser T4 Level 4-7			A		14/06/12	BMCE-TRANSMIT-009359 (BMCE-WTRAN-003282)	05/07/12	10/09/12	A	21/09/12 BMCE-TRANSMIT-011089			
			ZBP	E	ZBP-ZE-XX-PL-520-610	Riser T4 Levels 8-11			A		14/06/12	BMCE-TRANSMIT-009359 (BMCE-WTRAN-003282)	05/07/12	10/09/12	A	21/09/12 BMCE-TRANSMIT-011089			
			ZBP	E	ZBP-ZE-XX-PL-520-611	Riser M11	10/02/12			02/03/12	02/03/12	BMCE-TRANSMIT-007912 (BMCE-WTRAN-002659)	23/03/12	12/04/12	A	20/01/12 BMCE-TRANSMIT-008460			
		Issued for information on BMCE-TRANSMIT-019160 21/01/2014	ZBP	E	ZBP-ZE-XX-PL-520-612	Riser M12	10/02/12		A	24/02/12	24/02/12	BMCE-TRANSMIT-007786 (BMCE-WTRAN-002619)	16/03/12	24/04/12	B	11/05/12 BMCE-TRANSMIT-008777			
		Issued for information on BMCE-TRANSMIT-019160 21/01/2014	ZBP	E	ZBP-ZE-XX-PL-520-613	Riser M13	10/02/12		A	24/02/12	24/02/12	BMCE-TRANSMIT-007786 (BMCE-WTRAN-002619)	16/03/12	24/04/12	B	11/05/12 BMCE-TRANSMIT-008777			

Drawing Information

31 BCL-AC-XX-SH-001

			Action By		Zone	Drawing Number	Drawing Title	Date Required from Consultant	Date Submitted by Consultant	Document Revision	Planned Date to be Submitted to Board	Date Submitted to Board	BMCE Transmittal No	Date Response Required from Board	Date Returned from Board	Board Status	Date returned to Consultant	Date Required from Consultant	Date Submitted by Consultant
Item	Submission	Comments																	
		Issued for information on BMCE-TRANSMIT-019160 21/01/2014	ZBP	E		ZBP-ZE-XX-PL-520-614	Riser M14	10/02/12		A	24/02/12	24/02/12	BMCE-TRANSMIT-007786 (BMCE-WTRAN-002619)	16/03/12	24/04/12	B	11/05/12 BMCE-TRANSMIT-008777		
		Issued for information on BMCE-TRANSMIT-019160 21/01/2014	ZBP	E		ZBP-ZE-XX-PL-520-615	Riser M26	10/02/12			02/03/12	02/03/12	BMCE-TRANSMIT-007912 (BMCE-WTRAN-002659)	23/03/12	12/04/12	B	20/01/12 BMCE-TRANSMIT-009460		
		Issued for information on BMCE-TRANSMIT-019160 21/01/2014	ZBP	E		ZBP-ZE-XX-PL-520-616	Riser M40	10/02/12		A	24/02/12	24/02/12	BMCE-TRANSMIT-007786 (BMCE-WTRAN-002619)	16/03/12	24/04/12	B	11/05/12 BMCE-TRANSMIT-008777		
			ZBP	E		ZBP-ZE-XX-PL-520-617	Riser T3	13/04/12		A	03/05/12	17/12/12	BMCE-TRANSMIT-012842 (BMCE-WTRAN-005110)	07/01/13	04/01/13	B	15/01/13 BMCE-TRANSMIT-01339		
			ZBP	E		ZBP-ZE-XX-PL-520-618	Riser T4	04/05/12			11/06/12	17/12/12	BMCE-TRANSMIT-012842 (BMCE-WTRAN-005110)	07/01/13	04/01/13	C	15/01/13 BMCE-TRANSMIT-01339		
		Issued for information on BMCE-TRANSMIT-019160 21/01/2014	ZBP	E		ZBP-ZE-XX-PL-520-619	Riser M27B	10/02/12			02/03/12	02/03/12	BMCE-TRANSMIT-007912 (BMCE-WTRAN-002659)	23/03/12	12/04/12	B	20/01/12 BMCE-TRANSMIT-008460		
		Duplicate on RDD Schedule	ZBP	E		ZBP-ZE-XX-PL-520-606	Riser M15B	10/02/12			10/02/12								
	Mechanical Services Drawings Plantroom 22	DRAWING REMOVED BY ZBP	ZBP	E		ZBP-ZE-02-PL-512-111	Plantroom 22-Medical Gases	23/01/12			20/02/12			-					
		DRAWING REMOVED BY ZBP	ZBP	E		ZBP-ZE-02-PL-512-112	Plantroom 22-Medical Gases	23/01/12			20/02/12			-					
		Issued for information on BMCE-TRANSMIT-019160 21/01/14	ZBP	E		ZBP-ZE-02-PL-523-111	Plantroom 22 HTG & CHW	23/01/12		A	20/02/12	25/05/12	BMCE-TRANSMIT-009077 (BMCE-WTRAN-003145)	15/06/12	09/07/12	B	18/07/12 BMCE-TRANSMIT-009885		
		Issued for information on BMCE-TRANSMIT-019160 21/01/14	ZBP	E		ZBP-ZE-02-PL-523-112	Plantroom 22 HTG & CHW	23/01/12		A	20/02/12	25/05/12	BMCE-TRANSMIT-009077 (BMCE-WTRAN-003145)	15/06/12	09/07/12	B	18/07/12 BMCE-TRANSMIT-009885		
		Issued for information on BMCE-TRANSMIT-019160 21/01/14	ZBP	E		ZBP-ZE-02-PL-524-111	Plantroom 22 Ventilation	23/01/12		A	20/02/12	25/05/12	BMCE-TRANSMIT-009077 (BMCE-WTRAN-003145)	15/06/12	09/07/12	B	18/07/12 BMCE-TRANSMIT-009885		
		Issued for information on BMCE-TRANSMIT-019160 21/01/14	ZBP	E		ZBP-ZE-02-PL-524-112	Plantroom 22 Ventilation	23/01/12		A	20/02/12	25/05/12	BMCE-TRANSMIT-009077 (BMCE-WTRAN-003145)	15/06/12	09/07/12	B	18/07/12 BMCE-TRANSMIT-009885		
	Electrical Services Drawings	DRAWING REMOVED BY ZBP	ZBP	E		ZBP-ZE-02-PL-532-111	Plantroom 22 LV-Power	23/01/12			20/02/12			-					
		DRAWING REMOVED BY ZBP	ZBP	E		ZBP-ZE-02-PL-532-112	Plantroom 22 LV-Power	23/01/12			20/02/12			-					
	Public Health Services Drawings																		
		DRAWING REMOVED BY ZBP	ZBP	E		ZBP-ZE-02-PL-500-111	Plantroom 22-Water-Ser-ices	23/01/12			20/02/12			-					
		DRAWING REMOVED BY ZBP	ZBP	E		ZBP-ZE-02-PL-500-112	Plantroom 22-Water-Services	23/01/12			20/02/12			-					
		Removed - Drawing No longer in Use ZBP instruction	ZBP	E		ZBP-ZE-02-PL-581-221	Plantroom 22 Sanitation and Rainwater Layout	23/01/12			20/02/12			-					
		Removed - Drawing No longer in Use ZBP instruction	ZBP	E		ZBP-ZE-02-PL-581-222	Plantroom 22 Sanitation and Rainwater Layout	23/01/12			20/02/12			-					
	Mechanical Services Drawings Plantroom 31	Removed by ZBP	ZBP	E		ZBP-ZE-03-PL-512-121	Plantroom 31-Medical Gases	30/03/12			03/05/12			-					
		Removed by ZBP	ZBP	E		ZBP-ZE-03-PL-512-122	Plantroom 31-Medical Gases	30/03/12			03/05/12			-					
		Removed by ZBP	ZBP	E		ZBP-ZE-03-PL-512-123	Plantroom 31-Medical Gases	30/03/12			03/05/12			-					
		Removed by ZBP	ZBP	E		ZBP-ZE-03-PL-512-124	Plantroom 31-Medical Gases	30/03/12			03/05/12			-					
		Removed by ZBP	ZBP	E		ZBP-ZE-03-PL-512-125	Plantroom 31-Medical Gases	30/03/12			03/05/12			-					
		Removed by ZBP	ZBP	E		ZBP-ZE-03-PL-512-126	Plantroom 31-Medical Gases	30/03/12			03/05/12			-					
		Removed by ZBP	ZBP	E		ZBP-ZE-03-PL-512-127	Plantroom 31-Medical Gases	30/03/12			03/05/12			-					
		Removed by ZBP	ZBP	E		ZBP-ZE-03-PL-512-128	Plantroom 31-Medical Gases	30/03/12			03/05/12			-					

Drawing Information

31

BCL-AC-XX-SH-001

1st Submission

2nd Submission

			Action By	Zone	Drawing Number	Drawing Title	Date Required from Consultant	Date Submitted by Consultant	Document Revision	Planned Date to be Submitted to Board	Date Submitted to Board	BMCE Transmittal No	Date Response Required from Board	Date Returned from Board	Board Status	Date returned to Consultant	Date Required from Consultant	Date Submitted by Consultant
Item	Submission	Comments																
		Removed by ZBP	ZBP	E	ZBP-ZE-03-PL-523-121	Plantroom 31 HTG & CHW	30/03/12			03/05/12			-					
			ZBP	E	ZBP-ZD-03-PL-523-121	Plantroom 31 Pipewrok	30/03/12		A	03/05/12	18/05/12	BMCE-TRANSMIT-008920 (BMCE-WTRAN-003101)	08/06/12	10/09/12	A	20/09/12 BMCE-TRANSMIT-011077		
		Removed by ZBP	ZBP	E	ZBP-ZE-03-PL-523-122	Plantroom 31 HTG & CHW	30/03/12			03/05/12			-					
			ZBP	E	ZBP-ZD-03-PL-523-122	Plantroom 31 Pipework	30/03/12		A	03/05/12	18/05/12	BMCE-TRANSMIT-008920 (BMCE-WTRAN-003101)	08/06/12	10/09/12	A	20/09/12 BMCE-TRANSMIT-011077		
		Removed by ZBP	ZBP	E	ZBP-ZE-03-PL-523-123	Plantroom 31 HTG & CHW	30/03/12			03/05/12			-					
		ADDED	ZBP	E	ZBP-ZG-03-PL-523-123	Plantroom 31 Pipework	30/03/12		A	03/05/12	18/05/12	BMCE-TRANSMIT-008920 (BMCE-WTRAN-003101)	08/06/12	10/09/12	A	20/09/12 BMCE-TRANSMIT-011077		
		Removed by ZBP	ZBP	E	ZBP-ZE-03-PL-523-124	Plantroom 31 HTG & CHW	30/03/12			03/05/12			-					
			ZBP	E	ZBP-ZG-03-PL-523-124	Plantroom 31 Pipework	30/03/12		A	03/05/12	18/05/12	BMCE-TRANSMIT-008920 (BMCE-WTRAN-003101)	08/06/12	10/09/12	A	20/09/12 BMCE-TRANSMIT-011077		
		Removed by ZBP	ZBP	E	ZBP-ZE-03-PL-523-125	Plantroom 31 HTG & CHW	30/03/12			03/05/12			-					
			ZBP	E	ZBP-ZE-03-PL-523-125	Plantroom 31 Pipework	30/03/12			03/05/12	18/05/12	BMCE-TRANSMIT-008920 (BMCE-WTRAN-003101)	08/06/12	10/09/12	A	20/09/12 BMCE-TRANSMIT-011077		
		Removed by ZBP	ZBP	E	ZBP-ZE-03-PL-523-126	Plantroom 31 HTG & CHW	30/03/12			03/05/12			-					
			ZBP	E	ZBP-ZE-03-PL-523-126	Plantroom 31 Pipework	30/03/12			03/05/12	18/05/12	BMCE-TRANSMIT-008920 (BMCE-WTRAN-003101)	08/06/12	10/09/12	A	20/09/12 BMCE-TRANSMIT-011077		
		Removed by ZBP	ZBP	E	ZBP-ZE-03-PL-523-127	Plantroom 31 HTG & CHW	30/03/12			03/05/12			-					
			ZBP	E	ZBP-ZF-03-PL-523-130	Plantroom 31 Pipework					18/05/12	BMCE-TRANSMIT-008920 (BMCE-WTRAN-003101)	08/06/12	10/09/12	A	20/09/12 BMCE-TRANSMIT-011077		
			ZBP	E	ZBP-ZH-03-PL-523-127	Plantroom 31 Pipework	30/03/12		A	03/05/12	18/05/12	BMCE-TRANSMIT-008920 (BMCE-WTRAN-003101)	08/06/12	10/09/12	A	20/09/12 BMCE-TRANSMIT-011077		
			ZBP	E	ZBP-ZE-03-PL-523-128	Plantroom 31 HTG & CHW	30/03/12			03/05/12			-					
		CORRECTED DRAWING NUMBER FROM ZBP-ZE-03-PL-523-128 14.12.12	ZBP	H	ZBP-ZH-03-PL-523-128	Plantroom 31 Pipework	30/03/12		A	03/05/12	18/05/12	BMCE-TRANSMIT-008920 (BMCE-WTRAN-003101)	08/06/12	10/09/12	A	20/09/12 BMCE-TRANSMIT-011077		
			ZBP	E	ZBP-ZE-03-PL-523-129	Plantroom 31 HTG & CHW	30/03/12			03/05/12	18/05/12	BMCE-TRANSMIT-008920 (BMCE-WTRAN-003101)	08/06/12	10/09/12	A	20/09/12 BMCE-TRANSMIT-011077		
		Removed by ZBP	ZBP	E	ZBP-ZH-03-PL-523-130	Plantroom 31 Pipework												
		No longer in Use ZBP instruction	ZBP	E	ZBP-ZH-03-PL-523-129	Plantroom 31 Pipework	30/03/12			03/05/12			21/01/09					
		Removed by ZBP	ZBP	E	ZBP-ZE-03-PL-523-130	Plantroom 31 HTG & CHW	30/03/12			03/05/12			-					
		No longer in Use ZBP instruction	ZBP	E	ZBP-ZH-03-PL-523-130	Plantroom 31 Pipework	30/03/12			03/05/12			21/01/09					
		Removed by ZBP	ZBP	E	ZBP-ZE-03-PL-524-121	Plantroom 31 Ventilation	30/03/12			03/05/12			-					
		Removed by ZBP	ZBP	E	ZBP-ZE-03-PL-524-122	Plantroom 31 Ventilation	30/03/12			03/05/12			-					
		Removed by ZBP	ZBP	E	ZBP-ZE-03-PL-524-123	Plantroom 31 Ventilation	30/03/12			03/05/12			-					
		Removed by ZBP	ZBP	E	ZBP-ZE-03-PL-524-124	Plantroom 31 Ventilation	30/03/12			03/05/12			-					
			ZBP	E	ZBP-ZE-03-PL-524-125	Plantroom 31 Ventilation	30/03/12		E	03/05/12	05/06/13	BMCE-TRANSMIT-016119 (BMCE-WTRAN-007793)	26/06/13	10/07/13	A	BMCE-TRANSMIT-016829		
		Drawing is a duplicate on RDD Schedule	ZBP	E	ZBP-ZE-03-PL-524-126	Plantroom 31 Ventilation	30/03/12			03/05/12			-					
		Removed by ZBP	ZBP	E	ZBP-ZE-03-PL-524-127	Plantroom 31 Ventilation	30/03/12			03/05/12			-					
		Removed by ZBP	ZBP	E	ZBP-ZE-03-PL-524-128	Plantroom 31 Ventilation	30/03/12			03/05/12			-					

Drawing Information

31 BCL-AC-XX-SH-001

1st Submission2nd Submission

			Action By	Zone	Drawing Number	Drawing Title	Date Required from Consultant	Date Submitted by Consultant	Document Revision	Planned Date to be Submitted to Board	Date Submitted to Board	BMCE Transmittal No	Date Response Required from Board	Date Returned from Board	Board Status	Date returned to Consultant	Date Required from Consultant	Date Submitted by Consultant
Item	Submission	Comments																
		Removed by ZBP	ZBP	E	ZBP-ZE-03-PL-532-122	Plantroom-31-LV-Power-	30/03/12			03/05/12			-					
		Removed by ZBP	ZBP	E	ZBP-ZE-03-PL-532-123	Plantroom-31-LV-Power-	30/03/12			03/05/12			-					
		Removed by ZBP	ZBP	E	ZBP-ZE-03-PL-532-124	Plantroom-31-LV-Power-	30/03/12			03/05/12			-					
		Removed by ZBP	ZBP	E	ZBP-ZE-03-PL-532-125	Plantroom-31-LV-Power-	30/03/12			03/05/12			-					
		Electrical Services Drawings																
		Removed by ZBP	ZBP	E	ZBP-ZD-03-PL-532-121	Plantroom-31-LV-Power-	30/03/12			03/05/12			-					
			ZBP	E	ZBP-ZD-03-PL-532-122	Plantroom 31 LV Power	30/03/12			03/05/12	24/04/12	BMCE-TRANSMIT-008497 (BMCE-WTRAN-002926)	15/05/12	11/05/12	A	23/05/12 BMCE-TRANSMIT-009010		
		Incorrect drawing number - please refer to ZBP-ZG-03-PL-532-123	ZBP	E	ZBP-ZE-03-PL-532-123	Plantroom-31-LV-Power-	30/03/12			03/05/12	24/04/12	BMCE-TRANSMIT-008497 (BMCE-WTRAN-002926)	15/05/12	11/05/12	B	23/05/12 BMCE-TRANSMIT-009010		
		Issued for information on BMCE-TRANSMIT-019160 21/01/14	ZBP	E	ZBP-ZE-03-PL-532-124	Plantroom 31 LV Power	30/03/12			03/05/12	24/04/12	BMCE-TRANSMIT-008497 (BMCE-WTRAN-002926)	15/05/12	11/05/12	B	23/05/12 BMCE-TRANSMIT-009010		
		Removed by ZBP	ZBP	E	ZBP-ZH-03-PL-532-125	Plantroom-31-LV-Power-	30/03/12			03/05/12			-					
		Removed by ZBP	ZBP	E	ZBP-ZE-03-PL-532-126	Plantroom-31-LV-Power-	30/03/12			03/05/12			-					
		Removed by ZBP	ZBP	E	ZBP-ZE-03-PL-532-127	Plantroom-31-LV-Power-	30/03/12			03/05/12			-					
		Removed by ZBP	ZBP	E	ZBP-ZE-03-PL-532-128	Plantroom-31-LV-Power-	30/03/12			03/05/12			-					
		Removed by ZBP	ZBP	E	ZBP-ZE-03-PL-532-129	Plantroom-31-LV-Power-	30/03/12			03/05/12			-					
		Removed by ZBP	ZBP	E	ZBP-ZE-03-PL-532-130	Plantroom-31-LV-Power-	30/03/12			03/05/12			-					
	Public Health Services Drawings	Removed by ZBP	ZBP	E	ZBP-ZE-03-PL-500-121	Plantroom-31-Water-Services-	30/03/12			03/05/12			-					
		Removed by ZBP	ZBP	E	ZBP-ZE-03-PL-500-122	Plantroom-31-Water-Ser-ices-	30/03/12			03/05/12			-					

Drawing Information

31

BCL-AC-XX-SH-001

1st Submission

2nd Submission

			Action By	Zone	Drawing Number	Drawing Title	Date Required from Consultant	Date Submitted by Consultant	Document Revision	Planned Date to be Submitted to Board	Date Submitted to Board	BMCE Transmittal No	Date Response Required from Board	Date Returned from Board	Board Status	Date returned to Consultant	Date Required from Consultant	Date Submitted by Consultant
Item	Submission	Comments																
		Removed by ZBP	ZBP	E	ZBP-ZE-03-PL-500-123	Plantroom 31-Water Ser-ices	30/03/12			03/05/12			-					
		Removed by ZBP	ZBP	E	ZBP-ZE-03-PL-500-124	Plantroom 31-Water Ser-ices	30/03/12			03/05/12			-					
		Removed by ZBP	ZBP	E	ZBP-ZE-03-PL-500-125	Plantroom 31-Water Services	30/03/12			03/05/12			-					
		Removed by ZBP	ZBP	E	ZBP-ZE-03-PL-500-126	Plantroom 31-Water Ser-ices	30/03/12			03/05/12			-					
		Removed by ZBP	ZBP	E	ZBP-ZE-03-PL-500-127	Plantroom 31-Water Ser-ices	30/03/12			03/05/12			-					
		Removed by ZBP	ZBP	E	ZBP-ZE-03-PL-500-128	Plantroom 31-Water Services	30/03/12			03/05/12			-					
		Removed by ZBP	ZBP	E	ZBP-ZE-03-PL-500-129	Plantroom 31-Water Ser-ices	30/03/12			03/05/12			-					
		Removed by ZBP	ZBP	E	ZBP-ZE-03-PL-500-130	Plantroom 31-Water Ser-ices	30/03/12			03/05/12			-					
		Removed by ZBP	ZBP	E	ZBP-ZE-03-PL-581-313	Plantroom 31- Sanitation and Rainwater Layout	30/03/12			03/05/12			-					
		Removed by ZBP	ZBP	E	ZBP-ZE-03-PL-581-314	Plantroom 31- Sanitation and Rainwater Layout	30/03/12			03/05/12			-					
		Removed by ZBP	ZBP	E	ZBP-ZE-03-PL-581-315	Plantroom 31- Sanitation and Rainwater Layout	30/03/12			03/05/12			-					
		Removed by ZBP	ZBP	E	ZBP-ZE-04-PL-581-316	Plantroom 31-Roof Sanitation and Rainwater Layout	16/03/12			03/05/12			-					
		Removed by ZBP	ZBP	E	ZBP-ZD-03-PL-581-313	Plantroom 31- Sanitation and Rainwater Layout	30/03/12			03/05/12			-					
		Removed by ZBP	ZBP	E	ZBP-ZG-03-PL-581-314	Plantroom 31- Sanitation and Rainwater Layout	30/03/12			03/05/12			-					
		Removed by ZBP	ZBP	E	ZBP-ZE-03-PL-581-315	Plantroom 31- Sanitation and Rainwater Layout	30/03/12			03/05/12			-					
		Removed by ZBP	ZBP	E	ZBP-ZH-04-PL-581-316	Plantroom 31-Roof Sanitation and Rainwater Layout	16/03/12			03/05/12			-					
		Removed by ZBP	ZBP	E	ZBP-ZE-04-PL-581-317	Plantroom 31-Roof Sanitation and Rainwater Layout	16/03/12			03/05/12								
		Removed by ZBP	ZBP	E	ZBP-ZE-04-PL-581-318	Plantroom 31-Roof Sanitation and Rainwater Layout	16/03/12			03/05/12								
			ZBP	E	ZBP-XX-XX-SC-524-741	NCH Neuro Surgery Operating Theatre Ventilation Schamtic 22 AHU 01			A	03/05/12	30/04/12	BMCE-TRANSMIT-008613 (BMCE-WTRAN-002967)	21/05/12	06/07/12	B	18/07/12 BMCE-TRANSMIT-009901		
		Issued for information on BMCE-TRANSMIT-019160 21/01/14	ZBP	E	ZBP-XX-XX-SC-524-746	Cardiac Catheter Theatre and Adult Interventional Imaging Theatre Ventilation Schematic 22 AHU 09 & 10			A		18/05/12	BMCE-TRANSMIT-008910 (BMCE-WTRAN-003092)	08/06/12	15/08/12	B	23/08/12 BMCE-TRANSMIT-010487		
			ZBP	E	ZBP-XX-XX-SC-524-756	NHC Cardiac Operating Theatre Ventilation Schematic 22 AHU 02			A	03/05/12	30/04/12	BMCE-TRANSMIT-008613 (BMCE-WTRAN-002967)	21/05/12	06/07/12	B	18/07/12 BMCE-TRANSMIT-009901		
		Removed by ZBP	ZBP	E	ZBP-XX-XX-SC-524-758	Theatre Support Ventilation Schematic 22 AHU 27			A									
			ZBP	E	ZBP-XX-XX-SC-524-759	Basement FM Stores Ventilation Schematic 22 AHU 25			A	03/05/12	30/04/12	BMCE-TRANSMIT-008613 (BMCE-WTRAN-002967)	21/05/12	06/07/12	B	18/07/12 BMCE-TRANSMIT-009901		
			ZBP	E	ZBP-XX-XX-SC-524-760	First Floor Change Area Ventilation Schematic 22 AHU 04			A	04/05/12	18/05/12	BMCE-TRANSMIT-008922 (BMCE-WTRAN-003102)	08/06/12	14/08/12	A	03/09/12 BMCE-TRANSMIT-010678		
	Mechanical Services Schematics		ZBP	E	ZBP-XX-XX-SC-524-801	Ventilation Schematic (PR31) - AHU 01, 02, 03, 04, 11, 17, 18, 19, 20	30/03/12	26/04/12	A	03/05/12	30/04/12	BMCE-TRANSMIT-008613 (BMCE-WTRAN-002967)	21/05/12	06/07/12	A	18/07/12 BMCE-TRANSMIT-009901		
		Issued for information on BMCE-TRANSMIT-019160 21/01/14	ZBP	E	ZBP-XX-XX-SC-524-802	Vent lation Schematic (PR31) - AHU 05, 06, 07, 08, 09, 10, 15, 16	30/03/12	26/04/12	A	03/05/12	30/04/12	BMCE-TRANSMIT-008613 (BMCE-WTRAN-002967)	21/05/12	06/07/12	B	18/07/12 BMCE-TRANSMIT-009901		
			ZBP	E	ZBP-XX-XX-SC-524-803	Ventilation Schematic (PR31) - AHU 21 & 22	30/03/12	26/04/12	A	03/05/12	30/04/12	BMCE-TRANSMIT-008613 (BMCE-WTRAN-002967)	21/05/12	06/07/12	A	18/07/12 BMCE-TRANSMIT-009901		
		DRAWING REMOVED BY ZBP	ZBP	E	ZBP-XX-XX-SC-524-804	Ventilation Schematic (PR31) - AHU 23	30/03/12			03/05/12			-					

			Action By		Zone	Drawing Number	Drawing Title	Date Required from Consultant	Date Submitted by Consultant	Document Revision	Planned Date to be Submitted to Board	Date Submitted to Board	BMCE Transmittal No	Date Response Required from Board	Date Returned from Board	Board Status	Date returned to Consultant	Date Required from Consultant	Date Submitted by Consultant
Item	Submission	Comments																	
			ZBP	E	ZBP-XX-XX-SC-524-819	Ventilation Schematic (PR31) - AHU 38	30/03/12	26/04/12	A	03/05/12	30/04/12	BMCE-TRANSMIT-008613 (BMCE-WTRAN-002967)	21/05/12	06/07/12	A	18/07/12 BMCE-TRANSMIT-009901			
			ZBP	E	ZBP-XX-XX-SC-524-820	Ventilation Schematic (PR31) - AHU 39	30/03/12	26/04/12	A	03/05/12	30/04/12	BMCE-TRANSMIT-008613 (BMCE-WTRAN-002967)	21/05/12	06/07/12	A	18/07/12 BMCE-TRANSMIT-009901			
			ZBP	E	ZBP-XX-XX-SC-524-821	Ventilation Schematic (PR31) - AHU 40	30/03/12	26/04/12	A	03/05/12	30/04/12	BMCE-TRANSMIT-008613 (BMCE-WTRAN-002967)	21/05/12	06/07/12	A	18/07/12 BMCE-TRANSMIT-009901			
			ZBP	E	ZBP-XX-XX-SC-524-822	Ventilation Schematic (PR31) - AHU 41	30/03/12		A	03/05/12	30/04/12	BMCE-TRANSMIT-008613 (BMCE-WTRAN-002967)	21/05/12	06/07/12	A	18/07/12 BMCE-TRANSMIT-009901			
			ZBP	E	ZBP-XX-XX-SC-524-823	Ventilation Schematic (PR31) - AHU 42	30/03/12		A	03/05/12	30/04/12	BMCE-TRANSMIT-008613 (BMCE-WTRAN-002967)	21/05/12	06/07/12	A	18/07/12 BMCE-TRANSMIT-009901			
	DRAWING REMOVED BY ZBP		ZBP	E	ZBP-XX-XX-SC-524-824	Ventilation Schematic (PR31) - AHU 43	30/03/12			03/05/12			-						
	DRAWING REMOVED BY ZBP		ZBP	E	ZBP-XX-XX-SC-524-825	Ventilation Schematic (PR31) - AHU 44	30/03/12			03/05/12			-						
	DRAWING REMOVED BY ZBP		ZBP	E	ZBP-XX-XX-SC-524-826	Ventilation Schematic (PR31) - AHU 45	30/03/12			03/05/12			-						
	DRAWING REMOVED BY ZBP		ZBP	E	ZBP-XX-XX-SC-524-827	Ventilation Schematic (PR31) - AHU 46	30/03/12			03/05/12			-						
	DRAWING REMOVED BY ZBP		ZBP	E	ZBP-XX-XX-SC-524-828	Ventilation Schematic (PR31) - AHU 47	30/03/12			03/05/12			-						
			ZBP	E	ZBP-XX-XX-SC-524-829	Ventilation Schematic (PR31) - AHU 48	30/03/12		A	03/05/12	18/05/12	BMCE-TRANSMIT-008922 (BMCE-WTRAN-003102)	08/06/12	14/08/12	A	03/09/12 BMCE-TRANSMIT-010678			
	DRAWING REMOVED BY ZBP		ZBP	E	ZBP-XX-XX-SC-524-830	Ventilation Schematic (PR31) - AHU 49	30/03/12			03/05/12			-						
	DRAWING REMOVED BY ZBP		ZBP	E	ZBP-XX-XX-SC-524-831	Ventilation Schematic (PR31) - AHU 50	30/03/12			03/05/12			-						
	DRAWING REMOVED BY ZBP		ZBP	E	ZBP-XX-XX-SC-524-832	Ventilation Schematic (PR31) - AHU 51	30/03/12			03/05/12			-						
	Issued for information on BMCE-TRANSMIT-019160 21/01/14		ZBP	E	ZBP-XX-XX-SC-524-833	Ventilation Schematic (PR31) - AHU 52	30/03/12		A	03/05/12	30/04/12	BMCE-TRANSMIT-008613 (BMCE-WTRAN-002967)	21/05/12	06/07/12	B	18/07/12 BMCE-TRANSMIT-009901			
	Issued for information on BMCE-TRANSMIT-019160 21/01/14		ZBP	E	ZBP-XX-XX-SC-524-834	Ventilation Schematic (PR31) - AHU 53	30/03/12		A	03/05/12	18/05/12	BMCE-TRANSMIT-008908 (BMCE-WTRAN-003090)	08/06/12	06/07/12	B	18/07/12 BMCE-TRANSMIT-009908			
	No longer in Use ZBP instruction		ZBP	E	ZBP-XX-XX-SC-524-835	Ventilation Schematic (PR31) - AHU 54	30/03/12			03/05/12			21/01/00						
	Issued for information on BMCE-TRANSMIT-019160 21/01/14		ZBP	E	ZBP-XX-XX-SC-524-836	Ventilation Schematic (PR31) - AHU 55	30/03/12		A	03/05/12	30/04/12	BMCE-TRANSMIT-008613 (BMCE-WTRAN-002967)	21/05/12	06/07/12	B	18/07/12 BMCE-TRANSMIT-009901			
	Issued for information on BMCE-TRANSMIT-019160 21/01/14		ZBP	E	ZBP-XX-XX-SC-524-837	Ventilation Schematic (PR31) AHU 56 & 57	31/03/12		A	03/05/12	18/05/12	BMCE-TRANSMIT-008910 (BMCE-WTRAN-003092)	08/06/12	15/08/12	B	23/08/12 BMCE-TRANSMIT-010487			
	Issued for information on BMCE-TRANSMIT-019160 21/01/14		ZBP	E	ZBP-XX-XX-SC-524-838	Ventilation Schematic (PR31) - AHU 58	30/03/12		A	03/05/12	30/04/12	BMCE-TRANSMIT-008613 (BMCE-WTRAN-002967)	21/05/12	06/07/12	B	18/07/12 BMCE-TRANSMIT-009901			
	Issued for information on BMCE-TRANSMIT-019160 21/01/14		ZBP	E	ZBP-XX-XX-SC-524-839	Ventilation Schematic (PR31) - AHU 59	30/03/12		A	03/05/12	18/05/12	BMCE-TRANSMIT-008910 (BMCE-WTRAN-003092)	08/06/12	15/08/12	B	23/08/12 BMCE-TRANSMIT-010487			
			ZBP	E	ZBP-XX-XX-SC-524-840	Ventilation Schematic (PR31) - AHU 60	30/03/12		A	03/05/12	18/05/12	BMCE-TRANSMIT-008908 (BMCE-WTRAN-003090)	08/06/12	06/07/12	A	18/07/12 BMCE-TRANSMIT-009908			
	Issued for information on BMCE-TRANSMIT-019160 21/01/14		ZBP	E	ZBP-XX-XX-SC-524-841	Ventilation Schematic (PR31) - AHU 61	30/03/12		A	03/05/12	18/05/12	BMCE-TRANSMIT-008910 (BMCE-WTRAN-003092)	08/06/12	15/08/12	B	23/08/12 BMCE-TRANSMIT-010487			
	Issued for information on BMCE-TRANSMIT-019160 21/01/14		ZBP	E	ZBP-XX-XX-SC-524-842	Ventilation Schematic (PR31) - AHU 62	30/03/12		A	03/05/12	18/05/12	BMCE-TRANSMIT-008922 (BMCE-WTRAN-003102)	08/06/12	14/08/12	B	03/09/12 BMCE-TRANSMIT-010678			
			ZBP	E	ZBP-XX-XX-SC-524-843	Staff and Core C Ventilation Schematic (PR31) AHU 64	30/03/12		A	03/05/12	30/04/12	BMCE-TRANSMIT-008613 (BMCE-WTRAN-002967)	21/05/12	06/07/12	A	18/07/12 BMCE-TRANSMIT-009901			
	Issued for information on BMCE-TRANSMIT-019160 21/01/14		ZBP	E	ZBP-XX-XX-SC-524-844	Ventilation Schematic (PR31) AHU 13 & 14	30/03/12		A	03/05/12	18/05/12	BMCE-TRANSMIT-008910 (BMCE-WTRAN-003092)	08/06/12	15/08/12	B	23/08/12 BMCE-TRANSMIT-010487			
	Issued for information on BMCE-TRANSMIT-019160 21/01/14		ZBP	E	ZBP-XX-XX-SC-524-845	Ground Floor Radiology Xray Ventilation Schematic (PR31) AHU 54	30/03/12		A	03/05/12	30/04/12	BMCE-TRANSMIT-008613 (BMCE-WTRAN-002967)	21/05/12	06/07/12	B	18/07/12 BMCE-TRANSMIT-009901			
			ZBP	E	ZBP-XX-XX-SC-524-846	Fourth Floor Heamo Oncology Ward Ventilation Schematic 31 AHU 63	30/03/12		A	03/05/12	30/04/12	BMCE-TRANSMIT-008613 (BMCE-WTRAN-002967)	21/05/12	06/07/12	A	18/07/12 BMCE-TRANSMIT-009901			
	Issued for information on BMCE-TRANSMIT-019160 21/01/14		ZBP	E	ZBP-XX-XX-SC-524-863	First Floor MDU Ventilation Schematic 33 AHU 04	30/03/12		A	03/05/12	30/04/12	BMCE-TRANSMIT-008613 (BMCE-WTRAN-002967)	21/05/12	06/07/12	B	18/07/12 BMCE-TRANSMIT-009901			
	Issued for information on BMCE-TRANSMIT-019231 29/01/14		ZBP		ZBP-XX-XX-SC-524-893	Aseptic suite ventilation schematic			A		21/10/13	BMCE-TRANSMIT-018158 (BMCE-WTRAN-009200)	11/11/13	11/11/13	B	20/11/13 BMCE-TRANSMIT-018527			

Drawing Information

31 BCL-AC-XX-SH-001

			Action By	Zone	Drawing Number	Drawing Title	Date Required from Consultant	Date Submitted by Consultant	Document Revision	Planned Date to be Submitted to Board	Date Submitted to Board	BMCE Transmittal No	Date Response Required from Board	Date Returned from Board	Board Status	Date returned to Consultant	Date Required from Consultant	Date Submitted by Consultant
Item	Submission	Comments																
			ZBP	E	ZBP-XX-XX-SC-525-431	Secondary Chi led Water Distribution Schematic Plantroom 31 Sheet 1 of 2	30/03/12			03/05/12	18/05/12	BMCE-TRANSMIT-008912 (BME-WTRAN-003094)	08/06/12	14/08/12	A	03/09/12 BMCE-TRANSMIT-010677		
		Issued for information on BMCE-TRANSMIT-019160 22/01/2014	ZBP	E	ZBP-XX-XX-SC-525-432	Secondary Ch lled Water Schematic Plantroom 31	30/03/12			03/05/12	18/05/12	BMCE-TRANSMIT-008913 (BMCE-WTRAN-003095)	08/06/12	02/08/12	A	23/08/12 BMCE-TRANSMIT-010491		
			ZBP	E	ZBP-XX-XX-SC-521-401	Primary MTHW Heating Schematic Sheet 1 of 2		06/03/12	B		07/03/12	BMCE-TRANSMIT-007971 (BMCE-WTRAN-002670)	28/03/12	25/06/12	A	05/07/12 BMCE-TRANSMIT-009683		
			ZBP	E	ZBP-XX-XX-SC-521-402	Primary MTHW Heating Schematic Sheet 2 of 2		06/03/12	B		07/03/12	BMCE-TRANSMIT-007971 (BMCE-WTRAN-002670)	28/03/12	25/06/12	A	05/07/12 BMCE-TRANSMIT-009683		
			ZBP	E	ZBP-XX-XX-SC-525-501	Primary Chilled Water Schematic Sheet 1 of 2		06/03/12	B		07/03/12	BMCE-TRANSMIT-007971 (BMCE-WTRAN-002670)	28/03/12	25/06/12	A	05/07/12 BMCE-TRANSMIT-009683		
			ZBP	E	ZBP-XX-XX-SC-525-502	Primary Chilled Water Schematic Sheet 2 of 2		06/03/12	B		07/03/12	BMCE-TRANSMIT-007971 (BMCE-WTRAN-002670)	28/03/12	25/06/12	A	05/07/12 BMCE-TRANSMIT-009683		
			ZBP	E	ZBP-XX-XX-SC-525-503	Primary Chi led Water Distribution Schematic			C		18/05/12	BMCE-TRANSMIT-008912 (BME-WTRAN-003094)	08/06/12	14/08/12	A	03/09/12 BMCE-TRANSMIT-010677		

Drawing Information

31	BCL-AC-XX-SH-001						1st Submission							2nd Submission					
			Action By	Zone	Drawing Number	Drawing Title	Date Required from Consultant	Date Submitted by Consultant	Document Revision	Planned Date to be Submitted to Board	Date Submitted to Board	BMCE Transmittal No	Date Response Required from Board	Date Returned from Board	Board Status	Date returned to Consultant	Date Required from Consultant	Date Submitted by Consultant	
Item	Submission	Comments																	
	Electrical Services Schematics	Issued for information on BMCE-TRANSMIT-019160 22/01/2014	ZBP	E	ZBP-XX-XX-SC-532-051	Low Voltage Schematic - Substation 5A	30/03/12		A	30/03/12	19/04/12	BMCE-TRANSMIT-008521 (BMCE-WTRAN-002944)	10/05/12	11/05/12	B	24/05/12 BMCE-TRANSMIT-009060			
			ZBP	E	ZBP-XX-XX-SC-532-052	Low Voltage Schematic - Substation 5B	30/03/12		A	30/03/12	19/04/12	BMCE-TRANSMIT-008521 (BMCE-WTRAN-002944)	10/05/12	11/05/12	B	24/05/12 BMCE-TRANSMIT-009060			
			ZBP	E	ZBP-XX-XX-SC-532-021	Low Voltage Schematic - Substation 2A	30/03/12		A	30/03/12	09/05/12	BMCE-TRANSMIT-008751 (BMCE-WTRAN-003016)	30/05/12	22/06/12	A	04/07/12 BMCE-TRANSMIT-009670			
			ZBP	E	ZBP-XX-XX-SC-532-022	Low Voltage Schematic - Substation 2B	30/03/12		A	30/03/12	09/05/12	BMCE-TRANSMIT-008751 (BMCE-WTRAN-003016)	30/05/12	22/06/12	A	04/07/12 BMCE-TRANSMIT-009670			
	Public Health Services Schematics		ZBP	E	ZBP-XX-XX-SC-500-031	Domestic Water Services Schematic Plantroom 31	30/03/12		A	03/05/12	30/05/12	BMCE-TRANSMIT-009098 (BMCE-WTRAN-003159)	20/06/12	19/07/12	A	28/07/12 BMCE-TRANSMIT-010051 15/08/12			
	Plantroom 121 Mechanical Services Drawings		ZBP	E	ZBP-ZE-12-PL-524-161	Plantroom 121 Ventilation	31/08/12			05/10/12	08/04/13	BMCE-TRANSMIT-014973 (BMCE-WTRAN-006880)	29/04/13	07/05/13	C	20/05/13 BMCE-TRANSMIT-015769			
			ZBP	E	ZBP-ZE-12-PL-524-162	Plantroom 121 Ventilation	31/08/12			05/10/12	08/04/13	BMCE-TRANSMIT-014973 (BMCE-WTRAN-006880)	29/04/13	07/05/13	B	20/05/13 BMCE-TRANSMIT-015769			
			ZBP	E	ZBP-ZE-12-PL-523-161	Plantroom 121 HTG & CHW	31/08/12		A	05/10/12	08/04/13	BMCE-TRANSMIT-014973 (BMCE-WTRAN-006880)	29/04/13	07/05/13	C	20/05/13 BMCE-TRANSMIT-015769			
			ZBP	E	ZBP-ZE-12-PL-523-162	Plantroom 121 HTG & CHW	31/08/12			05/10/12	08/04/13	BMCE-TRANSMIT-014973 (BMCE-WTRAN-006880)	29/04/13	07/05/13	A	20/05/13 BMCE-TRANSMIT-015769			
	Electrical Services Drawings		ZBP	E	ZBP-ZE-12-PL-532-161	Plantroom 121 LV Power	31/08/12		A	05/10/12	06/05/13	BMCE-TRANSMIT-016119 (BMCE-WTRAN-007793)	27/05/13	10/07/13	A	BMCE-TRANSMIT-016829			
		Removed by ZBP	ZBP	E	ZBP-ZE-12-PL-532-162	Plantroom 121 LV Power	31/08/12			06/10/12			-						
	Public Health Services Drawings	Removed by ZBP	ZBP	E	ZBP-ZE-12-PL-581-161	Plantroom 121 Sanitary and Rainwater Layout	31/08/12			06/10/12			-						
		Removed by ZBP	ZBP	E	ZBP-ZE-12-PL-581-162	Plantroom 121 Sanitation and Rainwater Layout	31/08/12			06/10/12			-						
		Removed by ZBP	ZBP	E	ZBP-ZF-04-PL-512-046	Plantroom 121 Roof Sanitary and Rainwater Layout	31/08/12			06/10/12			-						
		Removed by ZBP	ZBP	E	ZBP-ZE-13-PL-581-164	Plantroom 121 Roof Sanitation and Rainwater Layout	31/08/12			06/10/12			-						
			ZBP	E	ZBP-XX-XX-SC-524-905	Ventilation Schematic (PR121) - AHU 05	31/08/12			05/10/12	09/11/12	BMCE-TRANSMIT-012216 (BMCE-WTRAN-04546)	30/11/12	03/12/12	A	06/12/12 BMCE-TRANSMIT-012805			
			ZBP	E	ZBP-XX-XX-SC-524-906	Ventilation Schematic (PR121) - AHU 06	31/08/12			05/10/12	09/11/12	BMCE-TRANSMIT-012216 (BMCE-WTRAN-04546)	30/11/12	03/12/12	A	06/12/12 BMCE-TRANSMIT-012805			
			ZBP	E	ZBP-XX-XX-SC-524-907	Ventilation Schematic (PR121) - AHU 07	31/08/12			05/10/12	09/11/12	BMCE-TRANSMIT-012216 (BMCE-WTRAN-04546)	30/11/12	03/12/12	A	06/12/12 BMCE-TRANSMIT-012805			
		No longer in Use ZBP instruction	ZBP	E	ZBP-XX-XX-SC-524-908	Ventilation Schematic (PR121) - AHU 08	31/08/12			06/10/12			21/01/00						
			ZBP	E	ZBP-XX-XX-SC-521-461	Secondary Heating Schematic Plantroom 121	31/08/12		A	05/10/12	18/12/12	BMCE-TRANSMIT-012940 (BMCE-WTRAN-005171)	08/01/13	07/01/13	A	16/01/13 BMCE-TRANSMIT-013348			
		DELETED BY ZBP	ZBP	E	ZBP-XX-XX-SC-521-462	Secondary Heating Distribution Schematic Plantroom 121	31/08/12			06/10/12			-						
		Issued for information on BMCE-TRANSMIT-019160 22/01/2014	ZBP	E	ZBP-XX-XX-SC-525-561	Secondary Chilled Water Schematic Plantroom 121	31/08/12		A	05/10/12	18/12/12	BMCE-TRANSMIT-012940 (BMCE-WTRAN-005171)	08/01/13	07/01/13	B	16/01/13 BMCE-TRANSMIT-			

Drawing Information

31 BCL-AC-XX-SH-001

1st Submission2nd Submission

			Action By	Zone	Drawing Number	Drawing Title	Date Required from Consultant	Date Submitted by Consultant	Document Revision	Planned Date to be Submitted to Board	Date Submitted to Board	BMCE Transmittal No	Date Response Required from Board	Date Returned from Board	Board Status	Date returned to Consultant	Date Required from Consultant	Date Submitted by Consultant
Item	Submission	Comments																
		DELETED BY ZBP	ZBP	E	ZBP-XX-XX-SC-525-562	Secondary Chi-led Water Distribution Schematic Plantroom 121-												
		Issued for information on BMCE-TRANSMIT-018897 18/12/2013	ZBP	E	ZBP-ZE-03-SE-590-002	Plantroom 31 Sections 2			A		14/12/12	BMCE-TRANSMIT-012891 (BMCE-WTRAN-005137)	04/01/13	04/01/13	B	16/01/13 BMCE-TRANSMIT-013355		
	Lighting	This was issued for information on BMCE-TRANSMIT-018891 18/12/13	MER	E	ME-SZ-B1-PL-541-502	Basement Floor Plan - NSGH Basement - FM Core C- Lighting Layout	23/01/12		A	30/03/12	06/06/12	BMCE-TRANSMIT-009244 (BMCE-WTRAN-003216)	27/06/12	11/07/12	B	16/07/12 BMCE-TRANSMIT-009862		
		This was issued for information on BMCE-TRANSMIT-018592 26/11/13	MER	E	ME-SZ-B1-PL-541-505	Basement Floor Plan - NSGH Basement - Catering - Lighting Layout	23/01/12		A	30/03/12	06/06/12	BMCE-TRANSMIT-009244 (BMCE-WTRAN-003216)	27/06/12	11/07/12	B	16/07/12 BMCE-TRANSMIT-009862		
		This was issued for information on BMCE-TRANSMIT-018592 26/11/13	MER	E	ME-SZ-B1-PL-541-506	Basement Floor Plan - NSGH Basement - Tunnel & FM Core F - Lighting Layout	23/01/12		A	30/03/12	06/06/12	BMCE-TRANSMIT-009244 (BMCE-WTRAN-003216)	27/06/12	11/07/12	B	16/07/12 BMCE-TRANSMIT-009862		
		This was issued for information only on BMCE-TRANSMIT-018891 18/12/13	MER	E	ME-SZ-B1-PL-541-510	Basement Floor Plan - NSGH Basement - Tunnel & FM Core F - Lighting Layout	23/01/12		A	30/03/12	06/06/12	BMCE-TRANSMIT-009244 (BMCE-WTRAN-003216)	27/06/12	11/07/12	B	16/07/12 BMCE-TRANSMIT-009862		
		This was issued for information on BMCE-TRANSMIT-018592 26/11/13	MER	E	ME-ZF-B1-PL-541-504	Basement Floor Plan. NSGH Basement, Catering. Lighting Layout Zone E			A		06/06/12	BMCE-TRANSMIT-009244 (BMCE-WTRAN-003216)	27/06/12	11/07/12	B	16/07/12 BMCE-TRANSMIT-009862		
		This was issued for information on BMCE-TRANSMIT-018592 26/11/13	MER	E	ME-ZE-00-PL-541-532	Ground Floor Plan NSGH - Radiology Lighting Layout	23/01/12		A	24/02/12	24/02/12	BMCE-TRANSMIT-007789 (BMCE-WTRAN-002621)	16/03/12	13/03/12	B	14/03/12 BMCE-TRANSMIT-008052		
		This was issued for information on BMCE-TRANSMIT-018592 26/11/13	MER	E	ME-ZE-00-PL-541-533	Ground Floor Plan NSGH - Radiology Lighting Layout	23/01/12		A	24/02/12	24/02/12	BMCE-TRANSMIT-007789 (BMCE-WTRAN-002621)	16/03/12	13/03/12	B	14/03/12 BMCE-TRANSMIT-008052		
		This was issued for information on BMCE-TRANSMIT-018592 26/11/13	MER	E	ME-ZE-00-PL-541-534	Ground Floor Plan NSGH - Medical Illustration Lighting Layout	23/01/12		A	24/02/12	24/02/12	BMCE-TRANSMIT-007789 (BMCE-WTRAN-002621)	16/03/12	13/03/12	B	14/03/12 BMCE-TRANSMIT-008052		
		This was issued for information on BMCE-TRANSMIT-018592 26/11/13	MER	E	ME-ZE-00-PL-541-535	Ground Floor Plan NCH - Radiology Lighting Layout	23/01/12		A	24/02/12	24/02/12	BMCE-TRANSMIT-007789 (BMCE-WTRAN-002621)	16/03/12	13/03/12	B	14/03/12 BMCE-TRANSMIT-008052		
		This was issued for information on BMCE-TRANSMIT-018592 26/11/13	MER	E	ME-ZE-00-PL-541-536	Ground Floor Plan NCH - Radiology Lighting Layout	23/01/12		A	24/02/12	24/02/12	BMCE-TRANSMIT-007789 (BMCE-WTRAN-002621)	16/03/12	13/03/12	B	14/03/12 BMCE-TRANSMIT-008052		
		This drawing was issued to the board for information Only on BMCE-TRANSMIT-018592	MER	E	ME-SZ-00-PL-541-531	Ground Floor Plan NCH - Radiology Lighting Layout	23/01/12		A	24/02/12	24/02/12	BMCE-TRANSMIT-007789 (BMCE-WTRAN-002621)	16/03/12	13/03/12	B	14/03/12 BMCE-TRANSMIT-008052		
		This drawing was issued to the board for information only on BMCE-TRANSMIT-018592	MER	E	ME-SZ-01-PL-541-506	First Floor Plan NCH - Theatres, Endoscopy & Recovery Lighting Layout	23/01/12		A	24/02/12	24/02/12	BMCE-TRANSMIT-007789 (BMCE-WTRAN-002621)	16/03/12	13/03/12	B	14/03/12 BMCE-TRANSMIT-008052		
		This was issued for information only on BMCE-TRANSMIT-018891 18/12/13	MER	E	ME-ZF-01-PL-541-507	First Floor Plan NCH - Theatres, Endoscopy & Recovery Lighting Layout	23/01/12		A	24/02/12	24/02/12	BMCE-TRANSMIT-007789 (BMCE-WTRAN-002621)	16/03/12	13/03/12	B	14/03/12 BMCE-TRANSMIT-008052		
		This was issued for information on BMCE-TRANSMIT-018592 26/11/13	MER	E	ME-ZE-01-PL-541-508	First Floor Plan NCH - Theatres, Endoscopy & Recovery Lighting Layout	23/01/12		A	24/02/12	24/02/12	BMCE-TRANSMIT-007789 (BMCE-WTRAN-002621)	16/03/12	13/03/12	B	14/03/12 BMCE-TRANSMIT-008052		
		This was issued for information on BMCE-TRANSMIT-018592 26/11/13	MER	E	ME-ZE-01-PL-541-509	First Floor Plan NCH - Interventional Radiology Lighting Layout	23/01/12		A	24/02/12	24/02/12	BMCE-TRANSMIT-007789 (BMCE-WTRAN-002621)	16/03/12	13/03/12	B	14/03/12 BMCE-TRANSMIT-008052		
		This was issued for information on BMCE-TRANSMIT-018592 26/11/13	MER	E	ME-ZE-01-PL-541-510	First Floor Plan NCH - Radiology, CT & MRI Lighting Layout	23/01/12		A	24/02/12	24/02/12	BMCE-TRANSMIT-007789 (BMCE-WTRAN-002621)	16/03/12	13/03/12	B	14/03/12 BMCE-TRANSMIT-008052		
		This drawing was issued to the board for information only on BMCE-TRANSMIT-018592	MER	E	ME-SZ-01-PL-541-533	First Floor Plan NSGH - Radiology Lighting Layout	23/01/12		A	24/02/12	24/02/12	BMCE-TRANSMIT-007789 (BMCE-WTRAN-002621)	16/03/12	13/03/12	B	14/03/12 BMCE-TRANSMIT-008052		
		This drawing was issued to the board for information only on BMCE-TRANSMIT-018592	MER	E	ME-SZ-01-PL-541-534	First Floor Plan NSGH - Radiology Lighting Layout	23/01/12		A	24/02/12	24/02/12	BMCE-TRANSMIT-007789 (BMCE-WTRAN-002621)	16/03/12	13/03/12	B	14/03/12 BMCE-TRANSMIT-008052		
		This drawing was issued to the board for information only on BMCE-TRANSMIT-018592	MER	E	ME-SZ-01-PL-541-535	First Floor Plan NSGH - Radiology Lighting Layout	23/01/12		A	24/02/12	24/02/12	BMCE-TRANSMIT-007789 (BMCE-WTRAN-002621)	16/03/12	13/03/12	B	14/03/12 BMCE-TRANSMIT-008052		
		This was issued for information on BMCE-TRANSMIT-018592 26/11/13	MER	E	ME-ZE-01-PL-541-536	First Floor Plan NCH - Nuclear Medicine Lighting Layout	23/01/12		A	24/02/12	24/02/12	BMCE-TRANSMIT-007789 (BMCE-WTRAN-002621)	16/03/12	13/03/12	B	14/03/12 BMCE-TRANSMIT-008052		
		This was issued for information on BMCE-TRANSMIT-018592 26/11/13	MER	E	ME-ZE-02-PL-541-517	Second Floor Plan NSGH/NCH Medical Physics & Bio-Engineering Lighting Layout	23/01/12		A	24/02/12	24/02/12	BMCE-TRANSMIT-007789 (BMCE-WTRAN-002621)	16/03/12	13/03/12	B	14/03/12 BMCE-TRANSMIT-008052		
			MER	E	ME-ZE-02-PL-541-518	Second Floor Plan NSGH Decontamination Suite Lighting Layout	23/01/12		A	24/02/12	24/02/12	BMCE-TRANSMIT-007789 (BMCE-WTRAN-002621)	16/03/12	13/03/12	A	14/03/12 BMCE-TRANSMIT-008052		
		This was issued for information on BMCE-TRANSMIT-018592 26/11/13	MER	E	ME-ZE-02-PL-541-519	Second Floor Plan NSGH Endoscopy Lighting Layout	23/01/12		A	24/02/12	24/02/12	BMCE-TRANSMIT-007789 (BMCE-WTRAN-002621)	16/03/12	13/03/12	B	14/03/12 BMCE-TRANSMIT-008052		
		This was issued for information on BMCE-TRANSMIT-018592 26/11/13	MER	E	ME-ZE-02-PL-541-523	Second Floor Plan NSGH Theatres Lighting Layout	23/01/12		A	24/02/12	24/02/12	BMCE-TRANSMIT-007789 (BMCE-WTRAN-002621)	16/03/12	13/03/12	B	14/03/12 BMCE-TRANSMIT-008052		
		This was issued for information on BMCE-TRANSMIT-018592 26/11/13	MER	E	ME-ZE-02-PL-541-534	Second Floor Plan NCH Transport Base Lighting Layout	23/01/12		A	24/02/12	24/02/12	BMCE-TRANSMIT-007789 (BMCE-WTRAN-002621)	16/03/12	13/03/12	B	14/03/12 BMCE-TRANSMIT-008052		
		This was issued for information on BMCE-TRANSMIT-018592 26/11/13	MER	E	ME-ZE-03-PL-541-503	Thrid Floor Plan - Hotel/Services/Staff Accommodation LightingLayout Zone K/E			A		01/03/13	BMCE-TRANSMIT-014279 (BMCE-WTRAN-006293)	22/03/13	12/04/13	B	30/04/13 BMCE-TRANSMIT-015420		
		This was issued for information on BMCE-TRANSMIT-018592 26/11/13	MER	E	ME-ZE-03-PL-541-504	Third Floor Plan NSGH/NCH Staff Change/Hotel Services/ Staff Accommodation Lintrion Layout			A		01/03/13	BMCE-TRANSMIT-014279 (BMCE-WTRAN-006293)	22/03/13	12/04/13	B	30/04/13 BMCE-TRANSMIT-015420		

Drawing Information

31 BCL-AC-XX-SH-001

			Action By	Zone	Drawing Number	Drawing Title	Date Required from Consultant	Date Submitted by Consultant	Document Revision	Planned Date to be Submitted to Board	Date Submitted to Board	BMCE Transmittal No	Date Response Required from Board	Date Returned from Board	Board Status	Date returned to Consultant	Date Required from Consultant	Date Submitted by Consultant		
Item	Submission	Comments																		
		Removed by Mercury - ME-ZE-XX-PL-541-514 SUBMITTED FOR RDD REVIEW	MER	E	ME-ZE-07-PL-541-505	Seventh Floor Plan NSGH Inpatient Wards Lighting Layout	16/03/12			03/05/12										
		Removed by Mercury - ME-ZE-XX-PL-541-512 SUBMITTED FOR RDD REVIEW	MER	E	ME-ZE-08-PL-541-503	Eighth Floor Plan NSGH Inpatient Wards Lighting Layout	16/03/12			03/05/12										
		Removed by Mercury - ME-ZE-XX-PL-541-513 SUBMITTED FOR RDD REVIEW	MER	E	ME-ZE-08-PL-541-504	Eighth Floor Plan NSGH Inpatient Wards Lighting Layout	16/03/12			03/05/12										
		Removed by Mercury - ME-ZE-XX-PL-541-514 SUBMITTED FOR RDD REVIEW	MER	E	ME-ZE-08-PL-541-505	Eighth Floor Plan NSGH Inpatient Wards Lighting Layout	16/03/12			03/05/12										
		Removed by Mercury - ME-ZE-XX-PL-541-512 SUBMITTED FOR RDD REVIEW	MER	E	ME-ZE-09-PL-541-503	Ninth Floor Plan NSGH Inpatient Wards Lighting Layout	16/03/12			03/05/12										
		Removed by Mercury - ME-ZE-XX-PL-541-512 SUBMITTED FOR RDD REVIEW	MER	E	ME-ZE-09-PL-541-504	Ninth Floor Plan NSGH Inpatient Wards Lighting Layout	16/03/12			03/05/12										
		Removed by Mercury - ME-ZE-XX-PL-541-513 SUBMITTED FOR RDD REVIEW	MER	E	ME-ZE-09-PL-541-505	Ninth Floor Plan NSGH Inpatient Wards Lighting Layout	16/03/12			03/05/12										
		Removed by Mercury - ME-ZE-XX-PL-541-514 SUBMITTED FOR RDD REVIEW	MER	E	ME-ZE-10-PL-541-503	Tenth Floor Plan NSGH Inpatient Wards Lighting Layout	16/03/12			03/05/12										
		Removed by Mercury - ME-ZE-XX-PL-541-512 SUBMITTED FOR RDD REVIEW	MER	E	ME-ZE-10-PL-541-504	Tenth Floor Plan NSGH Inpatient Wards Lighting Layout	16/03/12			03/05/12										
		Removed by Mercury - ME-ZE-XX-PL-541-513 SUBMITTED FOR RDD REVIEW	MER	E	ME-ZE-10-PL-541-505	Tenth Floor Plan NSGH Inpatient Wards Lighting Layout	16/03/12			03/05/12										
		Removed by Mercury - ME-ZE-XX-PL-541-514 SUBMITTED FOR RDD REVIEW	MER	E	ME-ZE-11-PL-541-503	Eleventh Floor Plan NSGH Inpatient Wards Lighting Layout	16/03/12			03/05/12										
		Removed by Mercury - ME-ZE-XX-PL-541-512 SUBMITTED FOR RDD REVIEW	MER	E	ME-ZE-11-PL-541-504	Eleventh Floor Plan NSGH Inpatient Wards Lighting Layout	16/03/12			03/05/12										
		Removed by Mercury - ME-ZE-XX-PL-541-513 SUBMITTED FOR RDD REVIEW	MER	E	ME-ZE-11-PL-541-505	Eleventh Floor Plan NSGH Inpatient Wards Lighting Layout	16/03/12			03/05/12										
		Removed by Mercury - ME-ZE-XX-PL-541-514 SUBMITTED FOR RDD REVIEW	MER	E	ME-ZE-11-PL-541-514	Eleventh Floor Plan NSGH Inpatient Wards Lighting Layout	16/03/12			03/05/12										
		This was issued for information on BMCE-TRANSMIT-018592 26/11/13	MER	E	ME-ZE-XX-PL-541-512	Sixth to Eleventh Floor Plan NSGH Inpatients Wards Lighting Layout, Zone E	16/03/12		A	03/05/12	17/05/12	BMCE-TRANSMIT-008898 (BMCE-WTRAN-003083)	07/06/12	11/06/12	B	18/06/12 BMCE-TRANSMIT-009387				
		This was issued for information on BMCE-TRANSMIT-018592 26/11/13	MER	E	ME-ZE-XX-PL-541-513	Sixth to Eleventh Floor Plan NSGH Inpatients Wards Lighting Layout, Zone E	16/03/12		A	03/05/12	17/05/12	BMCE-TRANSMIT-008898 (BMCE-WTRAN-003083)	07/06/12	11/06/12	B	18/06/12 BMCE-TRANSMIT-009387				
		This was issued for information on BMCE-TRANSMIT-018592 26/11/13	MER	E	ME-ZE-XX-PL-541-514	Sixth to Eleventh Floor Plan NSGH Inpatients Wards Lighting Layout, Zone E	16/03/12		A	03/05/12	17/05/12	BMCE-TRANSMIT-008898 (BMCE-WTRAN-003083)	07/06/12	11/06/12	B	18/06/12 BMCE-TRANSMIT-009387				
		Removed by Mercury - WRONG DRAWING NO.	MER	E	ME-XX-XX-SP-541-100	Lighting Calculations—Zone E							-							
		Removed by Mercury - DUPLICATE	MER	E	ME-XX-XX-SP-541-101	Luminaire Schedule—Zone E							-							
	SmallPower & Data	Removed By Mercury - NOT REQUIRED FOR RDD (SMALL POWER SHOWN ON NA 400 SERIES DRAWINGS)	MER	E	ME-ZE-00-PL-531-532	Ground Floor Plan NSGH Radiology Small Power & General Services Layout	23/01/12			20/02/12			-							
		Removed By Mercury - NOT REQUIRED FOR RDD (SMALL POWER SHOWN ON NA 400 SERIES DRAWINGS)	MER	E	ME-ZE-00-PL-531-533	Ground Floor Plan NSGH Radiology Small Power & General Services Layout	23/01/12			20/02/12			-							

Drawing Information

31 BCL-AC-XX-SH-001

1st Submission2nd Submission

		Comments	Action By	Zone	Drawing Number	Drawing Title	Date Required from Consultant	Date Submitted by Consultant	Document Revision	Planned Date to be Submitted to Board	Date Submitted to Board	BMCE Transmittal No	Date Response Required from Board	Date Returned from Board	Board Status	Date returned to Consultant	Date Required from Consultant	Date Submitted by Consultant
Item	Submission																	
		Removed By Mercury - NOT REQUIRED FOR RDD (SMALL POWER SHOWN ON NA 400 SERIES DRAWINGS)	MER	E	ME-ZE-00-PL-531-534	Ground Floor Plan NSGH – Medical Illustration Small Power & General Ser-ices Layout	23/01/12			20/02/12			-					
		Removed By Mercury - NOT REQUIRED FOR RDD (SMALL POWER SHOWN ON NA 400 SERIES DRAWINGS)	MER	E	ME-ZE-00-PL-531-535	Ground Floor Plan NCH – Radiology Small Power & General Ser-ices Layout	23/01/12			20/02/12			-					
		Removed By Mercury - NOT REQUIRED FOR RDD (SMALL POWER SHOWN ON NA 400 SERIES DRAWINGS)	MER	E	ME-ZE-00-PL-531-536	Ground Floor Plan NCH – Radiology Small Power & General Services Layout	23/01/12			20/02/12			-					
		Removed By Mercury - NOT REQUIRED FOR RDD (SMALL POWER SHOWN ON NA 400 SERIES DRAWINGS)	MER	E	ME-ZE-01-PL-531-508	First Floor Plan NCH – Theatres, Endoscopy & Recovery Small Power & General Ser-ices Layout	23/01/12			20/02/12			-					
		Removed By Mercury - NOT REQUIRED FOR RDD (SMALL POWER SHOWN ON NA 400 SERIES DRAWINGS)	MER	E	ME-ZE-01-PL-531-509	First Floor Plan NCH – Inter-entional Radiology Small Power & General Services Layout	23/01/12			20/02/12			-					
		Removed By Mercury - NOT REQUIRED FOR RDD (SMALL POWER SHOWN ON NA 400 SERIES DRAWINGS)	MER	E	ME-ZE-01-PL-531-510	First Floor Plan NCH – Radiology, CT & MRI Small Power & General Ser-ices Layout	23/01/12			20/02/12			-					
		Removed By Mercury - NOT REQUIRED FOR RDD (SMALL POWER SHOWN ON NA 400 SERIES DRAWINGS)	MER	E	ME-ZE-01-PL-531-536	First Floor Plan NCH – Nuclear Medicine Small Power & General Ser-ices Layout	23/01/12			20/02/12			-					
		Removed By Mercury - NOT REQUIRED FOR RDD (SMALL POWER SHOWN ON NA 400 SERIES DRAWINGS)	MER	E	ME-ZE-02-PL-531-517	Second Floor Plan NSGH/NCH – Medical Physics & & Bio Engineering Small Power & General Ser-ices Layout	23/01/12			20/02/12			-					
		Removed By Mercury - NOT REQUIRED FOR RDD (SMALL POWER SHOWN ON NA 400 SERIES DRAWINGS)	MER	E	ME-ZE-02-PL-531-518	Second Floor Plan NSGH Decontamination Suite Small Power & General Services Layout	23/01/12			20/02/12			-					
		Removed By Mercury - NOT REQUIRED FOR RDD (SMALL POWER SHOWN ON NA 400 SERIES DRAWINGS)	MER	E	ME-ZE-02-PL-531-519	Second Floor Plan NSGH Endoscopy Small Power & General Services Layout	23/01/12			20/02/12			-					
		Removed By Mercury - NOT REQUIRED FOR RDD (SMALL POWER SHOWN ON NA 400 SERIES DRAWINGS)	MER	E	ME-ZE-02-PL-531-523	Second Floor Plan NSGH Theatres Small Power & General Ser-ices Layout	23/01/12			20/02/12			-					
		Removed By Mercury - NOT REQUIRED FOR RDD (SMALL POWER SHOWN ON NA 400 SERIES DRAWINGS)	MER	E	ME-ZE-02-PL-531-534	Second Floor Plan NCH Transport Base Small Power & General Services Layout	23/01/12			20/02/12			-					
		Removed By Mercury - NOT REQUIRED FOR RDD (SMALL POWER SHOWN ON NA 400 SERIES DRAWINGS)	MER	E	ME-ZE-03-PL-531-504	Third Floor Plan NSGH/NCH Staff Change/Hotel Ser-ices/ Staff Accomodation Small Power & General Services Layout				20/02/12			-					
		Removed By Mercury - NOT REQUIRED FOR RDD (SMALL POWER SHOWN ON NA 400 SERIES DRAWINGS)	MER	E	ME-ZE-04-PL-531-512	Fourth Floor Plan NSGH Renal Patients & Day Unit Small Power & General Ser-ices Layout	16/03/12			03/05/12			-					
		Removed By Mercury - NOT REQUIRED FOR RDD (SMALL POWER SHOWN ON NA 400 SERIES DRAWINGS)	MER	E	ME-ZE-04-PL-531-513	Fourth Floor Plan NSGH Haemato Oncology Small Power & General Ser-ices Layout	16/03/12			03/05/12			-					
		Removed By Mercury - NOT REQUIRED FOR RDD (SMALL POWER SHOWN ON NA 400 SERIES DRAWINGS)	MER	E	ME-ZE-04-PL-531-514	Fourth Floor Plan NSGH Haemato Oncology Small Power & General Services Layout	16/03/12			03/05/12			-					
		Removed By Mercury - NOT REQUIRED FOR RDD (SMALL POWER SHOWN ON NA 400 SERIES DRAWINGS)	MER	E	ME-ZE-05-PL-531-512	Fifth Floor Plan NSGH Inpatient Wards Small Power & General Ser-ices Layout	16/03/12			03/05/12			-					
		Removed By Mercury - NOT REQUIRED FOR RDD (SMALL POWER SHOWN ON NA 400 SERIES DRAWINGS)	MER	E	ME-ZE-05-PL-531-513	Fifth Floor Plan NSGH Inpatient Wards Small Power & General Ser-ices Layout	16/03/12			03/05/12			-					
		Removed By Mercury - NOT REQUIRED FOR RDD (SMALL POWER SHOWN ON NA 400 SERIES DRAWINGS)	MER	E	ME-ZE-05-PL-531-514	Fifth Floor Plan NSGH Inpatient Wards Small Power & General Ser-ices Layout	16/03/12			03/05/12			-					
		Removed By Mercury - NOT REQUIRED FOR RDD (SMALL POWER SHOWN ON NA 400 SERIES DRAWINGS)	MER	E	ME-ZE-11-PL-531-514	Ele-enth Floor Plan NSGH Inpatient Wards Small Power & General Services Layout	16/03/12			03/05/12			-					
		Removed By Mercury - NOT REQUIRED FOR RDD (SMALL POWER SHOWN ON NA 400 SERIES DRAWINGS)	MER	E	ME-ZE-00-PL-532-532	Ground Floor Plan NSGH – Radiology High Level Layout	23/01/12			20/02/12			-					
		Removed By Mercury - NOT REQUIRED FOR RDD (SMALL POWER SHOWN ON NA 400 SERIES DRAWINGS)	MER	E	ME-ZE-00-PL-532-533	Ground Floor Plan NSGH – Radiology High Level Layout	23/01/12			20/02/12			-					
		Removed By Mercury - NOT REQUIRED FOR RDD (SMALL POWER SHOWN ON NA 400 SERIES DRAWINGS)	MER	E	ME-ZE-00-PL-532-534	Ground Floor Plan NSGH – Medical Illustration High Level Layout	23/01/12			20/02/12			-					
		Removed By Mercury - NOT REQUIRED FOR RDD (SMALL POWER SHOWN ON NA 400 SERIES DRAWINGS)	MER	E	ME-ZE-00-PL-532-535	Ground Floor Plan NCH – Radiology High Level Layout	23/01/12			20/02/12			-					
		Removed By Mercury - NOT REQUIRED FOR RDD (SMALL POWER SHOWN ON NA 400 SERIES DRAWINGS)	MER	E	ME-ZE-00-PL-532-536	Ground Floor Plan NCH – Radiology High Level Layout	23/01/12			20/02/12			-					
		Removed By Mercury - NOT REQUIRED FOR RDD (SMALL POWER SHOWN ON NA 400 SERIES DRAWINGS)	MER	E	ME-ZE-01-PL-532-508	First Floor Plan NCH – Theatres, Endoscopy & Recovery High Level Layout	23/01/12			20/02/12			-					
		Removed By Mercury - NOT REQUIRED FOR RDD (SMALL POWER SHOWN ON NA 400 SERIES DRAWINGS)	MER	E	ME-ZE-01-PL-532-509	First Floor Plan NCH – Inter-entional Radiology High Level Layout	23/01/12			20/02/12			-					
		Removed By Mercury - NOT REQUIRED FOR RDD (SMALL POWER SHOWN ON NA 400 SERIES DRAWINGS)	MER	E	ME-ZE-01-PL-532-510	First Floor Plan NCH – Radiology, CT & MRI High Level Layout	23/01/12			20/02/12			-					
		Removed By Mercury - NOT REQUIRED FOR RDD (SMALL POWER SHOWN ON NA 400 SERIES DRAWINGS)	MER	E	ME-ZE-01-PL-532-536	First Floor Plan NCH – Nuclear Medicine High Level Layout	23/01/12			20/02/12			-					
		Removed By Mercury - NOT REQUIRED FOR RDD (SMALL POWER SHOWN ON NA 400 SERIES DRAWINGS)	MER	E	ME-ZE-02-PL-532-517	Second Floor Plan NSGH/NCH – Medical Physics & & Bio Engineering High Level Layout	23/01/12			20/02/12			-					
		Removed By Mercury - NOT REQUIRED FOR RDD (SMALL POWER SHOWN ON NA 400 SERIES DRAWINGS)	MER	E	ME-ZE-02-PL-532-518	Second Floor Plan NSGH Decontamination Suite High Level Layout	23/01/12			20/02/12			-					

Drawing Information

31

BCL-AC-XX-SH-001

1st Submission

2nd Submission

Item	Submission	Comments	Action By		Zone	Drawing Number	Drawing Title	Date Required from Consultant	Date Submitted by Consultant	Document Revision	Planned Date to be Submitted to Board	Date Submitted to Board	BMCE Transmittal No	Date Response Required from Board	Date Returned from Board	Board Status	Date returned to Consultant	Date Required from Consultant	Date Submitted by Consultant
		Removed By Mercury - NOT REQUIRED FOR RDD (SMALL POWER SHOWN ON NA 400 SERIES DRAWINGS)	MER		E	ME-ZE-04-PL-532-512	Fourth Floor Plan NSGH Renal Patients & Day Unit High Le-el Layout	16/03/12			21/05/12			-					
		Removed By Mercury - NOT REQUIRED FOR RDD (SMALL POWER SHOWN ON NA 400 SERIES DRAWINGS)	MER		E	ME-ZE-04-PL-532-513	Fourth Floor Plan NSGH Haemato Oncology High Le-el Layout	16/03/12			03/05/12			-					
		Removed By Mercury - NOT REQUIRED FOR RDD (SMALL POWER SHOWN ON NA 400 SERIES DRAWINGS)	MER		E	ME-ZE-04-PL-532-514	Fourth Floor Plan NSGH Haemato Oncology High Level Layout	16/03/12			03/05/12			-					
		Removed By Mercury - NOT REQUIRED FOR RDD (SMALL POWER SHOWN ON NA 400 SERIES DRAWINGS)	MER		E	ME-ZE-05-PL-532-512	Fifth Floor Plan NSGH Inpatient Wards High Le-el Layout	16/03/12			03/05/12			-					
		Removed By Mercury - NOT REQUIRED FOR RDD (SMALL POWER SHOWN ON NA 400 SERIES DRAWINGS)	MER		E	ME-ZE-05-PL-532-513	Fifth Floor Plan NSGH Inpatient Wards High Le-el Layout	16/03/12			03/05/12			-					
		Removed By Mercury - NOT REQUIRED FOR RDD (SMALL POWER SHOWN ON NA 400 SERIES DRAWINGS)	MER		E	ME-ZE-05-PL-532-514	Fifth Floor Plan NSGH Inpatient Wards High Level Layout	16/03/12			03/05/12			-					
		Removed By Mercury - NOT REQUIRED FOR RDD (SMALL POWER SHOWN ON NA 400 SERIES DRAWINGS)	MER		E	ME-ZE-11-PL-532-514	Ele-enth Floor Plan NSGH Inpatient Wards High Le-el Layout	16/03/12			03/05/12			-					
		Removed By Mercury - NOT REQUIRED FOR RDD (SMALL POWER SHOWN ON NA 400 SERIES DRAWINGS)	MER		E	ME-ZE-00-PL-532-532	Ground Floor Plan NSGH - Radiology-ELV Systems low le-el Layout	23/01/12			20/02/12			-					
		Removed By Mercury - NOT REQUIRED FOR RDD (SMALL POWER SHOWN ON NA 400 SERIES DRAWINGS)	MER		E	ME-ZE-00-PL-532-533	Ground Floor Plan NSGH - Radiology-ELV Systems low le-el Layout	23/01/12			20/02/12			-					
		Removed By Mercury - NOT REQUIRED FOR RDD (SMALL POWER SHOWN ON NA 400 SERIES DRAWINGS)	MER		E	ME-ZE-00-PL-532-534	Ground Floor Plan NSGH - Medical Illustration ELV Systems low level Layout	23/01/12			20/02/12			-					
		Removed By Mercury - NOT REQUIRED FOR RDD (SMALL POWER SHOWN ON NA 400 SERIES DRAWINGS)	MER		E	ME-ZE-00-PL-532-535	Ground Floor Plan NCH - Radiology-ELV Systems low le-el Layout	23/01/12			20/02/12			-					
		Removed By Mercury - NOT REQUIRED FOR RDD (SMALL POWER SHOWN ON NA 400 SERIES DRAWINGS)	MER		E	ME-ZE-00-PL-532-536	Ground Floor Plan NCH - Radiology-ELV Systems low le-el Layout	23/01/12			20/02/12			-					
		Removed By Mercury - NOT REQUIRED FOR RDD (SMALL POWER SHOWN ON NA 400 SERIES DRAWINGS)	MER		E	ME-ZE-01-PL-532-508	First Floor Plan NCH - Theatres, Endoscopy & Recovery Lighting Layout	23/01/12			20/02/12			-					
		Removed By Mercury - NOT REQUIRED FOR RDD (SMALL POWER SHOWN ON NA 400 SERIES DRAWINGS)	MER		E	ME-ZE-01-PL-532-509	First Floor Plan NCH - Interventional Radiology-ELV Systems low level Layout	23/01/12			20/02/12			-					
		Removed By Mercury - NOT REQUIRED FOR RDD (SMALL POWER SHOWN ON NA 400 SERIES DRAWINGS)	MER		E	ME-ZE-01-PL-532-510	First Floor Plan NCH - Radiology, CT & MRI-ELV Systems low le-el Layout	23/01/12			20/02/12			-					
		Removed By Mercury - NOT REQUIRED FOR RDD (SMALL POWER SHOWN ON NA 400 SERIES DRAWINGS)	MER		E	ME-ZE-01-PL-532-536	First Floor Plan NCH - Nuclear Medicine ELV Systems low le-el Layout	23/01/12			20/02/12			-					
		Removed By Mercury - NOT REQUIRED FOR RDD (SMALL POWER SHOWN ON NA 400 SERIES DRAWINGS)	MER		E	ME-ZE-02-PL-532-517	Second Floor Plan NSGH/NCH- Medical Physics & Bio-Engineering ELV Systems low le-el Layout	23/01/12			20/02/12			-					
		Removed By Mercury - NOT REQUIRED FOR RDD (SMALL POWER SHOWN ON NA 400 SERIES DRAWINGS)	MER		E	ME-ZE-02-PL-532-518	Second Floor Plan NSGH Decontamination Suite ELV Systems low le-el Layout	23/01/12			20/02/12			-					
		Removed By Mercury - NOT REQUIRED FOR RDD (SMALL POWER SHOWN ON NA 400 SERIES DRAWINGS)	MER		E	ME-ZE-02-PL-532-519	Second Floor Plan NSGH Endoscopy ELV Systems low le-el Layout	23/01/12			20/02/12			-					
		Removed By Mercury - NOT REQUIRED FOR RDD (SMALL POWER SHOWN ON NA 400 SERIES DRAWINGS)	MER		E	ME-ZE-02-PL-532-523	Second Floor Plan NSGH Theatres ELV Systems low level Layout	23/01/12			20/02/12			-					
		Removed By Mercury - NOT REQUIRED FOR RDD (SMALL POWER SHOWN ON NA 400 SERIES DRAWINGS)	MER		E	ME-ZE-02-PL-532-534	Second Floor Plan NCH Transport Base ELV Systems low level Layout	23/01/12			20/02/12			-					
		Removed By Mercury - NOT REQUIRED FOR RDD (SMALL POWER SHOWN ON NA 400 SERIES DRAWINGS)	MER		E	ME-ZE-03-PL-532-504	Third Floor Plan NSGH/NCH Staff Change/Hotel Services/ Staff Accommodation ELV Systems low le-el Layout				20/02/12			-					
		Removed By Mercury - NOT REQUIRED FOR RDD (SMALL POWER SHOWN ON NA 400 SERIES DRAWINGS)	MER		E	ME-ZE-04-PL-532-512	Fourth Floor Plan NSGH Renal Patients & Day Unit ELV Systems low level Layout	16/03/12			03/05/12			-					
		Removed By Mercury - NOT REQUIRED FOR RDD (SMALL POWER SHOWN ON NA 400 SERIES DRAWINGS)	MER		E	ME-ZE-04-PL-532-513	Fourth Floor Plan NSGH Haemato Oncology ELV Systems low level Layout	16/03/12			03/05/12			-					
		Removed By Mercury - NOT REQUIRED FOR RDD (SMALL POWER SHOWN ON NA 400 SERIES DRAWINGS)	MER		E	ME-ZE-04-PL-532-514	Fourth Floor Plan NSGH Haemato Oncology ELV Systems low level Layout	16/03/12			03/05/12			-					
		Removed By Mercury - NOT REQUIRED FOR RDD (SMALL POWER SHOWN ON NA 400 SERIES DRAWINGS)	MER		E	ME-ZE-05-PL-532-512	Fifth Floor Plan NSGH Inpatient Wards ELV Systems low le-el Layout	16/03/12			03/05/12			-					
		Removed By Mercury - NOT REQUIRED FOR RDD (SMALL POWER SHOWN ON NA 400 SERIES DRAWINGS)	MER		E	ME-ZE-05-PL-532-513	Fifth Floor Plan NSGH Inpatient Wards ELV Systems low le-el Layout	16/03/12			03/05/12			-					
		Removed By Mercury - NOT REQUIRED FOR RDD (SMALL POWER SHOWN ON NA 400 SERIES DRAWINGS)	MER		E	ME-ZE-05-PL-532-514	Fifth Floor Plan NSGH Inpatient Wards ELV Systems low level Layout	16/03/12			03/05/12			-					
		Removed By Mercury - NOT REQUIRED FOR RDD (SMALL POWER SHOWN ON NA 400 SERIES DRAWINGS)	MER		E	ME-ZE-11-PL-532-514	Ele-enth Floor Plan NSGH Inpatient Wards ELV Systems low le-el Layout	16/03/12			03/05/12			-					
	Data Comms		MER		E	ME-SZ-B1-PL-556-502	Basement Floor Plan NSGH - Basement FM Core C Data Comms Layout	23/01/12		A	24/02/12	06/06/12	BMCE-TRANSMIT-009245 /BMCE-WTRAN-003217	27/06/12	06/07/12	A	18/07/12 BMCE-TRANSMIT-		

Drawing Information

31 BCL-AC-XX-SH-001

1st Submission2nd Submission

			Action By	Zone	Drawing Number	Drawing Title	Date Required from Consultant	Date Submitted by Consultant	Document Revision	Planned Date to be Submitted to Board	Date Submitted to Board	BMCE Transmittal No	Date Response Required from Board	Date Returned from Board	Board Status	Date returned to Consultant	Date Required from Consultant	Date Submitted by Consultant
Item	Submission	Comments																
		This was issued for information on BMCE-TRANSMIT-018891 18/12/13	MER	E	ME-ZE-01-PL-556-508	First Floor Plan NCH - Theatres, Endoscopy & Recovery Data Comms Layout	23/01/12		A	24/02/12	24/02/12	BMCE-TRANSMIT-007796 (BMCE-WTRAN-002628)	16/03/12	28/03/12	B	28/03/12 BMCE-TRANSMIT-008177		
		This was issued for information on BMCE-TRANSMIT-018891 18/12/13	MER	E	ME-ZE-01-PL-556-509	First Floor Plan NCH - Interventional Radiology Data Comms Layout	23/01/12		A	24/02/12	24/02/12	BMCE-TRANSMIT-007796 (BMCE-WTRAN-002628)	16/03/12	28/03/12	B	28/03/12 BMCE-TRANSMIT-008177		
		This was issued for information on BMCE-TRANSMIT-018592 28/11/13	MER	E	ME-ZE-01-PL-556-510	First Floor Plan NCH - Radiology, CT & MRI Data Comms Layout	23/01/12		A	24/02/12	24/02/12	BMCE-TRANSMIT-007796 (BMCE-WTRAN-002628)	16/03/12	28/03/12	B	28/03/12 BMCE-TRANSMIT-008177		
		This drawing was issued for review on BMCE-TRANSMIT-018616 Please refer to the drawing in Zone H	MER	E	ME-SZ-01-PL-556-533	First Floor Plan NSGH - Radiology Data Comms Layout	23/01/12		C	24/02/12	24/02/12	BMCE-TRANSMIT-007796 (BMCE-WTRAN-002628)	16/03/12	28/03/12	B	28/03/12 BMCE-TRANSMIT-008177		
		This drawing was issued for review on BMCE-TRANSMIT-018616 Please refer to the drawing in Zone H	MER	E	ME-SZ-01-PL-556-534	First Floor Plan NSGH - Radiology Data Comms Layout	23/01/12		C	24/02/12	24/02/12	BMCE-TRANSMIT-007796 (BMCE-WTRAN-002628)	16/03/12	28/03/12	B	28/03/12 BMCE-TRANSMIT-008177		
		This drawing was issued to the board for information Only on BMCE-TRANSMIT-018592	MER	E	ME-SZ-01-PL-556-535	First Floor Plan NCH - Radiology Data Comms Layout	23/01/12		A	24/02/12	24/02/12	BMCE-TRANSMIT-007796 (BMCE-WTRAN-002628)	16/03/12	28/03/12	B	28/03/12 BMCE-TRANSMIT-008177		
		This was issued for information on BMCE-TRANSMIT-018592 28/11/13	MER	E	ME-ZE-01-PL-556-536	First Floor Plan NCH - Nuclear Medicine Data Comms Layout	23/01/12		A	24/02/12	24/02/12	BMCE-TRANSMIT-007796 (BMCE-WTRAN-002628)	16/03/12	28/03/12	B	28/03/12 BMCE-TRANSMIT-008177		
			MER	E	ME-ZE-02-PL-556-517	Second Floor Plan NSGH/NCH Medical Physics & Bio-Engineering Data Comms Layout	23/01/12		A	24/02/12	24/02/12	BMCE-TRANSMIT-007796 (BMCE-WTRAN-002628)	16/03/12	28/03/12	A	28/03/12 BMCE-TRANSMIT-008177		
		This was issued for information on BMCE-TRANSMIT-018592 28/11/13	MER	E	ME-ZE-02-PL-556-518	Second Floor Plan NSGH Decontamination Suite Data CommsLayout	23/01/12		A	24/02/12	24/02/12	BMCE-TRANSMIT-007796 (BMCE-WTRAN-002628)	16/03/12	28/03/12	B	28/03/12 BMCE-TRANSMIT-008177		
		This was issued for information on BMCE-TRANSMIT-018592 28/11/13	MER	E	ME-ZE-02-PL-556-519	Second Floor Plan NSGH Endoscopy Data Comms Layout	23/01/12		A	24/02/12	24/02/12	BMCE-TRANSMIT-007796 (BMCE-WTRAN-002628)	16/03/12	28/03/12	B	28/03/12 BMCE-TRANSMIT-008177		
		This was issued for information on BMCE-TRANSMIT-018592 28/11/13	MER	E	ME-ZE-02-PL-556-523	Second Floor Plan NSGH Theatres Data Comms Layout	23/01/12		A	24/02/12	24/02/12	BMCE-TRANSMIT-007796 (BMCE-WTRAN-002628)	16/03/12	28/03/12	B	28/03/12 BMCE-TRANSMIT-008177		
			MER	E	ME-ZE-02-PL-556-523	Second Floor Plan NCH Transport Base Data Comms Layout	23/01/12		A	24/02/12	24/02/12	BMCE-TRANSMIT-007796 (BMCE-WTRAN-002628)	16/03/12	28/03/12	A	28/03/12 BMCE-TRANSMIT-008177		
			MER	E	ME-ZE-03-PL-556-504	Third Floor Plan NSGH/NCH Staff Change/Hotel Services/ Staff Accomodation Data Comms Layout			B	24/02/12	24/03/14	BMCE-TRANSMIT-019750 (BMCE-WTRAN-010133)	14/04/14	22/04/14	A			
			MER	E	ME-ZK-03-PL-556-503	Third Floor Plan NSGH/NCH Staff Change/Hotel Services/ Staff Accomodation Data Comms Layout			C	24/02/12	01/03/13	BMCE-TRANSMIT-014279 (BMCE-WTRAN-006293)	22/03/13	12/04/13	A			
			MER	E	ME-ZE-04-PL-556-512	Fourth Floor Plan NSGH Renal Patients & Day Unit Data Comms Layout	16/03/12		A	31/05/12	09/05/12	BMCE-TRANSMIT-008742 (BMCE-WTRAN-003012)	30/05/12	12/07/12	A	18/07/12 BMCE-TRANSMIT-009887		
			MER	E	ME-ZE-04-PL-556-513	Fourth Floor Plan NSGH Haemato-Oncology Data Comms Layout	16/03/12		A	03/05/12	09/05/12	BMCE-TRANSMIT-008742 (BMCE-WTRAN-003012)	30/05/12	12/07/12	A	18/07/12 BMCE-TRANSMIT-009887		
		This was issued for information on BMCE-TRANSMIT-018592 28/11/13	MER	E	ME-ZE-04-PL-556-514	Fourth Floor Plan NSGH Haemato-Oncology Data Comms Layout	16/03/12		A	03/05/12	09/05/12	BMCE-TRANSMIT-008742 (BMCE-WTRAN-003012)	30/05/12	12/07/12	B	18/07/12 BMCE-TRANSMIT-009887		
			MER	E	ME-ZE-05-PL-556-512	Fifth Floor Plan NSGH Inpatient Wards Data Comms Layout	16/03/12		A	03/05/12	09/05/12	BMCE-TRANSMIT-008742 (BMCE-WTRAN-003012)	30/05/12	12/07/12	A	18/07/12 BMCE-TRANSMIT-009887		
			MER	E	ME-ZE-05-PL-556-513	Fifth Floor Plan NSGH Inpatient Wards Data Comms Layout	16/03/12		A	03/05/12	09/05/12	BMCE-TRANSMIT-008742 (BMCE-WTRAN-003012)	30/05/12	12/07/12	A	18/07/12 BMCE-TRANSMIT-009887		
			MER	E	ME-ZE-05-PL-556-514	Fifth Floor Plan NSGH Inpatient Wards Data Comms Layout	16/03/12		A	03/05/12	09/05/12	BMCE-TRANSMIT-008742 (BMCE-WTRAN-003012)	30/05/12	12/07/12	A	18/07/12 BMCE-TRANSMIT-009887		
	BMS	Removed By Mercury - NOT REQUIRED FOR RDD (PART OF BMS DETAIL DESIGN)	MER	E	ME-ZE-00-PL-660-532	Ground Floor Plan NSGH - Radiology BMS Layout	23/01/12			20/02/12			-					
		Removed By Mercury - NOT REQUIRED FOR RDD (PART OF BMS DETAIL DESIGN)	MER	E	ME-ZE-00-PL-660-533	Ground Floor Plan NSGH - Radiology BMS Layout	23/01/12			20/02/12			-					
		Removed By Mercury - NOT REQUIRED FOR RDD (PART OF BMS DETAIL DESIGN)	MER	E	ME-ZE-00-PL-660-534	Ground Floor Plan NSGH - Medical Illustration BMS Layout	23/01/12			20/02/12			-					
		Removed By Mercury - NOT REQUIRED FOR RDD (PART OF BMS DETAIL DESIGN)	MER	E	ME-ZE-00-PL-660-535	Ground Floor Plan NCH - Radiology BMS Layout	23/01/12			20/02/12			-					
		Removed By Mercury - NOT REQUIRED FOR RDD (PART OF BMS DETAIL DESIGN)	MER	E	ME-ZE-00-PL-660-536	Ground Floor Plan NCH - Radiology BMS Layout	23/01/12			20/02/12			-					
		Removed By Mercury - NOT REQUIRED FOR RDD (PART OF BMS DETAIL DESIGN)	MER	E	ME-ZE-01-PL-660-508	First Floor Plan NCH - Theatres, Endoscopy & Recovery BMS Layout	23/01/12			20/02/12			-					
		Removed By Mercury - NOT REQUIRED FOR RDD (PART OF BMS DETAIL DESIGN)	MER	E	ME-ZE-01-PL-660-509	First Floor Plan NCH - Interventional Radiology BMS Layout	23/01/12			20/02/12			-					
		Removed By Mercury - NOT REQUIRED FOR RDD (PART OF BMS DETAIL DESIGN)	MER	E	ME-ZE-01-PL-660-510	First Floor Plan NCH - Radiology, CT & MRI BMS Layout	23/01/12			20/02/12			-					
		Removed By Mercury - NOT REQUIRED FOR RDD (PART OF BMS DETAIL DESIGN)	MER	E	ME-ZE-01-PL-660-536	First Floor Plan NCH - Nuclear Medicine BMS Layout	23/01/12			20/02/12			-					
		Removed By Mercury - NOT REQUIRED FOR RDD (PART OF BMS DETAIL DESIGN)	MER	E	ME-ZE-02-PL-660-517	Second Floor Plan NSGH/NCH Medical Physics & Bio-Engineering BMS Layout	23/01/12			20/02/12			-					

Drawing Information

31 BCL-AC-XX-SH-001

1st Submission2nd Submission

Item	Submission	Comments	Action By		Zone	Drawing Number	Drawing Title	Date Required from Consultant	Date Submitted by Consultant	Document Revision	Planned Date to be Submitted to Board	Date Submitted to Board	BMCE Transmittal No	Date Response Required from Board	Date Returned from Board	Board Status	Date returned to Consultant	Date Required from Consultant	Date Submitted by Consultant
		Not required for RDD review was Issued to the board for information only BMCE-TRANSMIT-017701	MER		E	ME-ZE-00-DC-H512-002	Le-el-0, Radiology from RAG-109 to mains												
		Not required for RDD review was Issued to the board for information only BMCE-TRANSMIT-017701	MER		E	ME-ZE-01-DC-H512-001	Le-el-1, Childrens Radiology From RCI-013 to Riser M38												
		Not required for RDD review was Issued to the board for information only BMCE-TRANSMIT-017701	MER		E	ME-ZE-01-DC-H512-002	Level 1, Nuclear Medicine from RNM-032 & Mains												
		Not required for RDD review was Issued to the board for information only BMCE-TRANSMIT-017701	MER		E	ME-ZE-02-DC-H512-001	Le-el-2, Endoscopy from END-035 to mains												
		Not required for RDD review was Issued to the board for information only BMCE-TRANSMIT-017701	MER		E	ME-ZE-02-DC-H512-002	Le-el-2, Medical Physies from Room-MP-010 to Mains												
		Not required for RDD review was Issued to the board for information only BMCE-TRANSMIT-017701	MER		E	ME-ZE-04-DC-H512-001	Level 4, Renal Haematology from HOW-031 to Mains												
		Not required for RDD review was Issued to the board for information only BMCE-TRANSMIT-017701	MER		E	ME-ZE-05-DC-H512-001	Le-el-5, Room GENWD-033 to Riser T5												
		Not required for RDD review was Issued to the board for information only BMCE-TRANSMIT-017701	MER		E	ME-ZE-11-DC-H512-001	Le-el-11, Room GENW4-032 to Riser T5												
		Issued for information on BMCE-TRANSMIT-019817 31/03/14	MER		E	ME-ZE-00-PL-H512-001	Medical Gas Installation, Level 0, Zone E			1		29/05/12	BMCE-TRANSMIT-009131 (BMCE-WTRAN-003175)	19/06/12	24/09/12	C	27/09/12 BMCE-TRANSMIT-011199		
			MER		E	ME-ZE-00-PL-H512-002	Medical Gas Installation, Level 0, Zone E - AGSS			1		29/05/12	BMCE-TRANSMIT-009131 (BMCE-WTRAN-003175)	19/06/12	24/09/12	C	27/09/12 BMCE-TRANSMIT-011199		
		Issued for information on BMCE-TRANSMIT-019817 31/03/14	MER		E	ME-ZE-01-PL-H512-001	Medical Gas Installation, Level 1, Zone E			1		29/05/12	BMCE-TRANSMIT-009127 (BMCE-WTRAN-003174)	19/06/12	24/09/12	C	27/09/12 BMCE-TRANSMIT-011196		
			MER		E	ME-ZE-01-PL-H512-002	Medical Gas Installation, Level 1, Zone E - AGSS			1		29/05/12	BMCE-TRANSMIT-009127 (BMCE-WTRAN-003174)	19/06/12	24/09/12	C	27/09/12 BMCE-TRANSMIT-011196		
		Issued for information on BMCE-TRANSMIT-019817 31/03/14	MER		E	ME-ZE-02-PL-H512-001	Medical Gas Installation, Level 2, Zone E			1		29/05/12	BMCE-TRANSMIT-009123 (BMCE-WTRAN-003172)	19/06/12	24/09/12	C	27/09/12 BMCE-TRANSMIT-011202		
			MER		E	ME-ZE-02-PL-H512-002	Medical Gas Installation, Level 2, Zone E - AGSS			1		29/05/12	BMCE-TRANSMIT-009123 (BMCE-WTRAN-003172)	19/06/12	24/09/12	C	27/09/12 BMCE-TRANSMIT-011202		
			MER		E	ME-ZE-03-PL-H512-001	Medical Gas Installation, Level 3, Zone E			1		29/05/12	BMCE-TRANSMIT-009125 (BMCE-WTRAN-003173)	19/06/12	01/10/12	C	04/10/12 BMCE-TRANSMIT-011325		
			MER		E	ME-ZE-03-PL-H512-002	Medical Gas Installation, Level 3, Zone E - AGSS			1		29/05/12	BMCE-TRANSMIT-009125 (BMCE-WTRAN-003173)	19/06/12	01/10/12	C	04/10/12 BMCE-TRANSMIT-011325		
		Issued for information on BMCE-TRANSMIT-019817 31/03/14	MER		E	ME-ZE-04-PL-H512-001	Medical Gas Installation, Level 4, Zone E			1		29/05/12	BMCE-TRANSMIT-009122 (BMCE-WTRAN-003171)	19/06/12	01/10/12	C	04/10/12 BMCE-TRANSMIT-011324		
			MER		E	ME-ZE-05-PL-H512-001	Medical Gas Installation, Level 5, Zone E			1		29/05/12	BMCE-TRANSMIT-009111 (BMCE-WTRAN-003165)	19/06/12	01/10/12	C	04/10/2012 BMCE-TRANSMIT-011322		
			MER		E	ME-ZE-06-PL-H512-001	Medical Gas Installation, Level 6, Zone E			1		29/05/12	BMCE-TRANSMIT-009119 (BMCE-TRANSMIT-003169)	19/06/12	01/10/12	C	04/10/12 BMCE-TRANSMIT-011331		
			MER		E	ME-ZE-07-PL-H512-001	Medical Gas Installation, Level 7, Zone E			1		29/05/12	BMCE-TRANSMIT-009109 (BMCE-WTRAN-003163)	19/06/12	01/10/12	C	04/10/12 BMCE-TRANSMIT-011329		
			MER		E	ME-ZE-08-PL-H512-001	Medical Gas Installation, Level 8, Zone E			1		29/05/12	BMCE-TRANSMIT-009115 (BMCE-WTRAN-003166)	19/06/12	01/10/12	C	04/10/12 BMCE-TRANSMIT-011322		
			MER		E	ME-ZE-09-PL-H512-001	Medical Gas Installation, Level 9, Zone E			1		29/05/12	BMCE-TRANSMIT-009117 (BMCE-WTRAN-003167)	19/06/12	01/10/12	C	04/10/12 BMCE-TRANSMIT-011326		
			MER		E	ME-ZE-10-PL-H512-001	Medical Gas Installation, Level 10, Zone E			1		29/05/12	BMCE-TRANSMIT-009120 (BMCE-WTRAN-003170)	19/06/12	01/10/12	C	04/10/12 BMCE-TRANSMIT-011323		
			MER		E	ME-ZE-11-PL-H512-001	Medical Gas Installation, Level 11, Zone E			1		29/05/12	BMCE-TRANSMIT-009118 (BMCE-WTRAN-003168)	19/06/12	01/10/12	C	04/10/12 BMCE-TRANSMIT-011327		
		Removed By Mercury - NOT REQUIRED FOR RDD (REFER TO HPI H512 SERIES DESIGN DRAWINGS)	MER		E	ME-ZE-00-PL-512-532	Ground Floor Plan NSGH - Radiology Medical Gases Layout	23/01/12			20/02/12			-					
		Removed By Mercury - NOT REQUIRED FOR RDD (REFER TO HPI H512 SERIES DESIGN DRAWINGS)	MER		E	ME-ZE-00-PL-512-533	Ground Floor Plan NSGH - Radiology Medical Gases Layout	23/01/12			20/02/12			-					
		Removed By Mercury - NOT REQUIRED FOR RDD (REFER TO HPI H512 SERIES DESIGN DRAWINGS)	MER		E	ME-ZE-00-PL-512-534	Ground Floor Plan NSGH - Medical Illustration Medical Gases Layout	23/01/12			20/02/12			-					
		Removed By Mercury - NOT REQUIRED FOR RDD (REFER TO HPI H512 SERIES DESIGN DRAWINGS)	MER		E	ME-ZE-00-PL-512-535	Ground Floor Plan NCH - Radiology Medical Gases Layout	23/01/12			20/02/12			-					
		Removed By Mercury - NOT REQUIRED FOR RDD (REFER TO HPI H512 SERIES DESIGN DRAWINGS)	MER		E	ME-ZE-00-PL-512-536	Ground Floor Plan NCH - Radiology Medical Gases Layout	23/01/12			20/02/12			-					
		Removed By Mercury - NOT REQUIRED FOR RDD (REFER TO HPI H512 SERIES DESIGN DRAWINGS)	MER		E	ME-ZE-01-PL-512-508	First Floor Plan NCH - Theatres, Endoscopy & Recovery Medical Gases Layout	23/01/12			20/02/12			-					

Drawing Information

31 BCL-AC-XX-SH-001

			Action By		Zone	Drawing Number	Drawing Title	Date Required from Consultant	Date Submitted by Consultant	Document Revision	Planned Date to be Submitted to Board	Date Submitted to Board	BMCE Transmittal No	Date Response Required from Board	Date Returned from Board	Board Status	Date returned to Consultant	Date Required from Consultant	Date Submitted by Consultant
Item	Submission	Comments																	
		Removed By Mercury - NOT REQUIRED FOR RDD (REFER TO HPI H512 SERIES DESIGN DRAWINGS)	MER	E	ME-ZE-06-PL-512-514	Fifth Floor Plan-NSGH Inpatient Wards Medical Gases Layout					20/02/12			-					
		Removed By Mercury - NOT REQUIRED FOR RDD (REFER TO HPI H512 SERIES DESIGN DRAWINGS)	MER	E	ME-ZE-11-PL-512-514	Fifth Floor Plan-NSGH Inpatient Wards Medical Gases Layout					20/02/12			-					
			MER	E	ME-ZE-XX-PL-556-512	Fifth to Eleventh Floor Plan NSGH Inpatient Wards Data Comms Layout	16/03/12			A	03/05/12	09/05/12	BMCE-TRANSMIT-008742 (BMCE-WTRAN-003012)	30/05/12	12/07/12	A	18/07/12 BMCE-TRANSMIT-009887		
			MER	E	ME-ZE-XX-PL-556-513	Fifth to Eleventh Floor Plan NSGH Inpatient Wards Data Comms Layout	16/03/12			A	03/05/12	09/05/12	BMCE-TRANSMIT-008742 (BMCE-WTRAN-003012)	30/05/12	12/07/12	A	18/07/12 BMCE-TRANSMIT-009887		
			MER	E	ME-ZE-XX-PL-556-514	Fifth to Eleventh Floor Plan NSGH Inpatient Wards Data Comms Layout	16/03/12			A	03/05/12	09/05/12	BMCE-TRANSMIT-008742 (BMCE-WTRAN-003012)	30/05/12	12/07/12	A	18/07/12 BMCE-TRANSMIT-009887		
		REMOVED BY MERCURY - SUPERSEDED BY ME-ZE-XX-PL-556-514	MER	E	ME-ZE-11-PL-556-514	Eleventh Floor Plan-NSGH Inpatient Wards Data Comms Layout	16/03/12				03/05/12			-					
	Fire Detection & Smoke Control	This was issued for information on BMCE-TRANSMIT-018592 26/11/13	MER	E	ME-ZF-B1-PL-572-504	Basement Floor Plan- NSGH Catering - Fire Detection & Smoke Control Layout	23/01/12			A	24/02/12	07/06/12	BMCE-TRANSMIT-009266 (BMCE-WTRAN-003230)	28/06/12	10/07/12	B	17/07/12 BMCE-TRANSMIT-009876		
		This was issued for information on BMCE-TRANSMIT-018592 26/11/13	MER	E	ME-SZ-B1-PL-572-505	Basement Floor Plan- NSGH Basement- Catering - Fire Detection & Smoke Control Layout	23/01/12			A	24/02/12	07/06/12	BMCE-TRANSMIT-009266 (BMCE-WTRAN-003230)	28/06/12	10/07/12	B	17/07/12 BMCE-TRANSMIT-009876		
		This was issued for information on BMCE-TRANSMIT-018592 26/11/13	MER	E	ME-SZ-B1-PL-572-506	Basement Floor Plan- NSGH Basement- Tunnel FM Stores & FM Core G - Fire Detection & Smoke Control Layout	23/01/12			A	24/02/12	07/06/12	BMCE-TRANSMIT-009266 (BMCE-WTRAN-003230)	28/06/12	10/07/12	B	17/07/12 BMCE-TRANSMIT-009876		
		This was issued for information on BMCE-TRANSMIT-018592 26/11/13	MER	E	ME-SZ-B1-PL-572-510	Basement Floor Plan- NSGH Basement- Tunnel & FM Core F - Fire Detection & Smoke Control Layout	23/01/12			A	24/02/12	07/06/12	BMCE-TRANSMIT-009266 (BMCE-WTRAN-003230)	28/06/12	10/07/12	B	17/07/12 BMCE-TRANSMIT-009876		
		This drawing was issued to the board for information Only on BMCE-TRANSMIT-018592	MER	E	ME-SZ-00-PL-572-531	Ground Floor Plan NCH - Radiology Fire Detection & Smoke Control Layout	23/01/12			A	24/02/12	24/02/12	BMCE-TRANSMIT-007791 (BMCE-WTRAN-002623)	16/03/12	20/03/12	B	27/03/12 BMCE-TRANSMIT-008147		
		This was issued for information on BMCE-TRANSMIT-018592 26/11/13	MER	E	ME-ZE-00-PL-572-532	Ground Floor Plan NSGH - Radiology Fire Detection & Smoke Control Layout	23/01/12			A	24/02/12	24/02/12	BMCE-TRANSMIT-007791 (BMCE-WTRAN-002623)	16/03/12	20/03/12	B	27/03/12 BMCE-TRANSMIT-008147		
		This was issued for information on BMCE-TRANSMIT-018592 26/11/13	MER	E	ME-ZE-00-PL-572-533	Ground Floor Plan NSGH - Radiology Fire Detection & Smoke Control Layout	23/01/12			A	24/02/12	24/02/12	BMCE-TRANSMIT-007791 (BMCE-WTRAN-002623)	16/03/12	20/03/12	B	27/03/12 BMCE-TRANSMIT-008147		
		This was issued for information on BMCE-TRANSMIT-018592 26/11/13	MER	E	ME-ZE-00-PL-572-534	Ground Floor Plan NSGH - Medical Illustration Fire Detection & Smoke Control Layout	23/01/12			A	24/02/12	24/02/12	BMCE-TRANSMIT-007791 (BMCE-WTRAN-002623)	16/03/12	20/03/12	B	27/03/12 BMCE-TRANSMIT-008147		
		This was issued for information on BMCE-TRANSMIT-018592 26/11/13	MER	E	ME-ZE-00-PL-572-535	Ground Floor Plan NCH - Radiology Fire Detection & Smoke Control Layout	23/01/12			A	24/02/12	24/02/12	BMCE-TRANSMIT-007791 (BMCE-WTRAN-002623)	16/03/12	20/03/12	B	27/03/12 BMCE-TRANSMIT-008147		
		This was issued for information on BMCE-TRANSMIT-018592 26/11/13	MER	E	ME-ZE-00-PL-572-536	Ground Floor Plan NCH - Radiology Fire Detection & Smoke Control Layout	23/01/12			A	24/02/12	24/02/12	BMCE-TRANSMIT-007791 (BMCE-WTRAN-002623)	16/03/12	20/03/12	B	27/03/12 BMCE-TRANSMIT-008147		
		This drawing was issue to the board for information only on BME-TRANSMIT-018592 26/11/13	MER	E	ME-SZ-01-PL-572-506	First Floor Plan NCH - Theatres, Endoscopy & Recovery Fire Detection & Smoke Control Layout	23/01/12			A	24/02/12	24/02/12	BMCE-TRANSMIT-007791 (BMCE-WTRAN-002623)	16/03/12	20/03/12	B	27/03/12 BMCE-TRANSMIT-008147		
			MER	E	ME-ZF-01-PL-572-507	First Floor Plan NCH - Theatres, Endoscopy & Recovery Fire Detection & Smoke Control Layout	23/01/12			A	24/02/12	24/02/12	BMCE-TRANSMIT-007791 (BMCE-WTRAN-002623)	16/03/12	20/03/12	C	27/03/12 BMCE-TRANSMIT-008147		
		REMOVED BY MERCURY - DRAWING DOES NOT EXIST	MER	E	ME-SZ-01-PL-572-507	First Floor Plan NCH - Theatres, Endoscopy & Recovery Fire Detection & Smoke Control Layout	23/01/12				24/02/12			21/01/09					
		This was issued for information on BMCE-TRANSMIT-018592 26/11/13	MER	E	ME-ZE-01-PL-572-508	First Floor Plan NCH - Theatres, Endoscopy & Recovery Fire Detection & Smoke Control Layout	23/01/12				24/02/12		BMCE-TRANSMIT-007791 (BMCE-WTRAN-002623)	21/01/00	20/03/12	B	27/03/12 BMCE-TRANSMIT-008147		
		This was issued for information on BMCE-TRANSMIT-018592 26/11/13	MER	E	ME-ZE-01-PL-572-509	First Floor Plan NCH - Interventional Radiology Fire Detection & Smoke Control Layout	23/01/12			A	24/02/12	24/02/12	BMCE-TRANSMIT-007791 (BMCE-WTRAN-002623)	16/03/12	20/03/12	B	27/03/12 BMCE-TRANSMIT-008147		
		This was issued for information on BMCE-TRANSMIT-018592 26/11/13	MER	E	ME-ZE-01-PL-572-510	First Floor Plan NCH - Radiology, CT & MRI Fire Detection & Smoke Control Layout	23/01/12			A	24/02/12	24/02/12	BMCE-TRANSMIT-007791 (BMCE-WTRAN-002623)	16/03/12	20/03/12	B	27/03/12 BMCE-TRANSMIT-008147		
		This was issued for information on BMCE-TRANSMIT-018592 26/11/13	MER	E	ME-SZ-01-PL-572-533	First Floor Plan NSGH - Radiology Fire Detection & Smoke Control Layout	23/01/12			C	24/02/12	24/02/12	BMCE-TRANSMIT-007791 (BMCE-WTRAN-002623)	16/03/12	20/03/12	B	27/03/12 BMCE-TRANSMIT-008147		
		This was issued for information on BMCE-TRANSMIT-018592 26/11/13	MER	E	ME-SZ-01-PL-572-533	First Floor Plan NSGH - Radiology Fire Detection & Smoke Control Layout	23/01/12			C	24/02/12	24/02/12	BMCE-TRANSMIT-007791 (BMCE-WTRAN-002623)	16/03/12	20/03/12	B	27/03/12 BMCE-TRANSMIT-008147		
			MER	E	ME-SZ-01-PL-572-535	First Floor Plan NSGH - Radiology Fire Detection & Smoke Control Layout	23/01/12			A	24/02/12	24/02/12	BMCE-TRANSMIT-007791 (BMCE-WTRAN-002623)	16/03/12	20/03/12	A	27/03/12 BMCE-TRANSMIT-008147		
		This was issued for information on BMCE-TRANSMIT-018592 26/11/13	MER	E	ME-ZE-01-PL-572-536	First Floor Plan NCH - Nuclear Medicine Fire Detection & Smoke Control Layout	23/01/12			A	24/02/12	24/02/12	BMCE-TRANSMIT-007791 (BMCE-WTRAN-002623)	16/03/12	20/03/12	B	27/03/12 BMCE-TRANSMIT-008147		
		This was issued for information on BMCE-TRANSMIT-018592 26/11/13	MER	E	ME-ZE-02-PL-572-517	Second Floor Plan NSGH/NCH Medical Physics & & Bio-Engineering Fire Detection & Smoke Control Layout	23/01/12			A	24/02/12	24/02/12	BMCE-TRANSMIT-007791 (BMCE-WTRAN-002623)	16/03/12	20/03/12	B	27/03/12 BMCE-TRANSMIT-008147		
		This was issued for information on BMCE-TRANSMIT-018592 26/11/13	MER	E	ME-ZE-02-PL-572-518	Second Floor Plan NSGH Decontamination Suite Fire Detection & Smoke Control Layout	23/01/12			A	24/02/12	24/02/12	BMCE-TRANSMIT-007791 (BMCE-WTRAN-002623)	16/03/12	20/03/12	B	27/03/12 BMCE-TRANSMIT-008147		
		This was issued for information on BMCE-TRANSMIT-018592 26/11/13	MER	E	ME-ZE-02-PL-572-519	Second Floor Plan NSGH Endoscopy Fire Detection & Smoke Control Layout	23/01/12			A	24/02/12	24/02/12	BMCE-TRANSMIT-007791 (BMCE-WTRAN-002623)	16/03/12	20/03/12	B	27/03/12 BMCE-TRANSMIT-008147		
		This was issued for information on BMCE-TRANSMIT-018592 26/11/13	MER	E	ME-ZE-02-PL-572-523	Second Floor Plan NSGH Theatres Fire Detection & Smoke Control Layout	23/01/12			A	24/02/12	24/02/12	BMCE-TRANSMIT-007791 (BMCE-WTRAN-002623)	16/03/12	20/03/12	B	27/03/12 BMCE-TRANSMIT-008147		

Drawing Information

31 BCL-AC-XX-SH-001

1st Submission2nd Submission

			Action By	Zone	Drawing Number	Drawing Title	Date Required from Consultant	Date Submitted by Consultant	Document Revision	Planned Date to be Submitted to Board	Date Submitted to Board	BMCE Transmittal No	Date Response Required from Board	Date Returned from Board	Board Status	Date returned to Consultant	Date Required from Consultant	Date Submitted by Consultant
Item	Submission	Comments																
		This was issued for information on BMCE-TRANSMIT-018592 26/11/13	MER	E	ME-ZE-05-PL-572-512	Fifth Floor Plan NSGH Inpatient Wards Fire Detection & Smoke Control Layout	16/03/12		A	03/05/12	09/05/12	BMCE-TRANSMIT-008745 (BMCE-WTRAN-003013)	30/05/12	06/06/2012	B	18/06/12 BMCE-TRANSMIT-009386		
		This was issued for information on BMCE-TRANSMIT-018592 26/11/13	MER	E	ME-ZE-05-PL-572-513	Fifth Floor Plan NSGH Inpatient Wards Fire Detection & Smoke Control Layout	16/03/12		A	03/05/12	09/05/12	BMCE-TRANSMIT-008745 (BMCE-WTRAN-003013)	30/05/12	06/06/2012	B	18/06/12 BMCE-TRANSMIT-009386		
			MER	E	ME-ZE-05-PL-572-514	Fifth Floor Plan NSGH Inpatient Wards Fire Detection & Smoke Control Layout	16/03/12		A	03/05/12	09/05/12	BMCE-TRANSMIT-008745 (BMCE-WTRAN-003013)	30/05/12	06/06/2012	A	18/06/12 BMCE-TRANSMIT-009386		
		REMOVED BY MERCURY - ME-ZE-XX-PL-572-514 SUBMITTED FOR RDD REVIEW	MER	E	ME-ZE-11-PL-572-514	Eleventh Floor Plan NSGH Inpatient Wards Fire Detection & Smoke Control Layout	16/03/12			09/05/12								
		This was issued for information on BMCE-TRANSMIT-018592 26/11/13	MER	E	ME-ZE-XX-PL-572-512	Sixth to Eleventh Floor Plan NSGH Inpatient Wards Fire Detection & Smoke Control Layout	16/03/12		A	03/05/12	09/05/12	BMCE-TRANSMIT-008745 (BMCE-WTRAN-003013)	30/05/12	06/06/2012	B	18/06/12 BMCE-TRANSMIT-009386		
		This was issued for information on BMCE-TRANSMIT-018592 26/11/13	MER	E	ME-ZE-XX-PL-572-513	Sixth to Eleventh Floor Plan NSGH Inpatient Wards Fire Detection & Smoke Control Layout	16/03/12		A	03/05/12	09/05/12	BMCE-TRANSMIT-008745 (BMCE-WTRAN-003013)	30/05/12	06/06/2012	B	18/06/12 BMCE-TRANSMIT-009386		
		This was issued for information on BMCE-TRANSMIT-018592 26/11/13	MER	E	ME-ZE-XX-PL-572-514	Sixth to Eleventh Floor Plan NSGH Inpatient Wards Fire Detection & Smoke Control Layout	16/03/12		A	03/05/12	09/05/12	BMCE-TRANSMIT-008745 (BMCE-WTRAN-003013)	30/05/12	06/06/2012	B	18/06/12 BMCE-TRANSMIT-009386		
PTS SYSTEM INSTALLATION		This drawing has been superseded by ME-XX-00-PL-569-001	MER	E	ME-ZE-00-PL-569-001	Ground Floor Plan - Pneumatic Tube Distribution	23/01/12		A	24/02/12	24/02/12	BMCE-TRANSMIT-007792 (BMCE-WTRAN-002624)	16/03/12	16/03/12	B	14/03/12 BMCE-TRANSMIT-009051		
		This drawing has been superseded by ME-XX-01-PL-569-002	MER	E	ME-ZE-01-PL-569-002	First Floor Plan - Pneumatic Tube Distribution	23/01/12		A	24/02/12	24/02/12	BMCE-TRANSMIT-007792 (BMCE-WTRAN-002624)	16/03/12	16/03/12	B	14/03/12 BMCE-TRANSMIT-009051		
			MER	E	ME-ZE-02-PL-569-003	Second Floor Plan - Pneumatic Tube Distribution	23/01/12		A	24/02/12	24/02/12	BMCE-TRANSMIT-007792 (BMCE-WTRAN-002624)	16/03/12	16/03/12	A	14/03/12 BMCE-TRANSMIT-009051		
		REMOVED BY MERCURY - SUPERSEDED BY ME-XX-00-PL-569-001	MER	E	ME-ZE-00-PL-569-104	Ground Floor Plan - Pneumatic Tube Distribution												
		REMOVED BY MERCURY - SUPERSEDED BY ME-XX-01-PL-569-002	MER	E	ME-ZE-01-PL-569-106	First Floor Plan - Pneumatic Tube Distribution												
		Issued for information on BMCE-TRANSMIT-019288 04/02/14	MER		ME-XX-00-PL-569-001	Ground Floor Plan - Pneumatic Tube Distribution			C		25/11/13	BMCE-TRANSMIT-018589 (BMCE-WTRAN-009476)	16/12/13	03/01/14	B	14/01/14 bmce-transmit-019037		
		Issued for information on BMCE-TRANSMIT-019288 04/02/14	MER		ME-XX-01-PL-569-002	First Floor Plan - Pneumatic Tube Distribution			A		25/11/13	BMCE-TRANSMIT-018589 (BMCE-WTRAN-009476)	16/12/13	03/01/14	B	14/01/14 bmce-transmit-019038		
		Issued for information on BMCE-TRANSMIT-019288 04/02/14	MER		ME-XX-02-PL-569-003	Second Floor Plan - Pneumatic Tube Distribution			A		25/11/13	BMCE-TRANSMIT-018589 (BMCE-WTRAN-009476)	16/12/13	03/01/14	B	14/01/14 bmce-transmit-019039		
			MER		ME-XX-03-PL-569-004	Third floor plan, Pneumatic Tube Distribution			A		25/11/13	BMCE-TRANSMIT-018589 (BMCE-WTRAN-009476)	16/12/13	03/01/14	A	14/01/14 bmce-transmit-019040		
			MER		ME-XX-04-PL-569-005	Fourth floor plan, Pneumatic Tube Distribution			A		25/11/13	BMCE-TRANSMIT-018589 (BMCE-WTRAN-009476)	16/12/13	03/01/14	A	14/01/14 bmce-transmit-019041		
			MER		ME-XX-05-PL-569-006	Fifth Floor Plan, Pneumatic Tube Distribution			B		25/11/13	BMCE-TRANSMIT-018589 (BMCE-WTRAN-009476)	16/12/13	03/01/14	A	14/01/14 bmce-transmit-019042		
			MER		ME-XX-06-PL-569-007	Sixth Floor Plan, Pneumatic Tube Distribution			B		25/11/13	BMCE-TRANSMIT-018589 (BMCE-WTRAN-009476)	16/12/13	03/01/14	A	14/01/14 bmce-transmit-019043		
			MER		ME-XX-07-PL-569-008	Seventh Floor Plan, Pneumatic Tube Distribution			A		25/11/13	BMCE-TRANSMIT-018589 (BMCE-WTRAN-009476)	16/12/13	03/01/14	A	14/01/14 bmce-transmit-019044		
			MER		ME-XX-08-PL-569-009	Eighth Floor Plan, Pneumatic Tube Distribution			A		25/11/13	BMCE-TRANSMIT-018589 (BMCE-WTRAN-009476)	16/12/13	03/01/14	A	14/01/14 bmce-transmit-019045		
			MER		ME-XX-09-PL-569-010	Ninth Floor Plan, Pneumatic Tube Distribution			A		25/11/13	BMCE-TRANSMIT-018589 (BMCE-WTRAN-009476)	16/12/13	03/01/14	A	14/01/14 bmce-transmit-019046		
			MER		ME-XX-10-PL-569-011	Tenth Floor Plan, Pneumatic Tube Distribution			A		25/11/13	BMCE-TRANSMIT-018589 (BMCE-WTRAN-009476)	16/12/13	03/01/14	A	14/01/14 bmce-transmit-019047		
			MER		ME-XX-11-PL-569-012	Eleventh Floor Plan, Pneumatic Tube Distribution			A		25/11/13	BMCE-TRANSMIT-018589 (BMCE-WTRAN-009476)	16/12/13	03/01/14	A	14/01/14 bmce-transmit-019048		
			MER		ME-XX-12-PL-569-013	Twelfth Floor Plan, Pneumatic Tube Distribution			A		25/11/13	BMCE-TRANSMIT-018589 (BMCE-WTRAN-009476)	16/12/13	03/01/14	A			
SPRINKLER DRAWINGS		Issued for information on BMCE-TRANSMIT-019712 18/03/14	MER	E	ME-ZE-B1-PL-575-306	Basement Level Void Layout			A		07/06/12	BMCE-TRANSMIT-009260 (BMCE-WTRAN-003224)	28/06/12	06/07/12	B	18/07/12BMCE-TRANSMIT-009899		
		Issued for information on BMCE-TRANSMIT-019712 18/03/14	MER	E	ME-ZE-B1-PL-575-307	Basement Level Ceiling Layout			A		07/06/12	BMCE-TRANSMIT-009260 (BMCE-WTRAN-003224)	28/06/12	06/07/12	B	18/07/12BMCE-TRANSMIT-009899		
			MER	E	ME-ZE-00-PL-575-306	Ground Floor Void Layout	23/01/12		A	24/02/12	24/02/12	BMCE-TRANSMIT-007790 (BMCE-WTRAN-0002622)	16/03/12	13/03/12	B	15/03/12 BMCE-TRANSMIT-009863		
			MER	E	ME-ZE-00-PL-575-307	Ground Floor Ceiling Layout	23/01/12		A	24/02/12	24/02/12	BMCE-TRANSMIT-007790 (BMCE-WTRAN-0002622)	16/03/12	13/03/12	B	15/03/12 BMCE-TRANSMIT-		

Drawing Information

31 BCL-AC-XX-SH-001

1st Submission2nd Submission

			Action By	Zone	Drawing Number	Drawing Title	Date Required from Consultant	Date Submitted by Consultant	Document Revision	Planned Date to be Submitted to Board	Date Submitted to Board	BMCE Transmittal No	Date Response Required from Board	Date Returned from Board	Board Status	Date returned to Consultant	Date Required from Consultant	Date Submitted by Consultant
Item	Submission	Comments																
			MER	E	ME-ZE-08-PL-575-306	Eighth Floor Void Layout	16/03/12		A	03/05/12	09/05/12	BMCE-TRANSMIT-008750 (BMCE-WTRAN-003015)	30/05/12		B	20/06/12 BMCE-TRANSMIT-009436		
			MER	E	ME-ZE-08-PL-575-307	Eighth Floor Void Layout	16/03/12		A	03/05/12	09/05/12	BMCE-TRANSMIT-008750 (BMCE-WTRAN-003015)	30/05/12		B	20/06/12 BMCE-TRANSMIT-009436		
			MER	E	ME-ZE-09-PL-575-306	Ninth Floor Void Layout	16/03/12		A	03/05/12	09/05/12	BMCE-TRANSMIT-008750 (BMCE-WTRAN-003015)	30/05/12		B	20/06/12 BMCE-TRANSMIT-009436		
			MER	E	ME-ZE-09-PL-575-307	Ninth Floor Void Layout	16/03/12		A	03/05/12	09/05/12	BMCE-TRANSMIT-008750 (BMCE-WTRAN-003015)	30/05/12		B	20/06/12 BMCE-TRANSMIT-009436		
			MER	E	ME-ZE-10-PL-575-306	Tenth Floor Void Layout	16/03/12		A	03/05/12	09/05/12	BMCE-TRANSMIT-008750 (BMCE-WTRAN-003015)	30/05/12		B	20/06/12 BMCE-TRANSMIT-009436		
			MER	E	ME-ZE-10-PL-575-307	Tenth Floor Void Layout	16/03/12		A	03/05/12	09/05/12	BMCE-TRANSMIT-008750 (BMCE-WTRAN-003015)	30/05/12		B	20/06/12 BMCE-TRANSMIT-009436		
			MER	E	ME-ZE-11-PL-575-306	Eleventh Floor Void Layout	16/03/12		A	03/05/12	09/05/12	BMCE-TRANSMIT-008750 (BMCE-WTRAN-003015)	30/05/12		B	20/06/12 BMCE-TRANSMIT-009436		
			MER	E	ME-ZE-11-PL-575-307	Eleventh Floor Void Layout	16/03/12		A	03/05/12	09/05/12	BMCE-TRANSMIT-008750 (BMCE-WTRAN-003015)	30/05/12		B	20/06/12 BMCE-TRANSMIT-009436		
		Duplicate on RDD Schedule	MER	E	ME-ZE-12-PL-575-306	Twelfth Floor Void Layout							21/01/00					
		NOT REQUIRED FOR RDD REVIEW - MERCURY INSTRUCTION	MER	E	ME-ZE-12-PL-575-307	Twelfth Floor Void Layout							21/01/00					
	CCTV & Door Access	This was issued for information on BMCE-TRANSMIT-018592 26/11/13	MER	E	ME-SZ-B1-PL-571-503	Basement Floor Plan food Waste Renal Tanks & FM Core D			A			BMCE-TRANSMIT-009256 (BMCE-WTRAN-003221)	21/01/00	13/07/12	B	19/07/12 BMCE-TRANSMIT-009932		
			MER	E	ME-ZF-B1-PL-571-504	Basement Floor Plan - NSGH Catering CCTV & Door Access Layout			A			07/06/12	28/06/12	13/07/12	A	19/07/12 BMCE-TRANSMIT-009932		
		REMOVED BY MERCURY - DRAWINGS DOES NOT EXIST	MER	E	ME-ZF-B1-PL-571-505	Basement Floor Plan - NSGH Catering CCTV & Door Access Layout			A									
			MER	E	ME-SZ-B1-PL-571-505	Basement Floor Plan - NSGH Basement Catering CCTV & Door Access Layout			A		07/06/12	BMCE-TRANSMIT-009256 (BMCE-WTRAN-003221)	28/06/12	13/07/12	A	19/07/12 BMCE-TRANSMIT-009932		
			MER	E	ME-SZ-B1-PL-571-506	Basement Floor Plan - NSGH Basement Tunnel FM Stores & FM Core G CCTV & Door Access Layout			A		08/06/12	BMCE-TRANSMIT-009256 (BMCE-WTRAN-003221)	29/06/12	13/07/12	A	19/07/12 BMCE-TRANSMIT-009932		
			MER	E	ME-SZ-B1-PL-571-506	Basement Floor Plan - NSGH Basement Tunnel FM Stores & FM Core G CCTV & Door Access Layout			B		26/02/13	BMCE-TRANSMIT-009244 (BMCE-WTRAN-003216)	19/03/13	25/03/13	A	03/05/13 BMCE-TRANSMIT-014906		
		This was issued for information on BMCE-TRANSMIT-018592 26/11/13	MER	E	ME-SZ-B1-PL-571-510	Basement Floor Plan - NSGH Basement Tunnel & FM Core F CCTV & Door Access Layout			A		08/06/12	BMCE-TRANSMIT-009256 (BMCE-WTRAN-003221)	29/06/12	13/07/12	B	19/07/12 BMCE-TRANSMIT-009932		
		This was issued for information on BMCE-TRANSMIT-018592 26/11/13	MER	E	ME-SZ-00-PL-571-531	Ground Floor Plan - NCH Radiology, CCTV & Door Access Layout	23/01/12		A	24/02/12	24/02/12	BMCE-TRANSMIT-007793 (BMCE-WTRAN-002625)	16/03/12	11/05/12	B	21/05/12 BMCE-TRANSMIT-008964		
		This was issued for information on BMCE-TRANSMIT-018592 26/11/13	MER	E	ME-ZE-00-PL-571-532	Ground Floor Plan - NSGH Radiology, CCTV & Door Access Layout	23/01/12		A	24/02/12	24/02/12	BMCE-TRANSMIT-007793 (BMCE-WTRAN-002625)	16/03/12	11/05/12	B	21/05/12 BMCE-TRANSMIT-008964		
		This was issued for information on BMCE-TRANSMIT-018592 26/11/13	MER	E	ME-ZE-00-PL-571-533	Ground Floor Plan - NSGH Radiology, CCTV & Door Access Layout	23/01/12		A	24/02/12	24/02/12	BMCE-TRANSMIT-007793 (BMCE-WTRAN-002625)	16/03/12	11/05/12	B	21/05/12 BMCE-TRANSMIT-008964		
		This was issued for information on BMCE-TRANSMIT-018592 26/11/13	MER	E	ME-ZE-00-PL-571-534	Ground Floor Plan - NSGH /NCH Medical Illustration, CCTV & Door Access Layout	23/01/12		A	24/02/12	24/02/12	BMCE-TRANSMIT-007793 (BMCE-WTRAN-002625)	16/03/12	11/05/12	B	21/05/12 BMCE-TRANSMIT-008964		
		This was issued for information on BMCE-TRANSMIT-018592 26/11/13	MER	E	ME-ZE-00-PL-571-535	Ground Floor Plan - NCH Radiology, CCTV & Door Access Layout	23/01/12		A	24/02/12	24/02/12	BMCE-TRANSMIT-007793 (BMCE-WTRAN-002625)	16/03/12	11/05/12	B	21/05/12 BMCE-TRANSMIT-008964		
		This was issued for information on BMCE-TRANSMIT-018592 26/11/13	MER	E	ME-ZE-00-PL-571-536	Ground Floor Plan - NCH Radiology, CCTV & Door Access Layout	23/01/12		A	24/02/12	24/02/12	BMCE-TRANSMIT-007793 (BMCE-WTRAN-002625)	16/03/12	11/05/12	B	21/05/12 BMCE-TRANSMIT-008964		
		This was issued for information on BMCE-TRANSMIT-018592 26/11/13	MER	E	ME-SZ-01-PL-571-506	First Floor Plan, NCH Theatres, Endoscopy & Recovery CCTV & Door Access Layout	23/01/12		A	24/02/12	24/02/12	BMCE-TRANSMIT-007793 (BMCE-WTRAN-002625)	16/03/12	11/05/12	B	21/05/12 BMCE-TRANSMIT-008964		
			MER	E	ME-ZF-01-PL-571-507	First Floor Plan, NCH Theatres, Endoscopy & Recovery CCTV & Door Access Layout	23/01/12		A	24/02/12	24/02/12	BMCE-TRANSMIT-007793 (BMCE-WTRAN-002625)	16/03/12	11/05/12	A	21/05/12 BMCE-TRANSMIT-008964		
		This was issued for information on BMCE-TRANSMIT-018592 26/11/13	MER	E	ME-ZE-01-PL-571-508	First Floor Plan, NCH Theatres, Endoscopy & Recovery CCTV & Door Access Layout	23/01/12		A	24/02/12	24/02/12	BMCE-TRANSMIT-007793 (BMCE-WTRAN-002625)	16/03/12	11/05/12	B	21/05/12 BMCE-TRANSMIT-008964		
		This was issued for information on BMCE-TRANSMIT-018592 26/11/13	MER	E	ME-ZE-01-PL-571-509	First Floor Plan, NCH Interventional Radiology CCTV & Door Access Layout	23/01/12		A	24/02/12	24/02/12	BMCE-TRANSMIT-007793 (BMCE-WTRAN-002625)	16/03/12	11/05/12	B	21/05/12 BMCE-TRANSMIT-008964		
		This was issued for information on BMCE-TRANSMIT-018592 26/11/13	MER	E	ME-ZE-01-PL-571-510	First Floor Plan, NCH Radiology Ct & MRI CCTV & Door Access Layout	23/01/12		A	24/02/12	24/02/12	BMCE-TRANSMIT-007793 (BMCE-WTRAN-002625)	16/03/12	11/05/12	B	21/05/12 BMCE-TRANSMIT-008964		
		This was issued for information on BMCE-TRANSMIT-018592 26/11/13	MER	E	ME-SZ-01-PL-571-533	First Floor Plan, NSGH Radiology CCTV & Door Access Layout	23/01/12		C	24/02/12	24/02/12	BMCE-TRANSMIT-007793 (BMCE-WTRAN-002625)	16/03/12	11/05/12	B	21/05/12 BMCE-TRANSMIT-008964		
		This was issued for information on BMCE-TRANSMIT-018592 26/11/13	MER	E	ME-SZ-01-PL-571-534	First Floor Plan, NSGH Radiology CCTV & Door Access Layout	23/01/12		C	24/02/12	24/02/12	BMCE-TRANSMIT-007793 (BMCE-WTRAN-002625)	16/03/12	11/05/12	B	21/05/12 BMCE-TRANSMIT-008964		

Drawing Information

31 BCL-AC-XX-SH-001

1st Submission2nd Submission

			Action By		Zone	Drawing Number	Drawing Title	Date Required from Consultant	Date Submitted by Consultant	Document Revision	Planned Date to be Submitted to Board	Date Submitted to Board	BMCE Transmittal No	Date Response Required from Board	Date Returned from Board	Board Status	Date returned to Consultant	Date Required from Consultant	Date Submitted by Consultant
Item	Submission	Comments																	
			MER	E	ME-ZE-05-PL-571-514	Fifth Floor Plan NSGH Inpatients Wards CCTV & Door Access Layout	16/03/12			A	03/05/12	10/05/12	BMCE-TRANSMIT-008758 (BMCE-WTRAN-003022)	31/05/12	13/07/12	A	18/07/12 BMCE-TRANSMIT-009891		
			MER	E	ME-ZE-XX-PL-571-512	Sixth to Eleventh Floor Plan NSGH Inpatient Wards CCTV & Door Access Layout	16/03/12			A	03/05/12	10/05/12	BMCE-TRANSMIT-008758 (BMCE-WTRAN-003022)	31/05/12	13/07/12	A	18/07/12 BMCE-TRANSMIT-009891		
			MER	E	ME-ZE-XX-PL-571-513	Sixth to Eleventh Floor Plan NSGH Inpatient Wards CCTV & Door Access Layout	16/03/12			A	03/05/12	10/05/12	BMCE-TRANSMIT-008758 (BMCE-WTRAN-003022)	31/05/12	13/07/12	A	18/07/12 BMCE-TRANSMIT-009891		
			MER	E	ME-ZE-XX-PL-571-514	Sixth to Eleventh Floor Plan NSGH Inpatient Wards CCTV & Door Access Layout	16/03/12			A	03/05/12	10/05/12	BMCE-TRANSMIT-008758 (BMCE-WTRAN-003022)	31/05/12	13/07/12	A	18/07/12 BMCE-TRANSMIT-009891		
	Nurses Call		MER	E	ME-SZ-00-PL-538-531	Ground Floor Plan, NCH Radiology Nurse Call Layout				A	24/02/12	24/02/12	BMCE-TRANSMIT-007795 (BMCE-WTRAN-002626)	16/03/12	10/07/12	A	18/07/12 BMCE-TRANSMIT-009902		
			MER	E	ME-SZ-01-PL-538-533	First Floor Plan. NSGH Radiology, Nurse Ca l Layout. Zone H/Zone E/Zone G				F		26/02/13	BMCE-TRANSMIT-014130 (BMCE-WRAN-006180)	19/03/13	25/03/13	A	03/05/13 BMCE-TRANSMIT-014906		
			MER	E	ME-SZ-01-PL-538-534	First Floor Plan. NSGH Radiology, Nurse Call Layout. Zone H/Zone E				F		26/02/13	BMCE-TRANSMIT-014130 (BMCE-WRAN-006180)	19/03/13	25/03/13	A	03/05/13 BMCE-TRANSMIT-014906		
		This was issued for information on BMCE-TRANSMIT-018592 26/11/13	MER	E	ME-ZE-04-PL-538-512	Fourth Floor Plan. NSGH Renal Inpatients & Day Unit. Nurse Call Layout Zone E				A		09/05/12	BMCE-TRANSMIT-008748 (BMCE-WTRAN-003014)	30/05/12	13/07/12	B	19/07/2012 BMCE-TRANSMIT-1907/2012 BMCE-TRANSMIT-		
		This was issued for information on BMCE-TRANSMIT-018592 26/11/13	MER	E	ME-ZE-04-PL-538-513	Fourth Floor Plan. NSGH Haemo-oncology, Nurse Ca l Layout Zone E				A		09/05/12	BMCE-TRANSMIT-008748 (BMCE-WTRAN-003014)	30/05/12	13/07/12	B	19/07/2012 BMCE-TRANSMIT-		
		This was issued for information on BMCE-TRANSMIT-018592 26/11/13	MER	E	ME-ZE-04-PL-538-514	Fourth Floor Plan. NSGH Haemo-oncology, Nurse Ca l Layout Zone E				A		09/05/12	BMCE-TRANSMIT-008748 (BMCE-WTRAN-003014)	30/05/12	13/07/12	B	19/07/2012 BMCE-TRANSMIT-		
		This was issued for information on BMCE-TRANSMIT-018592 26/11/13	MER	E	ME-ZE-05-PL-538-512	Fifth Floor Plan. NSGH Inpatient Wards. Nurse Ca l Layout Zone E				A		09/05/12	BMCE-TRANSMIT-008748 (BMCE-WTRAN-003014)	30/05/12	13/07/12	B	19/07/2012 BMCE-TRANSMIT-		
		This was issued for information on BMCE-TRANSMIT-018592 26/11/13	MER	E	ME-ZE-05-PL-538-513	Fifth Floor Plan. NSGH Inpatient Wards. Nurse Ca l Layout Zone E				A		09/05/12	BMCE-TRANSMIT-008748 (BMCE-WTRAN-003014)	30/05/12	13/07/12	B	19/07/2012 BMCE-TRANSMIT-		
		This was issued for information on BMCE-TRANSMIT-018592 26/11/13	MER	E	ME-ZE-05-PL-538-514	Fifth Floor Plan. NSGH Inpatient Wards. Nurse Ca l Layout Zone E				A		09/05/12	BMCE-TRANSMIT-008748 (BMCE-WTRAN-003014)	30/05/12	13/07/12	B	19/07/2012 BMCE-TRANSMIT-		
		This was issued for information on BMCE-TRANSMIT-018592 26/11/13	MER	E	ME-ZE-XX-PL-538-512	Sixth to Eleventh Floor Plan. NSGH Inpatient Wards. Nurse Call Layout Zone E				A		09/05/12	BMCE-TRANSMIT-008748 (BMCE-WTRAN-003014)	30/05/12	13/07/12	B	19/07/2012 BMCE-TRANSMIT-		
		This was issued for information on BMCE-TRANSMIT-018592 26/11/13	MER	E	ME-ZE-XX-PL-538-513	Sixth to Eleventh Floor Plan. NSGH Inpatient Wards. Nurse Call Layout Zone E				A		09/05/12	BMCE-TRANSMIT-008748 (BMCE-WTRAN-003014)	30/05/12	13/07/12	B	19/07/2012 BMCE-TRANSMIT-		
		This was issued for information on BMCE-TRANSMIT-018592 26/11/13	MER	E	ME-ZE-XX-PL-538-514	Sixth to Eleventh Floor Plan. NSGH Inpatient Wards. Nurse Call Layout Zone E				A		09/05/12	BMCE-TRANSMIT-008748 (BMCE-WTRAN-003014)	30/05/12	13/07/12	B	19/07/2012 BMCE-TRANSMIT-		
		This was issued for information on BMCE-TRANSMIT-018592 26/11/13	MER	E	ME-ZE-00-PL-538-532	Ground Floor Plan, NCH Radiology Nurse Call Layout				A	24/02/12	24/02/12	BMCE-TRANSMIT-007795 (BMCE-WTRAN-002626)	16/03/12	10/07/12	B	18/07/12 BMCE-TRANSMIT-009902		
		This was issued for information on BMCE-TRANSMIT-018592 26/11/13	MER	E	ME-ZE-00-PL-538-533	Ground Floor Plan, NCH Radiology Nurse Call Layout				A	24/02/12	24/02/12	BMCE-TRANSMIT-007795 (BMCE-WTRAN-002626)	16/03/12	10/07/12	B	18/07/12 BMCE-TRANSMIT-009902		
			MER	E	ME-ZE-00-PL-538-534	Ground Floor Plan, NCH Medical Illustration Nurse Call Layout				A	24/02/12	24/02/12	BMCE-TRANSMIT-007795 (BMCE-WTRAN-002626)	16/03/12	10/07/12	A	18/07/12 BMCE-TRANSMIT-009902		
		This was issued for information on BMCE-TRANSMIT-018592 26/11/13	MER	E	ME-ZE-00-PL-538-535	Ground Floor Plan, NCH Radiology Nurse Call Layout				A	24/02/12	24/02/12	BMCE-TRANSMIT-007795 (BMCE-WTRAN-002626)	16/03/12	10/07/12	B	18/07/12 BMCE-TRANSMIT-009902		
		Issued for information on BMCE-TRANSMIT-019288 04/02/14	MER	E	ME-ZE-00-PL-538-536	Ground Floor Plan, NCH Radiology Nurse Call Layout				A	24/02/12	24/02/12	BMCE-TRANSMIT-007795 (BMCE-WTRAN-002626)	16/03/12	10/07/12	C	18/07/12 BMCE-TRANSMIT-009902		
		This was issued for information on BMCE-TRANSMIT-018592 26/11/13	MER	E	ME-ZF-01-PL-538-507	First Floor Plan, NCH Theatres, Endoscopy & Recovery Nurse Call Layout				A	24/02/12	24/02/12	BMCE-TRANSMIT-007795 (BMCE-WTRAN-002626)	16/03/12	10/07/12	B	20/07/12 BMCE-TRANSMIT-009951		
			MER	E	ME-ZE-01-PL-538-508	First Floor Plan, NCH Theatres, Endoscopy & Recovery Nurse Call Layout				A	24/02/12	24/02/12	BMCE-TRANSMIT-007795 (BMCE-WTRAN-002626)	16/03/12	10/07/12	A	18/07/12 BMCE-TRANSMIT-009902		
		This was issued for information on BMCE-TRANSMIT-018592 26/11/13	MER	E	ME-ZE-01-PL-538-509	First Floor Plan, NCH Interventional Radiology Nurse Call Layout				A	24/02/12	24/02/12	BMCE-TRANSMIT-007795 (BMCE-WTRAN-002626)	16/03/12	10/07/12	B	18/07/12 BMCE-TRANSMIT-009902		
		This was issued for information on BMCE-TRANSMIT-018592 26/11/13	MER	E	ME-ZE-01-PL-538-510	First Floor Plan, NSGH - Radiology CT & MRI - Nurse Call Layout				A	24/02/12	24/02/12	BMCE-TRANSMIT-007795 (BMCE-WTRAN-002626)	16/03/12	10/07/12	B	18/07/12 BMCE-TRANSMIT-009902		
		This was issued for information on BMCE-TRANSMIT-018592 26/11/13	MER	E	ME-SZ-01-PL-538-535	First Floor Plan NSGH Radiology Nurse Call Layout				A	24/02/12	24/02/12	BMCE-TRANSMIT-007795 (BMCE-WTRAN-002626)	16/03/12	10/07/12	B	18/07/12 BMCE-TRANSMIT-009902		
		This was issued for information on BMCE-TRANSMIT-018592 26/11/13	MER	E	ME-ZE-01-PL-538-536	First Floor Plan NSGH Nuclear Medicine Nurse Call Layout				A	24/02/12	24/02/12	BMCE-TRANSMIT-007795 (BMCE-WTRAN-002626)	16/03/12	10/07/12	B	18/07/12 BMCE-TRANSMIT-009902		
			MER	E	ME-ZE-02-PL-538-517	Second Floor Plan NSGH/NCH Medical Physics & Bio-Engineering Nurse Call Layout				A	24/02/12	24/02/12	BMCE-TRANSMIT-007795 (BMCE-WTRAN-002626)	16/03/12	10/07/12	A	18/07/12 BMCE-TRANSMIT-009902		
			MER	E	ME-ZE-02-PL-538-518	Second Floor Plan NSGH Decontamination Suite Nurse Ca l Layout				A	24/02/12	24/02/12	BMCE-TRANSMIT-007795 (BMCE-WTRAN-002626)	16/03/12	10/07/12	A	18/07/12 BMCE-TRANSMIT-009902		
		This was issued for information on BMCE-TRANSMIT-018592 26/11/13	MER	E	ME-ZE-02-PL-538-523	Second floor Plan. NSGH Theatres Ados & Recovery Nurses Ca l Layout Zone F				E		01/03/13	BMCE-TRANSMIT-014279 (BMCE-WTRAN-006293)	22/03/13	12/04/13	B	30/04/13 BMCE-TRANSMIT-		

			Action By	Zone	Drawing Number	Drawing Title	Date Required from Consultant	Date Submitted by Consultant	Document Revision	Planned Date to be Submitted to Board	Date Submitted to Board	BMCE Transmittal No	Date Response Required from Board	Date Returned from Board	Board Status	Date returned to Consultant	Date Required from Consultant	Date Submitted by Consultant
Item	Submission	Comments																
			MER	E	ME-ZE-12-PL-575-306	Twelfth floor void layout Zone E General Layout Zone E			A		22/05/13	BMCE-TRANSMIT-015884 (BMCE-WTRAN-007579)	12/06/13	28/04/13	A	BMCE-TRANSMIT-015963.30/05/13		
	Hospital Drawings - Zone F Mechanical Services Drawings		ZBP	F	ZBP-ZF-00-PL-512-006	Medical Gases Layout Ground	23/03/12		A	27/04/12	02/05/12	BMCE-TRANSMIT-008652 (BMCE-WTRAN-002980)	23/05/12	06/07/12	A	17/07/12 BMCE-TRANSMIT-009877		
			ZBP	F	ZBP-ZF-01-PL-512-016	Medical Gases Layout First	23/03/12		A	27/04/12	02/05/12	BMCE-TRANSMIT-008652 (BMCE-WTRAN-002980)	23/05/12	06/07/12	A	17/07/12 BMCE-TRANSMIT-009877		
			ZBP	F	ZBP-ZF-02-PL-512-026	Medical Gases Layout Second	23/03/12		A	27/04/12	02/05/12	BMCE-TRANSMIT-008652 (BMCE-WTRAN-002980)	23/05/12	06/07/12	A	17/07/12 BMCE-TRANSMIT-009877		
	ZBP drawings not to be reviewed as not HPI drawings		ZBP	F	ZBP-ZF-04-PL-512-046	Medical Cases Layout Fourth	16/03/12			03/05/12	11/12/12	BMCE-TRANSMIT-012841 (BMCE-WTRAN-005109)	07/01/12					
	ZBP drawings not to be reviewed as not HPI drawings		ZBP	F	ZBP-ZF-XX-PL-512-066	Medical Cases Layout Generic Ward					11/12/12	BMCE-TRANSMIT-012841 (BMCE-WTRAN-005109)	07/01/12					
	REMOVED BY ZBP		ZBP	F	ZBP-ZF-XX-PL-512-066	Medical Cases Layout Generic Ward	23/03/12			27/04/12			-					
			ZBP	F	ZBP-ZF-12-PL-523-171	HTG & CHW Pipework Layout Plantroom 122 - Sheet 1 12th floor			A		26/02/13	BMCE-TRANSMIT-014131 (BMCE-WTRAN-006181)	19/03/13	26/03/13	A	03/08/13 BMCE-TRANSMIT-014910		
			ZBP	F	ZBP-ZF-12-PL-523-172	HTG & CHW Pipework Layout Plantroom 122 - Sheet 2 12th floor			A		26/02/13	BMCE-TRANSMIT-014131 (BMCE-WTRAN-006181)	19/03/13	26/03/13	B	03/08/13 BMCE-TRANSMIT-014910		
	Issued for information on BMCE-TRANSMIT-019136 21/01/14		ZBP	F	ZBP-ZF-12-PL-524-171	Ventilation Layout Plantroom 122 sheet 1 12th floor			A		26/02/13	BMCE-TRANSMIT-014131 (BMCE-WTRAN-006181)	19/03/13	26/03/13	B	03/08/13 BMCE-TRANSMIT-014910		
	Issued for information on BMCE-TRANSMIT-019136 21/01/14		ZBP	F	ZBP-ZF-12-PL-524-172	Ventilation Layout Plantroom 122 sheet 2 12th floor			A		26/02/13	BMCE-TRANSMIT-014131 (BMCE-WTRAN-006181)	19/03/13	26/03/13	B	03/08/13 BMCE-TRANSMIT-014910		
			ZBP	F	ZBP-ZF-12-SE-590-001				A		26/02/13	BMCE-TRANSMIT-014131 (BMCE-WTRAN-006181)	19/03/13	26/03/13	A	03/08/13 BMCE-TRANSMIT-014910		
	Issued for information on BMCE-TRANSMIT-019136 21/01/14		ZBP	F	ZBP-ZF-00-PL-523-006	HTG & CHW Layout Ground	23/03/12		A	27/04/12	02/05/12	BMCE-TRANSMIT-008652 (BMCE-WTRAN-002980)	23/05/12	06/07/12	B	17/07/12 BMCE-TRANSMIT-009877		
	Issued for information on BMCE-TRANSMIT-019136 21/01/14		ZBP	F	ZBP-ZF-01-PL-523-016	HTG & CHW Layout First	23/03/12		A	27/04/12	02/05/12	BMCE-TRANSMIT-008652 (BMCE-WTRAN-002980)	23/05/12	06/07/12	B	17/07/12 BMCE-TRANSMIT-009877		
			ZBP	F	ZBP-ZF-02-PL-523-026	HTG & CHW Layout Second	23/03/12		C	27/04/12	14/06/12	BMCE-TRANSMIT-009360 (BMCE-WTRAN003283)	05/07/12	10/09/12	A	20/09/12 BMCE-TRANSMIT-011046		
			ZBP	F	ZBP-ZF-04-PL-523-046	HTG & CHW Layout Fourth	16/03/12		A	03/05/12	28/05/12	BMCE-TRANSMIT-009096 (BMCE-WTRAN-003156)	18/06/12	19/07/12	A	26/07/12 BMCE-TRANSMIT-010001		
			ZBP	F	ZBP-ZF-06-PL-523-066	HTG & CHW Layout Sixth			A		07/06/12	BMCE-TRANSMIT-009264 (BMCE-WTRAN-003228)	28/06/12	10/09/12	A	20/09/12 BMCE-TRANSMIT-011049		
			ZBP	F	ZBP-ZF-11-PL-523-116	HTG & CHW Service Layout Eleventh Floor			A		28/05/12	BMCE-TRANSMIT-009096 (BMCE-WTRAN-003156)	18/06/12	19/07/12	A	26/07/12 BMCE-TRANSMIT-010001		
	Issued for information on BMCE-TRANSMIT-019224 28/01/2014		ZBP	F	ZBP-ZF-XX-PL-523-056	HTG & CHW Layout Generic Ward			A		28/05/12	BMCE-TRANSMIT-009096 (BMCE-WTRAN-003156)	18/06/12	19/07/12	B	26/07/12 BMCE-TRANSMIT-010001		
	DELETED BY ZBP		ZBP	F	ZBP-ZF-XX-PL-523-066	HTG & CHW Layout Generic Ward	23/03/12			27/04/12			-					
	Issued for information on BMCE-TRANSMIT-019224 28/01/2014		ZBP	F	ZBP-ZF-00-PL-524-006	Ventilation Layout Ground	23/03/12		A	27/04/12	02/05/12	BMCE-TRANSMIT-008647 (BMCE-WTRAN-002975)	23/05/12	06/07/12	B	17/07/12 BMCE-TRANSMIT-009878		
	Issued for information on BMCE-TRANSMIT-019136 21/01/14		ZBP	F	ZBP-ZF-01-PL-524-016	Ventilation Layout First	23/03/12		A	27/04/12	02/05/12	BMCE-TRANSMIT-008647 (BMCE-WTRAN-002975)	23/05/12	06/07/12	B	17/07/12 BMCE-TRANSMIT-009878		
	Issued for information on BMCE-TRANSMIT-019136 21/01/14		ZBP	F	ZBP-ZF-02-PL-524-026	Ventilation Layout Second	23/03/12		E	27/04/12	14/12/12	BMCE-TRANSMIT-012892 (BMCE-WTRAN-005138)	04/01/13	04/01/13	B	16/01/13 BMCE-TRANSMIT-013853		
	Issued for information on BMCE-TRANSMIT-019224 28/01/2014		ZBP	F	ZBP-ZF-04-PL-524-046	Ventilation Layout Fourth	16/03/12		A	03/05/12	31/05/12	BMCE-TRANSMIT-009172 (BMCE-WTRAN-003196)	21/06/12	19/07/12	B	01/08/12 BMCE-TRANSMIT-010097.15/08/12		
	Issued for information on BMCE-TRANSMIT-019224 28/01/2014		ZBP	F	ZBP-ZF-11-PL-524-116	Ventilation Layout Eleventh Floor			A		31/05/12	BMCE-TRANSMIT-009172 (BMCE-WTRAN-003196)	21/06/12	19/07/12	B	01/08/12 BMCE-TRANSMIT-010097.15/08/12		
	Issued for information on BMCE-TRANSMIT-019224 28/01/2014		ZBP	F	ZBP-ZF-XX-PL-524-056	Ventilation Layout Typical Tower Floor (5th, 7th - 10th Floors) NSGH Generic Ward			A		31/05/12	BMCE-TRANSMIT-009172 (BMCE-WTRAN-003196)	21/06/12	19/07/12	B	01/08/12 BMCE-TRANSMIT-010097.15/08/12		
	Issued for information on BMCE-TRANSMIT-019224 28/01/2014		ZBP	F	ZBP-ZF-XX-PL-524-066	Ventilation Layout Generic Ward	23/03/12		A	27/04/12	31/05/12	BMCE-TRANSMIT-009172 (BMCE-WTRAN-003196)	21/06/12	19/07/12	B	01/08/12 BMCE-TRANSMIT-010097.15/08/12		

Drawing Information

31 BCL-AC-XX-SH-001

			Action By		Zone	Drawing Number	Drawing Title	Date Required from Consultant	Date Submitted by Consultant	Document Revision	Planned Date to be Submitted to Board	Date Submitted to Board	BMCE Transmittal No	Date Response Required from Board	Date Returned from Board	Board Status	Date returned to Consultant	Date Required from Consultant	Date Submitted by Consultant
Item	Submission	Comments																	
	Electrical Services Drawings		ZBP	F		ZBP-ZF-00-PL-531-006	Small Power Layout Ground	23/03/12		A	27/04/12	02/05/12	BMCE-TRANSMIT-008653 (BMCE-WTRAN-002981)	23/05/12	02/08/12	A	23/08/12 BMCE-TRANSMIT-010489		
			ZBP	F		ZBP-ZF-01-PL-531-016	Small Power Layout First	23/03/12		A	27/04/12	02/05/12	BMCE-TRANSMIT-008653 (BMCE-WTRAN-002981)	23/05/12	02/08/12	A	23/08/12 BMCE-TRANSMIT-010489		
			ZBP	F		ZBP-ZF-02-PL-531-026	Small Power Layout Second	23/03/12		A	27/04/12	02/05/12	BMCE-TRANSMIT-008653 (BMCE-WTRAN-002981)	23/05/12	02/08/12	A	23/08/12 BMCE-TRANSMIT-010489		
			ZBP	F		ZBP-ZF-04-PL-531-046	Small Power Layout Fourth	16/03/12		A	03/05/12	08/05/12	BMCE-TRANSMIT-008691 (BBMCE-TRANSMIT-003000)	29/05/12	02/08/12	A	29/08/12 BMCE-TRANSMIT-010570		
			ZBP	F		ZBP-ZF-05-PL-531-056	Small Power Layout Fifth to Eleventh Floors NSGH Generic Wards	16/03/12		A	03/05/12	08/05/12	BMCE-TRANSMIT-008691 (BBMCE-TRANSMIT-003000)	29/05/12	02/08/12	A	29/08/12 BMCE-TRANSMIT-010570		
		REMOVED BY ZBP	ZBP	F		ZBP-ZF-XX-PL-531-066	Small Power Layout Generic Ward	23/03/12			27/04/12			-					
			ZBP	F		ZBP-ZF-00-PL-532-006	Containment/Sub-Main Layout Ground	23/03/12		A	27/04/12	02/05/12	BMCE-TRANSMIT-008653 (BMCE-WTRAN-002981)	23/05/12	02/08/12	A	23/08/12 BMCE-TRANSMIT-010489		
			ZBP	F		ZBP-ZF-01-PL-532-016	Containment/Sub-Main Layout First	23/03/12		A	27/04/12	02/05/12	BMCE-TRANSMIT-008653 (BMCE-WTRAN-002981)	23/05/12	02/08/12	A	23/08/12 BMCE-TRANSMIT-010489		
			ZBP	F		ZBP-ZF-02-PL-532-026	Containment/Sub-Main Layout Second	23/03/12		A	27/04/12	02/05/12	BMCE-TRANSMIT-008653 (BMCE-WTRAN-002981)	23/05/12	02/08/12	A	23/08/12 BMCE-TRANSMIT-010489		
			ZBP	F		ZBP-ZF-04-PL-532-046	Containment/Sub-Main Layout Fourth	16/03/12		A	03/05/12	08/05/12	BMCE-TRANSMIT-008691 (BBMCE-TRANSMIT-003000)	29/05/12	02/08/12	A	29/08/12 BMCE-TRANSMIT-010570		
			ZBP	F		ZBP-ZF-05-PL-532-056	Containment/Sub-Main Layout Fifth to Eleventh Floors NSGH Generic Ward	16/03/12		A	03/05/12	08/05/12	BMCE-TRANSMIT-008691 (BBMCE-TRANSMIT-003000)	29/05/12	02/08/12	A	29/08/12 BMCE-TRANSMIT-010570		
		REMOVED BY ZBP	ZBP	F		ZBP-ZF-XX-PL-532-066	Containment/Sub-main Layout Generic Ward	23/03/12			27/04/12			-					
		Issued for information on BMCE-TRANSMIT-019224 28/01/2014	ZBP	F		ZBP-ZF-00-PL-571-006	Security Layout Ground	23/03/12		A	27/04/12	02/05/12	BMCE-TRANSMIT-008653 (BMCE-WTRAN-002981)	23/05/12	02/08/12	B	23/08/12 BMCE-TRANSMIT-010489		
		Issued for information on BMCE-TRANSMIT-019224 28/01/2014	ZBP	F		ZBP-ZF-01-PL-571-016	Security Layout First	23/03/12		A	27/04/12	02/05/12	BMCE-TRANSMIT-008653 (BMCE-WTRAN-002981)	23/05/12	02/08/12	B	23/08/12 BMCE-TRANSMIT-010489		
		Issued for information on BMCE-TRANSMIT-019224 28/01/2014	ZBP	F		ZBP-ZF-02-PL-571-026	Security Layout Second	23/03/12		A	27/04/12	02/05/12	BMCE-TRANSMIT-008653 (BMCE-WTRAN-002981)	23/05/12	02/08/12	B	23/08/12 BMCE-TRANSMIT-010489		
		Issued for information on BMCE-TRANSMIT-019224 28/01/2014	ZBP	F		ZBP-ZF-04-PL-571-046	Security Layout Fourth	16/03/12		A	03/05/12	08/05/12	BMCE-TRANSMIT-008691 (BBMCE-TRANSMIT-003000)	29/05/12	02/08/12	B	29/08/12 BMCE-TRANSMIT-010570		
		Issued for information on BMCE-TRANSMIT-019224 28/01/2014	ZBP	F		ZBP-ZF-05-PL-571-056	Security Layout Fifth to Eleventh Floors NSGH Generic Ward	16/03/12		A	03/05/12	08/05/12	BMCE-TRANSMIT-008691 (BBMCE-TRANSMIT-003000)	29/05/12	02/08/12	B	29/08/12 BMCE-TRANSMIT-010570		
		REMOVED BY ZBP	ZBP	F		ZBP-ZF-XX-PL-571-066	Security Layout Generic Ward	23/03/12			27/04/12			-					
		Public Health Services Drawings																	
		Issued for information on BMCE-TRANSMIT-019224 28/01/2014	ZBP	F		ZBP-ZF-00-PL-500-006	Water & Gas Services Layout Ground	23/03/12		A	27/04/12	30/04/12	BMCE-TRANSMIT-008610 (BMCE-WTRAN-002965)	21/05/12	06/07/12	B	19/07/12 BMCE-TRANSMIT-009917		
		Issued for information on BMCE-TRANSMIT-019224 28/01/2014	ZBP	F		ZBP-ZF-01-PL-500-016	Water & Gas Services Layout First	23/03/12		A	27/04/12	30/04/12	BMCE-TRANSMIT-008610 (BMCE-WTRAN-002965)	21/05/12	07/07/12	B	19/07/12 BMCE-TRANSMIT-009917		
		Issued for information on BMCE-TRANSMIT-019224 28/01/2014	ZBP	F		ZBP-ZF-02-PL-500-026	Water & Gas Services Layout Second	23/03/12		A	27/04/12	30/04/12	BMCE-TRANSMIT-008610 (BMCE-WTRAN-002965)	21/05/12	08/07/12	B	19/07/12 BMCE-TRANSMIT-009917		
			ZBP	F		ZBP-ZF-04-PL-500-046	Water & Gas Services Layout Fourth	16/03/12		A	03/05/12	30/05/12	BMCE-TRANSMIT-009098 (BMCE-WTRAN-003159)	20/06/12	19/07/12	A	28/07/12 BMCE-TRANSMIT-010051 15/08/12		
			ZBP	F		ZBP-ZF-XX-PL-500-056	Water & Gas Services Layout Generic Ward			A		30/05/12	BMCE-TRANSMIT-009098 (BMCE-WTRAN-003159)	20/06/12	19/07/12	A	28/07/12 BMCE-TRANSMIT-010051 15/08/12		
		REMOVED BY ZBP	ZBP	F		ZBP-ZF-XX-PL-500-066	Water & Gas Services Layout Generic Ward	23/03/12			27/04/12			-					
			ZBP	F		ZBP-ZF-00-PL-581-006	Sanitation and Rainwater Layout Ground	23/03/12		B	27/04/12	09/07/12	BMCE-TRANSMIT-009729 (BMCE-WTRAN-003455)	30/07/12	03/08/12	A	20/08/12 BMCE-TRANSMIT-010399		
		Issued for information on BMCE-TRANSMIT-019224 28/01/2014	ZBP	F		ZBP-ZF-01-PL-581-016	Sanitation and Rainwater Layout First	23/03/12		B	27/04/12	09/07/12	BMCE-TRANSMIT-009729 (BMCE-WTRAN-003455)	30/07/12	03/08/12	B	20/08/12 BMCE-TRANSMIT-		

Drawing Information

31 BCL-AC-XX-SH-001

1st Submission2nd Submission

			Action By	Zone	Drawing Number	Drawing Title	Date Required from Consultant	Date Submitted by Consultant	Document Revision	Planned Date to be Submitted to Board	Date Submitted to Board	BMCE Transmittal No	Date Response Required from Board	Date Returned from Board	Board Status	Date returned to Consultant	Date Required from Consultant	Date Submitted by Consultant
Item	Submission	Comments																
		Issued for information on BMCE-TRANSMIT-019224 28/01/2014	ZBP	F	ZBP-ZF-XX-PL-520-634	Riser T1	04/05/12			27/04/12	17/12/12	BMCE-TRANSMIT-012842 (BMCE-WTRAN-005110)	07/01/13	04/01/13	B	15/01/13 BMCE-TRANSMIT-01339		
		Issued for information on BMCE-TRANSMIT-019224 28/01/2014	ZBP	F	ZBP-ZF-XX-PL-520-635	Riser T11	13/04/12			03/05/12	17/12/12	BMCE-TRANSMIT-012842 (BMCE-WTRAN-005110)	07/01/13	04/01/13	B	15/01/13 BMCE-TRANSMIT-01339		
		Issued for information on BMCE-TRANSMIT-019224 28/01/2014	ZBP	F	ZBP-ZF-XX-PL-520-636	Riser T12 Ground to Third Floor	04/05/12		A	11/06/12	09/07/12	BMCE-TRANSMIT-009727 (BMCE-WTRAN-003453)	30/07/12	03/08/12	B	20/08/12 BMCE-TRANSMIT-010396		
		Issued for information on BMCE-TRANSMIT-019224 28/01/2014	ZBP	F	ZBP-ZF-XX-PL-520-637	Riser T12 Fourth to Eleventh Floor	04/05/12		A	11/06/12	14/06/12	BMCE-TRANSMIT-009359 (BMCE-WTRAN-003282)	05/07/12	10/09/12	B	21/09/12 BMCE-TRANSMIT-011089		
			ZBP	F	ZBP-ZF-XX-PL-520-638	Riser T12 Levels 08-11			A	11/06/12	14/06/12	BMCE-TRANSMIT-009359 (BMCE-WTRAN-003282)	05/07/12	10/09/12	A	21/09/12 BMCE-TRANSMIT-011089		
			ZBP	F	ZBP-ZF-XX-PL-520-639	Riser T1 Level 04-11			A		14/06/12	BMCE-TRANSMIT-009359 (BMCE-WTRAN-003282)	05/07/12	10/09/12	A	21/09/12 BMCE-TRANSMIT-011089		
		REMOVED BY ZBP	ZBP	F	ZBP-ZF-02-PL-512-113	Plantroom 22 Medical Gases	13/04/12			25/05/12								
		REMOVED BY ZBP	ZBP	F	ZBP-ZF-02-PL-512-114	Plantroom 22 Medical Gases	13/04/12			25/05/12								
		REMOVED BY ZBP	ZBP	F	ZBP-ZF-02-PL-523-111	Plantroom 22 Pipework	23/01/12			20/02/12			21/01/00					
		REMOVED BY ZBP	ZBP	F	ZBP-ZF-02-PL-523-112	Plantroom 22 Pipework	23/01/12			20/02/12			21/01/00					
			ZBP	F	ZBP-ZF-02-PL-523-113	Plantroom 22 HTG & CHW	13/04/12		A	25/05/12	25/05/12	BMCE-TRANSMIT-009077 (BMCE-WTRAN-003145)	15/06/12	09/07/12	A	18/07/12 BMCE-TRANSMIT-009885		
		REMOVED BY ZBP	ZBP	F	ZBP-ZF-02-PL-524-111	Plantroom 22 Ventilation	23/01/12			20/02/12			21/01/00					
		REMOVED BY ZBP	ZBP	F	ZBP-ZF-02-PL-524-112	Plantroom 22 Ventilation	23/01/12			20/02/12			21/01/00					
			ZBP	F	ZBP-ZF-02-PL-523-114	Plantroom 22 HTG & CHW	13/04/12		A	25/05/12	25/05/12	BMCE-TRANSMIT-009077 (BMCE-WTRAN-003145)	15/06/12	09/07/12	A	18/07/12 BMCE-TRANSMIT-009885		
		Issued for information on BMCE-TRANSMIT-019224 28/01/2014	ZBP	F	ZBP-ZF-02-PL-524-113	Plantroom 22 Ventilation	13/04/12		A	25/05/12	25/05/12	BMCE-TRANSMIT-009077 (BMCE-WTRAN-003145)	15/06/12	09/07/12	B	18/07/12 BMCE-TRANSMIT-009885		
			ZBP	F	ZBP-ZF-02-PL-524-114	Plantroom 22 Ventilation	13/04/12		A	25/05/12	25/05/12	BMCE-TRANSMIT-009077 (BMCE-WTRAN-003145)	15/06/12	09/07/12	A	18/07/12 BMCE-TRANSMIT-009885		
		Removed by ZBP	ZBP	F	ZBP-ZF-02-PL-532-111	Plantroom 22 LV Power	23/01/12			20/02/12			21/01/00					
		Removed by ZBP	ZBP	F	ZBP-ZF-02-PL-532-112	Plantroom 22 LV Power	23/01/12			20/02/12			21/01/00					
		Issued for information on BMCE-TRANSMIT-019224 28/01/2014	ZBP	F	ZBP-ZF-02-PL-532-113	Plantroom 22 LV Power	13/04/12		A	25/05/12	06/06/12	BMCE-TRANSMIT-009248 (BMCE-WTRAN-003219)	27/06/12	18/06/12	B	20/06/12 BMCE-TRANSMIT-009446		
		REMOVED BY ZBP	ZBP	F	ZBP-ZF-02-PL-532-114	Plantroom 22 LV Power	13/04/12			25/05/12			-					
		REMOVED BY ZBP	ZBP	F	ZBP-ZF-02-PL-500-113	Plantroom 22 Water Services	13/04/12			25/05/12			-					
		REMOVED BY ZBP	ZBP	F	ZBP-ZF-02-PL-500-114	Plantroom 22 Water Services	13/04/12			25/05/12			-					
		REMOVED BY ZBP	ZBP	F	ZBP-ZF-02-PL-581-221	Plantroom 22 Sanitation and Rainwater Layout	13/04/12			25/05/12			21/01/00					
		REMOVED BY ZBP	ZBP	F	ZBP-ZF-02-PL-581-222	Plantroom 22 Sanitation and Rainwater Layout	13/04/12			25/05/12			21/01/00					
		REMOVED BY ZBP	ZBP	F	ZBP-ZF-02-PL-581-223	Plantroom 22 Sanitation and Rainwater Layout	13/04/12			25/05/12			-					
		REMOVED BY ZBP	ZBP	F	ZBP-ZF-02-PL-581-224	Plantroom 22 Sanitation and Rainwater Layout	13/04/12			25/05/12			-					
		REMOVED BY ZBP	ZBP	F	ZBP-ZF-03-PL-581-225	Plantroom 22 Roof Sanitation and Rainwater Layout	13/04/12			25/05/12			-					
		REMOVED BY ZBP	ZBP	F	ZBP-ZF-03-PL-581-226	Plantroom 22 Roof Sanitation and Rainwater Layout	13/04/12			25/05/12			-					
		REMOVED BY ZBP	ZBP	F	ZBP-ZF-03-PL-581-227	Plantroom 22 Roof Sanitation and Rainwater Layout	13/04/12			25/05/12			-					
		REMOVED BY ZBP	ZBP	F	ZBP-ZF-03-PL-581-228	Plantroom 22 Roof Sanitation and Rainwater Layout	13/04/12			25/05/12			-					
			ZBP	F	ZBP-ZF-12-PL-581-126	Plantroom 122 Sanitary and Rainwater Layout			A		10/04/13	BMCE-TRANSMIT-015015 (BMCE-WTRAN-006924)	01/05/13	07/05/13	A	20/05/13 BMCE-TRANSMIT-		

Drawing Information

31 BCL-AC-XX-SH-001

			Action By		Zone	Drawing Number	Drawing Title	Date Required from Consultant	Date Submitted by Consultant	Document Revision	Planned Date to be Submitted to Board	Date Submitted to Board	BMCE Transmittal No	Date Response Required from Board	Date Returned from Board	Board Status	Date returned to Consultant	Date Required from Consultant	Date Submitted by Consultant
Item	Submission	Comments																	
		REMOVED BY ZBP	ZBP	F	ZBP-XX-XX-SC-524-756	Ventilation Schematic (PR22) AHU 24	27/04/12				27/04/12			21/01/00					
			ZBP	F	ZBP-XX-XX-SC-524-757	Ventilation Schematic (PR22) AHU 11			A			31/05/12	BMCE-TRANSMIT-009171 (BMCE-WTRAN-003195)	21/06/12	19/07/12	B	26/07/12 BMCE-TRANSMIT-010000		
		Issued for information on BMCE-TRANSMIT-019224 28/01/2014	ZBP	F	ZBP-XX-XX-SC-524-758	Theatre Support Ventilation Schematic 22 AHU 07			A			31/05/12	BMCE-TRANSMIT-009171 (BMCE-WTRAN-003195)	21/06/12	19/07/12	B	26/07/12 BMCE-TRANSMIT-010000		
		Issued for information on BMCE-TRANSMIT-019136 21/01/14	ZBP	F	ZBP-XX-XX-SC-521-421	Secondary Heating Schematic Plantroom 22	27/04/12		A		27/04/12	31/05/12	BMCE-TRANSMIT-009171 (BMCE-WTRAN-003195)	21/06/12	19/07/12	B	26/07/12 BMCE-TRANSMIT-010000		
			ZBP	F	ZBP-XX-XX-SC-521-422	Secondary Heating Distribution Schematic Plantroom 22	27/04/12		A		27/04/12	31/05/12	BMCE-TRANSMIT-009171 (BMCE-WTRAN-003195)	21/06/12	19/07/12	A	26/07/12 BMCE-TRANSMIT-010000		
		Issued for information on BMCE-TRANSMIT-019224 28/01/2014	ZBP	F	ZBP-XX-XX-SC-525-521	Secondary Chilled Water Schematic Plantroom 22	27/04/12		A		27/04/12	31/05/12	BMCE-TRANSMIT-009171 (BMCE-WTRAN-003195)	21/06/12	19/07/12	B	26/07/12 BMCE-TRANSMIT-010000		
		Issued for information on BMCE-TRANSMIT-019224 28/01/2014	ZBP	F	ZBP-XX-XX-SC-525-522	Secondary Chilled Water Distribution Schematic Plantroom 22	27/04/12		A		27/04/12	31/05/12	BMCE-TRANSMIT-009171 (BMCE-WTRAN-003195)	21/06/12	19/07/12	B	26/07/12 BMCE-TRANSMIT-010000		
	Public Health Services Schematics	Issued for information on BMCE-TRANSMIT-019224 28/01/2014	ZBP	F	ZBP-XX-XX-SC-500-022	Domestic Water Services Schematic Plantroom 22	13/04/12		A		22/06/12	12/10/12	BMCE-TRANSMIT-011554 (BMCE-WTRAN-004207)	02/11/12	23/10/12	B	14/11/12 BMCE-TRANSMIT-012297		
	Mechanical Services Drawings Plantroom 32	REMOVED BY ZBP	ZBP	F	ZBP-ZF-03-PL-512-131	Plantroom 32 Medical Gases	18/05/12				22/06/12								
		REMOVED BY ZBP	ZBP	F	ZBP-ZF-03-PL-512-132	Plantroom 32 Medical Gases	18/05/12				22/06/12								
			ZBP	F	ZBP-ZF-03-PL-523-131	Plantroom 32 Pipework	18/05/12				22/06/12	20/11/12	BMCE-TRANSMIT-012349 (BMCE-WTRAN-004622)	11/12/12	03/12/12	B	06/12/12 BMCE-TRANSMIT-012782		
			ZBP	F	ZBP-ZF-03-PL-523-132	Plantroom 32 Pipework	18/05/12		A		22/06/12	12/07/12	BMCE-TRANSMIT-009795 (BMCE-WTRAN-003481)	02/08/12	10/09/12	A	20/09/12 BMCE-TRANSMIT-011948		
		Issued for information on BMCE-TRANSMIT-019224 28/01/2014	ZBP	F	ZBP-ZF-03-PL-524-130	Plantroom 31 Ventilation			A			20/12/12	BMCE-TRANSMIT-013094 (BMCE-WTRAN-005233)	10/01/13	21/01/13	B	28/01/13 BMCE-TRANSMIT-013583		
		Issued for information on BMCE-TRANSMIT-019136 21/01/14	ZBP	F	ZBP-ZF-03-PL-524-131	Plantroom 32 Ventilation	18/05/12		C		22/06/12	14/12/12	BMCE-TRANSMIT-012844 (BMCE-WTRAN-005111)	04/01/13	04/01/13	B	16/01/13 BMCE-TRANSMIT-013364		
		Issued for information on BMCE-TRANSMIT-019136 21/01/14	ZBP	F	ZBP-ZF-03-PL-524-132	Plantroom 32 Ventilation	18/05/12		A		22/06/12	14/12/12	BMCE-TRANSMIT-012844 (BMCE-WTRAN-005111)	04/01/13	04/01/13	B	16/01/13 BMCE-TRANSMIT-013364		
			ZBP	F	ZBP-ZF-02-SE-590-001	Plantroom 22 Sections 1			A			22/04/13	BMCE-TRANSMIT-015248 (BMCE-WTRAN-007110)	13/05/13	13/05/13	A	20/05/13 BMCE-TRANSMIT-015767		
			ZBP	F	ZBP-ZF-03-SE-590-001	Plantroom 32 Sections 1			A			14/12/12	BMCE-TRANSMIT-012896 (BMCE-WTRAN-005140)	04/01/13	04/01/13	B	16/01/13 BMCE-TRANSMIT-013342		
		This drawing is a duplicate see cell 1854	ZBP	F	ZBP-ZF-12-SE-590-001	Plantroom 122 Sections 1								-					
	Electrical Services Drawings		ZBP	F	ZBP-ZF-03-PL-532-131	Plantroom 32 LV Power	18/05/12		A		22/06/12	09/07/12	BMCE-TRANSMIT-009725 (BMCE-WTRAN-003451)	30/07/12	07/08/12	A	20/08/12 BMCE-TRANSMIT-010400		
		REMOVED BY ZBP	ZBP	F	ZBP-ZF-03-PL-532-132	Plantroom 32 LV Power	18/05/12				22/06/12			-					
		REMOVED BY ZBP	ZBP	F	ZBP-ZF-03-PL-500-131	Plantroom 32 Water Services	18/05/12				22/06/12			-					
		REMOVED BY ZBP	ZBP	F	ZBP-ZF-03-PL-500-132	Plantroom 32 Water Services	18/05/12				22/06/12			-					

			Action By	Zone	Drawing Number	Drawing Title	Date Required from Consultant	Date Submitted by Consultant	Document Revision	Planned Date to be Submitted to Board	Date Submitted to Board	BMCE Transmittal No	Date Response Required from Board	Date Returned from Board	Board Status	Date returned to Consultant	Date Required from Consultant	Date Submitted by Consultant		
Item	Submission	Comments																		
			ZBP	F	ZBP-XX-XX-SC-525-536	Secondary Chilled Water Distribution Schematic Plantroom 32 & 33	01/06/12		A	27/04/12	22/06/12	BMCE-TRANSMIT-009470 (BMCE-WTRAN-003316) REISSUED IN COLOUR	13/07/12	10/09/12	A	05/10/12 BMCE-TRANSMIT-011381				
Electrical Services Drawings			ZBP	F	ZBP-XX-XX-SC-532-031	Low Voltage Schematic - Substation 3A	18/05/12		A	27/04/12	27/06/12	BMCE-TRANSMIT-009536 (BMCE-WTRAN-003343)	18/07/12	13/07/12	B	01/08/12 BMCE-TRANSMIT-010095				
		REMOVED BY ZBP	ZBP	F	ZBP-XX-XX-SC-532-032	Low Voltage Schematic - Substation 3B	18/05/12			27/04/12	27/06/12		18/07/12							
Public Health Schematics		Issued for information on BMCE-TRANSMIT-019224 28/01/2014	ZBP	F	ZBP-XX-XX-SC-500-032	Domestic Water Services Schematic Plantroom 32	18/05/12		A	27/04/12	12/10/12	BMCE-TRANSMIT-011554 (BMCE-WTRAN-004207)	02/11/12	23/10/12	B	14/11/12 BMCE-TRANSMIT-012297				
		REMOVED BY ZBP	ZBP	F	ZBP-XX-XX-SC-500-001	Adult Renal Water Schematic	18/05/12			27/04/12			21/01/09							
	Plantroom-122	DUPLICATE ON RDD SCHEDULE	ZBP	F	ZBP-ZF-12-PL-523-171	Plantroom-122 HTG & CHW	21/08/12				06/10/12		21/01/00							
		DUPLICATE ON RDD SCHEDULE	ZBP	F	ZBP-ZF-12-PL-523-172	Plantroom-122 HTG & CHW	21/08/12				06/10/12		21/01/00							
		DUPLICATE ON RDD SCHEDULE	ZBP	F	ZBP-ZF-12-PL-524-171	Plantroom-122 Ventilation	21/08/12				06/10/12		21/01/00							
		DUPLICATE ON RDD SCHEDULE	ZBP	F	ZBP-ZF-12-PL-524-172	Plantroom-122 Ventilation	21/08/12				06/10/12		21/01/00							
Electrical Services Drawings			ZBP	F	ZBP-ZF-12-PL-532-171	Plantroom 122 LV Power	31/08/12		A	05/10/12	05/06/13	BMCE-TRANSMIT-0016119 (BMCE-WTRAN-007793)	26/06/13	10/07/13	A	BMCE-TRANSMIT-026829				
		REMOVED BY ZBP	ZBP	F	ZBP-ZF-12-PL-532-172	Plantroom-122 LV Power	31/08/12				06/10/12		-							
Public Health Services Drawings		REMOVED BY ZBP	ZBP	F	ZBP-ZF-12-PL-581-171	Plantroom-122 Sanitary and Rainwater Layout	21/08/12				06/10/12		21/01/00							
		REMOVED BY ZBP	ZBP	F	ZBP-ZF-12-PL-581-172	Plantroom-122 Sanitation and Rainwater Layout	21/08/12				06/10/12		-							
		REMOVED BY ZBP	ZBP	F	ZBP-ZF-12-PL-581-173	Plantroom-122 Roof Sanitary and Rainwater Layout	21/08/12				06/10/12		-							
		REMOVED BY ZBP	ZBP	F	ZBP-ZF-12-PL-581-174	Plantroom-122 Roof Sanitation and Rainwater Layout	21/08/12				06/10/12		-							
Mechanical Services Schematics			ZBP	F	ZBP-XX-XX-SC-524-911	Ventilation Schematic (PR122) - AHU 01	31/08/12			05/10/12	09/11/12	BMCE-TRANSMIT-012216 (BMCE-WTRAN-04546)	30/11/12	03/12/12	A	06/12/12 BMCE-TRANSMIT-012805				
			ZBP	F	ZBP-XX-XX-SC-524-912	Ventilation Schematic (PR122) - AHU 02	31/08/12			05/10/12	09/11/12	BMCE-TRANSMIT-012216 (BMCE-WTRAN-04546)	30/11/12	03/12/12	A	06/12/12 BMCE-TRANSMIT-012805				
			ZBP	F	ZBP-XX-XX-SC-524-913	Ventilation Schematic (PR122) - AHU 03	31/08/12			05/10/12	09/11/12	BMCE-TRANSMIT-012216 (BMCE-WTRAN-04546)	30/11/12	03/12/12	A	06/12/12 BMCE-TRANSMIT-012805				
			ZBP	F	ZBP-XX-XX-SC-524-914	Ventilation Schematic (PR122) - AHU 04	31/08/12			05/10/12	09/11/12	BMCE-TRANSMIT-012216 (BMCE-WTRAN-04546)	30/11/12	03/12/12	A	06/12/12 BMCE-TRANSMIT-012805				
			ZBP	F	ZBP-XX-XX-SC-524-915	Ventilation Schematic (PR122) - AHU 05	31/08/12			05/10/12	09/11/12	BMCE-TRANSMIT-012216 (BMCE-WTRAN-04546)	30/11/12	03/12/12	A	06/12/12 BMCE-TRANSMIT-012805				
			ZBP	F	ZBP-XX-XX-SC-524-916	Ventilation Schematic (PR122) - AHU 06	31/08/12			05/10/12	09/11/12	BMCE-TRANSMIT-012216 (BMCE-WTRAN-04546)	30/11/12	03/12/12	A	06/12/12 BMCE-TRANSMIT-012805				
			ZBP	F	ZBP-XX-XX-SC-524-917	Ventilation Schematic (PR122) - AHU 07	31/08/12			05/10/12	09/11/12	BMCE-TRANSMIT-012216 (BMCE-WTRAN-04546)	30/11/12	03/12/12	A	06/12/12 BMCE-TRANSMIT-012805				
		Issued for information on BMCE-TRANSMIT-019136 21/01/2014	ZBP	F	ZBP-XX-XX-SC-524-918	Isolation Rooms Schematic Zone F AHU 08 & 09			A		09/11/12	BMCE-TRANSMIT-012202 (BMCE-WTRAN-004540)	30/11/12	06/12/12	B	18/12/12 BMCE-TRANSMIT-012966				

Drawing Information

31 BCL-AC-XX-SH-001

1st Submission 2nd Submission

			Action By	Zone	Drawing Number	Drawing Title	Date Required from Consultant	Date Submitted by Consultant	Document Revision	Planned Date to be Submitted to Board	Date Submitted to Board	BMCE Transmittal No	Date Response Required from Board	Date Returned from Board	Board Status	Date returned to Consultant	Date Required from Consultant	Date Submitted by Consultant
Item	Submission	Comments																
			MER	F	ME-SZ-B1-PL-541-503	Basement Floor Plan - NSGH Basement Pharmacy Holding Area & FM Core M. Lighting Layout Zone F			A		06/06/12	BMCE-TRANSMIT-009244 (BMCE-WTRAN-003216)	27/06/12	11/07/12	A	16/07/12 BMCE-TRANSMIT-009862		
		Issued for infomation on BMCE-TRANSMIT-018891 18/12/13	MER	F	ME-ZF-B1-PL-541-504	Basement Floor Plan - NSGH Basement Catering. Lighting Layout Zone F			A		06/06/12	BMCE-TRANSMIT-009244 (BMCE-WTRAN-003216)	27/06/12	11/07/12	B	16/07/12 BMCE-TRANSMIT-009862		
		This was issued for information on BMCE-TRANSMIT-018726 09/12/12	MER	F	ME-ZF-01-PL-541-505	First Floor Plan NCH - Theatres, Endoscopy & Recovery Lighting Layout	23/03/12		A	27/04/12	01/05/12	BMCE-TRANSMIT-008618 (BMCE-WTRAN-002969)	22/05/12	11/07/12	B	19/07/12 BMCE-TRANSMIT-009924		
			MER	F	ME-SZ-00-PL-541-501	Ground Floor Plan - NSGH Main Entrance & Public Areas - Lighting Layout	23/03/12		F	27/04/12	01/05/12	BMCE-TRANSMIT-008618 (BMCE-WTRAN-002969)	22/05/12	11/07/12	A	19/07/12 BMCE-TRANSMIT-009924		
			MER	F	ME-SZ-00-PL-541-502	Ground Floor Plan - NSGH Main Entrance & Public Areas - Lighting Layout	23/03/12		F	27/04/12	01/05/12	BMCE-TRANSMIT-008618 (BMCE-WTRAN-002969)	22/05/12	11/07/12	A	19/07/12 BMCE-TRANSMIT-009924		
			MER	F	ME-SZ-00-PL-541-507	Ground Floor Plan - NSGH Main Entrance & Public Areas - Lighting Layout	23/03/12		F	27/04/12	01/05/12	BMCE-TRANSMIT-008618 (BMCE-WTRAN-002969)	22/05/12	11/07/12	A	19/07/12 BMCE-TRANSMIT-009924		
					ME-SZ-01-PL-541-501	First Floor Plan - NSGH Level 1 - Restaurant Dining & Servery - Lighting Layout	24/03/12				01/05/12	BMCE-TRANSMIT-008618 (BMCE-WTRAN-002969)	22/05/12	11/07/12	A	19/07/12 BMCE-TRANSMIT-009924		
			MER	F	ME-SZ-01-PL-541-506	First Floor Plan NCH - Theatres, Endoscopy & Recovery Lighting Layout	23/03/12		C	27/04/12	01/05/12	BMCE-TRANSMIT-008618 (BMCE-WTRAN-002969)	22/05/12	11/07/12	A	19/07/12 BMCE-TRANSMIT-009924		
		This was issued for information on BMCE-TRANSMIT-018592 26/11/13	MER	F	ME-ZF-01-PL-541-507	First Floor Plan NCH - Theatres, Endoscopy & Recovery Lighting Layout	23/03/12		C	27/04/12	01/05/12	BMCE-TRANSMIT-008618 (BMCE-WTRAN-002969)	22/05/12	11/07/12	B	19/07/12 BMCE-TRANSMIT-009924		
			MER	F	ME-ZF-02-PL-541-505	Second Floor Plan NSGH Dermatology Ward Lighting Layout	23/03/12		A	27/04/12	01/05/12	BMCE-TRANSMIT-008618 (BMCE-WTRAN-002969)	22/05/12	11/07/12	A	19/07/12 BMCE-TRANSMIT-009924		
			MER	F	ME-ZF-02-PL-541-506	Second Floor Plan NSGH Dermatology Ward Lighting Layout	23/03/12		A	27/04/12	01/05/12	BMCE-TRANSMIT-008618 (BMCE-WTRAN-002969)	22/05/12	11/07/12	A	19/07/12 BMCE-TRANSMIT-009924		
			MER	F	ME-ZF-02-PL-541-507	Second Floor Plan NSGH Endoscopy Lighting Layout	23/03/12		A	27/04/12	01/05/12	BMCE-TRANSMIT-008618 (BMCE-WTRAN-002969)	22/05/12	11/07/12	A	19/07/12 BMCE-TRANSMIT-009924		
		REMOVED BY MERCURY - DRAWING DOES NOT EXIST	MER	F	ME-ZF-03-PL-541-504	Third Floor Plan NSCHNCH Staff Change/Hotel Ser-ices/ Staff Accomedation Lighting Layout	23/03/12			27/04/12			-					
		REMOVED BY MERCURY - DRAWING DOES NOT EXIST	MER	F	ME-ZF-04-PL-541-512	Fourth Floor Plan NSGH Renal Patients & Day Unit Lighting Layout	16/03/12			03/05/12			-					
		REMOVED BY MERCURY - DRAWING DOES NOT EXIST	MER	F	ME-ZF-04-PL-541-513	Fourth Floor Plan NSGH Haemato-Oncology Lighting Layout	16/03/12			03/05/12			-					
		REMOVED BY MERCURY - DRAWING DOES NOT EXIST	MER	F	ME-ZF-04-PL-541-514	Fourth Floor Plan NSGH Haemato-Oncology Lighting Layout	16/03/12			03/05/12			-					
		REMOVED BY MERCURY - DRAWING DOES NOT EXIST	MER	F	ME-ZF-05-PL-541-512	Fifth Floor Plan NSGH Inpatient Wards Lighting Layout	16/03/12			03/05/12			-					
		REMOVED BY MERCURY - DRAWING DOES NOT EXIST	MER	F	ME-ZF-05-PL-541-513	Fifth Floor Plan NSGH Inpatient Wards Lighting Layout	16/03/12			03/05/12			-					
		REMOVED BY MERCURY - DRAWING DOES NOT EXIST	MER	F	ME-ZF-05-PL-541-514	Fifth Floor Plan NSGH Inpatient Wards Lighting Layout	16/03/12			03/05/12			-					
		REMOVED BY MERCURY - DRAWING DOES NOT EXIST	MER	F	ME-ZF-06-PL-541-514	Eleventh Floor Plan NSGH Inpatient Wards Lighting Layout	23/03/12			27/04/12			-					
		REMOVED BY MERCURY - DRAWING DOES NOT EXIST	MER	F	ME-ZF-B1-PL-541-514	Eleventh Floor Plan NSGH Inpatient Wards Lighting Layout	23/03/12			27/04/12			-					
		Issued for information on BMCE-TRANSMIT-019288 04/02/14	MER	F	ME-ZF-02-PL-541-101	Second Floor Plan - Plant Lighting Layout	23/03/12		A	27/04/12	01/05/12	BMCE-TRANSMIT-008618 (BMCE-WTRAN-002969)	22/05/12	11/07/12	B	19/07/12 BMCE-TRANSMIT-009924		
			MER	F	ME-ZF-02-PL-541-102	Second Floor Plan - Plant Lighting Layout	23/03/12		A	27/04/12	01/05/12	BMCE-TRANSMIT-008618 (BMCE-WTRAN-002969)	22/05/12	11/07/12	A	19/07/12 BMCE-TRANSMIT-009924		
			MER	F	ME-ZF-02-PL-541-103	Second Floor Plan - Plant Lighting Layout	16/03/12		A	03/05/12	01/05/12	BMCE-TRANSMIT-008618 (BMCE-WTRAN-002969)	22/05/12	11/07/12	A	19/07/12 BMCE-TRANSMIT-009924		
			MER	F	ME-ZF-03-PL-541-101	Third Floor Plan - Plant Lighting Layout	16/03/12		A	03/05/12	01/05/12	BMCE-TRANSMIT-008618 (BMCE-WTRAN-002969)	22/05/12	11/07/12	A	19/07/12 BMCE-TRANSMIT-009924		
			MER	F	ME-ZF-03-PL-541-102	Third Floor Plan - Plant Lighting Layout	16/03/12		A	03/05/12	01/05/12	BMCE-TRANSMIT-008618 (BMCE-WTRAN-002969)	22/05/12	11/07/12	A	19/07/12 BMCE-TRANSMIT-009924		
			MER	F	ME-ZF-03-PL-541-502	Third Floor Plan - NSGH/NCH Admin, Training, Health Records & Staff Facilities	16/03/12		A	03/05/12	01/05/12	BMCE-TRANSMIT-008618 (BMCE-WTRAN-002969)	22/05/12	11/07/12	A	19/07/12 BMCE-TRANSMIT-009924		
		This was issued for information on BMCE-TRANSMIT-018726 09/12/12	MER	F	ME-ZF-04-PL-541-503	Fourth Floor Plan - NSGH Renal Inpatients & Day Unit Lighting layout	16/03/12		A	03/05/12	17/05/12	BMCE-TRANSMIT-008898 (BMCE-WTRAN-003083)	07/06/12	11/06/12	B	18/06/12 BMCE-TRANSMIT-009387		
		This was issued for information on BMCE-TRANSMIT-018726 09/12/12	MER	F	ME-ZF-04-PL-541-504	Fourth Floor Plan - NSGH Renal Inpatients & Day Unit Lighting layout	16/03/12		A	03/05/12	17/05/12	BMCE-TRANSMIT-008898 (BMCE-WTRAN-003083)	07/06/12	11/06/12	B	18/06/12 BMCE-TRANSMIT-009387		
		This was issued for information on BMCE-TRANSMIT-018726 09/12/12	MER	F	ME-ZF-04-PL-541-505	Fourth Floor Plan - NSGH Renal Inpatients & Day Unit Lighting layout	16/03/12		A	03/05/12	17/05/12	BMCE-TRANSMIT-008898 (BMCE-WTRAN-003083)	07/06/12	11/06/12	B	18/06/12 BMCE-TRANSMIT-009387		
		This was issued for information on BMCE-TRANSMIT-018726 09/12/12	MER	F	ME-ZF-05-PL-541-503	Fifth Floor Plan - NSGH Inpatient Ward Lighting layout	16/03/12		A	03/05/12	17/05/12	BMCE-TRANSMIT-008898 (BMCE-WTRAN-003083)	07/06/12	11/06/12	B	18/06/12 BMCE-TRANSMIT-009387		

Drawing Information

31 BCL-AC-XX-SH-001

1st Submission2nd Submission

Item	Submission	Comments	Action By Zone		Drawing Number	Drawing Title	Date Required from Consultant	Date Submitted by Consultant	Document Revision	Planned Date to be Submitted to Board	Date Submitted to Board	BMCE Transmittal No	Date Response Required from Board	Date Returned from Board	Board Status	Date returned to Consultant	Date Required from Consultant	Date Submitted by Consultant
		REMOVED BY MERCURY - ME-ZF-XX-PL-541-503 SUBMITTED FOR RDD REVIEW	MER	F	ME-ZF-10-PL-541-503	Tenth Floor Plan - NSGH - Inpatient Ward Lighting layout	16/03/12			03/05/12			-					
		REMOVED BY MERCURY - ME-ZF-XX-PL-541-504 SUBMITTED FOR RDD REVIEW	MER	F	ME-ZF-10-PL-541-504	Tenth Floor Plan - NSGH - Inpatient Ward Lighting layout	16/03/12			03/05/12			-					
		REMOVED BY MERCURY - ME-ZF-XX-PL-541-505 SUBMITTED FOR RDD REVIEW	MER	F	ME-ZF-10-PL-541-505	Tenth Floor Plan - NSGH - Inpatient Ward Lighting layout	16/03/12			03/05/12			-					
		REMOVED BY MERCURY - DRAWING DOES NOT EXIST	MER	F	ME-ZF-06-PL-541-514	Eleventh Floor Plan - NSGH - Inpatient Ward Lighting layout	16/03/12			03/05/12								
		REMOVED BY MERCURY - DRAWING DOES NOT EXIST	MER	F	ME-ZF-B1-PL-541-514	Eleventh Floor Plan - NSGH - Inpatient Ward Lighting layout	16/03/12			03/05/12								
		REMOVED BY MERCURY - ME-ZF-XX-PL-541-503 SUBMITTED FOR RDD REVIEW	MER	F	ME-ZF-11-PL-541-503	Eleventh Floor Plan - NSGH - Inpatient Ward Lighting layout	16/03/12			03/05/12			-					
		REMOVED BY MERCURY - ME-ZF-XX-PL-541-504 SUBMITTED FOR RDD REVIEW	MER	F	ME-ZF-11-PL-541-504	Eleventh Floor Plan - NSGH - Inpatient Ward Lighting layout	16/03/12			03/05/12			-					
		REMOVED BY MERCURY - ME-ZF-XX-PL-541-505 SUBMITTED FOR RDD REVIEW	MER	F	ME-ZF-11-PL-541-505	Eleventh Floor Plan - NSGH - Inpatient Ward Lighting layout	16/03/12			03/05/12			-					
		TO BE ISSUED FOR REVIEW	MER	F	ME-ZF-12-PL-541-503	Twelfth Floor Plan - NSGH - Inpatient Ward Lighting layout	16/03/12			03/05/12			-					
		TO BE ISSUED FOR REVIEW	MER	F	ME-ZF-12-PL-541-504	Twelfth Floor Plan - NSGH - Inpatient Ward Lighting layout	16/03/12			03/05/12			-					
		TO BE ISSUED FOR REVIEW	MER	F	ME-ZF-12-PL-541-505	Twelfth Floor Plan - NSGH - Inpatient Ward Lighting layout	16/03/12			03/05/12			-					
		This was issued for information on BMCE-TRANSMIT-018726 09/12/12	MER	F	ME-ZF-XX-PL-541-503	Sixth to Eleventh Floor Plan - NSGH Inpatient Ward - Lighting Layout Zone F			A		17/05/12	BMCE-TRANSMIT-008898 (BMCE-WTRAN-003083)	07/06/12	11/06/12	B	18/06/12 BMCE-TRANSMIT-009387		
		This was issued for information on BMCE-TRANSMIT-018726 09/12/12	MER	F	ME-ZF-XX-PL-541-504	Sixth to Eleventh Floor Plan - NSGH Inpatient Ward - Lighting Layout Zone F			A		17/05/12	BMCE-TRANSMIT-008898 (BMCE-WTRAN-003083)	07/06/12	11/06/12	B	18/06/12 BMCE-TRANSMIT-009387		
		This was issued for information on BMCE-TRANSMIT-018726 09/12/12	MER	F	ME-ZF-XX-PL-541-505	Sixth to Eleventh Floor Plan - NSGH Inpatient Ward - Lighting Layout Zone F			A		17/05/12	BMCE-TRANSMIT-008898 (BMCE-WTRAN-003083)	07/06/12	11/06/12	B	18/06/12 BMCE-TRANSMIT-009387		
		REMOVED BY MERCURY - DUPLICATE	MER	F	ME-XX-XX-SP-541-101	Lighting Schedule - Zone F	23/03/12			27/04/12								
		REMOVED BY MERCURY - WRONG DRAWING NO.	MER	F	ME-XX-XX-SP-541-100	Lighting Calculations - Zone F	23/03/12			27/04/12			-					
	Small Power	Removed By Mercury - NOT REQUIRED FOR RDD (SMALL POWER SHOWN ON NA 400 SERIES DRAWINGS)	MER	F	ME-ZF-00-PL-531-507	Ground Floor Plan NSGH/NCH - Pharmacy/Dispensary Small Power & General Services Layout	23/03/12			27/04/12			-					
		Removed By Mercury - NOT REQUIRED FOR RDD (SMALL POWER SHOWN ON NA 400 SERIES DRAWINGS)	MER	F	ME-ZF-00-PL-531-508	Ground Floor Plan NCH Rehabilitation Suite & Therapies Small Power & General Services Layout	23/03/12			27/04/12			-					
		Removed By Mercury - NOT REQUIRED FOR RDD (SMALL POWER SHOWN ON NA 400 SERIES DRAWINGS)	MER	F	ME-ZF-01-PL-531-505	First Floor Plan NCH - Theatres, Endoscopy & Recovery Small Power & General Services Layout	23/03/12			27/04/12			-					
		Removed By Mercury - NOT REQUIRED FOR RDD (SMALL POWER SHOWN ON NA 400 SERIES DRAWINGS)	MER	F	ME-ZF-01-PL-531-507	First Floor Plan NCH - Theatres, Endoscopy & Recovery Small Power & General Services Layout	23/03/12			27/04/12			-					
		Removed By Mercury - NOT REQUIRED FOR RDD (SMALL POWER SHOWN ON NA 400 SERIES DRAWINGS)	MER	F	ME-ZF-02-PL-531-505	Second Floor Plan NSGH Dermatology Ward Small Power & General Services Layout	23/03/12			27/04/12			-					
		Removed By Mercury - NOT REQUIRED FOR RDD (SMALL POWER SHOWN ON NA 400 SERIES DRAWINGS)	MER	F	ME-ZF-02-PL-531-506	Second Floor Plan NSGH Dermatology Ward Small Power & General Services Layout	23/03/12			27/04/12			-					
		Removed By Mercury - NOT REQUIRED FOR RDD (SMALL POWER SHOWN ON NA 400 SERIES DRAWINGS)	MER	F	ME-ZF-02-PL-531-507	Second Floor Plan NSGH Endoscopy Small Power & General Services Layout	23/03/12			27/04/12			-					
		Removed By Mercury - NOT REQUIRED FOR RDD (SMALL POWER SHOWN ON NA 400 SERIES DRAWINGS)	MER	F	ME-ZF-03-PL-531-504	Third Floor Plan NSGH/NCH Staff Change/Hotel Services Staff Accommodation Small Power & General Services Layout	23/03/12			27/04/12			-					
		Removed By Mercury - NOT REQUIRED FOR RDD (SMALL POWER SHOWN ON NA 400 SERIES DRAWINGS)	MER	F	ME-ZF-04-PL-531-512	Fourth Floor Plan NSGH Renal Patients & Day Unit Small Power & General Services Layout	16/03/12			31/05/12			-					
		Removed By Mercury - NOT REQUIRED FOR RDD (SMALL POWER SHOWN ON NA 400 SERIES DRAWINGS)	MER	F	ME-ZF-04-PL-531-513	Fourth Floor Plan NSGH Haemato-Oncology Small Power & General Services Layout	16/03/12			31/05/12			-					
		Removed By Mercury - NOT REQUIRED FOR RDD (SMALL POWER SHOWN ON NA 400 SERIES DRAWINGS)	MER	F	ME-ZF-04-PL-531-514	Fourth Floor Plan NSGH Haemato-Oncology Small Power & General Services Layout	16/03/12			03/05/12			-					
		Removed By Mercury - NOT REQUIRED FOR RDD (SMALL POWER SHOWN ON NA 400 SERIES DRAWINGS)	MER	F	ME-ZF-05-PL-531-512	Fifth Floor Plan NSGH Inpatient Wards Small Power & General Services Layout	16/03/12			03/05/12			-					
		Removed By Mercury - NOT REQUIRED FOR RDD (SMALL POWER SHOWN ON NA 400 SERIES DRAWINGS)	MER	F	ME-ZF-05-PL-531-513	Fifth Floor Plan NSGH Inpatient Wards Small Power & General Services Layout	16/03/12			03/05/12			-					

			Action By	Zone	Drawing Number	Drawing Title	Date Required from Consultant	Date Submitted by Consultant	Document Revision	Planned Date to be Submitted to Board	Date Submitted to Board	BMCE Transmittal No	Date Response Required from Board	Date Returned from Board	Board Status	Date returned to Consultant	Date Required from Consultant	Date Submitted by Consultant
Item	Submission	Comments																
	High Level Layout	Removed By Mercury - NOT REQUIRED FOR RDD (SMALL POWER SHOWN ON NA 400 SERIES DRAWINGS)	MER	F	ME-ZF-00-PL-532-507	Ground Floor Plan NSGHINCH - Pharmacy Dispensary High Le-el Layout	23/03/12				27/04/12		-					
		Removed By Mercury - NOT REQUIRED FOR RDD (SMALL POWER SHOWN ON NA 400 SERIES DRAWINGS)	MER	F	ME-ZF-00-PL-532-508	Ground Floor Plan NCH Rehabilitation Suite & Therapies High Le-el Layout	23/03/12				27/04/12		-					
		Removed By Mercury - NOT REQUIRED FOR RDD (SMALL POWER SHOWN ON NA 400 SERIES DRAWINGS)	MER	F	ME-ZF-01-PL-532-505	First Floor Plan NCH - Theatre, Endoscopy & Recovery High Level Layout	23/03/12				27/04/12		-					
		Removed By Mercury - NOT REQUIRED FOR RDD (SMALL POWER SHOWN ON NA 400 SERIES DRAWINGS)	MER	F	ME-ZF-01-PL-532-507	First Floor Plan NCH - Theatre, Endoscopy & Recovery High Le-el Layout	23/03/12				27/04/12		-					
		Removed By Mercury - NOT REQUIRED FOR RDD (SMALL POWER SHOWN ON NA 400 SERIES DRAWINGS)	MER	F	ME-ZF-02-PL-532-505	Second Floor Plan NSGH Dermatology Ward High Le-el Layout	23/03/12				27/04/12		-					
		Removed By Mercury - NOT REQUIRED FOR RDD (SMALL POWER SHOWN ON NA 400 SERIES DRAWINGS)	MER	F	ME-ZF-02-PL-532-506	Second Floor Plan NSGH Dermatology Ward High Level Layout	23/03/12				27/04/12		-					
		Removed By Mercury - NOT REQUIRED FOR RDD (SMALL POWER SHOWN ON NA 400 SERIES DRAWINGS)	MER	F	ME-ZF-02-PL-532-507	Second Floor Plan NSGH Endoscopy High Le-el Layout	23/03/12				27/04/12		-					
		Removed By Mercury - NOT REQUIRED FOR RDD (SMALL POWER SHOWN ON NA 400 SERIES DRAWINGS)	MER	F	ME-ZF-03-PL-532-504	Third Floor Plan NSGHINCH Staff Change/Hotel Services/Staff Accomodation High Le-el Layout	23/03/12				27/04/12		-					
		Removed By Mercury - NOT REQUIRED FOR RDD (SMALL POWER SHOWN ON NA 400 SERIES DRAWINGS)	MER	F	ME-ZF-04-PL-532-512	Fourth Floor Plan NSGH Renal Patients & Day Unit High Le-el Layout	16/03/12				03/05/12		-					
		Removed By Mercury - NOT REQUIRED FOR RDD (SMALL POWER SHOWN ON NA 400 SERIES DRAWINGS)	MER	F	ME-ZF-04-PL-532-513	Fourth Floor Plan NSGH Haemato-Oncology High Level Layout	16/03/12				03/05/12		-					
		Removed By Mercury - NOT REQUIRED FOR RDD (SMALL POWER SHOWN ON NA 400 SERIES DRAWINGS)	MER	F	ME-ZF-04-PL-532-514	Fourth Floor Plan NSGH Haemato Oncology High Le-el Layout	16/03/12				03/05/12		-					
		Removed By Mercury - NOT REQUIRED FOR RDD (SMALL POWER SHOWN ON NA 400 SERIES DRAWINGS)	MER	F	ME-ZF-05-PL-532-512	Fifth Floor Plan NSGH Inpatient Wards High Le-el Layout	16/03/12				03/05/12		-					
		Removed By Mercury - NOT REQUIRED FOR RDD (SMALL POWER SHOWN ON NA 400 SERIES DRAWINGS)	MER	F	ME-ZF-05-PL-532-513	Fifth Floor Plan NSGH Inpatient Wards High Level Layout	16/03/12				03/05/12		-					
		Removed By Mercury - NOT REQUIRED FOR RDD (SMALL POWER SHOWN ON NA 400 SERIES DRAWINGS)	MER	F	ME-ZF-05-PL-532-514	Fifth Floor Plan NSGH Inpatient Wards High Le-el Layout	16/03/12				03/05/12		-					
		Removed By Mercury - NOT REQUIRED FOR RDD (SMALL POWER SHOWN ON NA 400 SERIES DRAWINGS)	MER	F	ME-ZF-06-PL-532-514	Eleventh Floor Plan NSGH Inpatient Wards High Le-el Layout	23/03/12				27/04/12		-					
		Removed By Mercury - NOT REQUIRED FOR RDD (SMALL POWER SHOWN ON NA 400 SERIES DRAWINGS)	MER	F	ME-ZF-B1-PL-532-514	Eleventh Floor Plan NSGH Inpatient Wards High Le-el Layout	23/03/12				27/04/12		-					
	Low Level Layout	Removed By Mercury - NOT REQUIRED FOR RDD (SMALL POWER SHOWN ON NA 400 SERIES DRAWINGS)	MER	F	ME-ZF-00-PL-532-507	Ground Floor Plan NSGHINCH - Pharmacy Dispensary ELV Systems low le-el Layout	23/03/12				27/04/12		-					
		Removed By Mercury - NOT REQUIRED FOR RDD (SMALL POWER SHOWN ON NA 400 SERIES DRAWINGS)	MER	F	ME-ZF-00-PL-532-508	Ground Floor Plan NCH Rehabilitation Suite & Therapies ELV Systems low le-el Layout	23/03/12				27/04/12		-					
		Removed By Mercury - NOT REQUIRED FOR RDD (SMALL POWER SHOWN ON NA 400 SERIES DRAWINGS)	MER	F	ME-ZF-01-PL-532-505	First Floor Plan NCH - Theatre, Endoscopy & Recovery ELV Systems low level Layout	23/03/12				27/04/12		-					
		Removed By Mercury - NOT REQUIRED FOR RDD (SMALL POWER SHOWN ON NA 400 SERIES DRAWINGS)	MER	F	ME-ZF-01-PL-532-507	First Floor Plan NCH - Theatre, Endoscopy & Recovery ELV Systems low le-el Layout	23/03/12				27/04/12		-					
		Removed By Mercury - NOT REQUIRED FOR RDD (SMALL POWER SHOWN ON NA 400 SERIES DRAWINGS)	MER	F	ME-ZF-02-PL-532-505	Second Floor Plan NSGH Dermatology Ward ELV Systems low le-el Layout	23/03/12				27/04/12		-					
		Removed By Mercury - NOT REQUIRED FOR RDD (SMALL POWER SHOWN ON NA 400 SERIES DRAWINGS)	MER	F	ME-ZF-02-PL-532-506	Second Floor Plan NSGH Dermatology Ward ELV Systems low le-el Layout	23/03/12				27/04/12		-					
		Removed By Mercury - NOT REQUIRED FOR RDD (SMALL POWER SHOWN ON NA 400 SERIES DRAWINGS)	MER	F	ME-ZF-02-PL-532-507	Second Floor Plan NSGH Endoscopy ELV Systems low level Layout	23/03/12				27/04/12		-					
		Removed By Mercury - NOT REQUIRED FOR RDD (SMALL POWER SHOWN ON NA 400 SERIES DRAWINGS)	MER	F	ME-ZF-03-PL-532-504	Third Floor Plan NSGHINCH Staff Change/Hotel Services/Staff Accomodation ELV Systems low le-el Layout	23/03/12				27/04/12		-					
		Removed By Mercury - NOT REQUIRED FOR RDD (SMALL POWER SHOWN ON NA 400 SERIES DRAWINGS)	MER	F	ME-ZF-04-PL-532-512	Fourth Floor Plan NSGH Renal Patients & Day Unit ELV Systems low le-el Layout	16/03/12				03/05/12		-					
		Removed By Mercury - NOT REQUIRED FOR RDD (SMALL POWER SHOWN ON NA 400 SERIES DRAWINGS)	MER	F	ME-ZF-04-PL-532-513	Fourth Floor Plan NSGH Haemato Oncology ELV Systems low le-el Layout	16/03/12				03/05/12		-					
		Removed By Mercury - NOT REQUIRED FOR RDD (SMALL POWER SHOWN ON NA 400 SERIES DRAWINGS)	MER	F	ME-ZF-04-PL-532-514	Fourth Floor Plan NSGH Haemato Oncology ELV Systems low level Layout	16/03/12				03/05/12		-					
		Removed By Mercury - NOT REQUIRED FOR RDD (SMALL POWER SHOWN ON NA 400 SERIES DRAWINGS)	MER	F	ME-ZF-05-PL-532-512	Fifth Floor Plan NSGH Inpatient Wards ELV Systems low le-el Layout	16/03/12				03/05/12		-					
		Removed By Mercury - NOT REQUIRED FOR RDD (SMALL POWER SHOWN ON NA 400 SERIES DRAWINGS)	MER	F	ME-ZF-05-PL-532-513	Fifth Floor Plan NSGH Inpatient Wards ELV Systems low le-el Layout	16/03/12				03/05/12		-					
		Removed By Mercury - NOT REQUIRED FOR RDD (SMALL POWER SHOWN ON NA 400 SERIES DRAWINGS)	MER	F	ME-ZF-05-PL-532-514	Fifth Floor Plan NSGH Inpatient Wards ELV Systems low level Layout	16/03/12				03/05/12		-					

Drawing Information

31 BCL-AC-XX-SH-001

1st Submission2nd Submission

			Action By	Zone	Drawing Number	Drawing Title	Date Required from Consultant	Date Submitted by Consultant	Document Revision	Planned Date to be Submitted to Board	Date Submitted to Board	BMCE Transmittal No	Date Response Required from Board	Date Returned from Board	Board Status	Date returned to Consultant	Date Required from Consultant	Date Submitted by Consultant
Item	Submission	Comments																
			MER	F	ME-ZF-00-PL-556-508	Ground Floor Plan NCH Rehabilitation Suite & Therapies Data Comms Layout	23/03/12		A	27/04/12	30/04/12	BMCE-TRANSMIT-008611 (BMCE-WTRAN-002966)	21/05/12	10/07/12	A	18/07/12 BMCE-TRANSMIT-009905		
		This was issued for information on BMCE-TRANSMIT-018726 09/12/12	MER	F	ME-ZF-01-PL-556-505	First Floor Plan NCH - Theatres, Endoscopy & Recovery Data Comms Layout	23/03/12		A	27/04/12	30/04/12	BMCE-TRANSMIT-008611 (BMCE-WTRAN-002966)	21/05/12	10/07/12	B	18/07/12 BMCE-TRANSMIT-009905		
		This was issued for information on BMCE-TRANSMIT-018592 28/11/13	MER	F	ME-ZF-01-PL-556-507	First Floor Plan NCH - Theatres, Endoscopy & Recovery Data Comms Layout	23/03/12		C	27/04/12	30/04/12	BMCE-TRANSMIT-008611 (BMCE-WTRAN-002966)	21/05/12	10/07/12	B	18/07/12 BMCE-TRANSMIT-009905		
		This was issued for information on BMCE-TRANSMIT-018726 09/12/12	MER	F	ME-ZF-02-PL-556-505	Second Floor Plan NSGH Dermatology Ward Data Comms Layout	23/03/12		A	27/04/12	30/04/12	BMCE-TRANSMIT-008611 (BMCE-WTRAN-002966)	21/05/12	10/07/12	B	18/07/12 BMCE-TRANSMIT-009905		
		This was issued for information on BMCE-TRANSMIT-018726 09/12/12	MER	F	ME-ZF-02-PL-556-506	Second Floor Plan NSGH Dermatology Ward Data Comms Layout	23/03/12		A	27/04/12	30/04/12	BMCE-TRANSMIT-008611 (BMCE-WTRAN-002966)	21/05/12	10/07/12	B	18/07/12 BMCE-TRANSMIT-009905		
		This was issued for information on BMCE-TRANSMIT-018726 09/12/12	MER	F	ME-ZF-02-PL-556-507	Second Floor Plan NSGH Endoscopy Data Comms Layout	23/03/12		A	27/04/12	30/04/12	BMCE-TRANSMIT-008611 (BMCE-WTRAN-002966)	21/05/12	10/07/12	B	18/07/12 BMCE-TRANSMIT-009905		
		REMOVED BY MERCURY - DRAWING DOES NOT EXIST	MER	F	ME-ZF-03-PL-556-504	Third Floor Plan NSGHINCH Staff Change/Hotel Services/ Staff Accomodation Data Comms Layout	23/03/12			27/04/12			-					
			MER	F	ME-ZF-03-PL-556-502	Third Floor Plan - NSGHINCH Admin, Training, Health Records & Staff Facilities, Data Comms Layout	23/03/12		A	27/04/12	30/04/12	BMCE-TRANSMIT-008611 (BMCE-WTRAN-002966)	21/05/12	10/07/12	A	18/07/12 BMCE-TRANSMIT-009905		
			MER	F	ME-ZF-04-PL-556-503	Fourth Floor Plan NSGH Renal Patients & Day Unit Data Comms Layout	16/03/12		A	03/05/12	09/05/12	BMCE-TRANSMIT-008742 (BMCE-WTRAN-003012)	30/05/12	12/07/12	A	18/07/12 BMCE-TRANSMIT-009887		
			MER	F	ME-ZF-04-PL-556-504	Fourth Floor Plan NSGH Haemato-Oncology Data Comms Layout	16/03/12		A	03/05/12	09/05/12	BMCE-TRANSMIT-008742 (BMCE-WTRAN-003012)	30/05/12	12/07/12	A	18/07/12 BMCE-TRANSMIT-009887		
			MER	F	ME-ZF-04-PL-556-505	Fourth Floor Plan NSGH Haemato-Oncology Data Comms Layout	16/03/12		A	03/05/12	09/05/12	BMCE-TRANSMIT-008742 (BMCE-WTRAN-003012)	30/05/12	12/07/12	A	18/07/12 BMCE-TRANSMIT-009887		
			MER	F	ME-ZF-05-PL-556-503	Fifth Floor Plan NSGH Inpatient Wards Data Comms Layout	16/03/12		A	03/05/12	09/05/12	BMCE-TRANSMIT-008742 (BMCE-WTRAN-003012)	30/05/12	12/07/12	A	18/07/12 BMCE-TRANSMIT-009887		
			MER	F	ME-ZF-05-PL-556-504	Fifth Floor Plan NSGH Inpatient Wards Data Comms Layout	16/03/12		A	03/05/12	09/05/12	BMCE-TRANSMIT-008742 (BMCE-WTRAN-003012)	30/05/12	12/07/12	A	18/07/12 BMCE-TRANSMIT-009887		
			MER	F	ME-ZF-05-PL-556-505	Fifth Floor Plan NSGH Inpatient Wards Data Comms Layout	16/03/12		A	03/05/12	09/05/12	BMCE-TRANSMIT-008742 (BMCE-WTRAN-003012)	30/05/12	12/07/12	A	18/07/12 BMCE-TRANSMIT-009887		
		This was issued for information on BMCE-TRANSMIT-018726 09/12/12	MER	F	ME-ZF-XX-PL-556-503	Sixth to Eleventh Floor Plan. NSGH Inpatient Wards. Data Comms Layout			A	03/05/12	09/05/12	BMCE-TRANSMIT-008742 (BMCE-WTRAN-003012)	30/05/12	12/07/12	B	18/07/12 BMCE-TRANSMIT-009887		
			MER	F	ME-ZF-XX-PL-556-504	Sixth to Eleventh Floor Plan. NSGH Inpatient Wards. Data Comms Layout			A	03/05/12	09/05/12	BMCE-TRANSMIT-008742 (BMCE-WTRAN-003012)	30/05/12	12/07/12	A	18/07/12 BMCE-TRANSMIT-009887		
			MER	F	ME-ZF-XX-PL-556-505	Sixth to Eleventh Floor Plan. NSGH Inpatient Wards. Data Comms Layout			A	03/05/12	09/05/12	BMCE-TRANSMIT-008742 (BMCE-WTRAN-003012)	30/05/12	12/07/12	A	18/07/12 BMCE-TRANSMIT-009887		
			MER	F	ME-SZ-00-PL-556-501	Ground Floor Plan - NSGH main Entrance and Public Address Areas Data Comms layout	16/03/12		D	03/05/12	30/04/12	BMCE-TRANSMIT-008611 (BMCE-WTRAN-002966)	21/05/12	10/07/12	A	18/07/12 BMCE-TRANSMIT-009905		
		This was issued for information on BMCE-TRANSMIT-018726	MER	F	ME-SZ-00-PL-556-502	Ground Floor Plan - NSGH main Entrance and Public Address Areas Data Comms layout	16/03/12		D	03/05/12	30/04/12	BMCE-TRANSMIT-008611 (BMCE-WTRAN-002966)	21/05/12	10/07/12	B	18/07/12 BMCE-TRANSMIT-009905		
			MER	F	ME-SZ-00-PL-556-507	Ground Floor Plan - NSGH main Entrance and Public Address Areas Data Comms layout	16/03/12		A	03/05/12	30/04/12	BMCE-TRANSMIT-008611 (BMCE-WTRAN-002966)	21/05/12	10/07/12	A	18/07/12 BMCE-TRANSMIT-009905		
			MER	F	ME-SZ-01-PL-556-501	First Floor Plan - NSGH Restaurant, Dining and Servery Data Comms Layout	16/03/12		D	03/05/12	30/04/12	BMCE-TRANSMIT-008611 (BMCE-WTRAN-002966)	21/05/12	10/07/12	A	18/07/12 BMCE-TRANSMIT-009905		
			MER	F	ME-SZ-01-PL-556-506	First Floor Plan NCH Theatres, Endoscopy & Recovery Layout	16/03/12		C	03/05/12	30/04/12	BMCE-TRANSMIT-008611 (BMCE-WTRAN-002966)	21/05/12	10/07/12	A	18/07/12 BMCE-TRANSMIT-009905		
			MER	F	ME-SZ-B1-PL-556-503	Basement floor Plan - Food Waste Renal Tanks & FM Core			A		06/06/12	BMCE-TRANSMIT-009245 (BMCE-WTRAN-003217)	27/06/12	06/07/12	A	18/07/12 BMCE-TRANSMIT-009903		
			MER	F	ME-ZF-B1-PL-556-504	Basement Floor Plan NSGH Basemetn Catering Data Comms Layout	23/01/12		A	24/02/12	06/06/12	BMCE-TRANSMIT-009245 (BMCE-WTRAN-003217)	27/06/12	06/07/12	A	18/07/12 BMCE-TRANSMIT-009903		
		REMOVED BY MERCURY - DRAWING DOES NOT EXIST	MER	F	ME-ZF-04-PL-556-512	Fourth Floor Plan NSGH Renal Patients & Day Unit Data Comms Layout	16/03/12			03/05/12			-					
		REMOVED BY MERCURY - DRAWING DOES NOT EXIST	MER	F	ME-ZF-04-PL-556-513	Fourth Floor Plan NSGH Haemato-Oncology Data Comms Layout	16/03/12			03/05/12			-					
		REMOVED BY MERCURY - DRAWING DOES NOT EXIST	MER	F	ME-ZF-04-PL-556-514	Fourth Floor Plan NSGH Haemato-Oncology Data Comms Layout	16/03/12			03/05/12			-					
		REMOVED BY MERCURY - DRAWING DOES NOT EXIST	MER	F	ME-ZF-05-PL-556-512	Fifth Floor Plan NSGH Inpatient Wards Data Comms Layout	16/03/12			03/05/12			-					
		REMOVED BY MERCURY - DRAWING DOES NOT EXIST	MER	F	ME-ZF-05-PL-556-513	Fifth Floor Plan NSGH Inpatient Wards Data Comms Layout	16/03/12			03/05/12			-					
		REMOVED BY MERCURY - DRAWING DOES NOT EXIST	MER	F	ME-ZF-05-PL-556-514	Fifth Floor Plan NSGH Inpatient Wards Data Comms Layout	16/03/12			03/05/12			-					

Drawing Information

31 BCL-AC-XX-SH-001

1st Submission2nd Submission

Item	Submission	Comments	Action By		Zone	Drawing Number	Drawing Title	Date Required from Consultant	Date Submitted by Consultant	Document Revision	Planned Date to be Submitted to Board	Date Submitted to Board	BMCE Transmittal No	Date Response Required from Board	Date Returned from Board	Board Status	Date returned to Consultant	Date Required from Consultant	Date Submitted by Consultant
		Removed By Mercury - NOT REQUIRED FOR RDD (PART OF BMS DETAIL DESIGN)	MER		F	ME-ZF-05-PL-660-512	Fifth Floor Plan NSGH Inpatient Wards BMS Layout	23/03/12			27/04/12			-					
		Removed By Mercury - NOT REQUIRED FOR RDD (PART OF BMS DETAIL DESIGN)	MER		F	ME-ZF-05-PL-660-513	Fifth Floor Plan NSGH Inpatient Wards BMS Layout	23/03/12			27/04/12			-					
		Removed By Mercury - NOT REQUIRED FOR RDD (PART OF BMS DETAIL DESIGN)	MER		F	ME-ZF-05-PL-660-514	Fifth Floor Plan NSGH Inpatient Wards BMS Layout	23/03/12			27/04/12			-					
		Removed By Mercury - NOT REQUIRED FOR RDD (PART OF BMS DETAIL DESIGN)	MER		F	ME-ZF-06-PL-660-514	Ele-enth Floor Plan NSGH Inpatient Wards BMS Layout	23/03/12			27/04/12			-					
		Removed By Mercury - NOT REQUIRED FOR RDD (PART OF BMS DETAIL DESIGN)	MER		F	ME-ZF-B1-PL-660-514	Ele-enth Floor Plan NSGH Inpatient Wards BMS Layout	23/03/12			27/04/12			-					
	MEDICAL GASES	Not required for RDD Review - was issued to board for information only BMCE-TRANSMIT-017701	MER		F	ME-ZF-00-DC-H512-001	Le-el-0, Childrens Rehab (room REH-024) & Mains												
		Not required for RDD Review - was issued to board for information only BMCE-TRANSMIT-017702	MER		F	ME-ZF-01-DC-H512-001	Le-el-1, Childrens theatres from THE-122 & mains to Riser M32												
		Not required for RDD Review - was issued to board for information only BMCE-TRANSMIT-017703	MER		F	ME-ZF-01-DC-H512-002	Le-el-1, Childrens theatre post-op recovery from THE-139												
		Not required for RDD Review - was issued to board for information only BMCE-TRANSMIT-017704	MER		F	ME-ZF-02-DC-H512-001	Level 2, Dermatology ward from Room DMW-032, Mains & DOPD to Riser M25												
		Not required for RDD Review - was issued to board for information only BMCE-TRANSMIT-017705	MER		F	ME-ZF-04-DC-H512-001	Le-el-4, Renal Ward from RENW-025 to Mains												
		Not required for RDD Review - was issued to board for information only BMCE-TRANSMIT-017706	MER		F	ME-ZF-06-DC-H512-001	Le-el-6, Room GENWA-031 to Mains												
		Issued for information on BMCE-TRANSMIT-019817 31/03/14	MER		F	ME-ZF-00-PL-H512-001	Medical Gas Installation, Level 0, Zone F			1		29/05/12	BMCE-TRANSMIT-009131 (BMCE-WTRAN-003175)	19/06/12	24/09/12	C	27/09/12 BMCE-TRANSMIT-011199		
		Issued for information on BMCE-TRANSMIT-019817 31/03/14	MER		F	ME-ZF-01-PL-H512-001	Medical Gas Installation, Level 1, Zone F			1		29/05/12	BMCE-TRANSMIT-009127 (BMCE-WTRAN-003174)	19/06/12	24/09/12	C	27/09/12 BMCE-TRANSMIT-011196		
			MER		F	ME-ZF-01-PL-H512-002	Medical Gas Installation, Level 1, Zone F - AGSS			1		29/05/12	BMCE-TRANSMIT-009127 (BMCE-WTRAN-003174)	19/06/12	24/09/12	C	27/09/12 BMCE-TRANSMIT-011196		
			MER		F	ME-ZF-02-PL-H512-001	Medical Gas Installation, Level 2, Zone F			1		29/05/12	BMCE-TRANSMIT-009123 (BMCE-WTRAN-003172)	19/06/12	24/09/12	C	27/09/12 BMCE-TRANSMIT-011202		
			MER		F	ME-ZF-02-PL-H512-002	Medical Gas Installation, Level 2, Zone F - AGSS			1		29/05/12	BMCE-TRANSMIT-009123 (BMCE-WTRAN-003172)	19/06/12	24/09/12	C	27/09/12 BMCE-TRANSMIT-011202		
			MER		F	ME-ZF-04-PL-H512-001	Medical Gas Installation, Level 4, Zone F			1		29/05/12	BMCE-TRANSMIT-009122 (BMCE-WTRAN-003171)	19/06/12	01/10/12	C	04/10/12 BMCE-TRANSMIT-011124		
			MER		F	ME-ZF-05-PL-H512-001	Medical Gas Installation, Level 5, Zone F			1		29/05/12	BMCE-TRANSMIT-009111 (BMCE-WTRAN-003165)	19/06/12	01/10/12	C	04/10/2012 BMCE-TRANSMIT-		
			MER		F	ME-ZF-06-PL-H512-001	Medical Gas Installation, Level 6, Zone F			1		29/05/12	BMCE-TRANSMIT-009119 (BMCE-WTRAN-003169)	19/06/12	01/10/12	C	04/10/12 BMCE-TRANSMIT-011331		
			MER		F	ME-ZF-07-PL-H512-001	Medical Gas Installation, Level 7, Zone F			1		29/05/12	BMCE-TRANSMIT-009109 (BMCE-WTRAN-003163)	19/06/12	01/10/12	C	04/10/12 BMCE-TRANSMIT-011123		
			MER		F	ME-ZF-08-PL-H512-001	Medical Gas Installation, Level 8, Zone F			1		29/05/12	BMCE-TRANSMIT-009115 (BMCE-WTRAN003166)	19/06/12	01/10/12	C	04/10/12 BMCE-TRANSMIT-011322		
			MER		F	ME-ZF-09-PL-H512-001	Medical Gas Installation, Level 9, Zone F			1		29/05/12	BMCE-TRANSMIT-009117 (BMCE-WTRAN-003167)	19/06/12	01/10/12	C	04/10/12 BMCE-TRANSMIT-011326		
			MER		F	ME-ZF-10-PL-H512-001	Medical Gas Installation, Level 10, Zone F			1		29/05/12	BMCE-TRANSMIT-009120 (BMCE-WTRAN-003170)	19/06/12	01/10/12	C	04/10/12 BMCE-TRANSMIT-011223		
			MER		F	ME-ZF-11-PL-H512-001	Medical Gas Installation, Level 11, Zone F			1		29/05/12	BMCE-TRANSMIT-009118 (BMCE-WTRAN-003168)	19/06/12	01/10/12	C	04/10/12 BMCE-TRANSMIT-011327		
	MEDICAL GASES	Removed By Mercury - NOT REQUIRED FOR RDD (REFER TO HPI H512 SERIES DESIGN DRAWINGS)	MER		F	ME-ZF-00-PL-512-507	Ground Floor Plan NSGH/NGH - Pharmacy Dispensary Medical Gases Layout	23/03/12			27/04/12			-					
		Removed By Mercury - NOT REQUIRED FOR RDD (REFER TO HPI H512 SERIES DESIGN DRAWINGS)	MER		F	ME-ZF-00-PL-512-508	Ground Floor Plan NGH Rehabilitation Suite & Therapies Medical Gases Layout	23/03/12			27/04/12			-					
		Removed By Mercury - NOT REQUIRED FOR RDD (REFER TO HPI H512 SERIES DESIGN DRAWINGS)	MER		F	ME-ZF-01-PL-512-505	First Floor Plan NGH - Theatres, Endoscopy & Recovery Medical Gases Layout	23/03/12			27/04/12			-					
		Removed By Mercury - NOT REQUIRED FOR RDD (REFER TO HPI H512 SERIES DESIGN DRAWINGS)	MER		F	ME-ZF-01-PL-512-507	First Floor Plan NGH - Theatres, Endoscopy & Recovery Medical Gases Layout	23/03/12			27/04/12			-					
		Removed By Mercury - NOT REQUIRED FOR RDD (REFER TO HPI H512 SERIES DESIGN DRAWINGS)	MER		F	ME-ZF-02-PL-512-505	Second Floor Plan NSGH Dermatology Ward Medical Gases Layout	23/03/12			27/04/12			-					

Drawing Information

31

BCL-AC-XX-SH-001

1st Submission

2nd Submission

Item	Submission	Comments	Action By		Zone	Drawing Number	Drawing Title	Date Required from Consultant	Date Submitted by Consultant	Document Revision	Planned Date to be Submitted to Board	Date Submitted to Board	BMCE Transmittal No	Date Response Required from Board	Date Returned from Board	Board Status	Date returned to Consultant	Date Required from Consultant	Date Submitted by Consultant
		This was issued for information on BMCE-TRANSMIT-018726 09/12/13	MER		F	ME-ZF-01-PL-572-505	First Floor Plan NCH - Theatres, Endoscopy & Recovery Fire Detection & Smoke Control Layout	23/03/12		A	27/04/12	01/05/12	BMCE-TRANSMIT-008614 (BMCE-WTRAN-002968)	22/05/12	11/07/12	B	19/07/12 BMCE-TRANSMIT-009922		
		This was issued for information on BMCE-TRANSMIT-018726 09/12/14	MER		F	ME-ZF-01-PL-572-507	First Floor Plan NCH - Theatres, Endoscopy & Recovery Fire Detection & Smoke Control Layout	23/03/12		C	27/04/12	01/05/12	BMCE-TRANSMIT-008614 (BMCE-WTRAN-002968)	22/05/12	11/07/12	B	19/07/12 BMCE-TRANSMIT-009922		
		This was issued for information on BMCE-TRANSMIT-018726 09/12/12	MER		F	ME-ZF-02-PL-572-505	Second Floor Plan NSGH Dermatology Ward Fire Detection & Smoke Control Layout	23/03/12		A	27/04/12	01/05/12	BMCE-TRANSMIT-008614 (BMCE-WTRAN-002968)	22/05/12	11/07/12	B	19/07/12 BMCE-TRANSMIT-009922		
			MER		F	ME-ZF-02-PL-572-506	Second Floor Plan NSGH Dermatology Ward Fire Detection & Smoke Control Layout	23/03/12		A	27/04/12	01/05/12	BMCE-TRANSMIT-008614 (BMCE-WTRAN-002968)	22/05/12	11/07/12	A	19/07/12 BMCE-TRANSMIT-009922		
			MER		F	ME-ZF-02-PL-572-507	Second Floor Plan NSGH Endoscopy Fire Detection & Smoke Control Layout	23/03/12		A	27/04/12	01/05/12	BMCE-TRANSMIT-008614 (BMCE-WTRAN-002968)	22/05/12	11/07/12	A	19/07/12 BMCE-TRANSMIT-009922		
		Removed by Mercury - DRAWING DOES NOT EXIST	MER		F	ME-ZF-03-PL-572-504	Third Floor Plan NSGH/NCH Staff Change/Hotel Services/Staff Accomodation Fire Detection & Smoke Control Layout	23/03/12			27/04/12			-					
		This was issued for information on BMCE-TRANSMIT-018726 09/12/12	MER		F	ME-ZF-03-PL-572-502	Third Floor Plan - NSGH/NCH Admin, Training, Health Records & Staff Facilities, Fire Detection & Smoke Control Layout	23/03/12		A	27/04/12	01/05/12	BMCE-TRANSMIT-008614 (BMCE-WTRAN-002968)	22/05/12	11/07/12	B	19/07/12 BMCE-TRANSMIT-009922		
		This was issued for information on BMCE-TRANSMIT-018726 09/12/12	MER		F	ME-ZF-04-PL-572-503	Fourth Floor Plan NSGH Renal Patients & Day Unit Fire Detection & Smoke Control Layout	16/03/12		A	03/05/12	09/05/12	BMCE-TRANSMIT-008745 (BMCE-WTRAN-003013)	30/05/12	06/06/12	B	18/06/12 BMCE-TRANSMIT-009386		
		This was issued for information on BMCE-TRANSMIT-018726 09/12/12	MER		F	ME-ZF-04-PL-572-504	Fourth Floor Plan NSGH Haemato-Oncology Fire Detection & Smoke Control Layout	16/03/12		A	03/05/12	09/05/12	BMCE-TRANSMIT-008745 (BMCE-WTRAN-003013)	30/05/12	06/06/12	B	18/06/12 BMCE-TRANSMIT-009386		
		This was issued for information on BMCE-TRANSMIT-018726 09/12/12	MER		F	ME-ZF-04-PL-572-505	Fourth Floor Plan NSGH Haemato-Oncology Fire Detection & Smoke Control Layout	16/03/12		A	03/05/12	09/05/12	BMCE-TRANSMIT-008745 (BMCE-WTRAN-003013)	30/05/12	06/06/12	B	18/06/12 BMCE-TRANSMIT-009386		
		This was issued for information on BMCE-TRANSMIT-018726 09/12/12	MER		F	ME-ZF-05-PL-572-503	Fifth Floor Plan NSGH Inpatient Wards Fire Detection & Smoke Control Layout	16/03/12		A	03/05/12	09/05/12	BMCE-TRANSMIT-008745 (BMCE-WTRAN-003013)	30/05/12	06/06/12	B	18/06/12 BMCE-TRANSMIT-009386		
		This was issued for information on BMCE-TRANSMIT-018726 09/12/12	MER		F	ME-ZF-05-PL-572-504	Fifth Floor Plan NSGH Inpatient Wards Fire Detection & Smoke Control Layout	16/03/12		A	03/05/12	09/05/12	BMCE-TRANSMIT-008745 (BMCE-WTRAN-003013)	30/05/12	06/06/12	B	18/06/12 BMCE-TRANSMIT-009386		
		This was issued for information on BMCE-TRANSMIT-018726 09/12/12	MER		F	ME-ZF-05-PL-572-505	Fifth Floor Plan NSGH Inpatient Wards Fire Detection & Smoke Control Layout	16/03/12		A	03/05/12	09/05/12	BMCE-TRANSMIT-008745 (BMCE-WTRAN-003013)	30/05/12	06/06/12	B	18/06/12 BMCE-TRANSMIT-009386		
		This was issued for information on BMCE-TRANSMIT-018726 09/12/12	MER		F	ME-ZF-XX-PL-572-503	Sixth to Eleventh Floor Plan. NSGH Inpatient Wards. Fire Detection & Smoke Control Layout			A		09/05/12	BMCE-TRANSMIT-008745 (BMCE-WTRAN-003013)	30/05/12	06/06/12	B	18/06/12 BMCE-TRANSMIT-009386		
		This was issued for information on BMCE-TRANSMIT-018726 09/12/12	MER		F	ME-ZF-XX-PL-572-504	Sixth to Eleventh Floor Plan. NSGH Inpatient Wards. Fire Detection & Smoke Control Layout			A		09/05/12	BMCE-TRANSMIT-008745 (BMCE-WTRAN-003013)	30/05/12	06/06/12	B	18/06/12 BMCE-TRANSMIT-009386		
		This was issued for information on BMCE-TRANSMIT-018726 09/12/12	MER		F	ME-ZF-XX-PL-572-505	Sixth to Eleventh Floor Plan. NSGH Inpatient Wards. Fire Detection & Smoke Control Layout			A		09/05/12	BMCE-TRANSMIT-008745 (BMCE-WTRAN-003013)	30/05/12	06/06/12	B	18/06/12 BMCE-TRANSMIT-009386		
		This was issued for information on BMCE-TRANSMIT-018726 09/12/12	MER		F	ME-SZ-00-PL-572-501	Ground Floor Plan NSGH main Entrance & Public Address Areas Fire Detection & Smoke Control Layout	23/03/12		D	27/04/12	01/05/12	BMCE-TRANSMIT-008614 (BMCE-WTRAN-002968)	22/05/12	11/07/12	B	19/07/12 BMCE-TRANSMIT-009922		
		This was issued for information on BMCE-TRANSMIT-018891 18/12/13	MER		F	ME-SZ-00-PL-572-502	Ground Floor Plan NSGH main Entrance & Public Address Areas Fire Detection & Smoke Control Layout	23/03/12		D	27/04/12	01/05/12	BMCE-TRANSMIT-008614 (BMCE-WTRAN-002968)	22/05/12	11/07/12	B	19/07/12 BMCE-TRANSMIT-009922		
			MER		F	ME-SZ-00-PL-572-507	Ground Floor Plan NSGH main Entrance & Public Address Areas Fire Detection & Smoke Control Layout	23/03/12		D	27/04/12	01/05/12	BMCE-TRANSMIT-008614 (BMCE-WTRAN-002968)	22/05/12	11/07/12	A	19/07/12 BMCE-TRANSMIT-009922		
		This was issued for information on BMCE-TRANSMIT-018891 18/12/13	MER		F	ME-SZ-01-PL-572-501	First Floor Plan - NSGH Restaurant, Dining and Servery Fire Detection & Smoke Control Layout	23/03/12		D	27/04/12	01/05/12	BMCE-TRANSMIT-008614 (BMCE-WTRAN-002968)	22/05/12	11/07/12	B	19/07/12 BMCE-TRANSMIT-009922		
		This was issued for information on BMCE-TRANSMIT-018891 18/12/14	MER		F	ME-SZ-01-PL-572-506	Firs Floor Plan - NSGH Theatres, Endoscopy & Recovery - Fire Detection Layout			C	27/04/12	01/05/12	BMCE-TRANSMIT-008614 (BMCE-WTRAN-002968)	22/05/12	11/07/12	B	19/07/12 BMCE-TRANSMIT-009922		
		This was issued for information on BMCE-TRANSMIT-018891 18/12/13	MER		F	ME-ZF-B1-PL-572-504	Basement Floor Plan NSGH Basement Catering Fire Detection & Smoke Control Layout	23/03/12		A	27/04/12	07/06/12	BMCE-TRANSMIT-009266 (BMCE-WTRAN-003230)	28/06/12	10/07/12	B	17/07/12 BMCE-TRANSMIT-009876		
		This was issued for information on BMCE-TRANSMIT-018726 09/12/12	MER		F	ME-SZ-B1-PL-572-503	Basement Floor Plan FM Core C Npharmacy Holding Area & FM Core Fire Detection Layout			A		07/06/12	BMCE-TRANSMIT-009266 (BMCE-WTRAN-003230)	28/06/12		B	17/07/12 BMCE-TRANSMIT-009876		
		Removed by Mercury - DRAWING DOES NOT EXIST	MER		F	ME-ZF-04-PL-572-512	Fourth Floor Plan NSGH Renal Patients & Day Unit Fire Detection & Smoke Control Layout	16/03/12			03/05/12			-					
		Removed by Mercury - DRAWING DOES NOT EXIST	MER		F	ME-ZF-04-PL-572-513	Fourth Floor Plan NSGH Haemato-Oncology Fire Detection & Smoke Control Layout	16/03/12			03/05/12			-					
		Removed by Mercury - DRAWING DOES NOT EXIST	MER		F	ME-ZF-04-PL-572-514	Fourth Floor Plan NSGH Haemato-Oncology Fire Detection & Smoke Control Layout	16/03/12			03/05/12			-					
		Removed by Mercury - DRAWING DOES NOT EXIST	MER		F	ME-ZF-05-PL-572-512	Fifth Floor Plan NSGH Inpatient Wards Fire Detection & Smoke Control Layout	16/03/12			03/05/12			-					
		Removed by Mercury - DRAWING DOES NOT EXIST	MER		F	ME-ZF-05-PL-572-513	Fifth Floor Plan NSGH Inpatient Wards Fire Detection & Smoke Control Layout	16/03/12			03/05/12			-					
		Removed by Mercury - DRAWING DOES NOT EXIST	MER		F	ME-ZF-05-PL-572-514	Fifth Floor Plan NSGH Inpatient Wards Fire Detection & Smoke Control Layout	16/03/12			03/05/12			-					
		Removed by Mercury - DRAWING DOES NOT EXIST	MER		F	ME-ZF-06-PL-572-514	Eleventh Floor Plan NSGH Inpatient Wards Fire Detection & Smoke Control Layout	23/03/12			27/04/12			-					
		Removed by Mercury - DRAWING DOES NOT EXIST	MER		F	ME-ZF-B1-PL-572-514	Eleventh Floor Plan NSGH Inpatient Wards Fire Detection & Smoke Control Layout	23/03/12			27/04/12			-					

Drawing Information

31 BCL-AC-XX-SH-001

1st Submission2nd Submission

			Action By	Zone	Drawing Number	Drawing Title	Date Required from Consultant	Date Submitted by Consultant	Document Revision	Planned Date to be Submitted to Board	Date Submitted to Board	BMCE Transmittal No	Date Response Required from Board	Date Returned from Board	Board Status	Date returned to Consultant	Date Required from Consultant	Date Submitted by Consultant
Item	Submission	Comments																
			MER	F	ME-ZF-02-PL-575-312	Second Floor Void Layout	23/03/12		A	27/04/12	02/05/12	BMCE-TRANSMIT-008650 (BMCE-WTRAN-002978)	23/05/12	06/06/2012	A	18/06/12 BMCE-TRANSMIT-009385		
			MER	F	ME-ZF-02-PL-575-313	Second Floor Ce iling layout	23/03/12		A	27/04/12	02/05/12	BMCE-TRANSMIT-008650 (BMCE-WTRAN-002978)	23/05/12	06/06/2012	A	18/06/12 BMCE-TRANSMIT-009385		
			MER	F	ME-ZF-03-PL-575-312	Third Floor Void Layout	23/03/12		A	27/04/12	02/05/12	BMCE-TRANSMIT-008650 (BMCE-WTRAN-002978)	23/05/12	06/06/2012	A	18/06/12 BMCE-TRANSMIT-009385		
			MER	F	ME-ZF-03-PL-575-313	Third Floor Ceiling Layout	23/03/12		A	27/04/12	02/05/12	BMCE-TRANSMIT-008650 (BMCE-WTRAN-002978)	23/05/12	06/06/2012	A	18/06/12 BMCE-TRANSMIT-009385		
		Issued for information on BMCE-TRANSMIT-019712 18/03/15	MER	F	ME-ZF-04-PL-575-312	Fourth Floor Void Layout	16/03/12		A	03/05/12	09/05/12	BMCE-TRANSMIT-008750 (BMCE-WTRAN-003015)	30/05/12		B	20/06/12 BMCE-TRANSMIT-009436		
		Issued for information on BMCE-TRANSMIT-019712 18/03/15	MER	F	ME-ZF-04-PL-575-313	Fourth Floor Ceiling Layout	16/03/12		A	03/05/12	09/05/12	BMCE-TRANSMIT-008750 (BMCE-WTRAN-003015)	30/05/12		B	20/06/12 BMCE-TRANSMIT-009436		
		Issued for information on BMCE-TRANSMIT-019712 18/03/15	MER	F	ME-ZF-05-PL-575-312	Fifth Floor Void Layout	16/03/12		A	03/05/12	09/05/12	BMCE-TRANSMIT-008750 (BMCE-WTRAN-003015)	30/05/12		B	20/06/12 BMCE-TRANSMIT-009436		
		Issued for information on BMCE-TRANSMIT-019712 18/03/15	MER	F	ME-ZF-05-PL-575-313	Fifth Floor Ceiling Layout	16/03/12		A	03/05/12	09/05/12	BMCE-TRANSMIT-008750 (BMCE-WTRAN-003015)	30/05/12		B	20/06/12 BMCE-TRANSMIT-009436		
		Issued for information on BMCE-TRANSMIT-019712 18/03/15	MER	F	ME-ZF-06-PL-575-312	Sixth Floor Void Layout	16/03/12		A	03/05/12	09/05/12	BMCE-TRANSMIT-008750 (BMCE-WTRAN-003015)	30/05/12		B	20/06/12 BMCE-TRANSMIT-009436		
		Issued for information on BMCE-TRANSMIT-019712 18/03/15	MER	F	ME-ZF-06-PL-575-313	Sixth Floor Ce iling Layout	16/03/12		A	03/05/12	09/05/12	BMCE-TRANSMIT-008750 (BMCE-WTRAN-003015)	30/05/12		B	20/06/12 BMCE-TRANSMIT-009436		
		Issued for information on BMCE-TRANSMIT-019712 18/03/15	MER	F	ME-ZF-07-PL-575-312	Seventh Floor Void Layout	16/03/12		A	03/05/12	09/05/12	BMCE-TRANSMIT-008750 (BMCE-WTRAN-003015)	30/05/12		B	20/06/12 BMCE-TRANSMIT-009436		
		Issued for information on BMCE-TRANSMIT-019712 18/03/15	MER	F	ME-ZF-07-PL-575-313	Seventh Floor Ce iling Layout	16/03/12		A	03/05/12	09/05/12	BMCE-TRANSMIT-008750 (BMCE-WTRAN-003015)	30/05/12		B	20/06/12 BMCE-TRANSMIT-009436		
		Issued for information on BMCE-TRANSMIT-019712 18/03/15	MER	F	ME-ZF-08-PL-575-312	Eighth Floor Void Layout	16/03/12		A	03/05/12	09/05/12	BMCE-TRANSMIT-008750 (BMCE-WTRAN-003015)	30/05/12		B	20/06/12 BMCE-TRANSMIT-009436		
		Issued for information on BMCE-TRANSMIT-019712 18/03/15	MER	F	ME-ZF-08-PL-575-313	Eighth Floor Ceiling Layout	16/03/12		A	03/05/12	09/05/12	BMCE-TRANSMIT-008750 (BMCE-WTRAN-003015)	30/05/12		B	20/06/12 BMCE-TRANSMIT-009436		
		Issued for information on BMCE-TRANSMIT-019712 18/03/15	MER	F	ME-ZF-09-PL-575-312	Ninth Floor Void Layout	16/03/12		A	03/05/12	09/05/12	BMCE-TRANSMIT-008750 (BMCE-WTRAN-003015)	30/05/12		B	20/06/12 BMCE-TRANSMIT-009436		
		Issued for information on BMCE-TRANSMIT-019712 18/03/15	MER	F	ME-ZF-09-PL-575-313	Ninth Floor Ceiling Layout	16/03/12		A	03/05/12	09/05/12	BMCE-TRANSMIT-008750 (BMCE-WTRAN-003015)	30/05/12		B	20/06/12 BMCE-TRANSMIT-009436		
		Issued for information on BMCE-TRANSMIT-019712 18/03/15	MER	F	ME-ZF-10-PL-575-312	Tenth Floor Void Layout	16/03/12		A	03/05/12	09/05/12	BMCE-TRANSMIT-008750 (BMCE-WTRAN-003015)	30/05/12		B	20/06/12 BMCE-TRANSMIT-009436		
		Issued for information on BMCE-TRANSMIT-019712 18/03/15	MER	F	ME-ZF-10-PL-575-313	Tenth Floor Ceiling Layout	16/03/12		A	03/05/12	09/05/12	BMCE-TRANSMIT-008750 (BMCE-WTRAN-003015)	30/05/12		B	20/06/12 BMCE-TRANSMIT-009436		
		Issued for information on BMCE-TRANSMIT-019712 18/03/15	MER	F	ME-ZF-11-PL-575-312	Eleventh Floor Void Layout	16/03/12		A	03/05/12	09/05/12	BMCE-TRANSMIT-008750 (BMCE-WTRAN-003015)	30/05/12		B	20/06/12 BMCE-TRANSMIT-009436		
		Issued for information on BMCE-TRANSMIT-019712 18/03/15	MER	F	ME-ZF-11-PL-575-313	Eleventh Floor Ceiling Layout	16/03/12		A	03/05/12	09/05/12	BMCE-TRANSMIT-008750 (BMCE-WTRAN-003015)	30/05/12		B	20/06/12 BMCE-TRANSMIT-009436		
			MER	F	ME-ZF-12-PL-575-312	Twelfth Floor Void Layout			B		24/03/14	BMCE-TRANSMIT-019750 (BMCE-WTRAN-010133)	14/04/14	22/04/14	A			
		REMOVED BY MERCURY - DRAWING DOES NOT EXIST	MER	F	ME-ZF-12-PL-575-313	Twelfth Floor Ce iling Layout							21/01/09					
	CCTV & Door Access	REMOVED BY MERCURY - DRAWING DOES NOT EXIST	MER	F	ME-ZF-00-PL-571-507	Ground Floor Plan NCHNSGH Pharmacy Dispensary CCTV & Door Access Layout	23/03/12			18/05/12			21/01/09					
		This was issued for information on BMCE-TRANSMIT-018726 09/12/12	MER	F	ME-ZF-00-PL-571-508	Ground Floor Plan NCH Rehabilitation Suite CCTV & Door Access Layout	23/03/12		A	18/05/12	17/05/12	BMCE-TRANSMIT-008899 (BMCE-WTRAN-003084)	07/06/12	13/07/12	B	18/07/12 BMCE-TRANSMIT-009882		
			MER	F	ME-ZF-01-PL-571-505	First Floor Plan NCH Theatres, Endoscopy & recovery CCTV & Door Access Layout	23/03/12		A	18/05/12	17/05/12	BMCE-TRANSMIT-008899 (BMCE-WTRAN-003084)	07/06/12	13/07/12	A	18/07/12 BMCE-TRANSMIT-009882		
		REMOVED BY MERCURY - DRAWING DOES NOT EXIST	MER	F	ME-ZF-01-PL-571-506	First Floor Plan NCH Theatres, Endoscopy & recovery CCTV & Door Access Layout	23/03/12			18/05/12			21/01/09					
		This was issued for information on BMCE-TRANSMIT-018726 09/12/12	MER	F	ME-ZF-01-PL-571-507	First Floor Plan NCH Theatres, Endoscopy & recovery CCTV & Door Access Layout	23/03/12		C	18/05/12	17/05/12	BMCE-TRANSMIT-008899 (BMCE-WTRAN-003084)	07/06/12	13/07/12	B	18/07/12 BMCE-TRANSMIT-009882		
		This was issued for information on BMCE-TRANSMIT-018726 09/12/12	MER	F	ME-ZF-02-PL-571-505	Second Floor Plan NSGH Dermatology Ward CCTV & Door Access Layout	23/03/12		A	18/05/12	17/05/12	BMCE-TRANSMIT-008899 (BMCE-WTRAN-003084)	07/06/12	13/07/12	B	18/07/12 BMCE-TRANSMIT-009882		
		This was issued for information on BMCE-TRANSMIT-018726 09/12/12	MER	F	ME-ZF-02-PL-571-506	Second Floor Plan NSGH Dermatology Ward CCTV & Door Access Layout	23/03/12		A	18/05/12	17/05/12	BMCE-TRANSMIT-008899 (BMCE-WTRAN-003084)	07/06/12	13/07/12	B	18/07/12 BMCE-TRANSMIT-009882		
			MER	F	ME-ZF-02-PL-571-507	Second Floor Plan NSGH Dermatology Ward CCTV & Door Access Layout	23/03/12		A	18/05/12	17/05/12	BMCE-TRANSMIT-008899 (BMCE-WTRAN-003084)	07/06/12	13/07/12	A	18/07/12 BMCE-TRANSMIT-		

Drawing Information

31

BCL-AC-XX-SH-001

1st Submission

2nd Submission

Item	Submission	Comments	Action By Zone		Drawing Number	Drawing Title	Date Required from Consultant	Date Submitted by Consultant	Document Revision	Planned Date to be Submitted to Board	Date Submitted to Board	BMCE Transmittal No	Date Response Required from Board	Date Returned from Board	Board Status	Date returned to Consultant	Date Required from Consultant	Date Submitted by Consultant
		This was issued for information on BMCE-TRANSMIT-018726	MER	F	ME-SZ-00-PL-571-501	Ground Floor Plan NSGH Main Entrance & Public Address Areas CCTV & Door Access Layout	23/03/12		D	18/05/12	17/05/12	BMCE-TRANSMIT-008899 (BMCE-WTRAN-003084)	07/06/12	13/07/12	B			
			MER	F	ME-SZ-00-PL-571-502	Ground Floor Plan NSGH Main Entrance & Public Address Areas CCTV & Door Access Layout	23/03/12		D	18/05/12	17/05/12	BMCE-TRANSMIT-008899 (BMCE-WTRAN-003084)	07/06/12	13/07/12	A	18/07/12 BMCE-TRANSMIT-009882		
		This was issued for information on BMCE-TRANSMIT-018726	MER	F	ME-SZ-00-PL-571-507	Ground Floor Plan NSGH Main Entrance & Public Address Areas CCTV & Door Access Layout	23/03/12		A	18/05/12	17/05/12	BMCE-TRANSMIT-008899 (BMCE-WTRAN-003084)	07/06/12	13/07/12	B	18/07/12 BMCE-TRANSMIT-009882		
			MER	F	ME-SZ-01-PL-571-501	First Floor Plan NSGH Restaurant, Dining and Servery CCTV & Door Access Layout	23/03/12		D	18/05/12	17/05/12	BMCE-TRANSMIT-008899 (BMCE-WTRAN-003084)	07/06/12	13/07/12	A	18/07/12 BMCE-TRANSMIT-009882		
		This drawing was issue to the board for information only on BME-TRANSMIT-018592 26/11/13	MER	F	ME-SZ-01-PL-571-506	First Floor Plan. NCH Theatres, Endoscopy & Recovery CCTV & Door Access Layout	23/03/12		C	18/05/12	17/05/12	BMCE-TRANSMIT-008899 (BMCE-WTRAN-003084)	07/06/12	13/07/12	B	18/07/12 BMCE-TRANSMIT-009882		
	Nurses Call	REMOVED BY MERCURY - DRAWING DOES NOT EXIST	MER	F	ME-ZF-00-PL-538-507	Ground Floor Plan. NCH/NSGH Pharmacy Dispensary Nurse Call Layout	23/03/12			18/05/12			23/06/09					
		This was issued for information on BMCE-TRANSMIT-018726 09/12/12	MER	F	ME-ZF-00-PL-538-508	Ground Floor Plan, NCH Rehabilitation Suite & Therapies Nurse Call Layout	23/03/12		A	27/04/12	22/05/12	BMCE-TRANSMIT-008883 (BMCE-WTRAN-003078)	12/06/12	02/07/12	B	04/07/12 BMCE-TRANSMIT-009665		
		This was issued for information on BMCE-TRANSMIT-018726 09/12/12	MER	F	ME-ZF-01-PL-538-505	First Floor Plan NCH Theatres, Endoscopy & Recovery Nurse Call Layout	23/03/12		A	27/04/12	22/05/12	BMCE-TRANSMIT-008883 (BMCE-WTRAN-003078)	12/06/12	02/07/12	B	04/07/12 BMCE-TRANSMIT-009665		
		This was issued for information on BMCE-TRANSMIT-018726 09/12/12	MER	F	ME-ZF-01-PL-538-507	First Floor Plan NCH Theatres, Endoscopy & Recovery Nurse Call Layout	23/03/12		C	27/04/12	22/05/12	BMCE-TRANSMIT-008883 (BMCE-WTRAN-003078)	12/06/12	02/07/12	B	04/07/12 BMCE-TRANSMIT-009665		
		This was issued for information on BMCE-TRANSMIT-018726 09/12/12	MER	F	ME-ZF-02-PL-538-505	Second Floor Plan NSGH Dermatology Ward Nurse Call layout	23/03/12		A	27/04/12	22/05/12	BMCE-TRANSMIT-008883 (BMCE-WTRAN-003078)	12/06/12	02/07/12	B	04/07/12 BMCE-TRANSMIT-009665		
		This was issued for information on BMCE-TRANSMIT-018726 09/12/12	MER	F	ME-ZF-02-PL-538-506	Second Floor Plan NSGH Dermatology Ward Nurse Call layout	23/03/12		A	27/04/12	22/05/12	BMCE-TRANSMIT-008883 (BMCE-WTRAN-003078)	12/06/12	02/07/12	B	04/07/12 BMCE-TRANSMIT-009665		
		This was issued for information on BMCE-TRANSMIT-018726 09/12/12	MER	F	ME-ZF-02-PL-538-507	Second Floor Plan NSGH Dermatology Ward Nurse Call layout	23/03/12		A	27/04/12	22/05/12	BMCE-TRANSMIT-008883 (BMCE-WTRAN-003078)	12/06/12	02/07/12	B	04/07/12 BMCE-TRANSMIT-009665		
			MER	F	ME-ZF-03-PL-538-502	Third Floor Plan NCH/NSGH Admin, Training, Health Records & Staff Facilities Nurse Call Layout	23/03/12		A	27/04/12	22/05/12	BMCE-TRANSMIT-008883 (BMCE-WTRAN-003078)	12/06/12	02/07/12	A	04/07/12 BMCE-TRANSMIT-009665		
		This was issued for information on BMCE-TRANSMIT-018726 09/12/12	MER	F	ME-ZF-04-PL-538-503	Fourth Floor Plan NSGH Renal Inpatients & Day Unit Nurse Call Layout	16/03/12		A	03/05/12	09/05/12	BMCE-TRANSMIT-008748 (BMCE-WTRAN-003014)	30/05/12	13/07/12	B	19/07/2012 BMCE-TRANSMIT-1907/2012		
		This was issued for information on BMCE-TRANSMIT-018726 09/12/12	MER	F	ME-ZF-04-PL-538-504	Fourth Floor Plan NSGH Renal Inpatients & Day Unit Nurse Call Layout	16/03/12		A	03/05/12	09/05/12	BMCE-TRANSMIT-008748 (BMCE-WTRAN-003014)	30/05/12	13/07/12	B	19/07/2012 BMCE-TRANSMIT-1907/2012		
		This was issued for information on BMCE-TRANSMIT-018726 09/12/12	MER	F	ME-ZF-04-PL-538-505	Fourth Floor Plan NSGH Renal Inpatients & Day Unit Nurse Call Layout	16/03/12		A	03/05/12	09/05/12	BMCE-TRANSMIT-008748 (BMCE-WTRAN-003014)	30/05/12	13/07/12	B	19/07/2012 BMCE-TRANSMIT-1907/2012		
			MER	F	ME-ZF-05-PL-538-503	Fifth Floor Plan NSGH Inpatient Ward Nurse Call layout	16/03/12		A	03/05/12	09/05/12	BMCE-TRANSMIT-008748 (BMCE-WTRAN-003014)	30/05/12	13/07/12	A	19/07/2012 BMCE-TRANSMIT-1907/2012		
			MER	F	ME-ZF-05-PL-538-504	Fifth Floor Plan NSGH Inpatient Ward Nurse Call layout	16/03/12		A	03/05/12	09/05/12	BMCE-TRANSMIT-008748 (BMCE-WTRAN-003014)	30/05/12	13/07/12	A	19/07/2012 BMCE-TRANSMIT-1907/2012		
		This was issued for information on BMCE-TRANSMIT-018726 09/12/12	MER	F	ME-ZF-05-PL-538-505	Fifth Floor Plan NSGH Inpatient Ward Nurse Call layout	16/03/12		A	03/05/12	09/05/12	BMCE-TRANSMIT-008748 (BMCE-WTRAN-003014)	30/05/12	13/07/12	B	20/07/12 BMCE-TRANSMIT-009934		
		This was issued for information on BMCE-TRANSMIT-018726 09/12/12	MER	F	ME-ZF-XX-PL-538-503	Sixth to Eleventh Floor Plan NSGH Inpatient Ward Nurse Call layout			A		09/05/12		30/05/12	13/07/12	B	19/07/2012 BMCE-TRANSMIT-1907/2012		
		This was issued for information on BMCE-TRANSMIT-018726 09/12/12	MER	F	ME-ZF-XX-PL-538-504	Sixth to Eleventh Floor Plan NSGH Inpatient Ward Nurse Call layout			A		09/05/12		30/05/12	13/07/12	B	19/07/2012 BMCE-TRANSMIT-1907/2012		
		This was issued for information on BMCE-TRANSMIT-018726 09/12/12	MER	F	ME-ZF-XX-PL-538-505	Sixth to Eleventh Floor Plan NSGH Inpatient Ward Nurse Call layout			A		09/05/12		30/05/12	13/07/12	B	19/07/2012 BMCE-TRANSMIT-1907/2012		
			MER	F	ME-SZ-00-PL-538-501	Ground Floor Plan NSGH Main Entrance and Public Areas Nurse Call Layout	23/03/12		D	27/04/12	22/05/12	BMCE-TRANSMIT-008883 (BMCE-WTRAN-003078)	12/06/12	02/07/12	A	04/07/12 BMCE-TRANSMIT-009665		
			MER	F	ME-SZ-00-PL-538-502	Ground Floor Plan NSGH Main Entrance and Public Areas Nurse Call Layout	23/03/12		D	27/04/12	22/05/12	BMCE-TRANSMIT-008883 (BMCE-WTRAN-003078)	12/06/12	02/07/12	A	04/07/12 BMCE-TRANSMIT-009665		
			MER	F	ME-SZ-00-PL-538-507	Ground Floor Plan NCH/NSGH Pharmacy Dispensary Nurse Call Layout	23/03/12		A	27/04/12	02/05/12	BMCE-TRANSMIT-008883 (BMCE-WTRAN-003078)	23/05/12	02/07/12	A	04/07/12 BMCE-TRANSMIT-009665		
			MER	F	ME-SZ-01-PL-538-501	First Floor Plan NSGH Restaurant, Dining and Servery Nurse Call Layout	23/03/12		A	27/04/12	22/05/12	BMCE-TRANSMIT-008883 (BMCE-WTRAN-003078)	12/06/12	02/07/12	B	04/07/12 BMCE-TRANSMIT-009665		
		This drawing was for review BMCE-TRANSMIT-018594 (BMCE-WTRAN-009481) 26/11/13	MER	F	ME-SZ-01-PL-538-506	First Floor Plan NCH Theatres, Endoscopy & Recovery Unit Nurse Call Layout	23/03/12		A	27/04/12	22/05/12	BMCE-TRANSMIT-008883 (BMCE-WTRAN-003078)	12/06/12	02/07/12	B	04/07/12 BMCE-TRANSMIT-009665		
	Mechanical Services Drawings Hospital Drawings - Zone G		ZBP	G	ZBP-ZG-00-PL-512-007	Medical Gases Layout Ground	15/06/11			06/10/11	17/10/12	BMCE-TRANSMIT-011674 (BMCE-WTRAN-004257)	07/11/12	22/10/12	C	25/10/12 BMCE-TRANSMIT-011874		
		IssueD for information on 15/10/13 BMCE-TRANSMIT-018607	ZBP	G	ZBP-ZG-01-PL-512-017	Medical Gases Layout First	15/06/11			06/10/11	12/10/12	BMCE-TRANSMIT-011549 (BMCE-WTRAN-004202)	02/11/12		B	08/11/12 BMCE-TRANSMIT-		

Drawing Information

31

BCL-AC-XX-SH-001

1st Submission

2nd Submission

			Action By	Zone	Drawing Number	Drawing Title	Date Required from Consultant	Date Submitted by Consultant	Document Revision	Planned Date to be Submitted to Board	Date Submitted to Board	BMCE Transmittal No	Date Response Required from Board	Date Returned from Board	Board Status	Date returned to Consultant	Date Required from Consultant	Date Submitted by Consultant
Item	Submission	Comments																
		IssueD for information on 15/10/13 BMCE-TRSANSMIT-018607	ZBP	G	ZBP-ZG-01-PL-523-017	HTG & CHW Layout First	15/06/11			06/10/11	12/10/12	BMCE-TRANSMIT-011548 (BMCE-WTRAN-004201)	02/11/12	24/10/12	B	01/11/12 BMCE-TRANSMIT-011995		
		IssueD for information on 15/10/13 BMCE-TRSANSMIT-018607	ZBP	G	ZBP-ZG-00-PL-524-007	Ventilation Layout Ground	15/06/11	08/12/11	F	06/10/11	15/12/11	BMCE-TRANSMIT-007133 (RE-ISSUED 28/05/12 BMCE-TRANSMIT-009100)	05/01/12	02/08/12	B	27/08/12 BMCE-TRANSMIT-010516		
		IssueD for information on 15/10/13 BMCE-TRSANSMIT-018607	ZBP	G	ZBP-ZG-01-PL-524-017	Ventilation Layout First	15/06/11		G	06/10/11	15/12/11	BMCE-TRANSMIT-007133 (RE-ISSUED 28/05/12 BMCE-TRANSMIT-009100)	05/01/12	02/08/12	B	27/08/12 BMCE-TRANSMIT-010516		
		IssueD for information on 15/10/13 BMCE-TRSANSMIT-018607	ZBP	G	ZBP-ZG-00-PL-526-007	Environmental Strategy Ground	03/02/12		C (D)	06/10/11	20/12/11	BMCE-TRANSMIT-007149 (RESUBMITTED 16.02.12 BMCE-TRANSMIT-007672)	10/01/12	11/05/12	B (REV D)	23/05/12 BMCE-TRANSMIT-009009 (REV D)		
			ZBP	G	ZBP-ZG-01-PL-526-017	Environmental Strategy First	03/02/12		C (D)	06/10/11	20/12/11	BMCE-TRANSMIT-007149 (RESUBMITTED 16.02.12 BMCE-TRANSMIT-007672)	10/01/12	11/05/12	A (REV D)	23/05/12 BMCE-TRANSMIT-009009 (REV D)		
			ZBP	G	ZBP-ZG-02-PL-526-027	Environmental Strategy Second	03/02/12		B	06/10/11	31/05/12	BMCE-TRANSMIT-009169 (BMCE-WTRAN-003193)	21/06/12	19/07/12	A	26/07/12 BMCE-TRANSMIT-009996 07/08/12		
Electrical Services Drawings			ZBP	G	ZBP-ZG-00-PL-531-007	Small Power Layout Ground	15/06/11		A	06/10/11	14/12/12	BMCE-TRANSMIT-012898 (BMCE-WTRAN-005144)	04/01/13	04/01/13	A	16/01/13 BMCE-TRANSMIT-013365		
			ZBP	G	ZBP-ZG-01-PL-531-017	Small Power Layout First	15/06/11		A	06/10/11	05/12/12	BMCE-TRANSMIT-012636 (BMCE-WTRAN-004961)	26/12/12	11/12/12	A	18/12/12 BMCE-TRANSMIT-012974		
			ZBP	G	ZBP-ZG-00-PL-532-007	Containment/Sub-Main Layout Ground	15/06/11			06/10/11	14/12/12	BMCE-TRANSMIT-012898 (BMCE-WTRAN-005144)	04/01/13	04/01/13	A	16/01/13 BMCE-TRANSMIT-013365		
			ZBP	G	ZBP-ZG-01-PL-532-017	Containment/Sub-Main Layout First	15/06/11			06/10/11	05/11/12	BMCE-TRANSMIT-011943 (BMCE-WTRAN-004380)	26/11/12		A	16/11/12 BMCE-TRANSMIT-012324		
			ZBP	G	ZBP-ZG-03-PL-532-123	Containment & Submain Routing and Small Power Plantroom 31 3rd Floor					05/11/12	BMCE-TRANSMIT-011943 (BMCE-WTRAN-004380)	26/11/12		A	16/11/12 BMCE-TRANSMIT-012324		
			ZBP	G	ZBP-ZG-03-PL-532-125	Containment & Submain Routing and Small Power Plantroom 31 3rd Floor					05/11/12	BMCE-TRANSMIT-011943 (BMCE-WTRAN-004380)	26/11/12		A	16/11/12 BMCE-TRANSMIT-012324		
			ZBP	G	ZBP-ZG-00-PL-571-007	Security Layout Ground	15/06/11		A	06/10/11	14/12/12	BMCE-TRANSMIT-012898 (BMCE-WTRAN-005144)	04/01/13	04/01/13	A	16/01/13 BMCE-TRANSMIT-013365		
			ZBP	G	ZBP-ZG-01-PL-571-017	Security Layout First	15/06/11		A	06/10/11	14/12/12	BMCE-TRANSMIT-012898 (BMCE-WTRAN-005144)	04/01/13	04/01/13	A	16/01/13 BMCE-TRANSMIT-013365		
		REMOVED BY XBP	ZBP	G	ZBP-ZG-03-PL-571-037	Security Layout Third				-			-					
Public Health Services Drawings		IssueD for information on 15/10/13 BMCE-TRSANSMIT-018607	ZBP	G	ZBP-ZG-00-PL-500-007	Water & Gas Services Layout Ground	15/06/11		C	06/10/11	29/08/12	BMCE-TRANSMIT-010511 (BMCE-WTRAN-003827)	19/09/12	03/10/12	B	04/10/12 BMCE-TRANSMIT-011333		
		IssueD for information on 15/10/13 BMCE-TRSANSMIT-018607	ZBP	G	ZBP-ZG-01-PL-500-017	Water & Gas Services Layout First	15/06/11		C	06/10/11	29/08/12	BMCE-TRANSMIT-010511 (BMCE-WTRAN-003827)	19/09/12	03/10/12	B	04/10/12 BMCE-TRANSMIT-011333		
			ZBP	G	ZBP-ZG-00-PL-581-007	Sanitation and Rainwater Layout Ground	15/06/11		B	06/10/11	09/02/12	BMCE-TRANSMIT-007409	01/03/12	12/03/12	A	23/3/2012 BMCE-TRANSMIT-008110		
			ZBP	G	ZBP-ZG-01-PL-581-017	Sanitation and Rainwater Layout First	15/06/11			06/10/11	17/10/12	BMCE-TRANSMIT-011678 (BMCE-WTRAN-004261)	07/11/12	22/10/12	A	25/10/12 BMCE-TRANSMIT-011677		
			ZBP	G	ZBP-ZG-03-PL-581-037	Sanitation and Rainwater Layout Third			B		14/06/12	BMCE-TRANSMIT-009356 (BMCE-WTRAN-003280)	05/07/12	10/09/12	A	05/10/12 BMCE-TRANSMIT-011383		
Riser Drawings			ZBP	G	ZBP-ZG-XX-PL-520-605	Riser M1	15/06/11			06/10/11	17/10/12	BMCE-TRANSMIT-011675 (BMCE-WTRAN-004258)	07/11/12	22/10/12	A	25/10/12 BMCE-TRANSMIT-011676		
		IssueD for information on 15/10/13 BMCE-TRSANSMIT-018607	ZBP	G	ZBP-ZG-XX-PL-520-606	Riser M2	15/06/11			06/10/11	12/10/12	BMCE-TRANSMIT-011551 (BMCE-WTRAN-004204)	02/11/12	21/11/12	B	08/11/12 BMCE-TRANSMIT-012182		
			ZBP	G	ZBP-ZG-XX-PL-520-607	Riser M8	15/06/11	08/12/11	E	06/10/11	15/12/11	BMCE-TRANSMIT-007133 (RE-ISSUED 28/05/12 BMCE-	05/01/12	14/08/12	A	27/08/12 BMCE-TRANSMIT-		

Drawing Information

31 BCL-AC-XX-SH-001

1st Submission2nd Submission

			Action By	Zone	Drawing Number	Drawing Title	Date Required from Consultant	Date Submitted by Consultant	Document Revision	Planned Date to be Submitted to Board	Date Submitted to Board	BMCE Transmittal No	Date Response Required from Board	Date Returned from Board	Board Status	Date returned to Consultant	Date Required from Consultant	Date Submitted by Consultant
Item	Submission	Comments																
			ZBP	G	ZBP-ZH-02-PL-581-028	Sanitation and Rainwater Layout Second	21/10/11		C	06/10/11	05/06/13	BMCE-TRANSMIT-0016119 (BMCE-TRANSMIT-007993)	26/06/13	10/07/13	A	BMCE-TRANSMIT-016829		
		REMOVED BY ZBP	ZBP	G	ZBP-ZG-02-PL-512-103	Plantroom 21 Medical Cases	15/06/11			30/11/11								
		REMOVED BY ZBP	ZBP	G	ZBP-ZG-02-PL-512-104	Plantroom 21 Medical Cases	15/06/11			30/11/11								
			ZBP	G	ZBP-ZG-02-PL-523-103	Plantroom 21 CHW & CHW	15/06/11		A	30/11/11	09/02/12	BMCE-TRANSMIT-007410 (RE-ISSUED 28/05/12 BMCE-TRANSMIT-009102)	01/03/12	19/07/12	A	28/07/12 BMCE-TRANSMIT-010060		
			ZBP	G	ZBP-ZG-02-PL-523-104	Plantroom 21 HTG & CHW	15/06/11		A	30/11/11	09/02/12	BMCE-TRANSMIT-007410 (RE-ISSUED 28/05/12 BMCE-TRANSMIT-009102)	01/03/12	19/07/12	A	28/07/12 BMCE-TRANSMIT-010060		
		IssueD for information on 15/10/13 BMCE-TRSANSMIT-018607	ZBP	G	ZBP-ZG-02-PL-524-103	Plantroom 21 Ventilation	15/06/11			30/11/11	09/02/12	BMCE-TRANSMIT-007410 (RE-ISSUED 28/05/12 BMCE-TRANSMIT-009102)	01/03/12	19/07/12	B	28/07/12 BMCE-TRANSMIT-010060		
		IssueD for information on 15/10/13 BMCE-TRSANSMIT-018607	ZBP	G	ZBP-ZG-02-PL-524-104	Plantroom 21 Ventilation	15/06/11		A	11/07/11	09/02/12	BMCE-TRANSMIT-007410 (RE-ISSUED 28/05/12 BMCE-TRANSMIT-009102)	01/03/12	19/07/12	B	28/07/12 BMCE-TRANSMIT-010060		
		IssueD for information on 15/10/13 BMCE-TRSANSMIT-018607	ZBP	G	ZBP-ZG-02-PL-532-103	Plantroom 21 LV Power	15/06/11		A	30/11/11	20/12/11	BMCE-TRANSMIT-007150	10/01/12	11/05/12	B	11/05/12 BMCE-TRANSMIT-008779		
		IssueD for information on 15/10/13 BMCE-TRSANSMIT-018607	ZBP	G	ZBP-ZD-02-SE-590-001	Plantroom 21 Sections 1 of 3					08/02/12	BMCE-TRANSMIT-007410 (RE-ISSUED 28/05/12 BMCE-TRANSMIT-009102)	29/02/12	18/07/12	B	28/07/12 BMCE-TRANSMIT-010060		
		IssueD for information on 15/10/13 BMCE-TRSANSMIT-018607	ZBP	G	ZBP-ZG-02-SE-590-002	Plantroom 21 Sections 2 of 3			A		09/02/12	BMCE-TRANSMIT-007410 (RE-ISSUED 28/05/12 BMCE-TRANSMIT-009102)	01/03/12	19/07/12	B	28/07/12 BMCE-TRANSMIT-010060		
			ZBP	G	ZBP-ZG-02-SE-590-003	Plantroom 21 Sections 3 of 3			A		09/02/12	BMCE-TRANSMIT-007410 (RE-ISSUED 28/05/12 BMCE-TRANSMIT-009102)	01/03/12	19/07/12	A	28/07/12 BMCE-TRANSMIT-010060		
		REMOVED BY ZBP	ZBP	G	ZBP-ZG-02-PL-532-104	Plantroom 21 LV Power	15/06/11			30/11/11			-					
		REMOVED BY ZBP	ZBP	G	ZBP-ZG-02-PL-500-103	Plantroom 21 Water Services	15/06/11			30/11/11			-					
		REMOVED BY ZBP	ZBP	G	ZBP-ZG-02-PL-500-104	Plantroom 21 Water Services	15/06/11			30/11/11			-					
		REMOVED BY ZBP	ZBP	G	ZBP-ZG-02-PL-581-213	Plantroom 21 Sanitation and Rainwater Layout	24/10/12			23/12/12			-					
		REMOVED BY ZBP	ZBP	G	ZBP-ZG-02-PL-581-214	Plantroom 21 Sanitation and Rainwater Layout	15/06/11			30/11/11			-					
		REMOVED BY ZBP	ZBP	G	ZBP-ZG-03-PL-581-215	Plantroom 21 Roof Sanitation and Rainwater Layout	24/10/12			23/12/12			-					
		REMOVED BY ZBP	ZBP	G	ZBP-ZG-03-PL-581-216	Plantroom 21 Roof Sanitation and Rainwater Layout				30/11/11								
		REMOVED BY ZBP	ZBP	G	ZBP-ZG-03-PL-581-217	Plantroom 21 Roof Sanitation and Rainwater Layout				30/11/11								
		REMOVED BY ZBP	ZBP	G	ZBP-ZG-03-PL-581-218	Plantroom 21 Roof Sanitation and Rainwater Layout				30/11/11								
	Mechanical Services Schematics		ZBP	G	ZBP-XX-XX-SC-524-701	Ventilation Schematic (PR21) - AHU 01	24/10/12		B	23/12/12	09/07/12	BMCE-TRANSMIT-009728 (BMCE-WTRAN-003454)	30/07/12	03/08/12	A	20/08/12 BMCE-TRANSMIT-010401		
		REMOVED BY ZBP	ZBP	G	ZBP-XX-XX-SC-524-702	Ventilation Schematic (PR21) - AHU 02				30/11/11								
			ZBP	G	ZBP-XX-XX-SC-524-703	Ventilation Schematic (PR21) - AHU 03	24/10/12			23/12/12	12/10/12	BMCE-TRANSMIT-011552 (BMCE-WTRAN-004205)	02/11/12		A	08/11/12 BMCE-TRANSMIT-012184		
			ZBP	G	ZBP-XX-XX-SC-524-704	Ventilation Schematic (PR21) - AHU 04	24/10/12			23/12/12	12/10/12	BMCE-TRANSMIT-011552 (BMCE-WTRAN-004205)	02/11/12		A	08/11/12 BMCE-TRANSMIT-012184		
			ZBP	G	ZBP-XX-XX-SC-524-705	Ventilation Schematic (PR21) - AHU 06	24/10/12			23/12/12	12/10/12	BMCE-TRANSMIT-011553 (BMCE-WTRAN-004206)	02/11/12		A	08/11/12 BMCE-TRANSMIT-012188		
		REMOVED BY ZBP	ZBP	G	ZBP-XX-XX-SC-524-706	Ventilation Schematic (PR21) - AHU 06				30/11/11								
		REMOVED BY ZBP	ZBP	G	ZBP-XX-XX-SC-524-707	Ventilation Schematic (PR21) - AHU 07				30/11/11								
			ZBP	G	ZBP-XX-XX-SC-524-707	Ventilation Schematic (PR21) - AHU 08, 09, 10, 11, 12, 13, 14, 15, 16 & 16			B		22/06/12	BMCE-TRANSMIT-009471 (BMCE-WTRAN-003317)	13/07/12	10/09/12	A	20/09/12 BMCE-TRANSMIT-011145		
			ZBP	G	ZBP-XX-XX-SC-524-708	Ventilation Schematic (PR21) - AHU 18				30/11/11	12/10/12	BMCE-TRANSMIT-011552 (BMCE-WTRAN-004205)	02/11/12		C	08/11/12 BMCE-TRANSMIT-012184		
			ZBP	G	ZBP-XX-XX-SC-524-709	Ventilation Schematic (PR21) - AHU 19				30/11/11	12/10/12	BMCE-TRANSMIT-011552 (BMCE-WTRAN-004205)	02/11/12		A	08/11/12 BMCE-TRANSMIT-		

Drawing Information

31

BCL-AC-XX-SH-001

			1st Submission																2nd Submission		
			Action By	Zone	Drawing Number	Drawing Title	Date Required from Consultant	Date Submitted by Consultant	Document Revision	Planned Date to be Submitted to Board	Date Submitted to Board	BMCE Transmittal No	Date Response Required from Board	Date Returned from Board	Board Status	Date returned to Consultant	Date Required from Consultant	Date Submitted by Consultant			
Item	Submission	Comments																			
			ZBP	G	ZBP-XX-XX-SC-524-716	Ventilation Schematic (PR21) - AHU 26 & 27			B	30/11/11	22/06/12	BMCE-TRANSMIT-009471 (BMCE-WTRAN-003317)	13/07/12	10/09/12	A	20/09/12 BMCE-TRANSMIT-011045					
			ZBP	G	ZBP-XX-XX-SC-524-717	Ventilation Schematic (PR21) - AHU 26 & 27	24/10/12		2	23/12/12	17/10/12	BMCE-TRANSMIT-011673 (BMCE-WTRAN-004256)	07/11/12	23/10/12	A	31/10/12 BMCE-TRANSMIT-011977					
		REMOVED BY ZBP	ZBP	G	ZBP-XX-XX-SC-524-718	Ventilation Schematic (PR21) - AHU 26 & 29				20/11/11			-								
		ADDED	ZBP	G	ZBP-XX-XX-SC-524-718	Ventilation Schematic (PR21) - AHU 30	24/10/12		B	23/12/12	22/06/12	BMCE-TRANSMIT-009471 (BMCE-WTRAN-003317)	13/07/12	10/09/12	A	20/09/12 BMCE-TRANSMIT-011045					
		REMOVED BY ZBP	ZBP	G	ZBP-XX-XX-SC-524-719	Ventilation Schematic (PR21) - AHU 30				20/11/11			-								
			ZBP	G	ZBP-XX-XX-SC-524-719	Ventilation Schematic (PR21) - AHU 31	24/10/12		B	23/12/12	22/06/12	BMCE-TRANSMIT-009471 (BMCE-WTRAN-003317)	13/07/12	10/09/12	A	20/09/12 BMCE-TRANSMIT-011045					
		IssueD for information on 15/10/13 BMCE-TRSANSMIT-018607	ZBP	G	ZBP-XX-XX-SC-524-720	Ventilation Schematic (PR21) - AHU 31		02/05/12	A	30/11/11	18/05/12	BMCE-TRANSMIT-008922 (BMCE-WTRAN-003102)	08/06/12	14/08/12	B	03/09/12 BMCE-TRANSMIT-010678					
		IssueD for information on 15/10/13 BMCE-TRSANSMIT-018607	ZBP	G	ZBP-XX-XX-SC-524-721	Ventilation Schematic (PR21) - AHU 32		03/05/12	A	30/11/11	18/05/12	BMCE-TRANSMIT-008922 (BMCE-WTRAN-003102)	08/06/12	14/08/12	B	03/09/12 BMCE-TRANSMIT-010678					
		REMOVED BY ZBP	ZBP	G	ZBP-XX-XX-SC-524-722	Ventilation Schematic (PR21) - AHU 33				20/11/11			-								
		REMOVED BY ZBP	ZBP	G	ZBP-XX-XX-SC-524-723	Ventilation Schematic (PR21) - AHU 34				20/11/11			-								
		ADDED	ZBP	G	ZBP-XX-XX-SC-524-723	Ventilation Schematic (PR21) - AHU 05				30/11/11	12/10/12	BMCE-TRANSMIT-011552 (BMCE-WTRAN-004205)	02/11/12		A	08/11/12 BMCE-TRANSMIT-012184					
		REMOVED BY ZBP	ZBP	G	ZBP-XX-XX-SC-524-724	Ventilation Schematic (PR21) - AHU 32															
		REMOVED BY ZBP	ZBP	G	ZBP-XX-XX-SC-524-725	Ventilation Schematic (PR21) - AHU 33															
		IssueD for information on 15/10/13 BMCE-TRSANSMIT-018607	ZBP	G	ZBP-XX-XX-SC-524-726	Ventilation Schematic (PR21) - AHU 34			A		09/11/12	BMCE-TRANSMIT-012197 (BMCE-WTRAN-004537)	30/11/12	06/12/12	B	18/12/12 BMCE-TRANSMIT-012967					
		IssueD for information on 15/10/13 BMCE-TRSANSMIT-018607	ZBP	G	ZBP-XX-XX-SC-521-411	Secondary Heating Schematic Plantroom 21			A	30/11/11	09/02/12	BMCE-TRANSMIT-007410 (RE-ISSUED 28/05/12 BMCE-TRANSMIT-009102)	01/03/12	19/07/12	B	28/07/12 BMCE-TRANSMIT-010060					
		Removed by ZBP	ZBP	G	ZBP-XX-XX-SC-521-413	Secondary Heating Distribution Schematic Plantroom 21	24/10/12			23/12/12			-								
		REMOVED BY ZBP	ZBP	G	ZBP-XX-XX-SC-521-511	Secondary Chilled Water Schematic Plantroom 21				20/11/11			-								
		REMOVED BY ZBP	ZBP	G	ZBP-XX-XX-SC-521-513	Secondary Chilled Water Distribution Schematic Plantroom 21				20/11/11			-								
	Electrical Services Schematics		ZBP	G	ZBP-XX-XX-SC-532-061	Low Voltage Schematic - Substation 6A			A	30/11/11	20/01/12	BMCE-TRANSMIT-007408	10/02/12	11/05/12	B	22/05/12 BMCE-TRANSMIT-008990					
			ZBP	G	ZBP-XX-XX-SC-532-062	Low Voltage Schematic - Substation 6B			A	30/11/11	20/01/12	BMCE-TRANSMIT-007408	10/02/12	11/05/12	B	22/05/12 BMCE-TRANSMIT-008991					
	Public Health Services Schematics		ZBP	G	ZBP-XX-XX-SC-500-021	Domestic Water Services Schematic Plantroom 21			A	30/11/11	09/02/12	BMCE-TRANSMIT-007410 (RE-ISSUED 28/05/12 BMCE-TRANSMIT-009102)	01/03/12	19/07/12	A	28/07/12 BMCE-TRANSMIT-010060					
		Drawing not applicable as This drawing has been superceded by HPI drawing	ZBP	G	ZBP-XX-XX-SC-500-002	NCH Renal Water Schematic			2	20/11/11	17/10/12	BMCE-TRANSMIT-011676 (BMCE-WTRAN-004256)	07/11/12	22/10/12	C	25/10/12 BMCE-TRANSMIT-011873					
	Pneumatic Tube Distribution		MER	G	ME-ZG-00-PL-569-001	Ground Floor Plan Pneumatic Tube Distribution	15/06/11		A	06/10/11	06/10/11	BMCE-TRANSMIT-006124	27/10/11	18/11/11	A	12/12/2011 BMCE-TRANSMIT-12/12/2011 BMCE-TRANSMIT-					
			MER	G	ME-ZG-01-PL-569-002	First Floor Plan Pneumatic Tube Distribution	15/06/11		A	06/10/11	06/10/11	BMCE-TRANSMIT-006124	27/10/11	18/11/11	A						
	Lighting	REMOVED BY MERCURY - DUPLICATE	MER	G	ME-SZ-00-PL-541-519	Grnd floor plan - NCH emergency dept lighting layout			C		07/10/11	BMCE-TRANSMIT-006148	28/10/11	29/11/11	B	12/12/11 BMCE-TRANSMIT-					

Drawing Information

31

BCL-AC-XX-SH-001

			Action By		Zone	Drawing Number	Drawing Title	Date Required from Consultant	Date Submitted by Consultant	Document Revision	Planned Date to be Submitted to Board	Date Submitted to Board	BMCE Transmittal No	Date Response Required from Board	Date Returned from Board	Board Status	Date returned to Consultant	Date Required from Consultant	Date Submitted by Consultant
Item	Submission	Comments																	
		REMOVED BY MERCURY - DUPLICATE	MER	G	ME-SZ-02-PL-541-521							06/10/11	BMCE-TRANSMIT-006122	27/10/11	30/11/11	B	12/12/11- BMCE-TRANSMIT-007280		
		REMOVED BY MERCURY - DUPLICATE	MER	G	ME-SZ-02-PL-541-522							06/10/11	BMCE-TRANSMIT-006122	27/10/11	30/11/11	B	12/12/11- BMCE-TRANSMIT-007280		

Drawing Information

31 BCL-AC-XX-SH-001

1st Submission2nd Submission

			Action By	Zone	Drawing Number	Drawing Title	Date Required from Consultant	Date Submitted by Consultant	Document Revision	Planned Date to be Submitted to Board	Date Submitted to Board	BMCE Transmittal No	Date Response Required from Board	Date Returned from Board	Board Status	Date returned to Consultant	Date Required from Consultant	Date Submitted by Consultant
Item	Submission	Comments																
		This was issued for information on BMCE-TRANSMIT-018727 09/12/13	MER	G	ME-ZG-02-PL-541-524	Second Floor Plan NSGH Theatres Lighting Layout	15/06/11			06/10/11	06/10/11	BMCE-TRANSMIT-006122	27/10/11	29/11/11	B	12/12/11 BMCE-TRANSMIT-007090		
		This was issued for information on BMCE-TRANSMIT-018727 09/12/13	MER	G	ME-ZG-02-PL-541-526	Second Floor Plan NSGH Theatres Lighting Layout	15/06/11			06/10/11	06/10/11	BMCE-TRANSMIT-006122	27/10/11	29/11/11	B	12/12/11 BMCE-TRANSMIT-007090		
			MER	G	ME-ZG-02-PL-541-540	Second Floor Plan NSGH Plantroom- Lighting Layout			C		01/03/13	BMCE-TRANSMIT-014279 (BMCE-WTRAN-006293)	22/03/13	12/04/13	A	30/04/13 BMCE-TRANSMIT-015421		
			MER	G	ME-ZG-02-PL-541-541	Second Floor Plan NSGH Plantroom- Lighting Layout	15/06/11		C	06/10/11	01/03/13	BMCE-TRANSMIT-014279 (BMCE-WTRAN-006293)	22/03/13	12/04/12	C	30/04/13 BMCE-TRANSMIT-015422		
		REMOVED BY MERCURY - WRONG DRAWING NO.	MER	G	ME-XX-XX-SP-541-100	Lighting Calculations - Zone G				06/10/11			-					
		REMOVED BY MERCURY - DUPLICATE	MER	G	ME-XX-XX-SP-541-101	Luminaire Schedule - Zone G				06/10/11			-					
	Small Power	Removed By Mercury - NOT REQUIRED FOR RDD (SMALL POWER SHOWN ON NA 400 SERIES DRAWINGS)	MER	G	ME-ZG-00-PL-531-525	Ground Floor Plan NSGH - AAU Small Power & General Services Layout	15/06/11				06/10/11							
		Removed By Mercury - NOT REQUIRED FOR RDD (SMALL POWER SHOWN ON NA 400 SERIES DRAWINGS)	MER	G	ME-ZG-00-PL-531-528	Ground Floor Plan NSGH - AAU Small Power & General Services Layout	15/06/11				06/10/11							
		Removed By Mercury - NOT REQUIRED FOR RDD (SMALL POWER SHOWN ON NA 400 SERIES DRAWINGS)	MER	G	ME-ZG-01-PL-531-525	First Floor Plan NSGH - CCW Small Power & General Services Layout	15/06/11				06/10/11							
		Removed By Mercury - NOT REQUIRED FOR RDD (SMALL POWER SHOWN ON NA 400 SERIES DRAWINGS)	MER	G	ME-ZG-01-PL-531-526	First Floor Plan NSGH - CCW Small Power & General Services Layout	15/06/11				06/10/11							
		Removed By Mercury - NOT REQUIRED FOR RDD (SMALL POWER SHOWN ON NA 400 SERIES DRAWINGS)	MER	G	ME-ZG-01-PL-531-527	First Floor Plan NSGH - CCW Small Power & General Services Layout	15/06/11				06/10/11							
		Removed By Mercury - NOT REQUIRED FOR RDD (SMALL POWER SHOWN ON NA 400 SERIES DRAWINGS)	MER	G	ME-ZG-01-PL-531-528	First Floor Plan NSGH - CCW Small Power & General Services Layout	15/06/11				06/10/11							
		Removed By Mercury - NOT REQUIRED FOR RDD (SMALL POWER SHOWN ON NA 400 SERIES DRAWINGS)	MER	G	ME-ZG-02-PL-531-524	Second Floor Plan NSGH Theatres Small Power & General Services Layout	15/06/11				06/10/11							
		Removed By Mercury - NOT REQUIRED FOR RDD (SMALL POWER SHOWN ON NA 400 SERIES DRAWINGS)	MER	G	ME-ZG-02-PL-531-526	Second Floor Plan NSGH Theatres Small Power & General Services Layout	15/06/11				06/10/11							
		Removed By Mercury - NOT REQUIRED FOR RDD (SMALL POWER SHOWN ON NA 400 SERIES DRAWINGS)	MER	G	ME-ZG-00-PL-532-525	Ground Floor Plan NSGH - AAU High Level Layout	15/06/11				06/10/11							
		Removed By Mercury - NOT REQUIRED FOR RDD (SMALL POWER SHOWN ON NA 400 SERIES DRAWINGS)	MER	G	ME-ZG-00-PL-532-528	Ground Floor Plan NSGH - AAU High Level Layout	15/06/11				06/10/11							
		Removed By Mercury - NOT REQUIRED FOR RDD (SMALL POWER SHOWN ON NA 400 SERIES DRAWINGS)	MER	G	ME-ZG-01-PL-532-525	First Floor Plan NSGH - CCW High Level Layout	15/06/11				06/10/11							
		Removed By Mercury - NOT REQUIRED FOR RDD (SMALL POWER SHOWN ON NA 400 SERIES DRAWINGS)	MER	G	ME-ZG-01-PL-532-526	First Floor Plan NSGH - CCW High Level Layout	15/06/11				06/10/11							
		Removed By Mercury - NOT REQUIRED FOR RDD (SMALL POWER SHOWN ON NA 400 SERIES DRAWINGS)	MER	G	ME-ZG-01-PL-532-527	First Floor Plan NSGH - CCW High Level Layout	15/06/11				06/10/11							
		Removed By Mercury - NOT REQUIRED FOR RDD (SMALL POWER SHOWN ON NA 400 SERIES DRAWINGS)	MER	G	ME-ZG-01-PL-532-528	First Floor Plan NSGH - CCW High Level Layout	15/06/11				06/10/11							
		Removed By Mercury - NOT REQUIRED FOR RDD (SMALL POWER SHOWN ON NA 400 SERIES DRAWINGS)	MER	G	ME-ZG-02-PL-532-524	Second Floor Plan NSGH Theatres High Level Layout	15/06/11				06/10/11							
		Removed By Mercury - NOT REQUIRED FOR RDD (SMALL POWER SHOWN ON NA 400 SERIES DRAWINGS)	MER	G	ME-ZG-02-PL-532-526	Second Floor Plan NSGH Theatres High Level Layout	15/06/11				06/10/11							
		Removed By Mercury - NOT REQUIRED FOR RDD (SMALL POWER SHOWN ON NA 400 SERIES DRAWINGS)	MER	G	ME-ZG-00-PL-532-525	Ground Floor Plan NSGH - AAU ELV Systems low level Layout	15/06/11				06/10/11							
		Removed By Mercury - NOT REQUIRED FOR RDD (SMALL POWER SHOWN ON NA 400 SERIES DRAWINGS)	MER	G	ME-ZG-00-PL-532-528	Ground Floor Plan NSGH - AAU ELV Systems low level Layout	15/06/11				06/10/11							
		Removed By Mercury - NOT REQUIRED FOR RDD (SMALL POWER SHOWN ON NA 400 SERIES DRAWINGS)	MER	G	ME-ZG-01-PL-532-525	First Floor Plan NSGH - CCW ELV Systems low level Layout	15/06/11				06/10/11							
		Removed By Mercury - NOT REQUIRED FOR RDD (SMALL POWER SHOWN ON NA 400 SERIES DRAWINGS)	MER	G	ME-ZG-01-PL-532-526	First Floor Plan NSGH - CCW ELV Systems low level Layout	15/06/11				06/10/11							
		Removed By Mercury - NOT REQUIRED FOR RDD (SMALL POWER SHOWN ON NA 400 SERIES DRAWINGS)	MER	G	ME-ZG-01-PL-532-527	First Floor Plan NSGH - CCW ELV Systems low level Layout	15/06/11				06/10/11							
		Removed By Mercury - NOT REQUIRED FOR RDD (SMALL POWER SHOWN ON NA 400 SERIES DRAWINGS)	MER	G	ME-ZG-01-PL-532-528	First Floor Plan NSGH - CCW ELV Systems low level Layout	15/06/11				06/10/11							
		Removed By Mercury - NOT REQUIRED FOR RDD (SMALL POWER SHOWN ON NA 400 SERIES DRAWINGS)	MER	G	ME-ZG-02-PL-532-524	Second Floor Plan NSGH Theatres ELV Systems low level Layout	15/06/11				06/10/11							
		Removed By Mercury - NOT REQUIRED FOR RDD (SMALL POWER SHOWN ON NA 400 SERIES DRAWINGS)	MER	G	ME-ZG-02-PL-532-526	Second Floor Plan NSGH Theatres ELV Systems low level Layout	15/06/11				06/10/11							

Drawing Information

31 BCL-AC-XX-SH-001

1st Submission2nd Submission

			Action By	Zone	Drawing Number	Drawing Title	Date Required from Consultant	Date Submitted by Consultant	Document Revision	Planned Date to be Submitted to Board	Date Submitted to Board	BMCE Transmittal No	Date Response Required from Board	Date Returned from Board	Board Status	Date returned to Consultant	Date Required from Consultant	Date Submitted by Consultant
Item	Submission	Comments																
			MER	G	ME-ZG-01-PL-575-300	First Floor Void Sprinklers Zone G	15/06/11			06/10/11	12/12/11	BMCE-TRANSMIT-006120	02/01/12	14/11/11	A	12/12/2011 BMCE-TRANSMIT-		
			MER	G	ME-ZG-01-PL-575-301	First Floor Ceiling Sprinklers Zone G	15/06/11			06/10/11	12/12/11	BMCE-TRANSMIT-006120	02/01/12	14/11/11	A	12/12/2011 BMCE-TRANSMIT-		
			MER	G	ME-ZG-02-PL-575-300	Second Floor Void Sprinklers Zone G	15/06/11			06/10/11	12/12/11	BMCE-TRANSMIT-006120	02/01/12	14/11/11	B	12/12/2011 BMCE-TRANSMIT-		
			MER	G	ME-ZG-02-PL-575-301	Second Floor Ceiling Sprinklers Zone G	15/06/11			06/10/11	12/12/11	BMCE-TRANSMIT-006120	02/01/12	14/11/11	B	12/12/2011 BMCE-TRANSMIT-		
			MER	G	ME-ZG-03-PL-575-300	Third Floor Void Sprinklers Zone G				06/10/11	12/12/11	BMCE-TRANSMIT-006120	02/01/12	14/11/11	A	12/12/2011 BMCE-TRANSMIT-		
	BMS	Removed By Mercury - NOT REQUIRED FOR RDD (PART OF BMS DETAIL DESIGN)	MER	G	ME-ZG-00-PL-660-525	Ground Floor Plan NSGH – AAU BMS Layout	15/06/11			06/10/11			-					
		Removed By Mercury - NOT REQUIRED FOR RDD (PART OF BMS DETAIL DESIGN)	MER	G	ME-ZG-00-PL-660-528	Ground Floor Plan NSGH – AAU BMS Layout	15/06/11			06/10/11			-					
		Removed By Mercury - NOT REQUIRED FOR RDD (PART OF BMS DETAIL DESIGN)	MER	G	ME-ZG-01-PL-660-525	First Floor Plan NSGH – CCW BMS Layout	15/06/11			06/10/11			-					
		Removed By Mercury - NOT REQUIRED FOR RDD (PART OF BMS DETAIL DESIGN)	MER	G	ME-ZG-01-PL-660-526	First Floor Plan NSGH – CCW BMS Layout	15/06/11			06/10/11			-					
		Removed By Mercury - NOT REQUIRED FOR RDD (PART OF BMS DETAIL DESIGN)	MER	G	ME-ZG-01-PL-660-527	First Floor Plan NSGH – CCW BMS Layout	15/06/11			06/10/11			-					
		Removed By Mercury - NOT REQUIRED FOR RDD (PART OF BMS DETAIL DESIGN)	MER	G	ME-ZG-01-PL-660-528	First Floor Plan NSGH – CCW BMS Layout	15/06/11			06/10/11			-					
		Removed By Mercury - NOT REQUIRED FOR RDD (PART OF BMS DETAIL DESIGN)	MER	G	ME-ZG-02-PL-660-524	Second Floor Plan NSGH Theatres BMS Layout	15/06/11			06/10/11			-					
		Removed By Mercury - NOT REQUIRED FOR RDD (PART OF BMS DETAIL DESIGN)	MER	G	ME-ZG-02-PL-660-526	Second Floor Plan NSGH Theatres BMS Layout	15/06/11			06/10/11			-					
	MEDICAL GASES	Issued to board for information only BMCE-TRANSMIT-017701	MER	G	ME-ZG-00-DC-H512-001	Le-el-0, AAW – Assessment Unit-Wards LHS (room-AAW-304) to Mains												
		Issued to board for information only BMCE-TRANSMIT-017701	MER	G	ME-ZG-00-DC-H512-002	Level-0, AAW – Assessment Unit (Room-AAW-357) to Mains												
		Issued to board for information only BMCE-TRANSMIT-017701	MER	G	ME-ZG-01-DC-H512-001	Le-el-1, CCW from CCW-047 & mains to Riser-M11												
			MER	G	ME-ZG-00-PL-H512-001	Medical Gas Installation, Level 0, Zone G			1		29/05/12	BMCE-TRANSMIT-009131 (BMCE-WTRAN-003175)	19/06/12	24/09/12	C	27/09/12 BMCE-TRANSMIT-011199		
			MER	G	ME-ZG-01-PL-H512-001	Medical Gas Installation, Level 1, Zone G			1		29/05/12	BMCE-TRANSMIT-009127 (BMCE-WTRAN-003174)	19/06/12	24/09/12	C	27/09/12 BMCE-TRANSMIT-011196		
			MER	G	ME-ZG-01-PL-H512-002	Medical Gas Installation, Level 1, Zone G - AGSS			1		29/05/12	BMCE-TRANSMIT-009127 (BMCE-WTRAN-003174)	19/06/12	24/09/12	C	27/09/12 BMCE-TRANSMIT-011196		
		Issued for information on BMCE-TRANSMIT-019817 31/03/14	MER	G	ME-ZG-02-PL-H512-001	Medical Gas Installation, Level 2, Zone G			1		29/05/12	BMCE-TRANSMIT-009123 (BMCE-WTRAN-003172)	19/06/12	15/08/12	C	20/08/12 BMCE-TRANSMIT-010372		
			MER	G	ME-ZG-02-PL-H512-002	Medical Gas Installation, Level 2, Zone G - AGSS			1		29/05/12	BMCE-TRANSMIT-009123 (BMCE-WTRAN-003172)	19/06/12	24/09/12	C	27/09/12 BMCE-TRANSMIT-011202		
			MER	G	ME-ZG-03-PL-H512-002	Medical Gas Installation, Level 3, Zone G - AGSS			1		29/05/12	BMCE-TRANSMIT-009125 (BMCE-WTRAN-003173)	19/06/12	01/10/12	C	04/10/12 BMCE-TRANSMIT-011325		
			MER	G	ME-ZG-03-PL-H512-001	Medical Gas Installation, Level 3, Zone G			1		29/05/12	BMCE-TRANSMIT-009125 (BMCE-WTRAN-003173)	19/06/12	01/10/12	C	04/10/12 BMCE-TRANSMIT-011325		
			MER	G	ME-ZG-04-PL-H512-001	Medical Gas Installation, Level 4, Zone G			1		29/05/12	BMCE-TRANSMIT-009122 (BMCE-WTRAN-03171)	19/06/12	01/10/12	C	04/10/12 BMCE-TRANSMIT-011324		
	MEDICAL GASES	Removed By Mercury - NOT REQUIRED FOR RDD (REFER TO HPI H512 SERIES DESIGN DRAWINGS)	MER	G	ME-ZG-00-PL-512-525	Ground Floor Plan NSGH – AAU Medical Gases Layout	15/06/11			06/10/11			-					
		Removed By Mercury - NOT REQUIRED FOR RDD (REFER TO HPI H512 SERIES DESIGN DRAWINGS)	MER	G	ME-ZG-00-PL-512-528	Ground Floor Plan NSGH – AAU Medical Gases Layout	15/06/11			06/10/11			-					
		Removed By Mercury - NOT REQUIRED FOR RDD (REFER TO HPI H512 SERIES DESIGN DRAWINGS)	MER	G	ME-ZG-01-PL-512-525	First Floor Plan NSGH – CCW Medical Gases Layout	15/06/11			06/10/11			-					
		Removed By Mercury - NOT REQUIRED FOR RDD (REFER TO HPI H512 SERIES DESIGN DRAWINGS)	MER	G	ME-ZG-01-PL-512-526	First Floor Plan NSGH – CCW Medical Gases Layout	15/06/11			06/10/11			-					

Drawing Information

31 BCL-AC-XX-SH-001

			1st Submission																2nd Submission		
			Action By	Zone	Drawing Number	Drawing Title	Date Required from Consultant	Date Submitted by Consultant	Document Revision	Planned Date to be Submitted to Board	Date Submitted to Board	BMCE Transmittal No	Date Response Required from Board	Date Returned from Board	Board Status	Date returned to Consultant	Date Required from Consultant	Date Submitted by Consultant			
Item	Submission	Comments																			
		This was issued for information on BMCE-TRANSMIT-018727 09/12/13	MER	G	ME-ZG-02-PL-572-526	Second Floor Plan NSGH Theatres Fire Detection & Smoke Control Layout	15/06/11		A	06/10/11	20/10/11	BMCE-TRANSMIT-006307	10/11/11	14/11/11	B	13/02/12 BMCE-TRANSMIT-007567					
			MER	G	ME-ZG-02-PL-572-540	Second Floor Plan Plantroom Fire Detection & Smoke Control Layout	15/06/11		B	06/10/11	01/03/13	BMCE-TRANSMIT-014279 (BMCE-WTRAN-006293)	22/03/13	12/04/13	B						
			MER	G	ME-ZG-02-PL-572-541	Second Floor Plan Plantroom Fire Detection & Smoke Control Layout	15/06/11		B	06/10/11	01/03/13	BMCE-TRANSMIT-014279 (BMCE-WTRAN-006293)	22/03/13	12/04/13	C						
	CCTV & Door Access		MER	G	ME-ZG-00-PL-571-525	Ground Floor Plan NSGH - AAU CCTV & Door Access Layout	15/06/11		A	06/10/11	06/10/11	06/10/11	27/10/11	02/07/12	A	12/07/12 BMCE-TRANSMIT-009763					
			MER	G	ME-SZ-00-PL-571-526	Ground Floor Plan NSGH - AAU CCTV & Door Access Layout	15/06/11		A	06/10/11	06/10/11	BMCE-TRANSMIT-006121	27/10/11	02/07/12	A	12/07/12 BMCE-TRANSMIT-009763					
			MER	G	ME-ZG-00-PL-571-528	Ground Floor Plan NSGH - AAU CCTV & Door Access Layout	15/06/11		A	06/10/11	06/10/11	BMCE-TRANSMIT-006121	27/10/11	02/07/12	A	12/07/12 BMCE-TRANSMIT-009763					
		This was issued for information on BMCE-TRANSMIT-018727 09/12/13	MER	G	ME-SZ-00-PL-571-529	Ground Floor Plan NSGH - AAU CCTV & Door Access Layout	15/06/11		A	06/10/11	06/10/11	BMCE-TRANSMIT-006121	27/10/11	02/07/12	B	12/07/12 BMCE-TRANSMIT-009763					

Drawing Information

31

BCL-AC-XX-SH-001

			Action By		Zone	Drawing Number	Drawing Title	Date Required from Consultant	Date Submitted by Consultant	Document Revision	Planned Date to be Submitted to Board	Date Submitted to Board	BMCE Transmittal No	Date Response Required from Board	Date Returned from Board	Board Status	Date returned to Consultant	Date Required from Consultant	Date Submitted by Consultant
Item	Submission	Comments																	
			MER	G	ME-ZG-01-PL-571-525	First Floor Plan NSGH - CCW CCTV & Door Access Layout	15/06/11			A	06/10/11	06/10/11	BMCE-TRANSMIT-006121	27/10/11	02/07/12	A	12/07/12 BMCE-TRANSMIT-009763		
			MER	G	ME-ZG-01-PL-571-526	First Floor Plan NSGH - CCW CCTV & Door Access Layout	15/06/11			A	06/10/11	06/10/11	BMCE-TRANSMIT-006121	27/10/11	02/07/12	A	12/07/12 BMCE-TRANSMIT-009763		
			MER	G	ME-ZG-01-PL-571-527	First Floor Plan NSGH - CCW CCTV & Door Access Layout	15/06/11			A	06/10/11	06/10/11	BMCE-TRANSMIT-006121	27/10/11	02/07/12	A	12/07/12 BMCE-TRANSMIT-009763		
			MER	G	ME-ZG-01-PL-571-528	First Floor Plan NSGH - CCW CCTV & Door Access Layout	15/06/11			A	06/10/11	06/10/11	BMCE-TRANSMIT-006121	27/10/11	02/07/12	A	12/07/12 BMCE-TRANSMIT-009763		
		This was issued for information on BMCE-TRANSMIT-018727 09/12/13	MER	G	ME-ZG-02-PL-571-524	Second Floor Plan NSGH Theatres CCTV & Door Access Layout	15/06/11			A	06/10/11	06/10/11	BMCE-TRANSMIT-006121	27/10/11	02/07/12	B	12/07/12 BMCE-TRANSMIT-009763		
			MER	G	ME-ZG-02-PL-571-526	Second Floor Plan NSGH Theatres CCTV & Door Access Layout	15/06/11			A	06/10/11	06/10/11	BMCE-TRANSMIT-006121	27/10/11	02/07/12	A	12/07/12 BMCE-TRANSMIT-009763		
	Nurse Call		MER	G	ME-ZG-00-PL-538-525	Ground Floor Plan NSGH - AAU Nurse Call Layout	15/06/11			A	06/10/11	06/10/11	BMCE-TRANSMIT-006119	27/10/11	31/07/12	A	30/08/12 BMCE-TRANSMIT-010595		
			MER	G	ME-SZ-00-PL-538-526	Ground Floor Plan NSGH - AAU Nurse Call Layout	15/06/11			A	06/10/11	06/10/11	BMCE-TRANSMIT-006119	27/10/11	31/07/12	A	30/08/12 BMCE-TRANSMIT-010595		
			MER	G	ME-ZG-00-PL-538-528	Ground Floor Plan NSGH - AAU Nurse Call Layout	15/06/11			A	06/10/11	06/10/11	BMCE-TRANSMIT-006119	27/10/11	31/07/12	A	30/08/12 BMCE-TRANSMIT-010595		
			MER	G	ME-SZ-00-PL-538-529	Ground Floor Plan NSGH - AAU Nurse Call Layout	15/06/11			A	06/10/11	06/10/11	BMCE-TRANSMIT-006119	27/10/11	31/07/12	A	30/08/12 BMCE-TRANSMIT-010595		
			MER	G	ME-ZG-01-PL-538-525	First Floor Plan NSGH - CCW Nurse Call Layout	15/06/11			A	06/10/11	06/10/11	BMCE-TRANSMIT-006119	27/10/11	31/07/12	A	30/08/12 BMCE-TRANSMIT-010595		
			MER	G	ME-ZG-01-PL-538-526	First Floor Plan NSGH - CCW Nurse Call Layout	15/06/11			A	06/10/11	06/10/11	BMCE-TRANSMIT-006119	27/10/11	31/07/12	A	30/08/12 BMCE-TRANSMIT-010595		
			MER	G	ME-ZG-01-PL-538-527	First Floor Plan NSGH - CCW Nurse Call Layout	15/06/11			A	06/10/11	06/10/11	BMCE-TRANSMIT-006119	27/10/11	31/07/12	A	30/08/12 BMCE-TRANSMIT-010595		
			MER	G	ME-ZG-01-PL-538-528	First Floor Plan NSGH - CCW Nurse Call Layout	15/06/11			A	06/10/11	06/10/11	BMCE-TRANSMIT-006119	27/10/11	31/07/12	A	30/08/12 BMCE-TRANSMIT-011095		
			MER	G	ME-ZG-02-PL-538-524	Second Floor Plan NSGH Theatres Nurse Call Layout	15/06/11			A	06/10/11	06/10/11	BMCE-TRANSMIT-006119	27/10/11	31/07/12	A	30/08/12 BMCE-TRANSMIT-010595		
			MER	G	ME-ZG-02-PL-538-526	Second Floor Plan NSGH Theatres Nurse Call Layout	15/06/11			A	06/10/11	06/10/11	BMCE-TRANSMIT-006119	27/10/11	31/07/12	A	30/08/12 BMCE-TRANSMIT-010595		
	Mechanical Services DrawingsHospital Drawings - Zone H	ZBP medical gas drawings superceded by HPI drawings	ZBP	H	ZBP-ZH-00-PL-512-008	Medical Gases Layout Ground	21/10/11			A	05/12/11	22/12/11	BMCE-TRANSMIT-007183	-	13/03/12	B	23/03/2012 BMCE-TRANSMIT-		
		ZBP medical gas drawings superceded by HPI drawings	ZBP	H	ZBP-ZH-01-PL-512-018	Medical Gases Layout First	21/10/11			A	05/12/11	22/12/11	BMCE-TRANSMIT-007183	-	13/03/12	B	23/03/2012 BMCE-TRANSMIT-		
		ZBP medical gas drawings superceded by HPI drawings	ZBP	H	ZBP-ZH-02-PL-512-028	Medical Gases Layout Second	21/10/11			A	05/12/11	22/12/11	BMCE-TRANSMIT-007183	-	13/03/12	B	23/03/2012 BMCE-TRANSMIT-		
		ZBP medical gas drawings superceded by HPI drawings	ZBP	H	ZBP-ZH-04-PL-512-048	Medical Gases Layout Fourth	16/03/12				03/05/12	11/12/12	BMCE-TRANSMIT-012841 (BMCE-WTRAN-005109)	07/01/13					
		ZBP medical gas drawings superceded by HPI drawings	ZBP	H	ZBP-ZH-XX-PL-512-058	Medical Gases Layout Generic Ward						11/12/12	BMCE-TRANSMIT-012841 (BMCE-WTRAN-005109)	07/01/13					
		ZBP medical gas drawings superceded by HPI drawings	ZBP	H	ZBP-ZH-XX-PL-512-068	Medical Gases Layout Generic Ward	21/10/11				05/12/11			-					
		Issued to board for information on BMCE-TRANSMIT-018070 15/10/13	ZBP	H	ZBP-ZH-00-PL-523-008	HTG & CHW Layout Ground	21/10/11			A	05/12/11	22/12/11	BMCE-TRANSMIT-007183	12/01/12	13/03/12	B	23/03/2012 BMCE-TRANSMIT-		
		Issued to board for information on BMCE-TRANSMIT-018070 15/10/13	ZBP	H	ZBP-ZH-01-PL-523-018	HTG & CHW Layout First	21/10/11			A	05/12/11	22/12/11	BMCE-TRANSMIT-007183	12/01/12	13/03/12	B	23/03/2012 BMCE-TRANSMIT-		
		Issued to board for information on BMCE-TRANSMIT-018070 15/10/13	ZBP	H	ZBP-ZH-02-PL-523-028	HTG & CHW Layout Second	21/10/11			A	05/12/11	22/12/11	BMCE-TRANSMIT-007183	12/01/12	13/03/12	B	23/03/2012 BMCE-TRANSMIT-		
		Issued to board for information on BMCE-TRANSMIT-018070 15/10/13	ZBP	H	ZBP-ZH-04-PL-523-048	HTG & CHW Layout Fourth	16/03/12			A	03/05/12	08/05/12	BMCE-TRANSMIT-008690 (BMCE-WTRAN-002999)	29/05/12	09/07/12	B	18/07/12 BMCE-TRANSMIT-009907		
		Issued for information on BMCE-TRANSMIT-018858 18/12/2013	ZBP	H	ZBP-ZH-11-PL-523-118	HTG & CHW Layout Eleventh Floor NSGH Ward				A		28/05/12	BMCE-TRANSMIT-009096 (BMCE-WTRAN-003156)	18/06/12	19/07/12	B	26/07/12 BMCE-TRANSMIT-010001		
		Issued for information on BMCE-TRANSMIT-018858 18/12/2013	ZBP	H	ZBP-ZH-XX-PL-523-058	HTG & CHW Layout Generic Ward				A		28/05/12	BMCE-TRANSMIT-009096 (BMCE-WTRAN-003156)	18/06/12	19/07/12	B	26/07/12 BMCE-TRANSMIT-010001		
			ZBP	H	ZBP-ZH-01-PL-523-118	Neuroscience Link Bridge				A		05/06/13	BMCE-TRANSMIT-0016119 (BMCE-WTRAN-007793)	26/06/13	10/07/13	A	BMCE-TRANSMIT-		

Drawing Information

31		BCL-AC-XX-SH-001					1st Submission										2nd Submission					
			Action By		Zone	Drawing Number	Drawing Title	Date Required from Consultant	Date Submitted by Consultant	Document Revision	Planned Date to be Submitted to Board	Date Submitted to Board	BMCE Transmittal No	Date Response Required from Board	Date Returned from Board	Board Status	Date returned to Consultant	Date Required from Consultant	Date Submitted by Consultant			
Item	Submission	Comments																				
			ZBP	H	ZBP-ZH-04-PL-526-048	Environmental Strategy Fourth	13/04/12		A		22/06/12	BMCE-TRANSMIT-009470 (BMCE-WTRAN-003316) REISSUED IN COLOUR	13/07/12	28/09/12	A	05/10/12 BMCE-TRANSMIT-011381						

Drawing Information

31

BCL-AC-XX-SH-001

			Action By		Zone	Drawing Number	Drawing Title	Date Required from Consultant	Date Submitted by Consultant	Document Revision	Planned Date to be Submitted to Board	Date Submitted to Board	BMCE Transmittal No	Date Response Required from Board	Date Returned from Board	Board Status	Date returned to Consultant	Date Required from Consultant	Date Submitted by Consultant
Item	Submission	Comments																	
		REMOVED BY ZBP	ZBP	H	ZBP-ZH-XX-PL-526-068	En-ironmental Treatment Generic Ward	21/10/11				05/12/11			-					
Electrical Services Drawings			ZBP	H	ZBP-ZH-00-PL-531-008	Small Power Layout Ground	21/10/11			A	05/12/11	08/12/11	BMCE-TRANSMIT-007034	29/12/11	11/05/12	A	14/05/12 BMCE-TRANSMIT-008797		
			ZBP	H	ZBP-ZH-01-PL-531-018	Small Power Layout First	21/10/11			A	05/12/11	08/12/11	BMCE-TRANSMIT-007034	29/12/11	11/05/12	A	14/05/12 BMCE-TRANSMIT-008797		
			ZBP	H	ZBP-ZH-02-PL-531-028	Sma l Power Layout Second	21/10/11			A	05/12/11	08/12/11	BMCE-TRANSMIT-007034	29/12/11	11/05/12	A	14/05/12 BMCE-TRANSMIT-008797		
			ZBP	H	ZBP-ZH-04-PL-531-048	Small Power Layout Fourth	16/03/12			A	03/05/12	08/05/12	BMCE-TRANSMIT-008691 (BMCE-WTRAN-00300)	29/05/12	02/08/12	A	29/08/12 BMCE-TRANSMIT-010570		
			ZBP	H	ZBP-ZH-XX-PL-531-058	Small Power Layout Fifth to Eleventh Floors NSGH Generic Wards	16/03/12			A	03/05/12	08/05/12	BMCE-TRANSMIT-008691 (BMCE-WTRAN-00300)	29/05/12	02/08/12	A			
		DRAWING NUMBER CHANGED DRAWING DELETED BY ZBP	ZBP	H	ZBP-ZH-XX-PL-531-068	Small Power Layout Generic Ward	16/03/12							-					
			ZBP	H	ZBP-ZH-00-PL-532-008	Containment/Sub-Main Layout Ground	21/10/11			A	05/12/11	08/12/11	BMCE-TRANSMIT-007034	29/12/11	11/05/12	A	14/05/12 BMCE-TRANSMIT-008797		
			ZBP	H	ZBP-ZH-01-PL-532-018	Containment/Sub-Main Layout First	21/10/11			A	05/12/11	08/12/11	BMCE-TRANSMIT-007034	29/12/11	11/05/12	A	14/05/12 BMCE-TRANSMIT-008797		
			ZBP	H	ZBP-ZH-02-PL-532-028	Containment/Sub-Main Layout Second	21/10/11			A	05/12/11	08/12/11	BMCE-TRANSMIT-007034	29/12/11	11/05/12	A	14/05/12 BMCE-TRANSMIT-008797		
			ZBP	H	ZBP-ZH-04-PL-532-048	Containment/Sub-main Layout Fourth	16/03/12				03/05/12	08/05/12	BMCE-TRANSMIT-008691 (BMCE-WTRAN-00300)	29/05/12	02/08/12	A	29/08/12 BMCE-TRANSMIT-010570		
			ZBP	H	ZBP-ZH-XX-PL-532-058	Containment/Sub-main Layout Fifth to Eleventh Floors NSGH Generic Ward	16/03/12			A	03/05/12	08/05/12	BMCE-TRANSMIT-008691 (BMCE-WTRAN-00300)	29/05/12	02/08/12	A			
		DRAWING NUMBER CHANGED DRAWING DELETED BY ZBP	ZBP	H	ZBP-ZH-XX-PL-532-068	Containment/Sub-main Layout Generic Ward	16/03/12							-					
		This was issued for information on BMCE-TRANSMIT-018858 17/12/13	ZBP	H	ZBP-ZH-00-PL-571-008	Security Layout Ground	21/10/11			A	05/12/11	08/12/11	BMCE-TRANSMIT-007034	29/12/11	11/05/12	B	14/05/12 BMCE-TRANSMIT-008797		
		This was issued for information on BMCE-TRANSMIT-018858 17/12/13	ZBP	H	ZBP-ZH-01-PL-571-018	Security Layout First	21/10/11			A	05/12/11	08/12/11	BMCE-TRANSMIT-007034	29/12/11	11/05/12	B	14/05/12 BMCE-TRANSMIT-008797		
		This was issued for information on BMCE-TRANSMIT-018858 17/12/13	ZBP	H	ZBP-ZH-02-PL-571-028	Security Layout Second	21/10/11			A	05/12/11	08/12/11	BMCE-TRANSMIT-007034	29/12/11	11/05/12	B	14/05/12 BMCE-TRANSMIT-008797		
		This was issued for information on BMCE-TRANSMIT-018858 17/12/13	ZBP	H	ZBP-ZH-04-PL-571-048	Security Layout Fourth	16/03/12			A	03/05/12	08/05/12	BMCE-TRANSMIT-008691 (BMCE-WTRAN-00300)	29/05/12	02/08/12	B	29/08/12 BMCE-TRANSMIT-010570		
		Security drawings please refer to Mercurys security drawings	ZBP	H	ZBP-ZH-XX-PL-571-058	Security Layout Fifth to Eleventh Floors NSGH Generic Wards	16/03/12			A	03/05/12	08/05/12	BMCE-TRANSMIT-008691 (BMCE-WTRAN-00300)	29/05/12	02/08/12	B			
		DRAWING NUMBER CHANGED DRAWING DELETED BY ZBP	ZBP	H	ZBP-ZH-XX-PL-571-068	Security Layout Generic Ward	16/03/12							-					
Public Health Services Drawings		Issued for information on BMCE-TRANSMIT-018070 15/10/13	ZBP	H	ZBP-ZH-00-PL-500-008	Water & Gas Services Layout	21/10/11			A	05/12/11	22/01/12	BMCE-TRANSMIT-007184	12/02/12	15/02/12	B	15/02/12 BMCE-TRANSMIT-007640		
		Issued for information on BMCE-TRANSMIT-018070 15/10/13	ZBP	H	ZBP-ZH-01-PL-500-018	Water & Gas Services Layout First	21/10/11			A	05/12/11	22/01/12	BMCE-TRANSMIT-007184	12/02/12	15/02/12	B	15/02/12 BMCE-TRANSMIT-007640		
		Issued to board for information on BMCE-TRANSMIT-018070 15/10/13	ZBP	H	ZBP-ZH-02-PL-500-028	Water & Gas Services Layout Second	21/10/11			A	05/12/11	22/01/12	BMCE-TRANSMIT-007184	12/02/12	15/02/12	B	15/02/12 BMCE-TRANSMIT-007640		
			ZBP	H	ZBP-ZH-04-PL-500-048	Water & Gas Services Layout Fourth	16/03/12			A	03/05/12	30/05/12	BMCE-TRANSMIT-009098 (BMCE-WTRAN-003159)	20/06/12	19/07/12	A	28/07/12 BMCE-TRANSMIT-010051 15/08/12		
			ZBP	H	ZBP-ZH-XX-PL-500-058	Water & Gas Service Layout Generic Tower Fifth to Eleventh				A		30/05/12	BMCE-TRANSMIT-009098 (BMCE-WTRAN-003159)	20/06/12	19/07/12	A	28/07/12 BMCE-TRANSMIT-010051 15/08/12		
		DRAWING NUMBER CHANGED DRAWING DELETED BY ZBP	ZBP	H	ZBP-ZH-XX-PL-500-068	Water & Gas Ser-ices Layout Generic Ward	16/03/12							-					
		This was issued for information on BMCE-TRANSMIT-018858 17/12/13	ZBP	H	ZBP-ZH-00-PL-581-008	Sanitation and Rainwater Layout Ground	21/10/11			A	05/12/11	22/01/12	BMCE-TRANSMIT-007184	12/02/12	15/02/12	B	15/02/12 BMCE-TRANSMIT-007640		
		This was issued for information on BMCE-TRANSMIT-018858 17/12/13	ZBP	H	ZBP-ZH-01-PL-581-018	Sanitation and Rainwater Layout Second	21/10/11			A	05/12/11	22/01/12	BMCE-TRANSMIT-007184	12/02/12	15/02/12	B	15/02/12 BMCE-TRANSMIT-007640		

Drawing Information

31 BCL-AC-XX-SH-001

			1st Submission																2nd Submission		
			Action By	Zone	Drawing Number	Drawing Title	Date Required from Consultant	Date Submitted by Consultant	Document Revision	Planned Date to be Submitted to Board	Date Submitted to Board	BMCE Transmittal No	Date Response Required from Board	Date Returned from Board	Board Status	Date returned to Consultant	Date Required from Consultant	Date Submitted by Consultant			
Item	Submission	Comments																			
		This was issued for information on BMCE-TRANSMIT-018858 17/12/13	ZBP	H	ZBP-ZH-XX-PL-520-622	Riser M10	21/10/11		A	05/12/11	22/12/11	BMCE-TRANSMIT-007183	12/01/12	13/03/12	B	23/03/2012 BMCE-TRANSMIT-					
		This was issued for information on BMCE-TRANSMIT-018858 17/12/13	ZBP	H	ZBP-ZH-XX-PL-520-623	Riser M21	21/10/11		A	05/12/11	22/12/11	BMCE-TRANSMIT-007183	12/01/12	13/03/12	B	23/03/2012 BMCE-TRANSMIT-					
			ZBP	H	ZBP-ZH-XX-PL-520-624	Riser T5	13/04/12		A	03/05/12	16/05/12	BMCE-TRANSMIT-008881 (BMCE-WTRAN-003076)	06/06/12	10/09/12	A	21/09/12 BMCE-TRANSMIT-011101					
			ZBP	H	ZBP-ZH-XX-PL-520-625	Riser T6	04/05/12		A	11/06/12	16/05/12	BMCE-TRANSMIT-008881 (BMCE-WTRAN-003077)	06/06/12	10/09/12	A	21/09/12 BMCE-TRANSMIT-011101					
			ZBP	H	ZBP-ZH-XX-PL-520-626	Riser T6 Levels 4-11			A		14/06/12	BMCE-TRANSMIT-009359 (BMCE-WTRAN-003282)	05/07/12	10/09/12	A	21/09/12 BMCE-TRANSMIT-011089					
			ZBP	H	ZBP-ZH-XX-PL-520-627	Riser T6 Level 08-11			A		14/06/12	BMCE-TRANSMIT-009359 (BMCE-WTRAN-003282)	05/07/12	10/09/12	A	21/09/12 BMCE-TRANSMIT-011089					
		This was issued for information only on BMCE-TRANSMIT-018070 15/10/13	ZBP	H	ZBP-XX-XX-PL-532-001	Typical Riser Details	21/10/11		B	05/12/11	20/12/11	BMCE-TRANSMIT-007148	10/01/12	24/04/12	B	14/05/12 BMCE-TRANSMIT-008792					
		DRAWING NUMBER CHANGED DRAWING DELETED BY ZBP	ZBP	H	ZBP-ZH-06-PL-581-068	Sanitation and Rainwater Layout Sixth Floor	16/03/12		A												
	Mechanical Services DrawingsPlantroom 124	This was issued for information on BMCE-TRANSMIT-018858 17/12/13	ZBP	H	ZBP-ZH-12-PL-523-191	Plantroom 124 Pipework	31/08/12		A	05/10/12	26/02/13	BMCE-TRANSMIT-014131 (BMCE-WTRAN-006181)	19/03/13	26/03/13	B	03/08/13 BMCE-TRANSMIT-014910					
		This was issued for information on BMCE-TRANSMIT-018858 17/12/13	ZBP	H	ZBP-ZH-12-PL-523-192	Plantroom 124 Pipework	31/08/12		A	05/10/12	26/02/13	BMCE-TRANSMIT-014131 (BMCE-WTRAN-006181)	19/03/13	26/03/13	B	03/08/13 BMCE-TRANSMIT-014910					
		This drawing is a duplicate	ZBP	H	ZBP-ZH-12-PL-523-191	HTG & CHW Pipework Layout Plantroom 124 - sheet 1 12th floor	31/08/12		A	05/10/12	26/02/13	BMCE-TRANSMIT-014131 (BMCE-WTRAN-006181)	19/03/13	26/03/13	B	03/08/13 BMCE-TRANSMIT-014910					

Drawing Information

31 BCL-AC-XX-SH-001

1st Submission2nd Submission

			Action By	Zone	Drawing Number	Drawing Title	Date Required from Consultant	Date Submitted by Consultant	Document Revision	Planned Date to be Submitted to Board	Date Submitted to Board	BMCE Transmittal No	Date Response Required from Board	Date Returned from Board	Board Status	Date returned to Consultant	Date Required from Consultant	Date Submitted by Consultant
Item	Submission	Comments																
		This was issued for information only on BMCE-TRANSMIT-018070 15/10/13	ZBP	H	ZBP-ZH-12-PL-524-191	Plantroom 124 Ventilation	31/08/12		A	05/10/12	26/02/13	BMCE-TRANSMIT-014131 (BMCE-WTRAN-006181)	19/03/13	26/03/13	B	03/08/13 BMCE-TRANSMIT-014910		
			ZBP	H	ZBP-ZH-12-PL-524-192	Plantroom 124 Ventilation	31/08/12		A	05/10/12	26/02/13	BMCE-TRANSMIT-014131 (BMCE-WTRAN-006181)	19/03/13	26/03/13	B	03/08/13 BMCE-TRANSMIT-014910		
		This was issued for information only on BMCE-TRANSMIT-018070 15/10/13	ZBP	H	ZBP-ZH-03-PL-524-128	Plantroom 31 Ventilation			D		14/12/12	BMCE-TRANSMIT-012844 (BMCE-WTRAN-005111)	04/01/13	04/01/13	B	16/01/13 BMCE-TRANSMIT-013364		
							31/08/12			05/10/12								
	Electrical Services Drawings	Removed by ZBP	ZBP	H	ZBP-ZH-03-PL-532-191	Plantroom 124 LV Power	31/08/12			05/10/12			-					
		Removed by ZBP	ZBP	H	ZBP-ZH-03-PL-532-192	Plantroom 124 LV Power	31/08/12			05/10/12			-					
		Public Health Services Drawings																
		Removed by ZBP	ZBP	H	ZBP-ZH-12-PL-581-191	Plantroom 124 Sanitary and Rainwater Layout	31/08/12			05/10/12			-					
		Removed by ZBP	ZBP	H	ZBP-ZH-12-PL-581-192	Plantroom 124 Sanitation and Rainwater Layout	31/08/12			05/10/12			-					
		Removed by ZBP	ZBP	H	ZBP-ZH-12-PL-581-193	Plantroom 124 Roof Sanitation and Rainwater Layout	31/08/12			05/10/12			-					
		Removed by ZBP	ZBP	H	ZBP-ZH-12-PL-581-194	Plantroom 124 Roof Sanitation and Rainwater Layout	31/08/12			05/10/12			-					
			ZBP	H		Plantroom 31 Zone H Level 3	30/03/12			03/05/12								
			ZBP	H	ZBP-ZH-12-PL-532-181	LV Power Layout Plantroom 124			A		05/06/13	BMCE-TRANSMIT-016119 (BMCE-WTRAN-007793)	26/06/13	10/07/13	A	BMCE-TRANSMIT-016829		
	Mechanical Services Schematics		ZBP	H	ZBP-XX-XX-SC-524-931	Ventilation Schematic (PR124) - AHU 01	31/08/12			05/10/12	09/11/12	BMCE-TRANSMIT-012216 (BMCE-WTRAN-04546)	30/11/12	03/12/12	A	06/12/12 BMCE-TRANSMIT-012805		
			ZBP	H	ZBP-XX-XX-SC-524-932	Ventilation Schematic (PR124) - AHU 02	31/08/12			05/10/12	09/11/12	BMCE-TRANSMIT-012216 (BMCE-WTRAN-04546)	30/11/12	03/12/12	A	06/12/12 BMCE-TRANSMIT-012805		
			ZBP	H	ZBP-XX-XX-SC-524-933	Ventilation Schematic (PR124) - AHU 03	31/08/12			05/10/12	09/11/12	BMCE-TRANSMIT-012216 (BMCE-WTRAN-04546)	30/11/12	03/12/12	A	06/12/12 BMCE-TRANSMIT-012805		
			ZBP	H	ZBP-XX-XX-SC-524-934	Ventilation Schematic (PR124) - AHU 04	31/08/12			05/10/12	09/11/12	BMCE-TRANSMIT-012216 (BMCE-WTRAN-04546)	30/11/12	03/12/12	A	06/12/12 BMCE-TRANSMIT-012805		
			ZBP	H	ZBP-XX-XX-SC-524-935	Ventilation Schematic (PR124) - AHU 05	31/08/12			05/10/12	09/11/12	BMCE-TRANSMIT-012216 (BMCE-WTRAN-04546)	30/11/12	03/12/12	A	06/12/12 BMCE-TRANSMIT-012805		
			ZBP	H	ZBP-XX-XX-SC-524-936	Ventilation Schematic (PR124) - AHU 06	31/08/12			05/10/12	09/11/12	BMCE-TRANSMIT-012216 (BMCE-WTRAN-04546)	30/11/12	03/12/12	A	06/12/12 BMCE-TRANSMIT-012805		
			ZBP	H	ZBP-XX-XX-SC-524-937	Ventilation Schematic (PR124) - AHU 07	31/08/12			05/10/12	09/11/12	BMCE-TRANSMIT-012216 (BMCE-WTRAN-04546)	30/11/12	03/12/12	A	06/12/12 BMCE-TRANSMIT-012805		
			ZBP	H	ZBP-XX-XX-SC-521-491	Secondary Heating Distribution Schematic Plantroom 124	31/08/12		A	05/10/12	18/12/12	BMCE-TRANSMIT-012940 (BMCE-WTRAN-005171)	08/01/13	07/01/13	A	16/01/13 BMCE-TRANSMIT-013348		
		Removed by ZBP	ZBP	H	ZBP-XX-XX-SC-521-492	Secondary Heating Distribution Schematic Plantroom 124	31/08/12			05/10/12			-					
		Issued for information on BMCE-TRANSMIT-018858 17/12/2013	ZBP	H	ZBP-XX-XX-SC-525-591	Secondary Chi led Water Distribution Schematic Plantroom 124	31/08/12		A	05/10/12	18/12/12	BMCE-TRANSMIT-012940 (BMCE-WTRAN-005171)	08/01/13	07/01/13	B	16/01/13 BMCE-TRANSMIT-013348		

Drawing Information

31 BCL-AC-XX-SH-001

1st Submission2nd Submission

			Action By	Zone	Drawing Number	Drawing Title	Date Required from Consultant	Date Submitted by Consultant	Document Revision	Planned Date to be Submitted to Board	Date Submitted to Board	BMCE Transmittal No	Date Response Required from Board	Date Returned from Board	Board Status	Date returned to Consultant	Date Required from Consultant	Date Submitted by Consultant
Item	Submission	Comments																
		Removed by ZBP	ZBP	H	ZBP-XX-XX-SC-525-592	Secondary Chi-led Water Distribution Schematic Plantroom-124	21/08/12			05/10/12			-					
	Lighting Layout																	
		This drawing was issued to the board for information only on BMCE-TRANSMIT-018592	MER	H	ME-SZ-01-PL-541-533	First Floor Plan HSGH Stroke Ward LightingLayout	21/10/11		B	05/12/11	22/12/11	BMCE-TRANSMIT-007175	12/01/12	09/02/12	B	15/02/12 BMCE-TRANSMIT-007641		
		This drawing was issued to the board for information only on BMCE-TRANSMIT-018592	MER	H	ME-SZ-01-PL-541-534	First Floor plan NSGH Radiology Lighting Layout	21/10/11		B	05/12/11	22/12/11	BMCE-TRANSMIT-007175	12/01/12	09/02/12	B	15/02/12 BMCE-TRANSMIT-007641		
		This drawing was issued to the board for information only on BMCE-TRANSMIT-018592	MER	H	ME-SZ-02-PL-541-525	Second Floor Plan NSGH Theatres AODOS & Recovery Lighting Layout	21/10/11		B	05/12/11	22/12/11	BMCE-TRANSMIT-007175	12/01/12	09/02/12	B	15/02/12 BMCE-TRANSMIT-007641		
			MER	H	ME-ZH-00-PL-541-506	Ground Floor Plan NSGH - Main Entrance Discharge Lounge Lighting Layout	21/10/11			05/12/11								
		Issued to board for information on BMCE-TRANSMIT-018891 18/12/13	MER	H	ME-ZH-00-PL-541-527	Ground Floor Plan NSGH AAU Lighting Layout	21/10/11		B	05/12/11	22/12/11	BMCE-TRANSMIT-007175	12/01/12	09/02/12	B	15/02/12 BMCE-TRANSMIT-007641		
		Issued to board for information on BMCE-TRANSMIT-018891 18/12/13	MER	H	ME-ZH-00-PL-541-530	Ground Floor Plan NSGH AAU Lighting Layout	21/10/11		B	05/12/11	22/12/11	BMCE-TRANSMIT-007175	12/01/12	09/02/12	B	15/02/12 BMCE-TRANSMIT-007641		
		Issued to board for information on BMCE-TRANSMIT-018891 18/12/13	MER	H	ME-ZH-01-PL-541-529	First Floor Plan NSGH Stroke Ward Lighting Layout	21/10/11		B	05/12/11	22/12/11	BMCE-TRANSMIT-007175	12/01/12	09/02/12	B	15/02/12 BMCE-TRANSMIT-007641		
		Issued to board for information on BMCE-TRANSMIT-018891 18/12/13	MER	H	ME-ZH-01-PL-541-530	First Floor Plan NSGH Stroke Ward Lighting Layout	21/10/11		B	05/12/11	22/12/11	BMCE-TRANSMIT-007175		09/02/12	B	15/02/12 BMCE-TRANSMIT-007641		
		Issued to board for information on BMCE-TRANSMIT-018891 18/12/13	MER	H	ME-ZH-01-PL-541-531	First Floor Plan NSGH MDU/Clinical Investigations Unit Lighting Layout	21/10/11		B	05/12/11	22/12/11	BMCE-TRANSMIT-007175		09/02/12	B	15/02/12 BMCE-TRANSMIT-007641		
		REMOVED BY MERCURY - DRAWING SUPERSEDED BY ME-ZH-01-PL-541-531	MER	H	ME-ZH-01-PL-541-532	First Floor Plan NSGH OPD Pre-Assessment Unit Lighting Layout	21/10/11			05/12/11			-					
		Issued to board for information on BMCE-TRANSMIT-018891 18/12/13	MER	H	ME-ZH-02-PL-541-527	Second Floor Plan NSGH Theatres Lighting Layout	21/10/11		B	05/12/11	22/12/11	BMCE-TRANSMIT-007175	12/01/12	09/02/12	B	15/02/12 BMCE-TRANSMIT-007641		
		Issued to board for information on BMCE-TRANSMIT-018891 18/12/13	MER	H	ME-ZH-02-PL-541-528	Second Floor Plan NSGH Theatres Lighting Layout	21/10/11		B	05/12/11	22/12/11	BMCE-TRANSMIT-007175	12/01/12	09/02/12	B	15/02/12 BMCE-TRANSMIT-007641		
		Issued to board for information on BMCE-TRANSMIT-018891 18/12/13	MER	H	ME-ZH-03-PL-541-527	Third Floor Plan Lighting Layout	21/10/11		B	05/12/11	22/12/11	BMCE-TRANSMIT-007175	12/01/12	09/02/12	B	15/02/12 BMCE-TRANSMIT-007641		
		Issued to board for information on BMCE-TRANSMIT-018891 18/12/13	MER	H	ME-ZH-03-PL-541-528	Third floor Plan Lighting Layout	21/10/11		B	05/12/11	22/12/11	BMCE-TRANSMIT-007175		09/02/12	B	15/02/12 BMCE-TRANSMIT-007641		
		Issued to board for information on BMCE-TRANSMIT-018891 18/12/13	MER	H	ME-ZH-04-PL-541-509	Fourth Floor Plan NSGH Renal Inpatients & Day Unit Lighting Layout	21/10/11		B	05/12/11	22/12/11	BMCE-TRANSMIT-007175		09/02/12	B	15/02/12 BMCE-TRANSMIT-007641		
		Issued to board for information on BMCE-TRANSMIT-018891 18/12/13	MER	H	ME-ZH-04-PL-541-510	Fourth Floor Plan NSGH Renal Inpatients & Day Unit Lighting Layout	21/10/11		B	05/12/11	22/12/11	BMCE-TRANSMIT-007175		09/02/12	B	15/02/12 BMCE-TRANSMIT-007641		
		Issued to board for information on BMCE-TRANSMIT-018891 18/12/13	MER	H	ME-ZH-04-PL-541-511	Fourth Floor Plan NSGH Renal Inpatients & Day Unit Lighting Layout	21/10/11		B	05/12/11	22/12/11	BMCE-TRANSMIT-007175		09/02/12	B	15/02/12 BMCE-TRANSMIT-007641		
		REMOVED BY MERCURY - ME-ZH-XX-PL-541-509 SUBMITTED FOR RDD REVIEW	MER	H	ME-ZH-05-PL-541-509	Fifth Floor Plan NSGH Inpatient Wards Lighting Layout	16/03/12			03/05/12			-					
		REMOVED BY MERCURY - ME-ZH-XX-PL-541-510 SUBMITTED FOR RDD REVIEW	MER	H	ME-ZH-05-PL-541-510	Fifth Floor Plan NSGH Inpatient Wards Lighting Layout	16/03/12			03/05/12			-					
		REMOVED BY MERCURY - ME-ZH-XX-PL-541-511 SUBMITTED FOR RDD REVIEW	MER	H	ME-ZH-05-PL-541-511	Fifth Floor Plan NSGH Inpatient Wards Lighting Layout	16/03/12			03/05/12			-					
			MER	H	ME-ZH-12-PL-541-509	Twelfth Floor Plan Plantrooms Ligthing Layout	21/10/11		B	05/12/11	22/12/11	BMCE-TRANSMIT-007175	12/01/12	09/02/12	A	15/02/12 BMCE-TRANSMIT-007641		
			MER	H	ME-ZH-12-PL-541-510	Twelfth Floor Plantrooms Lighting Layout	21/10/11		B	05/12/11	22/12/11	BMCE-TRANSMIT-007175	12/01/12	09/02/12	A	15/02/12 BMCE-TRANSMIT-007641		
			MER	H	ME-ZH-12-PL-541-511	Twelfth Floor Plan Plantroom Lighting Layout	21/10/11		B	05/12/11	22/12/11	BMCE-TRANSMIT-007175	12/01/12	09/02/12	A	15/02/12 BMCE-TRANSMIT-007641		
			MER	H	ME-ZH-XX-PL-541-509	Fifth to eleventh Floor Plan NSGH Inpatients Wards Lighting Layout	21/10/11		B	05/12/11	22/12/11	BMCE-TRANSMIT-007175	12/01/12	09/02/12	A	15/02/12 BMCE-TRANSMIT-007641		
		Issued to board for information on BMCE-TRANSMIT-018891 18/12/13	MER	H	ME-ZH-XX-PL-541-510	Fifth to eleventh Floor Plan NSGH Inpatients Wards Lighting Layout	21/10/11		B	05/12/11	22/12/11	BMCE-TRANSMIT-007175	12/01/12	09/02/12	B	15/02/12 BMCE-TRANSMIT-007641		
		Issued to board for information on BMCE-TRANSMIT-018891 18/12/13	MER	H	ME-ZH-XX-PL-541-511	Fifth to eleventh Floor Plan NSGH Inpatients Wards Lighting Layout	21/10/11		B	05/12/11	22/12/11	BMCE-TRANSMIT-007175 (RE-ISSUED 01.06.12 BMCE-TRANSMIT-009198)	12/01/12	19/06/12	B	19/06/12 BMCE-TRANSMIT-009412		
		REMOVED BY MERCURY - WRONG DRAWING NO,	MER	H	ME-XX-XX-SP-541-100	Lighting Calculations—Zone H				05/12/11			-					
	Small Power & General Services	Removed By Mercury - NOT REQUIRED FOR RDD (SMALL POWER SHOWN	MER	H	ME-ZH-00-PL-531-506	Ground Floor Plan NSGH - Main Entrance Discharge Lounge Small Power & General Services Layout	21/10/11			05/12/11			-					

Drawing Information

31

BCL-AC-XX-SH-001

1st Submission

2nd Submission

Item	Submission	Comments	Action By		Zone	Drawing Number	Drawing Title	Date Required from Consultant	Date Submitted by Consultant	Document Revision	Planned Date to be Submitted to Board	Date Submitted to Board	BMCE Transmittal No	Date Response Required from Board	Date Returned from Board	Board Status	Date returned to Consultant	Date Required from Consultant	Date Submitted by Consultant
		Removed By Mercury - NOT REQUIRED FOR RDD (SMALL POWER SHOWN ON NA 400 SERIES DRAWINGS)	MER		H	ME-ZH-02-PL-531-527	Second Floor Plan NSGH Theatres Small Power & General Ser-ices Layout	21/10/11			05/12/11			-					
		Removed By Mercury - NOT REQUIRED FOR RDD (SMALL POWER SHOWN ON NA 400 SERIES DRAWINGS)	MER		H	ME-ZH-02-PL-531-528	Second Floor Plan NSGH Theatres Small Power & General Ser-ices Layout	21/10/11			05/12/11			-					
		Removed By Mercury - NOT REQUIRED FOR RDD (SMALL POWER SHOWN ON NA 400 SERIES DRAWINGS)	MER		H	ME-ZH-04-PL-531-509	Fourth Floor Plan NSGH Renal Inpatients & Day Unit Small Power & General Ser-ices Layout	16/03/12			03/05/12			-					
		Removed By Mercury - NOT REQUIRED FOR RDD (SMALL POWER SHOWN ON NA 400 SERIES DRAWINGS)	MER		H	ME-ZH-04-PL-531-510	Fourth Floor Plan NSGH Renal Inpatients & Day Unit Small Power & General Ser-ices Layout	16/03/12			03/05/12			-					
		Removed By Mercury - NOT REQUIRED FOR RDD (SMALL POWER SHOWN ON NA 400 SERIES DRAWINGS)	MER		H	ME-ZH-04-PL-531-511	Fourth Floor Plan NSGH Renal Inpatients & Day Unit Small Power & General Services Layout	16/03/12			03/05/12			-					
		Removed By Mercury - NOT REQUIRED FOR RDD (SMALL POWER SHOWN ON NA 400 SERIES DRAWINGS)	MER		H	ME-ZH-05-PL-531-509	Fifth Floor Plan NSGH Inpatient Wards Small Power & General Ser-ices Layout	16/03/12			03/05/12			-					
		Removed By Mercury - NOT REQUIRED FOR RDD (SMALL POWER SHOWN ON NA 400 SERIES DRAWINGS)	MER		H	ME-ZH-05-PL-531-510	Fifth Floor Plan NSGH Inpatient Wards Small Power & General Ser-ices Layout	16/03/12			03/05/12			-					
		Removed By Mercury - NOT REQUIRED FOR RDD (SMALL POWER SHOWN ON NA 400 SERIES DRAWINGS)	MER		H	ME-ZH-05-PL-531-511	Fifth Floor Plan NSGH Inpatient Wards Small Power & General Ser-ices Layout	16/03/12			03/05/12			-					
	High Level Layout	Removed By Mercury - NOT REQUIRED FOR RDD (SMALL POWER SHOWN ON NA 400 SERIES DRAWINGS)	MER		H	ME-ZH-00-PL-532-506	Ground Floor Plan NSGH – Main Entrance Discharge Lounge High Level Layout	21/10/11			05/12/11			-					
		Removed By Mercury - NOT REQUIRED FOR RDD (SMALL POWER SHOWN ON NA 400 SERIES DRAWINGS)	MER		H	ME-ZH-00-PL-532-527	Ground Floor Plan NSGH AAU High Le- el Layout	21/10/11			05/12/11			-					
		Removed By Mercury - NOT REQUIRED FOR RDD (SMALL POWER SHOWN ON NA 400 SERIES DRAWINGS)	MER		H	ME-ZH-00-PL-532-530	Ground Floor Plan NSGH AAU High Le- el Layout	21/10/11			05/12/11			-					
		Removed By Mercury - NOT REQUIRED FOR RDD (SMALL POWER SHOWN ON NA 400 SERIES DRAWINGS)	MER		H	ME-ZH-01-PL-532-529	First Floor Plan NSGH Stroke Ward High Level Layout	21/10/11			05/12/11			-					
		Removed By Mercury - NOT REQUIRED FOR RDD (SMALL POWER SHOWN ON NA 400 SERIES DRAWINGS)	MER		H	ME-ZH-01-PL-532-530	First Floor Plan NSGH Stroke Ward High Le- el Layout	21/10/11			05/12/11			-					
		Removed By Mercury - NOT REQUIRED FOR RDD (SMALL POWER SHOWN ON NA 400 SERIES DRAWINGS)	MER		H	ME-ZH-01-PL-532-531	First Floor Plan NSGH MDU/Clinical In- estigations Unit High Le- el Layout	21/10/11			05/12/11			-					
		Removed By Mercury - NOT REQUIRED FOR RDD (SMALL POWER SHOWN ON NA 400 SERIES DRAWINGS)	MER		H	ME-ZH-01-PL-532-532	First Floor Plan NSGH OPD Pre Assessment Unit High Le- el Layout	21/10/11			05/12/11			-					
		Removed By Mercury - NOT REQUIRED FOR RDD (SMALL POWER SHOWN ON NA 400 SERIES DRAWINGS)	MER		H	ME-ZH-02-PL-532-527	Second Floor Plan NSGH Theatres High Level Layout	21/10/11			05/12/11			-					
		Removed By Mercury - NOT REQUIRED FOR RDD (SMALL POWER SHOWN ON NA 400 SERIES DRAWINGS)	MER		H	ME-ZH-02-PL-532-528	Second Floor Plan NSGH Theatres High Le- el Layout	21/10/11			05/12/11			-					
		Removed By Mercury - NOT REQUIRED FOR RDD (SMALL POWER SHOWN ON NA 400 SERIES DRAWINGS)	MER		H	ME-ZH-04-PL-532-509	Fourth Floor Plan NSGH Renal Inpatients & Day Unit High Le- el Layout	16/03/12			03/05/12			-					
		Removed By Mercury - NOT REQUIRED FOR RDD (SMALL POWER SHOWN ON NA 400 SERIES DRAWINGS)	MER		H	ME-ZH-04-PL-532-510	Fourth Floor Plan NSGH Renal Inpatients & Day Unit High Level Layout	16/03/12			03/05/12			-					
		Removed By Mercury - NOT REQUIRED FOR RDD (SMALL POWER SHOWN ON NA 400 SERIES DRAWINGS)	MER		H	ME-ZH-04-PL-532-511	Fourth Floor Plan NSGH Renal Inpatients & Day Unit High Level Layout	16/03/12			03/05/12			-					
		Removed By Mercury - NOT REQUIRED FOR RDD (SMALL POWER SHOWN ON NA 400 SERIES DRAWINGS)	MER		H	ME-ZH-05-PL-532-509	Fifth Floor Plan NSGH Inpatient Wards High Le- el Layout	16/03/12			03/05/12			-					
		Removed By Mercury - NOT REQUIRED FOR RDD (SMALL POWER SHOWN ON NA 400 SERIES DRAWINGS)	MER		H	ME-ZH-05-PL-532-510	Fifth Floor Plan NSGH Inpatient Wards High Le- el Layout	16/03/12			03/05/12			-					
		Removed By Mercury - NOT REQUIRED FOR RDD (SMALL POWER SHOWN ON NA 400 SERIES DRAWINGS)	MER		H	ME-ZH-05-PL-532-511	Fifth Floor Plan NSGH Inpatient Wards High Level Layout	16/03/12			03/05/12			-					
	Low Level Layout	Removed By Mercury - NOT REQUIRED FOR RDD (SMALL POWER SHOWN ON NA 400 SERIES DRAWINGS)	MER		H	ME-ZH-00-PL-532-506	Ground Floor Plan NSGH – Main Entrance Discharge Lounge ELV Systems low le- el Layout	21/10/11			05/12/11			-					
		Removed By Mercury - NOT REQUIRED FOR RDD (SMALL POWER SHOWN ON NA 400 SERIES DRAWINGS)	MER		H	ME-ZH-00-PL-532-527	Ground Floor Plan NSGH AAU ELV Systems low le- el Layout	21/10/11			05/12/11			-					
		Removed By Mercury - NOT REQUIRED FOR RDD (SMALL POWER SHOWN ON NA 400 SERIES DRAWINGS)	MER		H	ME-ZH-00-PL-532-530	Ground Floor Plan NSGH AAU ELV Systems low level Layout	21/10/11			05/12/11			-					
		Removed By Mercury - NOT REQUIRED FOR RDD (SMALL POWER SHOWN ON NA 400 SERIES DRAWINGS)	MER		H	ME-ZH-01-PL-532-529	First Floor Plan NSGH Stroke Ward ELV Systems low le- el Layout	21/10/11			05/12/11			-					
		Removed By Mercury - NOT REQUIRED FOR RDD (SMALL POWER SHOWN ON NA 400 SERIES DRAWINGS)	MER		H	ME-ZH-01-PL-532-530	First Floor Plan NSGH Stroke Ward ELV Systems low le- el Layout	21/10/11			05/12/11			-					
		Removed By Mercury - NOT REQUIRED FOR RDD (SMALL POWER SHOWN ON NA 400 SERIES DRAWINGS)	MER		H	ME-ZH-01-PL-532-531	First Floor Plan NSGH MDU/Clinical In- estigations Unit ELV Systems low level Layout	21/10/11			05/12/11			-					

Drawing Information

31 BCL-AC-XX-SH-001

1st Submission2nd Submission

Item	Submission	Comments	Action By		Zone	Drawing Number	Drawing Title	Date Required from Consultant	Date Submitted by Consultant	Document Revision	Planned Date to be Submitted to Board	Date Submitted to Board	BMCE Transmittal No	Date Response Required from Board	Date Returned from Board	Board Status	Date returned to Consultant	Date Required from Consultant	Date Submitted by Consultant
		Removed By Mercury - NOT REQUIRED FOR RDD (SMALL POWER SHOWN ON NA 400 SERIES DRAWINGS)	MER		H	ME-ZH-05-PL-532-509	Fifth Floor Plan NSGH Inpatient Wards ELV Systems low le- el- Layout	16/03/12			03/05/12			-					
		Removed By Mercury - NOT REQUIRED FOR RDD (SMALL POWER SHOWN ON NA 400 SERIES DRAWINGS)	MER		H	ME-ZH-05-PL-532-510	Fifth Floor Plan NSGH Inpatient Wards ELV Systems low le- el- Layout	16/03/12			03/05/12			-					
		Removed By Mercury - NOT REQUIRED FOR RDD (SMALL POWER SHOWN ON NA 400 SERIES DRAWINGS)	MER		H	ME-ZH-05-PL-532-511	Fifth Floor Plan NSGH Inpatient Wards ELV Systems low level- Layout	16/03/12			03/05/12			-					
		Removed By Mercury - NOT REQUIRED FOR RDD (SMALL POWER SHOWN ON NA 400 SERIES DRAWINGS)	MER		H	ME-ZH-05-PL-532-511	Ground Floor Plan NSGH - Main Entrance Discharge Lounge Data Comms Layout	21/10/11			06/12/11			-					
	Data Comms		MER		H	ME-ZH-00-PL-556-506	Ground Floor Plan NSGH - Main Entrance Discharge Lounge Data Comms Layout	21/10/11		B	05/12/11	24/03/14	BMCE-TRANSMIT-019750 (BMCE-WTRAN-010133)	14/04/14	22/04/14	A			
			MER		H	ME-SZ-01-PL-556-533	First Floor Plan NSGH Radiology Layout of Data Outlets	21/10/11		B	05/12/11	22/12/11	BMCE-TRANSMIT-007544	12/01/12	08/02/12	C	BMCE-TRANSMIT-007544 08/02/12		
			MER		H	ME-SZ-01-PL-556-534	First Floor Plan NSGH Radiology Layout of Data Outlets	21/10/11		B	05/12/11	22/12/11	BMCE-TRANSMIT-007544	12/01/12	08/02/12	C	BMCE-TRANSMIT-007544 08/02/12		
			MER		H	ME-SZ-02-PL-556-525	Second Floor Plan NSGH AODOS & Recovery Layout of Data Outlets	21/10/11		B	05/12/11	22/12/11	BMCE-TRANSMIT-007544	12/01/12	08/02/12	C	BMCE-TRANSMIT-007544 08/02/12		
			MER		H	ME-ZH-00-PL-556-527	Ground Floor Plan NSGH AAU Data Comms Layout	21/10/11		B	05/12/11	22/12/11	BMCE-TRANSMIT-007544	12/01/12	08/02/12	C	BMCE-TRANSMIT-007544 08/02/12		
			MER		H	ME-ZH-00-PL-556-530	Ground Floor Plan NSGH AAU Data Comms Layout	21/10/11		B	05/12/11	22/12/11	BMCE-TRANSMIT-007544	12/01/12	08/02/12	C	BMCE-TRANSMIT-007544 08/02/12		
			MER		H	ME-ZH-01-PL-556-529	First Floor Plan NSGH Stroke Ward Data Comms Layout	21/10/11		B	05/12/11	22/12/11	BMCE-TRANSMIT-007544	12/01/12	08/02/12	C	BMCE-TRANSMIT-007544 08/02/12		
			MER		H	ME-ZH-01-PL-556-530	First Floor Plan NSGH Stroke Ward Data Comms Layout	21/10/11		B	05/12/11	22/12/11	BMCE-TRANSMIT-007544	12/01/12	08/02/12	C	BMCE-TRANSMIT-007544 08/02/12		
			MER		H	ME-ZH-01-PL-556-531	First Floor Plan NSGH MDU/Clinical Investigations Unit Data Comms Layout	21/10/11		B	05/12/11	22/12/11	BMCE-TRANSMIT-007544	12/01/12	08/02/12	C	BMCE-TRANSMIT-007544 08/02/12		
		Removed by Mercury - DRAWING SUPERSEDED BY ME-ZH-01-PL-556-531	MER		H	ME-ZH-01-PL-556-532	First Floor Plan NSGH OPD Pre-Assessment Unit Data Comms Layout	21/10/11			06/12/11			21/01/00	06/02/12				
		Issued for information on BMCE-TRANSMIT-018891 18/12/13	MER		H	ME-ZH-02-PL-556-527	Second Floor Plan NSGH Theatres Data Comms Layout	21/10/11		B	05/12/11	22/12/11	BMCE-TRANSMIT-007544	12/01/12	08/02/12	B	BMCE-TRANSMIT-007544 08/02/12		
			MER		H	ME-ZH-02-PL-556-528	Second Floor Plan NSGH Theatres Data Comms Layout	21/10/11		B	05/12/11	22/12/11	BMCE-TRANSMIT-007544	12/01/12	08/02/12	A	BMCE-TRANSMIT-007544 08/02/12		
		Issued for information on BMCE-TRANSMIT-019288 04/02/14	MER		H	ME-ZH-04-PL-556-509	Fourth Floor Plan NSGH Renal Inpatients & Day Unit Data Comms Layout	21/10/11		B	05/12/11	22/12/11	BMCE-TRANSMIT-007544	12/01/12	08/02/12	C	BMCE-TRANSMIT-007544 08/02/12		
		Duplicate - Please refer to above drawing	MER		H	ME-ZH-04-PL-556-509	Fourth Floor Plan NSGH Renal Inpatients & Day Unit Data Comms Layout	21/10/11		B	05/12/11	22/12/11	BMCE-TRANSMIT-007544	12/01/12	08/02/12	E	BMCE-TRANSMIT-007544 08/02/12		
		Issued for information on BMCE-TRANSMIT-019288 04/02/14	MER		H	ME-ZH-04-PL-556-510	Fourth Floor Plan NSGH Renal Inpatients & Day Unit Data Comms Layout	21/10/11		B	05/12/11	22/12/11	BMCE-TRANSMIT-007544	12/01/12	08/02/12	C	BMCE-TRANSMIT-007544 08/02/12		
		Issued for information on BMCE-TRANSMIT-019841 02/04/2014	MER		H	ME-ZH-04-PL-556-511	Fourth Floor Plan NSGH Renal Inpatients & Day Unit Data Comms Layout	21/10/11		B	05/12/11	22/12/11	BMCE-TRANSMIT-007544	12/01/12	08/02/12	C	BMCE-TRANSMIT-007544 08/02/12		
			MER		H	ME-ZH-05-PL-556-509	Fifth Floor Plan NSGH Inpatient Wards Data Comms Layout	21/10/11		B	05/12/11	22/12/11	BMCE-TRANSMIT-007544	12/01/12	08/02/12	C	BMCE-TRANSMIT-007544 08/02/12		
			MER		H	ME-ZH-05-PL-556-510	Fifth Floor Plan NSGH Inpatient Wards Data Comms Layout	21/10/11		B	05/12/11	22/12/11	BMCE-TRANSMIT-007544	12/01/12	08/02/12	C	BMCE-TRANSMIT-007544 08/02/12		
			MER		H	ME-ZH-05-PL-556-511	Fifth Floor Plan NSGH Inpatient Wards Data Comms Layout	21/10/11		B	05/12/11	22/12/11	BMCE-TRANSMIT-007544	12/01/12	08/02/12	C	BMCE-TRANSMIT-007544 08/02/12		
	BMS	Removed By Mercury - NOT REQUIRED FOR RDD (PART OF BMS DETAIL DESIGN)	MER		H	ME-ZH-00-PL-660-506	Ground Floor Plan NSGH - Main Entrance Discharge Lounge BMS Layout	21/10/11			06/12/11			-					
		Removed By Mercury - NOT REQUIRED FOR RDD (PART OF BMS DETAIL DESIGN)	MER		H	ME-ZH-00-PL-660-527	Ground Floor Plan NSGH AAU BMS Layout	21/10/11			06/12/11			-					
		Removed By Mercury - NOT REQUIRED FOR RDD (PART OF BMS DETAIL DESIGN)	MER		H	ME-ZH-00-PL-660-530	Ground Floor Plan NSGH AAU BMS Layout	21/10/11			06/12/11			-					
		Removed By Mercury - NOT REQUIRED FOR RDD (PART OF BMS DETAIL DESIGN)	MER		H	ME-ZH-01-PL-660-529	First Floor Plan NSGH Stroke Ward BMS Layout	21/10/11			06/12/11			-					
		Removed By Mercury - NOT REQUIRED FOR RDD (PART OF BMS DETAIL DESIGN)	MER		H	ME-ZH-01-PL-660-530	First Floor Plan NSGH Stroke Ward BMS Layout	21/10/11			06/12/11			-					
		Removed By Mercury - NOT REQUIRED FOR RDD (PART OF BMS DETAIL DESIGN)	MER		H	ME-ZH-01-PL-660-531	First Floor Plan NSGH MDU/Clinical Investigations Unit BMS Layout	21/10/11			06/12/11			-					

Drawing Information

31

BCL-AC-XX-SH-001

1st Submission

2nd Submission

Item	Submission	Comments	Action By		Zone	Drawing Number	Drawing Title	Date Required from Consultant	Date Submitted by Consultant	Document Revision	Planned Date to be Submitted to Board	Date Submitted to Board	BMCE Transmittal No	Date Response Required from Board	Date Returned from Board	Board Status	Date returned to Consultant	Date Required from Consultant	Date Submitted by Consultant
		Not required for RDD Review - Issued to board for information only BMCE-TRANSMIT-001705	MER		H	ME-ZH-01-DC-H512-004	Level 1, Radiology Reception from RAF 016												
		Not required for RDD Review - Issued to board for information only BMCE-TRANSMIT-001706	MER		H	ME-ZH-04-DC-H512-001	Level 4, Renal Ward from RENW 154												
			MER		H	ME-ZH-00-PL-H512-001	Medical Gas Installation, Level 0, Zone H			1		29/05/12	BMCE-TRANSMIT-009131 (BMCE-WTRAN-003175)	19/06/12	24/09/12	C	27/09/12 BMCE-TRANSMIT-011199		
			MER		H	ME-ZH-01-PL-H512-001	Medical Gas Installation, Level 1, Zone H			1		29/05/12	BMCE-TRANSMIT-009127 (BMCE-WTRAN-003174)	19/06/12	24/09/12	C	27/09/12 BMCE-TRANSMIT-011196		
			MER		H	ME-ZH-01-PL-H512-002	Medical Gas Installation, Level 1, Zone H - AGSS			1		29/05/12	BMCE-TRANSMIT-009127 (BMCE-WTRAN-003174)	19/06/12	24/09/12	C	27/09/12 BMCE-TRANSMIT-011196		
		Issued for information on BMCE-TRANSMIT-019817 31/03/14	MER		H	ME-ZH-02-PL-H512-001	Medical Gas Installation, Level 2, Zone H			1		29/05/12	BMCE-TRANSMIT-009123 (BMCE-WTRAN-003172)	19/06/12	24/09/12	C	27/09/12 BMCE-TRANSMIT-011202		
			MER		H	ME-ZH-02-PL-H512-002	Medical Gas Installation, Level 2, Zone H - AGSS			1		29/05/12	BMCE-TRANSMIT-009123 (BMCE-WTRAN-003172)	19/06/12	24/09/12	C	27/09/12 BMCE-TRANSMIT-011202		
		Issued for information on BMCE-TRANSMIT-019817 31/03/14	MER		H	ME-ZH-04-PL-H512-001	Medical Gas Installation, Level 4, Zone H			1		29/05/12	BMCE-TRANSMIT-009122 (BMCE-WTRAN-003171)	19/06/12	01/10/12	C	04/10/12 BMCE-TRANSMIT-011324		
			MER		H	ME-ZH-05-PL-H512-001	Medical Gas Installation, Level 5, Zone H			1		29/05/12	BMCE-TRANSMIT-009111 (BMCE-WTRAN-003165)	19/06/12	01/10/12	C	04/10/2012 BMCE-TRANSMIT-011331		
			MER		H	ME-ZH-06-PL-H512-001	Medical Gas Installation, Level 6, Zone H			1		29/05/12	BMCE-TRANSMIT-009119 (BMCE-WTRAN-003169)	19/06/12	01/10/12	C	04/10/12 BMCE-TRANSMIT-011329		
			MER		H	ME-ZH-07-PL-H512-001	Medical Gas Installation, Level 7, Zone H			1		29/05/12	BMCE-TRANSMIT-009109 (BMCE-WTRAN-003163)	19/06/12	01/10/12	C	04/10/12 BMCE-TRANSMIT-011327		
			MER		H	ME-ZH-08-PL-H512-001	Medical Gas Installation, Level 8, Zone H			1		29/05/12	BMCE-TRANSMIT-009115 (BMCE-WTRAN-003166)	19/06/12	01/10/12	C	04/10/12 BMCE-TRANSMIT-011326		
			MER		H	ME-ZH-09-PL-H512-001	Medical Gas Installation, Level 9, Zone H			1		29/05/12	BMCE-TRANSMIT-009117 (BMCE-WTRAN-003167)	19/06/12	01/10/12	C	04/10/12 BMCE-TRANSMIT-011323		
			MER		H	ME-ZH-10-PL-H512-001	Medical Gas Installation, Level 10, Zone H			1		29/05/12	BMCE-TRANSMIT-009120 (BMCE-WTRAN-003170)	19/06/12	01/10/12	C	04/10/12 BMCE-TRANSMIT-011327		
			MER		H	ME-ZH-11-PL-H512-001	Medical Gas Installation, Level 11, Zone H			1		29/05/12	BMCE-TRANSMIT-009118 (BMCE-WTRAN-003168)	19/06/12	01/10/12	C	04/10/12 BMCE-TRANSMIT-011327		
	MEDICAL-GASES	Removed By Mercury - NOT REQUIRED FOR RDD (REFER TO HPI H512 SERIES DESIGN DRAWINGS)	MER		H	ME-ZH-00-PL-512-506	Ground Floor Plan NSGH - Main Entrance Discharge Lounge Medical Gases Layout	21/10/11			06/12/11			-					
		Removed By Mercury - NOT REQUIRED FOR RDD (REFER TO HPI H512 SERIES DESIGN DRAWINGS)	MER		H	ME-ZH-00-PL-512-527	Ground Floor Plan NSGH AAU Medical Gases Layout	21/10/11			06/12/11			-					
		Removed By Mercury - NOT REQUIRED FOR RDD (REFER TO HPI H512 SERIES DESIGN DRAWINGS)	MER		H	ME-ZH-00-PL-512-530	Ground Floor Plan NSGH AAU Medical Gases Layout	21/10/11			06/12/11			-					
		Removed By Mercury - NOT REQUIRED FOR RDD (REFER TO HPI H512 SERIES DESIGN DRAWINGS)	MER		H	ME-ZH-01-PL-512-529	First Floor Plan NSGH Stroke Ward Medical Gases Layout	21/10/11			06/12/11			-					
		Removed By Mercury - NOT REQUIRED FOR RDD (REFER TO HPI H512 SERIES DESIGN DRAWINGS)	MER		H	ME-ZH-01-PL-512-530	First Floor Plan NSGH Stroke Ward Medical Gases Layout	21/10/11			06/12/11			-					
		Removed By Mercury - NOT REQUIRED FOR RDD (REFER TO HPI H512 SERIES DESIGN DRAWINGS)	MER		H	ME-ZH-01-PL-512-531	First Floor Plan NSGH MDU Clinical Investigations Unit Medical Gases Layout	21/10/11			06/12/11			-					
		Removed By Mercury - NOT REQUIRED FOR RDD (REFER TO HPI H512 SERIES DESIGN DRAWINGS)	MER		H	ME-ZH-01-PL-512-532	First Floor Plan NSGH OPD Pre Assessment Unit Medical Gases Layout	21/10/11			06/12/11			-					
		Removed By Mercury - NOT REQUIRED FOR RDD (REFER TO HPI H512 SERIES DESIGN DRAWINGS)	MER		H	ME-ZH-02-PL-512-527	Second Floor Plan NSGH Theatres Medical Gases Layout	21/10/11			06/12/11			-					
		Removed By Mercury - NOT REQUIRED FOR RDD (REFER TO HPI H512 SERIES DESIGN DRAWINGS)	MER		H	ME-ZH-02-PL-512-528	Second Floor Plan NSGH Theatres Medical Gases Layout	21/10/11			06/12/11			-					
		Removed By Mercury - NOT REQUIRED FOR RDD (REFER TO HPI H512 SERIES DESIGN DRAWINGS)	MER		H	ME-ZH-04-PL-512-509	Fourth Floor Plan NSGH Renal Inpatients & Day Unit Medical Gases Layout	21/10/11						-					
		Removed By Mercury - NOT REQUIRED FOR RDD (REFER TO HPI H512 SERIES DESIGN DRAWINGS)	MER		H	ME-ZH-04-PL-512-510	Fourth Floor Plan NSGH Renal Inpatients & Day Unit Medical Gases Layout	21/10/11						-					
		Removed By Mercury - NOT REQUIRED FOR RDD (REFER TO HPI H512 SERIES DESIGN DRAWINGS)	MER		H	ME-ZH-04-PL-512-511	Fourth Floor Plan NSGH Renal Inpatients & Day Unit Medical Gases Layout	21/10/11						-					
		Removed By Mercury - NOT REQUIRED FOR RDD (REFER TO HPI H512 SERIES DESIGN DRAWINGS)	MER		H	ME-ZH-05-PL-512-509	Fifth Floor Plan NSGH Inpatient Wards Medical Gases Layout	21/10/11						-					
		Removed By Mercury - NOT REQUIRED FOR RDD (REFER TO HPI H512 SERIES DESIGN DRAWINGS)	MER		H	ME-ZH-05-PL-512-510	Fifth Floor Plan NSGH Inpatient Wards Medical Gases Layout	21/10/11						-					
		Removed By Mercury - NOT REQUIRED FOR RDD (REFER TO HPI H512 SERIES DESIGN DRAWINGS)	MER		H	ME-ZH-05-PL-512-511	Fifth Floor Plan NSGH Inpatient Wards Medical Gases Layout	21/10/11						-					

Drawing Information

31 BCL-AC-XX-SH-001

1st Submission2nd Submission

			Action By	Zone	Drawing Number	Drawing Title	Date Required from Consultant	Date Submitted by Consultant	Document Revision	Planned Date to be Submitted to Board	Date Submitted to Board	BMCE Transmittal No	Date Response Required from Board	Date Returned from Board	Board Status	Date returned to Consultant	Date Required from Consultant	Date Submitted by Consultant
Item	Submission	Comments																
			MER	H	ME-ZH-04-PL-571-511	Fourth Floor Plan NSGH Renal Inpatients & Day Unit CCTV/DoorAccess Layout	21/10/11		B	05/12/11	22/12/11	BMCE-TRANSMIT-007177	12/01/12	12/07/12	A	15/08/12 BMCE-TRANSMIT-010326		
			MER	H	ME-ZH-05-PL-571-509	Fifth Floor Plan NSGH Renal Inpatients & Day Unit CCTV/Door Access Layout	21/10/11		B	05/12/11	22/12/11	BMCE-TRANSMIT-007177	12/01/12	12/07/12	A	15/08/12 BMCE-TRANSMIT-010326		
			MER	H	ME-ZH-05-PL-571-511	Fifth Floor Plan NSGH Renal Inpatient & Day Unit CCTV/Door Access Layout	21/10/11		B	05/12/11	22/12/11	BMCE-TRANSMIT-007177	12/01/12	12/07/12	A	15/08/12 BMCE-TRANSMIT-010326		
			MER	H	ME-ZH-XX-PL-571-509	Sixth to Eleventh Floor Plan NSGH Inpatient Ward CCTV/Door Access	21/10/11		B	05/12/11	22/12/11	BMCE-TRANSMIT-007177	12/01/12	12/07/12	A	15/08/12 BMCE-TRANSMIT-010326		
			MER	H	ME-ZH-XX-PL-571-511	Sixth to Eleventh Floor Plan NSGH Inpatient Ward CCTV/Door Access	21/10/11		B	05/12/11	22/12/11	BMCE-TRANSMIT-007177	12/01/12	12/07/12	A	15/08/12 BMCE-TRANSMIT-010326		
	Fire Detection & Smoke Control	This drawing was issue to the board for information only on BME-TRANSMIT-018592 26/11/13	MER	H	ME-SZ-01-PL-572-533	First Floor Plan NSGH Radiology Fire Detection Layout	21/10/11		G	05/12/11	26/02/13	BMCE-TRANSMIT-014130 (BMCE-WTRAN-006180)	19/03/13	25/03/13	B	03/05/13 BMCE-TRANSMIT-014609		
		This drawing was issue to the board for information only on BME-TRANSMIT-018592 26/11/13	MER	H	ME-SZ-01-PL-572-534	First Floor Plan NSGH Radiology Fire Detection Layout	21/10/11		G	05/12/11	26/02/13	BMCE-TRANSMIT-014130 (BMCE-WTRAN-006180)	19/03/13	25/03/13	B	03/05/13 BMCE-TRANSMIT-014609		
			MER	H	ME-SZ-02-PL-572-525	Second Floor Plan NSGH Theatres, AODOS & Recovery Fire Detection Layout	21/10/11		E	05/12/11	26/02/13	BMCE-TRANSMIT-014130 (BMCE-WTRAN-006180)	19/03/13	25/03/13	A	03/05/13 BMCE-TRANSMIT-014609		
			MER	H	ME-ZH-00-PL-572-506	Ground Floor Plan NSGH - Main Entrance Discharge Lounge Fire Detection & Smoke Control Layout	21/10/11		D	05/12/11	24/03/14	BMCE-TRANSMIT-019750 (BMCE-WTRAN-010133)	14/04/14	22/04/14	A			
		Issued for information on BMCE-TRANSMIT-018891 18/12/13	MER	H	ME-ZH-00-PL-572-527	Ground Floor Plan NSGH AAU Fire Detection & Smoke Control Layout	21/10/11		B	05/12/11	22/12/11	BMCE-TRANSMIT-007173	12/01/12	13/02/12	B	13/02/12 BMCE-TRANSMIT-007570		
		Issued for information on BMCE-TRANSMIT-018891 18/12/13	MER	H	ME-ZH-00-PL-572-530	Ground Floor Plan NSGH AAU Fire Detection & Smoke Control Layout	21/10/11		B	05/12/11	22/12/11	BMCE-TRANSMIT-007173	12/01/12	13/02/12	B	13/02/12 BMCE-TRANSMIT-007570		
		Issued for information on BMCE-TRANSMIT-018891 18/12/13	MER	H	ME-ZH-01-PL-572-529	First Floor Plan NSGH Stroke Ward Fire Detection & Smoke Control Layout	21/10/11		B	05/12/11	22/12/11	BMCE-TRANSMIT-007173	12/01/12	13/02/12	B	13/02/12 BMCE-TRANSMIT-007570		
			MER	H	ME-ZH-01-PL-572-530	First Floor Plan NSGH Stroke Ward Fire Detection & Smoke Control Layout	21/10/11		B	05/12/11	22/12/11	BMCE-TRANSMIT-007173	12/01/12	13/02/12	A	13/02/12 BMCE-TRANSMIT-007570		
		Issued for information on BMCE-TRANSMIT-018891 18/12/13	MER	H	ME-ZH-01-PL-572-531	First Floor Plan NSGH MDU/Clinical Investigations Unit Fire Detection & Smoke Control Layout	21/10/11		B	05/12/11	22/12/11	BMCE-TRANSMIT-007173	12/01/12	13/02/12	B	13/02/12 BMCE-TRANSMIT-007570		
		Removed by Mercury - DRAWING SUPERSEDED BY ME-ZH-01-PL-572-531	MER	H	ME-ZH-01-PL-572-532	First Floor Plan NSGH OPD Pre Assessment Unit Fire Detection & Smoke Control Layout	21/10/11			06/12/11			21/01/00					
		Issued for information on BMCE-TRANSMIT-018891 18/12/13	MER	H	ME-ZH-02-PL-572-527	Second Floor Plan NSGH Theatres Fire Detection & Smoke Control Layout	21/10/11		B	05/12/11	22/12/11	BMCE-TRANSMIT-007173	12/01/12	13/02/12	B	13/02/12 BMCE-TRANSMIT-007570		
		Issued for information on BMCE-TRANSMIT-018891 18/12/13	MER	H	ME-ZH-02-PL-572-528	Second Floor Plan NSGH Theatres Fire Detection & Smoke Control Layout	21/10/11		B	05/12/11	22/12/11	BMCE-TRANSMIT-007173	12/01/12	13/02/12	B	13/02/12 BMCE-TRANSMIT-007570		
			MER	H	ME-ZH-03-PL-575-527	Third Floor Plan Fire Detection	21/10/11		B	05/12/11	22/12/11	BMCE-TRANSMIT-007173	12/01/12	13/02/12	A	13/02/12 BMCE-TRANSMIT-007570		
		Issued for information on BMCE-TRANSMIT-018891 18/12/13	MER	H	ME-ZH-03-PL-572-528	Third Floor Plan Fire Detection	21/10/11		B	05/12/11	22/12/11	BMCE-TRANSMIT-007173	12/01/12	13/02/12	B	13/02/12 BMCE-TRANSMIT-007570		
		Issued for information on BMCE-TRANSMIT-018891 18/12/13	MER	H	ME-ZH-04-PL-572-509	Fourth Floor Plan NSGH Renal Inpatients & Day Unit Fire Detection & Smoke Control Layout	21/10/11		B	05/12/11	22/12/11	BMCE-TRANSMIT-007173	12/01/12	13/02/12	B	13/02/12 BMCE-TRANSMIT-007570		
		Issued for information on BMCE-TRANSMIT-018891 18/12/13	MER	H	ME-ZH-04-PL-572-510	Fourth Floor Plan NSGH Renal Inpatients & Day Unit Fire Detection & Smoke Control Layout	21/10/11		B	05/12/11	22/12/11	BMCE-TRANSMIT-007173	12/01/12	13/02/12	B	13/02/12 BMCE-TRANSMIT-007570		
			MER	H	ME-ZH-04-PL-572-511	Fourth Floor Plan NSGH Renal Inpatients & Day Unit Fire Detection & Smoke Control Layout	21/11/11		B	05/12/11	22/12/11	BMCE-TRANSMIT-007173	12/01/12	13/02/12	A			
		Removed by Mercury - ME-ZH-XX-PL-572-509 SUBMITTED FOR RDD REVIEW	MER	H	ME-ZH-05-PL-572-509	Fifth Floor Plan NSGH Inpatient Wards Fire Detection & Smoke Control Layout	21/11/11			06/12/11			21/01/00					
		Removed by Mercury - ME-ZH-XX-PL-572-510 SUBMITTED FOR RDD REVIEW	MER	H	ME-ZH-05-PL-572-510	Fifth Floor Plan NSGH Inpatient Wards Fire Detection & Smoke Control Layout	21/11/11			06/12/11			21/01/00					
		Removed by Mercury - ME-ZH-XX-PL-572-511 SUBMITTED FOR RDD REVIEW	MER	H	ME-ZH-05-PL-572-511	Fifth Floor Plan NSGH Inpatient Wards Fire Detection & Smoke Control Layout	16/03/12			03/06/12			21/01/00					
		Issued for information on BMCE-TRANSMIT-018891 18/12/13	MER	H	ME-ZH-12-PL-572-509	Twelfth Floor Plan NSGH Plantrooms Fire Detection Layout	21/11/11		B	05/12/11	22/12/11	BMCE-TRANSMIT-007173	12/01/12	13/02/12	B	13/02/12 BMCE-TRANSMIT-007570		
		Issued for information on BMCE-TRANSMIT-018891 18/12/13	MER	H	ME-ZH-12-PL-572-510	Twelfth Floor Plan NSGH Plantrooms Fire Detection Layout	21/11/11		B	05/12/11	22/12/11	BMCE-TRANSMIT-007173	12/01/12	13/02/12	B	13/02/12 BMCE-TRANSMIT-007570		
		Issued for information on BMCE-TRANSMIT-018891 18/12/13	MER	H	ME-ZH-12-PL-572-511	Twelfth Floor Plan NSGH Plantrooms Fire Detection Layout	21/11/11		B	05/12/11	22/12/11	BMCE-TRANSMIT-007173	12/01/12	13/02/12	B	13/02/12 BMCE-TRANSMIT-007570		
			MER	H	ME-ZH-XX-PL-572-509	Fifth to Eleventh Floor Plan NSGH Inpatients Wards FireDetection Layout	21/11/11		B	05/12/11	22/12/11	BMCE-TRANSMIT-007173	12/01/12	13/02/12	A	13/02/12 BMCE-TRANSMIT-007570		
		Issued for information on BMCE-TRANSMIT-018891 18/12/13	MER	H	ME-ZH-XX-PL-572-510	Fifth to Eleventh Floor Plan NSGH Inpatients Wards FireDetection Layout	21/11/11		B	05/12/11	22/12/11	BMCE-TRANSMIT-007173	12/01/12	13/02/12	B	13/02/12 BMCE-TRANSMIT-007570		

Drawing Information

31 BCL-AC-XX-SH-001

1st Submission2nd Submission

			Action By	Zone	Drawing Number	Drawing Title	Date Required from Consultant	Date Submitted by Consultant	Document Revision	Planned Date to be Submitted to Board	Date Submitted to Board	BMCE Transmittal No	Date Response Required from Board	Date Returned from Board	Board Status	Date returned to Consultant	Date Required from Consultant	Date Submitted by Consultant
Item	Submission	Comments																
		Issued for information on BMCE-TRANSMIT-019712 18/03/14	MER	H	ME-ZH-05-PL-575-305	Fifth Floor Ceiling Layout	21/10/11		B	05/12/11	22/12/11	BMCE-TRANSMIT-007172	12/01/12	13/02/12	B	13/02/12 BMCE-TRANSMIT-007568		
		Issued for information on BMCE-TRANSMIT-019712 18/03/14	MER	H	ME-ZH-06-PL-575-304	Sixth Floor Void Layout	21/10/11		B	05/12/11	22/12/11	BMCE-TRANSMIT-007172	12/01/12	13/02/12	B	13/02/12 BMCE-TRANSMIT-007568		
		Issued for information on BMCE-TRANSMIT-019712 18/03/14	MER	H	ME-ZH-06-PL-575-305	Sixth Floor Ceiling Layout	21/10/11		B	05/12/11	22/12/11	BMCE-TRANSMIT-007172	12/01/12	13/02/12	B	13/02/12 BMCE-TRANSMIT-007568		
		Issued for information on BMCE-TRANSMIT-019712 18/03/14	MER	H	ME-ZH-07-PL-575-304	Seventh Floor Void Layout	21/10/11		B	05/12/11	22/12/11	BMCE-TRANSMIT-007172	12/01/12	13/02/12	B	13/02/12 BMCE-TRANSMIT-007568		
		Issued for information on BMCE-TRANSMIT-019712 18/03/14	MER	H	ME-ZH-07-PL-575-305	Seventh Floor Ceiling Layout	21/10/11		B	05/12/11	22/12/11	BMCE-TRANSMIT-007172	12/01/12	13/02/12	B	13/02/12 BMCE-TRANSMIT-007568		
		Issued for information on BMCE-TRANSMIT-019712 18/03/14	MER	H	ME-ZH-08-PL-575-304	Eighth Floor Void Layout	21/10/11		B	05/12/11	22/12/11	BMCE-TRANSMIT-007172	12/01/12	13/02/12	B	13/02/12 BMCE-TRANSMIT-007568		
		Issued for information on BMCE-TRANSMIT-019712 18/03/14	MER	H	ME-ZH-08-PL-575-305	Eighth Floor Ceiling Layout	21/10/11		B	05/12/11	22/12/11	BMCE-TRANSMIT-007172	12/01/12	13/02/12	B	13/02/12 BMCE-TRANSMIT-007568		
		Issued for information on BMCE-TRANSMIT-019712 18/03/14	MER	H	ME-ZH-09-PL-575-304	Ninth Floor Void Layout	21/10/11		B	05/12/11	22/12/11	BMCE-TRANSMIT-007172	12/01/12	13/02/12	B	13/02/12 BMCE-TRANSMIT-007568		
		Issued for information on BMCE-TRANSMIT-019712 18/03/14	MER	H	ME-ZH-09-PL-575-305	Ninth Floor Ceiling Layout	21/10/11		B	05/12/11	22/12/11	BMCE-TRANSMIT-007172	12/01/12	13/02/12	B	13/02/12 BMCE-TRANSMIT-007568		
		Issued for information on BMCE-TRANSMIT-019712 18/03/14	MER	H	ME-ZH-10-PL-575-304	Tenth Floor Void Layout	21/10/11		B	05/12/11	22/12/11	BMCE-TRANSMIT-007172	12/01/12	13/02/12	B	13/02/12 BMCE-TRANSMIT-007568		
		Issued for information on BMCE-TRANSMIT-019712 18/03/14	MER	H	ME-ZH-10-PL-575-305	Tenth Floor Ceiling Layout	21/10/11		B	05/12/11	22/12/11	BMCE-TRANSMIT-007172	12/01/12	13/02/12	B	13/02/12 BMCE-TRANSMIT-007568		
		Issued for information on BMCE-TRANSMIT-019712 18/03/14	MER	H	ME-ZH-11-PL-575-304	Eleventh floor Void Layout	21/10/11		B	05/12/11	22/12/11	BMCE-TRANSMIT-007172	12/01/12	13/02/12	B	13/02/12 BMCE-TRANSMIT-007568		
		Issued for information on BMCE-TRANSMIT-019712 18/03/14	MER	H	ME-ZH-11-PL-575-305	Eleventh Floor Ceiling Layout	21/10/11		B	05/12/11	22/12/11	BMCE-TRANSMIT-007172	12/01/12	13/02/12	B	13/02/12 BMCE-TRANSMIT-007568		
			MER	H	ME-ZH-12-PL-575-304	Twelfth Floor Void Layout	21/10/11		B	05/12/11	22/12/11	BMCE-TRANSMIT-007172	12/01/12	13/02/12	A	13/02/12 BMCE-TRANSMIT-007568		
	Pneumatic Tube System		MER	H	ME-ZH-00-PL-569-001	Ground Floor Plan Pneumatic Tube System			B		22/12/11	BMCE-TRANSMIT-007178	12/01/12	13/02/12	A	14/02/12 BMCE-TRANSMIT-		
			MER	H	ME-ZH-01-PL-569-002	First Floor plan Pneumatic Tube System			B		22/12/11	BMCE-TRANSMIT-007178	12/01/12	13/02/12	A	14/02/12 BMCE-TRANSMIT-		
			MER	H	ME-ZH-02-PL-569-003	Second Floor Plan Pneumatic Tube System			B		22/12/11	BMCE-TRANSMIT-007178	12/01/12	13/02/12	A	14/02/12 BMCE-TRANSMIT-		
			MER	H	ME-ZH-03-PL-569-004	Third Floor Plan Pneumatic Tube System			B		22/12/11	BMCE-TRANSMIT-007178	12/01/12	13/02/12	A	14/02/12 BMCE-TRANSMIT-		
			MER	H	ME-ZH-04-PL-569-005	Fourth Floor Plan Pneumatic Tube System			B		22/12/11	BMCE-TRANSMIT-007178	12/01/12	13/02/12	A	14/02/12 BMCE-TRANSMIT-		
			MER	H	ME-ZH-05-PL-569-006	Fifth Floor Plan Pneumatic Tube System			B		22/12/11	BMCE-TRANSMIT-007178	12/01/12	13/02/12	A	14/02/12 BMCE-TRANSMIT-		
			MER	H	ME-ZH-06-PL-569-007	Sixth Floor Plan Pneumatic Tube System			B		22/12/11	BMCE-TRANSMIT-007178	12/01/12	13/02/12	A	14/02/12 BMCE-TRANSMIT-		
			MER	H	ME-ZH-07-PL-569-008	Seventh Floor Plan Pneumatic Tube System			B		22/12/11	BMCE-TRANSMIT-007178	12/01/12	13/02/12	A	14/02/12 BMCE-TRANSMIT-		
			MER	H	ME-ZH-08-PL-569-009	Eighth Floor Plan Pneumatic Tube System			B		22/12/11	BMCE-TRANSMIT-007178	12/01/12	13/02/12	A	14/02/12 BMCE-TRANSMIT-		
			MER	H	ME-ZH-09-PL-569-010	Ninth Floor Plan Pneumatic Tube System			B		22/12/11	BMCE-TRANSMIT-007178	12/01/12	13/02/12	A	14/02/12 BMCE-TRANSMIT-		
			MER	H	ME-ZH-10-PL-569-011	Tenth Floor Plan Pneumatic Tube System			B		22/12/11	BMCE-TRANSMIT-007178	12/01/12	13/02/12	A	14/02/12 BMCE-TRANSMIT-		
			MER	H	ME-ZH-11-PL-569-012	Eleventh Floor Plan Pneumatic Tube System			B		22/12/11	BMCE-TRANSMIT-007178	12/01/12	13/02/12	A	14/02/12 BMCE-TRANSMIT-		
			MER	H	ME-ZH-12-PL-569-013	Twelfth Floor Plan Pneumatic System			B		22/12/11	BMCE-TRANSMIT-007178	12/01/12	13/02/12	A	14/02/12 BMCE-TRANSMIT-		
	Nurse Call		MER	H	ME-ZH-00-PL-538-527	Ground Floor Plan NSGH - AAU Nurse Call Layout	21/06/11		B	02/12/11	22/12/11	BMCE-TRANSMIT-007174	12/01/12	13/07/12	A	15/08/12 BMCE-TRANSMIT-010331		
			MER	H	ME-ZH-00-PL-538-530	Ground Floor Plan NSGH - AAU Nurse Call Layout	21/06/11		B	02/12/11	22/12/11	BMCE-TRANSMIT-007174	12/01/12	13/07/12	A	15/08/12 BMCE-TRANSMIT-		

Drawing Information

31	BCL-AC-XX-SH-001						1st Submission										2nd Submission				
							Date Required from Consultant	Date Submitted by Consultant	Document Revision	Planned Date to be Submitted to Board	Date Submitted to Board	BMCE Transmittal No	Date Response Required from Board	Date Returned from Board	Board Status	Date returned to Consultant	Date Required from Consultant	Date Submitted by Consultant			
Item	Submission	Comments	Action By	Zone	Drawing Number	Drawing Title															
		Issued for information on BMCE-TRANSMIT-01889118/12/13	MER	H	ME-ZH-XX-PL-538-510	Fifth to Eleventh Floor Plan NSGH Inpatients Wards nurse Ca I Layout	16/03/12			B	03/05/12	22/12/11	BMCE-TRANSMIT-007174	12/01/12	13/07/12	B	15/08/12 BMCE-TRANSMIT-010331				
			MER	H	ME-ZH-XX-PL-538-511	Fifth to Eleventh Floor Plan NSGH Inpatients Wards nurse Ca I Layout	16/03/12			B	03/05/12	22/12/11	BMCE-TRANSMIT-007174	12/01/12	13/07/12	A	15/08/12 BMCE-TRANSMIT-010331				
	Mechanical Services DrawingsHospital Drawings - Zone J	This was issued to board for information on BMCE-TRANSMIT-018565 22/11/13	ZBP	J	ZBP-ZJ-00-PL-512-009	Medical Gases Layout Ground	04/05/12			A	31/05/12	02/05/12	BMCE-TRANSMIT-008652 (BMCE-WTRAN-002980)	23/05/12	06/07/12	B	17/07/12 BMCE-TRANSMIT-009877				
			ZBP	J	ZBP-ZJ-01-PL-512-019	Medical Gases Layout First	04/05/12			A	31/05/12	02/05/12	BMCE-TRANSMIT-008652 (BMCE-WTRAN-002980)	23/05/12	06/07/12	A	17/07/12 BMCE-TRANSMIT-009877				

Drawing Information

31 BCL-AC-XX-SH-001

1st Submission2nd Submission

			Action By	Zone	Drawing Number	Drawing Title	Date Required from Consultant	Date Submitted by Consultant	Document Revision	Planned Date to be Submitted to Board	Date Submitted to Board	BMCE Transmittal No	Date Response Required from Board	Date Returned from Board	Board Status	Date returned to Consultant	Date Required from Consultant	Date Submitted by Consultant
Item	Submission	Comments																
		This was issued to board for information on BMCE-TRANSMIT-018565 22/11/13	ZBP	J	ZBP-ZJ-02-PL-512-029	Medical Gases Layout Second	04/05/12		A	31/05/12	02/05/12	BMCE-TRANSMIT-008652 (BMCE-WTRAN-002980)	23/05/12	06/07/12	B	17/07/12 BMCE-TRANSMIT-009877		
		ZBP drawings not to be reviewed as not HPI drawings	ZBP	J	ZBP-ZJ-04-PL-512-049	Medical Gases Layout Fourth	16/03/12		A	03/05/12	11/12/12	BMCE-TRANSMIT-012841 (BMCE-WTRAN-006109)	07/01/12					
			ZBP	J	ZBP-ZJ-11-PL-512-119	Ventilation Layout Eleventh			A									
		ZBP drawings not to be reviewed as not HPI drawings	ZBP	J	ZBP-ZJ-XX-PL-512-059	Medical Gases Layout Generic Ward			A		11/12/12	BMCE-TRANSMIT-012841 (BMCE-WTRAN-006109)	07/01/12					
		DRAWING NUMBER CHANGED DRAWING DELETED BY ZBP	ZBP	J	ZBP-ZJ-XX-PL-512-069	Medical Gases Layout Generic Ward	04/05/12			31/05/12			-					
		This was issued to board for information on BMCE-TRANSMIT-018565 22/11/13	ZBP	J	ZBP-ZJ-00-PL-523-009	HTG & CHW Layout Ground	04/05/12		B	31/05/12	22/11/12	BMCE-TRANSMIT-012401 (BMCE-WTRAN-004630)	13/12/12	03/12/12	B	06/12/12 BMCE-TRANSMIT-012794		
		This was issued to board for information on BMCE-TRANSMIT-018565 22/11/13	ZBP	J	ZBP-ZJ-01-PL-523-019	HTG & CHW Layout First	04/05/12		A	31/05/12	02/05/12	BMCE-TRANSMIT-008652 (BMCE-WTRAN-002980)	23/05/12	06/07/12	B	17/07/12 BMCE-TRANSMIT-009877		
			ZBP	J	ZBP-ZJ-02-PL-523-029	HTG & CHW Layout Second	04/05/12		C	31/05/12	04/12/12	BMCE-TRANSMIT-012652 (BMCE-WTRAN-004968)	03/01/13	14/12/12	C	16/01/13 BMCE-TRANSMIT-013347		
			ZBP	J	ZBP-ZJ-04-PL-523-049	HTG & CHW Layout Fourth	16/03/12		A	03/05/12	28/05/12	BMCE-TRANSMIT-009096 (BMCE-WTRAN-003156)	18/06/12	19/07/12	A	26/07/12 BMCE-TRANSMIT-010001		
			ZBP	J	ZBP-ZJ-11-PL-523-119	HTG & CHW Service Layout Eleventh Floor NSGH Ward			A		28/05/12	BMCE-TRANSMIT-009096 (BMCE-WTRAN-003156)	18/06/12	19/07/12	A	26/07/12 BMCE-TRANSMIT-010001		
		This was issued to board for information on BMCE-TRANSMIT-018565 22/11/13	ZBP	J	ZBP-ZJ-XX-PL-523-059	HTG & CHW Layout Generic Ward			A		28/05/12	BMCE-TRANSMIT-009096 (BMCE-WTRAN-003156)	18/06/12	19/07/12	B	26/07/12 BMCE-TRANSMIT-010001		
		DRAWING NUMBER CHANGED DRAWING DELETED BY ZBP	ZBP	J	ZBP-ZJ-XX-PL-523-069	HTG & CHW Layout Generic Ward	13/07/12			31/05/12			-					
			ZBP	J	ZBP-ZJ-00-PL-524-009	Ventilation Layout Ground	04/05/12		A	31/05/12	07/06/12	BMCE-TRANSMIT-009265 (BMCE-WTRAN-003229)	28/06/12	10/09/12	A	20/09/12 BMCE-TRANSMIT-011082		
		This was issued to board for information on BMCE-TRANSMIT-018565 22/11/13	ZBP	J	ZBP-ZJ-01-PL-524-019	Ventilation Layout First	04/05/12		A	31/05/12	02/05/12	BMCE-TRANSMIT-008652 (BMCE-WTRAN-002980)	23/05/12	06/07/12	B	17/07/12 BMCE-TRANSMIT-009877		
		This was issued to board for information on BMCE-TRANSMIT-018565 22/11/13	ZBP	J	ZBP-ZJ-02-PL-524-029	Ventilation Layout Second	04/05/12		A	31/05/12	07/06/12	BMCE-TRANSMIT-009265 (BMCE-WTRAN-003229)	28/06/12	10/09/12	A	20/09/12 BMCE-TRANSMIT-011082		
			ZBP	J	ZBP-ZJ-04-PL-524-049	Ventilation Layout Fourth	16/03/12		A	03/05/12	31/05/12	BMCE-TRANSMIT-009172 (BMCE-WTRAN-003196)	21/06/12	19/07/12	A	01/08/12 BMCE-TRANSMIT-010087		
			ZBP	J	ZBP-ZJ-11-PL-524-119	Ventilation Eleventh Floor			A		31/05/12	BMCE-TRANSMIT-009172 (BMCE-WTRAN-003196)	21/06/12	19/07/12	A	01/08/12 BMCE-TRANSMIT-010087		
			ZBP	J	ZBP-ZJ-XX-PL-524-059	Ventilation Layout Generic Ward			A		01/06/12	BMCE-TRANSMIT-009172 (BMCE-WTRAN-003196)	22/06/12	19/07/12	A	01/08/12 BMCE-TRANSMIT-010087		
		DRAWING NUMBER CHANGED DRAWING DELETED BY ZBP	ZBP	J	ZBP-ZJ-XX-PL-524-069	Ventilation Layout Generic Ward	16/03/12			31/05/12			-					
		This was issued to board for information on BMCE-TRANSMIT-018565 22/11/13	ZBP	J	ZBP-ZJ-00-PL-526-009	Environmental Treatment Ground	01/06/12		A	31/05/12	27/07/12	BMCE-TRANSMIT-009984 (BMCE-WTRAN-003590)	17/08/12	28/09/12	B	05/10/12 BMCE-TRANSMIT-011387		
		This was issued to board for information on BMCE-TRANSMIT-018565 22/11/13	ZBP	J	ZBP-ZJ-01-PL-526-019	Environmental Treatment First	01/06/12		A	31/05/12	27/07/12	BMCE-TRANSMIT-009984 (BMCE-WTRAN-003590)	17/08/12	28/09/12	B	05/10/12 BMCE-TRANSMIT-011387		
		This was issued to board for information on BMCE-TRANSMIT-018565 22/11/13	ZBP	J	ZBP-ZJ-02-PL-526-029	Environmental Treatment Second	01/06/12		A	31/05/12	27/07/12	BMCE-TRANSMIT-009984 (BMCE-WTRAN-003590)	17/08/12	28/09/12	B	05/10/12 BMCE-TRANSMIT-011387		
		This was issued to board for information on BMCE-TRANSMIT-018565 22/11/13	ZBP	J	ZBP-ZJ-04-PL-526-049	Environmental Treatment Fourth	01/06/12		A	03/05/12	22/06/12	BMCE-TRANSMIT-009470 (BMCE-WTRAN-003316)	13/07/12	28/09/12	B	05/10/12 BMCE-TRANSMIT-011391		
		REMOVED BY ZBP	ZBP	J	ZBP-ZJ-XX-PL-526-069	Environmental Treatment Generic Ward	13/07/12			31/05/12			-					
Electrical Services Drawings			ZBP	J	ZBP-ZJ-00-PL-531-009	Small Power Layout Ground	04/05/12		A	31/05/12	31/05/12	BMCE-TRANSMIT-009168 (BMCE-WTRAN-003192)	21/06/12	02/08/12	A	20/08/12 BMCE-TRANSMIT-010402		
			ZBP	J	ZBP-ZJ-01-PL-531-019	Small Power Layout First	04/05/12	01/05/12	A	31/05/12	01/05/12	BMCE-TRANSMIT-008626 (BMCE-WTRAN-002972)	22/05/12	02/08/12	A	20/08/12 BMCE-TRANSMIT-010392		
			ZBP	J	ZBP-ZJ-02-PL-531-029	Small Power Layout Second	04/05/12		A	31/05/12	31/05/12	BMCE-TRANSMIT-009168 (BMCE-WTRAN-003192)	21/06/12	02/08/12	A	20/08/12 BMCE-TRANSMIT-		

Drawing Information

31

BCL-AC-XX-SH-001

1st Submission

2nd Submission

			Action By	Zone	Drawing Number	Drawing Title	Date Required from Consultant	Date Submitted by Consultant	Document Revision	Planned Date to be Submitted to Board	Date Submitted to Board	BMCE Transmittal No	Date Response Required from Board	Date Returned from Board	Board Status	Date returned to Consultant	Date Required from Consultant	Date Submitted by Consultant
Item	Submission	Comments																
		This was issued to board for information on BMCE-TRANSMIT-018565 22/11/13	ZBP	J	ZBP-ZJ-00-PL-571-009	Security Layout Ground	04/05/12		A	31/05/12	31/05/12	BMCE-TRANSMIT-009168 (BMCE-WTRAN-003192)	21/06/12	02/08/12	B	20/08/12 BMCE-TRANSMIT-010402		
		This was issued to board for information on BMCE-TRANSMIT-018565 22/11/13	ZBP	J	ZBP-ZJ-01-PL-571-019	Security Layout First	04/05/12	01/05/12	A	31/05/12	01/05/12	BMCE-TRANSMIT-008626 (BMCE-WTRAN-002972)	22/05/12	02/08/12	B	20/08/12 BMCE-TRANSMIT-010387		
			ZBP	J	ZBP-ZJ-02-PL-571-029	Security Layout Second	04/05/12		A	31/05/12	31/05/12	BMCE-TRANSMIT-009168 (BMCE-WTRAN-003192)	21/06/12	02/08/12	A	20/08/12 BMCE-TRANSMIT-010402		
		This was issued to board for information on BMCE-TRANSMIT-018565 22/11/13	ZBP	J	ZBP-ZJ-04-PL-571-049	Security Layout Fourth	16/03/12		A	03/05/12	08/05/12	BMCE-TRANSMIT-008691 (BMCE-WTRAN-03000)	29/05/12	02/08/12	B	29/08/12 BMCE-TRANSMIT-010570		
		This was issued to board for information on BMCE-TRANSMIT-018565 22/11/13	ZBP	J	ZBP-ZJ-05-PL-571-059	Security Layout Fifth to Eleventh Floors NSGH Generic Ward	16/03/12		A	03/05/12	08/05/12	BMCE-TRANSMIT-008691 (BMCE-WTRAN-03000)	29/05/12	02/08/12	B	29/08/12 BMCE-TRANSMIT-010570		
		Removed by ZBP	ZBP	J	ZBP-ZJ-XX-PL-571-069	Security Layout Generic Ward	16/03/12			31/05/12			21/06/12					
	Public Health Services Drawings	This was issued to board for information on BMCE-TRANSMIT-018565 22/11/13	ZBP	J	ZBP-ZJ-00-PL-500-009	Water & Gas Services Layout Ground	04/05/12		A	31/05/12	07/06/12	BMCE-TRANSMIT-009258 (BMCE-WTRAN-003222)	28/06/12	10/09/12	A	11/09/12 BMCE-TRANSMIT-010876		
			ZBP	J	ZBP-ZJ-02-PL-500-019	Water & Gas Services Layout First	04/05/12		A	31/05/12	07/06/12	BMCE-TRANSMIT-009258 (BMCE-WTRAN-003222)	28/06/12	10/09/12	A	11/09/12 BMCE-TRANSMIT-010876		
			ZBP	J	ZBP-ZJ-01-PL-500-029	Water & Gas Services Layout Second	04/05/12		A	31/05/12	07/06/12	BMCE-TRANSMIT-009258 (BMCE-WTRAN-003222)	28/06/12	10/09/12	A	11/09/12 BMCE-TRANSMIT-010876		
			ZBP	J	ZBP-ZJ-04-PL-500-049	Water & Gas Services Layout Fourth	16/03/12		A	03/05/12	30/05/12	BME-TRANSMIT-009098 (BMCE-WTRAN-003159)	20/06/12	19/07/12	A	28/07/12 BMCE-TRANSMIT-010051 15/08/12		
					ZBP-ZJ-XX-PL-500-059	Water & Gas Services Layout Generic Tower Ward Fifth to Eleventh			A		30/05/12	BME-TRANSMIT-009098 (BMCE-WTRAN-003159)	20/06/12	19/07/12	A	28/07/12 BMCE-TRANSMIT-010051 15/08/12		
		REMOVED BY ZBP	ZBP	J	ZBP-ZJ-XX-PL-500-069	Water & Gas Services Layout Generic Ward	16/03/12			31/05/12			21/06/12					
			ZBP	J	ZBP-ZJ-00-PL-581-009	Sanitation and Rainwater Layout Ground	04/05/12		A	31/05/12	07/06/12	BMCE-TRANSMIT-009263 (BMCE-WTRAN-003227)	28/06/12	10/09/12	A	21/09/12 BMCE-TRANSMIT-011100		
		This was issued to board for information on BMCE-TRANSMIT-018565 22/11/13	ZBP	J	ZBP-ZJ-01-PL-581-019	Sanitation and Rainwater Layout First	04/05/12		A	31/05/12	07/06/12	BMCE-TRANSMIT-009263 (BMCE-WTRAN-003227)	28/06/12	10/09/12	B	21/09/12 BMCE-TRANSMIT-011100		
			ZBP	J	ZBP-ZJ-02-PL-581-029	Sanitation and Rainwater Layout Second	04/05/12		A	31/05/12	14/06/12	BMCE-TRANSMIT-009345 (BMCE-WTRAN-003277)	05/07/12	10/09/12	A	21/09/12 BMCE-TRANSMIT-011102		
		Removed by ZBP	ZBP	J	ZBP-ZJ-XX-PL-581-069	Sanitation and Rainwater Layout Generic Ward												
			ZBP	J	ZBP-ZJ-XX-PL-581-069	Sanitation and Rainwater Layout Generic Ward	16/03/12		A	31/05/12	14/12/12	BMCE-TRANSMIT-012893 (BMCE-WTRAN-005139)	04/01/13	04/01/13	A	16/01/13 BMCE-TRANSMIT-013362		
			ZBP	J	ZBP-ZJ-11-PL-581-119	Sanitation and Rainwater Layout Eleventh	18/04/12		A	31/05/12	14/12/12	BMCE-TRANSMIT-012893 (BMCE-WTRAN-005139)	04/01/13	04/01/13	A	16/01/13 BMCE-TRANSMIT-013362		
			ZBP	J	ZBP-ZJ-05-PL-581-059	Sanitation and Rainwater Layout Fifth			A		05/06/13	BMCE-TRANSMIT-016119 (BMCE-WTRAN-007793)	26/06/13	10/07/13	A	BMCE-TRANSMIT-016829		
			ZBP	J	ZBP-ZJ-03-PL-581-039	Sanitation and Rainwater Layout Eleventh			B		22/04/13	BMCE-TRANSMIT-015253 (BMCE-WTRAN-007114)	13/05/13	13/05/13	A	BMCE-TRANSMIT-015776 20/05/13		
			ZBP	J	ZBP-ZJ-04-PL-581-049	Sanitation and Rainwater Layout Fourth			A		05/06/13	BMCE-TRANSMIT-016119 (BMCE-WTRAN-007793)	26/06/13	10/07/13	A	BMCE-TRANSMIT-016829		
		DUPLICATE ON RDD SCHEDULE	ZBP	J	ZBP-ZJ-XX-PL-581-069	Sanitation and Rainwater Layout Sixth												
			ZBP	J	ZBP-ZJ-12-PL-581-129	Sanitation and Rainwater Layout Twelfth			A		10/04/13	BMCE-TRANSMIT-015015 (BMCE-WTRAN-006924)	01/05/13	07/05/13	A	20/05/13 BMCE-TRANSMIT-015773		
			ZBP	J	ZBP-ZJ-13-PL-581-139	Sanitation and Rainwater Layout Thirteenth			A		22/04/13	BMCE-TRANSMIT-015252 (BMCE-WTRAN-007113)	13/05/13	13/05/13	A	20/05/13 BMCE-TRANSMIT-015771		
			ZBP	J	ZBP-ZJ-12-PL-532-191	LY Power layout - platrium 123			A		05/06/13	BMCE-TRANSMIT-015252 (BMCE-WTRAN-007113)	26/06/13	10/07/13	A	BMCE-TRANSMIT-016829		
	Riser Drawings		ZBP	J	ZBP-ZJ-XX-PL-520-641	Riser M22	11/04/12			27/04/12	22/11/12	BMCE-TRANSMIT-012401 (BMCE-WTRAN-004630)	13/12/12	03/12/12	A	06/12/12 BMCE-TRANSMIT-		

Drawing Information

31 BCL-AC-XX-SH-001

			Action By		Zone	Drawing Number	Drawing Title	Date Required from Consultant	Date Submitted by Consultant	Document Revision	Planned Date to be Submitted to Board	Date Submitted to Board	BMCE Transmittal No	Date Response Required from Board	Date Returned from Board	Board Status	Date returned to Consultant	Date Required from Consultant	Date Submitted by Consultant
Item	Submission	Comments																	
		This was issued to board for information on BMCE-TRANSMIT-018565 22/11/13	ZBP	J		ZBP-ZJ-XX-PL-520-645	Riser T13 Fourth to Eleventh Floor	17/04/12		A	27/04/12	02/05/12	BMCE-TRANSMIT-008649 (BMCE-WTRAN-002977)	23/05/12	06/07/12	B	17/07/12 BMCE-TRANSMIT-009879		
		This was issued to board for information on BMCE-TRANSMIT-018565 22/11/13	ZBP	J		ZBP-ZJ-XX-PL-520-646	Riser T14	13/04/12		A	03/05/12	02/05/12	BMCE-TRANSMIT-008649 (BMCE-WTRAN-002977)	23/05/12	06/07/12	B	17/07/12 BMCE-TRANSMIT-009879		
		REMOVED BY ZBP	ZBP	J		ZBP-ZJ-XX-PL-520-656	Riser M25 Levels: 04, 05, 06 & 07			A									
		REMOVED BY ZBP	ZBP	J		ZBP-ZJ-XX-PL-520-657	Riser M25 Levels 08, 09, 10 & 11			A									
	Mechanical Services Drawings Plantroom 33	REMOVED BY ZBP	ZBP	J		ZBP-ZJ-03-PL-512-141	Plantroom 33 Medical Gases	01/06/12			06/07/12								
		REMOVED BY ZBP	ZBP	J		ZBP-ZJ-03-PL-512-142	Plantroom 33 Medical Gases	01/06/12			06/07/12								
			ZBP	J		ZBP-ZJ-03-PL-523-141	Plantroom 33 Pipework	01/06/12		A	06/07/12	12/07/12	BMCE-TRANSMIT-009795 (BMCE-WTRAN-003481)	02/08/12	10/09/12	A	20/09/12 BMCE-TRANSMIT-011048		
			ZBP	J		ZBP-ZJ-03-PL-523-142	Plantroom 33 Pipework	01/06/12		A	06/07/12	12/07/12	BMCE-TRANSMIT-009795 (BMCE-WTRAN-003481)	02/08/12	10/09/12	A	20/09/12 BMCE-TRANSMIT-011048		
			ZBP	J		ZBP-ZJ-03-PL-524-141	Plantroom 33 Ventilation	01/06/12		A	06/07/12	12/07/12	BMCE-TRANSMIT-009795 (BMCE-WTRAN-003481)	02/08/12	10/09/12	A	20/09/12 BMCE-TRANSMIT-011048		
		This was issued to board for information on BMCE-TRANSMIT-018565 22/11/13	ZBP	J		ZBP-ZJ-03-PL-524-142	Plantroom 33 Ventilation	01/06/12		A	06/07/12	18/12/12	BMCE-TRANSMIT-012924 (BMCE-WTRAN-005163)	08/01/13	04/01/13	B	16/01/13 BMCE-TRANSMIT-013349		
		Issued for information on BMCE-TRANSMIT-019232 29/01/14	ZBP	J		ZBP-ZJ-03-SE-590-001	Plantroom 33 Sections			A		12/07/12	BMCE-TRANSMIT-009795 (BMCE-WTRAN-003481)	02/08/12	10/09/12	A	20/09/12 BMCE-TRANSMIT-011048		
	Electrical Services Drawings	Removed by ZBP	ZBP	J		ZBP-XX-03-PL-532-141	Plantroom 33 LV Power	01/06/12			06/07/12			21/01/09					
		Removed by ZBP	ZBP	J		ZBP-XX-03-PL-532-142	Plantroom 33 LV Power	01/06/12			06/07/12								
		Public Health Services Drawings																	
		Removed by ZBP	ZBP	J		ZBP-ZJ-03-PL-500-141	Plantroom 33 Water Services	01/06/12			06/07/12								
		Removed by ZBP	ZBP	J		ZBP-ZJ-03-PL-500-142	Plantroom 33 Water Services	01/06/12			06/07/12								
		Removed by ZBP	ZBP	J		ZBP-ZJ-03-PL-501-331	Plantroom 33 Sanitation and Rainwater Layout	01/06/12			06/07/12			21/01/09					
	Mechanical Services Schematics		ZBP	J		ZBP-XX-XX-SC-524-861	Ventilation Schematic (PR33) - AHU 01	15/06/12		A	31/05/12	11/07/12	BMCE-TRANSMIT-009782 (BMCE-WTRAN-003473)	01/08/12	10/09/12	A	20/09/12 BMCE-TRANSMIT-011041		
			ZBP	J		ZBP-XX-XX-SC-524-862	Ventilation Schematic (PR33) - AHU 02 & 03	15/06/12		A	31/05/12	11/07/12	BMCE-TRANSMIT-009782 (BMCE-WTRAN-003473)	01/08/12	10/09/12	A	20/09/12 BMCE-TRANSMIT-011041		
			ZBP	J		ZBP-XX-XX-SC-524-864	Ventilation Schematic (PR33)-AHU 04	15/06/12		A	31/05/12	11/07/12	BMCE-TRANSMIT-009782 (BMCE-WTRAN-003473)	01/08/12	10/09/12	A	20/09/12 BMCE-TRANSMIT-011041		
			ZBP	J		ZBP-XX-XX-SC-524-865	Ventilation Schematic (PR33)-AHU 05	15/06/12		A	31/05/12	11/07/12	BMCE-TRANSMIT-009782 (BMCE-WTRAN-003473)	01/08/12	10/09/12	A	20/09/12 BMCE-TRANSMIT-011041		
	Electrical Services Schematics		ZBP	J		ZBP-XX-XX-SC-532-041	Low Voltage Schematic - Substation 4A	01/06/12		A	31/05/12	09/07/12	BMCE-TRANSMIT-009724 (BMCE-WTRAN-003450)	30/07/12	12/07/12	B	19/07/12 BMCE-TRANSMIT-009930		
			ZBP	J		ZBP-XX-XX-SC-532-042	Low Voltage Schematic - Substation 4B	01/06/12		A	31/05/12	09/07/12	BMCE-TRANSMIT-009724 (BMCE-WTRAN-003450)	30/07/12	12/07/12	B	19/07/12 BMCE-TRANSMIT-009930		
	Public Health Services Schematics	This was issued to board for information on BMCE-TRANSMIT-018565 22/11/13	ZBP	J		ZBP-XX-XX-SC-500-033	Domestic Water Services Schematic Plantroom 33	01/06/12		A	31/05/12	12/10/12	BMCE-TRANSMIT-011554 (BMCE-WTRAN-004207)	02/11/12	23/10/12	B	14/11/12 BMCE-TRANSMIT-		

Drawing Information

31 BCL-AC-XX-SH-001

1st Submission2nd Submission

			Action By	Zone	Drawing Number	Drawing Title	Date Required from Consultant	Date Submitted by Consultant	Document Revision	Planned Date to be Submitted to Board	Date Submitted to Board	BMCE Transmittal No	Date Response Required from Board	Date Returned from Board	Board Status	Date returned to Consultant	Date Required from Consultant	Date Submitted by Consultant
Item	Submission	Comments																
			ZBP	J	ZBP-ZJ-12-PL-523-182	Plantroom 123 Pipework	31/08/12		A	05/10/12	26/02/13	BMCE-TRANSMIT-014131 (BMCE-WTRAN-006181)	19/03/13	26/03/13	B	03/085/13 BMCE-TRANSMIT-014910		
		This was issued to board for information on BMCE-TRANSMIT-018565 22/11/13	ZBP	J	ZBP-ZJ-12-PL-524-181	Plantroom 123 Ventilation	31/08/12		A	05/10/12	26/02/13	BMCE-TRANSMIT-014131 (BMCE-WTRAN-006181)	19/03/13	26/03/13	B	03/085/13 BMCE-TRANSMIT-014910		
		This was issued to board for information on BMCE-TRANSMIT-018565 22/11/13	ZBP	J	ZBP-ZJ-12-PL-524-182	Plantroom 123 Ventilation	31/08/12		A	05/10/12	26/02/13	BMCE-TRANSMIT-014131 (BMCE-WTRAN-006181)	19/03/13	26/03/13	B	03/085/13 BMCE-TRANSMIT-014910		
	Electrical Services Drawings		ZBP	J	ZBP-ZJ-03-PL-532-141	Containment/Sub-Mains Routing & SmaI Power Ground Floor Plantroom 33			A	11/07/12	12/07/12	BMCE-TRANSMIT-009796 (BMCE-WTRAN-003482)	02/08/12	07/08/12	A	20/08/12 BMCE-TRANSMIT-010398		
		Removed by ZBP	ZBP	J	ZBP-ZJ-03-PL-532-181	Plantroom 123 LV-Power	31/08/12			05/10/12			-					
		Removed by ZBP	ZBP	J	ZBP-ZJ-03-PL-532-182	Plantroom 123 LV-Power	31/08/12			05/10/12			-					
	Public Health Services Drawings	Removed by ZBP	ZBP	J	ZBP-ZJ-12-PL-581-181	Plantroom 123 Sanitary and Rainwater Layout	31/08/12			05/10/12			-					
		Removed by ZBP	ZBP	J	ZBP-ZJ-12-PL-581-182	Plantroom 123 Sanitation and Rainwater Layout	31/08/12			05/10/12			-					
		Removed by ZBP	ZBP	J	ZBP-ZJ-12-PL-581-183	Plantroom 123 Roof Sanitary and Rainwater Layout	31/08/12			05/10/12			-					
		Removed by ZBP	ZBP	J	ZBP-ZJ-12-PL-581-184	Plantroom 123 Roof Sanitation and Rainwater Layout	31/08/12			05/10/12			-					
	Mechanical Services Schematics		ZBP	J	ZBP-XX-XX-SC-524-921	Ventilation Schematic (PR123) - AHU 01	31/08/12			05/10/12	09/11/12	BMCE-TRANSMIT-012216 (BMCE-WTRAN-04546)	30/11/12	03/12/12	A	06/12/12 BMCE-TRANSMIT-012805		
			ZBP	J	ZBP-XX-XX-SC-524-922	Ventilation Schematic (PR123) - AHU 02	31/08/12			05/10/12	09/11/12	BMCE-TRANSMIT-012216 (BMCE-WTRAN-04546)	30/11/12	03/12/12	A	06/12/12 BMCE-TRANSMIT-012805		
			ZBP	J	ZBP-XX-XX-SC-524-923	Ventilation Schematic (PR123) - AHU 03	31/08/12			05/10/12	09/11/12	BMCE-TRANSMIT-012216 (BMCE-WTRAN-04546)	30/11/12	03/12/12	A	06/12/12 BMCE-TRANSMIT-012805		
			ZBP	J	ZBP-XX-XX-SC-524-924	Ventilation Schematic (PR123) - AHU 04	31/08/12			05/10/12	09/11/12	BMCE-TRANSMIT-012216 (BMCE-WTRAN-04546)	30/11/12	03/12/12	A	06/12/12 BMCE-TRANSMIT-012805		
			ZBP	J	ZBP-XX-XX-SC-524-925	Ventilation Schematic (PR123) - AHU 05	31/08/12			05/10/12	09/11/12	BMCE-TRANSMIT-012216 (BMCE-WTRAN-04546)	30/11/12	03/12/12	A	06/12/12 BMCE-TRANSMIT-012805		
			ZBP	J	ZBP-XX-XX-SC-524-926	Ventilation Schematic (PR123) - AHU 06	31/08/12			05/10/12	09/11/12	BMCE-TRANSMIT-012216 (BMCE-WTRAN-04546)	30/11/12	03/12/12	A	06/12/12 BMCE-TRANSMIT-012805		
			ZBP	J	ZBP-XX-XX-SC-524-927	Ventilation Schematic (PR123) - AHU 07	31/08/12			05/10/12	09/11/12	BMCE-TRANSMIT-012216 (BMCE-WTRAN-04546)	30/11/12	03/12/12	A	06/12/12 BMCE-TRANSMIT-012805		
		This was issued to board for information on BMCE-TRANSMIT-018565 22/11/13	ZBP	J	ZBP-XX-XX-SC-521-481	Secondary Heating Distribution Schematic Plantroom 123	31/08/12		A	05/10/12	18/12/12	BMCE-TRANSMIT-012940 (BMCE-WTRAN-005171)	08/01/13	07/01/13	B	16/01/13 BMCE-TRANSMIT-013348		
		Removed by ZBP	ZBP	J	ZBP-XX-XX-SC-521-482	Secondary Heating Distribution Schematic Plantroom 123	31/08/12			05/10/12			-					
		This was issued to board for information on BMCE-TRANSMIT-018565 22/11/13	ZBP	J	ZBP-XX-XX-SC-525-581	Secondary Chi led Water Distribution Schematic Plantroom 123	31/08/12		A	05/10/12	18/12/12	BMCE-TRANSMIT-012940 (BMCE-WTRAN-005171)	08/01/13	07/01/13	B	16/01/13 BMCE-TRANSMIT-013348		
		Removed by ZBP	ZBP	J	ZBP-XX-XX-SC-525-582	Secondary Chi led Water Distribution Schematic Plantroom 123	31/08/12			05/10/12			-					
		This was issued to board for information on BMCE-TRANSMIT-018565 22/11/13	ZBP	J	ZBP-XX-XX-DT-581-001	Typical Details			A		29/04/13	BMCE-TRANSMIT-015383 (BMCE-WTRAN-007201)	20/05/13	29/04/13	B	BMCE-TRANSMIT-		

Drawing Information

31 BCL-AC-XX-SH-001

			1st Submission																2nd Submission		
			Action By	Zone	Drawing Number	Drawing Title	Date Required from Consultant	Date Submitted by Consultant	Document Revision	Planned Date to be Submitted to Board	Date Submitted to Board	BMCE Transmittal No	Date Response Required from Board	Date Returned from Board	Board Status	Date returned to Consultant	Date Required from Consultant	Date Submitted by Consultant			
Item	Submission	Comments																			
		Issued for information on BMCE-TRANSMIT-018891 18/12/13	MER	J	ME-ZJ-00-PL-541-539	Ground Floor Plan NSGH OPD Lighting Layout	04/05/12		A	31/05/12	08/05/12	BMCE-TRANSMIT-008681 (BMCE-WTRAN0002992)	29/05/12	11/06/12	B	14/06/12 BMCE-TRANSMIT-009340					
		Issued for information on BMCE-TRANSMIT-018891 18/12/13	MER	J	ME-ZJ-00-PL-541-540	Ground Floor Plan NSGH OPD Lighting Layout	04/05/12		A	31/05/12	08/05/12	BMCE-TRANSMIT-008681 (BMCE-WTRAN0002992)	29/05/12	11/06/12	B	14/06/12 BMCE-TRANSMIT-009340					
		Issued for information on BMCE-TRANSMIT-018891 18/12/13	MER	J	ME-ZJ-01-PL-541-537	First Floor Plan NSGH OPD Lighting Layout	04/05/12		A	31/05/12	08/05/12	BMCE-TRANSMIT-008681 (BMCE-WTRAN0002992)	29/05/12	11/06/12	B	14/06/12 BMCE-TRANSMIT-009340					
			MER	J	ME-ZJ-01-PL-541-538	First Floor Plan NSGH OPD Lighting Layout	04/05/12		A	31/05/12	08/05/12	BMCE-TRANSMIT-008681 (BMCE-WTRAN0002992)	29/05/12	11/06/12	A	14/06/12 BMCE-TRANSMIT-009340					
		Issued for information on BMCE-TRANSMIT-018891 18/12/13	MER	J	ME-ZJ-01-PL-541-539	First Floor Plan NSGH OPD Lighting Layout	04/05/12		A	31/05/12	08/05/12	BMCE-TRANSMIT-008681 (BMCE-WTRAN0002992)	29/05/12	11/06/12	B	14/06/12 BMCE-TRANSMIT-009340					
			MER	J	ME-ZJ-02-PL-541-529	Second Floor Plan NSGH Dermatology OPD Lighting Layout	04/05/12		A	31/05/12	08/05/12	BMCE-TRANSMIT-008681 (BMCE-WTRAN0002992)	29/05/12	11/06/12	A	14/06/12 BMCE-TRANSMIT-009340					
		This was issued for information on BMCE-TRANSMIT-018728 09/12/13	MER	J	ME-ZJ-02-PL-541-530	Second Floor Plan NSGH Dermatology OPD Lighting Layout	04/05/12		A	31/05/12	08/05/12	BMCE-TRANSMIT-008681 (BMCE-WTRAN0002992)	29/05/12	11/06/12	B	14/06/12 BMCE-TRANSMIT-009340					

BCL-AC-XX-SH-001

2nd Submission

			Action By		Zone	Drawing Number	Drawing Title	Date Required from Consultant	Date Submitted by Consultant	Document Revision	Planned Date to be Submitted to Board	Date Submitted to Board	BMCE Transmittal No	Date Response Required from Board	Date Returned from Board	Board Status	Date returned to Consultant	Date Required from Consultant	Date Submitted by Consultant
Item	Submission	Comments																	
		This was issued for information on BMCE-TRANSMIT-018728 09/12/13	MER	J	ME-ZJ-02-PL-541-531	Second Floor Plan NSGH Renal Dialysis Lighting Layout	04/05/12			A	31/05/12	08/05/12	BMCE-TRANSMIT-008681 (BMCE-WTRAN0002992)	29/05/12	11/06/12	B	14/06/12 BMCE-TRANSMIT-009340		
		This was issued for information on BMCE-TRANSMIT-018728 09/12/13	MER	J	ME-ZJ-02-PL-541-532	Second Floor Plan NSGH Renal Dialysis Lighting Layout	04/05/12			A	31/05/12	08/05/12	BMCE-TRANSMIT-008681 (BMCE-WTRAN0002992)	29/05/12	11/06/12	B	14/06/12 BMCE-TRANSMIT-009340		
		This was issued for information on BMCE-TRANSMIT-018728 09/12/13	MER	J	ME-ZJ-02-PL-541-533	Second Floor Plan NSGH Renal Dialysis Lighting Layout	04/05/12			A	31/05/12	08/05/12	BMCE-TRANSMIT-008681 (BMCE-WTRAN0002992)	29/05/12	11/06/12	B	14/06/12 BMCE-TRANSMIT-009340		
			MER	J	ME-ZJ-03-PL-541-109	Third Floor Plan Plantroom Lighting Layout	04/05/12			A	31/05/12	08/05/12	BMCE-TRANSMIT-008681 (BMCE-WTRAN0002992)	29/05/12	11/06/12	A	14/06/12 BMCE-TRANSMIT-009340		
		This was issued for information on BMCE-TRANSMIT-018728 09/12/13	MER	J	ME-ZJ-04-PL-541-506	Fourth Floor Plan NSGH Renal Inpatients & Day Unit Lighting Layout	16/03/12			A	03/05/12	17/05/12	BMCE-TRANSMIT-008898 (BMCE-WTRAN-003083)	07/06/12	11/06/12	B	18/06/12 BMCE-TRANSMIT-009387		
		This was issued for information on BMCE-TRANSMIT-018728 09/12/13	MER	J	ME-ZJ-04-PL-541-507	Fourth Floor Plan NSGH Renal Inpatients & Day Unit Lighting Layout	16/03/12			A	03/05/12	17/05/12	BMCE-TRANSMIT-008898 (BMCE-WTRAN-003083)	07/06/12	11/06/12	B	18/06/12 BMCE-TRANSMIT-009387		
		This was issued for information on BMCE-TRANSMIT-018728 09/12/13	MER	J	ME-ZJ-04-PL-541-508	Fourth Floor Plan NSGH Renal Inpatients & Day Unit Lighting Layout	16/03/12			A	03/05/12	17/05/12	BMCE-TRANSMIT-008898 (BMCE-WTRAN-003083)	07/06/12	11/06/12	B	18/06/12 BMCE-TRANSMIT-009387		
		This was issued for information on BMCE-TRANSMIT-018728 09/12/13	MER	J	ME-ZJ-05-PL-541-506	Fifth Floor Plan NSGH Inpatient Wards Lighting Layout	16/03/12			A	03/05/12	17/05/12	BMCE-TRANSMIT-008898 (BMCE-WTRAN-003083)	07/06/12	11/06/12	B	18/06/12 BMCE-TRANSMIT-009387		
		This was issued for information on BMCE-TRANSMIT-018728 09/12/13	MER	J	ME-ZJ-05-PL-541-507	Fifth Floor Plan NSGH Inpatient Wards Lighting Layout	16/03/12			A	03/05/12	17/05/12	BMCE-TRANSMIT-008898 (BMCE-WTRAN-003083)	07/06/12	11/06/12	B	18/06/12 BMCE-TRANSMIT-009387		
		This was issued for information on BMCE-TRANSMIT-018728 09/12/13	MER	J	ME-ZJ-05-PL-541-508	Fifth Floor Plan NSGH Inpatient Wards Lighting Layout	16/03/12			A	03/05/12	17/05/12	BMCE-TRANSMIT-008898 (BMCE-WTRAN-003083)	07/06/12	11/06/12	B	18/06/12 BMCE-TRANSMIT-009387		
		This was issued for information on BMCE-TRANSMIT-018728 09/12/13	MER	J	ME-ZJ-XX-PL-541-506	Sixth to Eleventh Floor Plan NSGH Inpatient Wards Lighting Layout				A	03/05/12	17/05/12	BMCE-TRANSMIT-008898 (BMCE-WTRAN-003083)	07/06/12	11/06/12	B	18/06/12 BMCE-TRANSMIT-009387		
		This was issued for information on BMCE-TRANSMIT-018728 09/12/13	MER	J	ME-ZJ-XX-PL-541-507	Sixth to Eleventh Floor Plan NSGH Inpatient Wards Lighting Layout				A	03/05/12	17/05/12	BMCE-TRANSMIT-008898 (BMCE-WTRAN-003083)	07/06/12	11/06/12	B	18/06/12 BMCE-TRANSMIT-009387		
		This was issued for information on BMCE-TRANSMIT-018728 09/12/13	MER	J	ME-ZJ-XX-PL-541-508	Sixth to Eleventh Floor Plan NSGH Inpatient Wards Lighting Layout				A	03/05/12	17/05/12	BMCE-TRANSMIT-008898 (BMCE-WTRAN-003083)	07/06/12	11/06/12	B	18/06/12 BMCE-TRANSMIT-009387		
		REMOVED BY MERCURY - ME-ZJ-XX-PL-541-506 SUBMITTED FOR RDD REVIEW	MER	↓	ME-ZJ-06-PL-541-506	Sixth Floor Plan NSGH Inpatient Wards Lighting Layout													
		REMOVED BY MERCURY - ME-ZJ-XX-PL-541-507 SUBMITTED FOR RDD REVIEW	MER	↓	ME-ZJ-06-PL-541-507	Sixth Floor Plan NSGH Inpatient Wards Lighting Layout													
		REMOVED BY MERCURY - ME-ZJ-XX-PL-541-508 SUBMITTED FOR RDD REVIEW	MER	↓	ME-ZJ-06-PL-541-508	Sixth Floor Plan NSGH Inpatient Wards Lighting Layout													
		REMOVED BY MERCURY - ME-ZJ-XX-PL-541-506 SUBMITTED FOR RDD REVIEW	MER	↓	ME-ZJ-07-PL-541-506	Seventh Floor Plan NSGH Inpatient Wards Lighting Layout													
		REMOVED BY MERCURY - ME-ZJ-XX-PL-541-507 SUBMITTED FOR RDD REVIEW	MER	↓	ME-ZJ-07-PL-541-507	Seventh Floor Plan NSGH Inpatient Wards Lighting Layout													
		REMOVED BY MERCURY - ME-ZJ-XX-PL-541-508 SUBMITTED FOR RDD REVIEW	MER	↓	ME-ZJ-07-PL-541-508	Seventh Floor Plan NSGH Inpatient Wards Lighting Layout													
		REMOVED BY MERCURY - ME-ZJ-XX-PL-541-506 SUBMITTED FOR RDD REVIEW	MER	↓	ME-ZJ-08-PL-541-506	Eighth Floor Plan NSGH Inpatient Wards Lighting Layout													
		REMOVED BY MERCURY - ME-ZJ-XX-PL-541-507 SUBMITTED FOR RDD REVIEW	MER	↓	ME-ZJ-08-PL-541-507	Eighth Floor Plan NSGH Inpatient Wards Lighting Layout													
		REMOVED BY MERCURY - ME-ZJ-XX-PL-541-508 SUBMITTED FOR RDD REVIEW	MER	↓	ME-ZJ-08-PL-541-508	Eighth Floor Plan NSGH Inpatient Wards Lighting Layout													
		REMOVED BY MERCURY - ME-ZJ-XX-PL-541-506 SUBMITTED FOR RDD REVIEW	MER	↓	ME-ZJ-09-PL-541-506	Ninth Floor Plan NSGH Inpatient Wards Lighting Layout													
		REMOVED BY MERCURY - ME-ZJ-XX-PL-541-507 SUBMITTED FOR RDD REVIEW	MER	↓	ME-ZJ-09-PL-541-507	Ninth Floor Plan NSGH Inpatient Wards Lighting Layout													
		REMOVED BY MERCURY - ME-ZJ-XX-PL-541-508 SUBMITTED FOR RDD REVIEW	MER	↓	ME-ZJ-09-PL-541-508	Ninth Floor Plan NSGH Inpatient Wards Lighting Layout													
		REMOVED BY MERCURY - ME-ZJ-XX-PL-541-506 SUBMITTED FOR RDD REVIEW	MER	↓	ME-ZJ-10-PL-541-506	Tenth Floor Plan NSGH Inpatient Wards Lighting Layout													
		REMOVED BY MERCURY - ME-ZJ-XX-PL-541-507 SUBMITTED FOR RDD REVIEW	MER	↓	ME-ZJ-10-PL-541-507	Tenth Floor Plan NSGH Inpatient Wards Lighting Layout													
		REMOVED BY MERCURY - ME-ZJ-XX-PL-541-508 SUBMITTED FOR RDD REVIEW	MER	↓	ME-ZJ-10-PL-541-508	Tenth Floor Plan NSGH Inpatient Wards Lighting Layout													
		REMOVED BY MERCURY - ME-ZJ-XX-PL-541-506 SUBMITTED FOR RDD REVIEW	MER	↓	ME-ZJ-11-PL-541-506	Eleventh Floor Plan NSGH Inpatient Wards Lighting Layout													
		REMOVED BY MERCURY - ME-ZJ-XX-PL-541-507 SUBMITTED FOR RDD REVIEW	MER	↓	ME-ZJ-11-PL-541-507	Eleventh Floor Plan NSGH Inpatient Wards Lighting Layout													
		REMOVED BY MERCURY - ME-ZJ-XX-PL-541-508 SUBMITTED FOR RDD REVIEW	MER	↓	ME-ZJ-11-PL-541-508	Eleventh Floor Plan NSGH Inpatient Wards Lighting Layout													

Drawing Information

31 BCL-AC-XX-SH-001

1st Submission2nd Submission

			Action By	Zone	Drawing Number	Drawing Title	Date Required from Consultant	Date Submitted by Consultant	Document Revision	Planned Date to be Submitted to Board	Date Submitted to Board	BMCE Transmittal No	Date Response Required from Board	Date Returned from Board	Board Status	Date returned to Consultant	Date Required from Consultant	Date Submitted by Consultant
Item	Submission	Comments																
		Removed By Mercury - NOT REQUIRED FOR RDD (SMALL POWER SHOWN ON NA 400 SERIES DRAWINGS)	MER	J	ME-ZJ-02-PL-531-533	Second Floor Plan NSGH-Renal Dialysis-Small Power & General Ser-ices Layout	13/07/12			21/05/12			-					
		Removed By Mercury - NOT REQUIRED FOR RDD (SMALL POWER SHOWN ON NA 400 SERIES DRAWINGS)	MER	J	ME-ZJ-04-PL-531-506	Fourth Floor Plan NSGH-Renal Inpatients & Day Unit Small Power & General Services Layout	13/07/12			21/05/12			-					
		Removed By Mercury - NOT REQUIRED FOR RDD (SMALL POWER SHOWN ON NA 400 SERIES DRAWINGS)	MER	J	ME-ZJ-04-PL-531-507	Fourth Floor Plan NSGH-Renal Inpatients & Day Unit Small Power & General Ser-ices Layout	16/03/12			03/05/12			-					
		Removed By Mercury - NOT REQUIRED FOR RDD (SMALL POWER SHOWN ON NA 400 SERIES DRAWINGS)	MER	J	ME-ZJ-04-PL-531-508	Fourth Floor Plan NSGH-Renal Inpatients & Day Unit Small Power & General Ser-ices Layout	16/03/12			03/05/12			-					
		Removed By Mercury - NOT REQUIRED FOR RDD (SMALL POWER SHOWN ON NA 400 SERIES DRAWINGS)	MER	J	ME-ZJ-05-PL-531-506	Fifth Floor Plan NSGH-Inpatient Wards-Small Power & General Services Layout	16/03/12			03/05/12			-					
		Removed By Mercury - NOT REQUIRED FOR RDD (SMALL POWER SHOWN ON NA 400 SERIES DRAWINGS)	MER	J	ME-ZJ-05-PL-531-507	Fifth Floor Plan NSGH-Inpatient Wards-Small Power & General Ser-ices Layout	16/03/12			03/05/12			-					
		Removed By Mercury - NOT REQUIRED FOR RDD (SMALL POWER SHOWN ON NA 400 SERIES DRAWINGS)	MER	J	ME-ZJ-05-PL-531-508	Fifth Floor Plan NSGH-Inpatient Wards-Small Power & General Ser-ices Layout	16/03/12			03/05/12			-					
		Removed By Mercury - NOT REQUIRED FOR RDD (SMALL POWER SHOWN ON NA 400 SERIES DRAWINGS)	MER	J	ME-ZJ-00-PL-532-537	Ground Floor Plan NSGH-Rehabilitation & Therapies High Le-el Layout	13/07/12			21/05/12			-					
		Removed By Mercury - NOT REQUIRED FOR RDD (SMALL POWER SHOWN ON NA 400 SERIES DRAWINGS)	MER	J	ME-ZJ-00-PL-532-538	Ground Floor Plan NSGH-Rehabilitation & Therapies High Le-el Layout	13/07/12			21/05/12			-					
		Removed By Mercury - NOT REQUIRED FOR RDD (SMALL POWER SHOWN ON NA 400 SERIES DRAWINGS)	MER	J	ME-ZJ-00-PL-532-539	Ground Floor Plan NSGH-OPD High Level Layout	13/07/12			21/05/12			-					
		Removed By Mercury - NOT REQUIRED FOR RDD (SMALL POWER SHOWN ON NA 400 SERIES DRAWINGS)	MER	J	ME-ZJ-00-PL-532-540	Ground Floor Plan NSGH-OPD High Le-el Layout	13/07/12			21/05/12			-					
		Removed By Mercury - NOT REQUIRED FOR RDD (SMALL POWER SHOWN ON NA 400 SERIES DRAWINGS)	MER	J	ME-ZJ-01-PL-532-537	First Floor Plan NSGH-OPD High Le-el Layout	13/07/12			21/05/12			-					
		Removed By Mercury - NOT REQUIRED FOR RDD (SMALL POWER SHOWN ON NA 400 SERIES DRAWINGS)	MER	J	ME-ZJ-01-PL-532-538	First Floor Plan NSGH-OPD High Level Layout	13/07/12			21/05/12			-					

Drawing Information

31 BCL-AC-XX-SH-001

1st Submission2nd Submission

			Action By	Zone	Drawing Number	Drawing Title	Date Required from Consultant	Date Submitted by Consultant	Document Revision	Planned Date to be Submitted to Board	Date Submitted to Board	BMCE Transmittal No	Date Response Required from Board	Date Returned from Board	Board Status	Date returned to Consultant	Date Required from Consultant	Date Submitted by Consultant
Item	Submission	Comments																
		Removed By Mercury - NOT REQUIRED FOR RDD (SMALL POWER SHOWN ON NA 400 SERIES DRAWINGS)	MER	J	ME-ZJ-01-PL-532-539	First Floor Plan NSGH OPD High Le- el Layout	13/07/12			21/05/12			-					
		Removed By Mercury - NOT REQUIRED FOR RDD (SMALL POWER SHOWN ON NA 400 SERIES DRAWINGS)	MER	J	ME-ZJ-02-PL-532-529	Second Floor Plan NSGH Dermatology OPD High Le- el Layout	13/07/12			21/05/12			-					
		Removed By Mercury - NOT REQUIRED FOR RDD (SMALL POWER SHOWN ON NA 400 SERIES DRAWINGS)	MER	J	ME-ZJ-02-PL-532-530	Second Floor Plan NSGH Dermatology OPD High Level Layout	13/07/12			21/05/12			-					
		Removed By Mercury - NOT REQUIRED FOR RDD (SMALL POWER SHOWN ON NA 400 SERIES DRAWINGS)	MER	J	ME-ZJ-02-PL-532-531	Second Floor Plan NSGH Renal Dialysis High Le- el Layout	13/07/12			21/05/12			-					
		Removed By Mercury - NOT REQUIRED FOR RDD (SMALL POWER SHOWN ON NA 400 SERIES DRAWINGS)	MER	J	ME-ZJ-02-PL-532-532	Second Floor Plan NSGH Renal Dialysis High Le- el Layout	13/07/12			21/05/12			-					
		Removed By Mercury - NOT REQUIRED FOR RDD (SMALL POWER SHOWN ON NA 400 SERIES DRAWINGS)	MER	J	ME-ZJ-02-PL-532-533	Second Floor Plan NSGH Renal Dialysis High Level Layout	13/07/12			21/05/12			-					
		Removed By Mercury - NOT REQUIRED FOR RDD (SMALL POWER SHOWN ON NA 400 SERIES DRAWINGS)	MER	J	ME-ZJ-04-PL-532-506	Fourth Floor Plan NSGH Renal Inpatients & Day Unit High Le- el Layout	16/03/12			03/05/12			-					
		Removed By Mercury - NOT REQUIRED FOR RDD (SMALL POWER SHOWN ON NA 400 SERIES DRAWINGS)	MER	J	ME-ZJ-04-PL-532-507	Fourth Floor Plan NSGH Renal Inpatients & Day Unit High Le- el Layout	16/03/12			03/05/12			-					
		Removed By Mercury - NOT REQUIRED FOR RDD (SMALL POWER SHOWN ON NA 400 SERIES DRAWINGS)	MER	J	ME-ZJ-04-PL-532-508	Fourth Floor Plan NSGH Renal Inpatients & Day Unit High Le- el Layout	16/03/12			03/05/12			-					
		Removed By Mercury - NOT REQUIRED FOR RDD (SMALL POWER SHOWN ON NA 400 SERIES DRAWINGS)	MER	J	ME-ZJ-05-PL-532-506	Fifth Floor Plan NSGH Inpatient Wards High Level Layout	16/03/12			03/05/12			-					
		Removed By Mercury - NOT REQUIRED FOR RDD (SMALL POWER SHOWN ON NA 400 SERIES DRAWINGS)	MER	J	ME-ZJ-05-PL-532-507	Fifth Floor Plan NSGH Inpatient Wards High Le- el Layout	16/03/12			03/05/12			-					
		Removed By Mercury - NOT REQUIRED FOR RDD (SMALL POWER SHOWN ON NA 400 SERIES DRAWINGS)	MER	J	ME-ZJ-05-PL-532-508	Fifth Floor Plan NSGH Inpatient Wards High Le- el Layout	16/03/12			03/05/12			-					
		Removed By Mercury - NOT REQUIRED FOR RDD (SMALL POWER SHOWN ON NA 400 SERIES DRAWINGS)	MER	J	ME-ZJ-00-PL-532-537	Ground Floor Plan NSGH - Rehabilitation & Therapies ELV Systems low level Layout	13/07/12			21/05/12			-					
		Removed By Mercury - NOT REQUIRED FOR RDD (SMALL POWER SHOWN ON NA 400 SERIES DRAWINGS)	MER	J	ME-ZJ-00-PL-532-538	Ground Floor Plan NSGH - Rehabilitation & Therapies ELV Systems low le- el Layout	13/07/12			21/05/12			-					
		Removed By Mercury - NOT REQUIRED FOR RDD (SMALL POWER SHOWN ON NA 400 SERIES DRAWINGS)	MER	J	ME-ZJ-00-PL-532-539	Ground Floor Plan NSGH OPD ELV Systems low le- el Layout	13/07/12			21/05/12			-					
		Removed By Mercury - NOT REQUIRED FOR RDD (SMALL POWER SHOWN ON NA 400 SERIES DRAWINGS)	MER	J	ME-ZJ-00-PL-532-540	Ground Floor Plan NSGH OPD ELV Systems low le- el Layout	13/07/12			21/05/12			-					
		Removed By Mercury - NOT REQUIRED FOR RDD (SMALL POWER SHOWN ON NA 400 SERIES DRAWINGS)	MER	J	ME-ZJ-01-PL-532-537	First Floor Plan NSGH OPD ELV Systems low level Layout	13/07/12			21/05/12			-					
		Removed By Mercury - NOT REQUIRED FOR RDD (SMALL POWER SHOWN ON NA 400 SERIES DRAWINGS)	MER	J	ME-ZJ-01-PL-532-538	First Floor Plan NSGH OPD ELV Systems low le- el Layout	13/07/12			21/05/12			-					
		Removed By Mercury - NOT REQUIRED FOR RDD (SMALL POWER SHOWN ON NA 400 SERIES DRAWINGS)	MER	J	ME-ZJ-01-PL-532-539	First Floor Plan NSGH OPD ELV Systems low le- el Layout	13/07/12			21/05/12			-					
		Removed By Mercury - NOT REQUIRED FOR RDD (SMALL POWER SHOWN ON NA 400 SERIES DRAWINGS)	MER	J	ME-ZJ-02-PL-532-529	Second Floor Plan NSGH Dermatology OPD ELV Systems low le- el Layout	13/07/12			21/05/12			-					
		Removed By Mercury - NOT REQUIRED FOR RDD (SMALL POWER SHOWN ON NA 400 SERIES DRAWINGS)	MER	J	ME-ZJ-02-PL-532-530	Second Floor Plan NSGH Dermatology OPD ELV Systems low level Layout	13/07/12			21/05/12			-					
		Removed By Mercury - NOT REQUIRED FOR RDD (SMALL POWER SHOWN ON NA 400 SERIES DRAWINGS)	MER	J	ME-ZJ-02-PL-532-531	Second Floor Plan NSGH Renal Dialysis ELV Systems low le- el Layout	13/07/12			21/05/12			-					
		Removed By Mercury - NOT REQUIRED FOR RDD (SMALL POWER SHOWN ON NA 400 SERIES DRAWINGS)	MER	J	ME-ZJ-02-PL-532-532	Second Floor Plan NSGH Renal Dialysis ELV Systems low le- el Layout	13/07/12			21/05/12			-					
		Removed By Mercury - NOT REQUIRED FOR RDD (SMALL POWER SHOWN ON NA 400 SERIES DRAWINGS)	MER	J	ME-ZJ-02-PL-532-533	Second Floor Plan NSGH Renal Dialysis ELV Systems low level Layout	13/07/12			21/05/12			-					
		Removed By Mercury - NOT REQUIRED FOR RDD (SMALL POWER SHOWN ON NA 400 SERIES DRAWINGS)	MER	J	ME-ZJ-04-PL-532-506	Fourth Floor Plan NSGH Renal Inpatients & Day Unit ELV Systems low le- el Layout	13/07/12			21/05/12			-					
		Removed By Mercury - NOT REQUIRED FOR RDD (SMALL POWER SHOWN ON NA 400 SERIES DRAWINGS)	MER	J	ME-ZJ-04-PL-532-507	Fourth Floor Plan NSGH Renal Inpatients & Day Unit ELV Systems low le- el Layout	13/07/12			21/05/12			-					
		Removed By Mercury - NOT REQUIRED FOR RDD (SMALL POWER SHOWN ON NA 400 SERIES DRAWINGS)	MER	J	ME-ZJ-04-PL-532-508	Fourth Floor Plan NSGH Renal Inpatients & Day Unit ELV Systems low level Layout	16/03/12			03/05/12			-					
		Removed By Mercury - NOT REQUIRED FOR RDD (SMALL POWER SHOWN ON NA 400 SERIES DRAWINGS)	MER	J	ME-ZJ-05-PL-532-506	Fifth Floor Plan NSGH Inpatient Wards ELV Systems low level Layout	16/03/12			03/05/12			-					
		Removed By Mercury - NOT REQUIRED FOR RDD (SMALL POWER SHOWN ON NA 400 SERIES DRAWINGS)	MER	J	ME-ZJ-05-PL-532-507	Fifth Floor Plan NSGH Inpatient Wards ELV Systems low le- el Layout	16/03/12			03/05/12			-					
		Removed By Mercury - NOT REQUIRED FOR RDD (SMALL POWER SHOWN ON NA 400 SERIES DRAWINGS)	MER	J	ME-ZJ-05-PL-532-508	Fifth Floor Plan NSGH Inpatient Wards ELV Systems low le- el Layout	16/03/12			03/05/12			-					
			MER	J	ME-ZJ-XX-PL-556-506	Sixth to Eleventh Floor Plan NSGH Inpatient Wards Data Comms Layout			A	03/05/12	09/05/12	BMCE-TRANSMIT-008742 /BMCE-WTRAN-003012)	30/05/12	12/07/12	A	18/07/12 BMCE-TRANSMIT-		

Drawing Information

31 BCL-AC-XX-SH-001

1st Submission2nd Submission

			Action By	Zone	Drawing Number	Drawing Title	Date Required from Consultant	Date Submitted by Consultant	Document Revision	Planned Date to be Submitted to Board	Date Submitted to Board	BMCE Transmittal No	Date Response Required from Board	Date Returned from Board	Board Status	Date returned to Consultant	Date Required from Consultant	Date Submitted by Consultant
Item	Submission	Comments																
		Issued for information on BMCE-TRANSMIT-018891 18/12/13	MER	J	ME-ZJ-01-PL-556-538	First Floor Plan NSGH OPD Data Comms Layout	09/05/12		A	31/05/12	08/05/12	BMCE-TRANSMIT-008682 (BMCE-WTRAN-002993)	29/05/12	11/07/12	B	19/07/12 BMCE-TRANSMIT-009933		
			MER	J	ME-ZJ-01-PL-556-539	First Floor Plan NSGH OPD Data Comms Layout	10/05/12		A	31/05/12	08/05/12	BMCE-TRANSMIT-008682 (BMCE-WTRAN-002993)	29/05/12	11/07/12	A	19/07/12 BMCE-TRANSMIT-009933		
		This was issued for information on BMCE-TRANSMIT-018728 09/12/13	MER	J	ME-ZJ-02-PL-556-529	Second Floor Plan NSGH Dermatology OPD Data Comms Layout	11/05/12		A	31/05/12	08/05/12	BMCE-TRANSMIT-008682 (BMCE-WTRAN-002993)	29/05/12	11/07/12	B	19/07/12 BMCE-TRANSMIT-009933		
		This was issued for information on BMCE-TRANSMIT-018728 09/12/13	MER	J	ME-ZJ-02-PL-556-530	Second Floor Plan NSGH Dermatology OPD Data Comms Layout	12/05/12		A	31/05/12	08/05/12	BMCE-TRANSMIT-008682 (BMCE-WTRAN-002993)	29/05/12	11/07/12	B	19/07/12 BMCE-TRANSMIT-009933		
			MER	J	ME-ZJ-02-PL-556-531	Second Floor Plan NSGH Renal Dialysis Data Comms Layout	13/05/12		A	31/05/12	08/05/12	BMCE-TRANSMIT-008682 (BMCE-WTRAN-002993)	29/05/12	11/07/12	A	19/07/12 BMCE-TRANSMIT-009933		
		This was issued for information on BMCE-TRANSMIT-018728 09/12/13	MER	J	ME-ZJ-02-PL-556-532	Second Floor Plan NSGH Renal Dialysis Data Comms Layout	14/05/12		A	31/05/12	08/05/12	BMCE-TRANSMIT-008682 (BMCE-WTRAN-002993)	29/05/12	11/07/12	B	19/07/12 BMCE-TRANSMIT-009933		
		This was issued for information on BMCE-TRANSMIT-018728 09/12/13	MER	J	ME-ZJ-02-PL-556-533	Second Floor Plan NSGH Renal Dialysis Data Comms Layout	15/05/12		A	31/05/12	08/05/12	BMCE-TRANSMIT-008682 (BMCE-WTRAN-002993)	29/05/12	11/07/12	B	19/07/12 BMCE-TRANSMIT-009933		
		This was issued for information on BMCE-TRANSMIT-018728 09/12/13	MER	J	ME-ZJ-03-PL-556-109	Third Floor Plan Plant, Layout of Data Outlets Zone J			A	31/05/12	08/05/12	BMCE-TRANSMIT-008682 (BMCE-WTRAN-002993)	29/05/12	11/07/12	B	19/07/12 BMCE-TRANSMIT-009933		
			MER	J	ME-ZJ-04-PL-556-506	Fourth Floor Plan NSGH Renal Inpatients & Day Unit Data Comms Layout	16/03/12		A	03/05/12	09/05/12	BMCE-TRANSMIT-008742 (BMCE-WTRAN-003012)	30/05/12	12/07/12	A	18/07/12 BMCE-TRANSMIT-009887		
			MER	J	ME-ZJ-04-PL-556-507	Fourth Floor Plan NSGH Renal Inpatients & Day Unit Data Comms Layout	16/03/12		A	03/05/12	09/05/12	BMCE-TRANSMIT-008742 (BMCE-WTRAN-003012)	30/05/12	12/07/12	A	18/07/12 BMCE-TRANSMIT-009887		
			MER	J	ME-ZJ-04-PL-556-508	Fourth Floor Plan NSGH Renal Inpatients & Day Unit Data Comms Layout	16/03/12		A	03/05/12	09/05/12	BMCE-TRANSMIT-008742 (BMCE-WTRAN-003012)	30/05/12	12/07/12	A	18/07/12 BMCE-TRANSMIT-009887		
			MER	J	ME-ZJ-05-PL-556-506	Fifth Floor Plan NSGH Inpatient Wards Data Comms Layout	16/03/12		A	03/05/12	09/05/12	BMCE-TRANSMIT-008742 (BMCE-WTRAN-003012)	30/05/12	12/07/12	A	18/07/12 BMCE-TRANSMIT-009887		
			MER	J	ME-ZJ-05-PL-556-507	Fifth Floor Plan NSGH Inpatient Wards Data Comms Layout	16/03/12		A	03/05/12	09/05/12	BMCE-TRANSMIT-008742 (BMCE-WTRAN-003012)	30/05/12	12/07/12	A	18/07/12 BMCE-TRANSMIT-009887		
			MER	J	ME-ZJ-05-PL-556-508	Fifth Floor Plan NSGH Inpatient Wards Data Comms Layout	16/03/12		A	03/05/12	09/05/12	BMCE-TRANSMIT-008742 (BMCE-WTRAN-003012)	30/05/12	12/07/12	A	18/07/12 BMCE-TRANSMIT-009887		
BMS		Removed By Mercury - NOT REQUIRED FOR RDD (PART OF BMS DETAIL DESIGN)	MER	J	ME-ZJ-00-PL-660-537	Ground Floor Plan NSGH - Rehabilitation & Therapies BMS Layout	13/07/12			21/05/12			-					
		Removed By Mercury - NOT REQUIRED FOR RDD (PART OF BMS DETAIL DESIGN)	MER	J	ME-ZJ-00-PL-660-538	Ground Floor Plan NSGH - Rehabilitation & Therapies BMS Layout	13/07/12			21/05/12			-					
		Removed By Mercury - NOT REQUIRED FOR RDD (PART OF BMS DETAIL DESIGN)	MER	J	ME-ZJ-00-PL-660-539	Ground Floor Plan NSGH OPD BMS Layout	13/07/12			21/05/12			-					
		Removed By Mercury - NOT REQUIRED FOR RDD (PART OF BMS DETAIL DESIGN)	MER	J	ME-ZJ-00-PL-660-540	Ground Floor Plan NSGH OPD BMS Layout	13/07/12			21/05/12			-					
		Removed By Mercury - NOT REQUIRED FOR RDD (PART OF BMS DETAIL DESIGN)	MER	J	ME-ZJ-01-PL-660-537	First Floor Plan NSGH OPD BMS Layout	13/07/12			21/05/12			-					
		Removed By Mercury - NOT REQUIRED FOR RDD (PART OF BMS DETAIL DESIGN)	MER	J	ME-ZJ-01-PL-660-538	First Floor Plan NSGH OPD BMS Layout	13/07/12			21/05/12			-					
		Removed By Mercury - NOT REQUIRED FOR RDD (PART OF BMS DETAIL DESIGN)	MER	J	ME-ZJ-01-PL-660-539	First Floor Plan NSGH OPD BMS Layout	13/07/12			21/05/12			-					
		Removed By Mercury - NOT REQUIRED FOR RDD (PART OF BMS DETAIL DESIGN)	MER	J	ME-ZJ-02-PL-660-529	Second Floor Plan NSGH Dermatology OPD BMS Layout	13/07/12			21/05/12			-					
		Removed By Mercury - NOT REQUIRED FOR RDD (PART OF BMS DETAIL DESIGN)	MER	J	ME-ZJ-02-PL-660-530	Second Floor Plan NSGH Dermatology OPD BMS Layout	13/07/12			21/05/12			-					
		Removed By Mercury - NOT REQUIRED FOR RDD (PART OF BMS DETAIL DESIGN)	MER	J	ME-ZJ-02-PL-660-531	Second Floor Plan NSGH Renal Dialysis BMS Layout	13/07/12			21/05/12			-					
		Removed By Mercury - NOT REQUIRED FOR RDD (PART OF BMS DETAIL DESIGN)	MER	J	ME-ZJ-02-PL-660-532	Second Floor Plan NSGH Renal Dialysis BMS Layout	13/07/12			21/05/12			-					
		Removed By Mercury - NOT REQUIRED FOR RDD (PART OF BMS DETAIL DESIGN)	MER	J	ME-ZJ-02-PL-660-533	Second Floor Plan NSGH Renal Dialysis BMS Layout	13/07/12			21/05/12			-					
		Removed By Mercury - NOT REQUIRED FOR RDD (PART OF BMS DETAIL DESIGN)	MER	J	ME-ZJ-04-PL-660-506	Fourth Floor Plan NSGH Renal Inpatients & Day Unit BMS Layout	13/07/12			21/05/12			-					
		Removed By Mercury - NOT REQUIRED FOR RDD (PART OF BMS DETAIL DESIGN)	MER	J	ME-ZJ-04-PL-660-507	Fourth Floor Plan NSGH Renal Inpatients & Day Unit BMS Layout	13/07/12			21/05/12			-					
		Removed By Mercury - NOT REQUIRED FOR RDD (PART OF BMS DETAIL DESIGN)	MER	J	ME-ZJ-04-PL-660-508	Fourth Floor Plan NSGH Renal Inpatients & Day Unit BMS Layout	13/07/12			21/05/12			-					
		Removed By Mercury - NOT REQUIRED FOR RDD (PART OF BMS DETAIL DESIGN)	MER	J	ME-ZJ-05-PL-660-506	Fifth Floor Plan NSGH Inpatient Wards BMS Layout	13/07/12			21/05/12			-					

Drawing Information

31 BCL-AC-XX-SH-001

1st Submission2nd Submission

			Action By	Zone	Drawing Number	Drawing Title	Date Required from Consultant	Date Submitted by Consultant	Document Revision	Planned Date to be Submitted to Board	Date Submitted to Board	BMCE Transmittal No	Date Response Required from Board	Date Returned from Board	Board Status	Date returned to Consultant	Date Required from Consultant	Date Submitted by Consultant
Item	Submission	Comments																
			MER	J	ME-ZJ-02-PL-H512-001	Medical Gas Installation, Level 2, Zone J			1		29/05/12	BMCE-TRANSMIT-009123 (BMCE-WTRAN-003172)	19/06/12	24/09/12	C	27/09/12 BMCE-TRANSMIT-011202		
			MER	J	ME-ZJ-03-PL-H512-001	Medical Gas Installation, Level 3, Zone J			1		29/05/12	BMCE-TRANSMIT-009125 (BMCE-WTRAN-003173)	19/06/12	01/10/12	C	04/10/12 BMCE-TRANSMIT-011325		
		Issued for information on BMCE-TRANSMIT-019817 31/03/14	MER	J	ME-ZJ-04-PL-H512-001	Medical Gas Installation, Level 4, Zone J			1		29/05/12	BMCE-TRANSMIT-009122 (BMCE-WTRAN-003171)	19/06/12	01/10/12	C	04/10/12 BMCE-TRANSMIT-011324		
			MER	J	ME-ZJ-05-PL-H512-001	Medical Gas Installation, Level 5, Zone J			1		29/05/12	BMCE-TRANSMIT-009111 (BMCE-WTRAN-003165)	19/06/12	01/10/12	C	04/10/2012 BMCE-TRANSMIT-011322		
			MER	J	ME-ZJ-06-PL-H512-001	Medical Gas Installation, Level 6, Zone J			1		29/05/12	BMCE-TRANSMIT-009119 (BMCE-WTRAN-003169)	19/06/12	01/10/12	C	04/10/12 BMCE-TRANSMIT-011331		
			MER	J	ME-ZJ-07-PL-H512-001	Medical Gas Installation, Level 7, Zone J			1		29/05/12	BMCE-TRANSMIT-009109 (BMCE-WTRAN-003163)	19/06/12	01/10/12	C	04/10/12 BMCE-TRANSMIT-011329		
			MER	J	ME-ZJ-08-PL-H512-001	Medical Gas Installation, Level 8, Zone J			1		29/05/12	BMCE-TRANSMIT-009115 (BMCE-WTRAN-003166)	19/06/12	01/10/12	C	04/10/12 BMCE-TRANSMIT-011322		
			MER	J	ME-ZJ-09-PL-H512-001	Medical Gas Installation, Level 9, Zone J			1		29/05/12	BMCE-TRANSMIT-009117 (BMCE-WTRAN-003167)	19/06/12	01/10/12	C	04/10/12 BMCE-TRANSMIT-011326		
			MER	J	ME-ZJ-10-PL-H512-001	Medical Gas Installation, Level 10, Zone J			1		29/05/12	BMCE-TRANSMIT-009120 (BMCE-WTRAN-003170)	19/06/12	01/10/12	C	04/10/12 BMCE-TRANSMIT-011323		
			MER	J	ME-ZJ-11-PL-H512-001	Medical Gas Installation, Level 11, Zone J			1		29/05/12	BMCE-TRANSMIT-009118 (BMCE-WTRAN-003168)	19/06/12	01/10/12	C	04/10/12 BMCE-TRANSMIT-011327		
		Removed By Mercury - NOT REQUIRED FOR RDD (REFER TO HPI H512 SERIES DESIGN DRAWINGS)	MER	J	ME-ZJ-00-PL-512-537	Ground Floor Plan NSGH - Rehabilitation & Therapies Medical Gases Layout	13/07/12			21/05/12			-					
		Removed By Mercury - NOT REQUIRED FOR RDD (REFER TO HPI H512 SERIES DESIGN DRAWINGS)	MER	J	ME-ZJ-00-PL-512-538	Ground Floor Plan NSGH - Rehabilitation & Therapies Medical Gases Layout	13/07/12			21/05/12			-					
		Removed By Mercury - NOT REQUIRED FOR RDD (REFER TO HPI H512 SERIES DESIGN DRAWINGS)	MER	J	ME-ZJ-00-PL-512-539	Ground Floor Plan NSGH OPD Medical Gases Layout	13/07/12			21/05/12			-					
		Removed By Mercury - NOT REQUIRED FOR RDD (REFER TO HPI H512 SERIES DESIGN DRAWINGS)	MER	J	ME-ZJ-00-PL-512-540	Ground Floor Plan NSGH OPD Medical Gases Layout	13/07/12			21/05/12			-					
		Removed By Mercury - NOT REQUIRED FOR RDD (REFER TO HPI H512 SERIES DESIGN DRAWINGS)	MER	J	ME-ZJ-01-PL-512-537	First Floor Plan NSGH OPD Medical Gases Layout	13/07/12			21/05/12			-					
		Removed By Mercury - NOT REQUIRED FOR RDD (REFER TO HPI H512 SERIES DESIGN DRAWINGS)	MER	J	ME-ZJ-01-PL-512-538	First Floor Plan NSGH OPD Medical Gases Layout	13/07/12			21/05/12			-					
		Removed By Mercury - NOT REQUIRED FOR RDD (REFER TO HPI H512 SERIES DESIGN DRAWINGS)	MER	J	ME-ZJ-01-PL-512-539	First Floor Plan NSGH OPD Medical Gases Layout	13/07/12			21/05/12			-					
		Removed By Mercury - NOT REQUIRED FOR RDD (REFER TO HPI H512 SERIES DESIGN DRAWINGS)	MER	J	ME-ZJ-02-PL-512-529	Second Floor Plan NSGH Dermatology OPD Medical Gases Layout	13/07/12			21/05/12			-					
		Removed By Mercury - NOT REQUIRED FOR RDD (REFER TO HPI H512 SERIES DESIGN DRAWINGS)	MER	J	ME-ZJ-02-PL-512-530	Second Floor Plan NSGH Dermatology OPD Medical Gases Layout	13/07/12			21/05/12			-					
		Removed By Mercury - NOT REQUIRED FOR RDD (REFER TO HPI H512 SERIES DESIGN DRAWINGS)	MER	J	ME-ZJ-02-PL-512-531	Second Floor Plan NSGH Renal Dialysis Medical Gases Layout	13/07/12			21/05/12			-					
		Removed By Mercury - NOT REQUIRED FOR RDD (REFER TO HPI H512 SERIES DESIGN DRAWINGS)	MER	J	ME-ZJ-02-PL-512-532	Second Floor Plan NSGH Renal Dialysis Medical Gases Layout	13/07/12			21/05/12			-					
		Removed By Mercury - NOT REQUIRED FOR RDD (REFER TO HPI H512 SERIES DESIGN DRAWINGS)	MER	J	ME-ZJ-02-PL-512-533	Second Floor Plan NSGH Renal Dialysis Medical Gases Layout	13/07/12			21/05/12			-					
		Removed By Mercury - NOT REQUIRED FOR RDD (REFER TO HPI H512 SERIES DESIGN DRAWINGS)	MER	J	ME-ZJ-04-PL-512-506	Fourth Floor Plan NSGH Renal Inpatients & Day Unit Medical Gases Layout	13/07/12			21/05/12			-					
		Removed By Mercury - NOT REQUIRED FOR RDD (REFER TO HPI H512 SERIES DESIGN DRAWINGS)	MER	J	ME-ZJ-04-PL-512-507	Fourth Floor Plan NSGH Renal Inpatients & Day Unit Medical Gases Layout	13/07/12			21/05/12			-					
		Removed By Mercury - NOT REQUIRED FOR RDD (REFER TO HPI H512 SERIES DESIGN DRAWINGS)	MER	J	ME-ZJ-04-PL-512-508	Fourth Floor Plan NSGH Renal Inpatients & Day Unit Medical Gases Layout	13/07/12			21/05/12			-					
		Removed By Mercury - NOT REQUIRED FOR RDD (REFER TO HPI H512 SERIES DESIGN DRAWINGS)	MER	J	ME-ZJ-05-PL-512-506	Fifth Floor Plan NSGH Inpatient Wards Medical Gases Layout	13/07/12			21/05/12			-					
		Removed By Mercury - NOT REQUIRED FOR RDD (REFER TO HPI H512 SERIES DESIGN DRAWINGS)	MER	J	ME-ZJ-05-PL-512-507	Fifth Floor Plan NSGH Inpatient Wards Medical Gases Layout	13/07/12			21/05/12			-					
		Removed By Mercury - NOT REQUIRED FOR RDD (REFER TO HPI H512 SERIES DESIGN DRAWINGS)	MER	J	ME-ZJ-05-PL-512-508	Fifth Floor Plan NSGH Inpatient Wards Medical Gases Layout	13/07/12			21/05/12			-					
	Fire Detection & Smoke Control	Issued for information on BMCE-TRANSMIT-018891 18/12/13.	MER	J	ME-ZJ-00-PL-512-537	Ground Floor Plan NSGH - Rehabilitation & Therapies Fire Detection & Smoke Control Layout	04/05/12		A	31/05/12	08/05/12	BMCE-TRANSMIT-008688 (BMCE-WTRAN-000997)	29/05/12		B	20/06/12 BMCE-TRANSMIT-		

Drawing Information

31 BCL-AC-XX-SH-001

1st Submission2nd Submission

Item	Submission	Comments	Action By		Zone	Drawing Number	Drawing Title	Date Required from Consultant	Date Submitted by Consultant	Document Revision	Planned Date to be Submitted to Board	Date Submitted to Board	BMCE Transmittal No	Date Response Required from Board	Date Returned from Board	Board Status	Date returned to Consultant	Date Required from Consultant	Date Submitted by Consultant
		This was issued for information on BMCE-TRANSMIT-018728 09/12/13	MER	J		ME-ZJ-04-PL-572-508	Fourth Floor Plan NSGH Renal Inpatients & Day Unit Fire Detection & Smoke Control Layout	16/03/12		A	03/05/12	09/05/12	B,C,E-TRANSMIT-008745 (BMCE-WTRAN-003013)	30/05/12	06/06/12	B	18/06/12 BMCE-TRANSMIT-009386		
		This was issued for information on BMCE-TRANSMIT-018728 09/12/13	MER	J		ME-ZJ-05-PL-572-506	Fifth Floor Plan NSGH Inpatient Wards Fire Detection & Smoke Control Layout	13/07/12		A	31/05/12	09/05/12	B,C,E-TRANSMIT-008745 (BMCE-WTRAN-003013)	30/05/12	06/06/12	B	18/06/12 BMCE-TRANSMIT-009386		
		This was issued for information on BMCE-TRANSMIT-018728 09/12/13	MER	J		ME-ZJ-05-PL-572-507	Fifth Floor Plan NSGH Inpatient Wards Fire Detection & Smoke Control Layout	13/07/12		A	31/05/12	09/05/12	B,C,E-TRANSMIT-008745 (BMCE-WTRAN-003013)	30/05/12	06/06/12	B	18/06/12 BMCE-TRANSMIT-009386		
		This was issued for information on BMCE-TRANSMIT-018728 09/12/13	MER	J		ME-ZJ-05-PL-572-508	Fifth Floor Plan NSGH Inpatient Wards Fire Detection & Smoke Control Layout	13/07/12		A	31/05/12	09/05/12	B,C,E-TRANSMIT-008745 (BMCE-WTRAN-003013)	30/05/12	06/06/12	B	18/06/12 BMCE-TRANSMIT-009386		
		This was issued for information on BMCE-TRANSMIT-018728 09/12/13	MER	J		ME-ZJ-XX-PL-572-506	Sixth to Eleventh Floor Plan NSGH Inpatient Wards Fire Detection & Smoke Control Layout	16/03/12		A	03/05/12	09/05/12	B,C,E-TRANSMIT-008745 (BMCE-WTRAN-003013)	30/05/12	06/06/12	B	18/06/12 BMCE-TRANSMIT-009386		
		This was issued for information on BMCE-TRANSMIT-018728 09/12/13	MER	J		ME-ZJ-XX-PL-572-507	Sixth to Eleventh Floor Plan NSGH Inpatient Wards Fire Detection & Smoke Control Layout	16/03/12		A	03/05/12	09/05/12	B,C,E-TRANSMIT-008745 (BMCE-WTRAN-003013)	30/05/12	06/06/12	B	18/06/12 BMCE-TRANSMIT-009386		
		This was issued for information on BMCE-TRANSMIT-018728 09/12/13	MER	J		ME-ZJ-XX-PL-572-508	Sixth to Eleventh Floor Plan NSGH Inpatient Wards Fire Detection & Smoke Control Layout	16/03/12		A	03/05/12	09/05/12	B,C,E-TRANSMIT-008745 (BMCE-WTRAN-003013)	30/05/12	06/06/12	B	18/06/12 BMCE-TRANSMIT-009386		
	Pneumatic Tube System		MER	J		ME-ZJ-00-PL-569-001	Ground Floor Plan Pneumatic Tube System	04/05/12		A	31/05/12	04/05/12	BMCE-TRANSMIT=008685 (BMCE-WTRAN-002996)	21/06/12	08/06/12	A	14/06/12 BMCE-TRANSMIT-009362		
			MER	J		ME-ZJ-01-PL-569-002	First Floor plan Pneumatic Tube System	04/05/12		A	31/05/12	04/05/12	BMCE-TRANSMIT=008685 (BMCE-WTRAN-002996)	21/06/12	09/06/12	A	14/06/12 BMCE-TRANSMIT-009362		
			MER	J		ME-ZJ-02-PL-569-003	Second Floor Plan Pneumatic Tube System	04/05/12		A	31/05/12	04/05/12	BMCE-TRANSMIT=008685 (BMCE-WTRAN-002996)	21/06/12	10/06/12	A	14/06/12 BMCE-TRANSMIT-009362		
			MER	J		ME-ZJ-03-PL-569-004	Third Floor Plan Pneumatic Tube System	04/05/12		A	31/05/12	04/05/12	BMCE-TRANSMIT=008685 (BMCE-WTRAN-002996)	21/06/12	11/06/12	A	14/06/12 BMCE-TRANSMIT-009362		
		This area is incorporated in ME-XX-04-PL-569-005 (RDD Issue - 03/05/13 M.E-TRANSMIT-002403) Mercury Instruction	MER	J		ME-ZJ-04-PL-569-005	Fourth Floor Plan Pneumatic Tube System	16/03/12			03/05/12			24/05/12					
		This area is incorporated in ME-XX-05-PL-569-006 (RDD Issue - 03/05/13 M.E-TRANSMIT-002403) Mercury Instruction	MER	J		ME-ZJ-05-PL-569-006	Fifth Floor Plan Pneumatic Tube System	16/03/12			03/05/12			24/05/12					
		This area is incorporated in ME-XX-XX-PL-569-006 (RDD Issue - 03/05/13 M.E-TRANSMIT-002403) Mercury Instruction	MER	J		ME-ZJ-06-PL-569-007	Sixth Floor Plan Pneumatic Tube System	16/03/12			03/05/12			24/05/12					
		This area is incorporated in ME-XX-XX-PL-569-006 (RDD Issue - 03/05/13 M.E-TRANSMIT-002403) Mercury Instruction	MER	J		ME-ZJ-07-PL-569-008	Seventh Floor Plan Pneumatic Tube System	16/03/12			03/05/12			24/05/12					
		This area is incorporated in ME-XX-XX-PL-569-006 (RDD Issue - 03/05/13 M.E-TRANSMIT-002403) Mercury Instruction	MER	J		ME-ZJ-08-PL-569-009	Eighth Floor Plan Pneumatic Tube System	16/03/12			03/05/12			24/05/12					
		This area is incorporated in ME-XX-XX-PL-569-006 (RDD Issue - 03/05/13 M.E-TRANSMIT-002403) Mercury Instruction	MER	J		ME-ZJ-09-PL-569-010	Ninth Floor Plan Pneumatic Tube System	16/03/12			03/05/12			24/05/12					
		This area is incorporated in ME-XX-XX-PL-569-006 (RDD Issue - 03/05/13 M.E-TRANSMIT-002403) Mercury Instruction	MER	J		ME-ZJ-10-PL-569-011	Tenth Floor Plan Pneumatic Tube System	16/03/12			03/05/12			24/05/12					
		This area is incorporated in ME-XX-XX-PL-569-006 (RDD Issue - 03/05/13 M.E-TRANSMIT-002403) Mercury Instruction	MER	J		ME-ZJ-11-PL-569-012	Eleventh Floor Plan Pneumatic Tube System	16/03/12			03/05/12			24/05/12					
		REMOVED BY MERCURY - SUPERSEDED BY ME-XX-12-PL-569-013	MER	J		ME-ZJ-12-PL-569-013	Twelfth Floor Plantroom 123							21/06/09					
	Sprinklers		MER	J		ME-ZJ-00-PL-575-310	Ground Floor Void Layout	04/05/12		A	31/05/12	04/05/12	BMCE-TRANSMIT-008684 (BMCE-WTRAN-002995)	25/05/12		A	19/06/12 BMCE-TRANSMIT-009424		
			MER	J		ME-ZJ-00-PL-575-311	Ground Floor Ceiling Layout	04/05/12		A	31/05/12	04/05/12	BMCE-TRANSMIT-008684 (BMCE-WTRAN-002995)	25/05/12		A	19/06/12 BMCE-TRANSMIT-009424		
		Issued for information on BMCE-TRANSMIT-019712 18/03/14	MER	J		ME-ZJ-01-PL-575-310	First Floor Void Layout	04/05/12		A	31/05/12	04/05/12	BMCE-TRANSMIT-008684 (BMCE-WTRAN-002995)	25/05/12		B	19/06/12 BMCE-TRANSMIT-009424		
		Issued for information on BMCE-TRANSMIT-019712 18/03/14	MER	J		ME-ZJ-01-PL-575-311	First Floor Ceiling Layout	04/05/12		A	31/05/12	04/05/12	BMCE-TRANSMIT-008684 (BMCE-WTRAN-002995)	25/05/12		B	19/06/12 BMCE-TRANSMIT-009424		
		Issued for information on BMCE-TRANSMIT-019712 18/03/14	MER	J		ME-ZJ-02-PL-575-310	Second Floor Void Layout	04/05/12		A	31/05/12	04/05/12	BMCE-TRANSMIT-008684 (BMCE-WTRAN-002995)	25/05/12		B	19/06/12 BMCE-TRANSMIT-009424		
		Issued for information on BMCE-TRANSMIT-019712 18/03/14	MER	J		ME-ZJ-02-PL-575-311	Second Floor Ceiling Layout	04/05/12		A	31/05/12	04/05/12	BMCE-TRANSMIT-008684 (BMCE-WTRAN-002995)	25/05/12		B	19/06/12 BMCE-TRANSMIT-009424		
			MER	J		ME-ZJ-03-PL-575-310	Third Floor Void Layout	04/05/12		A	31/05/12	04/05/12	BMCE-TRANSMIT-008684 (BMCE-WTRAN-002995)	25/05/12		A	19/06/12 BMCE-TRANSMIT-009424		
			MER	J		ME-ZJ-03-PL-575-311	Third Floor Ceiling Layout	04/05/12		A	31/05/12	04/05/12	BMCE-TRANSMIT-008684 (BMCE-WTRAN-002995)	25/05/12		A	19/06/12 BMCE-TRANSMIT-009424		
		Issued for information on BMCE-TRANSMIT-019712 18/03/14	MER	J		ME-ZJ-04-PL-575-310	Fourth Floor Void Layout	16/03/12		A	03/05/12	09/05/12	BMCE-TRANSMIT-008750 (BMCE-WTRAN-003013)	30/05/12		B	20/06/12 BMCE-TRANSMIT-		

Drawing Information

31 BCL-AC-XX-SH-001

1st Submission2nd Submission

			Action By	Zone	Drawing Number	Drawing Title	Date Required from Consultant	Date Submitted by Consultant	Document Revision	Planned Date to be Submitted to Board	Date Submitted to Board	BMCE Transmittal No	Date Response Required from Board	Date Returned from Board	Board Status	Date returned to Consultant	Date Required from Consultant	Date Submitted by Consultant
Item	Submission	Comments																
		Issued for information on BMCE-TRANSMIT-019712 18/03/14	MER	J	ME-ZJ-11-PL-575-311	Eleventh Floor Ceiling Layout	16/03/12		A	03/05/12	09/05/12	BMCE-TRANSMIT-008750 (BMCE-WTRAN-003015)	30/05/12		B	20/06/12 BMCE-TRANSMIT-009436		
		Duplicate on RDD Schedule	MER	J	ME-ZJ-12-PL-575-310	Twelfth Floor Plantroom 123 Pipework Layout							21/01/00					
	CCTV/Door Access		MER	J	ME-ZJ-00-PL-571-537	Ground Floor Plan NSGH Rehabilitation & Therapies CCTV & Door Access Layout	04/05/12		A	31/05/12	08/05/12	BMCE-TRANSMIT-008683 (BMCE-WTRAN-002994)	29/05/12	11/07/12	A	16/07/12 BMCE-TRANSMIT-009860		
		REMOVED BY MERCURY - DRAWING DOES NOT EXIST	MER	J	ME-ZJ-00-PL-571-571	Ground Floor Plan NSGH Rehabilitation & Therapies CCTV & Door Access Layout	04/05/12			31/05/12								
			MER	J	ME-ZJ-00-PL-571-538				A	01/06/12	08/05/12	BMCE-TRANSMIT-008683 (BMCE-WTRAN-002994)	29/05/12	11/07/12	A	16/07/12 BMCE-TRANSMIT-009860		
		Issued for information on BMCE-TRANSMIT-018891 18/12/13	MER	J	ME-ZJ-00-PL-571-539	Ground Floor Plan NSGH OPD CCTV & Door Access Layout	04/05/12		A	31/05/12	08/05/12	BMCE-TRANSMIT-008683 (BMCE-WTRAN-002994)	29/05/12	11/07/12	B	16/07/12 BMCE-TRANSMIT-009860		
			MER	J	ME-ZJ-00-PL-571-540	Ground Floor Plan NSGH OPD CCTV & Door Access Layout	04/05/12		A	31/05/12	08/05/12	BMCE-TRANSMIT-008683 (BMCE-WTRAN-002994)	29/05/12	11/07/12	A	16/07/12 BMCE-TRANSMIT-009860		
			MER	J	ME-ZJ-01-PL-571-537	First Floor Plan NSGH OPD CCTV & Door Access Layout	04/05/12		A	31/05/12	08/05/12	BMCE-TRANSMIT-008683 (BMCE-WTRAN-002994)	29/05/12	11/07/12	A	16/07/12 BMCE-TRANSMIT-009860		
		REMOVED BY MERCURY - DRAWING DOES NOT EXIST	MER	J	ME-ZJ-01-PL-571-571	First Floor Plan NSGH OPD CCTV & Door Access Layout	04/05/12			31/05/12								
			MER	J	ME-ZJ-01-PL-571-538	First Floor Plan NSGH OPD CCTV & Door Access Layout zone j			A		08/05/12	BMCE-TRANSMIT-008683 (BMCE-WTRAN-002994)	29/05/12	11/07/12	B	16/07/12 BMCE-TRANSMIT-009860		
			MER	J	ME-ZJ-01-PL-571-539	First Floor Plan NSGH OPD CCTV & Door Access Layout	04/05/12		A	31/05/12	08/05/12	BMCE-TRANSMIT-008683 (BMCE-WTRAN-002994)	29/05/12	11/07/12	B	16/07/12 BMCE-TRANSMIT-009860		
		This was issued for information on BMCE-TRANSMIT-018728 09/12/13	MER	J	ME-ZJ-02-PL-571-529	Second Floor Plan NSGH Dermatology OPD CCTV & Door Access Panel	04/05/12		A	31/05/12	08/05/12	BMCE-TRANSMIT-008683 (BMCE-WTRAN-002994)	29/05/12	11/07/12	B	16/07/12 BMCE-TRANSMIT-009860		
			MER	J	ME-ZJ-02-PL-571-530	Second Floor Plan NSGH Dermatology OPD CCTV & Door Access Panel	04/05/12		A	31/05/12	08/05/12	BMCE-TRANSMIT-008683 (BMCE-WTRAN-002994)	29/05/12	11/07/12	A	16/07/12 BMCE-TRANSMIT-009860		
		This was issued for information on BMCE-TRANSMIT-018728 09/12/13	MER	J	ME-ZJ-02-PL-571-531	Second Floor Plan NSGH Renal Dialysis CCTV & Door Access Layout	04/05/12		A	31/05/12	08/05/12	BMCE-TRANSMIT-008683 (BMCE-WTRAN-002994)	29/05/12	11/07/12	B	16/07/12 BMCE-TRANSMIT-009860		
			MER	J	ME-ZJ-02-PL-571-532	Second Floor Plan NSGH Renal Dialysis CCTV & Door Access Layout	04/05/12		A	31/05/12	08/05/12	BMCE-TRANSMIT-008683 (BMCE-WTRAN-002994)	29/05/12	11/07/12	A	16/07/12 BMCE-TRANSMIT-009860		
		This was issued for information on BMCE-TRANSMIT-018728 09/12/13	MER	J	ME-ZJ-02-PL-571-533	Second Floor Plan NSGH Renal Dialysis CCTV & Door Access Layout	04/05/12		A	31/05/12	08/05/12	BMCE-TRANSMIT-008683 (BMCE-WTRAN-002994)	29/05/12	11/07/12	B	16/07/12 BMCE-TRANSMIT-009860		
		Issued for information on BMCE-TRANSMIT-018891 18/12/13	MER	J	ME-ZJ-03-PL-571-109	Third Floor Plant CCTV & Door Access Layout	04/05/12		A	31/05/12	08/05/12	BMCE-TRANSMIT-008683 (BMCE-WTRAN-002994)	29/05/12	11/07/12	B	16/07/12 BMCE-TRANSMIT-009860		
			MER	J	ME-ZJ-04-PL-571-506	Fourth Floor Plan NSGH Renal Inpatients & Day Unit CCTV/DoorAccess Layout	16/03/12		A	03/05/12	10/05/12	BMCE-TRANSMIT-008758 (BMCE-WTRAN-003022)	31/05/12	13/07/12	A	18/07/12 BMCE-TRANSMIT-009891		
			MER	J	ME-ZJ-04-PL-571-507	Fourth Floor Plan NSGH Renal Inpatients & Day Unit CCTV/DoorAccess Layout	16/03/12		A	03/05/12	10/05/12	BMCE-TRANSMIT-008758 (BMCE-WTRAN-003022)	31/05/12	13/07/12	A	18/07/12 BMCE-TRANSMIT-009891		
			MER	J	ME-ZJ-04-PL-571-508	Fourth Floor Plan NSGH Renal Inpatients & Day Unit CCTV/DoorAccess Layout	16/03/12		A	03/05/12	10/05/12	BMCE-TRANSMIT-008758 (BMCE-WTRAN-003022)	31/05/12	13/07/12	A	18/07/12 BMCE-TRANSMIT-009891		
			MER	J	ME-ZJ-05-PL-571-506	Fifth Floor Plan NSGH Renal Inpatients & Day Unit CCTV/DoorAccess Layout	16/03/12		A	03/05/12	10/05/12	BMCE-TRANSMIT-008758 (BMCE-WTRAN-003022)	31/05/12	13/07/12	A	18/07/12 BMCE-TRANSMIT-009891		
			MER	J	ME-ZJ-05-PL-571-507	Fifth Floor Plan NSGH Renal Inpatients & Day Unit CCTV/DoorAccess Layout	16/03/12		A	03/05/12	10/05/12	BMCE-TRANSMIT-008758 (BMCE-WTRAN-003022)	31/05/12	13/07/12	A	18/07/12 BMCE-TRANSMIT-009891		
			MER	J	ME-ZJ-05-PL-571-508	Fifth Floor Plan NSGH Renal Inpatients & Day Unit CCTV/DoorAccess Layout	16/03/12		A	03/05/12	10/05/12	BMCE-TRANSMIT-008758 (BMCE-WTRAN-003022)	31/05/12	13/07/12	A	18/07/12 BMCE-TRANSMIT-009891		
			MER	J	ME-ZJ-XX-PL-571-506	Sixth to Eleventh Floor Plan NSGH Inpatient Ward CCTV & Door Access Layout	16/03/12		A	03/05/12	10/05/12	BMCE-TRANSMIT-008758 (BMCE-WTRAN-003022)	31/05/12	13/07/12	A	18/07/12 BMCE-TRANSMIT-009891		
			MER	J	ME-ZJ-XX-PL-571-507	Sixth to Eleventh Floor Plan NSGH Inpatient Ward CCTV & Door Access Layout	16/03/12		A	03/05/12	10/05/12	BMCE-TRANSMIT-008758 (BMCE-WTRAN-003022)	31/05/12	13/07/12	A	18/07/12 BMCE-TRANSMIT-009891		
			MER	J	ME-ZJ-XX-PL-571-508	Sixth to Eleventh Floor Plan NSGH Inpatient Ward CCTV & Door Access Layout	16/03/12		A	03/05/12	10/05/12	BMCE-TRANSMIT-008758 (BMCE-WTRAN-003022)	31/05/12	13/07/12	A	18/07/12 BMCE-TRANSMIT-009891		
	Nurse Call	This was issued for information on BMCE-TRANSMIT-018728 09/12/13	MER	J	ME-ZJ-00-PL-538-537	Ground Floor Plan NSGH - Rehabilitation & Therapies Nurse Call Layout	04/05/12		A	31/05/12	08/05/12	BMCE-TRANSMIT-008689 (BCE-WTRAN-002998)	29/05/12	12/07/12	B			
		This was issued for information on BMCE-TRANSMIT-018728 09/12/13	MER	J	ME-ZJ-00-PL-538-538	Ground Floor Plan NSGH - Rehabilitation & Therapies Nurse Call Layout	04/05/12		A	31/05/12	08/05/12	BMCE-TRANSMIT-008689 (BCE-WTRAN-002998)	29/05/12	12/07/12	B			
		This was issued for information on BMCE-TRANSMIT-018728 09/12/13	MER	J	ME-ZJ-00-PL-538-539	Ground Floor Plan NSGH - OPD Nurse Call Layout	04/05/12		A	31/05/12	08/05/12	BMCE-TRANSMIT-008689 (BCE-WTRAN-002998)	29/05/12	12/07/12	B			

Drawing Information

31 BCL-AC-XX-SH-001

1st Submission2nd Submission

			Action By	Zone	Drawing Number	Drawing Title	Date Required from Consultant	Date Submitted by Consultant	Document Revision	Planned Date to be Submitted to Board	Date Submitted to Board	BMCE Transmittal No	Date Response Required from Board	Date Returned from Board	Board Status	Date returned to Consultant	Date Required from Consultant	Date Submitted by Consultant
Item	Submission	Comments																
		This was issued for information on BMCE-TRANSMIT-018728 09/12/13	MER	J	ME-ZJ-05-PL-538-507	Fifth Floor Plan. NSGH Inpatients Wards. Nurses Call Layout	16/03/12		A	03/05/12	09/05/12	BMCE-TRANSMIT-008748 (BMCE-WTRAN-003014)	30/05/12	12/07/12	B	19/07/2012 BMCE-TRANSMIT-1907/2012		
		This was issued for information on BMCE-TRANSMIT-018728 09/12/13	MER	J	ME-ZJ-05-PL-538-508	Fifth Floor Plan. NSGH Inpatients Wards. Nurses Call Layout	16/03/12		A	03/05/12	09/05/12	BMCE-TRANSMIT-008748 (BMCE-WTRAN-003014)	30/05/12	12/07/12	B	19/07/2012 BMCE-TRANSMIT-1907/2012		
		This was issued for information on BMCE-TRANSMIT-018728 09/12/13	MER	J	ME-ZJ-XX-PL-538-506	Fifth to Eleventh Floor Plan NSGH Inpatients Wards Nurse Call Layout	16/03/12		A	03/05/12	09/05/12	BMCE-TRANSMIT-008748 (BMCE-WTRAN-003014)	30/05/12	12/07/12	B	19/07/2012 BMCE-TRANSMIT-1907/2012		
		This was issued for information on BMCE-TRANSMIT-018728 09/12/13	MER	J	ME-ZJ-XX-PL-538-507	Fifth to Eleventh Floor Plan NSGH Inpatients Wards Nurse Call Layout	16/03/12		A	03/05/12	09/05/12	BMCE-TRANSMIT-008748 (BMCE-WTRAN-003014)	30/05/12	12/07/12	B	19/07/2012 BMCE-TRANSMIT-1907/2012		
		This was issued for information on BMCE-TRANSMIT-018728 09/12/13	MER	J	ME-ZJ-XX-PL-538-508	Fifth to Eleventh Floor Plan NSGH Inpatients Wards Nurse Call Layout	16/03/12		A	03/05/12	09/05/12	BMCE-TRANSMIT-008748 (BMCE-WTRAN-003014)	30/05/12	12/07/12	B	19/07/2012 BMCE-TRANSMIT-1907/2012		
	Lighting		MER	J	ME-ZJ-12-PL-541-506	Twelfth floor plan lighting layour plantroom 123			B		22/05/13	BMCE-TRANSMIT-015884 (BMCE-WTRAN-007579)	12/06/13	28/04/13	A			
			MER	J	ME-ZJ-12-PL-541-507	Twelfth floor plan lighting layour plantroom 123			B		22/05/13	BMCE-TRANSMIT-015884 (BMCE-WTRAN-007579)	12/06/13	28/04/13	A			
			MER	J	ME-ZJ-12-PL-541-508	Twelfth floor plan lighting layour plantroom 123			A		22/05/13	BMCE-TRANSMIT-015884 (BMCE-WTRAN-007579)	12/06/13	28/04/13	A	BMCE-TRANSMIT-015963 30/05/13		
		Issued for information on BMCE-TRANSMIT-019288 04/02/14	MER	J	ME-ZJ-12-PL-572-506	Twelfth floor plan Fire detection 123			A		22/05/13	BMCE-TRANSMIT-015884 (BMCE-WTRAN-007579)	12/06/13	28/04/13	B	BMCE-TRANSMIT-015963 30/05/13		
		Issued for information on BMCE-TRANSMIT-019288 04/02/14	MER	J	ME-ZJ-12-PL-572-507	Twelfth floor plan Fire detection 123			A		22/05/13	BMCE-TRANSMIT-015884 (BMCE-WTRAN-007579)	12/06/13	28/04/13	B	BMCE-TRANSMIT-015963 30/05/13		
		Issued for information on BMCE-TRANSMIT-019288 04/02/14	MER	J	ME-ZJ-12-PL-572-508	Twelfth floor plan Fire detection 123			A		22/05/13	BMCE-TRANSMIT-015884 (BMCE-WTRAN-007579)	12/06/13	28/04/13	B	BMCE-TRANSMIT-015963 30/05/13		
			MER	J	ME-ZJ-12-PL-575-310	Twelfth floor void layout zone J General Arrangement			A		22/05/13	BMCE-TRANSMIT-015884 (BMCE-WTRAN-007579)	12/06/13	28/04/13	A	BMCE-TRANSMIT-015963 30/05/13		
Mechanical Services Drawings Hospital Drawings - Zone K		THIS WAS ISSUED FOR INFORMATION ONLY ON BMCE-TRANSMIT-018069 24/09/13	ZBP	K	ZBP-ZK-00-PL-523-010	HTG & CHW Layout Ground	25/08/12		A	28/11/11	08/12/11	BMCE-TRANSMIT-007036	29/12/11	13/02/12	B	13/02/12 BMCE-TRANSMIT-007561		
		THIS WAS ISSUED FOR INFORMATION ONLY ON BMCE-TRANSMIT-018069 24/09/13	ZBP	K	ZBP-ZK-01-PL-523-020	HTG & CHW Layout First	25/08/12		A	28/11/11	08/12/11	BMCE-TRANSMIT-007036	29/12/11	13/02/12	B	13/02/12 BMCE-TRANSMIT-007561		
		THIS WAS ISSUED FOR INFORMATION ONLY ON BMCE-TRANSMIT-018069 24/09/13	ZBP	K	ZBP-ZK-02-PL-523-030	HTG & CHW Layout Second	25/08/12		A	28/11/11	08/12/11	BMCE-TRANSMIT-007036	29/12/11	13/02/12	B	13/02/12 BMCE-TRANSMIT-007561		
		THIS WAS ISSUED FOR INFORMATION ONLY ON BMCE-TRANSMIT-018069 24/09/13	ZBP	K	ZBP-ZK-03-PL-523-040	HTG & CHW Layout Third (Low Level)	25/08/12		A	28/11/11	08/12/11	BMCE-TRANSMIT-007036	29/12/11	13/02/12	B	13/02/12 BMCE-TRANSMIT-007561		
		REMOVED BY MERCURY	ZBP	K	ZBP-ZK-03-PL-523-041	HTG & CHW Layout Third (High Level)	24/10/11			28/11/11								

Drawing Information

31 BCL-AC-XX-SH-001

1st Submission2nd Submission

			Action By	Zone	Drawing Number	Drawing Title	Date Required from Consultant	Date Submitted by Consultant	Document Revision	Planned Date to be Submitted to Board	Date Submitted to Board	BMCE Transmittal No	Date Response Required from Board	Date Returned from Board	Board Status	Date returned to Consultant	Date Required from Consultant	Date Submitted by Consultant
Item	Submission	Comments																
			ZBP	K	ZBP-ZK-04-PL-523-050	HTG & CHW Layout Fourth	27/04/12		A	31/05/12	01/06/12	BMCE-TRANSMIT-009191 (BMCE-WTRAN-003206)	22/06/12	19/07/12	A	01/08/12 BMCE-TRANSMIT-010102 15/08/12		
		This was issued for infotmation on BMCE-TRANSMIT-017345 19/08/13	ZBP	K	ZBP-ZK-05-PL-523-060	HTG & CHW Layout Fifth	27/04/12		A	31/05/12	01/06/12	BMCE-TRANSMIT-009191 (BMCE-WTRAN-003206)	22/06/12	19/07/12	B	01/08/12 BMCE-TRANSMIT-010102 15/08/12		
		This was issued for infotmation on BMCE-TRANSMIT-017345 19/08/13	ZBP	K	ZBP-ZK-06-PL-523-070	HTG & CHW Layout Sixth	27/04/12		A	31/05/12	01/06/12	BMCE-TRANSMIT-009191 (BMCE-WTRAN-003206)	22/06/12	19/07/12	B	01/08/12 BMCE-TRANSMIT-010102 15/08/12		
		This was issued for infotmation on BMCE-TRANSMIT-017345 19/08/13	ZBP	K	ZBP-ZK-07-PL-523-080	HTG & CHW Layout Seventh	27/04/12		A	31/05/12	01/06/12	BMCE-TRANSMIT-009191 (BMCE-WTRAN-003206)	22/06/12	19/07/12	B	01/08/12 BMCE-TRANSMIT-010102 15/08/12		
			ZBP	K	ZBP-ZK-08-PL-523-090	HTG & CHW Layout Eighth	27/04/12		A	31/05/12	01/06/12	BMCE-TRANSMIT-009191 (BMCE-WTRAN-003206)	22/06/12	19/07/12	A	01/08/12 BMCE-TRANSMIT-010102 15/08/12		
			ZBP	K	ZBP-ZK-09-PL-523-100	HTG & CHW Layout Ninth	27/04/12		A	31/05/12	01/06/12	BMCE-TRANSMIT-009191 (BMCE-WTRAN-003206)	22/06/12	19/07/12	A	01/08/12 BMCE-TRANSMIT-010102 15/08/12		
			ZBP	K	ZBP-ZK-10-PL-523-110	HTG & CHW Layout Tenth	27/04/12		A	31/05/12	01/06/12	BMCE-TRANSMIT-009191 (BMCE-WTRAN-003206)	22/06/12	19/07/12	A	01/08/12 BMCE-TRANSMIT-010102 15/08/12		
			ZBP	K	ZBP-ZK-11-PL-523-120	HTG & CHW Layout Eleventh	27/04/12		A	31/05/12	01/06/12	BMCE-TRANSMIT-009191 (BMCE-WTRAN-003206)	22/06/12	19/07/12	A	01/08/12 BMCE-TRANSMIT-010102 15/08/12		
			ZBP	K	ZBP-ZK-00-PL-524-010	Ventilation Layout Ground	24/10/11		A	28/11/11	08/12/11	BMCE-TRANSMIT-007036	29/12/11	13/02/12	A	13/02/12 BMCE-TRANSMIT-007561		
		This was issued for infotmation on BMCE-TRANSMIT-017345 19/08/13	ZBP	K	ZBP-ZK-01-PL-524-020	Ventilation Layout First	24/10/11		A	28/11/11	08/12/11	BMCE-TRANSMIT-007036	29/12/11	13/02/12	B	13/02/12 BMCE-TRANSMIT-007561		
		This was issued for infotmation on BMCE-TRANSMIT-017345 19/08/13	ZBP	K	ZBP-ZK-02-PL-524-030	Ventilation Layout Second	24/10/11		A	28/11/11	08/12/11	BMCE-TRANSMIT-007036	29/12/11	13/02/12	B	13/02/12 BMCE-TRANSMIT-007561		
		This was issued for infotmation on BMCE-TRANSMIT-017345 19/08/13	ZBP	K	ZBP-ZK-03-PL-524-040	Ventilation Layout Third (Low Level)	25/08/12		A	28/11/11	08/12/11	BMCE-TRANSMIT-007036	29/12/11	13/02/12	B	13/02/12 BMCE-TRANSMIT-007561		
		REMOVED BY ZBP	ZBP	K	ZBP-ZK-03-PL-524-041	Ventilation Layout Third (High Level)	25/08/12			28/11/11			21/01/00					
			ZBP	K	ZBP-ZK-04-PL-524-050	Ventilation Layout Fourth	27/04/12		A	31/05/12	01/06/12	BMCE-TRANSMIT-009191 (BMCE-WTRAN-003206)	22/06/12	19/07/12	A	01/08/12 BMCE-TRANSMIT-010102 15/08/12		
		This was issued for infotmation on BMCE-TRANSMIT-017345 19/08/13	ZBP	K	ZBP-ZK-05-PL-524-060	Ventilation Layout Fifth	27/04/12		A	31/05/12	01/06/12	BMCE-TRANSMIT-009191 (BMCE-WTRAN-003206)	22/06/12	19/07/12	B	01/08/12 BMCE-TRANSMIT-010102 15/08/12		
		This was issued for infotmation on BMCE-TRANSMIT-017345 19/08/13	ZBP	K	ZBP-ZK-06-PL-524-070	Ventilation Layout Sixth	27/04/12		A	31/05/12	01/06/12	BMCE-TRANSMIT-009191 (BMCE-WTRAN-003206)	22/06/12	19/07/12	B	01/08/12 BMCE-TRANSMIT-010102 15/08/12		
		This was issued for infotmation on BMCE-TRANSMIT-017345 19/08/13	ZBP	K	ZBP-ZK-07-PL-524-080	Ventilation Layout Seventh	27/04/12		A	31/05/12	01/06/12	BMCE-TRANSMIT-009191 (BMCE-WTRAN-003206)	22/06/12	19/07/12	B	01/08/12 BMCE-TRANSMIT-010102 15/08/12		
			ZBP	K	ZBP-ZK-08-PL-524-090	Ventilation Layout Eighth	27/04/12		A	31/05/12	01/06/12	BMCE-TRANSMIT-009191 (BMCE-WTRAN-003206)	22/06/12	19/07/12	A	01/08/12 BMCE-TRANSMIT-010102 15/08/12		
		This was issued for infotmation on BMCE-TRANSMIT-017345 19/08/13	ZBP	K	ZBP-ZK-09-PL-524-100	Ventilation Layout Ninth	27/04/12		A	31/05/12	01/06/12	BMCE-TRANSMIT-009191 (BMCE-WTRAN-003206)	22/06/12	19/07/12	B	01/08/12 BMCE-TRANSMIT-010102 15/08/12		
		This was issued for infotmation on BMCE-TRANSMIT-017345 19/08/13	ZBP	K	ZBP-ZK-10-PL-524-110	Ventilation Layout Tenth	27/04/12		A	31/05/12	01/06/12	BMCE-TRANSMIT-009191 (BMCE-WTRAN-003206)	22/06/12	19/07/12	B	01/08/12 BMCE-TRANSMIT-010102 15/08/12		
		This was issued for infotmation on BMCE-TRANSMIT-017345 19/08/13	ZBP	K	ZBP-ZK-11-PL-524-120	Ventilation Layout Eleventh	27/04/12		A	31/05/12	01/06/12	BMCE-TRANSMIT-009191 (BMCE-WTRAN-003206)	22/06/12	19/07/12	B	01/08/12 BMCE-TRANSMIT-010102 15/08/12		
			ZBP	K	ZBP-ZK-00-PL-526-010	Environmental Strategy Ground	13/04/12		A		04/12/12	BMCE-TRANSMIT-012650 (BMCE-WTRAN-004966)	03/01/12	28/01/13	C	04/02/13 BMCE-TRANSMIT-013705		
			ZBP	K	ZBP-ZK-01-PL-526-020	Environmental Strategy First	13/04/12		A		04/12/12	BMCE-TRANSMIT-012650 (BMCE-WTRAN-004966)	03/01/12	28/01/13	C	04/02/13 BMCE-TRANSMIT-013705		
			ZBP	K	ZBP-ZK-02-PL-526-030	Environmental Strategy Second	13/04/12		A		04/12/12	BMCE-TRANSMIT-012650 (BMCE-WTRAN-004966)	03/01/12	28/01/13	A	04/02/13 BMCE-TRANSMIT-013705		
		Duplicate drawing of the above	ZBP	K	ZBP-ZK-02-PL-526-030	Environmental Strategy Second	13/04/12		A		04/12/12	BMCE-TRANSMIT-012650 (BMCE-WTRAN-004966)	03/01/12					
			ZBP	K	ZBP-ZK-03-PL-526-040	Environmental Strategy Third	13/04/12		A		14/06/12	BMCE-TRANSMIT-009352 (BMCE-WTRAN-003278)	05/07/12	10/09/12	A	20/09/12 BMCE-TRANSMIT-011065		
			ZBP	K	ZBP-ZK-04-PL-526-050	Environmental Strategy Typical Ward Support	27/04/12		A	31/05/12	22/06/12	BMCE-TRANSMIT-009470 (BMCE-WTRAN-003316) RE-ISSUED IN COLOUR	13/07/12	28/09/12	A	05/10/12 BMCE-TRANSMIT-011391		
		REMOVED BY ZBP	ZBP	K	ZBP-ZK-05-PL-526-060	Environmental Treatment Fifth	27/04/12			21/05/12								
		REMOVED BY ZBP	ZBP	K	ZBP-ZK-06-PL-526-070	Environmental Treatment Sixth	27/04/12			21/05/12								

Drawing Information

31 BCL-AC-XX-SH-001

			Action By		Zone	Drawing Number	Drawing Title	Date Required from Consultant	Date Submitted by Consultant	Document Revision	Planned Date to be Submitted to Board	Date Submitted to Board	BMCE Transmittal No	Date Response Required from Board	Date Returned from Board	Board Status	Date returned to Consultant	Date Required from Consultant	Date Submitted by Consultant
Item	Submission	Comments																	
	Electrical Services Drawings		ZBP	K	ZBP-ZK-00-PL-531-010	Small Power Layout Ground	25/08/11			B	28/11/11	08/12/11	BMCE-TRANSMIT-007035	29/12/11	11/05/12	A	23/05/12 BMCE-TRANSMIT-009008		
			ZBP	K	ZBP-ZK-01-PL-531-020	Small Power Layout First	25/08/11			B	28/11/11	08/12/11	BMCE-TRANSMIT-007035	29/12/11	11/05/12	A	23/05/12 BMCE-TRANSMIT-009008		
			ZBP	K	ZBP-ZK-02-PL-531-030	Small Power Layout Second	25/08/11			B	28/11/11	08/12/11	BMCE-TRANSMIT-007035	29/12/11	11/05/12	A	23/05/12 BMCE-TRANSMIT-009008		
			ZBP	K	ZBP-ZK-03-PL-531-040	Small Power Layout Third	25/08/11			B	28/11/11	08/12/11	BMCE-TRANSMIT-007035	29/12/11	11/05/12	A	23/05/12 BMCE-TRANSMIT-009008		
			ZBP	K	ZBP-ZK-04-PL-531-050	Small Power Layout Fourth	27/04/12			A	31/05/12	01/06/12	BMCE-TRANSMIT-009192 (BMCE-WTRAN-003207)	22/06/12	02/08/12	A	23/08/12 BMCE-TRANSMIT-010486		
			ZBP	K	ZBP-ZK-05-PL-531-060	Small Power Layout Fifth	27/04/12			A	31/05/12	01/06/12	BMCE-TRANSMIT-009192 (BMCE-WTRAN-003207)	22/06/12	02/08/12	A	23/08/12 BMCE-TRANSMIT-010486		
			ZBP	K	ZBP-ZK-06-PL-531-070	Small Power Layout Sixth	27/04/12			A	31/05/12	01/06/12	BMCE-TRANSMIT-009192 (BMCE-WTRAN-003207)	22/06/12	02/08/12	A	23/08/12 BMCE-TRANSMIT-010486		
			ZBP	K	ZBP-ZK-07-PL-531-080	Small Power Layout Seventh	27/04/12			A	31/05/12	01/06/12	BMCE-TRANSMIT-009192 (BMCE-WTRAN-003207)	22/06/12	02/08/12	A	23/08/12 BMCE-TRANSMIT-010486		
			ZBP	K	ZBP-ZK-08-PL-531-090	Small Power Layout Eighth	27/04/12			A	31/05/12	01/06/12	BMCE-TRANSMIT-009192 (BMCE-WTRAN-003207)	22/06/12	02/08/12	A	23/08/12 BMCE-TRANSMIT-010486		
			ZBP	K	ZBP-ZK-09-PL-531-100	Small Power Layout Ninth	27/04/12			A	31/05/12	01/06/12	BMCE-TRANSMIT-009192 (BMCE-WTRAN-003207)	22/06/12	02/08/12	A	23/08/12 BMCE-TRANSMIT-010486		
			ZBP	K	ZBP-ZK-10-PL-531-110	Small Power Layout Tenth	27/04/12			A	31/05/12	01/06/12	BMCE-TRANSMIT-009192 (BMCE-WTRAN-003207)	22/06/12	02/08/12	A	23/08/12 BMCE-TRANSMIT-010486		
			ZBP	K	ZBP-ZK-11-PL-531-120	Small Power Layout Eleventh	27/04/12			A	31/05/12	01/06/12	BMCE-TRANSMIT-009192 (BMCE-WTRAN-003207)	22/06/12	02/08/12	A	23/08/12 BMCE-TRANSMIT-010486		
			ZBP	K	ZBP-ZK-00-PL-532-010	Containment/Sub-Main Layout Ground	25/08/12			B	28/11/11	08/12/11	BMCE-TRANSMIT-007035	29/12/11	11/05/12	A	23/05/12 BMCE-TRANSMIT-009008		
			ZBP	K	ZBP-ZK-01-PL-532-020	Containment/Sub-Main Layout First	25/08/12			B	28/11/11	08/12/11	BMCE-TRANSMIT-007035	29/12/11	11/05/12	A	23/05/12 BMCE-TRANSMIT-009008		
			ZBP	K	ZBP-ZK-02-PL-532-030	Containment/Sub-Main Layout Second	25/08/12			B	28/11/11	08/12/11	BMCE-TRANSMIT-007035	29/12/11	11/05/12	A	23/05/12 BMCE-TRANSMIT-009008		
			ZBP	K	ZBP-ZK-03-PL-532-040	Containment/Sub-Main Layout Third	25/08/12			B	28/11/11	08/12/11	BMCE-TRANSMIT-007035	29/12/11	11/05/12	A	23/05/12 BMCE-TRANSMIT-009008		
			ZBP	K	ZBP-ZK-04-PL-532-050	Containment/Sub-Main Layout Fourth	27/04/12			A	31/05/12	01/06/12	BMCE-TRANSMIT-009192 (BMCE-WTRAN-003207)	22/06/12	02/08/12	A	23/08/12 BMCE-TRANSMIT-010486		
			ZBP	K	ZBP-ZK-05-PL-532-060	Containment/Sub-Main Layout Fifth	27/04/12			A	31/05/12	01/06/12	BMCE-TRANSMIT-009192 (BMCE-WTRAN-003207)	22/06/12	02/08/12	A	23/08/12 BMCE-TRANSMIT-010486		
			ZBP	K	ZBP-ZK-06-PL-532-070	Containment/Sub-Main Layout Sixth	27/04/12			A	31/05/12	01/06/12	BMCE-TRANSMIT-009192 (BMCE-WTRAN-003207)	22/06/12	02/08/12	A	23/08/12 BMCE-TRANSMIT-010486		
			ZBP	K	ZBP-ZK-07-PL-532-080	Containment/Sub-Main Layout Seventh	27/04/12			A	31/05/12	01/06/12	BMCE-TRANSMIT-009192 (BMCE-WTRAN-003207)	22/06/12	02/08/12	A	23/08/12 BMCE-TRANSMIT-010486		
			ZBP	K	ZBP-ZK-08-PL-532-090	Containment/Sub-Main Layout Eighth	27/04/12			A	31/05/12	01/06/12	BMCE-TRANSMIT-009192 (BMCE-WTRAN-003207)	22/06/12	02/08/12	A	23/08/12 BMCE-TRANSMIT-010486		
			ZBP	K	ZBP-ZK-09-PL-532-100	Containment/Sub-Main Layout Ninth	27/04/12			A	31/05/12	01/06/12	BMCE-TRANSMIT-009192 (BMCE-WTRAN-003207)	22/06/12	02/08/12	A	23/08/12 BMCE-TRANSMIT-010486		
			ZBP	K	ZBP-ZK-10-PL-532-110	Containment/Sub-Main Layout Tenth	27/04/12			A	31/05/12	01/06/12	BMCE-TRANSMIT-009192 (BMCE-WTRAN-003207)	22/06/12	02/08/12	A	23/08/12 BMCE-TRANSMIT-010486		
			ZBP	K	ZBP-ZK-11-PL-532-120	Containment/Sub-Main Layout Eleventh	27/04/12			A	31/05/12	01/06/12	BMCE-TRANSMIT-009192 (BMCE-WTRAN-003207)	22/06/12	02/08/12	A	23/08/12 BMCE-TRANSMIT-010486		
			ZBP	K	ZBP-ZK-00-PL-571-010	Security Layout Ground	25/08/12			A	28/11/11	08/12/11	BMCE-TRANSMIT-007035	29/12/11	11/05/12	A	23/05/12 BMCE-TRANSMIT-009008		
			ZBP	K	ZBP-ZK-01-PL-571-020	Security Layout First	25/08/12			A	28/11/11	08/12/11	BMCE-TRANSMIT-007035	29/12/11	11/05/12	A	23/05/12 BMCE-TRANSMIT-009008		
			ZBP	K	ZBP-ZK-02-PL-571-030	Security Layout Second	25/08/12			B	28/11/11	08/12/11	BMCE-TRANSMIT-007035	29/12/11	11/05/12	A	23/05/12 BMCE-TRANSMIT-009008		
			ZBP	K	ZBP-ZK-03-PL-571-040	Security Layout Third	25/08/12			B	28/11/11	08/12/11	BMCE-TRANSMIT-007035	29/12/11	11/05/12	A	23/05/12 BMCE-TRANSMIT-009008		
		This was issued for information on BMCE-TRANSMIT-017345 19/08/13	ZBP	K	ZBP-ZK-04-PL-571-050	Security Layout Fourth	27/04/12			A	31/05/12	01/06/12	BMCE-TRANSMIT-009192 (BMCE-WTRAN-003207)	22/06/12	02/08/12	B	23/08/12 BMCE-TRANSMIT-010486		

Drawing Information

31 BCL-AC-XX-SH-001

1st Submission2nd Submission

			Action By	Zone	Drawing Number	Drawing Title	Date Required from Consultant	Date Submitted by Consultant	Document Revision	Planned Date to be Submitted to Board	Date Submitted to Board	BMCE Transmittal No	Date Response Required from Board	Date Returned from Board	Board Status	Date returned to Consultant	Date Required from Consultant	Date Submitted by Consultant
Item	Submission	Comments																
		This was issued for infoimation on BMCE-TRANSMIT-017345 19/08/13	ZBP	K	ZBP-ZK-09-PL-571-100	Security Layout Ninth	27/04/12		A	31/05/12	01/06/12	BMCE-TRANSMIT-009192 (BMCE-WTRAN-003207)	22/06/12	02/08/12	B	23/08/12 BMCE-TRANSMIT-010486		
		This was issued for infoimation on BMCE-TRANSMIT-017345 19/08/13	ZBP	K	ZBP-ZK-10-PL-571-110	Security Layout Tenth	27/04/12		A	31/05/12	01/06/12	BMCE-TRANSMIT-009192 (BMCE-WTRAN-003207)	22/06/12	02/08/12	B	23/08/12 BMCE-TRANSMIT-010486		
		This was issued for infoimation on BMCE-TRANSMIT-017345 19/08/13	ZBP	K	ZBP-ZK-11-PL-571-120	Security Layout Eleventh	27/04/12		A	31/05/12	01/06/12	BMCE-TRANSMIT-009192 (BMCE-WTRAN-003207)	22/06/12	02/08/12	B	23/08/12 BMCE-TRANSMIT-010486		
	Public Health Services Drawings	REVISION G WAS ISSUED FOR INFORMATION ONLY ON BMCE-TRANSMIT-018069 25/10/13	ZBP	K	ZBP-ZK-00-PL-500-010	Water & Gas Services Layout Ground	25/08/12		B	28/11/11	02/12/11	BMCE-TRANSMIT-006949	23/12/11		B	14/02/12 BMCE-TRANSMIT-007629		
		REVISION G WAS ISSUED FOR INFORMATION ONLY ON BMCE-TRANSMIT-018069 25/10/13	ZBP	K	ZBP-ZK-01-PL-500-020	Water & Gas Services Layout First	25/08/12		B	28/11/11	02/12/11	BMCE-TRANSMIT-006949	23/12/11		B	14/02/12 BMCE-TRANSMIT-007629		
		REVISION f WAS ISSUED FOR INFORMATION ONLY ON BMCE-TRANSMIT-001512 24/09/13	ZBP	K	ZBP-ZK-02-PL-500-030	Water & Gas Services Layout Second	25/08/12		B	28/11/11	02/12/11	BMCE-TRANSMIT-006949	23/12/11		B	14/02/12 BMCE-TRANSMIT-007629		
		Issued for information on BMCE-TRANSMIT-019232 29/01/14	ZBP	K	ZBP-ZK-03-PL-500-040	Water Services Layout Third	25/08/12		A	28/11/11	02/12/11	BMCE-TRANSMIT-006949	23/12/11		B	14/02/12 BMCE-TRANSMIT-007629		
		This was issued for infoimation on BMCE-TRANSMIT-017345 19/08/13	ZBP	K	ZBP-ZK-04-PL-500-050	Water Services Layout Fourth	27/04/12		A	31/05/12	06/06/12	BMCE-TRANSMIT-009246 (BMCE-WTRAN-003218)	27/06/12	10/09/12	B	21/09/12 BMCE-TRANSMIT-011092		
		This was issued for infoimation on BMCE-TRANSMIT-017345 19/08/13	ZBP	K	ZBP-ZK-05-PL-500-060	Water Services Layout Fifth	27/04/12		A	31/05/12	06/06/12	BMCE-TRANSMIT-009246 (BMCE-WTRAN-003218)	27/06/12	10/09/12	B	21/09/12 BMCE-TRANSMIT-011092		
		This was issued for infoimation on BMCE-TRANSMIT-017345 19/08/13	ZBP	K	ZBP-ZK-06-PL-500-070	Water Services Layout Sixth	27/04/12		A	31/05/12	06/06/12	BMCE-TRANSMIT-009246 (BMCE-WTRAN-003218)	27/06/12	10/09/12	B	21/09/12 BMCE-TRANSMIT-011092		
		This was issued for infoimation on BMCE-TRANSMIT-017345 19/08/13	ZBP	K	ZBP-ZK-07-PL-500-080	Water Services Layout Seventh	27/04/12		A	31/05/12	06/06/12	BMCE-TRANSMIT-009246 (BMCE-WTRAN-003218)	27/06/12	10/09/12	B	21/09/12 BMCE-TRANSMIT-011092		
		This was issued for infoimation on BMCE-TRANSMIT-017345 19/08/13	ZBP	K	ZBP-ZK-08-PL-500-090	Water Services Layout Eighth	27/04/12		A	31/05/12	06/06/12	BMCE-TRANSMIT-009246 (BMCE-WTRAN-003218)	27/06/12	10/09/12	B	21/09/12 BMCE-TRANSMIT-011092		
		This was issued for infoimation on BMCE-TRANSMIT-017345 19/08/13	ZBP	K	ZBP-ZK-09-PL-500-100	Water Services Layout Ninth	27/04/12		A	31/05/12	06/06/12	BMCE-TRANSMIT-009246 (BMCE-WTRAN-003218)	27/06/12	10/09/12	B	21/09/12 BMCE-TRANSMIT-011092		
		This was issued for infoimation on BMCE-TRANSMIT-017345 19/08/13	ZBP	K	ZBP-ZK-10-PL-500-110	Water Services Layout Tenth	27/04/12		A	31/05/12	06/06/12	BMCE-TRANSMIT-009246 (BMCE-WTRAN-003218)	27/06/12	10/09/12	B	21/09/12 BMCE-TRANSMIT-011092		
		This was issued for infoimation on BMCE-TRANSMIT-017345 19/08/13	ZBP	K	ZBP-ZK-11-PL-500-120	Water Services Layout Eleventh	27/04/12		A	31/05/12	06/06/12	BMCE-TRANSMIT-009246 (BMCE-WTRAN-003218)	27/06/12	10/09/12	B	21/09/12 BMCE-TRANSMIT-011092		
			ZBP	K	ZBP-ZK-00-PL-581-010	Sanitation and Rainwater Layout Ground	24/10/11		A	28/11/11	02/12/11	BMCE-TRANSMIT-006949	23/12/11		A	14/02/12 BMCE-TRANSMIT-007629		
			ZBP	K	ZBP-ZK-01-PL-581-020	Sanitation and Rainwater Layout First	24/10/11		A	28/11/11	02/12/11	BMCE-TRANSMIT-006949	23/12/11		A	14/02/12 BMCE-TRANSMIT-007629		
			ZBP	K	ZBP-ZK-02-PL-581-030	Sanitation and Rainwater Layout Second	24/10/11		A	28/11/11	02/12/11	BMCE-TRANSMIT-006949	23/12/11		A	14/02/12 BMCE-TRANSMIT-007629		
			ZBP	K	ZBP-ZK-03-PL-581-040	Sanitation and Rainwater Layout Third	24/10/11		A	28/11/11	02/12/11	BMCE-TRANSMIT-006949	23/12/11		A	14/02/12 BMCE-TRANSMIT-007629		
			ZBP	K	ZBP-ZK-04-PL-581-050	Sanitation and Rainwater Layout Fourth	27/04/12		A	31/05/12	06/06/12	BMCE-TRANSMIT-009246 (BMCE-WTRAN-003218)	27/06/12	10/09/12	A	21/09/12 BMCE-TRANSMIT-011092		
			ZBP	K	ZBP-ZK-05-PL-581-060	Sanitation and Rainwater Layout Fifth	27/04/12		A	31/05/12	06/06/12	BMCE-TRANSMIT-009246 (BMCE-WTRAN-003218)	27/06/12	10/09/12	A	21/09/12 BMCE-TRANSMIT-011092		
			ZBP	K	ZBP-ZK-06-PL-581-070	Sanitation and Rainwater Layout Sixth	27/04/12		A	31/05/12	06/06/12	BMCE-TRANSMIT-009246 (BMCE-WTRAN-003218)	27/06/12	10/09/12	A	21/09/12 BMCE-TRANSMIT-011092		
			ZBP	K	ZBP-ZK-07-PL-581-080	Sanitation and Rainwater Layout Seventh	27/04/12		A	31/05/12	06/06/12	BMCE-TRANSMIT-009246 (BMCE-WTRAN-003218)	27/06/12	10/09/12	A	21/09/12 BMCE-TRANSMIT-011092		
			ZBP	K	ZBP-ZK-08-PL-581-090	Sanitation and Rainwater Layout Eighth	27/04/12		A	31/05/12	06/06/12	BMCE-TRANSMIT-009246 (BMCE-WTRAN-003218)	27/06/12	10/09/12	A	21/09/12 BMCE-TRANSMIT-011092		
			ZBP	K	ZBP-ZK-09-PL-581-100	Sanitation and Rainwater Layout Ninth	27/04/12		A	31/05/12	06/06/12	BMCE-TRANSMIT-009246 (BMCE-WTRAN-003218)	27/06/12	10/09/12	A	21/09/12 BMCE-TRANSMIT-011092		
			ZBP	K	ZBP-ZK-10-PL-581-110	Sanitation and Rainwater Layout Tenth	27/04/12		A	31/05/12	06/06/12	BMCE-TRANSMIT-009246 (BMCE-WTRAN-003218)	27/06/12	10/09/12	A	21/09/12 BMCE-TRANSMIT-011092		
			ZBP	K	ZBP-ZK-11-PL-581-120	Sanitation and Rainwater Layout Eleventh	27/04/12		A	31/05/12	06/06/12	BMCE-TRANSMIT-009246 (BMCE-WTRAN-003218)	27/06/12	10/09/12	A	21/09/12 BMCE-TRANSMIT-011092		
		This was issued for infoimation on BMCE-TRANSMIT-017345 19/08/13	ZBP	K	ZBP-ZK-12-PL-581-130	Sanitation and Rainwater Layout Twelfth			A		22/04/13	BMCE-TRANSMIT-015254 (BMCE-WTRAN-007115)	13/05/13	13/05/13	B	20/05/13 BMCE-TRANSMIT-015768		
			ZBP	K	ZBP-ZK-13-PL-581-140	Sanitation and Rainwater Layout Thirteenth			A		22/04/13	BMCE-TRANSMIT-015255 (BMCE-WTRAN-007116)	13/05/13	13/05/13	A	20/05/13 BMCE-TRANSMIT-		

			Date		Action By	Zone	Drawing Number	Drawing Title	Date Required from Consultant	Date Submitted by Consultant	Document Revision	Planned Date to be Submitted to Board	Date Submitted to Board	BMCE Transmittal No	Date Response Required from Board	Date Returned from Board	Board Status	Date returned to Consultant	Date Required from Consultant	Date Submitted by Consultant
Item	Submission	Comments																		
		REMOVED BY ZBP	ZBP	K	ZBP-FM-B1-PL-523-063	HTG & CHW Layout-Basement-		27/04/12				31/05/12			-					
		REMOVED BY ZBP	ZBP	K	ZBP-FM-B1-PL-523-064	HTG & CHW Layout-Basement-		27/04/12				31/05/12			-					
		REMOVED BY ZBP	ZBP	K	ZBP-FM-B1-PL-523-670	Basement-Vai-e-Room		27/04/12				31/05/12			-					
		Revision C was issued for information on BMCE-TRANSMIT-017345 19/08/13	ZBP	K	ZBP-FM-B1-PL-524-061	Ventilation Layout Basement		27/04/12		A		31/05/12	08/12/11	BMCE-TRANSMIT-007036	29/12/11		B	13/02/12 BMCE-TRANSMIT-007561		
		REMOVED BY ZBP	ZBP	K	ZBP-FM-B1-PL-524-062	Ventilation Layout-Basement-		27/04/12				31/05/12			-					
			ZBP	K	ZBP-FM-B1-PL-524-063	Ventilation Layout Basement		27/04/12		A		31/05/12	07/06/12	BMCE-TRANSMIT-009262 (BMCE-WTRAN-003226)	28/06/12	10/09/12	A	20/09/12 BMCE-TRANSMIT-011068		
		Issued for information on BMCE-TRANSMIT-019137 21/01/2014	ZBP	K	ZBP-FM-B1-PL-524-064	Ventilation Layout Basement		27/04/12		A		31/05/12	07/06/12	BMCE-TRANSMIT-009262 (BMCE-WTRAN-003226)	28/06/12	10/09/12	B	20/09/12 BMCE-TRANSMIT-011068		
Electrical Services Drawings			ZBP	K	ZBP-FM-B1-PL-531-061	Small Power Layout Basement		27/04/12		B			08/12/11	BMCE-TRANSMIT-007035	29/12/11	11/05/12	A	23/05/12 BMCE-TRANSMIT-009008		
			ZBP	K	ZBP-FM-B1-PL-531-062	Small Power Layout Basement		27/04/12		B			08/12/11	BMCE-TRANSMIT-007035	29/12/11	11/05/12	A	23/05/12 BMCE-TRANSMIT-009008		
			ZBP	K	ZBP-FM-B1-PL-531-063	Small Power Layout Basement		27/04/12		B			08/12/11	BMCE-TRANSMIT-007035	29/12/11	11/05/12	A	23/05/12 BMCE-TRANSMIT-009008		
			ZBP	K	ZBP-FM-B1-PL-531-064	Small Power Layout Basement		27/04/12		B			08/12/11	BMCE-TRANSMIT-007035	29/12/11	11/05/12	A	23/05/12 BMCE-TRANSMIT-009008		
			ZBP	K	ZBP-FM-B1-PL-532-061	Containment/Sub-Main Layout Basement		27/04/12		B		31/05/12	08/12/11	BMCE-TRANSMIT-007035	29/12/11	11/05/12	A	23/05/12 BMCE-TRANSMIT-009008		
			ZBP	K	ZBP-FM-B1-PL-532-062	Containment/Sub-Main Layout Basement		27/04/12		B		31/05/12	08/12/11	BMCE-TRANSMIT-007035	29/12/11	11/05/12	A	23/05/12 BMCE-TRANSMIT-009008		
			ZBP	K	ZBP-FM-B1-PL-532-063	Containment/Sub-Main Layout Basement		27/04/12		B		31/05/12	08/12/11	BMCE-TRANSMIT-007035	29/12/11	11/05/12	A	23/05/12 BMCE-TRANSMIT-009008		
			ZBP	K	ZBP-FM-B1-PL-532-064	Containment/Sub-Main Layout Basement		27/04/12		B		31/05/12	08/12/11	BMCE-TRANSMIT-007035	29/12/11	11/05/12	A	23/05/12 BMCE-TRANSMIT-009008		
			ZBP	K	ZBP-FM-B1-PL-571-061	Security Layout Basement		27/04/12		B			08/12/11	BMCE-TRANSMIT-007035	29/12/11	11/05/12	A	23/05/12 BMCE-TRANSMIT-009008		
			ZBP	K	ZBP-FM-B1-PL-571-062	Security Layout Basement		27/04/12		A			08/12/11	BMCE-TRANSMIT-007035	29/12/11	11/05/12	A	23/05/12 BMCE-TRANSMIT-009008		
			ZBP	K	ZBP-FM-B1-PL-571-063	Security Layout Basement		27/04/12		A			08/12/11	BMCE-TRANSMIT-007035	29/12/11	11/05/12	A	23/05/12 BMCE-TRANSMIT-009008		
			ZBP	K	ZBP-FM-B1-PL-571-064	Security Layout Basement		27/04/12		B			08/12/11	BMCE-TRANSMIT-007035	29/12/11	11/05/12	A	23/05/12 BMCE-TRANSMIT-009008		
Public Health Services Drawings			ZBP	K	ZBP-FM-B1-PL-500-061	Water & Gas Services Layout Basement		27/04/12		B		30/11/11	02/12/11	BMCE-TRANSMIT-006949	23/12/11		B	14/02/12 BMCE-TRANSMIT-007629		18/05/2012
			ZBP	K	ZBP-FM-B1-PL-500-061	Water & Gas Services Layout Basement				E			04/11/12	BMCE-TRANSMIT-012634 (BMCE-WTRAN-004960)	25/11/12	12/12/12	A	16/01/13 BMCE-TRANSMIT-013358		
		REMOVED BY ZBP	ZBP	K	ZBP-FM-B1-PL-500-062	Water & Gas Services Layout-Basement-		27/04/12				30/11/11			-					
		REMOVED BY ZBP	ZBP	K	ZBP-FM-B1-PL-500-063	Water & Gas Ser-ices Layout-Basement-		27/04/12				30/11/11			-					
		REMOVED BY ZBP	ZBP	K	ZBP-FM-B1-PL-500-064	Water & Gas Ser-ices Layout-Basement-		27/04/12				30/11/11			-					

Drawing Information

31

BCL-AC-XX-SH-001

1st Submission

2nd Submission

			Action By	Zone	Drawing Number	Drawing Title	Date Required from Consultant	Date Submitted by Consultant	Document Revision	Planned Date to be Submitted to Board	Date Submitted to Board	BMCE Transmittal No	Date Response Required from Board	Date Returned from Board	Board Status	Date returned to Consultant	Date Required from Consultant	Date Submitted by Consultant
Item	Submission	Comments																
		This was issued for information on BMCE-TRANSMIT-017345 19/08/13	ZBP	K	ZBP-FM-B1-PL-581-064	Sanitation and Rainwater Layout Basement	27/04/12			31/05/12	17/12/12	BMCE-TRANSMIT-012905 (BMCE-WTRAN-005150)	07/01/13	04/01/13	B	15/01/13 BMCE-TRANSMIT-013338		
		Revision E was issued for information only on BMCE-TRANSMIT-018069 24/19/13	ZBP	K	ZBP-FM-B1-PL-581-065	Sanitation and Rainwater Layout Generic Ward			C		04/06/13	BMCE-TRANSMIT-016093 (BMCE-WTRAN-007775)	25/09/13	08/07/13	B	TRANSMIT-016815		
			ZBP	K	ZBP-FM-B1-PL-590-100	Basement Combined Mechanical Services			C		29/04/13	BMCE-TRANSMIT-015380 (BMCE-WTRAN-007198)	20/05/13	29/04/13	A	BMCE-TRANSMIT-015980 30/05/13		
		This was issued for information on BMCE-TRANSMIT-017345 19/08/13	ZBP	K	ZBP-ZK-12-PL-532-195	LV Power Layout - 12th floor tower core			B		22/04/13	BMCE-TRANSMIT-015249 (BMCE-WTRAN-007111)	13/05/13	03/05/13	B	21/05/13 BMCE-TRANSMIT-015829		
			ZBP	K	ZBP-XX-XX-SC-500-001	Primary Domestic Water Services Schematic	27/04/12		A		30/05/12	BMCE-TRANSMIT-009098 (BMCE-WTRAN-003159)	20/06/12	19/07/12	A	28/07/12 BMCE-TRANSMIT-010051 15/08/12		
	Lighting	Issued for information on BMCE-TRANSMIT-018891 18/12/13	MER	K	ME-SZ-00-PL-541-501	Ground Floor Plan NSGH - Main Entrance & Public Areas Lighting Layout			C	12/01/00	02/12/11	BMCE-TRANSMIT-006946	23/12/11	31/01/12	B	BMCE-TRANSMIT-007475 02/02/10		
			MER	K	ME-SZ-00-PL-541-502	Ground Floor Plan NSGH - Main Entrance & Public Areas Lighting Layout			B	12/01/00	02/12/11	BMCE-TRANSMIT-006946	23/12/11	01/02/12	A	BMCE-TRANSMIT-007475 02/02/11		
		Issued for information on BMCE-TRANSMIT-018891 18/12/13	MER	K	ME-ZK-00-PL-541-503	Ground Floor Plan NSGH - Main Entrance & Public Areas Lighting Layout	24/10/11		C	28/11/11	02/12/11	BMCE-TRANSMIT-006946	23/12/11	02/02/12	B	BMCE-TRANSMIT-007475 02/02/12		
		Issued for information on BMCE-TRANSMIT-018891 18/12/13	MER	K	ME-ZK-00-PL-541-504	Ground Floor Plan NSGH - Main Entrance & Public Areas Lighting Layout	24/10/11		C	28/11/11	02/12/11	BMCE-TRANSMIT-006946	23/12/11	02/02/12	B	BMCE-TRANSMIT-007475 02/02/12		
			MER	K	ME-ZK-00-PL-541-505	Ground Floor Plan NSGH - Main Entrance & Public Areas Lighting Layout	24/10/11		C	28/11/11	02/12/11	BMCE-TRANSMIT-006946	23/12/11	02/02/12	A	BMCE-TRANSMIT-007475 02/02/12		
			MER	K	ME-SZ-00-PL-541-507	Ground Floor Plan NSGH - Pharmacy Dispensary Lighting Layout	24/10/11		C	28/11/11	02/12/11	BMCE-TRANSMIT-006946	23/12/11	02/02/12	A	BMCE-TRANSMIT-007475 02/02/12		
		This drawing number is a duplicate of below	MER	K	ME-ZK-01-PL-541-501	First Floor Plan NSGH Atrium & Restaurant Lighting Layout	24/10/11		C	28/11/11	02/12/11	BMCE-TRANSMIT-006946	23/12/11	02/02/12	B	BMCE-TRANSMIT-007475 02/02/12		
		Issued for information on BMCE-TRANSMIT-018891 18/12/13	MER	K	ME-ZK-01-PL-541-502	First Floor Plan NSGH Atrium & Restaurant Lighting Layout	24/10/11		C	28/11/11	02/12/11	BMCE-TRANSMIT-006946	23/12/11	02/02/12	B	BMCE-TRANSMIT-007475 02/02/12		
		Issued for information on BMCE-TRANSMIT-018891 18/12/13	MER	K	ME-ZK-01-PL-541-503	First Floor Plan NSGH Main Entrance Sanctuary & Public Core Lighting Layout	24/10/11		C	28/11/11	02/12/11	BMCE-TRANSMIT-006946	23/12/11	02/02/12	B	BMCE-TRANSMIT-007475 02/02/12		
		Issued for information on BMCE-TRANSMIT-018891 18/12/13	MER	K	ME-ZK-01-PL-541-504	First Floor Plan NSGH Atrium Lighting Layout	24/10/11		C	28/11/11	02/12/11	BMCE-TRANSMIT-006946	23/12/11	02/02/12	B	BMCE-TRANSMIT-007475 02/02/12		
		Issued for information on BMCE-TRANSMIT-018891 18/12/13	MER	K	ME-ZK-02-PL-541-501	Second Floor Plan NSGH Pub ic Core A and FM Support Lighting Layout	24/10/11		C	28/11/11	02/12/11	BMCE-TRANSMIT-006946	23/12/11	02/02/12	B	BMCE-TRANSMIT-007475 02/02/12		
			MER	K	ME-ZK-02-PL-541-502	Second Floor Plan NSGH Bed Core C & FM Support Lighting Layout	24/10/11		C	28/11/11	02/12/11	BMCE-TRANSMIT-006946	23/12/11	02/02/12	A	BMCE-TRANSMIT-007475 02/02/12		
			MER	K	ME-ZK-02-PL-541-503	Second Floor Plan NSGH Pub ic Core B & Support Lighting Layout	24/10/11		C	28/11/11	02/12/11	BMCE-TRANSMIT-006946	23/12/11	02/02/12	A	BMCE-TRANSMIT-007475 02/02/12		
		Issued for information on BMCE-TRANSMIT-018891 18/12/13	MER	K	ME-ZK-02-PL-541-504	Second Floor Plan NSGH Core D & FM Support Lighting Layout	24/10/11		C	28/11/11	02/12/11	BMCE-TRANSMIT-006946	23/12/11	02/02/12	B	BMCE-TRANSMIT-007475 02/02/12		
		Issued for information on BMCE-TRANSMIT-018891 18/12/13	MER	K	ME-ZK-03-PL-541-501	Third Floor Plan NSGH/NCH Admin, Training, Health Records & Staff Facilities Lighting Layout	24/10/11		C	28/11/11	02/12/11	BMCE-TRANSMIT-006946	23/12/11	02/02/12	B	BMCE-TRANSMIT-007475 02/02/12		
		Issued for information on BMCE-TRANSMIT-018891 18/12/13	MER	K	ME-ZK-03-PL-541-503	Third Floor Plan NSGH/NCH Staff Change, Hotel Services, Staff Accommodation Lighting Layout	24/10/11		C	28/11/11	02/12/11	BMCE-TRANSMIT-006946	23/12/11	02/02/12	B	BMCE-TRANSMIT-007475 02/02/12		
		Issued for information on BMCE-TRANSMIT-018891 18/12/13	MER	K	ME-ZK-04-PL-541-501	Fourth Floor Plan NSGH Renal Inpatients & Day Unit Lighting Layout	27/04/12		C	31/05/12	02/12/11	BMCE-TRANSMIT-006946	23/12/11	02/02/12	B	BMCE-TRANSMIT-007475 02/02/12		
		Issued for information on BMCE-TRANSMIT-018891 18/12/13	MER	K	ME-ZK-04-PL-541-502	Fourth Floor Plan NSGH Renal Inpatients & Day Unit Lighting Layout	27/04/12		C	31/05/12	02/12/11	BMCE-TRANSMIT-006946	23/12/11	02/02/12	B	BMCE-TRANSMIT-007475 02/02/12		
		Issued for information on BMCE-TRANSMIT-018891 18/12/13	MER	K	ME-ZK-05-PL-541-501	Fifth Floor Plan NSGH Inpatient Wards Lighting Layout	27/04/12		C	31/05/12	02/12/11	BMCE-TRANSMIT-006946	23/12/11	02/02/12	B	BMCE-TRANSMIT-007475 02/02/12		
		Issued for information on BMCE-TRANSMIT-018891 18/12/13	MER	K	ME-ZK-05-PL-541-502	Fifth Floor Plan NSGH Inpatient Wards Lighting Layout	27/04/12		C	31/05/12	02/12/11	BMCE-TRANSMIT-006946	23/12/11	02/02/12	B	BMCE-TRANSMIT-007475 02/02/12		
		Issued for information on BMCE-TRANSMIT-018891 18/12/13	MER	K	ME-ZK-06-PL-541-501	Sixth Floor Plan NSGH Inpatient Wards Lighting Layout	27/04/12		C	31/05/12	02/12/11	BMCE-TRANSMIT-006946	23/12/11	02/02/12	B	BMCE-TRANSMIT-007475 02/02/12		
		Issued for information on BMCE-TRANSMIT-018891 18/12/13	MER	K	ME-ZK-06-PL-541-502	Sixth Floor Plan NSGH Inpatient Wards Lighting Layout	27/04/12		C	31/05/12	02/12/11	BMCE-TRANSMIT-006946	23/12/11	02/02/12	B	BMCE-TRANSMIT-007475 02/02/12		
		Issued for information on BMCE-TRANSMIT-018891 18/12/13	MER	K	ME-ZK-07-PL-541-501	Seventh Floor Plan NSGH Inpatient Wards Lighting Layout	27/04/12		C	31/05/12	02/12/11	BMCE-TRANSMIT-006946	23/12/11	02/02/12	B	BMCE-TRANSMIT-007475 02/02/12		
		Issued for information on BMCE-TRANSMIT-018891 18/12/13	MER	K	ME-ZK-07-PL-541-502	Seventh Floor Plan NSGH Inpatient Wards Lighting Layout	27/04/12		C	31/05/12	02/12/11	BMCE-TRANSMIT-006946	23/12/11	02/02/12	B	BMCE-TRANSMIT-007475 02/02/12		
		Issued for information on BMCE-TRANSMIT-018891 18/12/13	MER	K	ME-ZK-08-PL-541-501	Eighth Floor Plan NSGH Inpatient Wards Lighting Layout	27/04/12		C	31/05/12	02/12/11	BMCE-TRANSMIT-006946	23/12/11	02/02/12	B	BMCE-TRANSMIT-007475 02/02/12		

Drawing Information

31 BCL-AC-XX-SH-001

1st Submission2nd Submission

		Action By		Zone		Drawing Number		Drawing Title		Date Required from Consultant	Date Submitted by Consultant	Document Revision	Planned Date to be Submitted to Board	Date Submitted to Board	BMCE Transmittal No	Date Response Required from Board	Date Returned from Board	Board Status	Date returned to Consultant	Date Required from Consultant	Date Submitted by Consultant
Item	Submission	Comments																			
		Removed By Mercury - NOT REQUIRED FOR RDD (SMALL POWER SHOWN ON NA 400 SERIES DRAWINGS)		MER	K	ME-ZK-00-PL-531-503		Ground Floor Plan NSGH - Main Entrance & Public Areas Small Power & General Services Layout		24/10/11			28/11/11			-					
		Removed By Mercury - NOT REQUIRED FOR RDD (SMALL POWER SHOWN ON NA 400 SERIES DRAWINGS)		MER	K	ME-ZK-00-PL-531-504		Ground Floor Plan NSGH - Main Entrance & Public Areas Small Power & General Services Layout		24/10/11			28/11/11			-					
		Removed By Mercury - NOT REQUIRED FOR RDD (SMALL POWER SHOWN ON NA 400 SERIES DRAWINGS)		MER	K	ME-ZK-00-PL-531-505		Ground Floor Plan NSGH - Main Entrance & Public Areas Small Power & General Services Layout		24/10/11			28/11/11			-					
		Removed By Mercury - NOT REQUIRED FOR RDD (SMALL POWER SHOWN ON NA 400 SERIES DRAWINGS)		MER	K	ME-ZK-01-PL-531-502		First Floor Plan NSGH Atrium & Restaurant Small Power & General Services Layout		24/10/11			28/11/11			-					
		Removed By Mercury - NOT REQUIRED FOR RDD (SMALL POWER SHOWN ON NA 400 SERIES DRAWINGS)		MER	K	ME-ZK-01-PL-531-503		First Floor Plan NSGH Main Entrance Sanctuary & Public Core Small Power & General Services Layout		24/10/11			28/11/11			-					
		Removed By Mercury - NOT REQUIRED FOR RDD (SMALL POWER SHOWN ON NA 400 SERIES DRAWINGS)		MER	K	ME-ZK-01-PL-531-504		First Floor Plan NSGH Atrium Small Power & General Services Layout		24/10/11			28/11/11			-					
		Removed By Mercury - NOT REQUIRED FOR RDD (SMALL POWER SHOWN ON NA 400 SERIES DRAWINGS)		MER	K	ME-ZK-02-PL-531-501		Second Floor Plan NSGH Public Core A and FM Support Small Power & General Services Layout		24/10/11			28/11/11			-					
		Removed By Mercury - NOT REQUIRED FOR RDD (SMALL POWER SHOWN ON NA 400 SERIES DRAWINGS)		MER	K	ME-ZK-02-PL-531-502		Second Floor Plan NSGH Bed Core C & FM Support Small Power & General Services Layout		24/10/11			28/11/11			-					
		Removed By Mercury - NOT REQUIRED FOR RDD (SMALL POWER SHOWN ON NA 400 SERIES DRAWINGS)		MER	K	ME-ZK-02-PL-531-503		Second Floor Plan NSGH Public Core B & Support Small Power & General Services Layout		24/10/11			28/11/11			-					
		Removed By Mercury - NOT REQUIRED FOR RDD (SMALL POWER SHOWN ON NA 400 SERIES DRAWINGS)		MER	K	ME-ZK-02-PL-531-504		Second Floor Plan NSGH Core D & FM Support Small Power & General Services Layout		24/10/11			28/11/11			-					
		Removed By Mercury - NOT REQUIRED FOR RDD (SMALL POWER SHOWN ON NA 400 SERIES DRAWINGS)		MER	K	ME-ZK-03-PL-531-501		Third Floor Plan NSGH INCH Admin, Training, Health Records & Staff Facilities Small Power & General Services Layout		24/10/11			28/11/11			-					
		Removed By Mercury - NOT REQUIRED FOR RDD (SMALL POWER SHOWN ON NA 400 SERIES DRAWINGS)		MER	K	ME-ZK-03-PL-531-503		Third Floor Plan NSGH INCH Staff Change, Hotel Services, Staff Accommodation Small Power & General Services Layout		24/10/11			28/11/11			-					
		Removed By Mercury - NOT REQUIRED FOR RDD (SMALL POWER SHOWN ON NA 400 SERIES DRAWINGS)		MER	K	ME-ZK-04-PL-531-501		Fourth Floor Plan NSGH Renal Inpatients & Day Unit Small Power & General Services Layout								-					
		Removed By Mercury - NOT REQUIRED FOR RDD (SMALL POWER SHOWN ON NA 400 SERIES DRAWINGS)		MER	K	ME-ZK-04-PL-531-502		Fourth Floor Plan NSGH Renal Inpatients & Day Unit Small Power & General Services Layout								-					
		Removed By Mercury - NOT REQUIRED FOR RDD (SMALL POWER SHOWN ON NA 400 SERIES DRAWINGS)		MER	K	ME-ZK-05-PL-531-501		Fifth Floor Plan NSGH Inpatient Wards Small Power & General Services Layout								-					
		Removed By Mercury - NOT REQUIRED FOR RDD (SMALL POWER SHOWN ON NA 400 SERIES DRAWINGS)		MER	K	ME-ZK-05-PL-531-502		Fifth Floor Plan NSGH Inpatient Wards Small Power & General Services Layout								-					
		Removed By Mercury - NOT REQUIRED FOR RDD (SMALL POWER SHOWN ON NA 400 SERIES DRAWINGS)		MER	K	ME-ZK-06-PL-531-501		Sixth Floor Plan NSGH Inpatient Wards Small Power & General Services Layout								-					

Drawing Information

31 BCL-AC-XX-SH-001

1st Submission2nd Submission

		Comments	Action By	Zone	Drawing Number	Drawing Title	Date Required from Consultant	Date Submitted by Consultant	Document Revision	Planned Date to be Submitted to Board	Date Submitted to Board	BMCE Transmittal No	Date Response Required from Board	Date Returned from Board	Board Status	Date returned to Consultant	Date Required from Consultant	Date Submitted by Consultant
Item	Submission																	
		Removed By Mercury - NOT REQUIRED FOR RDD (SMALL POWER SHOWN ON NA 400 SERIES DRAWINGS)	MER	K	ME-ZK-06-PL-531-502	Sixth Floor Plan NSGH Inpatient Wards Small Power & General Services Layout							-					
		Removed By Mercury - NOT REQUIRED FOR RDD (SMALL POWER SHOWN ON NA 400 SERIES DRAWINGS)	MER	K	ME-ZK-07-PL-531-501	Seventh Floor Plan NSGH Inpatient Wards Small Power & General Services Layout							-					
		Removed By Mercury - NOT REQUIRED FOR RDD (SMALL POWER SHOWN ON NA 400 SERIES DRAWINGS)	MER	K	ME-ZK-07-PL-531-502	Seventh Floor Plan NSGH Inpatient Wards Small Power & General Services Layout							-					
		Removed By Mercury - NOT REQUIRED FOR RDD (SMALL POWER SHOWN ON NA 400 SERIES DRAWINGS)	MER	K	ME-ZK-08-PL-531-501	Eighth Floor Plan NSGH Inpatient Wards Small Power & General Services Layout							-					
		Removed By Mercury - NOT REQUIRED FOR RDD (SMALL POWER SHOWN ON NA 400 SERIES DRAWINGS)	MER	K	ME-ZK-08-PL-531-502	Eighth Floor Plan NSGH Inpatient Wards Small Power & General Services Layout							-					
		Removed By Mercury - NOT REQUIRED FOR RDD (SMALL POWER SHOWN ON NA 400 SERIES DRAWINGS)	MER	K	ME-ZK-09-PL-531-501	Ninth Floor Plan NSGH Inpatient Wards Small Power & General Services Layout							-					
		Removed By Mercury - NOT REQUIRED FOR RDD (SMALL POWER SHOWN ON NA 400 SERIES DRAWINGS)	MER	K	ME-ZK-09-PL-531-502	Ninth Floor Plan NSGH Inpatient Wards Small Power & General Services Layout							-					
		Removed By Mercury - NOT REQUIRED FOR RDD (SMALL POWER SHOWN ON NA 400 SERIES DRAWINGS)	MER	K	ME-ZK-10-PL-531-501	Tenth Floor Plan NSGH Inpatient Wards Small Power & General Services Layout							-					
		Removed By Mercury - NOT REQUIRED FOR RDD (SMALL POWER SHOWN ON NA 400 SERIES DRAWINGS)	MER	K	ME-ZK-10-PL-531-502	Tenth Floor Plan NSGH Inpatient Wards Small Power & General Services Layout							-					
		Removed By Mercury - NOT REQUIRED FOR RDD (SMALL POWER SHOWN ON NA 400 SERIES DRAWINGS)	MER	K	ME-ZK-11-PL-531-501	Eleventh Floor Plan NSGH Inpatient Wards Small Power & General Services Layout							-					
		Removed By Mercury - NOT REQUIRED FOR RDD (SMALL POWER SHOWN ON NA 400 SERIES DRAWINGS)	MER	K	ME-ZK-11-PL-531-502	Eleventh Floor Plan NSGH Inpatient Wards Small Power & General Services Layout							-					
		Removed By Mercury - NOT REQUIRED FOR RDD (SMALL POWER SHOWN ON NA 400 SERIES DRAWINGS)	MER	K	ME-ZK-B1-PL-531-501	Basement Floor Plan NSGH Core D Small Power & General Services Layout							-					
		Removed By Mercury - NOT REQUIRED FOR RDD (SMALL POWER SHOWN ON NA 400 SERIES DRAWINGS)	MER	K	ME-ZK-00-PL-532-503	Ground Floor Plan NSGH - Main Entrance & Public Areas High Level Layout	24/10/11			28/11/11			-					
		Removed By Mercury - NOT REQUIRED FOR RDD (SMALL POWER SHOWN ON NA 400 SERIES DRAWINGS)	MER	K	ME-ZK-00-PL-532-504	Ground Floor Plan NSGH - Main Entrance & Public Areas High Level Layout	24/10/11			28/11/11			-					
		Removed By Mercury - NOT REQUIRED FOR RDD (SMALL POWER SHOWN ON NA 400 SERIES DRAWINGS)	MER	K	ME-ZK-00-PL-532-505	Ground Floor Plan NSGH - Main Entrance & Public Areas High Level Layout	24/10/11			28/11/11			-					
		Removed By Mercury - NOT REQUIRED FOR RDD (SMALL POWER SHOWN ON NA 400 SERIES DRAWINGS)	MER	K	ME-ZK-01-PL-532-502	First Floor Plan NSGH Atrium & Restaurant High Level Layout	24/10/11			28/11/11			-					
		Removed By Mercury - NOT REQUIRED FOR RDD (SMALL POWER SHOWN ON NA 400 SERIES DRAWINGS)	MER	K	ME-ZK-01-PL-532-503	First Floor Plan NSGH Main Entrance Sanctuary & Public Core High Level Layout	24/10/11			28/11/11			-					
		Removed By Mercury - NOT REQUIRED FOR RDD (SMALL POWER SHOWN ON NA 400 SERIES DRAWINGS)	MER	K	ME-ZK-01-PL-532-504	First Floor Plan NSGH Atrium High Level Layout	24/10/11			28/11/11			-					
		Removed By Mercury - NOT REQUIRED FOR RDD (SMALL POWER SHOWN ON NA 400 SERIES DRAWINGS)	MER	K	ME-ZK-02-PL-532-501	Second Floor Plan NSGH Public Core A and FM Support High Level Layout	24/10/11			28/11/11			-					
		Removed By Mercury - NOT REQUIRED FOR RDD (SMALL POWER SHOWN ON NA 400 SERIES DRAWINGS)	MER	K	ME-ZK-02-PL-532-502	Second Floor Plan NSGH Bed Core C & FM Support High Level Layout	24/10/11			28/11/11			-					
		Removed By Mercury - NOT REQUIRED FOR RDD (SMALL POWER SHOWN ON NA 400 SERIES DRAWINGS)	MER	K	ME-ZK-02-PL-532-503	Second Floor Plan NSGH Public Core B & Support High Level Layout	24/10/11			28/11/11			-					
		Removed By Mercury - NOT REQUIRED FOR RDD (SMALL POWER SHOWN ON NA 400 SERIES DRAWINGS)	MER	K	ME-ZK-02-PL-532-504	Second Floor Plan NSGH Core D & FM Support High Level Layout	24/10/11			28/11/11			-					
		Removed By Mercury - NOT REQUIRED FOR RDD (SMALL POWER SHOWN ON NA 400 SERIES DRAWINGS)	MER	K	ME-ZK-03-PL-532-501	Third Floor Plan NSGH/NCH Admin, Training, Health Records & Staff Facilities High Level Layout	24/10/11			28/11/11			-					
		Removed By Mercury - NOT REQUIRED FOR RDD (SMALL POWER SHOWN ON NA 400 SERIES DRAWINGS)	MER	K	ME-ZK-03-PL-532-503	Third Floor Plan NSGH/NCH Staff Change, Hotel Services, Staff Accommodation High Level Layout	24/10/11			28/11/11			-					
		Removed By Mercury - NOT REQUIRED FOR RDD (SMALL POWER SHOWN ON NA 400 SERIES DRAWINGS)	MER	K	ME-ZK-04-PL-532-501	Fourth Floor Plan NSGH Renal Inpatients & Day Unit High Level Layout							-					
		Removed By Mercury - NOT REQUIRED FOR RDD (SMALL POWER SHOWN ON NA 400 SERIES DRAWINGS)	MER	K	ME-ZK-04-PL-532-502	Fourth Floor Plan NSGH Renal Inpatients & Day Unit High Level Layout							-					
		Removed By Mercury - NOT REQUIRED FOR RDD (SMALL POWER SHOWN ON NA 400 SERIES DRAWINGS)	MER	K	ME-ZK-05-PL-532-501	Fifth Floor Plan NSGH Inpatient Wards High Level Layout							-					
		Removed By Mercury - NOT REQUIRED FOR RDD (SMALL POWER SHOWN ON NA 400 SERIES DRAWINGS)	MER	K	ME-ZK-05-PL-532-502	Fifth Floor Plan NSGH Inpatient Wards High Level Layout							-					
		Removed By Mercury - NOT REQUIRED FOR RDD (SMALL POWER SHOWN ON NA 400 SERIES DRAWINGS)	MER	K	ME-ZK-06-PL-532-501	Sixth Floor Plan NSGH Inpatient Wards High Level Layout							-					
		Removed By Mercury - NOT REQUIRED FOR RDD (SMALL POWER SHOWN ON NA 400 SERIES DRAWINGS)	MER	K	ME-ZK-06-PL-532-502	Sixth Floor Plan NSGH Inpatient Wards High Level Layout							-					
		Removed By Mercury - NOT REQUIRED FOR RDD (SMALL POWER SHOWN ON NA 400 SERIES DRAWINGS)	MER	K	ME-ZK-07-PL-532-501	Seventh Floor Plan NSGH Inpatient Wards High Level Layout							-					

Drawing Information

31	BCL-AC-XX-SH-001					1st Submission												2nd Submission			
		Action By	Zone	Drawing Number	Drawing Title	Date Required from Consultant	Date Submitted by Consultant	Document Revision	Planned Date to be Submitted to Board	Date Submitted to Board	BMCE Transmittal No	Date Response Required from Board	Date Returned from Board	Board Status	Date returned to Consultant	Date Required from Consultant	Date Submitted by Consultant				
Item	Submission	Comments																			
		Removed By Mercury - NOT REQUIRED FOR RDD (SMALL POWER SHOWN ON NA 400 SERIES DRAWINGS)	MER	K	ME-ZK-01-PL-532-503	First Floor Plan NSGH Main Entrance Sanctuary & Public Core ELV Systems low level Layout	24/10/11				28/11/11	-									
		Removed By Mercury - NOT REQUIRED FOR RDD (SMALL POWER SHOWN ON NA 400 SERIES DRAWINGS)	MER	K	ME-ZK-01-PL-532-504	First Floor Plan NSGH Atrium ELV Systems low level Layout	24/10/11				28/11/11	-									
		Removed By Mercury - NOT REQUIRED FOR RDD (SMALL POWER SHOWN ON NA 400 SERIES DRAWINGS)	MER	K	ME-ZK-02-PL-532-501	Second Floor Plan NSGH Public Core A and FM Support ELV Systems low level Layout	24/10/11				28/11/11	-									
		Removed By Mercury - NOT REQUIRED FOR RDD (SMALL POWER SHOWN ON NA 400 SERIES DRAWINGS)	MER	K	ME-ZK-02-PL-532-502	Second Floor Plan NSGH Bed Core C & FM Support ELV Systems low level Layout	24/10/11				28/11/11	-									
		Removed By Mercury - NOT REQUIRED FOR RDD (SMALL POWER SHOWN ON NA 400 SERIES DRAWINGS)	MER	K	ME-ZK-02-PL-532-503	Second Floor Plan NSGH Public Core B & Support ELV Systems low level Layout	24/10/11				28/11/11	-									
		Removed By Mercury - NOT REQUIRED FOR RDD (SMALL POWER SHOWN ON NA 400 SERIES DRAWINGS)	MER	K	ME-ZK-02-PL-532-504	Second Floor Plan NSGH Core D & FM Support ELV Systems low level Layout	24/10/11				28/11/11	-									
		Removed By Mercury - NOT REQUIRED FOR RDD (SMALL POWER SHOWN ON NA 400 SERIES DRAWINGS)	MER	K	ME-ZK-03-PL-532-501	Third Floor Plan NSGH/NCH Admin, Training, Health Records & Staff Facilities ELV Systems low level Layout	24/10/11				28/11/11	-									
		Removed By Mercury - NOT REQUIRED FOR RDD (SMALL POWER SHOWN ON NA 400 SERIES DRAWINGS)	MER	K	ME-ZK-03-PL-532-503	Third Floor Plan NSGH/NCH Staff Change, Hotel Services, Staff Accommodation ELV Systems low level Layout	24/10/11				28/11/11	-									
		Removed By Mercury - NOT REQUIRED FOR RDD (SMALL POWER SHOWN ON NA 400 SERIES DRAWINGS)	MER	K	ME-ZK-04-PL-532-501	Fourth Floor Plan NSGH Renal Inpatients & Day Unit ELV Systems low level Layout						-									
		Removed By Mercury - NOT REQUIRED FOR RDD (SMALL POWER SHOWN ON NA 400 SERIES DRAWINGS)	MER	K	ME-ZK-04-PL-532-502	Fourth Floor Plan NSGH Renal Inpatients & Day Unit ELV Systems low level Layout						-									
		Removed By Mercury - NOT REQUIRED FOR RDD (SMALL POWER SHOWN ON NA 400 SERIES DRAWINGS)	MER	K	ME-ZK-05-PL-532-501	Fifth Floor Plan NSGH Inpatient Wards ELV Systems low level Layout						-									
		Removed By Mercury - NOT REQUIRED FOR RDD (SMALL POWER SHOWN ON NA 400 SERIES DRAWINGS)	MER	K	ME-ZK-05-PL-532-502	Fifth Floor Plan NSGH Inpatient Wards ELV Systems low level Layout						-									
		Removed By Mercury - NOT REQUIRED FOR RDD (SMALL POWER SHOWN ON NA 400 SERIES DRAWINGS)	MER	K	ME-ZK-06-PL-532-501	Sixth Floor Plan NSGH Inpatient Wards ELV Systems low level Layout						-									
		Removed By Mercury - NOT REQUIRED FOR RDD (SMALL POWER SHOWN ON NA 400 SERIES DRAWINGS)	MER	K	ME-ZK-06-PL-532-502	Sixth Floor Plan NSGH Inpatient Wards ELV Systems low level Layout						-									
		Removed By Mercury - NOT REQUIRED FOR RDD (SMALL POWER SHOWN ON NA 400 SERIES DRAWINGS)	MER	K	ME-ZK-07-PL-532-501	Seventh Floor Plan NSGH Inpatient Wards ELV Systems low level Layout						-									
		Removed By Mercury - NOT REQUIRED FOR RDD (SMALL POWER SHOWN ON NA 400 SERIES DRAWINGS)	MER	K	ME-ZK-07-PL-532-502	Seventh Floor Plan NSGH Inpatient Wards ELV Systems low level Layout						-									
		Removed By Mercury - NOT REQUIRED FOR RDD (SMALL POWER SHOWN ON NA 400 SERIES DRAWINGS)	MER	K	ME-ZK-08-PL-532-501	Eighth Floor Plan NSGH Inpatient Wards ELV Systems low level Layout						-									
		Removed By Mercury - NOT REQUIRED FOR RDD (SMALL POWER SHOWN ON NA 400 SERIES DRAWINGS)	MER	K	ME-ZK-08-PL-532-502	Eighth Floor Plan NSGH Inpatient Wards ELV Systems low level Layout						-									
		Removed By Mercury - NOT REQUIRED FOR RDD (SMALL POWER SHOWN ON NA 400 SERIES DRAWINGS)	MER	K	ME-ZK-09-PL-532-501	Ninth Floor Plan NSGH Inpatient Wards ELV Systems low level Layout						-									
		Removed By Mercury - NOT REQUIRED FOR RDD (SMALL POWER SHOWN ON NA 400 SERIES DRAWINGS)	MER	K	ME-ZK-09-PL-532-502	Ninth Floor Plan NSGH Inpatient Wards ELV Systems low level Layout						-									
		Removed By Mercury - NOT REQUIRED FOR RDD (SMALL POWER SHOWN ON NA 400 SERIES DRAWINGS)	MER	K	ME-ZK-10-PL-532-501	Tenth Floor Plan NSGH Inpatient Wards ELV Systems low level Layout						-									
		Removed By Mercury - NOT REQUIRED FOR RDD (SMALL POWER SHOWN ON NA 400 SERIES DRAWINGS)	MER	K	ME-ZK-10-PL-532-502	Tenth Floor Plan NSGH Inpatient Wards ELV Systems low level Layout						-									
		Removed By Mercury - NOT REQUIRED FOR RDD (SMALL POWER SHOWN ON NA 400 SERIES DRAWINGS)	MER	K	ME-ZK-11-PL-532-501	Eleventh Floor Plan NSGH Inpatient Wards ELV Systems low level Layout						-									
		Removed By Mercury - NOT REQUIRED FOR RDD (SMALL POWER SHOWN ON NA 400 SERIES DRAWINGS)	MER	K	ME-ZK-11-PL-532-502	Eleventh Floor Plan NSGH Inpatient Wards ELV Systems low level Layout						-									
		Removed By Mercury - NOT REQUIRED FOR RDD (SMALL POWER SHOWN ON NA 400 SERIES DRAWINGS)	MER	K	ME-ZK-B1-PL-532-501	Basement Floor Plan NSGH Core D ELV Systems low level Layout						-									
		Removed from schedule - drawing has been moved to tab 19 Lighting	MER	K	ME-XX-XX-SP-541-110	Lighting Calculations - Zone K			A		31/01/14	BMCE TRANSMIT-010243 (BMCE-WTRAN-000845)	21/02/14								
		Removed from schedule - drawing has been moved to tab 19 Lighting	MER	K	ME-XX-XX-SP-541-111	Lighting Calculations - Adults			A		31/01/14	BMCE TRANSMIT-010243 (BMCE-WTRAN-000845)	21/02/14								
	Data Comms		MER	K	ME-SZ-00-PL-556-501	Ground Floor Plan NSGH - Main Entrance & Public Areas Data Comms Layout			B		26/02/13	BMCE-TRANSMIT-014130 (BMCE-WTRAN-006180)	19/03/13	25/03/13	A	03/05/13 BMCE-TRANSMIT-014906					
		This was issued for information on BMCE-TRANSMIT-018726	MER	K	ME-SZ-00-PL-556-502	Ground Floor Plan NSGH - Main Entrance & Public Areas Data Comms Layout			E		26/02/13	BMCE-TRANSMIT-014130 (BMCE-WTRAN-006180)	19/03/13	25/03/13	B	03/05/13 BMCE-TRANSMIT-014906					
		Issued for information on BMCE-TRANSMIT-018891 18/12/13	MER	K	ME-ZK-00-PL-556-503	Ground Floor Plan NSGH - Main Entrance & Public Areas Data Comms Layout	24/10/11				28/11/11	02/12/11	BMCE-TRANSMIT-006348	23/12/11	23/12/11	B					

Drawing Information

31

BCL-AC-XX-SH-001

1st Submission

2nd Submission

			Action By		Zone	Drawing Number	Drawing Title	Date Required from Consultant	Date Submitted by Consultant	Document Revision	Planned Date to be Submitted to Board	Date Submitted to Board	BMCE Transmittal No	Date Response Required from Board	Date Returned from Board	Board Status	Date returned to Consultant	Date Required from Consultant	Date Submitted by Consultant	
Item	Submission	Comments																		
		Issued for information on BMCE-TRANSMIT-018891 18/12/13	MER	K	ME-ZK-XX-PL-556-501	Fifth to Eleventh Floor Plan NSGH Inpatient Wards Layout of Data Outlets							BMCE-TRANSMIT-006348	21/01/00	23/12/11	B				
			MER	K	ME-ZK-XX-PL-556-502	Fifth to Eleventh Floor Plan NSGH Inpatient Wards Layout of Data Outlets							BMCE-TRANSMIT-006348	21/01/00	23/12/11	A				
		Incorporated in Drawing ME-ZK-XX-PL-556-501 Mercury Instruction	MER	K	ME-ZK-05-PL-556-501	Fifth Floor Plan NSGH Inpatient Wards Data Comms Layout	27/04/12				31/05/12			-						
		Incorporated in Drawing ME-ZK-XX-PL-556-502 Mercury Instruction	MER	K	ME-ZK-05-PL-556-502	Fifth Floor Plan NSGH Inpatient Wards Data Comms Layout	27/04/12				31/05/12			-						
		Incorporated in Drawing ME-ZK-XX-PL-556-501 Mercury Instruction	MER	K	ME-ZK-06-PL-556-501	Sixth Floor Plan NSGH Inpatient Wards Data Comms Layout	27/04/12				31/05/12			-						
		Incorporated in Drawing ME-ZK-XX-PL-556-502 Mercury Instruction	MER	K	ME-ZK-06-PL-556-502	Sixth Floor Plan NSGH Inpatient Wards Data Comms Layout	27/04/12				31/05/12			-						
		Incorporated in Drawing ME-ZK-XX-PL-556-501 Mercury Instruction	MER	K	ME-ZK-07-PL-556-501	Sixth Floor Plan NSGH Inpatient Wards Data Comms Layout	27/04/12				31/05/12			-						
		Incorporated in Drawing ME-ZK-XX-PL-556-502 Mercury Instruction	MER	K	ME-ZK-07-PL-556-502	Sixth Floor Plan NSGH Inpatient Wards Data Comms Layout	27/04/12				31/05/12			-						
		Incorporated in Drawing ME-ZK-XX-PL-556-501 Mercury Instruction	MER	K	ME-ZK-08-PL-556-501	Eighth Floor Plan NSGH Inpatient Wards Data Comms Layout	27/04/12				31/05/12			-						
		Incorporated in Drawing ME-ZK-XX-PL-556-502 Mercury Instruction	MER	K	ME-ZK-08-PL-556-502	Eighth Floor Plan NSGH Inpatient Wards Data Comms Layout	27/04/12				31/05/12			-						
		Incorporated in Drawing ME-ZK-XX-PL-556-501 Mercury Instruction	MER	K	ME-ZK-09-PL-556-501	Ninth Floor Plan NSGH Inpatient Wards Data Comms Layout	27/04/12				31/05/12			-						
		Incorporated in Drawing ME-ZK-XX-PL-556-502 Mercury Instruction	MER	K	ME-ZK-09-PL-556-502	Ninth Floor Plan NSGH Inpatient Wards Data Comms Layout	27/04/12				31/05/12			-						
		Incorporated in Drawing ME-ZK-XX-PL-556-501 Mercury Instruction	MER	K	ME-ZK-10-PL-556-501	Tenth Floor Plan NSGH Inpatient Wards Data Comms Layout	27/04/12				31/05/12			-						
		Incorporated in Drawing ME-ZK-XX-PL-556-502 Mercury Instruction	MER	K	ME-ZK-10-PL-556-502	Tenth Floor Plan NSGH Inpatient Wards Data Comms Layout	27/04/12				31/05/12			-						
		Incorporated in Drawing ME-ZK-XX-PL-556-501 Mercury Instruction	MER	K	ME-ZK-11-PL-556-501	Eleventh Floor Plan NSGH Inpatient Wards Data Comms Layout	27/04/12				31/05/12			-						
		Incorporated in Drawing ME-ZK-XX-PL-556-502 Mercury Instruction	MER	K	ME-ZK-11-PL-556-502	Eleventh Floor Plan NSGH Inpatient Wards Data Comms Layout	27/04/12				31/05/12									
				MER	K	ME-ZK-B1-PL-556-501	Basement Floor Plan NSGH Core D Data Comms Layout			C			06/06/12	BMCE-TRANSMIT-009245 (BMCE-WTRAN-003217)	27/06/12	06/07/12	A	18/07/12 BMCE-TRANSMIT-009903		
			REMOVED BY MERCURY	MER	K	ME-ZK-XX-PL-556-501	Fifth to Eleventh Floor Plan NSGH Inpatient Wards Data Comms Layout	16/03/12				03/05/12								
			REMOVED BY MERCURY	MER	K	ME-ZK-XX-PL-556-502	Fifth to Eleventh Floor Plan NSGH Inpatient Wards Data Comms Layout	16/03/12				03/05/12								
		Sprinklers		MER	K	ME-ZK-B1-PL-575-308	Basement Floor Void Sprinklers Zone K	24/10/11			B	28/11/11	02/12/11	BMCE-TRANSMIT-006947	23/12/11	09/12/11	B	BMCE-TRANSMIT-007445 27/01/12		
				MER	K	ME-ZK-B1-PL-575-309	Basement Floor Void Sprinklers Zone K	24/10/2011			B	28/11/2011	02/12/2011	BMCE-TRANSMIT-006947	23/12/2011	09/12/2011	B	BMCE-TRANSMIT-007445 27/01/12		
				MER	K	ME-ZK-00-PL-575-308	Ground Floor Void Sprinklers Zone K	24/10/11			B	28/11/11	02/12/11	BMCE-TRANSMIT-006947	23/12/11	09/12/11	B	BMCE-TRANSMIT-007445 27/01/12		
				MER	K	ME-ZK-00-PL-575-309	Ground Floor Ceiling Sprinklers Zone K	24/10/11			B	28/11/11	02/12/11	BMCE-TRANSMIT-006947	23/12/11	09/12/11	B	BMCE-TRANSMIT-007445 27/01/12		
				MER	K	ME-ZK-01-PL-575-308	First Floor Void Sprinklers Zone K	24/10/11			B	28/11/11	02/12/11	BMCE-TRANSMIT-006947	23/12/11	09/12/11	B	BMCE-TRANSMIT-007445 27/01/12		
				MER	K	ME-ZK-01-PL-575-309	First Floor Ceiling Sprinklers Zone K	24/10/11			B	28/11/11	02/12/11	BMCE-TRANSMIT-006947	23/12/11	09/12/11	B	BMCE-TRANSMIT-007445 27/01/12		
			MER	K	ME-ZK-02-PL-575-308	Second Floor Void Sprinklers Zone K	24/10/11			B	28/11/11	02/12/11	BMCE-TRANSMIT-006947	23/12/11	09/12/11	B	BMCE-TRANSMIT-007445 27/01/12			
			MER	K	ME-ZK-02-PL-575-309	Second Floor Ceiling Sprinklers Zone K	24/10/11			B	28/11/11	02/12/11	BMCE-TRANSMIT-006947	23/12/11	09/12/11	B	BMCE-TRANSMIT-007445 27/01/12			

Drawing Information

31 BCL-AC-XX-SH-001

1st Submission2nd Submission

			Action By		Zone	Drawing Number	Drawing Title	Date Required from Consultant	Date Submitted by Consultant	Document Revision	Planned Date to be Submitted to Board	Date Submitted to Board	BMCE Transmittal No	Date Response Required from Board	Date Returned from Board	Board Status	Date returned to Consultant	Date Required from Consultant	Date Submitted by Consultant
Item	Submission	Comments																	
			MER	K	ME-ZK-03-PL-575-308	Third Floor Void Sprinklers Zone K	24/10/11			B	28/11/11	02/12/11	BMCE-TRANSMIT-006947	23/12/11	09/12/11	B	BMCE-TRANSMIT-007445 27/01/12		
			MER	K	ME-ZK-03-PL-575-309	Third Floor Ceiling Sprinklers Zone K	24/10/11			B	28/11/11	02/12/11	BMCE-TRANSMIT-006947	23/12/11	09/12/11	B	BMCE-TRANSMIT-007445 27/01/12		
		Issued for information on BMCE-TRANSMIT-019712 18/03/14	MER	K	ME-ZK-04-PL-575-308	Fourth Floor Void Sprinklers Zone K	27/04/12			B	31/05/12	02/12/11	BMCE-TRANSMIT-006947	23/12/11	09/12/11	B	BMCE-TRANSMIT-007445 27/01/12		
		Issued for information on BMCE-TRANSMIT-019712 18/03/14	MER	K	ME-ZK-04-PL-575-309	Fourth Floor Ceiling Sprinklers Zone K	27/04/12			B	31/05/12	02/12/11	BMCE-TRANSMIT-006947	23/12/11	09/12/11	B	BMCE-TRANSMIT-007445 27/01/12		
		Issued for information on BMCE-TRANSMIT-019712 18/03/14	MER	K	ME-ZK-05-PL-575-308	Fifth Floor Void Sprinklers Zone K	27/04/12			B	31/05/12	02/12/11	BMCE-TRANSMIT-006947	23/12/11	09/12/11	B	BMCE-TRANSMIT-007445 27/01/12		
		Issued for information on BMCE-TRANSMIT-019712 18/03/14	MER	K	ME-ZK-05-PL-575-309	Fifth Floor Ceiling Sprinklers Zone K	27/04/12			B	31/05/12	02/12/11	BMCE-TRANSMIT-006947	23/12/11	09/12/11	B	BMCE-TRANSMIT-007445 27/01/12		
		Issued for information on BMCE-TRANSMIT-019712 18/03/14	MER	K	ME-ZK-06-PL-575-308	Sixth Floor Void Sprinklers Zone K	27/04/12			B	31/05/12	02/12/11	BMCE-TRANSMIT-006947	23/12/11	09/12/11	B	BMCE-TRANSMIT-007445 27/01/12		
		Issued for information on BMCE-TRANSMIT-019712 18/03/14	MER	K	ME-ZK-06-PL-575-309	Sixth Floor Ceiling Sprinklers Zone K	27/04/12			B	31/05/12	02/12/11	BMCE-TRANSMIT-006947	23/12/11	09/12/11	B	BMCE-TRANSMIT-007445 27/01/12		
		Issued for information on BMCE-TRANSMIT-019712 18/03/14	MER	K	ME-ZK-07-PL-575-308	Seventh Floor Void Sprinklers Zone K	27/04/12			B	31/05/12	02/12/11	BMCE-TRANSMIT-006947	23/12/11	09/12/11	B	BMCE-TRANSMIT-007445 27/01/12		
		Issued for information on BMCE-TRANSMIT-019712 18/03/14	MER	K	ME-ZK-07-PL-575-309	Seventh Floor Ceiling Sprinklers Zone K	27/04/12			B	31/05/12	02/12/11	BMCE-TRANSMIT-006947	23/12/11	09/12/11	B	BMCE-TRANSMIT-007445 27/01/12		
		Issued for information on BMCE-TRANSMIT-019712 18/03/14	MER	K	ME-ZK-08-PL-575-308	Eighth Floor Void Sprinklers Zone K	27/04/12			B	31/05/12	02/12/11	BMCE-TRANSMIT-006947	23/12/11	09/12/11	B	BMCE-TRANSMIT-007445 27/01/12		
		Issued for information on BMCE-TRANSMIT-019712 18/03/14	MER	K	ME-ZK-08-PL-575-309	Eighth Floor Ceiling Sprinklers Zone K	27/04/12			B	31/05/12	02/12/11	BMCE-TRANSMIT-006947	23/12/11	09/12/11	B	BMCE-TRANSMIT-007445 27/01/12		
		Issued for information on BMCE-TRANSMIT-019712 18/03/14	MER	K	ME-ZK-09-PL-575-308	Ninth Floor Void Sprinklers Zone K	27/04/12			B	31/05/12	02/12/11	BMCE-TRANSMIT-006947	23/12/11	09/12/11	B	BMCE-TRANSMIT-007445 27/01/12		
		Issued for information on BMCE-TRANSMIT-019712 18/03/14	MER	K	ME-ZK-09-PL-575-309	Ninth Floor Ceiling Sprinklers Zone K	27/04/12			B	31/05/12	02/12/11	BMCE-TRANSMIT-006947	23/12/11	09/12/11	B	BMCE-TRANSMIT-007445 27/01/12		
		Issued for information on BMCE-TRANSMIT-019712 18/03/14	MER	K	ME-ZK-10-PL-575-308	Tenth Floor Void Sprinklers Zone K	27/04/12			B	31/05/12	02/12/11	BMCE-TRANSMIT-006947	23/12/11	09/12/11	B	BMCE-TRANSMIT-007445 27/01/12		
		Issued for information on BMCE-TRANSMIT-019712 18/03/14	MER	K	ME-ZK-10-PL-575-309	Tenth Floor Ceiling Sprinklers Zone K	27/04/12			B	31/05/12	02/12/11	BMCE-TRANSMIT-006947	23/12/11	09/12/11	B	BMCE-TRANSMIT-007445 27/01/12		
		Issued for information on BMCE-TRANSMIT-019712 18/03/14	MER	K	ME-ZK-11-PL-575-308	Eleventh Floor Void Sprinklers Zone K	27/04/12			B	31/05/12	02/12/11	BMCE-TRANSMIT-006947	23/12/11	09/12/11	B	BMCE-TRANSMIT-007445 27/01/12		
		Issued for information on BMCE-TRANSMIT-019712 18/03/14	MER	K	ME-ZK-11-PL-575-309	Eleventh Floor Ceiling Sprinklers Zone K	27/04/12			B	31/05/12	02/12/11	BMCE-TRANSMIT-006947	23/12/11	09/12/11	B	BMCE-TRANSMIT-007445 27/01/12		
		Issued for information on BMCE-TRANSMIT-019712 18/03/14	MER	K	ME-ZK-12-PL-575-308	Twelfth Floor Void Sprinklers Zone K				B		02/12/11	BMCE-TRANSMIT-006947	23/12/11	09/12/11	B	BMCE-TRANSMIT-007445 27/01/12		
		Issued for information on BMCE-TRANSMIT-019712 18/03/14	MER	K	ME-ZK-12-PL-575-309	Twelfth Floor Ceiling Sprinklers Zone K				B		02/12/11	BMCE-TRANSMIT-006947	23/12/11	09/12/11	B	BMCE-TRANSMIT-007445 27/01/12		
	BMS	Removed By Mercury - NOT REQUIRED FOR RDD (PART OF BMS DETAIL DESIGN)	MER	K	ME-ZK-00-PL-660-503	Ground Floor Plan NSGH - Main Entrance & Public Areas BMS Layout	24/10/11				28/11/11			21/01/00					
		Removed By Mercury - NOT REQUIRED FOR RDD (PART OF BMS DETAIL DESIGN)	MER	K	ME-ZK-00-PL-660-504	Ground Floor Plan NSGH - Main Entrance & Public Areas BMS Layout	24/10/11				28/11/11			21/01/00					
		Removed By Mercury - NOT REQUIRED FOR RDD (PART OF BMS DETAIL DESIGN)	MER	K	ME-ZK-00-PL-660-505	Ground Floor Plan NSGH - Main Entrance & Public Areas BMS Layout	24/10/11				28/11/11			21/01/00					
		Removed By Mercury - NOT REQUIRED FOR RDD (PART OF BMS DETAIL DESIGN)	MER	K	ME-ZK-01-PL-660-502	First Floor Plan NSGH Atrium & Restaurant BMS Layout	24/10/11				28/11/11			21/01/00					
		Removed By Mercury - NOT REQUIRED FOR RDD (PART OF BMS DETAIL DESIGN)	MER	K	ME-ZK-01-PL-660-503	First Floor Plan NSGH Main Entrance Sanctuary & Public Core BMS Layout	24/10/11				28/11/11			21/01/00					
		Removed By Mercury - NOT REQUIRED FOR RDD (PART OF BMS DETAIL DESIGN)	MER	K	ME-ZK-01-PL-660-504	First Floor Plan NSGH Atrium BMS Layout	24/10/11				28/11/11			21/01/00					
		Removed By Mercury - NOT REQUIRED FOR RDD (PART OF BMS DETAIL DESIGN)	MER	K	ME-ZK-02-PL-660-501	Second Floor Plan NSGH Public Core A and FM Support BMS Layout	24/10/11				28/11/11			21/01/00					
		Removed By Mercury - NOT REQUIRED FOR RDD (PART OF BMS DETAIL DESIGN)	MER	K	ME-ZK-02-PL-660-502	Second Floor Plan NSGH Bed Core C & FM Support BMS Layout	24/10/11				28/11/11			21/01/00					
		Removed By Mercury - NOT REQUIRED FOR RDD (PART OF BMS DETAIL DESIGN)	MER	K	ME-ZK-02-PL-660-503	Second Floor Plan NSGH Public Core B & Support BMS Layout	24/10/11				28/11/11			21/01/00					
		Removed By Mercury - NOT REQUIRED FOR RDD (PART OF BMS DETAIL DESIGN)	MER	K	ME-ZK-02-PL-660-504	Second Floor Plan NSGH Core D & FM Support BMS Layout	24/10/11				28/11/11			21/01/00					

Drawing Information

31 BCL-AC-XX-SH-001

			Action By		Zone	Drawing Number	Drawing Title	Date Required from Consultant	Date Submitted by Consultant	Document Revision	Planned Date to be Submitted to Board	Date Submitted to Board	BMCE Transmittal No	Date Response Required from Board	Date Returned from Board	Board Status	Date returned to Consultant	Date Required from Consultant	Date Submitted by Consultant
Item	Submission	Comments																	
		Removed By Mercury - NOT REQUIRED FOR RDD (PART OF BMS DETAIL DESIGN)	MER	K	ME-ZK-10-PL-660-501	Tenth Floor Plan NSGH Inpatient Wards BMS Layout								21/01/00					
		Removed By Mercury - NOT REQUIRED FOR RDD (PART OF BMS DETAIL DESIGN)	MER	K	ME-ZK-10-PL-660-502	Tenth Floor Plan NSGH Inpatient Wards BMS Layout								21/01/00					
		Removed By Mercury - NOT REQUIRED FOR RDD (PART OF BMS DETAIL DESIGN)	MER	K	ME-ZK-11-PL-660-501	Eleventh Floor Plan NSGH Inpatient Wards BMS Layout								21/01/00					
		Removed By Mercury - NOT REQUIRED FOR RDD (PART OF BMS DETAIL DESIGN)	MER	K	ME-ZK-11-PL-660-502	Eleventh Floor Plan NSGH Inpatient Wards BMS Layout								21/01/00					
		Removed By Mercury - NOT REQUIRED FOR RDD (PART OF BMS DETAIL DESIGN)	MER	K	ME-ZK-B1-PL-660-501	Basement Floor Plan NSGH Core D BMS Layout								21/01/00					
	Medical Gas	No longer in use - Mercury Instruction	MER	K	ME-ZK-00-PL-H512-001	Medical Gas Installation, Level 0, Zone K			1		29/05/12	BMCE-TRANSMIT-000131- (BMCE-WTRAN-003175)	19/06/12	24/09/12	G	27/09/12 BMCE-TRANSMIT-011199			
		No longer in use - Mercury Instruction	MER	K	ME-ZK-01-PL-H512-001	Medical Gas Installation, Level 1, Zone K			1		29/05/12	BMCE-TRANSMIT-000127- (BMCE-WTRAN-003174)	19/06/12	24/09/12	G	27/09/12 BMCE-TRANSMIT-011196			
		No longer in use - Mercury Instruction	MER	K	ME-ZK-02-PL-H512-001	Medical Gas Installation, Level 2, Zone K			1		29/05/12	BMCE-TRANSMIT-000123- (BMCE-WTRAN-003172)	19/06/12	24/09/12	G	27/09/12 BMCE-TRANSMIT-011202			
		No longer in use - Mercury Instruction	MER	K	ME-ZK-04-PL-H512-001	Medical Gas Installation, Level 4, Zone K			1		29/05/12	BMCE-TRANSMIT-000122- (BMCE-WTRAN-003171)	19/06/12	01/10/12	G	04/10/12 BMCE-TRANSMIT-011224			
		No longer in use - Mercury Instruction	MER	K	ME-ZK-05-PL-H512-001	Medical Gas Installation, Level 5, Zone K			1		29/05/12	BMCE-TRANSMIT-000111- (BMCE-WTRAN-003165)	19/06/12	01/10/12	G	04/10/12 BMCE-TRANSMIT-011301			
		No longer in use - Mercury Instruction	MER	K	ME-ZK-06-PL-H512-001	Medical Gas Installation, Level 6, Zone K			1		29/05/12	BMCE-TRANSMIT-000110- (BMCE-WTRAN-003169)	19/06/12	01/10/12	G	04/10/12 BMCE-TRANSMIT-011325			
		No longer in use - Mercury Instruction	MER	K	ME-ZK-07-PL-H512-001	Medical Gas Installation, Level 7, Zone K			1		29/05/12	BMCE-TRANSMIT-000109- (BMCE-WTRAN-003163)	19/06/12	01/10/12	G	04/10/12 BMCE-TRANSMIT-011325			
		No longer in use - Mercury Instruction	MER	K	ME-ZK-08-PL-H512-001	Medical Gas Installation, Level 8, Zone K			1		29/05/12	BMCE-TRANSMIT-000115- (BMCE-WTRAN-003166)	19/06/12	01/10/12	G	04/10/12 BMCE-TRANSMIT-011322			
		No longer in use - Mercury Instruction	MER	K	ME-ZK-09-PL-H512-001	Medical Gas Installation, Level 9, Zone K			1		29/05/12	BMCE-TRANSMIT-000117- (BMCE-WTRAN-003167)	19/06/12	01/10/12	G	04/10/12 BMCE-TRANSMIT-011322			
		No longer in use - Mercury Instruction	MER	K	ME-ZK-10-PL-H512-001	Medical Gas Installation, Level 10, Zone K			1		29/05/12	BMCE-TRANSMIT-000120- (BMCE-WTRAN-003170)	19/06/12	01/10/12	G	04/10/12 BMCE-TRANSMIT-011323			
		No longer in use - Mercury Instruction	MER	K	ME-ZK-11-PL-H512-001	Medical Gas Installation, Level 11, Zone K			1		29/05/12	BMCE-TRANSMIT-000118- (BMCE-WTRAN-003168)	19/06/12	01/10/12	G	04/10/12 BMCE-TRANSMIT-011327			
			MER	K	ME-ZK-12-PL-H512-001	Medical Gas Installation, Level 12, Zone K			1		29/05/12	BMCE-TRANSMIT-000137- (BMCE-WTRAN-003177)	19/06/12	01/10/12	A	05/10/12 BMCE-TRANSMIT-011384			
	MEDICAL GASES	Removed By Mercury - NOT REQUIRED FOR RDD (REFER TO HPI H512 SERIES DESIGN DRAWINGS)	MER	K	ME-ZK-00-PL-512-503	Ground Floor Plan NSGH -Main Entrance & Public Areas Medical Gases Layout	24/10/11				28/11/11								
		Removed By Mercury - NOT REQUIRED FOR RDD (REFER TO HPI H512 SERIES DESIGN DRAWINGS)	MER	K	ME-ZK-00-PL-512-504	Ground Floor Plan NSGH - Main Entrance & Public Areas Medical Gases Layout	24/10/11				28/11/11			21/01/00					
		Removed By Mercury - NOT REQUIRED FOR RDD (REFER TO HPI H512 SERIES DESIGN DRAWINGS)	MER	K	ME-ZK-00-PL-512-505	Ground Floor Plan NSGH - Main Entrance & Public Areas Medical Gases Layout	24/10/11				28/11/11			21/01/00					
		Removed By Mercury - NOT REQUIRED FOR RDD (REFER TO HPI H512 SERIES DESIGN DRAWINGS)	MER	K	ME-ZK-01-PL-512-502	First Floor Plan NSGH Atrium & Restaurant Medical Gases Layout	24/10/11				28/11/11			21/01/00					
		Removed By Mercury - NOT REQUIRED FOR RDD (REFER TO HPI H512 SERIES DESIGN DRAWINGS)	MER	K	ME-ZK-01-PL-512-503	First Floor Plan NSGH Main Entrance Sanctuary & Public Core Medical Gases Layout	24/10/11				28/11/11			21/01/00					
		Removed By Mercury - NOT REQUIRED FOR RDD (REFER TO HPI H512 SERIES DESIGN DRAWINGS)	MER	K	ME-ZK-01-PL-512-504	First Floor Plan NSGH Atrium Medical Gases Layout	24/10/11				28/11/11			21/01/00					
		Removed By Mercury - NOT REQUIRED FOR RDD (REFER TO HPI H512 SERIES DESIGN DRAWINGS)	MER	K	ME-ZK-02-PL-512-501	Second Floor Plan NSGH Public Core A and FM Support Medical Gases Layout	24/10/11				28/11/11			21/01/00					
		Removed By Mercury - NOT REQUIRED FOR RDD (REFER TO HPI H512 SERIES DESIGN DRAWINGS)	MER	K	ME-ZK-02-PL-512-502	Second Floor Plan NSGH Bed Core C & FM Support Medical Gases Layout	24/10/11				28/11/11			21/01/00					
		Removed By Mercury - NOT REQUIRED FOR RDD (REFER TO HPI H512 SERIES DESIGN DRAWINGS)	MER	K	ME-ZK-02-PL-512-503	Second Floor Plan NSGH Public Core B & Support Medical Gases Layout	24/10/11				28/11/11			21/01/00					
		Removed By Mercury - NOT REQUIRED FOR RDD (REFER TO HPI H512 SERIES DESIGN DRAWINGS)	MER	K	ME-ZK-02-PL-512-504	Second Floor Plan NSGH Core D & FM Support Medical Gases Layout	24/10/11				28/11/11			21/01/00					
		Removed By Mercury - NOT REQUIRED FOR RDD (REFER TO HPI H512 SERIES DESIGN DRAWINGS)	MER	K	ME-ZK-03-PL-512-501	Third Floor Plan NSGH INCH Admin, Training, Health Records & Staff Facilities Medical Gases Layout	24/10/11				28/11/11			21/01/00					
		Removed By Mercury - NOT REQUIRED FOR RDD (REFER TO HPI H512 SERIES DESIGN DRAWINGS)	MER	K	ME-ZK-03-PL-512-503	Third Floor Plan NSGH INCH Staff Change, Hotel Services, Staff Accommodation Medical Gases Layout	24/10/11				28/11/11			21/01/00					

Drawing Information

Sl. No.	BCL-AC-XX-SH-001						1st Submission										2nd Submission			
			Action By	Zone	Drawing Number	Drawing Title	Date Required from Consultant	Date Submitted by Consultant	Document Revision	Planned Date to be Submitted to Board	Date Submitted to Board	BMCE Transmittal No	Date Response Required from Board	Date Returned from Board	Board Status	Date returned to Consultant	Date Required from Consultant	Date Submitted by Consultant		
Item	Submission	Comments																		
		Removed By Mercury - NOT REQUIRED FOR RDD (REFER TO HPI H512 SERIES DESIGN DRAWINGS)	MER	K	ME-ZK-07-PL-512-501	Se-enth Floor Plan NSGH Inpatient Wards Medical Gases Layout							21/01/00							
		Removed By Mercury - NOT REQUIRED FOR RDD (REFER TO HPI H512 SERIES DESIGN DRAWINGS)	MER	K	ME-ZK-07-PL-512-502	Se-enth Floor Plan NSGH Inpatient Wards Medical Gases Layout							21/01/00							
		Removed By Mercury - NOT REQUIRED FOR RDD (REFER TO HPI H512 SERIES DESIGN DRAWINGS)	MER	K	ME-ZK-08-PL-512-501	Eighth Floor Plan NSGH Inpatient Wards Medical Gases Layout							21/01/00							
		Removed By Mercury - NOT REQUIRED FOR RDD (REFER TO HPI H512 SERIES DESIGN DRAWINGS)	MER	K	ME-ZK-08-PL-512-502	Eighth Floor Plan NSGH Inpatient Wards Medical Gases Layout							21/01/00							
		Removed By Mercury - NOT REQUIRED FOR RDD (REFER TO HPI H512 SERIES DESIGN DRAWINGS)	MER	K	ME-ZK-09-PL-512-501	Ninth Floor Plan NSGH Inpatient Wards Medical Gases Layout							21/01/00							
		Removed By Mercury - NOT REQUIRED FOR RDD (REFER TO HPI H512 SERIES DESIGN DRAWINGS)	MER	K	ME-ZK-09-PL-512-502	Ninth Floor Plan NSGH Inpatient Wards Medical Gases Layout							21/01/00							
		Removed By Mercury - NOT REQUIRED FOR RDD (REFER TO HPI H512 SERIES DESIGN DRAWINGS)	MER	K	ME-ZK-10-PL-512-501	Tenth Floor Plan NSGH Inpatient Wards Medical Gases Layout							21/01/00							
		Removed By Mercury - NOT REQUIRED FOR RDD (REFER TO HPI H512 SERIES DESIGN DRAWINGS)	MER	K	ME-ZK-10-PL-512-502	Tenth Floor Plan NSGH Inpatient Wards Medical Gases Layout							21/01/00							
		Removed By Mercury - NOT REQUIRED FOR RDD (REFER TO HPI H512 SERIES DESIGN DRAWINGS)	MER	K	ME-ZK-11-PL-512-501	Ele-enth Floor Plan NSGH Inpatient Wards Medical Gases Layout							21/01/00							
		Removed By Mercury - NOT REQUIRED FOR RDD (REFER TO HPI H512 SERIES DESIGN DRAWINGS)	MER	K	ME-ZK-11-PL-512-502	Eleventh Floor Plan NSGH Inpatient Wards Medical Gases Layout							21/01/00							
		Removed By Mercury - NOT REQUIRED FOR RDD (REFER TO HPI H512 SERIES DESIGN DRAWINGS)	MER	K	ME-ZK-B1-PL-512-501	Basement Floor Plan NSGH Core D Medical Gases Layout							21/01/00							
	Fire Detection & Smoke Control		MER	K	ME-SZ-00-PL-572-501	Ground Floor Plan NSGH - Main Entrance & Public Areas Fire Detection & Smoke Control Layout			B		02/12/11	BMCE-TRANSMIT-006944	23/12/11	22/12/11	C	22/12/11 BMCE-TRANSMIT-007186				
		Issued for information on BMCE-TRANSMIT-018891 18/12/13	MER	K	ME-SZ-00-PL-572-502	Ground Floor Plan NSGH - Main Entrance & Public Areas Fire Detection & Smoke Control Layout			B		02/12/11	BMCE-TRANSMIT-006944	23/12/11	22/12/11	B	22/12/11 BMCE-TRANSMIT-007186				
		Issued for information on BMCE-TRANSMIT-018891 18/12/13	MER	K	ME-ZK-00-PL-572-503	Ground Floor Plan NSGH - Main Entrance & Public Areas Fire Detection & Smoke Control Layout	24/10/11		B	28/11/11	02/12/11	BMCE-TRANSMIT-006944	23/12/11	22/12/11	B	22/12/11 BMCE-TRANSMIT-007186				
		Issued for information on BMCE-TRANSMIT-018891 18/12/13	MER	K	ME-ZK-00-PL-572-504	Ground Floor Plan NSGH - Main Entrance & Public Areas Fire Detection & Smoke Control Layout	24/10/11		B	28/11/11	02/12/11	BMCE-TRANSMIT-006944	23/12/11	22/12/11	B	22/12/11 BMCE-TRANSMIT-007186				
		Issued for information on BMCE-TRANSMIT-018891 18/12/13	MER	K	ME-ZK-00-PL-572-505	Ground Floor Plan NSGH - Main Entrance & Public Areas Fire Detection & Smoke Control Layout	24/10/11		B	28/11/11	02/12/11	BMCE-TRANSMIT-006944	23/12/11	22/12/11	B	22/12/11 BMCE-TRANSMIT-007186				
		Issued for information on BMCE-TRANSMIT-018891 18/12/13	MER	K	ME-SZ-00-PL-572-507	Ground Floor Plan NSGH - Pharmacy & Dispensary Fire Detection & Smoke Control Layout			B		02/12/11	BMCE-TRANSMIT-006944	23/12/11	22/12/11	B	22/12/11 BMCE-TRANSMIT-007186				
		Issued for information on BMCE-TRANSMIT-018891 18/12/13	MER	K	ME-ZK-01-PL-572-502	First Floor Plan NSGH Atrium & Restaurant Fire Detection & Smoke Control Layout	24/10/11		B	28/11/11	02/12/11	BMCE-TRANSMIT-006944	23/12/11	22/12/11	B	22/12/11 BMCE-TRANSMIT-007186				
		Issued for information on BMCE-TRANSMIT-019870 08/04/14	MER	K	ME-SZ-01-PL-572-501	First Floor Plan NSGH Main Entrance Sanctuary & Public Core Fire Detection & Smoke Control Layout			B		02/12/11	BMCE-TRANSMIT-006944	23/12/11	22/12/11	B	22/12/11 BMCE-TRANSMIT-007186				
		Issued for information on BMCE-TRANSMIT-018891 18/12/13	MER	K	ME-ZK-01-PL-572-503	First Floor Plan NSGH Main Entrance Sanctuary & Public Core Fire Detection & Smoke Control Layout	24/10/11		B	28/11/11	02/12/11	BMCE-TRANSMIT-006944	23/12/11	22/12/11	B	22/12/11 BMCE-TRANSMIT-007186				
		Issued for information on BMCE-TRANSMIT-018891 18/12/13	MER	K	ME-ZK-01-PL-572-504	First Floor Plan NSGH Atrium Fire Detection & Smoke Control Layout	24/10/11		B	28/11/11	02/12/11	BMCE-TRANSMIT-006944	23/12/11	22/12/11	B	22/12/11 BMCE-TRANSMIT-007186				
			MER	K	ME-ZK-02-PL-572-501	Second Floor Plan NSGH Pub ic Core A and FM Support Fire Detection & Smoke Control Layout	24/10/11		B	28/11/11	02/12/11	BMCE-TRANSMIT-006944	23/12/11	22/12/11	A	22/12/11 BMCE-TRANSMIT-007186				
		Issued for information on BMCE-TRANSMIT-018891 18/12/13	MER	K	ME-ZK-02-PL-572-502	Second Floor Plan NSGH Bed Core C & FM Support Fire Detection & Smoke Control Layout	24/10/11		B	28/11/11	02/12/11	BMCE-TRANSMIT-006944	23/12/11	22/12/11	B	22/12/11 BMCE-TRANSMIT-007186				
			MER	K	ME-ZK-02-PL-572-503	Second Floor Plan NSGH Public Core B & Support Fire Detection & Smoke Control Layout	24/10/11		B	28/11/11	02/12/11	BMCE-TRANSMIT-006944	23/12/11	22/12/11	A	22/12/11 BMCE-TRANSMIT-007186				
		Issued for information on BMCE-TRANSMIT-018891 18/12/13	MER	K	ME-ZK-02-PL-572-504	Second Floor Plan NSGH Core D & FM Support Fire Detection & Smoke Control Layout	24/10/11		B	28/11/11	02/12/11	BMCE-TRANSMIT-006944	23/12/11	22/12/11	B	22/12/11 BMCE-TRANSMIT-007186				
		Issued for information on BMCE-TRANSMIT-018891 18/12/13	MER	K	ME-ZK-03-PL-572-501	Third Floor Plan NSGH/NCH Admin, Training, Health Records & Staff Facilities Fire Detection & Smoke Control Layout	24/10/11		B	28/11/11	02/12/11	BMCE-TRANSMIT-006944	23/12/11	22/12/11	B	22/12/11 BMCE-TRANSMIT-007186				
		Issued for information on BMCE-TRANSMIT-018891 18/12/13	MER	K	ME-ZK-03-PL-572-503	Third Floor Plan NSGH/NCH Staff Change, Hotel Services, Staff Accommodation Fire Detection & Smoke Control Layout	24/10/11		B	28/11/11	02/12/11	BMCE-TRANSMIT-006944	23/12/11	22/12/11	B	22/12/11 BMCE-TRANSMIT-007186				
		Issued for information on BMCE-TRANSMIT-018891 18/12/13	MER	K	ME-ZK-04-PL-572-501	Fourth Floor Plan NSGH Renal Inpatients & Day Unit Fire Detection & Smoke Control Layout	27/04/12		B	31/05/12	02/12/11	BMCE-TRANSMIT-006944	23/12/11	22/12/11	B	22/12/11 BMCE-TRANSMIT-007186				
		Issued for information on BMCE-TRANSMIT-018891 18/12/13	MER	K	ME-ZK-04-PL-572-502	Fourth Floor Plan NSGH Renal Inpatients & Day Unit Fire Detection & Smoke Control Layout	27/04/12		B	31/05/12	02/12/11	BMCE-TRANSMIT-006944	23/12/11	22/12/11	B	22/12/11 BMCE-TRANSMIT-007186				
		Issued for information on BMCE-TRANSMIT-018891 18/12/13	MER	K	ME-ZK-05-PL-572-501	Fifth Floor Plan NSGH Inpatient Wards Fire Detection & Smoke Control Layout	27/04/12		B	31/05/12	02/12/11	BMCE-TRANSMIT-006944	23/12/11	22/12/11	B	22/12/11 BMCE-TRANSMIT-007186				

			Action By		Zone	Drawing Number	Drawing Title	Date Required from Consultant	Date Submitted by Consultant	Document Revision	Planned Date to be Submitted to Board	Date Submitted to Board	BMCE Transmittal No	Date Response Required from Board	Date Returned from Board	Board Status	Date returned to Consultant	Date Required from Consultant	Date Submitted by Consultant
Item	Submission	Comments																	
		Issued for information on BMCE-TRANSMIT-018891 18/12/13	MER	K	ME-ZK-12-PL-572-502	Twelfth Floor Plan NSGH Plantroom 122				B		02/12/11	BMCE-TRANSMIT-006944	23/12/11	22/12/11	B	22/12/11 BMCE-TRANSMIT-007186		
		Issued for information on BMCE-TRANSMIT-018891 18/12/13	MER	K	ME-ZK-XX-PL-572-501	Sixth to Tenth Floor Plan NSGH Inpatient Wards Fire Detection & Smoke Control Layout				B		02/12/11	BMCE-TRANSMIT-006944	23/12/11	22/12/11	B	22/12/11 BMCE-TRANSMIT-007186		
		Issued for information on BMCE-TRANSMIT-018891 18/12/13	MER	K	ME-ZK-XX-PL-572-502	Sixth to Tenth Floor Plan NSGH Inpatient Wards Fire Detection & Smoke Control Layout				B		02/12/11	BMCE-TRANSMIT-006944	23/12/11	22/12/11	B	22/12/11 BMCE-TRANSMIT-007186		
		Issued for information on BMCE-TRANSMIT-018891 18/12/13	MER	K	ME-ZK-B1-PL-572-501	Basement Floor Plan NSGH Core D Fire Detection & Smoke Control Layout				B		02/12/11	BMCE-TRANSMIT-006944	23/12/11	22/12/11	B	22/12/11 BMCE-TRANSMIT-007186		
		Issued for information on BMCE-TRANSMIT-018891 18/12/13	MER	K	ME-SZ-B1-PL-572-502	Basement Floor Plan AGV Charging & FM Core C Fire Detection Layout				C		07/06/12	BMCE-TRANSMIT-009266 (BMCE-WTRAN-003230)	28/06/12	10/07/12	B	17/07/12 BMCE-TRANSMIT-009876		
	CCTV/Door Access	Issued for information on BMCE-TRANSMIT-018891 18/12/13	MER	K	ME-ZK-B1-PL-571-501	Basement Floor Plan NSGH Basement Food Waste Renal Tanks & FM Core D CCTV & Door Access Layout	24/10/11			C	30/11/11	07/06/12	BMCE-TRANSMIT-009256 (BMCE-WTRAN-003221)	28/06/12	13/07/12	B	19/07/12 BMCE-TRANSMIT-009932		
			MER	K	ME-SZ-B1-PL-571-502	Basement Floor Plan NSGH Basement AVG Charging & FM Core C CCTV & Door Access Layout	24/10/11			C	30/11/11	07/06/12	BMCE-TRANSMIT-009256 (BMCE-WTRAN-003221)	28/06/12	13/07/12	A	19/07/12 BMCE-TRANSMIT-009932		
		This was issued for information on BMCE-TRANSMIT-018726	MER	K	ME-SZ-00-PL-571-501	Ground Floor Plan NSGH Main Entrance & Public Areas CCTV & Door Access Layout	24/10/11				30/11/11	06/12/11	BMCE-TRANSMIT-006943	27/12/11	13/07/12	B	15/08/12 BMCE-TRANSMIT-010325		
		Issued for information on BMCE-TRANSMIT-018891 18/12/13	MER	K	ME-SZ-00-PL-571-502	Ground Floor Plan NSGH Main Entrance & Public Areas CCTV & Door Access Layout	24/10/11				30/11/11	06/12/11	BMCE-TRANSMIT-006943	27/12/11	13/07/12	B	15/08/12 BMCE-TRANSMIT-010325		
			MER	K	ME-ZK-00-PL-571-503	Ground Floor Plan NSGH Main Entrance & Public Areas CCTV & Door Access Layout	24/10/11				30/11/11	06/12/11	BMCE-TRANSMIT-006943	27/12/11	13/07/12	A	15/08/12 BMCE-TRANSMIT-010325		
		Issued for information on BMCE-TRANSMIT-018891 18/12/13	MER	K	ME-ZK-00-PL-571-504	Ground Floor Plan NSGH Main Entrance & Public Areas CCTV & Door Access Layout	24/10/11				30/11/11	06/12/11	BMCE-TRANSMIT-006943	27/12/11	13/07/12	B	15/08/12 BMCE-TRANSMIT-010325		
			MER	K	ME-ZK-00-PL-571-505	Ground Floor Plan NSGH Main Entrance & Public Areas CCTV & Door Access Layout	24/10/11				30/11/11	06/12/11	BMCE-TRANSMIT-006943	27/12/11	13/07/12	A	15/08/12 BMCE-TRANSMIT-010325		
		Issued for information on BMCE-TRANSMIT-018891 18/12/13	MER	K	ME-SZ-01-PL-571-501	First Floor Plan NSGH Level 1 Restaurant , Dining , Servery CCTV & Door Access Layout	24/10/11				30/11/11	06/12/11	BMCE-TRANSMIT-006943	27/12/11	13/07/12	B	15/08/12 BMCE-TRANSMIT-010325		
		Issued for information on BMCE-TRANSMIT-018891 18/12/13	MER	K	ME-ZK-01-PL-571-502	First Floor Plan NSGH Level 1 Restaurant , Dining , Servery CCTV & Door Access Layout	24/10/11				30/11/11	06/12/11	BMCE-TRANSMIT-006943	27/12/11	13/07/12	B	15/08/12 BMCE-TRANSMIT-010325		
		Issued for information on BMCE-TRANSMIT-018891 18/12/13	MER	K	ME-ZK-01-PL-571-503	First Floor Plan NSGH Main Entrance, Sanctuary & Public Core B CCTV & Door Access Layout	24/10/11				30/11/11	06/12/11	BMCE-TRANSMIT-006943	27/12/11	13/07/12	B	15/08/12 BMCE-TRANSMIT-010325		
		Issued for information on BMCE-TRANSMIT-018891 18/12/13	MER	K	ME-ZK-01-PL-571-504	First Floor Plan NSGH Restaurant , FM Core D CCTV & Door Access Layout	24/10/11				30/11/11	06/12/11	BMCE-TRANSMIT-006943	27/12/11	13/07/12	B	15/08/12 BMCE-TRANSMIT-010325		
		Issued for information on BMCE-TRANSMIT-018891 18/12/13	MER	K	ME-ZK-02-PL-571-501	Second Floor Plan NSGH Level 2 Public Core A FM Support and Bed Management CCTV & Door Access layout	24/10/11				30/11/11	06/12/11	BMCE-TRANSMIT-006943	27/12/11	13/07/12	B	15/08/12 BMCE-TRANSMIT-010325		
			MER	K	ME-ZK-02-PL-571-502	Second Floor Plan NSGH Level 2 FM/Bed Core C & FM Support CCTV & Door Access layout	24/10/11				30/11/11	06/12/11	BMCE-TRANSMIT-006943	27/12/11	13/07/12	A	15/08/12 BMCE-TRANSMIT-010325		
			MER	K	ME-ZK-02-PL-571-503	Second Floor Plan NSGH Level 2 Public Core B & Support CCTV & Door Access layout	24/10/11				30/11/11	06/12/11	BMCE-TRANSMIT-006943	27/12/11	13/07/12	A	15/08/12 BMCE-TRANSMIT-010325		
		Issued for information on BMCE-TRANSMIT-018891 18/12/13	MER	K	ME-ZK-03-PL-571-501	Third Floor Plan NSGH/INCH Admin, Training, Health Records & Staff Facilities CCTV & Door Access Layout	24/10/11				30/11/11	06/12/11	BMCE-TRANSMIT-006943	27/12/11	13/07/12	B	15/08/12 BMCE-TRANSMIT-010325		
			MER	K	ME-ZK-03-PL-571-503	Third Floor Plan NSGH/INCH Staff Change/Hotel Services/Staff Accomodation CCTV & Door Access layout	24/10/11				30/11/11	06/12/11	BMCE-TRANSMIT-006943	27/12/11	13/07/12	A	15/08/12 BMCE-TRANSMIT-010325		
			MER	K	ME-ZK-04-PL-571-501	Fourth Floor Plan NSGH Renal Inpatients & Day Unit CCTV/DoorAccess Layout	27/04/12				31/05/12	06/12/11	BMCE-TRANSMIT-006943	27/12/11	13/07/12	A	15/08/12 BMCE-TRANSMIT-010325		
		Issued for information on BMCE-TRANSMIT-018891 18/12/13	MER	K	ME-ZK-04-PL-571-502	Fourth Floor Plan NSGH Renal Inpatients & Day Unit CCTV/DoorAccess Layout	27/04/12				31/05/12	06/12/11	BMCE-TRANSMIT-006943	27/12/11	13/07/12	B	15/08/12 BMCE-TRANSMIT-010325		
			MER	K	ME-ZK-05-PL-571-501	Fifth Floor Plan NSGH Inpatient Ward CCTV & Door Access Layout	27/04/12				31/05/12	06/12/11	BMCE-TRANSMIT-006943	27/12/11	13/07/12	A	15/08/12 BMCE-TRANSMIT-010325		
		Issued for information on BMCE-TRANSMIT-018891 18/12/13	MER	K	ME-ZK-05-PL-571-502	Fifth Floor Plan NSGH Inpatient Ward CCTV & Door Access Layout	27/04/12				31/05/12	06/12/11	BMCE-TRANSMIT-006943	27/12/11	13/07/12	B	15/08/12 BMCE-TRANSMIT-010325		
		Issued for information on BMCE-TRANSMIT-018891 18/12/13	MER	K	ME-ZK-12-PL-571-501	Twelfth Floor Plan NSGH Plantroom CCTV & Door Access Layout						06/12/11	BMCE-TRANSMIT-006943	27/12/11	13/07/12	B	15/08/12 BMCE-TRANSMIT-010325		
		Issued for information on BMCE-TRANSMIT-018891 18/12/13	MER	K	ME-ZK-12-PL-571-502	Twelfth Floor Plan NSGH Plantroom CCTV & Door Access Layout						06/12/11	BMCE-TRANSMIT-006943	27/12/11	13/07/12	B	15/08/12 BMCE-TRANSMIT-010325		
		Issued for information on BMCE-TRANSMIT-018891 18/12/13	MER	K	ME-ZK-XX-PL-571-501	Sixth to Eleventh Floor Plan NSGH Inpatient Wards CCTV & Door Access layout	27/04/12				31/05/12	06/12/11	BMCE-TRANSMIT-006943	27/12/11	13/07/12	B	15/08/12 BMCE-TRANSMIT-010325		
		Issued for information on BMCE-TRANSMIT-018891 18/12/13	MER	K	ME-ZK-XX-PL-571-502	Sixth to Eleventh Floor Plan NSGH Inpatient Wards CCTV & Door Access layout	27/04/12				31/05/12	06/12/11	BMCE-TRANSMIT-006943	27/12/11	13/07/12	B	15/08/12 BMCE-TRANSMIT-010325		

			Action By		Zone	Drawing Number	Drawing Title	Date Required from Consultant	Date Submitted by Consultant	Document Revision	Planned Date to be Submitted to Board	Date Submitted to Board	BMCE Transmittal No	Date Response Required from Board	Date Returned from Board	Board Status	Date returned to Consultant	Date Required from Consultant	Date Submitted by Consultant
Item	Submission	Comments																	
			MER	K	ME-ZK-03-PL-538-501	Third Floor Plan NSGHINCH Admin, Training, Health Records & Staff Facilities Fire Detection & Smoke Control Layout	24/10/11		A	30/11/11	24/03/14	BMCE-TRANSMIT-019750 (BMCE-WTRAN-010133)	14/04/14	22/04/14					
			MER	K	ME-ZK-03-PL-538-503	Third Floor Plan NSGHINCH Staff Change, Hotel Services, Staff Accomodation Fire Detection & Smoke Control Layout	24/10/11		A	30/11/11	01/03/13	BMCE-TRANSMIT-014279 (-BMCE-WTRAN-006293)	22/03/13	12/04/13	A				
	Issued for information on BMCE-TRANSMIT-018891 18/12/13		MER	K	ME-ZK-04-PL-538-501	Fourth Floor Plan NSGH Renal Inpatients & Day Unit Fire Detection & Smoke Control Layout	27/04/12		A	31/05/12	07/06/12	BMCE-TRANSMIT-009251 (BMCE-WTRAN-003220)	28/06/12	12/07/12	B	19/07/12 BMCE-TRANSMIT-009831			
			MER	K	ME-ZK-04-PL-538-502	Fourth Floor Plan NSGH Renal Inpatients & Day Unit Fire Detection & Smoke Control Layout	27/04/12		A	31/05/12	08/06/12	BMCE-TRANSMIT-009251 (BMCE-WTRAN-003220)	29/06/12	12/07/12	A	19/07/12 BMCE-TRANSMIT-009831			
			MER	K	ME-ZK-05-PL-538-501	Fifth Floor Plan NSGH Inpatient Wards Fire Detection & Smoke Control Layout	27/04/12		A	31/05/12	07/06/12	BMCE-TRANSMIT-009251 (BMCE-WTRAN-003220)	28/06/12	12/07/12	A	19/07/12 BMCE-TRANSMIT-009831			
			MER	K	ME-ZK-05-PL-538-502	Fifth Floor Plan NSGH Inpatient Wards Fire Detection & Smoke Control Layout	27/04/12		A	31/05/12	08/06/12	BMCE-TRANSMIT-009251 (BMCE-WTRAN-003220)	29/06/12	12/07/12	A	19/07/12 BMCE-TRANSMIT-009831			
	REMOVED BY MERCURY - ME-ZK-XX-PL-538-501 SUBMITTED FOR RDD REVIEW		MER	K	ME-ZK-11-PL-538-501	Eleventh Floor Plan NSGH Inpatient Wards Fire Detection & Smoke Control Layout	27/04/12			31/05/12									
	REMOVED BY MERCURY - ME-ZK-XX-PL-538-502 SUBMITTED FOR RDD REVIEW		MER	K	ME-ZK-11-PL-538-502	Eleventh Floor Plan NSGH Inpatient Wards Fire Detection & Smoke Control Layout	27/04/12			31/05/12									
	REMOVED BY MERCURY - DRAWING DOES NOT EXIST		MER	K	ME-ZK-12-PL-538-501	Twelfth Floor Plan NSGH Platroom-121													
	REMOVED BY MERCURY - DRAWING DOES NOT EXIST		MER	K	ME-ZK-12-PL-538-502	Twelfth Floor Plan NSGH Platroom-121													
			MER	K	ME-ZK-XX-PL-538-501	Sixth to Tenth Floor Plan NSGH Inpatient Wards Fire Detection & Smoke Control Layout	27/04/12		A	31/05/12	08/06/12	BMCE-TRANSMIT-009251 (BMCE-WTRAN-003220)	29/06/12	12/07/12	A	19/07/12 BMCE-TRANSMIT-009831			
			MER	K	ME-ZK-XX-PL-538-502	Sixth to Tenth Floor Plan NSGH Inpatient Wards Fire Detection & Smoke Control Layout	27/04/12		A	31/05/12	08/06/12	BMCE-TRANSMIT-009251 (BMCE-WTRAN-003220)	29/06/12	12/07/12	A	19/07/12 BMCE-TRANSMIT-009831			
	REMOVED BY MERCURY - DRAWING DOES NOT EXIST		MER	K	ME-ZK-B1-PL-538-501	Basement Floor Plan NSGH Core D Fire Detection & Smoke Control Layout	27/04/12			31/05/12									
	REMOVED BY MERCURY - DRAWING DOES NOT EXIST		MER	K	ME-SZ-B1-PL-538-502	Basement Floor Plan NSGH AGV Charging & FM Core C Fire Detection & Smoke Control Layout	27/04/12			31/05/12									
	Lighting Layout	REMOVED BY MERCURY - DUPLICATE ON SCHEDULE	MER	K	ME-ZK-12-PL-541-501	Twelfth floor plan NSGH Inpatient wards lighting layout													
			MER	K	ME-ZK-12-PL-541-502	Twelfth floor plan NSGH Inpatient wards lighting layout													
	Removed from schedule - drawing has been moved to tab 19 Lighting		MER	K	ME-XX-XX-SP-541-100	Lighting calcs			A		31/01/14	BMCE-TRANSMIT-019243 (BMCE-WTRAN-009845)	21/02/14						
Pneumatic Tube System	REMOVED BY MERCURY - SUPERSEDED BY ME-XX-00-PL-569-001		MER	K	ME-ZK-00-PL-569-001	Ground Floor Plan Pneumatic Tube System	24/10/11			30/11/11									
	REMOVED BY MERCURY - SUPERSEDED BY ME-XX-01-PL-569-002		MER	K	ME-ZK-01-PL-569-002	First Floor plan Pneumatic Tube System	24/10/11			30/11/11									
	REMOVED BY MERCURY - SUPERSEDED BY ME-XX-02-PL-569-003		MER	K	ME-ZK-02-PL-569-003	Second Floor Plan Pneumatic Tube System	24/10/11			30/11/11									
	REMOVED BY MERCURY - SUPERSEDED BY ME-XX-03-PL-569-004		MER	K	ME-ZK-03-PL-569-004	Third Floor Plan Pneumatic Tube System	24/10/11			30/11/11									
	REMOVED BY MERCURY - SUPERSEDED BY ME-XX-04-PL-569-005		MER	K	ME-ZK-04-PL-569-005	Fourth Floor Plan Pneumatic Tube System	27/04/12			31/05/12									
	REMOVED BY MERCURY - SUPERSEDED BY ME-XX-05-PL-569-006		MER	K	ME-ZK-05-PL-569-006	Fifth Floor Plan Pneumatic Tube System	27/04/12			31/05/12									
	REMOVED BY MERCURY - SUPERSEDED BY ME-XX-06-PL-569-007		MER	K	ME-ZK-06-PL-569-007	Sixth Floor Plan Pneumatic Tube System	27/04/12			31/05/12									
	REMOVED BY MERCURY - SUPERSEDED BY ME-XX-07-PL-569-008		MER	K	ME-ZK-07-PL-569-008	Seventh Floor Plan Pneumatic Tube System	27/04/12			31/05/12									
	REMOVED BY MERCURY - SUPERSEDED BY ME-XX-08-PL-569-009		MER	K	ME-ZK-08-PL-569-009	Eighth Floor Plan Pneumatic Tube System	27/04/12			31/05/12									
	REMOVED BY MERCURY - SUPERSEDED BY ME-XX-09-PL-569-010		MER	K	ME-ZK-09-PL-569-010	Ninth Floor Plan Pneumatic Tube System	27/04/12			31/05/12									
	REMOVED BY MERCURY - SUPERSEDED BY ME-XX-10-PL-569-011		MER	K	ME-ZK-10-PL-569-011	Tenth Floor Plan Pneumatic Tube System	27/04/12			31/05/12									
	REMOVED BY MERCURY - SUPERSEDED BY ME-XX-10-PL-569-011		MER	K	ME-ZK-11-PL-569-012	Eleventh Floor Plan Pneumatic Tube System	27/04/12			31/05/12									

Drawing Information

31 BCL-AC-XX-SH-001

1st Submission2nd Submission

			Action By	Zone	Drawing Number	Drawing Title	Date Required from Consultant	Date Submitted by Consultant	Document Revision	Planned Date to be Submitted to Board	Date Submitted to Board	BMCE Transmittal No	Date Response Required from Board	Date Returned from Board	Board Status	Date returned to Consultant	Date Required from Consultant	Date Submitted by Consultant
Item	Submission	Comments																
		Removed by ZBP	ZBP		ZBP-ZBP-XX-PL-520-669	Riser-M32							-					
		Removed by ZBP	ZBP		ZBP-ZBP-XX-PL-520-670	Riser-M34							-					
		Removed by ZBP	ZBP		ZBP-ZBP-XX-PL-520-671	Riser-M39							-					
			ZBP		ZBP-SZ-B1-PL-512-100	Medical Gases Infrastructure strategy Basement		03/05/12	A		18/05/12	BMCE-TRANSMIT-008905 (BMCEOWTRAN-003087)	08/06/12	14/08/12	A	04/09/12 BMCE-TRANSMIT-010745		
		Not to be reviews as replaced by Mercury HPI drawings	ZBP		ZBP-SZ-00-PL-512-101	Medical-Gases-Infrastructure-Strategy-Ground	16/01/12		B		04/05/12	BMCE-TRANSMIT-008680 (BMCE-WTRAN-002991)	25/05/12	28/09/12	G	05/10/12 BMCE-TRANSMIT-011385		
		Not to be reviews as replaced by Mercury HPI drawings	ZBP		ZBP-SZ-01-PL-512-102	Medical-Gases-Infrastructure-Strategy-First	16/01/12		B		04/05/12	BMCE-TRANSMIT-008680 (BMCE-WTRAN-002991)	25/05/12	28/09/12	G	05/10/12 BMCE-TRANSMIT-011385		
		Not to be reviews as replaced by Mercury HPI drawings	ZBP		ZBP-SZ-02-PL-512-103	Medical-Gases-Infrastructure-Strategy-Second	16/01/12		B		04/05/12	BMCE-TRANSMIT-008680 (BMCE-WTRAN-002991)	25/05/12	28/09/12	G	05/10/12 BMCE-TRANSMIT-011385		
		Not to be reviews as replaced by Mercury HPI drawings	ZBP		ZBP-SZ-03-PL-512-104	Medical-Gases-Infrastructure-Strategy-Third	16/01/12		B		04/05/12	BMCE-TRANSMIT-008680 (BMCE-WTRAN-002991)	25/05/12	28/09/12	G	05/10/12 BMCE-TRANSMIT-011385		
		Not to be reviews as replaced by Mercury HPI drawings	ZBP		ZBP-SZ-04-PL-512-105	Medical-Gases-Infrastructure-Strategy-Fourth	16/01/12		B		04/05/12	BMCE-TRANSMIT-008680 (BMCE-WTRAN-002991)	25/05/12	28/09/12	G	05/10/12 BMCE-TRANSMIT-011385		
			ZBP		ZBP-SZ-XX-PL-512-106	Medical Gases Infrastructure Strategy Fifth to Eleventh Floor		03/05/12	A		18/05/12	BMCE-TRANSMIT-008905 (BMCEOWTRAN-003087)	08/06/12	14/08/12	A	04/09/12 BMCE-TRANSMIT-010745		
		Issued for information on BMCE-TRANSMIT-019137 21/01/2014	ZBP		ZBP-SZ-XX-PL-524-350	Smoke Vent Locations Levels 02,04,05,06,12 & 13			A		18/01/13	BMCE-TRANSMIT-013399 (BMCE-WTRAN-005569)	08/02/13	21/01/13	B	28/01/13 BMCE-TRANSMIT-013585		
			ZBP		ZBP-SZ-12-SE-590-002	Plantroom 122 Sections J-J to P-P	22/02/13		A		26/02/13	BMCE-TRANSMIT-014131 (BMCE-WTRAN-006181)	19/03/13	26/03/13	A	03/04/13 BMCE-TRANSMIT-014910		
			ZBP		ZBP-SZ-12-SE-590-003	Plantroom 121,122,123 &124 Sections R-R	22/02/13		A		26/02/13	BMCE-TRANSMIT-014131 (BMCE-WTRAN-006181)	19/03/13	26/03/13	A	03/04/13 BMCE-TRANSMIT-014910		
	DX REFRIGERATION	REMOVED BY MERCURY (NOT DESIGNED BY MERCURY)	MER		ME-XX-B1-PL-525-001	Basement Floor Plan—DX-Refrigeration-Layout Scale 1:300							-					
		REMOVED BY MERCURY (NOT DESIGNED BY MERCURY)	MER		ME-XX-00-PL-525-002	Ground Floor Plan—DX-Refrigeration-Layout Scale 1:300							-					
		REMOVED BY MERCURY (NOT DESIGNED BY MERCURY)	MER		ME-XX-01-PL-525-003	First Floor Plan—DX-Refrigeration-Layout Scale 1:300							-					
		REMOVED BY MERCURY (NOT DESIGNED BY MERCURY)	MER		ME-XX-02-PL-525-004	Second Floor Plan—DX-Refrigeration-Layout Scale 1:300							-					
		REMOVED BY MERCURY (NOT DESIGNED BY MERCURY)	MER		ME-XX-XX-SK-525-001	DX-Refrigeration Room Layouts & Details							-					
	PNEUMATIC TUBE	REMOVED BY MERCURY - DRAWING DOES NOT EXIST	MER		ME-XX-B1-PL-569-001	Basement Level—Pneumatic Tube System Layout							-					
		REMOVED BY MERCURY - Duplicate on RDD	MER		ME-XX-00-PL-569-001	Ground Floor Level—Pneumatic Tube System Layout							-					
		REMOVED BY MERCURY - Duplicate on RDD	MER		ME-XX-01-PL-569-001	First Floor Level—Pneumatic Tube System Layout							-					
		REMOVED BY MERCURY - Duplicate on RDD	MER		ME-XX-02-PL-569-001	Second Floor Level—Pneumatic Tube System Layout							-					
		REMOVED BY MERCURY - Duplicate on RDD	MER		ME-XX-03-PL-569-001	Third Floor Level—Pneumatic Tube System Layout							-					
		REMOVED BY MERCURY - Duplicate on RDD	MER		ME-XX-04-PL-569-001	Fourth Floor Level—Pneumatic Tube System Layout							-					
		REMOVED BY MERCURY - Duplicate on RDD	MER		ME-XX-05-PL-569-001	Fifth Floor Level—Pneumatic Tube System Layout							-					
		REMOVED BY MERCURY - Duplicate on RDD	MER		ME-XX-06-PL-569-001	Sixth Floor Level—Pneumatic Tube System Layout							-					
		REMOVED BY MERCURY - Duplicate on RDD	MER		ME-XX-07-PL-569-001	Seventh Floor Level—Pneumatic Tube System Layout							-					
		REMOVED BY MERCURY - Duplicate on RDD	MER		ME-XX-08-PL-569-001	Eighth Floor Level—Pneumatic Tube System Layout							-					
		REMOVED BY MERCURY - Duplicate on RDD	MER		ME-XX-09-PL-569-001	Ninth Floor Level—Pneumatic Tube System Layout							-					

Drawing Information

31 BCL-AC-XX-SH-001

1st Submission2nd Submission

			Action By	Zone	Drawing Number	Drawing Title	Date Required from Consultant	Date Submitted by Consultant	Document Revision	Planned Date to be Submitted to Board	Date Submitted to Board	BMCE Transmittal No	Date Response Required from Board	Date Returned from Board	Board Status	Date returned to Consultant	Date Required from Consultant	Date Submitted by Consultant
Item	Submission	Comments																
		Removed By Mercury - NOT REQUIRED FOR RDD (REFER TO NA 400 SERIES DRAWINGS FOR DRY RISER DETAILS)	MER		ME-XX-07-PL-575-400	Seventh Floor—Dry Riser Location Details							-					
		Removed By Mercury - NOT REQUIRED FOR RDD (REFER TO NA 400 SERIES DRAWINGS FOR DRY RISER DETAILS)	MER		ME-XX-08-PL-575-400	Eighth Floor—Dry Riser Location Details							-					
		Removed By Mercury - NOT REQUIRED FOR RDD (REFER TO NA 400 SERIES DRAWINGS FOR DRY RISER DETAILS)	MER		ME-XX-09-PL-575-400	Nth Floor—Dry Riser Location Details							-					
		Removed By Mercury - NOT REQUIRED FOR RDD (REFER TO NA 400 SERIES DRAWINGS FOR DRY RISER DETAILS)	MER		ME-XX-10-PL-575-400	Tenth Floor—Dry Riser Location Details							-					
		Removed By Mercury - NOT REQUIRED FOR RDD (REFER TO NA 400 SERIES DRAWINGS FOR DRY RISER DETAILS)	MER		ME-XX-11-PL-575-400	Eleventh Floor—Dry Riser Location Details							-					
		Removed By Mercury - NOT REQUIRED FOR RDD (REFER TO NA 400 SERIES DRAWINGS FOR DRY RISER DETAILS)	MER		ME-XX-12-PL-575-400	Twelfth Floor—Dry Riser Location Details							-					
		Removed By Mercury - NOT REQUIRED FOR RDD (REFER TO NA 400 SERIES DRAWINGS FOR DRY RISER DETAILS)	MER		ME-XX-13-PL-575-400	R Floor—Dry Riser Location Details							-					
		Removed By Mercury - NOT REQUIRED FOR RDD (REFER TO NA 400 SERIES DRAWINGS FOR DRY RISER DETAILS)	MER		ME-XX-B1-PL-575-400	Basement—Dry Riser Location Details							-					
													-					
		Removed By Mercury - NOT REQUIRED FOR RDD (REFER TO NA 400 SERIES DRAWINGS FOR DRY RISER DETAILS)	MER		ME-XX-00-PL-575-450	G Floor—Stair Cores A,B,C,D,F,G—Dry Risers							-					
		Removed By Mercury - NOT REQUIRED FOR RDD (REFER TO NA 400 SERIES DRAWINGS FOR DRY RISER DETAILS)	MER		ME-XX-01-PL-575-450	First Floor Stair Cores A,B,C,D,F,G—Dry Risers							-					
		Removed By Mercury - NOT REQUIRED FOR RDD (REFER TO NA 400 SERIES DRAWINGS FOR DRY RISER DETAILS)	MER		ME-XX-02-PL-575-450	Second Floor Stair Cores A,B,C,D,F,G—Dry Risers							-					
		Removed By Mercury - NOT REQUIRED FOR RDD (REFER TO NA 400 SERIES DRAWINGS FOR DRY RISER DETAILS)	MER		ME-XX-03-PL-575-450	Third Floor Stair Cores A,B,C,D,F,G—Dry Risers							-					
		Removed By Mercury - NOT REQUIRED FOR RDD (REFER TO NA 400 SERIES DRAWINGS FOR DRY RISER DETAILS)	MER		ME-XX-04-PL-575-450	Fth Floor—Stair Cores A,B,C,D,F,G—Dry Risers							-					
		Removed By Mercury - NOT REQUIRED FOR RDD (REFER TO NA 400 SERIES DRAWINGS FOR DRY RISER DETAILS)	MER		ME-XX-05-PL-575-450	Fifth Twelfth Floor Stair Cores A,B,C,D,F,G—Dry Risers							-					
		Removed By Mercury - NOT REQUIRED FOR RDD (REFER TO NA 400 SERIES DRAWINGS FOR DRY RISER DETAILS)	MER		ME-XX-B1-PL-575-450	Basement Stair Cores A,B,C,D,F,G—Dry Risers							-					
			MER		ME-XX-00-PL-570-001	Ground Floor Plan. Anti Ligation Area			A	12/07/12	13/07/12	BMCE-TRANSMIT-009805 (BMCE-WTRAN-003490)	03/08/12	15/08/12	A	27/08/12 BMCE-TRANSMIT-010517		
			MER		ME-XX-01-PL-570-001	First Floor Plan. Anti Ligation Area			A	12/07/12	13/07/12	BMCE-TRANSMIT-009805 (BMCE-WTRAN-003490)	03/08/12	15/08/12	A	27/08/12 BMCE-TRANSMIT-010517		
			MER		ME-XX-02-PL-570-001	Second Floor Plan. Anti Ligation Area			A	12/07/12	13/07/12	BMCE-TRANSMIT-009805 (BMCE-WTRAN-003490)	03/08/12	15/08/12	A	27/08/12 BMCE-TRANSMIT-010517		
			MER		ME-XX-03-PL-570-001	Third Floor Plan. Anti Ligation Area			A	12/07/12	13/07/12	BMCE-TRANSMIT-009805 (BMCE-WTRAN-003490)	03/08/12	15/08/12	A	27/08/12 BMCE-TRANSMIT-010517		
		Issued for information on BMCE-TRANSMIT-019816 31/03/14	MER		ME-XX-04-PL-570-001	Fourth Floor Plan. Anti Ligation Area			A	12/07/12	13/07/12	BMCE-TRANSMIT-009805 (BMCE-WTRAN-003490)	03/08/12	15/08/12	B	27/08/12 BMCE-TRANSMIT-010517		
		Mercury Instructed to remove as This was issued for information (Part of Outline Design, Refer to Current Sprinkler Drawings)	MER		ME-WS-00-PL-575-001	Site Plan							-					
		Mercury Instructed to remove as This was issued for information (Part of Outline Design, Refer to Current Sprinkler Drawings)	MER		ME-WS-XX-SC-575-001	Automatic Sprinkler Protection Schematic							-					
		Mercury Instructed to remove as This was issued for information (Part of Outline Design, Refer to Current Sprinkler Drawings)	MER		ME-WS-XX-SC-575-002	Dry Riser & Water Foam—Schematic							-					
		Mercury Instructed to remove as This was issued for information (Part of Outline Design, Refer to Current Sprinkler Drawings)	MER		ME-WS-XX-SC-575-003	Gas Suppression System—Schematic							-					
		(TO BE SHOWN ON THE SCHEDULE FOR COMPLETENESS PART OF OUTLINE DESIGN FOR BOARD (TO BE SHOWN ON THE SCHEDULE FOR COMPLETENESS	MER		ME-XX-00-PL-575-100	Ground Floor Sprinkler—Block Plan & Risers							-					
		(TO BE SHOWN ON THE SCHEDULE FOR COMPLETENESS PART OF OUTLINE DESIGN FOR BOARD (TO BE SHOWN ON THE SCHEDULE FOR COMPLETENESS	MER		ME-XX-01-PL-575-101	First Floor Sprinkler—Block Plan & Risers							-					
		(TO BE SHOWN ON THE SCHEDULE FOR COMPLETENESS PART OF OUTLINE DESIGN FOR BOARD (TO BE SHOWN ON THE SCHEDULE FOR COMPLETENESS	MER		ME-XX-02-PL-575-102	Second Floor Sprinkler—Block Plan & Risers							-					

Drawing Information

31 BCL-AC-XX-SH-001

1st Submission2nd Submission

			Action By	Zone	Drawing Number	Drawing Title	Date Required from Consultant	Date Submitted by Consultant	Document Revision	Planned Date to be Submitted to Board	Date Submitted to Board	BMCE Transmittal No	Date Response Required from Board	Date Returned from Board	Board Status	Date returned to Consultant	Date Required from Consultant	Date Submitted by Consultant
Item	Submission	Comments																
		(TO BE SHOWN ON THE SCHEDULE FOR COMPLETENESS PART OF OUTLINE DESIGN FOR BOARD (TO BE SHOWN ON THE SCHEDULE FOR COMPLETENESS PART OF OUTLINE DESIGN FOR BOARD	MER		ME-XX-13-PL-575-113	Roof Level Sprinkler Block Plan & Risers							-					
		(TO BE SHOWN ON THE SCHEDULE FOR COMPLETENESS PART OF OUTLINE DESIGN FOR BOARD	MER		ME-XX-01-PL-575-120	Basement Sprinkler Block Plan & Risers							-					
										07/02/12								
IT HUBS AND COMP ROOMS		(TO BE SHOWN ON THE SCHEDULE FOR COMPLETENESS PART OF OUTLINE DESIGN FOR BOARD (TO BE SHOWN ON THE SCHEDULE FOR COMPLETENESS PART OF OUTLINE DESIGN FOR BOARD	MER		ME-XX-00-PL-575-200	Ground Floor Sprinkler System Exclusions							-					
		(TO BE SHOWN ON THE SCHEDULE FOR COMPLETENESS PART OF OUTLINE DESIGN FOR BOARD	MER		ME-XX-01-PL-575-201	First Floor Sprinkler System Exclusions							-					
		(TO BE SHOWN ON THE SCHEDULE FOR COMPLETENESS PART OF OUTLINE DESIGN FOR BOARD	MER		ME-XX-02-PL-575-202	Second Floor Sprinkler System Exclusions							-					
		(TO BE SHOWN ON THE SCHEDULE FOR COMPLETENESS PART OF OUTLINE DESIGN FOR BOARD	MER		ME-XX-03-PL-575-203	Third Floor Sprinkler System Exclusions							-					
		(TO BE SHOWN ON THE SCHEDULE FOR COMPLETENESS PART OF OUTLINE DESIGN FOR BOARD	MER		ME-XX-04-PL-575-204	Fourth Floor Sprinkler System Exclusions							-					
		(TO BE SHOWN ON THE SCHEDULE FOR COMPLETENESS PART OF OUTLINE DESIGN FOR BOARD	MER		ME-XX-05-PL-575-205	Fifth Floor Sprinkler System Exclusions							-					
		(TO BE SHOWN ON THE SCHEDULE FOR COMPLETENESS PART OF OUTLINE DESIGN FOR BOARD	MER		ME-XX-06-PL-575-206	Sixth Floor Sprinkler System Exclusions							-					
		(TO BE SHOWN ON THE SCHEDULE FOR COMPLETENESS PART OF OUTLINE DESIGN FOR BOARD	MER		ME-XX-07-PL-575-207	Seventh Floor Sprinkler System Exclusions							-					
		(TO BE SHOWN ON THE SCHEDULE FOR COMPLETENESS PART OF OUTLINE DESIGN FOR BOARD	MER		ME-XX-08-PL-575-208	Eighth Floor Sprinkler System Exclusions							-					
		(TO BE SHOWN ON THE SCHEDULE FOR COMPLETENESS PART OF OUTLINE DESIGN FOR BOARD	MER		ME-XX-09-PL-575-209	Ninth Floor Sprinkler System Exclusions							-					
		(TO BE SHOWN ON THE SCHEDULE FOR COMPLETENESS PART OF OUTLINE DESIGN FOR BOARD	MER		ME-XX-10-PL-575-210	Tenth Floor Sprinkler System Exclusions							-					
		(TO BE SHOWN ON THE SCHEDULE FOR COMPLETENESS PART OF OUTLINE DESIGN FOR BOARD	MER		ME-XX-11-PL-575-211	Eleventh Floor Sprinkler System Exclusions							-					
		(TO BE SHOWN ON THE SCHEDULE FOR COMPLETENESS PART OF OUTLINE DESIGN FOR BOARD	MER		ME-XX-12-PL-575-212	Twelfth Floor Sprinkler System Exclusions							-					
		(TO BE SHOWN ON THE SCHEDULE FOR COMPLETENESS PART OF OUTLINE DESIGN FOR BOARD	MER		ME-XX-13-PL-575-213	Roof Level Sprinkler System Exclusions							-					
		(TO BE SHOWN ON THE SCHEDULE FOR COMPLETENESS PART OF OUTLINE DESIGN FOR BOARD	MER		ME-XX-01-PL-575-220	Basement Sprinkler System Exclusions							-					
IT HUBS ROOM			MER		ME-XX-00-PL-556-001	Ground Floor Plan IT Hub RM 103			A		24/08/12	BMCE-TRANSMIT-010504 (BMCE-WTRAN-003824)	14/09/12	17/10/12	C	23/10/12 BMCE-TRANSMIT-011790		
		Issued for information on BMCE-TRANSMIT-019288 04/02/14	MER		ME-XX-00-PL-556-002	Ground Floor Plan IT Hub RM 104			A		24/08/12	BMCE-TRANSMIT-010504 (BMCE-WTRAN-003824)	14/09/12	17/10/12	C	23/10/12 BMCE-TRANSMIT-011790		
		Issued for information on BMCE-TRANSMIT-019288 04/02/14	MER		ME-XX-00-PL-556-003	Ground Floor Plan IT Hub RM 105			A		24/08/12	BMCE-TRANSMIT-010504 (BMCE-WTRAN-003824)	14/09/12	17/10/12	B	23/10/12 BMCE-TRANSMIT-011790		
			MER		ME-XX-00-PL-556-004	Ground Floor Plan IT Hub RM 106			A		24/08/12	BMCE-TRANSMIT-010504 (BMCE-WTRAN-003824)	14/09/12	17/10/12	B	23/10/12 BMCE-TRANSMIT-011790		
			MER		ME-XX-00-PL-556-005	Ground Floor Plan IT Hub RM 107			A		24/08/12	BMCE-TRANSMIT-010504 (BMCE-WTRAN-003824)	14/09/12	17/10/12	B	23/10/12 BMCE-TRANSMIT-011790		
			MER		ME-XX-00-PL-556-006	Ground Floor Plan IT Hub RM 108			A		24/08/12	BMCE-TRANSMIT-010504 (BMCE-WTRAN-003824)	14/09/12	17/10/12	A	23/10/12 BMCE-TRANSMIT-011790		
			MER		ME-XX-00-PL-556-007	Ground Floor Plan IT Hub RM 109			A		24/08/12	BMCE-TRANSMIT-010504 (BMCE-WTRAN-003824)	14/09/12	17/10/12	A	23/10/12 BMCE-TRANSMIT-011790		
		Issued for information on BMCE-TRANSMIT-019288 04/02/14	MER		ME-XX-00-PL-556-008	Ground Floor Plan IT Hub RM 110			A		24/08/12	BMCE-TRANSMIT-010504 (BMCE-WTRAN-003824)	14/09/12	17/10/12	B	23/10/12 BMCE-TRANSMIT-011790		
			MER		ME-XX-00-PL-556-009	Ground Floor Plan IT Hub RM 111			A		24/08/12	BMCE-TRANSMIT-010504 (BMCE-WTRAN-003824)	14/09/12	17/10/12	B	23/10/12 BMCE-TRANSMIT-011790		
			MER		ME-XX-00-PL-556-010	Ground Floor Plan IT Hub RM 112			A		24/08/12	BMCE-TRANSMIT-010504 (BMCE-WTRAN-003824)	14/09/12	17/10/12	B	23/10/12 BMCE-TRANSMIT-011790		
			MER		ME-XX-01-PL-556-001	First Floor plan IT Hub RM 113			A		24/08/12	BMCE-TRANSMIT-010504 (BMCE-WTRAN-003824)	14/09/12	17/10/12	B	23/10/12 BMCE-TRANSMIT-011790		
			MER		ME-XX-01-PL-556-002	First Floor plan IT Hub RM 114			A		24/08/12	BMCE-TRANSMIT-010504 (BMCE-WTRAN-003824)	14/09/12	17/10/12	B	23/10/12 BMCE-TRANSMIT-011790		

Drawing Information

31 BCL-AC-XX-SH-001

1st Submission2nd Submission

			Action By	Zone	Drawing Number	Drawing Title	Date Required from Consultant	Date Submitted by Consultant	Document Revision	Planned Date to be Submitted to Board	Date Submitted to Board	BMCE Transmittal No	Date Response Required from Board	Date Returned from Board	Board Status	Date returned to Consultant	Date Required from Consultant	Date Submitted by Consultant
Item	Submission	Comments																
			MER		ME-XX-02-PL-556-006	Second Floor Plan IT Hub RM 129			A		24/08/12	BMCE-TRANSMIT-010504 (BMCE-WTRAN-003824)	14/09/12	17/10/12	A	23/10/12 BMCE-TRANSMIT-011790		
			MER		ME-XX-02-PL-556-007	Second Floor Plan IT Hub RM 130			A		24/08/12	BMCE-TRANSMIT-010504 (BMCE-WTRAN-003824)	14/09/12	17/10/12	A	23/10/12 BMCE-TRANSMIT-011790		
		Issued for informaton on BMCE-TRANSMIT-019288 04/02/14	MER		ME-XX-02-PL-556-008	Second Floor Plan IT Hub RM 131			A		24/08/12	BMCE-TRANSMIT-010504 (BMCE-WTRAN-003824)	14/09/12	17/10/12	C	23/10/12 BMCE-TRANSMIT-011790		
			MER		ME-XX-03-PL-556-001	Third Floor Plan IT Hub RM 132			A		24/08/12	BMCE-TRANSMIT-010504 (BMCE-WTRAN-003824)	14/09/12	17/10/12	C	23/10/12 BMCE-TRANSMIT-011790		
			MER		ME-XX-03-PL-556-002	Third Floor Plan IT Hub RM 133			A		24/08/12	BMCE-TRANSMIT-010504 (BMCE-WTRAN-003824)	14/09/12	17/10/12	C	23/10/12 BMCE-TRANSMIT-011790		
			MER		ME-XX-03-PL-556-003	Third Floor Plan IT Hub RM 134			A		24/08/12	BMCE-TRANSMIT-010504 (BMCE-WTRAN-003824)	14/09/12	17/10/12	A	23/10/12 BMCE-TRANSMIT-011790		
			MER		ME-XX-03-PL-556-004	Third Floor Plan IT Hub RM 135			A		24/08/12	BMCE-TRANSMIT-010504 (BMCE-WTRAN-003824)	14/09/12	17/10/12	A	23/10/12 BMCE-TRANSMIT-011790		
			MER		ME-XX-04-PL-556-001	Fourth Floor Plan IT Hub RM 136			A		24/08/12	BMCE-TRANSMIT-010504 (BMCE-WTRAN-003824)	14/09/12	17/10/12	B	23/10/12 BMCE-TRANSMIT-011790		
			MER		ME-XX-04-PL-556-002	Fourth Floor Plan IT Hub RM 137			A		24/08/12	BMCE-TRANSMIT-010504 (BMCE-WTRAN-003824)	14/09/12	17/10/12	C	23/10/12 BMCE-TRANSMIT-011790		
			MER		ME-XX-04-PL-556-003	Fourth Floor Plan IT Hub RM 138			A		24/08/12	BMCE-TRANSMIT-010504 (BMCE-WTRAN-003824)	14/09/12	17/10/12	A	23/10/12 BMCE-TRANSMIT-011790		
			MER		ME-XX-04-PL-556-004	Fourth Floor Plan IT Hub RM 139			A		24/08/12	BMCE-TRANSMIT-010504 (BMCE-WTRAN-003824)	14/09/12	17/10/12	A	23/10/12 BMCE-TRANSMIT-011790		
			MER		ME-XX-04-PL-556-005	Fourth Floor Plan IT Hub RM 140			A		24/08/12	BMCE-TRANSMIT-010504 (BMCE-WTRAN-003824)	14/09/12	17/10/12	A	23/10/12 BMCE-TRANSMIT-011790		
			MER		ME-XX-04-PL-556-006	Fourth Floor Plan IT Hub RM 141			A		24/08/12	BMCE-TRANSMIT-010504 (BMCE-WTRAN-003824)	14/09/12	17/10/12	A	23/10/12 BMCE-TRANSMIT-011790		
			MER		ME-XX-05-PL-556-001	Fifth Floor Plan IT Hub RM 142			A		24/08/12	BMCE-TRANSMIT-010504 (BMCE-WTRAN-003824)	14/09/12	17/10/12	B	23/10/12 BMCE-TRANSMIT-011790		
			MER		ME-XX-05-PL-556-002	Fifth Floor Plan IT Hub RM 143			A		24/08/12	BMCE-TRANSMIT-010504 (BMCE-WTRAN-003824)	14/09/12	17/10/12	A	23/10/12 BMCE-TRANSMIT-011790		
			MER		ME-XX-05-PL-556-003	Fifth Floor Plan IT Hub RM 144			A		24/08/12	BMCE-TRANSMIT-010504 (BMCE-WTRAN-003824)	14/09/12	17/10/12	A	23/10/12 BMCE-TRANSMIT-011790		
			MER		ME-XX-05-PL-556-004	Fifth Floor Plan IT Hub RM 145			A		24/08/12	BMCE-TRANSMIT-010504 (BMCE-WTRAN-003824)	14/09/12	17/10/12	A	23/10/12 BMCE-TRANSMIT-011790		
			MER		ME-XX-06-PL-556-001	Sixth Floor Plan IT Hub RM 146			A		24/08/12	BMCE-TRANSMIT-010504 (BMCE-WTRAN-003824)	14/09/12	17/10/12	B	23/10/12 BMCE-TRANSMIT-011790		
			MER		ME-XX-06-PL-556-002	Sixth Floor Plan IT Hub RM 147			A		24/08/12	BMCE-TRANSMIT-010504 (BMCE-WTRAN-003824)	14/09/12	17/10/12	B	23/10/12 BMCE-TRANSMIT-011790		
			MER		ME-XX-06-PL-556-003	Sixth Floor Plan IT Hub RM 148			A		24/08/12	BMCE-TRANSMIT-010504 (BMCE-WTRAN-003824)	14/09/12	17/10/12	A	23/10/12 BMCE-TRANSMIT-011790		
			MER		ME-XX-06-PL-556-004	Sixth Floor Plan IT Hub RM 149			A		24/08/12	BMCE-TRANSMIT-010504 (BMCE-WTRAN-003824)	14/09/12	17/10/12	A	23/10/12 BMCE-TRANSMIT-011790		
			MER		ME-XX-07-PL-556-001	Seventh Floor Plan IT Hub RM 150			A		24/08/12	BMCE-TRANSMIT-010504 (BMCE-WTRAN-003824)	14/09/12	17/10/12	B	23/10/12 BMCE-TRANSMIT-011790		
			MER		ME-XX-07-PL-556-002	Seventh Floor Plan IT Hub RM 151			A		24/08/12	BMCE-TRANSMIT-010504 (BMCE-WTRAN-003824)	14/09/12	17/10/12	B	23/10/12 BMCE-TRANSMIT-011790		
			MER		ME-XX-07-PL-556-003	Seventh Floor Plan IT Hub RM 152			A		24/08/12	BMCE-TRANSMIT-010504 (BMCE-WTRAN-003824)	14/09/12	17/10/12	A	23/10/12 BMCE-TRANSMIT-011790		
			MER		ME-XX-07-PL-556-004	Seventh Floor Plan IT Hub RM 153			A		24/08/12	BMCE-TRANSMIT-010504 (BMCE-WTRAN-003824)	14/09/12	17/10/12	A	23/10/12 BMCE-TRANSMIT-011790		
			MER		ME-XX-08-PL-556-001	Eighth Floor Plan IT Hub RM 154			A		24/08/12	BMCE-TRANSMIT-010504 (BMCE-WTRAN-003824)	14/09/12	17/10/12	B	23/10/12 BMCE-TRANSMIT-011790		
			MER		ME-XX-08-PL-556-002	Eighth Floor Plan IT Hub RM 155			A		24/08/12	BMCE-TRANSMIT-010504 (BMCE-WTRAN-003824)	14/09/12	17/10/12	B	23/10/12 BMCE-TRANSMIT-011790		
			MER		ME-XX-08-PL-556-003	Eighth Floor Plan IT Hub RM 156			A		24/08/12	BMCE-TRANSMIT-010504 (BMCE-WTRAN-003824)	14/09/12	17/10/12	A	23/10/12 BMCE-TRANSMIT-011790		
			MER		ME-XX-08-PL-556-004	Eighth Floor Plan IT Hub RM 157			A		24/08/12	BMCE-TRANSMIT-010504 (BMCE-WTRAN-003824)	14/09/12	17/10/12	A	23/10/12 BMCE-TRANSMIT-011790		
			MER		ME-XX-09-PL-556-001	Ninth Floor Plan IT Hub RM 158			A		24/08/12	BMCE-TRANSMIT-010504 (BMCE-WTRAN-003824)	14/09/12	17/10/12	B	23/10/12 BMCE-TRANSMIT-011790		
			MER		ME-XX-09-PL-556-002	Ninth Floor Plan IT Hub RM 159			A		24/08/12	BMCE-TRANSMIT-010504 (BMCE-WTRAN-003824)	14/09/12	17/10/12	A	23/10/12 BMCE-TRANSMIT-011790		

Drawing Information

31		BCL-AC-XX-SH-001		1st Submission															2nd Submission		
			Action By	Zone	Drawing Number	Drawing Title	Date Required from Consultant	Date Submitted by Consultant	Document Revision	Planned Date to be Submitted to Board	Date Submitted to Board	BMCE Transmittal No	Date Response Required from Board	Date Returned from Board	Board Status	Date returned to Consultant	Date Required from Consultant	Date Submitted by Consultant			
Item	Submission	Comments																			
		This was not required for RDD Review - Will be issued to board for information only	MER		ME-SZ-SL-DC-H512-002	Se-eral-Le-els, L3, GW1 to Riser-M38 & G/F-ring-main			A		14/08/13	BMCE-TRANSMIT-017263- (BMCE-WTRAN-008566)	04/09/13	16/10/13	D	18/10/13 BMCE-TRANSMIT-018131					
		This was not required for RDD Review - Will be issued to board for information only	MER		ME-SZ-SL-DC-H512-003	Se-eral-Le-els, L4 Childrens Phys-unit to Riser-M32 & G/Floor-Ring-main			A		14/08/13	BMCE-TRANSMIT-017263- (BMCE-WTRAN-008566)	04/09/13	16/10/13	D	18/10/13 BMCE-TRANSMIT-018131					
		This was not required for RDD Review - Will be issued to board for information only	MER		ME-SZ-SL-DC-H512-004	Several Levels, Level 11, Ward B then Ward A to Riser-M25 & G/Floor-Ring-main			A		14/08/13	BMCE-TRANSMIT-017263- (BMCE-WTRAN-008566)	04/09/13	16/10/13	D	18/10/13 BMCE-TRANSMIT-018131					
		This was not required for RDD Review - Will be issued to board for information only	MER		ME-SZ-DC-PL-H512-005	Se-eral-Le-els, Le-el 11, Ward D then Ward C to Riser-M25A & G/Floor-Ring-Main			A		14/08/13	BMCE-TRANSMIT-017263- (BMCE-WTRAN-008566)	04/09/13	16/10/13	D	18/10/13 BMCE-TRANSMIT-018131					
		This was not required for RDD Review - Will be issued to board for information only	MER		ME-SZ-DC-PL-H512-005	Se-eral-Le-els, Le-el 11, Ward D then Ward C to Riser-M25A & G/Floor-Ring-Main			A		14/08/13	BMCE-TRANSMIT-017263- (BMCE-WTRAN-008566)	04/09/13	16/10/13	D	18/10/13 BMCE-TRANSMIT-018131					
		This was not required for RDD Review - Will be issued to board for information only	MER		ME-SZ-SL-DC-H512-006	Several Levels, L2, Medical Physices to Riser-M38 & G/Floor Mains			A		14/08/13	BMCE-TRANSMIT-017263- (BMCE-WTRAN-008566)	04/09/13	16/10/13	D	18/10/13 BMCE-TRANSMIT-018131					
		This was not required for RDD Review - Will be issued to board for information only	MER		ME-SZ-SL-DC-H512-007	Se-eral-Le-els, Child theatres & mains to Riser-M32 & G/F mains			A		14/08/13	BMCE-TRANSMIT-017263- (BMCE-WTRAN-008566)	04/09/13	16/10/13	D	18/10/13 BMCE-TRANSMIT-018131					
		This was not required for RDD Review - Will be issued to board for information only	MER		ME-SZ-SL-DC-H512-008	Se-eral-Le-els, Nitrous Oxide mains from Le-el 2 Theatres to Riser-M25A & G/F to Source			A		14/08/13	BMCE-TRANSMIT-017263- (BMCE-WTRAN-008566)	04/09/13	16/10/13	D	18/10/13 BMCE-TRANSMIT-018131					
		This was not required for RDD Review - Will be issued to board for information only	MER		ME-SZ-SL-DC-H512-009	Se-eral-Le-els, Enterex Mains from L1 CCW-025 to Riser-M11, G/Floor & Source			A		14/08/13	BMCE-TRANSMIT-017263- (BMCE-WTRAN-008566)	04/09/13	16/10/13	D	18/10/13 BMCE-TRANSMIT-018131					
		This was not required for RDD Review - Will be issued to board for information only	MER		ME-SZ-SL-PL-H512-010	Several Levels, Heliox Mains from L1 CCW-088 to Riser-M38, G/Floor & Source			A		14/08/13	BMCE-TRANSMIT-017263- (BMCE-WTRAN-008566)	04/09/13	16/10/13	D	18/10/13 BMCE-TRANSMIT-018131					
		This was not required for RDD Review - Will be issued to board for information only	MER		ME-SZ-SL-PL-H512-010	Se-eral-Le-els, Heliox Mains from L1 CCW-088 to Riser-M38, G/Floor & Source			A		14/08/13	BMCE-TRANSMIT-017263- (BMCE-WTRAN-008566)	04/09/13	16/10/13	D	18/10/13 BMCE-TRANSMIT-018131					
		This was not required for RDD Review - Will be issued to board for information only	MER		ME-SZ-SL-DC-H512-011	Se-eral-Le-els, Heliox Mains from CCW-025 To Riser-M11 & G/Floor mains			A		14/08/13	BMCE-TRANSMIT-017263- (BMCE-WTRAN-008566)	04/09/13	16/10/13	D	18/10/13 BMCE-TRANSMIT-018131					
		This was not required for RDD Review - Will be issued to board for information only	MER		ME-SZ-SL-DC-H512-012	Several Levels, MA4 Childrens Ring-Main			A		14/08/13	BMCE-TRANSMIT-017263- (BMCE-WTRAN-008566)	04/09/13	16/10/13	D	18/10/13 BMCE-TRANSMIT-018131					
		This was not required for RDD Review - Will be issued to board for information only	MER		ME-SZ-SL-DC-H512-013	Se-eral-Le-els, MA4 Adult-Ring-Main			A		14/08/13	BMCE-TRANSMIT-017263- (BMCE-WTRAN-008566)	04/09/13	16/10/13	D	18/10/13 BMCE-TRANSMIT-018131					
		This was not required for RDD Review - Will be issued to board for information only	MER		ME-SZ-SL-DC-H512-014	Se-eral-Le-els, MA4, L4 Haematology to L2 Ring-main			A		14/08/13	BMCE-TRANSMIT-017263- (BMCE-WTRAN-008566)	04/09/13	16/10/13	D	18/10/13 BMCE-TRANSMIT-018131					
		This was not required for RDD Review - Will be issued to board for information only	MER		ME-SZ-SL-DC-H512-015	Se-eral-Le-els, SA7 Childrens Ring-Main			A		14/08/13	BMCE-TRANSMIT-017263- (BMCE-WTRAN-008566)	04/09/13	16/10/13	D	18/10/13 BMCE-TRANSMIT-018131					
		This was not required for RDD Review - Will be issued to board for information only	MER		ME-SZ-SL-DC-H512-016	Several Levels, SA7 Adult-Ring-Main			A		14/08/13	BMCE-TRANSMIT-017263- (BMCE-WTRAN-008566)	04/09/13	16/10/13	D	18/10/13 BMCE-TRANSMIT-018131					
		This was not required for RDD Review - Will be issued to board for information only	MER		ME-SZ-SL-DC-H512-017	Se-eral-Le-els, Vacuum Mains from Childrens EMC G/Floor to Riser-M38 & Plant room			A		14/08/13	BMCE-TRANSMIT-017263- (BMCE-WTRAN-008566)	04/09/13	16/10/13	D	18/10/13 BMCE-TRANSMIT-018131					
		This was not required for RDD Review - Will be issued to board for information only	MER		ME-SZ-SL-DC-H512-018	Se-eral-Le-els, Vacuum Mains from G/Floor RCG-064 to Riser-M32 & Plant room			A		14/08/13	BMCE-TRANSMIT-017263- (BMCE-WTRAN-008566)	04/09/13	16/10/13	D	18/10/13 BMCE-TRANSMIT-018131					
		This was not required for RDD Review - Will be issued to board for information only	MER		ME-SZ-SL-DC-H512-019	Se-eral-Le-els, Vacuum Mains from Adults EMC Resus, Major-Treatment rooms & mains to riser-M11 & L3 Plant Room			A		14/08/13	BMCE-TRANSMIT-017263- (BMCE-WTRAN-008566)	04/09/13	16/10/13	D	18/10/13 BMCE-TRANSMIT-018131					
		This was not required for RDD Review - Will be issued to board for information only	MER		ME-SZ-SL-DC-H512-020	Several Levels, Vacuum Mains from G/Floor-ORT & Mains to Riser-M25A & L3 Plant Room			A		14/08/13	BMCE-TRANSMIT-017263- (BMCE-WTRAN-008566)	04/09/13	16/10/13	D	18/10/13 BMCE-TRANSMIT-018131					
		This was not required for RDD Review - Will be issued to board for information only	MER		ME-SZ-SL-DC-H512-021	Se-eral-Le-els, Vacuum from L4 RENW-154 to Riser-T5, Le-el 11 to Riser-T12 & L12 Plant Room			A		14/08/13	BMCE-TRANSMIT-017263- (BMCE-WTRAN-008566)	04/09/13	16/10/13	D	18/10/13 BMCE-TRANSMIT-018131					
		This was not required for RDD Review - Will be issued to board for information only	MER		ME-SZ-SL-DC-H512-022	Se-eral-Le-els, Vacuum from L4 RENW-093 to Riser-T12 to Le-el 12 plant Room			A		14/08/13	BMCE-TRANSMIT-017263- (BMCE-WTRAN-008566)	04/09/13	16/10/13	D	18/10/13 BMCE-TRANSMIT-018131					
		This was not required for RDD Review - Will be issued to board for information only	MER		ME-SZ-SL-DC-H512-023	Several Levels, CO2 Mains from L2 THE-202 & mains to Riser-M25A & Source							21/01/00								
		This was not required for RDD Review - Will be issued to board for information only	MER		ME-SZ-SL-DC-H512-024	Several Levels, AGSS from G/Floor-OPD Dental to Riser-M38 & Level 4 Plant Room							21/01/00								
		This was not required for RDD Review - Will be issued to board for information only	MER		ME-SZ-SL-DC-H512-025	Se-eral-Le-els, AGSS from G/Floor-OPD Lung Lab to Riser-M32 & Le-el 4 Plant Room							21/01/00								
		This was not required for RDD Review - Will be issued to board for information only	MER		ME-SZ-SL-DC-H512-026	Se-eral-Le-els, AGSS from G/Floor RCG Radiology to Riser-M32 & Level 4 Plant Room							21/01/00								
		This was not required for RDD Review - Will be issued to board for information only	MER		ME-SZ-SL-DC-H512-027	Several Levels, AGSS from G/Floor-EMCC to Riser-M38 & Level 4 Plant Room							21/01/00								
		This was not required for RDD Review - Will be issued to board for information only	MER		ME-SZ-SL-DC-H512-028	Se-eral-Le-els, AGSS from G/Floor-RAG Radiology to Riser-M11 & Le-el 3 Plant Room							21/01/00								
		This was not required for RDD Review - Will be issued to board for information only	MER		ME-SZ-SL-DC-H512-029	Se-eral-Le-els, AGSS from G/Floor-EMCA to Riser-M11 & Le-el 3 Plant Room							21/01/00								
		This was not required for RDD Review - Will be issued to board for information only	MER		ME-SZ-SL-DC-H512-030	Se-eral-Le-els, AGSS from L1 CCW-088 (Childrens 12 bed) to Riser-M38 & L4 Plant Room							21/01/00								

Drawing Information

31 BCL-AC-XX-SH-001

1st Submission2nd Submission

			Action By	Zone	Drawing Number	Drawing Title	Date Required from Consultant	Date Submitted by Consultant	Document Revision	Planned Date to be Submitted to Board	Date Submitted to Board	BMCE Transmittal No	Date Response Required from Board	Date Returned from Board	Board Status	Date returned to Consultant	Date Required from Consultant	Date Submitted by Consultant
Item	Submission	Comments																
		This was not required for RDD Review - Will be issued to board for information only	MER		ME-SZ-02-DC-H512-002	Le-el 2, Post-Op Recovery (THE-243) to Theatre mains							21/01/00					
		This was not required for RDD Review - Will be issued to board for information only	MER		ME-SZ-02-DC-H512-003	Le-el 2, C/Exam rooms from THE-250 to Theatre mains							21/01/00					
		This was not required for RDD Review - Will be issued to board for information only	MER		ME-XX-00-DC-H512-001	Oxygen Ring Main			A		14/09/13	BMCE-TRANSMIT-017262 (BMCE-WTRAN-008566)	04/09/13	16/10/13	D	20/10/13 BMCE-TRANSMIT-018131		
		This was not required for RDD Review - Will be issued to board for information only	MER		ME-XX-XX-SC-H512-001	Medical Gas Installation, Oxygen Schematic							21/01/00					
		This was not required for RDD Review - Will be issued to board for information only	MER		ME-XX-XX-SC-H512-002	Medical Gas Installation, Nitrous Oxide Schematic							21/01/00					
		This was not required for RDD Review - Will be issued to board for information only	MER		ME-XX-XX-SC-H512-003	Medical Gas Installation, Entonox Schematic							21/01/00					
		This was not required for RDD Review - Will be issued to board for information only	MER		ME-XX-XX-SC-H512-004	Medical Gas Installation, Heliox Schematic							21/01/00					
		This was not required for RDD Review - Will be issued to board for information only	MER		ME-XX-XX-SC-H512-005	Medical Gas Installation, MA4 Schematic Childrens Hospital							21/01/00					
		This was not required for RDD Review - Will be issued to board for information only	MER		ME-XX-XX-SC-H512-006	Medical Gas Installation, MA4 Schematic Adult Hospital							21/01/00					
		This was not required for RDD Review - Will be issued to board for information only	MER		ME-XX-XX-SC-H512-007	Medical Gas Installation, SA7 Schematic Childrens Hospital							21/01/00					
		This was not required for RDD Review - Will be issued to board for information only	MER		ME-XX-XX-SC-H512-008	Medical Gas Installation, SA7 Schematic Adult Hospital							21/01/00					
		This was not required for RDD Review - Will be issued to board for information only	MER		ME-XX-XX-SC-H512-009	Medical Gas Installation, Vacuum Schematic Childrens Hospital							21/01/00					
		This was not required for RDD Review - Will be issued to board for information only	MER		ME-XX-XX-SC-H512-010	Medical Gas Installation, Vacuum Schematic Adult Hospital							21/01/00					
		This was not required for RDD Review - Will be issued to board for information only	MER		ME-XX-XX-SC-H512-011	Medical Gas Installation, Vacuum Schematic Tower Block							21/01/00					
		Superseded by ME-EW-XX-PL-H512-002	MER		ME-EW-XX-PL-H512-001	Medical gas Installation, Ground Floor, External To Main Hospital Building			1		29/05/12	BMCE-TRANSMIT-009110 (BMCE-WTRAN-003164)	19/06/12	01/10/12	C	04/10/12 BMCE-TRANSMIT-011320		
			MER		ME-EW-XX-PL-H512-002	Medical Gas installation Oxygen to maternity V.I.E			1		31/03/14	BMCE-TRANSMIT-019820 (BMCE-WTRAN-010164)	21/04/14	22/04/14	B			
			MER		ME-SZ-B1-PL-H512-001	Medical Gas Installaions Basement			1		31/03/14	BMCE-TRANSMIT-019820 (BMCE-WTRAN-010164)	21/04/14	22/04/14	B			
			MER		ME-SZ-SL-PL-H512-001	Several levels medical gas installations			1		31/03/14	BMCE-TRANSMIT-019820 (BMCE-WTRAN-010164)	21/04/14	22/04/14	B			
	ENERGY CENTRE		ZBP	EC	ZBP-EC-XX-SH-500-001	MEP Hazard Control Sheet - Energy Centre			A	26/10/12	05/11/12	BMCE-TRANSMIT-011897 (BMCE-WTRAN-004359)	26/11/12	07/12/12	B	19/12/12 BMCE-TRANSMIT-012984		
	Mechanical Services		ZBP	EC	ZBP-EC-00-PL-521-001	Energy Centre Ground Floor Mechanical Services Sheet 1 of 2			D		24/04/12	BMCE-TRANSMIT-008453 (BMCE-WTRAN-002881)	15/05/12	22/06/12	A	05/07/12 BMCE-TRANSMIT-009693		
			ZBP	EC	ZBP-EC-00-PL-521-002	Energy Centre Ground Floor Mechanical Services Sheet 2 of 2			C		24/04/12	BMCE-TRANSMIT-008453 (BMCE-WTRAN-002881)	15/05/12	22/06/12	A	05/07/12 BMCE-TRANSMIT-009693		
			ZBP	EC	ZBP-EC-01-PL-521-011	Energy Centre First Floor Mechanical Services Sheet 1 of 2			A		24/04/12	BMCE-TRANSMIT-008453 (BMCE-WTRAN-002881)	15/05/12	22/06/12	A	05/07/12 BMCE-TRANSMIT-009693		
			ZBP	EC	ZBP-EC-01-PL-521-012	Energy Centre First Floor Mechanical Services Sheet 2 of 2			A		24/04/12	BMCE-TRANSMIT-008453 (BMCE-WTRAN-002881)	15/05/12	22/06/12	A	05/07/12 BMCE-TRANSMIT-009693		
			ZBP	EC	ZBP-EC-02-PL-521-021	Energy Centre Second Floor Mechanical Services Sheet 1 of 2			C		24/04/12	BMCE-TRANSMIT-008453 (BMCE-WTRAN-002881)	15/05/12	22/06/12	A	05/07/12 BMCE-TRANSMIT-009693		
			ZBP	EC	ZBP-EC-02-PL-521-022	Energy Centre Second Floor Mechanical Services Sheet 2 of 2			C		24/04/12	BMCE-TRANSMIT-008453 (BMCE-WTRAN-002881)	15/05/12	22/06/12	A	05/07/12 BMCE-TRANSMIT-009693		
			ZBP	EC	ZBP-EC-03-PL-521-031	Energy CentreRoof Level Mechanical Services Sheet 1 of 2			C		24/04/12	BMCE-TRANSMIT-008453 (BMCE-WTRAN-002881)	15/05/12	22/06/12	A	05/07/12 BMCE-TRANSMIT-009693		
			ZBP	EC	ZBP-EC-03-PL-521-032	Energy Centre Roof Level Mechanical Services Sheet 2 of 2			C		24/04/12	BMCE-TRANSMIT-008453 (BMCE-WTRAN-002881)	15/05/12	22/06/12	A	05/07/12 BMCE-TRANSMIT-009693		
		Removed by ZBP 14.12.12	ZBP	EC	ZBP-EC-03-PL-521-103	Energy Centre Sections												
		Issued for information on BMCE-TRANSMIT-019782 27/03/14	ZBP	EC	ZBP-EC-XX-SC-513-001	Fuel Oil Schematic			E		07/12/12	BMCE-TRANSMIT-012819 (BMCE-WTRAN-005091)	03/01/13	03/01/13	B	16/01/13 BMCE-TRANSMIT-013354		
		Issued for information on BMCE-TRANSMIT-019719 19/03/14	ZBP	EC	ZBP-EC-XX-SC-513-002	Natural Gas Schematic EC and NSGH			F		16/05/12	BMCE-TRANSMIT-008882 (BMCE-WTRAN-003077)	06/06/12	10/09/12	B	21/09/12 BMCE-TRANSMIT-		

Drawing Information

31 BCL-AC-XX-SH-001

			Action By		Zone	Drawing Number	Drawing Title	Date Required from Consultant	Date Submitted by Consultant	Document Revision	Planned Date to be Submitted to Board	Date Submitted to Board	BMCE Transmittal No	Date Response Required from Board	Date Returned from Board	Board Status	Date returned to Consultant	Date Required from Consultant	Date Submitted by Consultant
Item	Submission	Comments																	
		Issued for information on BMCE-TRANSMIT-019782 27/03/14	ZBP	EC	ZBP-EC-01-PL-532-012	Energy Centre First Floor Electrical Services Sheet 2 of 2				C		24/04/12	BMCE-TRANSMIT-008493 (BMCE-WTRAN-002899)	15/05/12	11/05/12	B	24/05/12 BMCE-TRANSMIT-009054		
		Issued for information on BMCE-TRANSMIT-019782 27/03/14	ZBP	EC	ZBP-EC-02-PL-532-021	Energy Centre Second Floor Electrical Services Sheet 1 of 2				C		24/04/12	BMCE-TRANSMIT-008493 (BMCE-WTRAN-002899)	15/05/12	11/05/12	B	24/05/12 BMCE-TRANSMIT-009054		
		Issued for information on BMCE-TRANSMIT-019782 27/03/14	ZBP	EC	ZBP-EC-02-PL-532-022	Energy Centre Second Floor Electrical Services Sheet 2 of 2				C		24/04/12	BMCE-TRANSMIT-008493 (BMCE-WTRAN-002899)	15/05/12	11/05/12	B	24/05/12 BMCE-TRANSMIT-009054		
			ZBP	EC	ZBP-EC-03-PL-532-031	Energy CentreRoof Level Electrical Services Sheet 1 of 2				C		24/04/12	BMCE-TRANSMIT-008493 (BMCE-WTRAN-002899)	15/05/12	11/05/12	A	24/05/12 BMCE-TRANSMIT-009054		
			ZBP	EC	ZBP-EC-03-PL-532-032	Energy Centre Roof Level Electrical Services Sheet 2 of 2				C		24/04/12	BMCE-TRANSMIT-008493 (BMCE-WTRAN-002899)	15/05/12	11/05/12	A	24/05/12 BMCE-TRANSMIT-009054		
			ZBP	EC	ZBP-EC-XX-SC-532-103	Energy Centre Schematic Sub-station A				D		24/04/12	BMCE-TRANSMIT-008523 (BMCE-WTRAN-2946)	15/05/12	11/05/12	A	24/05/12 BMCE-TRANSMIT-009050		
			ZBP	EC	ZBP-EC-XX-SC-532-104	Energy Centre Schematic Sub-station B				D		24/04/12	BMCE-TRANSMIT-008523 (BMCE-WTRAN-2946)	15/05/12	11/05/12	A	24/05/12 BMCE-TRANSMIT-009050		
			ZBP	EC	ZBP-EC-XX-SC-532-105	Energy Centre MV Earthing schematic				A		24/04/12	BMCE-TRANSMIT-008523 (BMCE-WTRAN-2946)	15/05/12	11/05/12	A	24/05/12 BMCE-TRANSMIT-009050		
			ZBP	EC	ZBP-EC-XX-SC-532-106	Energy Centre LV Earthing schematic				A		24/04/12	BMCE-TRANSMIT-008523 (BMCE-WTRAN-2946)	15/05/12	11/05/12	A	24/05/12 BMCE-TRANSMIT-009050		
		Issued for information on BMCE-TRANSMIT-019782 27/03/14	ZBP	EC	ZBP-XX-00-SC-755-001	Site Wide 11kV Schematic				D	11/07/12	12/07/12	BMCE-TRANSMIT-009797 (BMCE-WTRAN-003483)	02/08/12	07/08/12	B	20/08/12 BMCE-TRANSMIT-010380		
			ZBP	EC	ZBP-EC-XX-SH-600-224	Cable Schedule Substation 4				B		09/07/12	BMCE-TRANSMIT-009724 (BMCE-WTRAN-003450)	30/07/12	12/07/12	A	19/07/12 BMCE-TRANSMIT-009930		
			ZBP	EC	ZBP-EC-XX-SH-600-234					B		09/07/12	BMCE-TRANSMIT-009724 (BMCE-WTRAN-003450)	30/07/12	12/07/12	A	19/07/12 BMCE-TRANSMIT-009930		
			ZBP	EC	ZBP-EC-XX-SH-600-281	Energy Centre LV Cable Schedules				C		31/05/12	BMCE-TRANSMIT-009170 (BMCE-WTRAN-003194)	21/06/12	02/08/12	A	20/08/12 BMCE-TRANSMIT-010384		
			ZBP	EC	ZBP-EC-XX-SH-600-282	Energy Centre Protective Device Settings Schedules				B		31/05/12	BMCE-TRANSMIT-009170 (BMCE-WTRAN-003194)	21/06/12	02/08/12	A	20/08/12 BMCE-TRANSMIT-010384		
			ZBP	EC	ZBP-EC-XX-SH-600-283	Energy Centre Distribution Board Schedule				B		18/05/12	BMCE-TRANSMIT-008909 (BMCE-WTRAN-003091)	08/06/12	02/08/12	B	20/08/12 BMCE-TRANSMIT-010385		
			ZBP	EC	ZBP-XX-XX-SH-600-221	LV Cable Schedule Substation 1				A		06/08/12	BMCE-TRANSMIT-010033 (BMCE-WTRAN-003609)	27/08/12		B	03/09/12 BMCE-TRANSMIT-010675		
			ZBP		ZBP-XX-XX-SH-600-224	Substation 4 cable schedules				C		05/12/12	BMCE-TRANSMIT-012644 (BMCE-WTRAN-004963)	26/12/12	11/12/12	A	07/01/13 BMCE-TRANSMIT-013168		
			ZBP		ZBP-XX-XX-SH-600-226	Substation 6 cable schedules				C		05/12/12	BMCE-TRANSMIT-012644 (BMCE-WTRAN-004963)	26/12/12	11/12/12	A	07/01/13 BMCE-TRANSMIT-013168		
			ZBP	EC	ZBP-XX-XX-SH-600-231	Protective Device Setting Schedule Sub - Staion 1				A		06/08/12	BMCE-TRANSMIT-010033 (BMCE-WTRAN-003609)	27/08/12		B	03/09/12 BMCE-TRANSMIT-010675		
			ZBP	EC	ZBP-XX-XX-SH-600-324	Schedules of Equipment - Extract Fans				B		31/05/12	BMCE-TRANSMIT-009174 (BMCE-WTRAN0003198)	21/06/12	19/07/12	A	28/07/12 BMCE-TRANSMIT-010039 07/08/12		
			ZBP	EC	ZBP-XX-XX-SH-600-326	HWS Storgae & HWS Circulation Pumps				C		09/07/12	BMCE-TRANSMIT-009731 (BMCE-WTRAN-003458)	30/07/12	03/08/12	B	20/08/12 BMCE-TRANSMIT-010382		
			ZBP	EC	ZBP-XX-XX-SH-600-332	VAV Terminal Units				A		09/07/12	BMCE-TRANSMIT-009726 (BMCE-WTRAN-003452)	30/07/12	03/08/12	A	20/08/12 BMCE-TRANSMIT-010383		
			ZBP		ZBP-XX-XX-SH-600-234	Substation 4 protective device settings schedules				C		05/12/12	BMCE-TRANSMIT-012644 (BMCE-WTRAN-004963)	26/12/12	11/12/12	A	07/01/13 BMCE-TRANSMIT-013168		
			ZBP		ZBP-XX-XX-SH-600-241	Substaion 1 Distribution Board Schedules				A		04/12/12	BMCE-TRANSMIT-012645 (BMCE-WTRAN-004964)	25/12/12	11/12/12	B	19/12/12 BMCE-TRANSMIT-012886		
			ZBP		ZBP-XX-XX-SH-600-244	Substaion 4 Distribution Board Schedules				A		04/12/12	BMCE-TRANSMIT-012645 (BMCE-WTRAN-004964)	25/12/12	11/12/12	B	19/12/12 BMCE-TRANSMIT-012886		
			ZBP		ZBP-XX-XX-SH-600-246	Substation 6 Distribution Board Schedules				B		05/12/12	BMCE-TRANSMIT0012644 (BMCE-WTRAN-004963)	26/12/12	11/12/12	B	07/01/13 BMCE-TRANSMIT-013168		
			ZBP	EC	ZBP-EC-XX-SH-600-363	Energy Centre Plate Heat Exchangers Servicing Labs				A	12/11/12	13/11/12	BMCE-TRANSMIT-012269 (BMCE-WTRAN-004568)	04/12/12	07/12/12	A	19/12/12 BMCE-TRANSMIT-012885		
			ZBP	EC	ZBP-XX-XX-SH-600-366	Schedules of Equipment - Water Tanks Cisterns				A		09/07/12	BMCE-TRANSMIT-009730 (BMCE-WTRAN-003456)	30/07/12	03/08/12	A	20/08/12 BMCE-TRANSMIT-010386		
			ZBP	EC	ZBP-XX-XX-SH-600-367	Schedules of Equipment - Domestic Water Booster Pumps				A		09/07/12	BMCE-TRANSMIT-009730 (BMCE-WTRAN-003456)	30/07/12	03/08/12	A	20/08/12 BMCE-TRANSMIT-010386		
			ZBP		ZBP-XX-XX-SH-600-370	Shedules of electric heaters				A		25/02/14	BMCE-TRANSMIT-019509 (BMCE-WTRAN-009980)	18/03/14	03/03/14	B			

Drawing Information

31

BCL-AC-XX-SH-001

1st Submission

2nd Submission

Item	Submission	Comments	Action By Zone		Drawing Number	Drawing Title	Date Required from Consultant	Date Submitted by Consultant	Document Revision	Planned Date to be Submitted to Board	Date Submitted to Board	BMCE Transmittal No	Date Response Required from Board	Date Returned from Board	Board Status	Date returned to Consultant	Date Required from Consultant	Date Submitted by Consultant
			MER	EC	ME-EC-03-PL-541-001	Roof Plan. NSGH Energy Centre. Lighting Layout			B		25/05/12	BMCE-TRANSMIT-009080 (BMCE-WTRAN-003148)	15/06/12	12/07/12	B	16/07/12 BMCE-TRANSMIT-009864		
			MER	EC	ME-EC-03-PL-571-001	Roof plan NSGH Energy centre CCTV & Door access			B		25/05/12	BMCE-TRANSMIT-009080 (BMCE-WTRAN-003148)	15/06/12	12/07/12	B	16/07/12 BMCE-TRANSMIT-009864		
			MER	EC	ME-EC-03-PL-572-001	Roof plan NSGH Energy centre Fire detection layout			A		25/05/12	BMCE-TRANSMIT-009080 (BMCE-WTRAN-003148)	15/06/12	12/07/12	C	16/07/12 BMCE-TRANSMIT-009864		
		REMOVED BY MERCURY	MER	EC	ME-EC-00-PL-556-001	Ground Floor Plan. NSGH Energy Centre. Data Outlets												
		REMOVED BY MERCURY	MER	EC	ME-EC-00-PL-556-002	First Floor Plan. NSGH Energy Centre. Data Outlets												
		REMOVED BY MERCURY	MER	EC	ME-EC-00-PL-556-003	Second Floor Plan. NSGH Energy Centre. Data Outlets												
		REMOVED BY MERCURY	MER	EC	ME-EC-00-PL-556-004	Roof Plan. NSGH Energy Centre. Data Outlets												
			ZBP		ZBP-AB-XX-PL-591-001	Combined services VIE building ground & 1st floor			A		07/02/14	BMCE-TRANSMIT-019340	28/02/14	17/02/14	B	18/02/14 BMCE-TRANSMIT-019451		
EXTERNAL SITE SERVICES		Removed by ZBP	ZBP	EW	ZBP-EW-XX-PL-591-001	New Services Site Plan Sheet 1 of 13												
			ZBP	EW	ZBP-EW-XX-PL-591-002	New Services Site Plan Sheet 2 of 13			B		05/06/13	BMCE-TRANSMIT-016119 (BMCE-WTRAN-007793)	26/06/13	10/07/13	A	BMCE-TRANSMIT-016829		
			ZBP	EW	ZBP-EW-XX-PL-591-003	New Services Site Plan Sheet 3 of 13			B		05/06/13	BMCE-TRANSMIT-016119 (BMCE-WTRAN-007793)	26/06/13	10/07/13	A	BMCE-TRANSMIT-016829		
			ZBP	EW	ZBP-EW-XX-PL-591-004	New Services Site Plan Sheet 4 of 13			B		05/06/13	BMCE-TRANSMIT-016119 (BMCE-WTRAN-007793)	26/06/13	10/07/13	A	BMCE-TRANSMIT-016829		
			ZBP	EW	ZBP-EW-XX-PL-591-005	New Services Site Plan Sheet 5 of 13			B		05/06/13	BMCE-TRANSMIT-016119 (BMCE-WTRAN-007793)	26/06/13	10/07/13	A	BMCE-TRANSMIT-016829		
			ZBP	EW	ZBP-EW-XX-PL-591-006	New Services Site Plan Sheet 6 of 13			C		05/06/13	BMCE-TRANSMIT-016119 (BMCE-WTRAN-007793)	26/06/13	10/07/13	A	BMCE-TRANSMIT-016829		
			ZBP	EW	ZBP-EW-XX-PL-591-007	New Services Site Plan Sheet 7 of 13			B		05/06/13	BMCE-TRANSMIT-016119 (BMCE-WTRAN-007793)	26/06/13	10/07/13	A	BMCE-TRANSMIT-016829		
			ZBP	EW	ZBP-EW-XX-PL-591-008	New Services Site Plan Sheet 8 of 13			B		05/06/13	BMCE-TRANSMIT-016119 (BMCE-WTRAN-007793)	26/06/13	10/07/13	A	BMCE-TRANSMIT-016829		
			ZBP	EW	ZBP-EW-XX-PL-591-009	New Services Site Plan Sheet 8 of 13			B		05/06/13	BMCE-TRANSMIT-016119 (BMCE-WTRAN-007793)	26/06/13	10/07/13	A	BMCE-TRANSMIT-016829		
		Removed by ZBP	ZBP	EW	ZBP-EW-XX-PL-591-010	New Services Site Plan Sheet 9 of 13												
			ZBP	EW	ZBP-EW-XX-PL-591-011	New Services Site Plan Sheet 10 of 13			B		05/06/13	BMCE-TRANSMIT-016119 (BMCE-WTRAN-007793)	26/06/13	10/07/13	A	BMCE-TRANSMIT-016829		
			ZBP	EW	ZBP-EW-XX-PL-591-012	New Services Site Plan Sheet 11 of 13			B		05/06/13	BMCE-TRANSMIT-016119 (BMCE-WTRAN-007793)	26/06/13	10/07/13	A	BMCE-TRANSMIT-016829		
			ZBP	EW	ZBP-EW-XX-PL-591-013	New Services Site Plan Sheet 12 of 13			B		05/06/13	BMCE-TRANSMIT-016119 (BMCE-WTRAN-007793)	26/06/13	10/07/13	A	BMCE-TRANSMIT-016829		
			ZBP	EW	ZBP-EW-XX-PL-591-014	New Services Site Plan Sheet 13 of 13			B		05/06/13	BMCE-TRANSMIT-016119 (BMCE-WTRAN-007793)	26/06/13	10/07/13	A	BMCE-TRANSMIT-016829		
			ZBP	EW	ZBP-EW-XX-PL-512-001	MEDICAL GASES BETWEEN GASES STORE A & C			A		19/06/13	BMCE-TRANSMIT-016359 (BMCE-WTRAN-007930)	10/07/13	27/06/13	B	17/07/13 BMCE-TRANSMIT-016824		
3RD SUBMISSION TO BOARD			ZBP	EW	ZBP-EW-XX-PL-512-001	MEDICAL GASES BETWEEN GASES STORE A & C			E		07/02/14	BMCE-TRANSMIT-019340	28/02/14	17/02/14	B	18/02/14 BMCE-TRANSMIT-019451		
Extent of Dimming			ZBP		ZBP-XX-00-SK-541-001	Extent of Dimming Ground Floor			A		09/07/12	BMCE-TRANSMIT-009718 (BMCE-WTRAN-003449) drawing to be resubmitted as	30/07/12	20/08/12	A	04/09/12 BMCE-TRANSMIT-010748		
			ZBP		ZBP-XX-01-SK-541-001	Extent of Dimming First Floor			A		09/07/12	BMCE-TRANSMIT-009718 (BMCE-WTRAN-003449) drawing to be resubmitted as	30/07/12	20/08/12	A	04/09/12 BMCE-TRANSMIT-010748		
			ZBP		ZBP-XX-02-SK-541-001	Extent of Dimming Second Floor			A		09/07/12	BMCE-TRANSMIT-009718 (BMCE-WTRAN-003449) drawing to be resubmitted as	30/07/12	20/08/12	A	04/09/12 BMCE-TRANSMIT-010748		
			ZBP		ZBP-XX-03-SK-541-001	Extent of Dimming Third Floor			A		09/07/12	BMCE-TRANSMIT-009718 (BMCE-WTRAN-003449)	30/07/12	20/08/12	A	04/09/12 BMCE-TRANSMIT-010748		

Drawing Information

31 BCL-AC-XX-SH-001

			Action By		Zone	Drawing Number	Drawing Title	Date Required from Consultant	Date Submitted by Consultant	Document Revision	Planned Date to be Submitted to Board	Date Submitted to Board	BMCE Transmittal No	Date Response Required from Board	Date Returned from Board	Board Status	Date returned to Consultant	Date Required from Consultant	Date Submitted by Consultant
Item	Submission	Comments																	
			MER			MER-XX-SL-TS-227	Clinical Lights			0		14/03/13	BMCE-TRANSMIT-014488 (BMCE-WTRAN-006487)	04/04/13	21/05/13	C	BMCE-TRANSMIT-015385 21/05/13		28/05/2013
			MER			MER-XX-SL-TS-240	Medical Aire and Vaccum plant			0		08/04/13	BMCE-TRANSMIT-014976 (BMCE-WTRAN-006884)	29/04/13	16/10/13	C	18/10/13 BMCE-TRANSMIT-018130		
			MER			MER-XX-SL-TS-269	Bedhead Switching			0		23/07/13	BMCE-TRANSMIT-016891 (BMCE-WTRAN-008289)	13/08/13	14/08/13	B			
	VIE																		
	CAUSE & EFFECT										22/02/12								
	MAINTENANCE & ACCESS																		
	ACCESS & SECURITY																		
	SIGNAGE																		
	I.T.																		
	PATIENT ENTERTAINMENT																		
	P.A.																		
	COMPONENT REVIEWS																		
	BOILERS										09/05/12								
	TRANSFORMERS										09/07/12								
	AHU'S										09/07/12								
	CHILLERS										24/08/12								
	GENERATORS										12/12/11								
	CHP																		
	PUMPS										01/08/12								
	BMS										27/02/12								
	THEATRE PENDANTS										31/05/12								
	BED HEAD TRUNKING		MER			ME-SZ-XX-DT-S532-082	General Arrangement For 790 Flatwall Layout - MESC1000			1	14/04/12	05/12/12	BMCE-TRANSMIT-012735 (BMCE-WTRAN-005047)	26/12/12	12/03/13	C	20/04/13 BMCE-TRANSMIT-014705		
			MER			ME-SZ-XX-DT-S532-037	General Arrangement For 790 Flatwall Layout - MESC1012A			6		05/12/12	BMCE-TRANSMIT-012735 (BMCE-WTRAN-005047)	26/12/12	12/03/13	C	20/04/13 BMCE-TRANSMIT-014705		
			MER			ME-SZ-XX-DT-S532-056	General Arrangement For 790 Flatwall Layout - MESC1029			1		05/12/12	BMCE-TRANSMIT-012735 (BMCE-WTRAN-005047)	26/12/12	12/03/13	C	20/04/13 BMCE-TRANSMIT-014705		
			MER			ME-SZ-XX-DT-S532-086	General Arrangement For 790 Flatwall Layout - MESC1033			1		05/12/12	BMCE-TRANSMIT-012735 (BMCE-WTRAN-005047)	26/12/12	12/03/13	C	20/04/13 BMCE-TRANSMIT-014705		
			MER			ME-SZ-XX-DT-S532-064	General Arrangement For 790 Flatwall/Modus Layout - MESD1021			1		05/12/12	BMCE-TRANSMIT-012735 (BMCE-WTRAN-005047)	26/12/12	12/03/13	C	20/04/13 BMCE-TRANSMIT-014705		
			MER			ME-SZ-XX-DT-S532-065	General Arrangement For 790 Flatwall/Modus Layout - MESD1023			1		05/12/12	BMCE-TRANSMIT-012735 (BMCE-WTRAN-005047)	26/12/12	12/03/13	C	20/04/13 BMCE-TRANSMIT-014705		
			MER			ME-SZ-XX-DT-S532-067	General Arrangement For 790 Flatwall/Modus Layout - MESD1029			1		05/12/12	BMCE-TRANSMIT-012735 (BMCE-WTRAN-005047)	26/12/12	12/03/13	C	20/04/13 BMCE-TRANSMIT-014705		
			MER			ME-SZ-XX-DT-S532-066	General Arrangement For Ext-Modus Layout - MESD1030			4		05/12/12	BMCE-TRANSMIT-012735 (BMCE-WTRAN-005047)	26/12/12	12/03/13	C	20/04/13 BMCE-TRANSMIT-		

Drawing Information

31 BCL-AC-XX-SH-001

1st Submission2nd Submission

			Action By	Zone	Drawing Number	Drawing Title	Date Required from Consultant	Date Submitted by Consultant	Document Revision	Planned Date to be Submitted to Board	Date Submitted to Board	BMCE Transmittal No	Date Response Required from Board	Date Returned from Board	Board Status	Date returned to Consultant	Date Required from Consultant	Date Submitted by Consultant
Item	Submission	Comments																
			MER		ME-SZ-XX-DT-S532-026	General Arrangement For Modus Layout - MEST1023A			1		05/12/12	BMCE-TRANSMIT-012735 (BMCE-WTRAN-005047)	26/12/12	12/03/13	C	20/04/13 BMCE-TRANSMIT-014705		
			MER		ME-SZ-XX-DT-S532-051	General Arrangement For Modus Layout - MEST1023CG			1		05/12/12	BMCE-TRANSMIT-012735 (BMCE-WTRAN-005047)	26/12/12	12/03/13	C	20/04/13 BMCE-TRANSMIT-014705		
			MER		ME-SZ-XX-DT-S532-027	General Arrangement For 790 Flatwa I/Modus Layout - MEST1025			1		05/12/12	BMCE-TRANSMIT-012735 (BMCE-WTRAN-005047)	26/12/12	12/03/13	C	20/04/13 BMCE-TRANSMIT-014705		
			MER		ME-SZ-XX-DT-S532-031	General Arrangement For 790 Flatwall Layout - MEST1028			1		05/12/12	BMCE-TRANSMIT-012735 (BMCE-WTRAN-005047)	26/12/12	12/03/13	C	20/04/13 BMCE-TRANSMIT-014705		
			MER		ME-SZ-XX-DT-S532-028	General Arrangement For Modus Layout - MEST1029			1		05/12/12	BMCE-TRANSMIT-012735 (BMCE-WTRAN-005047)	26/12/12	12/03/13	C	20/04/13 BMCE-TRANSMIT-014705		
			MER		ME-SZ-XX-DT-S532-029	General Arrangement For Modus Layout - MEST1029A			1		05/12/12	BMCE-TRANSMIT-012735 (BMCE-WTRAN-005047)	26/12/12	12/03/13	C	20/04/13 BMCE-TRANSMIT-014705		
			MER		ME-SZ-XX-DT-S532-053	General Arrangement For Modus Layout - MEST1029C			1		05/12/12	BMCE-TRANSMIT-012735 (BMCE-WTRAN-005047)	26/12/12	12/03/13	C			
	Spreadsheet	Issued for information on BMCE-TRANSMIY-019967 22/04/14	MER		ME-XX-XX-SH-S532-001	Bedhead Trunking Scedule			5		01/07/13	BMCE-TRANSMIT-016551 (BMCE-WTRAN-008022)	22/07/13	30/07/13	B			
			MER		ME-SZ-XX-DT-S532-015	General Layout MEST1009B			1		22/04/14	BMCE-TRANSMIT-019967 (BMCE-WTRAN-010265)	13/05/14					
			MER		ME-SZ-XX-DT-S532-016	General Layout MEST1010			2		22/04/14	BMCE-TRANSMIT-019967 (BMCE-WTRAN-010265)	13/05/14					
			MER		ME-SZ-XX-DT-S532-017	General Layout MEST1016			2		22/04/14	BMCE-TRANSMIT-019967 (BMCE-WTRAN-010265)	13/05/14					
			MER		ME-SZ-XX-DT-S532-021	General Arrangement MEST1019			3		22/04/14	BMCE-TRANSMIT-019967 (BMCE-WTRAN-010265)	13/05/14					
			MER		ME-SZ-XX-DT-S532-033	General Arrangement MESC 1025			2		22/04/14	BMCE-TRANSMIT-019967 (BMCE-WTRAN-010265)	13/05/14					
			MER		ME-SZ-XX-DT-S532-038	General Arrangement MESC1021			3		22/04/14	BMCE-TRANSMIT-019967 (BMCE-WTRAN-010265)	13/05/14					
			MER		ME-SZ-XX-DT-S532-044	General Arrangement MEST1008CG			3		22/04/14	BMCE-TRANSMIT-019967 (BMCE-WTRAN-010265)	13/05/14					
			MER		ME-SZ-XX-DT-S532-057	General Arrangement MEST 1031			3		22/04/14	BMCE-TRANSMIT-019967 (BMCE-WTRAN-010265)	13/05/14					
			MER		ME-SZ-XX-DT-S532-058	General Arrangement MEST 1032			2		22/04/14	BMCE-TRANSMIT-019967 (BMCE-WTRAN-010265)	13/05/14					
			MER		ME-SZ-XX-DT-S532-061	General Arrangement MESC1032			2		22/04/14	BMCE-TRANSMIT-019967 (BMCE-WTRAN-010265)	13/05/14					
			MER		ME-SZ-XX-DT-S532-062	General Arrangement MEST1000B			5		22/04/14	BMCE-TRANSMIT-019967 (BMCE-WTRAN-010265)	13/05/14					
			MER		ME-SZ-XX-DT-S532-134	General Arrangement Nurse Call			3		22/04/14	BMCE-TRANSMIT-019967 (BMCE-WTRAN-010265)	13/05/14					
			MER		ME-SZ-XX-DT-S532-182	General Arrangement MESC1030			4		22/04/14	BMCE-TRANSMIT-019967 (BMCE-WTRAN-010265)	13/05/14					
			MER		ME-SZ-XX-DT-S532-183	General Arrangement MEST1020B			2		22/04/14	BMCE-TRANSMIT-019967 (BMCE-WTRAN-010265)	13/05/14					
			MER		ME-SZ-XX-DT-S532-184	General Arrangement MEST1022A			2		22/04/14	BMCE-TRANSMIT-019967 (BMCE-WTRAN-010265)	13/05/14					
			MER		ME-SZ-XX-DT-S532-185	General Arrangement MEST1023C			1		22/04/14	BMCE-TRANSMIT-019967 (BMCE-WTRAN-010265)	13/05/14					
			MER		ME-SZ-XX-DT-S532-186	General Arrangement MEST1033			3		22/04/14	BMCE-TRANSMIT-019967 (BMCE-WTRAN-010265)	13/05/14					
			MER		ME-SZ-XX-DT-S532-210	General Arrangement MESC1034			3		22/04/14	BMCE-TRANSMIT-019967 (BMCE-WTRAN-010265)	13/05/14					
			MER		ME-SZ-XX-DT-S532-268	General Arrangement MESC1021B			1		22/04/14	BMCE-TRANSMIT-019967 (BMCE-WTRAN-010265)	13/05/14					
			MER		ME-SZ-XX-DT-S532-491	General Arrangement MESC1029A			1		22/04/14	BMCE-TRANSMIT-019967 (BMCE-WTRAN-010265)	13/05/14					
			MER		ME-XX-XX-SH-S532-002	Bedhead Trunking Scedule			2		22/04/14	BMCE-TRANSMIT-019967 (BMCE-WTRAN-010265)	13/05/14					
	I.T. EQUIPMENT									01/04/12								

Drawing Information

31 BCL-AC-XX-SH-001

1st Submission2nd Submission

			Action By	Zone	Drawing Number	Drawing Title	Date Required from Consultant	Date Submitted by Consultant	Document Revision	Planned Date to be Submitted to Board	Date Submitted to Board	BMCE Transmittal No	Date Response Required from Board	Date Returned from Board	Board Status	Date returned to Consultant	Date Required from Consultant	Date Submitted by Consultant
Item	Submission	Comments																
			ZBP		ZBP-XX-XX-SP-539-204	Uninterruptible Power Supplies		03/02/12	B	24/02/12	29/02/12	BMCE-TRANSMIT-007868 (BMCE-WTRAN-002650)	21/03/12	11/05/12	A	24/05/12 BMCE-TRANSMIT-009066		
			ZBP		ZBP-XX-XX-SP-539-207	Earthing & Bonding Specification		03/02/12	B	24/02/12	29/02/12	BMCE-TRANSMIT-007868 (BMCE-WTRAN-002650)	21/03/12	11/05/12	A	24/05/12 BMCE-TRANSMIT-009066		
			ZBP		ZBP-XX-XX-SP-539-208	Water Detection System		03/02/12	B	24/02/12	29/02/12	BMCE-TRANSMIT-007868 (BMCE-WTRAN-002650)	21/03/12	11/05/12	B	24/05/12 BMCE-TRANSMIT-009066		
			ZBP		ZBP-XX-XX-SP-541-205	Lighting Installation		03/02/12	B	24/02/12	29/02/12	BMCE-TRANSMIT-007868 (BMCE-WTRAN-002650)	21/03/12	11/05/12	B	24/05/12 BMCE-TRANSMIT-009066		
			ZBP		ZBP-XX-XX-SP-541-248	Lighting Calcs & Luminaire Selection		03/02/12	B	24/02/12	29/02/12	BMCE-TRANSMIT-007868 (BMCE-WTRAN-002650)	21/03/12	11/05/12	A	24/05/12 BMCE-TRANSMIT-009066		
			ZBP		ZBP-XX-XX-SP-551-210	Public Address System		03/02/12	B	24/02/12	29/02/12	BMCE-TRANSMIT-007868 (BMCE-WTRAN-002650)	21/03/12	11/05/12	A	24/05/12 BMCE-TRANSMIT-009066		
			ZBP		ZBP-XX-XX-SP-554-212	TV & Radio Distribution System		03/02/12	B	24/02/12	29/02/12	BMCE-TRANSMIT-007868 (BMCE-WTRAN-002650)	21/03/12	11/05/12	B	24/05/12 BMCE-TRANSMIT-009066		
			ZBP		ZBP-XX-XX-SP-557-217	Nurse Call Systems		03/02/12	B	24/02/12	29/02/12	BMCE-TRANSMIT-007868 (BMCE-WTRAN-002650)	21/03/12	11/05/12	B	24/05/12 BMCE-TRANSMIT-009066		
			ZBP		ZBP-XX-XX-SP-559-211	Induction Loop Systems		03/02/12	B	24/02/12	29/02/12	BMCE-TRANSMIT-007868 (BMCE-WTRAN-002650)	21/03/12	11/05/12	A	24/05/12 BMCE-TRANSMIT-009066		
			ZBP		ZBP-XX-XX-SP-571-213	Security		03/02/12	B	24/02/12	29/02/12	BMCE-TRANSMIT-007868 (BMCE-WTRAN-002650)	21/03/12	11/05/12	B	24/05/12 BMCE-TRANSMIT-009066		
			ZBP		ZBP-XX-XX-SP-571-216	Disabled To let Alarms		03/02/12	B	24/02/12	29/02/12	BMCE-TRANSMIT-007868 (BMCE-WTRAN-002650)	21/03/12	11/05/12	B	24/05/12 BMCE-TRANSMIT-009066		
			ZBP		ZBP-XX-XX-SP-572-214	Fire Alarms		03/02/12	C	24/02/12	29/02/12	BMCE-TRANSMIT-007868 (BMCE-WTRAN-002650)	21/03/12	11/05/12	B	24/05/12 BMCE-TRANSMIT-009066		
		Issued for information on BMCE-TRANSMIT-019868 08/04/14	ZBP		ZBP-XX-XX-SP-500-103	Hot & Cold Water Supply Systems		06/03/2012	B		07/03/2012	BMCE-TRANSMIT-007972 (BMCE-WTRAN-002671)	28/03/12	22/06/2012	B	05/07/12 BMCE-TRANSMIT-009674		
		Issued for information on BMCE-TRANSMIT-019868 08/04/14	ZBP		ZBP-XX-XX-XP-500-104	Water Treatment Equipment		06/03/2012	B		07/03/2012	BMCE-TRANSMIT-007972 (BMCE-WTRAN-002671)	28/03/12	22/06/2012	B	05/07/12 BMCE-TRANSMIT-009674		
			ZBP		ZBP-XX-XX-SP-581-101	Rainwater Drainage Systems		06/03/2012	B		07/03/2012	BMCE-TRANSMIT-007972 (BMCE-WTRAN-002671)	28/03/12	22/06/2012	B	05/07/12 BMCE-TRANSMIT-009674		
			ZBP		ZBP-XX-XX-SP-581-102	Above Ground Foul Drainage System			D		18/05/2012	BMCE-TRANSMIT-008914 (BMCE-WTRAN-003096)	08/06/12	14/08/2012	B	03/09/12 BMCE-TRANSMIT-010679		
		Issued for information on BMCE-TRANSMIT-019868 08/04/14	ZBP		ZBP-XX-XX-SP-511-352	Natural Gas supply Systems		06/03/2012	B		07/03/2012	BMCE-TRANSMIT-007973 (BMCE-WTRAN-002672)	28/03/12	22/06/2012	B	05/07/12 BMCE-TRANSMIT-009671		
		Issued for information on BMCE-TRANSMIT-019868 08/04/14	ZBP		ZBP-XX-XX-SP-511-354	External Fire Hydrant Systems		06/03/2012	B		07/03/2012	BMCE-TRANSMIT-007973 (BMCE-WTRAN-002672)	28/03/12	22/06/2012	B	05/07/12 BMCE-TRANSMIT-009671		
		Issued for information on BMCE-TRANSMIT-019868 08/04/14	ZBP		ZBP-XX-XX-SP-512-304	Performance Specification - Medical Gas Installation		06/03/2012	B		07/03/2012	BMCE-TRANSMIT-007973 (BMCE-WTRAN-002672)	28/03/12	22/06/2012	B	05/07/12 BMCE-TRANSMIT-009671		
		Issued for information on BMCE-TRANSMIT-019868 08/04/14	ZBP		ZBP-XX-XX-SP-569-306	Pneumatic Tube Transport System		06/03/2012	B		07/03/2012	BMCE-TRANSMIT-007973 (BMCE-WTRAN-002672)	28/03/12	22/06/2012	B	05/07/12 BMCE-TRANSMIT-009671		
		Issued for information on BMCE-TRANSMIT-019868 08/04/14	ZBP		ZBP-XX-XX-SP-572-305	Fire Fighting Systems		06/03/2012	B		07/03/2012	BMCE-TRANSMIT-007973 (BMCE-WTRAN-002672)	28/03/12	22/06/2012	B	05/07/12 BMCE-TRANSMIT-009671		
		Issued for information on BMCE-TRANSMIT-019748 24/03/14	ZBP		ZBP-XX-XX-SP-660-401	Y40 Performance Spec for BMS & Automatic Controls Volume 1			B	24/10/2012	24/10/2012	BMCE-TRANSMIT-011815 (BMCE-WTRAN-004300)	14/11/12	19/02/2013	B	20/02/13 BMCE-TRANSMIT-014075		
			ZBP		ZBP-XX-XX-SP-660-402	BMS & Auto Controls Volume 2 MTHW & LTHW Heating Systems			D	24/10/2012	24/10/2012	BMCE-TRANSMIT-011815 (BMCE-WTRAN-004300)	14/11/12	19/02/2013	B	20/02/13 BMCE-TRANSMIT-014075		
		Issued for information on BMCE-TRANSMIT-019748 24/03/14	ZBP		ZBP-XX-XX-SP-660-403	BMS & Auto Controls Volume 3 Chilled Water Systems			D	24/10/2012	24/10/2012	BMCE-TRANSMIT-011815 (BMCE-WTRAN-004300)	14/11/12	19/02/2013	B	20/02/13 BMCE-TRANSMIT-014075		
			ZBP		ZBP-XX-XX-SP-660-404	BMS & Auto Controls Volume 4 Cold Water Systems			B		15/06/2012	BMCE-TRANSMIT-009361 (BMCE-WTRAN-003284)	06/07/12	10/09/2012	A	20/09/12 BMCE-TRANSMIT-011062		
		Issued for information on BMCE-TRANSMIT-019265 05/02/14	ZBP		ZBP-XX-XX-SP-660-406	BMS & Auto Controls Volume 6 Misc Items			C	24/10/2012	24/10/2012	BMCE-TRANSMIT-011815 (BMCE-WTRAN-004300)	14/11/12	19/02/2013	B	20/02/13 BMCE-TRANSMIT-014075		
			ZBP		ZBP-XX-XX-SP-660-451	BMS & Automatic Controls Volume 5.1 Ventilation Systems PR21			A		07/06/2012	BMCE-TRANSMIT-009259 (BMCE-WTRAN-003223)	28/06/12	10/09/2012	A	20/09/12 BMCE-TRANSMIT-011054		
		Issued for information on BMCE-TRANSMIT-019748 24/03/14	ZBP		ZBP-XX-XX-SP-660-452	BMS & Automatic Controls Volume 5.2 Ventilation Systems PR22			A		07/06/2012	BMCE-TRANSMIT-009259 (BMCE-WTRAN-003223)	28/06/12	10/09/2012	B	20/09/12 BMCE-TRANSMIT-011054		
		Issued for information on BMCE-TRANSMIT-019748 24/03/14	ZBP		ZBP-XX-XX-SP-660-453	BMS & Automatic Controls Volume 5.3 Ventilation Systems PR31			A		07/06/2012	BMCE-TRANSMIT-009259 (BMCE-WTRAN-003223)	28/06/12	10/09/2012	B	20/09/12 BMCE-TRANSMIT-011054		
			ZBP		ZBP-XX-XX-SP-660-454	BMS & Automatic Control Volume 5.4 Ventilation PR32			A	24/10/2012	24/10/2012	BMCE-TRANSMIT-011815 (BMCE-WTRAN-004300)	14/11/12	19/02/2013	B	20/02/13 BMCE-TRANSMIT-014075		
		Issued for information on BMCE-TRANSMIT-019748 24/03/14	ZBP		ZBP-XX-XX-SP-660-455	BMS & Automatic Control Volume 5.5 Ventilation System PR 33			A	24/10/2012	24/10/2012	BMCE-TRANSMIT-011815 (BMCE-WTRAN-004300)	14/11/12			20/02/13 BMCE-TRANSMIT-		

RDD MASTER SCHEDULE - NHS Greater Glasgow & Clyde / New South Glasgow Hospitals (NSGH) Project - Adults & Childrens Hospital

[illegible]

32		AGV's		BCL-AC-XX-SH-001		Drawing Information										
						1st Submission										
						Date Required from Consultant	Date Submitted by Consultant	Document Revision	Planned Date to be Submitted to Board	Date Submitted to Board	Date Response Required from Board (+3 Weeks)	Date Returned from Board	Board Status	Date returned to Consultant	Date Required from Consultant	
Item	Submission		Comments													
			SWISS LOG	SWL-SZ-01-PL-564-322	Mounting Layout		18/08/2013	B		23/08/13 BMCE-TRANSMIT-017385 (BMCE-WTRAN-008678)	13/09/2013	06/09/2013	A	BMCE-TRANSMIT-017741 18/09/2013		
			SWISS LOG	SWL-SZ-01-PL-564-323	Mounting Layout		18/08/2013	B		23/08/13 BMCE-TRANSMIT-017385 (BMCE-WTRAN-008678)	13/09/2013	06/09/2013	A	BMCE-TRANSMIT-017741 18/09/2013		
			SWISS LOG	SWL-SZ-01-PL-564-324	Mounting Layout		18/08/2013	B		23/08/13 BMCE-TRANSMIT-017385 (BMCE-WTRAN-008678)	13/09/2013	06/09/2013	A	BMCE-TRANSMIT-017741 18/09/2013		
			SWISS LOG	SWL-SZ-01-PL-564-325	Mounting Layout		18/08/2013	B		23/08/13 BMCE-TRANSMIT-017385 (BMCE-WTRAN-008678)	13/09/2013	06/09/2013	A	BMCE-TRANSMIT-017741 18/09/2013		
			SWISS LOG	SWL-SZ-01-PL-564-326	Mounting Layout		18/08/2013	B		23/08/13 BMCE-TRANSMIT-017385 (BMCE-WTRAN-008678)	13/09/2013	06/09/2013	A	BMCE-TRANSMIT-017741 18/09/2013		
			SWISS LOG	SWL-SZ-02-PL-564-327	Mounting Layout		18/08/2013	B		23/08/13 BMCE-TRANSMIT-017385 (BMCE-WTRAN-008678)	13/09/2013	06/09/2013	A	BMCE-TRANSMIT-017741 18/09/2013		
			SWISS LOG	SWL-SZ-02-PL-564-328	Mounting Layout		18/08/2013	B		23/08/13 BMCE-TRANSMIT-017385 (BMCE-WTRAN-008678)	13/09/2013	06/09/2013	A	BMCE-TRANSMIT-017741 18/09/2013		
			SWISS LOG	SWL-SZ-02-PL-564-329	Mounting Layout		18/08/2013	B		23/08/13 BMCE-TRANSMIT-017385 (BMCE-WTRAN-008678)	13/09/2013	06/09/2013	A	BMCE-TRANSMIT-017741 18/09/2013		

[illegible]

34BCL-AC-XX-SH-001			1ST SUBMISSION RDD														OVERDUE	2ND SUBMISSION RDD										OVERDUE
			Action By	Drawing Number	Drawing Title	Date Required from Consultant	Date Submitted by Consultant	Document Revision	Planned Date to be Submitted to Board	Date Submitted to Board	BMCE Transmittal No	Date Response Required from Board (+8 Weeks)	Date Received from Board	Board Status	Date Returned to Consultant	OVERDUE	Date Required from Consultant	Date Submitted by Consultant	Document Revision	Planned Date to be Submitted to Board	Date Submitted to Board	BMCE Transmittal No	Date Response Required from Board (+8 Weeks)	Date Received from Board	Board Status	Date Returned to Consultant	OVERDUE	
Item	Submission	Comments																										
34	Radiation Protection Strategy																											

BCL-AC-XX-SH-001			1ST SUBMISSION RDD													OVERDUE		2ND SUBMISSION RDD													OVERDUE	
			Action By	Drawing Number	Drawing Title	Date Required from Consultant	Date Submitted by Consultant	Document Revision	Planned Date to be Submitted to Board	Date Submitted to Board	BMCE Transmittal No	Date Response Required from Board (+8 Weeks)	Date Received from Board	Board Status	Date Returned to Consultant	OVERDUE	Date Required from Consultant	Date Submitted by Consultant	Document Revision	Planned Date to be Submitted to Board	Date Submitted to Board	BMCE Transmittal No	Date Response Required from Board (+8 Weeks)	Date Received from Board	Board Status	Date Returned to Consultant	OVERDUE					
Item	Submission	Comments																														
			NA	NA-XX-00-PL-330-202	Ground Floor Plan - NCH Entrance and OPD - Radiation Protec ion Strategy Plan	02/09/2011	02/09/2011	5	14/09/2011	15/09/2011	BMCE-TRANSMIT-005102	12/10/2011		A	BMCE-TRANSMIT-008536 25 04/2012				11 06/2012	6		29/06/2012	BMCE-TRANSMIT-009596	17/07/2012	08/08/2012	A	BMCE-TRANSMIT-010392					
			NA	NA-XX-00-PL-330-204	Ground Floor Plan - NCH Emergency Department & Decontamination Un t - Radiation Protection Strategy Plan	02/09/2011	02/09/2011	5	14/09/2011	15/09/2011	BMCE-TRANSMIT-005102	12/10/2011		B	BMCE-TRANSMIT-008536 25 04/2012				11 06/2012	6		29/06/2012	BMCE-TRANSMIT-009596	17/07/2012	08/08/2012	A	BMCE-TRANSMIT-010392					
			NA	NA-XX-00-PL-330-205	Ground Floor Plan - NSGH Emergency Department - Radiation Protection Strategy Plan	02/09/2011	02/09/2011	5	14/09/2011	15/09/2011	BMCE-TRANSMIT-005102	12/10/2011		B	BMCE-TRANSMIT-008536 25 04/2012				11 06/2012	6		29/06/2012	BMCE-TRANSMIT-009596	17/07/2012	08/08/2012	A	BMCE-TRANSMIT-010392					
			NA	NA-XX-00-PL-330-207	Ground Floor Plan - NSGH Radiology - Radiation Protection Strategy Plan	02/09/2011	02/09/2011	5	14/09/2011	15/09/2011	BMCE-TRANSMIT-005102	12/10/2011		B	BMCE-TRANSMIT-008536 25 04/2012				11 06/2012	6		29/06/2012	BMCE-TRANSMIT-009596	17/07/2012	08/08/2012	A	BMCE-TRANSMIT-010392					
			NA	NA-XX-00-PL-330-208	Ground Floor Plan - NCH Radiology - Radiation Protection Strategy Plan	02/09/2011	02/09/2011	5	14/09/2011	15/09/2011	BMCE-TRANSMIT-005102	12/10/2011		B	BMCE-TRANSMIT-008536 25 04/2012				11 06/2012	6		29/06/2012	BMCE-TRANSMIT-009596	17/07/2012	08/08/2012	A	BMCE-TRANSMIT-010392					
			NA	NA-XX-01-PL-330-201	First Floor Plan - NCH Theatres / Radiology & Interventional Radiology - Radiation Protection Strategy Plan	02/09/2011	02/09/2011	5	14/09/2011	15/09/2011	BMCE-TRANSMIT-005102	12/10/2011		B	BMCE-TRANSMIT-008536 25 04/2012				11 06/2012	7		29/06/2012	BMCE-TRANSMIT-009596	17/07/2012	08/08/2012	A	BMCE-TRANSMIT-010392					
			NA	NA-XX-01-PL-330-204	First Floor Plan - NSGH Coronary Care Unit (CCU) - Radiation Protection Strategy Plan	02/09/2011	02/09/2011	4	14/09/2011	15/09/2011	BMCE-TRANSMIT-005102	12/10/2011		A	BMCE-TRANSMIT-008536 25 04/2012				11 06/2012	5		29/06/2012	BMCE-TRANSMIT-009596	17/07/2012	08/08/2012	A	BMCE-TRANSMIT-010392					
			NA	NA-XX-01-PL-330-207	First Floor Plan - NSGH Radiology - Radiation Protection Strategy Plan	02/09/2011	02/09/2011	4	14/09/2011	15/09/2011	BMCE-TRANSMIT-005102	12/10/2011		B	BMCE-TRANSMIT-008536 25 04/2012				11 06/2012	5		29/06/2012	BMCE-TRANSMIT-009596	17/07/2012	08/08/2012	A	BMCE-TRANSMIT-010392					
			NA	NA-XX-01-PL-330-208	First Floor Plan - NSGH Nuclear Medicine - Radiation Protection Strategy Plan	02/09/2011	02/09/2011	5	14/09/2011	15/09/2011	BMCE-TRANSMIT-005102	12/10/2011		B	BMCE-TRANSMIT-008536 25 04/2012				11 06/2012	6		29/06/2012	BMCE-TRANSMIT-009596	17/07/2012	08/08/2012	A	BMCE-TRANSMIT-010392					
			NA	NA-XX-02-PL-330-202	Second Floor Plan - NCH Schehal ion Ward - Radiation Protection Strategy Plan	02/09/2011	02/09/2011	5	14/09/2011	15/09/2011	BMCE-TRANSMIT-005102	12/10/2011		C	BMCE-TRANSMIT-008536 25 04/2012				11 06/2012	7		29/06/2012	BMCE-TRANSMIT-009596	17/07/2012	08/08/2012	B	BMCE-TRANSMIT-010392					
			NA	NA-XX-02-PL-330-204	Second Floor Plan - NSGH Endoscopy / Decontamination / Medical Physics - Radiation Protection Strategy Plan	02/09/2011	02/09/2011	5	14/09/2011	15/09/2011	BMCE-TRANSMIT-005102	12/10/2011		A	BMCE-TRANSMIT-008536 25 04/2012				11 06/2012	6		29/06/2012	BMCE-TRANSMIT-009596	17/07/2012	08/08/2012	A	BMCE-TRANSMIT-010392					
			NA	NA-XX-02-PL-330-205	Second Floor Plan - NSGH Theatres + Plant (1 of 2) - Radia ion Protec ion Strategy Plan	02/09/2011	02/09/2011	4	14/09/2011	15/09/2011	BMCE-TRANSMIT-005102	12/10/2011		C	BMCE-TRANSMIT-008536 25 04/2012				11 06/2012	6		29/06/2012	BMCE-TRANSMIT-009596	17/07/2012	08/08/2012	B	BMCE-TRANSMIT-010392					
			NA	NA-XX-02-PL-330-206	Second Floor Plan - NSGH Theatres + Plant (2 of 2) - Radia ion Protec ion Strategy Plan	02/09/2011	02/09/2011	4	14/09/2011	15/09/2011	BMCE-TRANSMIT-005102	12/10/2011		B	BMCE-TRANSMIT-008536 25 04/2012				11 06/2012	6		29/06/2012	BMCE-TRANSMIT-009596	17/07/2012	08/08/2012	A	BMCE-TRANSMIT-010392					
	Specialist Equipment Strategy	Movement Joints issued for information only. Incorporated within the 330 finishes series	NA	NA-XX-B1-PL-480-150	Basement Floor Plan - Special ist Equipment Slab Recesses & Movement Joint Strategy Plan	02/09/2011	14/09/2011	3	14/09/2011	19/09/2011	BMCE-TRANSMIT-005832																					
		Movement Joints issued for information only. Incorporated within the 330 finishes series	NA	NA-XX-00-PL-480-150	Ground Floor - Specialist Equipment Slab Recesses & Movement Joint Strategy Plan	02/09/2011	14/09/2011	4	14/09/2011	19.09.2011	BMCE-TRANSMIT-005832																					
		Movement Joints issued for information only. Incorporated within the 330 finishes series	NA	NA-XX-01-PL-480-150	First Floor - Special ist Equipment Slab Recesses & Movement Joint Strategy Plan	02/09/2011	14/09/2011	5	14/09/2011	19.09.2011	BMCE-TRANSMIT-005832																					
		Movement Joints issued for information only. Incorporated within the 330 finishes series	NA	NA-XX-02-PL-480-150	Second Floor - Specialist Equipment Slab Recesses & Movement Joint Strategy Plan	02/09/2011	14/09/2011	4	14/09/2011	19.09.2011	BMCE-TRANSMIT-005832																					
		Movement Joints issued for information only. Incorporated within the 330 finishes series	NA	NA-xx-03-PL-480-150	Third Floor Plan - Specialist Equipment Slab Recesses & Movement Joint Strategy Plan	02/09/2011	14/09/2011	3	14/09/2011	19/09/2011	BMCE-TRANSMIT-005832																					
		Movement Joints issued for information only. Incorporated within the 330 finishes series	NA	NA-xx-04-PL-480-150	Fourth Floor Plan - Specialist Equipment Slab Recesses & Movement Joint Strategy Plan	02/09/2011	14/09/2011	3	14/09/2011	19/09/2011	BMCE-TRANSMIT-005832																					
		Movement Joints issued for information only. Incorporated within the 330 finishes series	NA	NA-xx-05-PL-480-150	Fif h Floor Plan - Specialist Equipment Slab Recesses & Movement Joint Strategy Plan	02/09/2011	14/09/2011	3	14/09/2011	19/09/2011	BMCE-TRANSMIT-005832																					
		Movement Joints issued for information only. Incorporated within the 330 finishes series	NA	NA-xx-06-PL-480-150	Six h Floor - Special ist Equipment Slab Recesses & Movement Joint Strategy Plan	02/09/2011	14/09/2011	4	14/09/2011	19/09/2011	BMCE-TRANSMIT-005832																					
		Movement Joints issued for information only. Incorporated within the 330 finishes series	NA	NA-xx-07-PL-480-150	Seventh Floor Plan - Specialist Equipment Slab Recesses & Movement Joint Strategy Plan	02/09/2011	14/09/2011	3	14/09/2011	19/09/2011	BMCE-TRANSMIT-005832																					
		Movement Joints issued for information only. Incorporated within the 330 finishes series	NA	NA-xx-08-PL-480-150	Eighth Floor Plan - Specialist Equipment Slab Recesses & Movement Joint Strategy Plan	02/09/2011	14/09/2011	1	14/09/2011	19/09/2011	BMCE-TRANSMIT-005832																					
		Movement Joints issued for information only. Incorporated within the 330 finishes series	NA	NA-xx-09-PL-480-150	Ninth Floor Plan - Specialist Equipment Slab Recesses & Movement Joint Strategy Plan	02/09/2011	14/09/2011	1	14/09/2011	19/09/2011	BMCE-TRANSMIT-005832																					
		Movement Joints issued for information only. Incorporated within the 330 finishes series	NA	NA-xx-10-PL-480-150	Tenth Floor Plan - Special ist Equipment Slab Recesses & Movement Joint Strategy Plan	02/09/2011	14/09/2011	1	14/09/2011	19/09/2011	BMCE-TRANSMIT-005832																					
		Movement Joints issued for information only. Incorporated within the 330 finishes series	NA	NA-xx-11-PL-480-150	Eleventh Floor Plan - Special ist Equipment Slab Recesses & Movement Joint Strategy Plan	02/09/2011	14/09/2011	3	14/09/2011	19/09/2011	BMCE-TRANSMIT-005832																					
			NA	NA-xx-12-PL-480-150	Twelf h Floor Plan - Specialist Equipment Slab Recesses & Movement Joint Strategy Plan																											
	Lead Lined plasterboard details		AST	AST-XX-XX-DT-252-070	Lead Lining Details Sheet 1 - Typical Junctions - up to Code 7	05/03/2012	05/03/2012	A	03/04/2012	03/04/2012	BMCE-TRANSMIT-008244	29/05/2012	23/04/2012	A	BMCE-TRANSMIT-008500 23/04/12																	

34 BCL-AC-XX-SH-001

BCL-AC-XX-SH-001			1ST SUBMISSION RDD												OVERDUE	2ND SUBMISSION RDD												OVERDUE
			Action By	Drawing Number	Drawing Title	Date Required from Consultant	Date Submitted by Consultant	Document Revision	Planned Date to be Submitted to Board	Date Submitted to Board	BMCE Transmittal No	Date Response Required from Board (+8 Weeks)	Date Received from Board	Board Status	Date Returned to Consultant	OVERDUE	Date Required from Consultant	Date Submitted by Consultant	Document Revision	Planned Date to be Submitted to Board	Date Submitted to Board	BMCE Transmittal No	Date Response Required from Board (+8 Weeks)	Date Received from Board	Board Status	Date Returned to Consultant	OVERDUE	
Item	Submission	Comments																										
			AST	AST-XX-XX-DT-252-071	Lead Lining Details Sheet 2 - Door Jambs & Noggins - up to Code 7	05/03/2012	05/03/2012	A	03/04/2012	03/04/2012	BMCE-TRANSMIT-008244	29/05/2012	23/04/2012	C	BMCE-TRANSMIT-012709 05 11/2012 23/04 12			19 08/2013	B		18/02/2014	BMCE-TRANSMIT--019458	04/03/2014					
			AST	AST-XX-XX-DT-252-072	Lead Lining Details Sheet 3 - Door Post Details	23/04/2012	02/04/2012	A	03/04/2012	03/04/2012	BMCE-TRANSMIT-008244	29/05/2012	23/04/2012	A	BMCE-TRANSMIT-008900 23/04 12													
			AST	AST-XX-XX-DT-252-073	Lead Lining Deta ls Sheet 4 - External Wall/Column Abutment - up to Code 7	23/04/2012	02/04/2012	A	03/04/2012	03/04/2012	BMCE-TRANSMIT-008244	21/05/2012		A	BMCE-TRANSMIT-012709 05 11/2012 23/04 12													
			AST	AST-XX-XX-DT-252-074	Lead Lining Deta ls Sheet 5 - Socket Treatment - up to Code 7	23/04/2012	02/04/2012	A	03/04/2012	03/04/2012	BMCE-TRANSMIT-008244	21/05/2012		C	BMCE-TRANSMIT-012709 05 11/2012 23/04 12			19 08/2013	B		18/02/2014	BMCE-TRANSMIT--019458	04/03/2014					
			AST	AST-XX-XX-DT-252-075	Lead Lining Details Sheet 6 - Change in Lead Code Thickness Thickness	23/04/2012	02/04/2012	A	03/04/2012	03/04/2012	BMCE-TRANSMIT-008244	21/05/2012		B	BMCE-TRANSMIT-012709 05 11/2012 23/04 12													
		Drawing not required	AST	AST-XX-XX-DT-252-076	Lead Lining Details Sheet 7 - Low Level Walls & Nib End Deta ls - up to Code 7	23/04/2012						21/05/2012																
			AST	AST-XX-XX-DT-252-090	MRI Break Out Panel		18/06/201	B		02/07/201	BMCE-TRANSMIT-016582	23/07/2013	02/08/2013	B	BMCE-TRANSMIT-017311 15 08/2013													
			AST	AST-XX-XX-DT-252-111	Alternative Lead Board Joint Detail		21/03/2013	1		10/04/2013	BMCE-TRANSMIT-015043	01/05/2013	07/05/2013	B	BMCE-TRANSMIT-015512 07 05/2013													
			AST	AST-XX-XX-DT-252-076	Lead Lining Treatment To Service Penetrations		15/04/2013	1		29/04/2013	BMCE-TRANSMIT-015391	20/05/2013		C	BMCE-TRANSMIT-016389 20 06/2013			02 07/2013	A		04/07/2013	BMCE-TRANSMIT-016627	18/07/2013	31/07/2013	B	BMCE-TRANSMIT-017312 15 08/2013		
			AST	AST-XX-XX-DT-252-143	Lead Lined Partition to Schiehal ion Room		12/02/2013	1		03/03/2014	BMCE-TRANSMIT-019618	24/03/2014	04/04/2014	C	BMCE-TRANSMIT-019927 14 04/2014													
			AST	AST-XX-XX-DT-252-144	Schiehal ion Room Door Post Detail		06/03/2014	2		10/03/2014	BMCE-TRANSMIT-019632	31/03/2014	03.04.2014	A	BMCE-TRANSMIT-019914 30.04 2014													
			AST	AST-XX-XX-DT-252-146	Schiehallion Room Lead Protection To Room Corner Movement Joint		07/02/2014	1		14/02/2014	BMCE-TRANSMIT-019429	28/02/2014	03.04.2014	A	BMCE-TRANSMIT-019913 11.04.2014													
			NHSGC	NHSGC-AC-XX-SH-330-200	NCH Radiation Compliance Advice Schedule			2		24/04/2012	BMCE-TRANSMIT-008501	15/05/2012	09/08/2012	B	BMCE-TRANSMIT-010389 20 08/2012													
			NHSGC	NHSGC-AC-XX-SH-330-201	Adult Radiation Compliance Advice Schedule			2		24/04/1/12	BMCE-TRANSMIT-008501	15/05/2012	09/08/2012	B	BMCE-TRANSMIT-010389 20 08/2012													
			NHSGC	NHSGC-AC-XX-SH-330-202	Laser Compliance Advice Schedule			1		24/04/2012	BMCE-TRANSMIT-008501	15/05/2012	09/08/2012	B	BMCE-TRANSMIT-010389 20 08/2012													
	TDSL		TDSL	TDS-XX-XX-SH-321-011	Lead Screen Schedule		04/06/2013	2		05/06/2013	BMCE-TRANSMIT-016151	26/06/2013	08/07/201	B	BMCE-TRANSMIT-016850 16 07/2013													

34BCL-AC-XX-SH-001			1ST SUBMISSION RDD													OVERDUE	2ND SUBMISSION RDD													OVERDUE
			Action By	Drawing Number	Drawing Title	Date Required from Consultant	Date Submitted by Consultant	Document Revision	Planned Date to be Submitted to Board	Date Submitted to Board	BMCE Transmittal No	Date Response Required from Board (+8 Weeks)	Date Received from Board	Board Status	Date Returned to Consultant	OVERDUE	Date Required from Consultant	Date Submitted by Consultant	Document Revision	Planned Date to be Submitted to Board	Date Submitted to Board	BMCE Transmittal No	Date Response Required from Board (+8 Weeks)	Date Received from Board	Board Status	Date Returned to Consultant	OVERDUE			
Item	Submission	Comments																												

RSD MASTER SCHEDULE - NHS Greater Glasgow & Clyde / New South Glasgow Hospitals (NSGH) Project - Adults & Children Hospital						Brookfield Multiplex Europe																																			
						Drawing Information																																			
BCLAC XX-BH 001						1st Submission												2nd Submission												3rd Submission											
Item	Submit on	Comments	Action By	Drawing Number	Drawing Title	Date Required from Consultant	Date Submitted by Consultant	Document Review on	Planned Date to be Submitted to Board	Date Submitted to Board	BMCE Transmittal No	Date Response Required from Board (2 Weeks)	Date Received from Board	Board Status	Date Returned to Consultant	Date Required from Consultant	Date Submitted by Consultant	Document Review on	Planned Date to be Submitted to Board	Date Submitted to Board	Date Response Required from Board (2 Weeks)	Date Received from Board	Board Status	Date Returned to Consultant	Date Required from Consultant	Date Submitted by Consultant	Document Review on	Planned Date to be Submitted to Board	Date Submitted to Board	Date Response Required from Board (2 Weeks)	Date Received from Board	Board Status	Date Returned to Consultant								
35	Acoustic Strategy		NA	NA-XX-BE-PL-330-350	Basement - Acoustic Strategy Plan	14/12/2011	14/12/2011	4	01/01/2012	03/04/2012	BMCE-TRANSMIT-008258	24/04/2012	14/05/2012	A	BMCE-TRANSMIT-008997 21.05.12		12/10/2012	6		BMCE-TRANSMIT-015401 16/05/2013	30/05/2013	22/02/2013	B	BMCE-TRANSMIT-015713 16/05/2013																	
			NA	NA-XX-GB-PL-330-350	Ground Floor - Acoustic Strategy Plan	14/12/2011	22/03/2012	5	01/01/2012	03/04/2012	BMCE-TRANSMIT-008258	24/04/2012	14/05/2012	B	BMCE-TRANSMIT-008997 21.05.12		12/10/2012	8		BMCE-TRANSMIT-015401 16/05/2013	30/05/2013	22/02/2013	A	BMCE-TRANSMIT-015713 16/05/2013																	
			NA	NA-XX-C1-PL-330-350	First Floor - Acoustic Strategy Plan	14/12/2011	22/03/2012	5	01/01/2012	03/04/2012	BMCE-TRANSMIT-008258	24/04/2012	14/05/2012	B	BMCE-TRANSMIT-008997 21.05.12		12/10/2012	9		BMCE-TRANSMIT-015401 16/05/2013	30/05/2013	22/02/2013	A	BMCE-TRANSMIT-015713 16/05/2013																	
			NA	NA-XX-C2-PL-330-350	Second Floor - Acoustic Strategy Plan	14/12/2011	14/12/2011	4	01/01/2012	03/04/2012	BMCE-TRANSMIT-008258	24/04/2012	14/05/2012	B	BMCE-TRANSMIT-008997 21.05.12		12/10/2012	6		BMCE-TRANSMIT-015401 16/05/2013	30/05/2013	22/02/2013	A	BMCE-TRANSMIT-015713 16/05/2013																	
			NA	NA-XX-C3-PL-330-350	Third Floor - Acoustic Strategy Plan	14/12/2011	14/12/2011	4	01/01/2012	03/04/2012	BMCE-TRANSMIT-008258	24/04/2012	14/05/2012	B	BMCE-TRANSMIT-008997 21.05.12		12/10/2012	10		BMCE-TRANSMIT-015401 16/05/2013	30/05/2013	22/02/2013	B	BMCE-TRANSMIT-015713 16/05/2013																	
			NA	NA-XX-D4-PL-330-350	Fourth Floor - Acoustic Strategy Plan	14/12/2011	14/12/2011	4	01/01/2012	03/04/2012	BMCE-TRANSMIT-008258	24/04/2012	14/05/2012	A	BMCE-TRANSMIT-008997 21.05.12		12/10/2012	6		BMCE-TRANSMIT-015401 16/05/2013	30/05/2013	22/02/2013	A	BMCE-TRANSMIT-015713 16/05/2013																	
			NA	NA-XX-D5-PL-330-350	Fifth Floor - Acoustic Strategy Plan	14/12/2011	14/12/2011	4	01/01/2012	03/04/2012	BMCE-TRANSMIT-008258	24/04/2012	14/05/2012	A	BMCE-TRANSMIT-008997 21.05.12		12/10/2012	6		BMCE-TRANSMIT-015401 16/05/2013	30/05/2013	22/02/2013	A	BMCE-TRANSMIT-015713 16/05/2013																	
			NA	NA-XX-D6-PL-330-350	Sixth Floor - Acoustic Strategy Plan	14/12/2011	14/12/2011	4	01/01/2012	03/04/2012	BMCE-TRANSMIT-008258	24/04/2012	14/05/2012	A	BMCE-TRANSMIT-008997 21.05.12		12/10/2012	6		BMCE-TRANSMIT-015401 16/05/2013	30/05/2013	22/02/2013	A	BMCE-TRANSMIT-015713 16/05/2013																	
		These drawings were not issued for RSD. Refer to Level 6	NA	NA-XX-BE-PL-330-350	Basement - Acoustic Strategy Plan																																				
		These drawings were not issued for RSD. Refer to Level 6	NA	NA-XX-GB-PL-330-350	Ground Floor - Acoustic Strategy Plan																																				
		These drawings were not issued for RSD. Refer to Level 6	NA	NA-XX-C1-PL-330-350	First Floor - Acoustic Strategy Plan																																				
		These drawings were not issued for RSD. Refer to Level 6	NA	NA-XX-C2-PL-330-350	Second Floor - Acoustic Strategy Plan																																				
		These drawings were not issued for RSD. Refer to Level 6	NA	NA-XX-C3-PL-330-350	Third Floor - Acoustic Strategy Plan																																				
	Acoustic Strategy Reports		ALC	ALC-S2-SL-OC-660-001	Adults and Children Acoustic Report	20/04/2012		7		22/05/2012	BMCE-TRANSMIT-008987	12/06/2012	11/05/2012	B	BMCE-TRANSMIT-008987 22/05/12		12/04/2013	10		BMCE-TRANSMIT-015137 16/04/2013	30/04/2013	07/05/2013	A	BMCE-TRANSMIT-015137 16/04/2013																	
			ALC	ALC-S2-SL-OC-660-002	Adult Acoustic Design Report	20/04/2012		4		22/05/2012	BMCE-TRANSMIT-008987	12/06/2012	11/05/2012	C	BMCE-TRANSMIT-008987 22/05/12		16/12/2012	5		BMCE-TRANSMIT-012915 14/12/2012	04/01/2013	21/02/2013	B	BMCE-TRANSMIT-014306 12/03/2013		12/04/2013	6		BMCE-TRANSMIT-015137 16/04/2013	30/04/2013	07/05/2013	A	BMCE-TRANSMIT-015137 16/04/2013								
			ALC	ALC-EC-XX-OC-660-001-01	Energy Centre Acoustic Report	20/04/2012		8		22/05/2012	BMCE-TRANSMIT-008987	12/06/2012	11/05/2012	B	BMCE-TRANSMIT-008987 22/05/12																										
			ALC	ALC-S2-SL-OC-660-004	Auditorium Room Acoustic Brief	20/04/2012		3		22/05/2012	BMCE-TRANSMIT-008987	12/06/2012	11/05/2012	B	BMCE-TRANSMIT-008987 22/05/12		12/04/2013	3		BMCE-TRANSMIT-015137 16/04/2013	30/04/2013	29/07/2013	B	BMCE-TRANSMIT-015137 16/04/2013																	
			ALC	ALC-S2-SL-OC-660-005	Adults & Children Building - Draft Acoustic Test Programme		14/05/2013	6		20/05/2013	BMCE-TRANSMIT-015005	03/06/2013	02/07/2013	B	BMCE-TRANSMIT-016004 05/07/2013		05/06/2013	1		BMCE-TRANSMIT-017216 15/06/2013	29/06/2013	16/09/2013	B	BMCE-TRANSMIT-017021 25/09/2013		24/03/2014	3		BMCE-TRANSMIT-015147 24/03/2014	07/04/2014											
			ALC	ALC-S2-SL-OC-660-006	Adults & Children Building - Acoustic Test Programme Local on Markings		28/05/2013	6		04/07/2013	BMCE-TRANSMIT-016036	20/07/2013	29/07/2013	B	BMCE-TRANSMIT-017226 12/08/2013		05/06/2013	1		BMCE-TRANSMIT-017216 15/06/2013	29/06/2013	16/09/2013	A	BMCE-TRANSMIT-017021 25/09/2013																	

RDD MASTER SCHEDULE - NHS Greater Glasgow & Clyde / New South Glasgow Hospitals (NSGH) Project - Adults & Childrens Hospital												Drawing Information												Brookfield Multiplex Europe		
26	BCL-AC-XX-SH-001					1st Submission										2nd Submission										OVERDUE
			Action By	Drawing Number	Drawing Title	Date Required from Consultant	Date Submitted by Consultant	Document Revision	Planned Date to be Submitted to Board	Date Submitted to Board	Date Response Required from Board (+3 Weeks)	Date Returned from Board	Board Status	Date returned to Consultant	Date Required from Consultant	Date Submitted by Consultant	Document Revision	Planned Date to be Submitted to Board	Date Submitted to Board	Date Response Required from Board (+2 Weeks)	Date Received from Board	Board Status	Date Returned to Consultant	OVERDUE		
Item	Submission		Comments																							
General Joinery			Colour, Service Layout, Maintenance, Lifecycle, H & S																							
				NA-SP-L10	Windows-Rooflights-Screens-Louvres		02/04/2013	13		BMCE-TRANSMIT-015426 19/04/2013	10/05/2013	19/06/2013	A	BMCE-TRANSMIT-016560 01/07/2013												
				NA-SP-P20	Unframed Isolated Trim-Skirting-Sundry Items		08/03/2012	5		BMCE-TRANSMIT-009608 29/06/2012	20/07/2012	09/11/2012	B	BMCE-TRANSMIT-012217 12/11/2012												
				NA-SP-N10	General Fixtures Furnishings Equipment		30/04/2012	2		BMCE-TRANSMIT-009780 11/07/2012	31/07/2012	22/11/2012	B	BMCE-TRANSMIT-012774 05/12/2012		10/01/2013	4		BMCE-TRANSMIT-013570 28/01/2013	11/02/2013		B	BMCE-TRANSMIT-013879 12/02/2013			
				NA-SH-321-203	Internal Glazed Screen Schedule - Lightwells		02/04/2013	1		BMCE-TRANSMIT-015426 19/04/2013	10/05/2013	19/06/2013	B	BMCE-TRANSMIT-016560 01/07/2013												
				NA-XX-XX-DT-321-002	Internal Glazes Screen Schedule - Lightwells		02/04/2013	B		BMCE-TRANSMIT-015426 19/04/2013	10/05/2013	19/06/2013	A	BMCE-TRANSMIT-016560 01/07/2013												
				NA-SZ-SL-DT-321-529	Window Cill Details Type 1		08/03/2012	1		BMCE-TRANSMIT-009608 29/06/2012	20/07/2012	22/11/2012	B	BMCE-TRANSMIT-012451 12/11/2012												
				NA-SZ-SL-DT-321-530	Window Cill Details Type 2		08/03/2012	1		BMCE-TRANSMIT-009608 29/06/2012	20/07/2012	22/11/2012	B	BMCE-TRANSMIT-012451 12/11/2012												
				NA-SZ-SL-DT-321-531	Window Cill Details Type 3		08/03/2012	1		BMCE-TRANSMIT-009608 29/06/2012	20/07/2012	22/11/2012	B	BMCE-TRANSMIT-012451 12/11/2012												
				NA-XX-XX-DT-322-701	Lightwell 1 Screens		02/04/2013	2		BMCE-TRANSMIT-015426 19/04/2013	10/05/2013	19/06/2013	A	BMCE-TRANSMIT-016560 01/07/2013												
				NA-XX-XX-DT-322-702	Lightwell 2 Screens		02/04/2013	2		BMCE-TRANSMIT-015426 19/04/2013	10/05/2013	19/06/2013	A	BMCE-TRANSMIT-016560 01/07/2013												
				NA-XX-XX-DT-322-703	Lightwell 3 Screens		02/04/2013	2		BMCE-TRANSMIT-015426 19/04/2013	10/05/2013	19/06/2013	A	BMCE-TRANSMIT-016560 01/07/2013												
				NA-XX-XX-DT-400-500	Group 2 Equipment Dimensions		09/01/2013	1		BMCE-TRANSMIT-013324 15/01/2013	05/02/2013		B	BMCE-TRANSMIT-013324 15/01/2013												
				NA-XX-XX-DT-400-501	Group 2 Equipment Dimensions		09/01/2013	1		BMCE-TRANSMIT-013324 15/01/2013	05/02/2013		B	BMCE-TRANSMIT-013324 15/01/2013												
				NA-XX-XX-DT-400-502	Group 2 Equipment Dimensions		09/01/2013	1		BMCE-TRANSMIT-013324 15/01/2013	05/02/2013		B	BMCE-TRANSMIT-013324 15/01/2013												

[illegible]

[illegible]

[illegible]

[illegible]

© 2006 The Authors
Journal compilation © 2006 Blackwell Publishing Ltd

OVERDUE
OVERDUE

[illegible]

38 - Hoists	654	02/05/2014

38 - Hoists

RDD MASTER SCHEDULE - NHS Greater Glasgow & Clyde / New South Glasgow Hospitals (NSGH) Project - Adults & Childrens Hospital														Brookfield Multiplex Europe																						
6	BCL-AC-XX-SH-001													1st Submission											2nd Submission											OVERDUE
	Action By	Drawing Number	Drawing Title	Date Required from Consultant	Date Submitted by Consultant	Document Revision	Planned Date to be Submitted to Board	Date Submitted to Board	Date Response Required from Board (+3 Weeks)	Date Returned from Board	Board Status	Date returned to Consultant	Date Required from Consultant	Date Submitted by Consultant	Document Revision	Planned Date to be Submitted to Board	Date Submitted to Board	BMCE Transmittal No	Date Response Required from Board (+2 Weeks)	Date Received from Board	Board Status	Date Returned to Consultant	OVERDUE													
Item	Submission	Comments																																		

38 - Hoists

RDD MASTER SCHEDULE - NHS Greater Glasgow & Clyde / New South Glasgow Hospitals (NSGH) Project - Adults & Childrens Hospital														Brookfield Multiplex Europe											
6	BCL-AC-XX-SH-001					1st Submission								2nd Submission										OVERDUE	
			Action By	Drawing Number	Drawing Title	Date Required from Consultant	Date Submitted by Consultant	Document Revision	Planned Date to be Submitted to Board	Date Submitted to Board	Date Response Required from Board (+3 Weeks)	Date Returned from Board	Board Status	Date returned to Consultant	Date Required from Consultant	Date Submitted by Consultant	Document Revision	Planned Date to be Submitted to Board	Date Submitted to Board	BMCE Transmittal No	Date Response Required from Board (+2 Weeks)	Date Received from Board	Board Status	Date Returned to Consultant	OVERDUE
Item	Submission	Comments																							

RDD MASTER SCHEDULE - NHS Greater Glasgow & Clyde / New South Glasgow Hospitals (NSGH) P

BCL-AC-XX-SH-001

			Action By	Drawing Number
Item	Submission	Comments		
Catering Equipment				
			CDS	CDS-XX-XX-DC-430-90113
			CDS	CDS-XX-XX-DC-430-90243
			CDS	CDS-XX-XX-DC-430-90502
			CDS	CDS-XX-XX-DC-430-90503
			CDS	CDS-XX-XX-DC-430-90514
			CDS	CDS-XX-XX-DC-430-90515
			CDS	CDS-XX-XX-DC-430-90516
			CDS	CDS-XX-XX-DC-430-90519
			CDS	CDS-XX-XX-DC-430-90521
			CDS	CDS-XX-XX-DC-430-90529
			CDS	CDS-XX-XX-DC-430-90541
			CDS	CDS-XX-XX-DC-430-90542
		This was issued to board in meeting - Theses were never issued via aconex for Review	CDS	CDS-XX-XX-PL-430-900
		This was issued to board in meeting - Theses were never issued via aconex for Review	CDS	CDS-XX-XX-PL-524-010
		This was issued to board in meeting - Theses were never issued via aconex for Review	CDS	CDS-XX-XX-SH-524-522

		This was issued to board in meeting - Theses were never issued via aconex for Review	CDS	CDS-ZB-01-PL-430-016
		This was issued to board in meeting - Theses were never issued via aconex for Review	CDS	CDS-ZB-01-PL-430-017
		This was issued to board in meeting - Theses were never issued via aconex for Review	CDS	CDS-ZB-01-SH-430-508
		This was issued to board in meeting - Theses were never issued via aconex for Review	CDS	CDS-ZB-02-PL-430-022
		This was issued to board in meeting - Theses were never issued via aconex for Review	CDS	CDS-ZB-02-PL-430-023
		This was issued to board in meeting - Theses were never issued via aconex for Review	CDS	CDS-ZB-02-SH-430-511
		This was issued to board in meeting - Theses were never issued via aconex for Review	CDS	CDS-ZB-03-PL-430-024
		This was issued to board in meeting - Theses were never issued via aconex for Review	CDS	CDS-ZB-03-PL-430-025
		This was issued to board in meeting - Theses were never issued via aconex for Review	CDS	CDS-ZB-03-SH-430-512
		This was issued to board in meeting - Theses were never issued via aconex for Review	CDS	CDS-ZB-B1-PL-430-005
		This was issued to board in meeting - Theses were never issued via aconex for Review	CDS	CDS-ZB-B1-PL-430-007
		This was issued to board in meeting - Theses were never issued via aconex for Review	CDS	CDS-ZB-B1-PL-430-044
		This was issued to board in meeting - Theses were never issued via aconex for Review	CDS	CDS-ZB-B1-PL-430-045
		This was issued to board in meeting - Theses were never issued via aconex for Review	CDS	CDS-ZB-B1-PL-430-046
		This was issued to board in meeting - Theses were never issued via aconex for Review	CDS	CDS-ZB-B1-PL-430-047
		This was issued to board in meeting - Theses were never issued via aconex for Review	CDS	CDS-ZB-B1-PL-430-048
		This was issued to board in meeting - Theses were never issued via aconex for Review	CDS	CDS-ZB-B1-PL-430-049
		This was issued to board in meeting - Theses were never issued via aconex for Review	CDS	CDS-ZB-B1-PL-430-050
		This was issued to board in meeting - Theses were never issued via aconex for Review	CDS	CDS-ZB-B1-PL-430-051
		This was issued to board in meeting - Theses were never issued via aconex for Review	CDS	CDS-ZB-B1-PL-430-052
		This was issued to board in meeting - Theses were never issued via aconex for Review	CDS	CDS-ZB-B1-PL-430-053

		This was issued to board in meeting - Theses were never issued via aconex for Review	CDS	CDS-ZB-B1-PL-430-054
		This was issued to board in meeting - Theses were never issued via aconex for Review	CDS	CDS-ZB-B1-PL-430-055
		This was issued to board in meeting - Theses were never issued via aconex for Review	CDS	CDS-ZB-B1-PL-430-056
		This was issued to board in meeting - Theses were never issued via aconex for Review	CDS	CDS-ZB-B1-PL-430-057
		This was issued to board in meeting - Theses were never issued via aconex for Review	CDS	CDS-ZB-B1-PL-430-058
		This was issued to board in meeting - Theses were never issued via aconex for Review	CDS	CDS-ZB-B1-PL-430-059
		This was issued to board in meeting - Theses were never issued via aconex for Review	CDS	CDS-ZB-B1-PL-430-071
		This was issued to board in meeting - Theses were never issued via aconex for Review	CDS	CDS-ZB-B1-PL-524-013
		This was issued to board in meeting - Theses were never issued via aconex for Review	CDS	CDS-ZB-B1-SH-430-505
		This was issued to board in meeting - Theses were never issued via aconex for Review	CDS	CDS-ZB-B1-SH-524-525
		This was issued to board in meeting - Theses were never issued via aconex for Review	CDS	CDS-ZC-04-PL-430-026
		This was issued to board in meeting - Theses were never issued via aconex for Review	CDS	CDS-ZC-04-PL-430-027
		This was issued to board in meeting - Theses were never issued via aconex for Review	CDS	CDS-ZC-04-SH-430-513
		This was issued to board in meeting - Theses were never issued via aconex for Review	CDS	CDS-ZD-01-PL-430-018
		This was issued to board in meeting - Theses were never issued via aconex for Review	CDS	CDS-ZD-01-PL-430-019
		This was issued to board in meeting - Theses were never issued via aconex for Review	CDS	CDS-ZD-01-SH-430-509
		This was issued to board in meeting - Theses were never issued via aconex for Review	CDS	CDS-ZF-01-PL-430-003
		This was issued to board in meeting - Theses were never issued via aconex for Review	CDS	CDS-ZF-01-PL-430-060
		This was issued to board in meeting - Theses were never issued via aconex for Review	CDS	CDS-ZF-01-PL-430-061
		This was issued to board in meeting - Theses were never issued via aconex for Review	CDS	CDS-ZF-01-PL-430-062
		This was issued to board in meeting - Theses were never issued via aconex for Review	CDS	CDS-ZF-01-PL-430-063

		This was issued to board in meeting - Theses were never issued via aconex for Review	CDS	CDS-ZF-01-PL-430-064
		This was issued to board in meeting - Theses were never issued via aconex for Review	CDS	CDS-ZF-01-PL-430-065
		This was issued to board in meeting - Theses were never issued via aconex for Review	CDS	CDS-ZF-01-PL-430-069
		This was issued to board in meeting - Theses were never issued via aconex for Review	CDS	CDS-ZF-01-PL-524-011
		This was issued to board in meeting - Theses were never issued via aconex for Review	CDS	CDS-ZF-01-PL-524-012
		This was issued to board in meeting - Theses were never issued via aconex for Review	CDS	CDS-ZF-01-SH-430-503
		This was issued to board in meeting - Theses were never issued via aconex for Review	CDS	CDS-ZF-01-SH-524-523
		This was issued to board in meeting - Theses were never issued via aconex for Review	CDS	CDS-ZF-01-SH-524-524
		This was issued to board in meeting - Theses were never issued via aconex for Review	CDS	CDS-ZH-00-PL-430-008
		This was issued to board in meeting - Theses were never issued via aconex for Review	CDS	CDS-ZH-00-PL-430-009
		This was issued to board in meeting - Theses were never issued via aconex for Review	CDS	CDS-ZH-00-SH-430-506
		This was issued to board in meeting - Theses were never issued via aconex for Review	CDS	CDS-ZH001-PL-430-014
		This was issued to board in meeting - Theses were never issued via aconex for Review	CDS	CDS-ZH-01-PL-430-015
		This was issued to board in meeting - Theses were never issued via aconex for Review	CDS	CDS-ZH-01-SH-430-507
		This was issued to board in meeting - Theses were never issued via aconex for Review	CDS	CDS-ZJ-02-PL-430-020
		This was issued to board in meeting - Theses were never issued via aconex for Review	CDS	CDS-02-PL-430-021
		This was issued to board in meeting - Theses were never issued via aconex for Review	CDS	CDS-ZJ-02-SH-430-510
		This was issued to board in meeting - Theses were never issued via aconex for Review	CDS	CDS-ZK001-PL-430-004
		This was issued to board in meeting - Theses were never issued via aconex for Review	CDS	CDS-ZK-01-PL-430-066
		This was issued to board in meeting - Theses were never issued via aconex for Review	CDS	CDS-ZK-01-PL-430-067
		This was issued to board in meeting - Theses were never issued via aconex for Review	CDS	CDS-ZK-01-PL-430-068

		This was issued to board in meeting - Theses were never issued via aconex for Review	CDS	CDS-ZK-01-PL-430-070
		This was issued to board in meeting - Theses were never issued via aconex for Review	CDS	CDS-ZK-01-SH-430-504
		This was issued to board in meeting - Theses were never issued via aconex for Review	CDS	CDS-ZK-04-PL-430-028
		This was issued to board in meeting - Theses were never issued via aconex for Review	CDS	CDS-ZK-04-PL-460-029
		This was issued to board in meeting - Theses were never issued via aconex for Review	CDS	CDS-ZK-04-SH-430-514
		This was issued to board in meeting - Theses were never issued via aconex for Review	CDS	CDS-ZK-04-PL-430-030
		This was issued to board in meeting - Theses were never issued via aconex for Review	CDS	CDS-ZK-05-PL-430-031
		This was issued to board in meeting - Theses were never issued via aconex for Review	CDS	CDS-ZK-05-SH-430-515
		This was issued to board in meeting - Theses were never issued via aconex for Review	CDS	CDS-ZK-06-PL-430-032
		This was issued to board in meeting - Theses were never issued via aconex for Review	CDS	CDS-ZK-06-PL-430-033
		This was issued to board in meeting - Theses were never issued via aconex for Review	CDS	CDS-ZK-06-SH-430-516
		This was issued to board in meeting - Theses were never issued via aconex for Review	CDS	CDS-ZK-07-PL-430-034
		This was issued to board in meeting - Theses were never issued via aconex for Review	CDS	CDS-ZK-07-PL-430-035
		This was issued to board in meeting - Theses were never issued via aconex for Review	CDS	CDS-ZK-07-SH-430-517
		This was issued to board in meeting - Theses were never issued via aconex for Review	CDS	CDS-ZK-08-PL-430-036
		This was issued to board in meeting - Theses were never issued via aconex for Review	CDS	CDS-ZK-08-PL-430-037
		This was issued to board in meeting - Theses were never issued via aconex for Review	CDS	CDS-ZK-08-SH-430-518
		This was issued to board in meeting - Theses were never issued via aconex for Review	CDS	CDS-ZK-09-PL-430-038
		This was issued to board in meeting - Theses were never issued via aconex for Review	CDS	CDS-ZK-09-PL-430-039
		This was issued to board in meeting - Theses were never issued via aconex for Review	CDS	CDS-ZK-09-SH-430-519
		This was issued to board in meeting - Theses were never issued via aconex for Review	CDS	CDS-ZK-10-PL-430-040

		This was issued to board in meeting - Theses were never issued via aconex for Review	CDS	CDS-ZK-10-PL-430-041
		This was issued to board in meeting - Theses were never issued via aconex for Review	CDS	CDS-ZK-10-SH-430-520
		This was issued to board in meeting - Theses were never issued via aconex for Review	CDS	CDS-ZK-11-PL-430-042
		This was issued to board in meeting - Theses were never issued via aconex for Review	CDS	CDS-ZK-11-PL-430-043
		This was issued to board in meeting - Theses were never issued via aconex for Review	CDS	CDS-ZK-11-SH-430-521
		This was issued to board in meeting - Theses were never issued via aconex for Review	CDS	CDS-XX-XX-DC-430-90101
		This was issued to board in meeting - Theses were never issued via aconex for Review	CDS	CDS-XX-XX-DC-430-90102
		This was issued to board in meeting - Theses were never issued via aconex for Review	CDS	CDS-XX-XX-DC-430-90103
		This was issued to board in meeting - Theses were never issued via aconex for Review	CDS	CDS-XX-XX-DC-430-90104
		This was issued to board in meeting - Theses were never issued via aconex for Review	CDS	CDS-XX-XX-DC-430-90105
		This was issued to board in meeting - Theses were never issued via aconex for Review	CDS	CDS-XX-XX-DC-430-90106
		This was issued to board in meeting - Theses were never issued via aconex for Review	CDS	CDS-XX-XX-DC-430-90107
		This was issued to board in meeting - Theses were never issued via aconex for Review	CDS	CDS-XX-XX-DC-430-90108
		This was issued to board in meeting - Theses were never issued via aconex for Review	CDS	CDS-XX-XX-DC-430-90109
		This was issued to board in meeting - Theses were never issued via aconex for Review	CDS	CDS-XX-XX-DC-430-90110
		This was issued to board in meeting - Theses were never issued via aconex for Review	CDS	CDS-XX-XX-DC-430-90111

		This was issued to board in meeting - Theses were never issued via aconex for Review	CDS	CDS-XX-XX-DC-430-90112
		This was issued to board in meeting - Theses were never issued via aconex for Review	CDS	CDS-XX-XX-DC-430-90201
		This was issued to board in meeting - Theses were never issued via aconex for Review	CDS	CDS-XX-XX-DC-430-90202
		This was issued to board in meeting - Theses were never issued via aconex for Review	CDS	CDS-XX-XX-DC-430-90203
		This was issued to board in meeting - Theses were never issued via aconex for Review	CDS	CDS-XX-XX-DC-430-90204
		This was issued to board in meeting - Theses were never issued via aconex for Review	CDS	CDS-XX-XX-DC-430-90205
		This was issued to board in meeting - Theses were never issued via aconex for Review	CDS	CDS-XX-XX-DC-430-90206
		This was issued to board in meeting - Theses were never issued via aconex for Review	CDS	CDS-XX-XX-DC-430-90207
		This was issued to board in meeting - Theses were never issued via aconex for Review	CDS	CDS-XX-XX-DC-430-90208
		This was issued to board in meeting - Theses were never issued via aconex for Review	CDS	CDS-XX-XX-DC-430-90209
		This was issued to board in meeting - Theses were never issued via aconex for Review	CDS	CDS-XX-XX-DC-430-90210
		This was issued to board in meeting - Theses were never issued via aconex for Review	CDS	CDS-XX-XX-DC-430-90211
		This was issued to board in meeting - Theses were never issued via aconex for Review	CDS	CDS-XX-XX-DC-430-90212
		This was issued to board in meeting - Theses were never issued via aconex for Review	CDS	CDS-XX-XX-DC-430-90213
		This was issued to board in meeting - Theses were never issued via aconex for Review	CDS	CDS-XX-XX-DC-430-90214

		This was issued to board in meeting - Theses were never issued via aconex for Review	CDS	CDS-XX-XX-DC-430-90215
		This was issued to board in meeting - Theses were never issued via aconex for Review	CDS	CDS-XX-XX-DC-430-90216
		This was issued to board in meeting - Theses were never issued via aconex for Review	CDS	CDS-XX-XX-DC-430-90217
		This was issued to board in meeting - Theses were never issued via aconex for Review	CDS	CDS-XX-XX-DC-430-90218
		This was issued to board in meeting - Theses were never issued via aconex for Review	CDS	CDS-XX-XX-DC-430-90219
		This was issued to board in meeting - Theses were never issued via aconex for Review	CDS	CDS-XX-XX-DC-430-90220
		This was issued to board in meeting - Theses were never issued via aconex for Review	CDS	CDS-XX-XX-DC-430-90221
		This was issued to board in meeting - Theses were never issued via aconex for Review	CDS	CDS-XX-XX-DC-430-90222
		This was issued to board in meeting - Theses were never issued via aconex for Review	CDS	CDS-XX-XX-DC-430-90223
		This was issued to board in meeting - Theses were never issued via aconex for Review	CDS	CDS-XX-XX-DC-430-90224
		This was issued to board in meeting - Theses were never issued via aconex for Review	CDS	CDS-XX-XX-DC-430-90225
		This was issued to board in meeting - Theses were never issued via aconex for Review	CDS	CDS-XX-XX-DC-430-90226
		This was issued to board in meeting - Theses were never issued via aconex for Review	CDS	CDS-XX-XX-DC-430-90227
		This was issued to board in meeting - Theses were never issued via aconex for Review	CDS	CDS-XX-XX-DC-430-90228
		This was issued to board in meeting - Theses were never issued via aconex for Review	CDS	CDS-XX-XX-DC-430-90229

		This was issued to board in meeting - Theses were never issued via aconex for Review	CDS	CDS-XX-XX-DC-430-90230
		This was issued to board in meeting - Theses were never issued via aconex for Review	CDS	CDS-XX-XX-DC-430-90231
		This was issued to board in meeting - Theses were never issued via aconex for Review	CDS	CDS-XX-XX-DC-430-90232
		This was issued to board in meeting - Theses were never issued via aconex for Review	CDS	CDS-XX-XX-DC-430-90233
		This was issued to board in meeting - Theses were never issued via aconex for Review	CDS	CDS-XX-XX-DC-430-90234
		This was issued to board in meeting - Theses were never issued via aconex for Review	CDS	CDS-XX-XX-DC-430-90235
		This was issued to board in meeting - Theses were never issued via aconex for Review	CDS	CDS-XX-XX-DC-430-90236
		This was issued to board in meeting - Theses were never issued via aconex for Review	CDS	CDS-XX-XX-DC-430-90237
		This was issued to board in meeting - Theses were never issued via aconex for Review	CDS	CDS-XX-XX-DC-430-90238
		This was issued to board in meeting - Theses were never issued via aconex for Review	CDS	CDS-XX-XX-DC-430-90239
		This was issued to board in meeting - Theses were never issued via aconex for Review	CDS	CDS-XX-XX-DC-430-90240
		This was issued to board in meeting - Theses were never issued via aconex for Review	CDS	CDS-XX-XX-DC-430-90241
		This was issued to board in meeting - Theses were never issued via aconex for Review	CDS	CDS-XX-XX-DC-430-90501
		This was issued to board in meeting - Theses were never issued via aconex for Review	CDS	CDS-XX-XX-DC-430-90504
		This was issued to board in meeting - Theses were never issued via aconex for Review	CDS	CDS-XX-XX-DC-430-90505

		This was issued to board in meeting - Theses were never issued via aconex for Review	CDS	CDS-XX-XX-DC-430-90506
		This was issued to board in meeting - Theses were never issued via aconex for Review	CDS	CDS-XX-XX-DC-430-90507
		This was issued to board in meeting - Theses were never issued via aconex for Review	CDS	CDS-XX-XX-DC-430-90508
		This was issued to board in meeting - Theses were never issued via aconex for Review	CDS	CDS-XX-XX-DC-430-90509
		This was issued to board in meeting - Theses were never issued via aconex for Review	CDS	CDS-XX-XX-DC-430-90510
		This was issued to board in meeting - Theses were never issued via aconex for Review	CDS	CDS-XX-XX-DC-430-90511
		This was issued to board in meeting - Theses were never issued via aconex for Review	CDS	CDS-XX-XX-DC-430-90512
		This was issued to board in meeting - Theses were never issued via aconex for Review	CDS	CDS-XX-XX-DC-430-90513
		This was issued to board in meeting - Theses were never issued via aconex for Review	CDS	CDS-XX-XX-DC-430-90517
		This was issued to board in meeting - Theses were never issued via aconex for Review	CDS	CDS-XX-XX-DC-430-90518
		This was issued to board in meeting - Theses were never issued via aconex for Review	CDS	CDS-XX-XX-DC-430-90520
		This was issued to board in meeting - Theses were never issued via aconex for Review	CDS	CDS-XX-XX-DC-430-90522
		This was issued to board in meeting - Theses were never issued via aconex for Review	CDS	CDS-XX-XX-DC-430-90523
		This was issued to board in meeting - Theses were never issued via aconex for Review	CDS	CDS-XX-XX-DC-430-90525
		This was issued to board in meeting - Theses were never issued via aconex for Review	CDS	CDS-XX-XX-DC-430-90526

		This was issued to board in meeting - Theses were never issued via aconex for Review	CDS	CDS-XX-XX-DC-430-90527
		This was issued to board in meeting - Theses were never issued via aconex for Review	CDS	CDS-XX-XX-DC-430-90528
		This was issued to board in meeting - Theses were never issued via aconex for Review	CDS	CDS-XX-XX-DC-430-90530
		This was issued to board in meeting - Theses were never issued via aconex for Review	CDS	CDS-XX-XX-DC-430-90531
		This was issued to board in meeting - Theses were never issued via aconex for Review	CDS	CDS-XX-XX-DC-430-90533
		This was issued to board in meeting - Theses were never issued via aconex for Review	CDS	CDS-XX-XX-DC-430-90534
		This was issued to board in meeting - Theses were never issued via aconex for Review	CDS	CDS-XX-XX-DC-430-90535
		This was issued to board in meeting - Theses were never issued via aconex for Review	CDS	CDS-XX-XX-DC-430-90536
		This was issued to board in meeting - Theses were never issued via aconex for Review	CDS	CDS-XX-XX-DC-430-90537
		This was issued to board in meeting - Theses were never issued via aconex for Review	CDS	CDS-XX-XX-DC-430-90538
		This was issued to board in meeting - Theses were never issued via aconex for Review	CDS	CDS-XX-XX-DC-430-90539
		This was issued to board in meeting - Theses were never issued via aconex for Review	CDS	CDS-XX-XX-DC-430-90540
	CDS Equipment Data Sheets Returned to The Board 28/11/2012	These will be re-issued as Technical Submittals	BMCE- TRANSMI T 014100	
	Revised/Additional Data Sheets Issued to Board 22/02/2013	All returned as Status A	BMCE- TRANSMI T 014200	

roject - Adults & Childrens Hospital

Drawing Title	Date Required from Consultant	Date Submitted by Consultant	Document Revision	Planned Date to be Submitted to Board	Date Submitted to Board
Large Crockery Storage Cupboard			1		22/02/2013
Fire Supression System			0		22/02/2013
Moffat Fabricated Sinks			0		22/02/2013
Moffat Wall Shelves and Cupboards			0		22/02/2013
EAIS Gasttonorm Trolley			0		22/02/2013
Slingsby Bench Unit			0		22/02/2013
Rubbermaid Dunage Rack			0		22/02/2013
Karcher Pressure Washer			0		22/02/2013
Rubbermaid Undercounter Bin			0		22/02/2013
CED Cutlery Stand			0		22/02/2013
Metal Cabinet COSHH Cupboard			0		22/02/2013
Noble Fire Supression System			0		22/02/2013
Generic Services Connections			0		
Generic Regen Kitchen Extract Canopy			0		
Generic Pass Through Dishwash Extract Calculations			0		

Regen Kitchen CCW-032 General Arrangement			4		
Regen Kitchen CCW-032 Service Layout			3		
Regen Kitchen CCW-032 Equipment & Services Schedule			4		
Regen Kitchen ARU-001 General Arrangement			4		
Regen Kitchen ARU-001 Service Layout			3		
Regen Kitchen ARU-001 Equipment & Services Schedule			4		
Regen Kitchen GWS-011/012 General Arrangement			5		
Regen Kitchen GWS-011/012 Service Layout			5		
Regen Kitchen GWS-011/012 Equipment & Services Schedule			5		
Patient Catering Area General Arrangement			15		
Patient Catering Area Services Layout			12		
Patient Catering Area Diet Supplements Room Elevations			3		
Patient Catering Area Diet Production Room Elevations			3		
Patient Catering Area Hygiene Stations Room Elevations			3		
Patient Catering Area Stationery Menus Room Elevations			2		
Patient Catering Area Meal Picking & Packing			4		
Patient Catering Area Freezer Room			2		
Patient Catering Area General Provisions			3		
Patient Catering Area Equipment & Disposable Store Room			2		
Patient Catering Area PPE Store Room			2		
Patient Entertainment Area COSHH Store Room			2		

Patient Entertainment Area Milk/Dairy Store Room			2		
Patient Catering Area Processed Foods Room			3		
Patient Catering Area Fruit & Salad Store Room			2		
Patient Catering Area Condensers			0		
Patient Catering Area Colroom Controls			2		
Patient Catering Area Trolley Wash & Typical Corridor Elevations			2		
Patient Catering Area Meal Assembly			3		
Patient Catering Area Diet Prep Extract Canopy			0		
Patient Catering Area Equipment & Services Schedule			8		
Patient Catering Area Diet Prep Canopy Extract Calculations			0		
Regen Kitchen DCFP-049 General Arrangement			4		
Regen Kitchen DCFP-049 Services Layout			4		
Regen Kitchen DCFP-049 Equipment & Services Schedule			4		
Regen Kitchen CCU-073 General Arrangement			4		
Regen Kitchen CCU-073 Services Layout			3		
Regen Kitchen CCU-073 Equipment & Services Schedule			4		
Main Restaurant General Arrangement			17		
Main Restaurant Services Layout			4		
Main Restaurant Main Kitchens Elevations			5		
Main Restaurant Dishwash Elevations			5		
Main Restaurant Freezer Store Elevations			3		

Main Restaurant Dry Store/Disposables Elevations			3		
Main Restaurant Store Elevations			2		
Main Restaurant Services Layout			6		
Main Restaurant Cooking Island			0		
Main Restaurant Dishwash Area			0		
Main Restaurant Equipment and Services Schedule			10		
Main Kitchen Canopy Extract Calculations			0		
Dishwash Canopy Extract Calculations			0		
Regen Kitchen AAW-160/161 General Arrangement			4		
Regen Kitchen AAW-160/161 services Layout			5		
Regen Kitchen AAW-160/161 Equipment & Services Schedule			4		
Regen Kitchen STW-042 General Arrangement			6		
Regen Kitchen STW-042 Services Layout			5		
Regen Kitchen STW-042 Equipment Services Schedule			4		
Regen Kitchen DMW-083 General Arrangement			4		
Regen Kitchen DMW-083 Services Layout			3		
Regen Kitchen DMQ-083 Equipment & Services Schedule			4		
Coffee Shop General Arrangement			13		
Coffee Shop Served Elevations			4		
Coffee Shop Wash Up Elevations			6		
Coffee Shop Food Store Elevations			3		

Coffee Shop Services Layout			7		
Coffee Shop Equipment and Services Schedule			6		
Regen Kitchen WS4-013/014 General Arrangement			5		
Regen Kitchen WS4-013/014 Services Layout			5		
Regen Kitchen WS4-013/14 Equipment and services schedule			4		
Regen Kitchen WS5-017/017 General Arrangement			6		
Regen Kitchen WS5-017/018 Service Layout			6		
Regen Kitchen WS5-017/018 Equipment & Services Schedule			4		
Regen Kitchen WS6-017/018 General Arrangement			6		
Regen Kitchen WS6-017/018 Services Layout			6		
Regen Kitchen WS6-017/018 Equipment & Services Schedule			4		
Regen Kitchen WS7-017/018 General Arrangement			5		
Regen Kitchen WS7-017/018 Services Layout			6		
Regen Kitchen WS7-017/018 Equipment & Services Schedule			4		
Regen Kitchen WS8-017/018 General Arrangement			7		
Regen Kitchen WS7-017/018 Services Layout			6		
Regen Kitchen WS8-017/018 Equipment & Services Schedule			5		
Regen Kitchen WS9-017/018 General Arrangement			8		
Regen Kitchen WS9-017/018 Services Layout			7		
Regen Kitchen WS9-017/018 Equipment & Services Schedule			5		
Regen Kitchen WS10-017/018 General Arrangement			8		

Regen Kicthen WS10-017/018 Services Layout			7		
Regen Kitchen WS10-017/018 Equipment & Services Schedule			6		
Regen Kitchen WS11-017/018 General Arrangement			7		
Regen Kitchen WS11-017/018 Services Layout			6		
Regen Kicthen WS11-017/018 Equipment & Services Schedule			6		
Wall & Centre benches			1		
sink units			1		
walls shelves			0		
wall cupboards			0		
service riser			0		
dishwasher canopies			0		
small crockery storage cupboard			1		
cleans dishwash table			1		
dirtyes dishwash table			1		
admin office table			1		
walk in cold rooms			1		

crookline extract canopies			0		
upright double door freezer			0		
upright single door freezer			0		
upright double door			0		
blast chiller			0		
insect killer			0		
microwave oven			0		
4 tier static racking			0		
high denisty racking			0		
front loading disjwaser			0		
transport trolley			0		
mobile storage unit			0		
bench unit with coat hooks			0		
dunage rack for bread store			0		
wall mpunted water boiler			0		

table top water boiler			0		
pressure washer			0		
undercounter refrigerator			0		
undercounter waste bin			0		
plate lowerator twin stack			0		
conveyor toaster			0		
pass through dishwasher			0		
admin office table			1		
plate lowerator single stack			0		
electirc twin plan fryer			0		
electric hob cook top			0		
electric boiling pan			0		
electric steamer			0		
cutlery stand			0		
undercounter 3 door refrigerator			0		

undercounter freezer			0		
clearing trolley			0		
jacket potato oven			0		
double panini grill			0		
gas grill			0		
gas open top range			0		
gas solid top range			0		
rack dishwasher			0		
refrigerated salad prep counter			0		
refrigerated multitask display			0		
10 grid combi oven			0		
20 grid combo oven			0		
Moffat fabricated tables			0		
Foster walk in cold rooms			0		
upright double door freezer			0		

upright single door freezer			0		
upright double door refrigerator			0		
blast chiller			0		
insect killer			0		
panasonic microwave			0		
storage racking			0		
from loading dishwasher			0		
trolley units			0		
wall mounted water boiler			0		
table top water boiler			0		
undercounter single door refrigerator			0		
conveyor toaster			0		
pass through dishwasher			0		
twin pan fryer			0		
hob cook top			0		

boiling pan			0		
steamer			0		
3 door refrigerator			0		
single door freezer			0		
jacket potato oven			0		
double panini grill			0		
gas grill			0		
gas range			0		
rack dishwasher			0		
salad prep refrigerator			0		
retail display			0		
self cook combination oven			0		

1st Submission					
BMCE-TRANSMITTIAL NUMBER	Date Response Required from Board (+3 Weeks)	Date Returned from Board	Board Status	Date returned to Consultant	Date Required from Consultant
BMCE-TRANSMIT-014116	15/03/2013	25/03/2013	A	26/03/13 BMCE- TRANSMIT-014809	
BMCE-TRANSMIT-014116	15/03/2013	25/03/2013	A	26/03/13 BMCE- TRANSMIT-014809	
			B		
			A		
			A		

			B		
			B		
			A		
			B		
			B		
			A		
			B		
			B		
			A		
			B		
			B		
			A		
			A		
			B		
			A		
			A		
			B		
			A		
			A		
			A		
			A		

			A		
			B		
			A		
			B		
			A		
			A		
			B		
			B		
			A		
			B		
			B		
			B		
			A		
			B		

			A		
			A		
			A		
			B		
			B		
			B		
			A		
			A		
			B		
			B		
			A		
			B		
			B		
			A		
			B		
			B		
			A		
			B		
			B		
			A		
			A		

[illegible]

[illegible]

[illegible]

[illegible]

[illegible]

[illegible]

			A	21/02/2013 BMCE-TRANSMIT-014100	
			A	21/02/2013 BMCE-TRANSMIT-014100	
tion

[illegible]

[illegible]

Brookfield Multiplex Europe

[illegible]

[illegible]

RDD MASTER SCHEDULE - NHS Greater Glasgow & Clyde / New South Glasgow Hospitals (NSGH) Project - Car Park			
41			
1st Submissio			
Comments	Action By	Zone	Drawing Number
	FES		149-RA-FES-001
Issued for information on BMCE-TRANSMIT-018486 13/11/13	FES		FES-CP-00-PL-500-001
Issued for information on BMCE-TRANSMIT-018486 13/11/13	FES		FES-CP-00-PL-524-001
	FES		FES-CP-00-SE-530-001
	FES		FES-CP-XX-PL-530-001
	FES		FES-CP-00-PL-531-001
	FES		FES-CP-01-PL-531-001

	FES		FES-CP-02-PL-531-001_00
	FES		FES-CP-03-PL-531-001
	FES		FES-CP-04-PL-531-001
	FES		FES-CP-05-PL-531-001
	FES		FES-CP-06-PL-531-001
	FES		FES-CP-XX-SC-532-001
	FES		FES-CP-XX-DT-532-001
	FES		FES-CP-00-SC-533-001
	FES		FES-CP-01-PL-533-001
	FES		FES-CP-02-PL-533-001
	FES		FES-CP-03-PL-533-001_00
	FES		FES-CP-04-PL-533-001
	FES		FES-CP-05-PL-533-001

	FES		FES-CP-06-PL-533-001
	FES		FES-CP-00-PL-541-001_00
	FES		FES-CP-01-PL-541-001_00
	FES		FES-CP-02-PL-541-001_00
	FES		FES-CP-03-PL-541-001
	FES		FES-CP-04-PL-541-001
	FES		FES-CP-05-PL-541-001
	FES		FES-CP-06-PL-541-001
	FES		FES-CP-XX-SC-541-001
	FES		FES-CP-XX-SC-571-001_00
Issued for information on BMCE-TRANSMIT-018486 13/11/13	FES		FES-CP-00-PL-572-001
Issued for information on BMCE-TRANSMIT-018486 13/11/13	FES		FES-CP-00-PL-572-002

Issued for information on BMCE-TRANSMIT-018486 13/11/13	FES		FES-CP-01-PL-572-001
Issued for information on BMCE-TRANSMIT-018486 13/11/13	FES		FES-CP-02-PL-572-001
Issued for information on BMCE-TRANSMIT-018486 13/11/13	FES		FES-CP-03-PL-572-001
Issued for information on BMCE-TRANSMIT-018486 13/11/13	FES		FES-CP-04-PL-572-001
Issued for information on BMCE-TRANSMIT-018486 13/11/13	FES		FES-CP-05-PL-572-001
Issued for information on BMCE-TRANSMIT-018486 13/11/13	FES		FES-CP-06-PL-572-001
	FES		FES-CP-XX-SC-572-001
	FES		FES-CP-XX-SC-572-002
Issued for information on BMCE-TRANSMIT-018486 13/11/13	FES		FES-CP-XX-SC-572-003
Drawing no longer in use	FES		~~FES-CP-XX-PL-574-002~~
	FES		FES-CP-00-PL-579-001
	FES		FES-CP-06-PL-579-001

	FES		FES-CP-00-PL-581-001
Issued for information on BMCE-TRANSMIT-018486 13/11/13	FES		FES-CP-00-PL-591-001_00
	FES		FES-CP-01-PL-591-001
	FES		FES-CP-02-PL-591-001
	FES		FES-CP-03-PL-591-001
	FES		FES-CP-04-PL-591-001
	FES		FES-CP-05-PL-591-001
	FES		FES-CP-06-PL-591-001
	FES		FES-CP-XX-PL-700-001
	FES		FES-CP-XX-PL-700-002
Technical Submission	FES		FES-CP-XX-TS-001
	FES		FES-CP-XX-TS-002

	FES		FES-CP-XX-TS-003
	FES		FES-CP-XX-TS-004
	FES		FES-CP-XX-TS-005
	WSP		
			WSP-CP-XX-SP-200-010
			WSP-AB-XX-SE-200-344
			WSP-CP-XX-DT-210-329
			WSP-CP-00-PL-210-101
			WSP-CP-00-PL-210-102
			WSP-CP-00-PL-210-103
			WSP-CP-00-PL-220-201
			WSP-CP-00-PL-220-202

			WSP-CP-00-PL-220-203
			WSP-CP-01-PL-220-201
			WSP-CP-02-PL-220-201
			WSP-CP-03-PL-220-202
			WSP-CP-03-PL-220-203
			WSP-CP-04-PL-220-203
			WSP-CP-03-PL-220-203
			WSP-CP-XX-PL-220-201
			WSP-CP-XX-PL-220-202
			WSP-CP-00-DT-220-204
			WSP-CP-XX-260-001
			WSP-CP-XX-260-401
			WSP-CP-XX-260-402

			WSP-CP-00-PL-581-001
			WSP-CP-01-PL-581-001
			WSP-CP-02-PL-581-001
			WSP-CP-03-PL-581-001
			WSP-CP-04-PL-581-001
			WSP-CP-05-PL-581-001
			WSP-CP-06-PL-581-001
			WSP-CP-XX-PL-713-001
			WSP-CP-XX-PL-713-301
			WSP-CP-XX-DT-714-201
			WSP-CP-XX-DT-714-202
			WSP-CP-XX-PL-771-001

	HYPOSTYLE		
			HYP-CP-00-PL-220-110
			HYP-CP-01-PL-220-111
			HYP-CP-02-PL-220-112
			HYP-CP-03-PL-220-113
			HYP-CP-06-PL-220-114
			HYP-CP-00-DT-230-301
			HYP-CP-XX-DT-251-001
			HYP-CP-XX-DT-251-002
			HYP-CP-XX-DT-251-003
			HYP-CP-XX-DT-251-004
			HYP-CP-XX-DT-251-005
			HYP-CP-XX-DT-251-006

			HYP-CP-XX-DT-251-009
			HYP-C--XX-DT-251-017
			HYP-CP-XX-DT-251-018
			HYP-CP-XX-DT-251-024
			HYP-CP-XX-DT-251-025
			HYP-CP-XX-DT-251-026
			HYP-CP-XX-DT-251-027
			HYP-CP-XX-DT-251-028
			HYP-CP-XX-DT-322-001
			HYP-CP-XX-DT-322-002
			HYP-CP-XX-DT-322-101
			HYP-CP-XX-DT-400-001
			HYP-CP-XX-DT-400-002

			HYP-CP-00-DT-814-001
			HYP-CP-XX-EL-251-101
			HYP-CP-XX-EL-251-102
			HYP-CP-XX-EL-321-101
			HYP-CP-XX-EL-321-102
			HYP-CP-XX-PL-210-101
			HYP-CP-XX-PL-210-102
			HYP-CP-XX-SE-260-101
	APT SKIDATA		APT-CP-00-DT-715-001

[illegible]

Drawing Title	Date Required from Consultant	Date Submitted by Consultant	Document Revision	Planned Date to be Submitted to Board	Date Submitted to Board
Risk Management Lightning protection calcs		19/06/2013	0		19/06/2013
Level 0 Water Services Layout			A		03/09/2013
Level 0 Ventilation Layout			A		03/09/2013
Electrical Containment Fixing Services			A		03/09/2013
Ground floor porters office electrical services layout			A		03/09/2013
Level 0 Small Power Services Layout			A		03/09/2013
Level 1 Small Power Services Layout			A		03/09/2013

Level 2 Small Power Services Layout			A		03/09/2013
Level 3 Small Power Services Layout			A		03/09/2013
Level 4 Small Power Services Layout			A		03/09/2013
Level 5 Small Power Services Layout			A		03/09/2013
Level 6 Small Power Services Layout			A		03/09/2013
Electrical LV Distribution Single Line Schematic Diagram			A		03/09/2013
Proposed MV/LV Switchrooms			A		03/09/2013
Level 0 Containment Services Layout			A		03/09/2013
First Floor Containment Services Layout			A		03/09/2013
Level 2 Containment Services Layout			A		03/09/2013
Level 3 Containment Services Layout			A		03/09/2013
Level 4 Containment Services Layout			A		03/09/2013
Level 5 Containment Services Layout			A		03/09/2013

Sixth Floor Containment Services Layout			A		03/09/2013
Level 0 Lighting & Emergency Lighting Services Layout			A		03/09/2013
Level 1 Lighting & Emergency Lighting Services Layout			A		03/09/2013
Level 2 Lighting & Emergency Lighting Services Layout			A		03/09/2013
Level 3 Lighting & Emergency Lighting Services Layout			A		03/09/2013
Level 4 Lighting & Emergency Lighting Services Layout			A		03/09/2013
Level 5 Lighting & Emergency Lighting Services Layout			A		03/09/2013
Level 6 Lighting & Emergency Lighting Services Layout			A		03/09/2013
Electrical services lighting controls schematic			A		13/11/2013
Electrical Services Security Systems Schematic			A		13/11/2013
Level 0 Fire Alarms & Security Layout			A		03/09/2013
Ground Floor Dry Riser Layout			A		03/09/2013

Level 1 Fire Alarms & Security Layout			A		03/09/2013
Level 2 Fire Alarms & Security Layout			A		03/09/2013
Level 3 Fire Alarms & Security Layout			A		03/09/2013
Level 4 Fire Alarms & Security Layout			A		03/09/2013
Level 5 Fire Alarms & Security Layout			A		03/09/2013
Level 6 Fire Alarms & Security Layout			A		03/09/2013
Electrical Services Fire Detection and Alarm Schematic			A		03/09/2013
CCTV System Schematic Typical System Detail			A		03/09/2013
Proposed ICT Schematic			A		03/09/2013
Dry Riser Layout					
Ground Lightning Protection		01/07/2013	0		01/07/2013
Roof Lightning Protection		01/07/2013	0		01/07/2013

Ground Floor Drainage Layout			A		03/09/2013
Level 0 Builderswork Requirements Layout			A		03/09/2013
Level 1 Builderswork Requirements Layout			A		03/09/2013
Level 2 Builderswork Requirements Layout			A		03/09/2013
Level 3 Builderswork Requirements Layout			A		03/09/2013
Level 4 Builderswork Requirements Layout			A		03/09/2013
Level 5 Builderswork Requirements Layout			B		03/09/2013
Sixth Floor BWICS			A		03/09/2013
Proposed external site services layout			B		03/09/2013
Proposed Earth farm layout			A		03/09/2013
Electric Transformers			0		05/12/2013
Disabled Refuge			1		14/04/2014

Security Installation			1		14/04/2014
Electrical Accessories			1		14/04/2014
Lighting Installation			1		14/04/2014
Car park Access Road Setting Report		07/06/2013	A		12/06/2013
Car Park Assumptions		13/01/2011	2		12/06/2013
Pilecap Reinforcement		13/06/2013	C		18/06/2013
Piling Layout - Car Park 1		04/06/2013	D		12/06/2013
Foundation Layout - Car Park 1		04/06/2013	C		12/06/2013
Ramp Setting Out		31/05/2013	1		12/06/2013
Car Park 1 Level 00 GA		17/05/2013	A		12/06/2013
Core 2 - Substructure Concrete Layout		06/06/2013	A		12/06/2013

Core 1 - Substructure Concrete		06/06/2013	1		12/06/2013
Car Park 1 Level 01 GA		26/04/2013	A		12/06/2013
Car Park 1 Level 02 GA		10/05/2013	A		12/06/2013
Levels 03-06 Above Ground Drainage		04/04/2013	1		12/06/2013
Car Park 1 Level 03 GA		10/05/2013	A		12/06/2013
Car Park 1 Level 04 & 05 GA		10/05/2013	A		12/06/2013
Car Park 1 Level 06 GA		10/05/2013	A		12/06/2013
Core 1 - Concrete Floor Plans		02/05/2013	1		12/06/2013
Core 2 - Concrete Floor Plans		30/04/2013	1		12/06/2013
Transformer Bund Reinforcement		11/10/2013	1		23/10/2013
Grid G.A		26/04/2013	A		12/06/2013
Core 1 - Steelwork Floor Plans		02/05/2013	1		12/06/2013
Core 2 - Steelwork Floor Plans		30/04/2013	1		12/06/2013

Ground Floor Plan Above ground rainwater drainage layout		29/05/2013	1		12/06/2013
First Floor Plan Above ground rainwater drainage layout		29/05/2013	1		12/06/2013
Second Floor Plan Above ground rainwater drainage layout		29/05/2013	1		12/06/2013
Third Floor Plan Above ground rainwater drainage layout		29/05/2013	1		12/06/2013
Fourth Floor Plan Above ground rainwater drainage layout		29/05/2013	1		12/06/2013
Fifth Floor Plan Above ground rainwater drainage layout		29/05/2013	1		12/06/2013
Sixth Floor Plan Above ground rainwater drainage layout		29/05/2013	1		12/06/2013
Road Layout & Geometry		07/06/2013	A		12/06/2013
Car Park 1 Cotour & Levels Layout		22/02/2013	2		12/06/2013
Car Park & Access Road Construction Details		07/06/2013	A		12/06/2013
Car Park & Access Road Construction Details		07/06/2013	A		12/06/2013
Car Park 1 Drainage Layout		10/05/2013	3		12/06/2013

Ground Floor Plan		03/07/2013	J		04/07/2013
First Floor Plan		03/07/2013	J		04/07/2013
Second Floor Plan		03/07/2013	J		04/07/2013
Third Floor Plan		03/07/2013	K		04/07/2013
Sixth Floor Plan		03/07/2013	G		04/07/2013
Proposed Substation Stairs		22/07/2013	0		24/07/2013
Stone Copes To Straight walls		22/07/2013	A		24/07/2013
Ashlar Setting Out To East Elevation		22/07/2013	B		24/07/2013
Ashlar Setting Out To North Elevation		22/07/2013	B		24/07/2013
Ashlar Setting Out To South Elevation		22/07/2013	B		24/07/2013
Ashlar Setting Out To East Elevation		22/07/2013	A		24/07/2013
Ashlar Setting Out To west Elevation Plan, Sections & Elevations		22/07/2013	B		24/07/2013

Ashlar Setting Out To West Elevation Sheet 2		28/08/2013	A		05/09/2013
Timber Clad Setting Out to West Elevation		27/01/2014	2		04/02/2014
Timber Clad Setting Out To East Elevation		07/01/2014	2		14/01/2014
Timber Clad Setting Out To East Elevation/Part South Elevation		07/01/2014	0		14/01/2014
Timber Clad Setting Out To East Elevation/Part South Elevation Showing Patterns & Pattern Layout On Elevation		07/01/2014	0		14/01/2014
Timber Clad West Elevation Individual Panel Elevations		27/01/2014	0		04/02/2014
Timber Clad Setting Out To West Elevation Louvre Pattern Set Out 1 of 2		27/01/2014	0		04/02/2014
Timber Clad Setting Out To West Elevation Louvre Pattern Set Out 2 of 2		27/01/2014	0		04/02/2014
Main Entrance Door Details		22/07/2013	0		24/07/2013
Door Types & Schedules		22/07/2013	0		24/07/2013
Door Types And Schedule		04/07/2013	0		24/07/2013
Main Entrance Door Details		22/07/2013	0		24/07/2013
Berry Barrier Details On Ground Floor		22/07/2013	0		24/07/2013

Berry Barrier Details On 1st to 5th Floors		22/07/2013	0		22/07/2013
Proposed North & South Elevations		22/07/2013	C		22/07/2013
Proposed East & West Elevations		22/07/2013	B		22/07/2013
Staircore 1 Planar Glazing & Alucobond Setting Out		22/07/2013	B		22/07/2013
Main Staircore Planar Glazing & Alucobond Setting Out		22/07/2013	B		22/07/2013
Main Staircore Floorplans & Details		22/07/2013	D		22/07/2013
Staircore 1 Floorplans & Details		22/07/2013	D		22/07/2013
Proposed Sections		22/07/2013	B		22/07/2013
Main Car Park Sign		31/01/2014	0		17/02/2014

[illegible]

BMCE Transmittal No	Date Response Required from Board	Date Returned from Board	Board Status	Date returned to Consultant	Date Required from Consultant	Date Submitted by Consultant	Document Revision
BMCE-TRANSMIT-016358 (BMCE-WTRAN-007937)	10/07/2013	28/06/2013	A	BMCE-TRANSMIT-017033			
BMCE-TRANSMIT-017567 (BMCE-WTRAN-008779)	24/09/2013	25/09/2013	B	01/10/13 BMCE-TRANSMIT-017859			
BMCE-TRANSMIT-017567 (BMCE-WTRAN-008779)	24/09/2013	25/09/2013	B	01/10/13 BMCE-TRANSMIT-017859			
BMCE-TRANSMIT-017567 (BMCE-WTRAN-008779)	24/09/2013	25/09/2013	A	01/10/13 BMCE-TRANSMIT-017859			
BMCE-TRANSMIT-017567 (BMCE-WTRAN-008779)	24/09/2013	25/09/2013	A	01/10/13 BMCE-TRANSMIT-017859			
BMCE-TRANSMIT-017567 (BMCE-WTRAN-008779)	24/09/2013	25/09/2013	B	01/10/13 BMCE-TRANSMIT-017859			C
BMCE-TRANSMIT-017567 (BMCE-WTRAN-008779)	24/09/2013	25/09/2013	A	01/10/13 BMCE-TRANSMIT-017859			

BMCE-TRANSMIT-017567 (BMCE-WTRAN-008779)	24/09/2013	25/09/2013	A	01/10/13 BMCE-TRANSMIT-017859			
BMCE-TRANSMIT-017567 (BMCE-WTRAN-008779)	24/09/2013	25/09/2013	A	01/10/13 BMCE-TRANSMIT-017859			
BMCE-TRANSMIT-017567 (BMCE-WTRAN-008779)	24/09/2013	25/09/2013	A	01/10/13 BMCE-TRANSMIT-017859			
BMCE-TRANSMIT-017567 (BMCE-WTRAN-008779)	24/09/2013	25/09/2013	A	01/10/13 BMCE-TRANSMIT-017859			
BMCE-TRANSMIT-017567 (BMCE-WTRAN-008779)	24/09/2013	25/09/2013	A	01/10/13 BMCE-TRANSMIT-017859			B
BMCE-TRANSMIT-017567 (BMCE-WTRAN-008779)	24/09/2013	25/09/2013	A	01/10/13 BMCE-TRANSMIT-017859			
BMCE-TRANSMIT-017567 (BMCE-WTRAN-008779)	24/09/2013	25/09/2013	C	01/10/13 BMCE-TRANSMIT-017859			B
BMCE-TRANSMIT-017567 (BMCE-WTRAN-008779)	24/09/2013	25/09/2013	A	01/10/13 BMCE-TRANSMIT-017859			
BMCE-TRANSMIT-017567 (BMCE-WTRAN-008779)	24/09/2013	25/09/2013	A	01/10/13 BMCE-TRANSMIT-017859			B
BMCE-TRANSMIT-017567 (BMCE-WTRAN-008779)	24/09/2013	25/09/2013	A	01/10/13 BMCE-TRANSMIT-017859			B
BMCE-TRANSMIT-017567 (BMCE-WTRAN-008779)	24/09/2013	25/09/2013	A	01/10/13 BMCE-TRANSMIT-017859			B
BMCE-TRANSMIT-017567 (BMCE-WTRAN-008779)	24/09/2013	25/09/2013	A	01/10/13 BMCE-TRANSMIT-017859			B
BMCE-TRANSMIT-017567 (BMCE-WTRAN-008779)	24/09/2013	25/09/2013	A	01/10/13 BMCE-TRANSMIT-017859			B

BMCE-TRANSMIT-017567 (BMCE-WTRAN-008779)	24/09/2013	25/09/2013	A	01/10/13 BMCE-TRANSMIT-017859			B
BMCE-TRANSMIT-017567 (BMCE-WTRAN-008779)	24/09/2013	25/09/2013	A	01/10/13 BMCE-TRANSMIT-017859			
BMCE-TRANSMIT-017567 (BMCE-WTRAN-008779)	24/09/2013	25/09/2013	A	01/10/13 BMCE-TRANSMIT-017859			
BMCE-TRANSMIT-017567 (BMCE-WTRAN-008779)	24/09/2013	25/09/2013	A	01/10/13 BMCE-TRANSMIT-017859			
BMCE-TRANSMIT-017567 (BMCE-WTRAN-008779)	24/09/2013	25/09/2013	A	01/10/13 BMCE-TRANSMIT-017859			
BMCE-TRANSMIT-017567 (BMCE-WTRAN-008779)	24/09/2013	25/09/2013	A	01/10/13 BMCE-TRANSMIT-017859			
BMCE-TRANSMIT-017567 (BMCE-WTRAN-008779)	24/09/2013	25/09/2013	A	01/10/13 BMCE-TRANSMIT-017859			
BMCE-TRANSMIT-017567 (BMCE-WTRAN-008779)	24/09/2013	25/09/2013	A	01/10/13 BMCE-TRANSMIT-017859			
BMCE-TRANSMIT-017567 (BMCE-WTRAN-008779)	24/09/2013	25/09/2013	B	15/10/13 BMCE-TRANSMIT-018066			
BMCE-TRANSMIT-018485 (BMCE-WTRAN-009413)	04/12/2013	17/01/2014	A	21/01/14 BMCE-TRANSMIT-019127			
BMCE-TRANSMIT-018485 (BMCE-WTRAN-009413)	04/12/2013	17/01/2014	A	21/01/14 BMCE-TRANSMIT-019127			
BMCE-TRANSMIT-017567 (BMCE-WTRAN-008779)	24/09/2013	25/09/2013	B	15/10/13 BMCE-TRANSMIT-018066			
BMCE-TRANSMIT-017567 (BMCE-WTRAN-008779)	24/09/2013	25/09/2013	B	01/10/13 BMCE-TRANSMIT-017859			

BMCE-TRANSMIT-017567 (BMCE-WTRAN-008779)	24/09/2013	25/09/2013	B	15/10/13 BMCE-TRANSMIT-018066			
BMCE-TRANSMIT-017567 (BMCE-WTRAN-008779)	24/09/2013	25/09/2013	B	15/10/13 BMCE-TRANSMIT-018066			
BMCE-TRANSMIT-017567 (BMCE-WTRAN-008779)	24/09/2013	25/09/2013	B	15/10/13 BMCE-TRANSMIT-018066			
BMCE-TRANSMIT-017567 (BMCE-WTRAN-008779)	24/09/2013	25/09/2013	B	15/10/13 BMCE-TRANSMIT-018066			
BMCE-TRANSMIT-017567 (BMCE-WTRAN-008779)	24/09/2013	25/09/2013	B	15/10/13 BMCE-TRANSMIT-018066			
BMCE-TRANSMIT-017567 (BMCE-WTRAN-008779)	24/09/2013	25/09/2013	B	15/10/13 BMCE-TRANSMIT-018066			
BMCE-TRANSMIT-017567 (BMCE-WTRAN-008779)	24/09/2013	25/09/2013	B	15/10/13 BMCE-TRANSMIT-018066			
BMCE-TRANSMIT-017567 (BMCE-WTRAN-008779)	24/09/2013	25/09/2013	B	15/10/13 BMCE-TRANSMIT-018066			
BMCE-TRANSMIT-017567 (BMCE-WTRAN-008779)	24/09/2013	25/09/2013	A	01/10/13 BMCE-TRANSMIT-017859			
BMCE-TRANSMIT-017567 (BMCE-WTRAN-008779)	24/09/2013	25/09/2013	B	01/10/13 BMCE-TRANSMIT-017859			
BMCE-TRANSMIT-016549 (BMCE-WTRAN-008020)	22/07/2013	10/07/2013	A	BMCE-TRANSMIT-016756 11/07/2013			A
BMCE-TRANSMIT-016549 (BMCE-WTRAN-008020)	22/07/2013	10/07/2013	A	BMCE-TRANSMIT-016756 11/07/2013			A

BMCE-TRANSMIT-017567 (BMCE-WTRAN-008779)	24/09/2013	25/09/2013	A	01/10/13 BMCE-TRANSMIT-017859			
BMCE-TRANSMIT-017567 (BMCE-WTRAN-008779)	24/09/2013	25/09/2013	B	01/10/13 BMCE-TRANSMIT-017859			
BMCE-TRANSMIT-017567 (BMCE-WTRAN-008779)	24/09/2013	25/09/2013	A	01/10/13 BMCE-TRANSMIT-017859			
BMCE-TRANSMIT-017567 (BMCE-WTRAN-008779)	24/09/2013	25/09/2013	A	01/10/13 BMCE-TRANSMIT-017859			
BMCE-TRANSMIT-017567 (BMCE-WTRAN-008779)	24/09/2013	25/09/2013	A	01/10/13 BMCE-TRANSMIT-017859			C
BMCE-TRANSMIT-017567 (BMCE-WTRAN-008779)	24/09/2013	25/09/2013	A	01/10/13 BMCE-TRANSMIT-017859			C
BMCE-TRANSMIT-017567 (BMCE-WTRAN-008779)	24/09/2013	25/09/2013	A	01/10/13 BMCE-TRANSMIT-017859			C
BMCE-TRANSMIT-017567 (BMCE-WTRAN-008779)	24/09/2013	25/09/2013	A	01/10/13 BMCE-TRANSMIT-017859			C
BMCE-TRANSMIT-017567 (BMCE-WTRAN-008779)	24/09/2013	25/09/2013	A	01/10/13 BMCE-TRANSMIT-017859			C
BMCE-TRANSMIT-017567 (BMCE-WTRAN-008779)	24/09/2013	25/09/2013	A	01/10/13 BMCE-TRANSMIT-017859			
BMCE-TRANSMIT-018699 (BMCE-WTRAN-009557)	26/12/2013	13/01/2014	B	14/01/14 BMCE-TRANSMIT-019027			
BMCE-TRANSMIT-019924 (BMCE-WTRAN-010232)	05/05/2014						

BMCE-TRANSMIT-019924 (BMCE-WTRAN-010232)	05/05/2014						
BMCE-TRANSMIT-019924 (BMCE-WTRAN-010232)	05/05/2014						
BMCE-TRANSMIT-019924 (BMCE-WTRAN-010232)	05/05/2014						
BMCE-TRANSMIT-016248	03/07/2013	28/06/2013	A	BMCE-TRANSMIT-016589 02/07/2013			
BMCE-TRANSMIT-016248	03/07/2013	20/06/2013	A	BMCE-TRANSMIT-016641 04/07/2013			
BMCE-TRANSMIT-016341	09/07/2013	28/06/2013	A	BMCE-TRANSMIT-016590 02/07/2013			
BMCE-TRANSMIT-016248	03/07/2013	20/06/2013	A	BMCE-TRANSMIT-016641 04/07/2013			
BMCE-TRANSMIT-016248	09/07/2013	20/06/2013	A	BMCE-TRANSMIT-016641 04/07/2013			
BMCE-TRANSMIT-016248	09/07/2013	20/06/2013	A	BMCE-TRANSMIT-016641 04/07/2013			
BMCE-TRANSMIT-016248	03/07/2013	20/06/2013	A	BMCE-TRANSMIT-016641 04/07/2013			
BMCE-TRANSMIT-016248	03/07/2013	20/06/2013	A	BMCE-TRANSMIT-016641 04/07/2013			

BMCE-TRANSMIT-018194	14/11/2013	15/11/2013	A	BMCE-TRANSMIT-018526 20/11/2013			
BMCE-TRANSMIT-016248	03/07/2013	20/06/2013	A	BMCE-TRANSMIT-016641 04/07/2013			
BMCE-TRANSMIT-016248	03/07/2013	20/06/2013	A	BMCE-TRANSMIT-016641 04/07/2013			
BMCE-TRANSMIT-016248	03/07/2013	28/06/2013	A	BMCE-TRANSMIT-016589 02/07/2013		28/02/2014	D
BMCE-TRANSMIT-016248	03/07/2013	28/06/2013	A	BMCE-TRANSMIT-016589 02/07/2013			
BMCE-TRANSMIT-016248	03/07/2013	28/06/2013	A	BMCE-TRANSMIT-016589 02/07/2013		15/08/2013	E
BMCE-TRANSMIT-016248	03/07/2013	28/06/2013	A	BMCE-TRANSMIT-016589 02/07/2013			
BMCE-TRANSMIT-016248	03/07/2013	20/06/2013	A	BMCE-TRANSMIT-016641 04/07/2013			

[illegible]

BMCE-TRANSMIT-017601	19/09/2013	02/10/2013	B	BMCE-TRANSMIT-017955 08/10/2013			
BMCE-TRANSMIT-019297	25/02/2014	03/03/20174	A	BMCE-TRANSMIT-019613 06/03/2014			
BMCE-TRANSMIT-019044	04/02/2014	28/01/2014	A	BMCE-TRANSMIT-019241 20/01/2014			
BMCE-TRANSMIT-019044	04/02/2014	28/01/2014	A	BMCE-TRANSMIT-019241 20/01/2014			
BMCE-TRANSMIT-019044	04/02/2014	28/01/2014	A	BMCE-TRANSMIT-019241 20/01/2014			
BMCE-TRANSMIT-019297	25/02/2014	03/03/20174	A	BMCE-TRANSMIT-019613 06/03/2014			
BMCE-TRANSMIT-019297	25/02/2014	03/03/20174	A	BMCE-TRANSMIT-019613 06/03/2014			
BMCE-TRANSMIT-019297	25/02/2014	03/03/20174	A	BMCE-TRANSMIT-019613 06/03/2014			
BMCE-TRANSMIT-016925	14/07/2013	30/07/2013	A	BMCE-TRANSMIT-017065 01/08/2013			
BMCE-TRANSMIT-016925	14/07/2013	30/07/2013	A	BMCE-TRANSMIT-017065 01/08/2013			
BMCE-TRANSMIT-016925	14/08/2013	02/10/2013	A	BMCE-TRANSMIT-017957 08/10/2013			
BMCE-TRANSMIT-016925	14/07/2013	30/07/2013	A	BMCE-TRANSMIT-017065 01/08/2013			
BMCE-TRANSMIT-016925	14/07/2013	30/07/2013	A	BMCE-TRANSMIT-017065 01/08/2013			

22/07/2013	22/07/2013	30/07/2013	B	BMCE- TRANSMIT- 017065 01/08/2013			
22/07/2013	22/07/2013	30/07/2013	A	BMCE- TRANSMIT- 017065 01/08/2013			
22/07/2013	22/07/2013	30/07/2013	A	BMCE- TRANSMIT- 017065 01/08/2013			
22/07/2013	22/07/2013	30/07/2013	A	BMCE- TRANSMIT- 017065 01/08/2013			
22/07/2013	22/07/2013	30/07/2013	A	BMCE- TRANSMIT- 017065 01/08/2013			
22/07/2013	22/07/2013	30/07/2013	A	BMCE- TRANSMIT- 017065 01/08/2013		14/02/2014	D
22/07/2013	22/07/2013	30/07/2013	A	BMCE- TRANSMIT- 017065 01/08/2013			
22/07/2013	22/07/2013	30/07/2013	A	BMCE- TRANSMIT- 017065 01/08/2013			
22/07/2013	22/07/2013	30/07/2013	A	BMCE- TRANSMIT- 017065 01/08/2013			
BMCE-TRANSMIT- 019436	10/03/2014	24/02/2014	B	BMCE- TRANSMIT- 019570 27/02/2014			

[illegible]

Planned Date to be Submitted to Board	Date Submitted to Board	Date Response Required from Board	Date Received from Board	Board Status	Date Returned to Consultant	Date Required from Consultant	Date Submitted by Consultant
	08/01/14 BMCE-TRANSMIT-018958 (BMCE-WTRAN-009695)	29/01/2014	27/01/2014	A			

[illegible]

C	08/01/14 BMCE-TRANSMIT-018958 (BMCE-WTRAN-009695)	29/01/2014	27/01/2014	A			
	05/08/2013	BMCE-TRANSMIT-017086 (BMCE-TRANSMIT-017086)	23/08/2013	A	04/09/13 BMCE-TRANSMIT-017590		
	05/08/2013	BMCE-TRANSMIT-017086 (BMCE-TRANSMIT-017086)	23/08/2013	A	04/09/13 BMCE-TRANSMIT-017590		

C	08/01/14 BMCE-TRANSMIT-018958 (BMCE-WTRAN-009695)	29/01/2014	27/01/2014	A			
C	08/01/14 BMCE-TRANSMIT-018958 (BMCE-WTRAN-009695)	29/01/2014	27/01/2014	A			
	08/01/14 BMCE-TRANSMIT-018958 (BMCE-WTRAN-009695)	29/01/2014	27/01/2014	A			
	08/01/14 BMCE-TRANSMIT-018958 (BMCE-WTRAN-009695)	29/01/2014	27/01/2014	A			
	08/01/14 BMCE-TRANSMIT-018958 (BMCE-WTRAN-009695)	29/01/2014	27/01/2014	A			
	08/01/14 BMCE-TRANSMIT-018958 (BMCE-WTRAN-009695)	29/01/2014	27/01/2014	A			
	08/01/14 BMCE-TRANSMIT-018958 (BMCE-WTRAN-009695)	29/01/2014	27/01/2014	A			
	08/01/14 BMCE-TRANSMIT-018958 (BMCE-WTRAN-009695)	29/01/2014	27/01/2014	A			

[illegible]

[illegible]

[illegible]

	BMCE-TRANSMIT-017515 29/08/2013	19/09/2013	23/09/2013	B	BMCE-TRANSMIT-017834 26/09/2013		24/09/2013
	BMCE-TRANSMIT-017515 29/08/2013	19/09/2013	23/09/2013	B	BMCE-TRANSMIT-017834 26/09/2013		24/09/2013
	BMCE-TRANSMIT-017515 29/08/2013	19/09/2013	23/09/2013	B	BMCE-TRANSMIT-017834 26/09/2013		24/09/2013
	BMCE-TRANSMIT-017515 29/08/2013	19/09/2013	23/09/2013	B	BMCE-TRANSMIT-017834 26/09/2013		24/09/2013
	BMCE-TRANSMIT-017515 29/08/2013	19/09/2013	23/09/2013	B	BMCE-TRANSMIT-017834 26/09/2013		24/09/2013
	BMCE-TRANSMIT-017601 05/09/2013	19/09/2013	02/10/2013	B	BMCE-TRANSMIT-017955 08/10/2013		

[illegible]

[illegible]

[illegible]

[illegible]

[illegible]

[illegible]

B		08/01/14 BMCE- TRANSMIT- 018958 ~~BMCE~~	29/01/2014	27/01/2014	A			
B		08/01/14 BMCE- TRANSMIT- 018958 ~~BMCE~~	29/01/2014	27/01/2014	A			

[illegible]

[illegible]

